


**R.C. HARRIS WATER TREATMENT PLANT
INSTALLATION OF A STANDBY GENERATOR FOR CRITICAL LOADS
CONTRACT No. 25ECS-MI-03HA**

ISSUED FOR TENDER, MARCH 18, 2025



2701 QUEEN ST.E., SCARBOROUGH, ON M4E 1H4

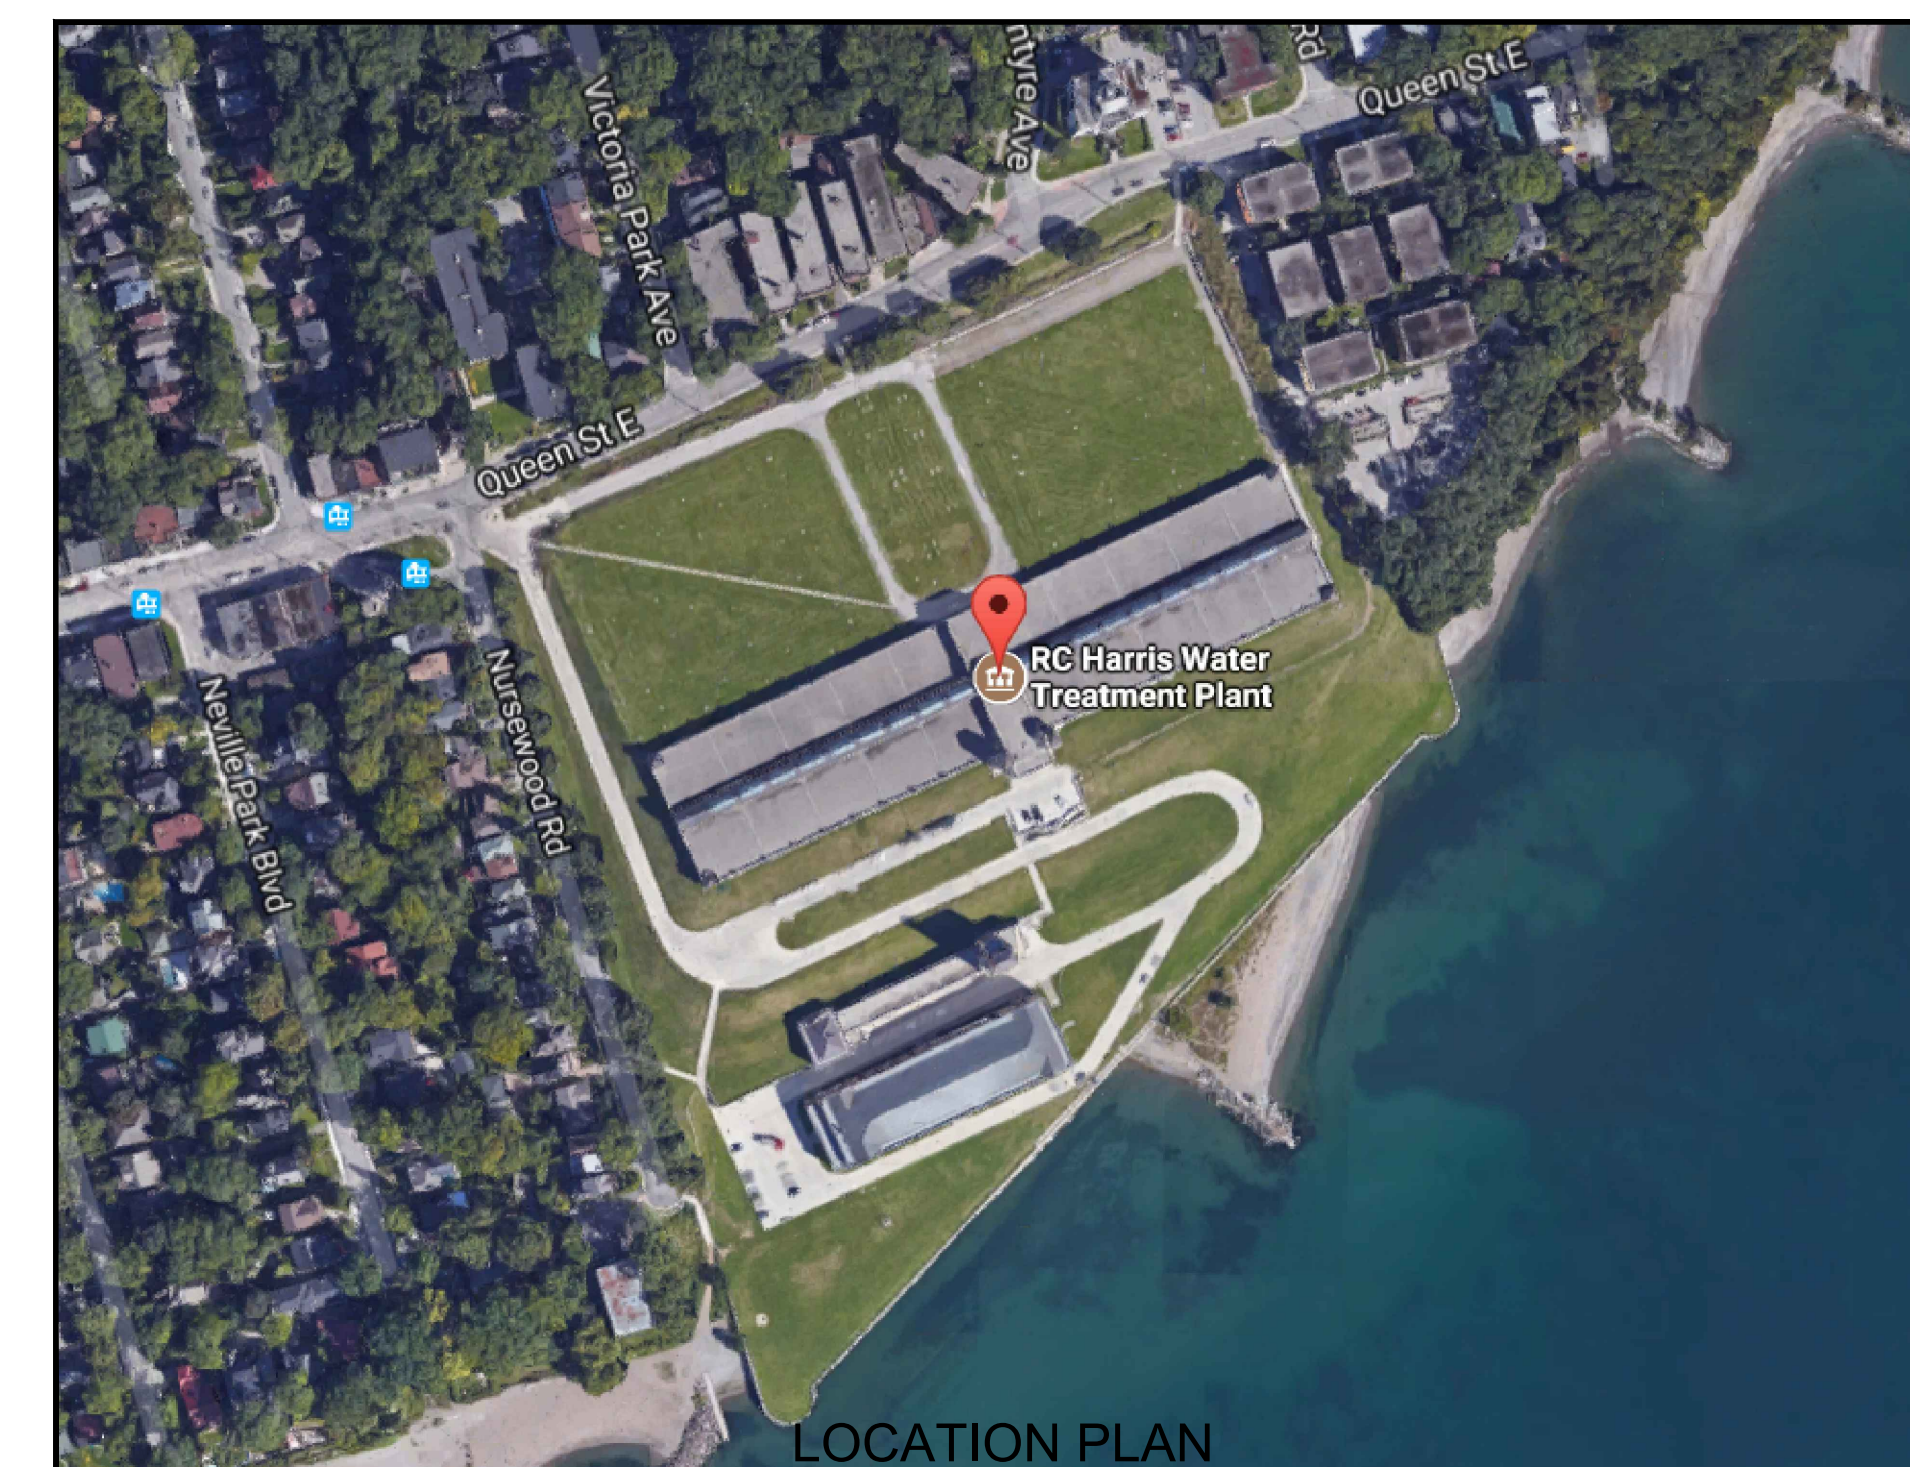

100-175 GALAXY BOULEVARD
TORONTO, ONTARIO, M9W 0C9
TEL 416 679 1930 FAX 416 675 4620
www.arcadis.com



LOU DI GIRONIMO
GENERAL MANAGER
TORONTO WATER

JENNIFER GRAHAM HARKNESS, P.ENG.
CHIEF ENGINEER & EXECUTIVE DIRECTOR
ENGINEERING AND CONSTRUCTION SERVICES

Drawing: J:\MI6-0273 TOR_HARRISWTP-STANDBYGENERATOR\500_CAD\401-CAD\1-SS OR BU\SHEET\1 GENERAL\2F-2017-08-2_G002.DWG
Layout: Tab: G002
Date: 03/25/2025 Time: 10:36:30 AM


DRAWING INDEX			
ITEM	CITY DWG No.	DISCIPLINE	DRAWING DESCRIPTION
GENERAL			
1	2F-2017-08-1	G001	COVER PAGE
2	2F-2017-08-2	G002	DRAWING INDEX - 1
3	2F-2017-08-3	G003	DRAWING INDEX - 2
4	2F-2017-08-4	G004	OVERALL SITE PLAN
ARCHITECTURAL			
5	2F-2017-08-5	A001	GENERAL INFORMATION
6	2F-2017-08-6	A100	FLOOR PLANS, SECTIONS AND ELEVATIONS
7	2F-2017-08-7	A200	DETAILS AND SCHEDULES
8	2F-2017-08-8	A300	ARCHITECTURAL REMOVAL, MODIFICATION AND REINSTATEMENT WORK
9	2F-2017-08-9	A400	ARCHITECTURAL REMOVAL, MODIFICATION AND REINSTATEMENT WORK
STRUCTURAL			
10	2F-2017-08-10	S001	GENERAL NOTES
11	2F-2017-08-11	S002	TYPICAL DETAILS
12	2F-2017-08-12	S003	RMF DEMOLITION - EXISTING MONORAIL AT EL. 88.00 AND EL. 92.10
13	2F-2017-08-13	S004	RMF DEMOLITION - PART PLAN AT EL. 88.00 AND SECTION
14	2F-2017-08-14	S006	RMF GENERATOR PAD - PLAN AT EL. 88.00, SECTION AND DETAILS
15	2F-2017-08-15	S008	FILTER GALLERY - EXTEND WALKWAY LAYOUT
16	2F-2017-08-16	S009	FILTER GALLERY - NEW PLATFORM PLAN, SECTIONS AND DETAILS
17	2F-2017-08-17	S010	TRANSFORMER BLDG - PROPOSED SUMP PIT PLAN, SECTIONS & DETAILS
18	2F-2017-08-18	S011	PIPE GALLERY, GENERATOR ROOM & WATER CONDUIT - SECTION ELEVATION & DETAILS
19	2F-2017-08-19	S012	PIPE GALLERY, GENERATOR ROOM & WATER CONDUIT - SECTION ELEVATION & DETAILS
MECHANICAL			
20	2F-2017-08-20	M001	GENERAL LAYOUT
21	2F-2017-08-21	M201	PIPE GALLERY - RENOVATIONS AND DEMOLITION
22	2F-2017-08-22	M201A	ENLARGED PLAN GENERATOR ROOM. HVAC
23	2F-2017-08-23	M201B	ENLARGED PLAN GENERATOR ROOM. PIPING
24	2F-2017-08-24	M202	PIPE GALLERY - EXHAUST STACK SECTION, ELEVATION
25	2F-2017-08-25	M203	PIPE GALLERY - COMBUSTION AIR INTAKE SECTION, ELEVATION
26	2F-2017-08-26	M207	FILTER GALLERY PLATFORM LAYOUT
27	2F-2017-08-27	M208	MECHANICAL DETAILS - 1
28	2F-2017-08-28	M209	MECHANICAL DETAILS - 2
29	2F-2017-08-29	M210	TRANSFORMER TUNNEL SUMP PUMP - PLAN AND ELEVATION
ELECTRICAL			
30	2F-2017-08-30	E001	ELECTRICAL LEGEND & ABBREVIATIONS - 1
31	2F-2017-08-31	E002	ELECTRICAL LEGEND & ABBREVIATIONS - 2
32	2F-2017-08-32	E003	ELECTRICAL LEGEND & ABBREVIATIONS - 3
33	2F-2017-08-33	E004	OVERALL SITE PLAN
34	2F-2017-08-34	E010	MASTER POWER SYSTEM BLOCK DIAGRAM





DRAWING INDEX			
ITEM	CITY DWG No.	DISCIPLINE	DRAWING DESCRIPTION
ELECTRICAL (CONT.)			
35	2F-2017-08-35	E011	MASTER SINGLE LINE DIAGRAM
36	2F-2017-08-36	E012	OVERALL GENERAL SINGLE LINE DIAGRAM 1
37	2F-2017-08-37	E013	OVERALL GENERAL SINGLE LINE DIAGRAM 2
38	2F-2017-08-38	E014	ATS & STANDBY GENERATOR WIRING SCHEMATIC
39	2F-2017-08-39	E015	ATS & STANDBY CONTROL WIRING BLOCK DIAGRAM
40	2F-2017-08-40	E016	FILTER CV PANEL CONTROL WIRING BLOCK DIAGRAM
41	2F-2017-08-41	E101	FHA-ELS-MCC-0400A/B SINGLE LINE DIAGRAM - MODIFICATIONS
42	2F-2017-08-42	E102	FHA-ELS-MCC-0400A/B ELEVATION LAYOUT - EXISTING AND MODIFICATIONS
43	2F-2017-08-43	E103	FHA-ELS-PDP-0400E SINGLE LINE DIAGRAM - NEW STANDBY BUS
44	2F-2017-08-44	E104	FHA-ELS-PDP-0400E ELEVATION LAYOUT
45	2F-2017-08-45	E105	FHA-ELS-PDP-0401A/B SINGLE LINE DIAGRAM - EXISTING
46	2F-2017-08-46	E106	FHA-ELS-PDP-0401A/B SINGLE LINE DIAGRAM - MODIFICATIONS
47	2F-2017-08-47	E107	FHA-ELS-PDP-0401A/B ELEVATION LAYOUT
48	2F-2017-08-48	E108	FHA-ELS-PDP-0506 SINGLE LINE DIAGRAM - MODIFICATIONS
49	2F-2017-08-49	E111	FHA-ELS-PDP-0500A/B SINGLE LINE DIAGRAM - MODIFICATIONS
50	2F-2017-08-50	E112	FHA-ELS-PDP-0500A/B ELEVATION LAYOUT - EXISTING AND MODIFICATIONS
51	2F-2017-08-51	E121	FHA-ELS-MCC-0600A/B SINGLE LINE DIAGRAM - MODIFICATIONS
52	2F-2017-08-52	E122	FHA-ELS-MCC-0600A/B ELEVATION LAYOUT - EXISTING AND MODIFICATIONS
53	2F-2017-08-53	E131	FHA-ELS-PDP-0300 SINGLE LINE DIAGRAM - MODIFICATIONS
54	2F-2017-08-54	E132	FHA-ELS-PDP-0300 ELEVATION LAYOUT - EXISTING AND MODIFICATIONS
55	2F-2017-08-55	E133	FHA-ELS-PDP-0300E SINGLE LINE DIAGRAM - NEW STANDBY BUS
56	2F-2017-08-56	E134	FHA-ELS-PDP-0300E ELEVATION LAYOUT - NEW
57	2F-2017-08-57	E135	FHA-ELS-MCC-0301A SINGLE LINE DIAGRAM - EXISTING
58	2F-2017-08-58	E136	FHA-ELS-MCC-0301B SINGLE LINE DIAGRAM - EXISTING
59	2F-2017-08-59	E141	FHA-ELS-MCC-0200A/B SINGLE LINE DIAGRAM - MODIFICATIONS
60	2F-2017-08-60	E142	FHA-ELS-MCC-0200A/B ELEVATION LAYOUT - EXISTING AND MODIFICATIONS
61	2F-2017-08-61	E143	FHA-ELS-PDP-0200E SINGLE LINE DIAGRAM - NEW STANDBY BUS
62	2F-2017-08-62	E144	FHA-ELS-PDP-0200E ELEVATION LAYOUT - NEW
63	2F-2017-08-63	E201	ELECTRICAL FLOOR PLAN - RMF PIPE GALLERY (EL. 88.00)
64	2F-2017-08-64	E202	ELECTRICAL FLOOR PLAN - RMF MCC ROOM (EL. 88.00)
65	2F-2017-08-65	E203	ELECTRICAL FLOOR PLAN - LOWER FILTER PIPE GALLERY (EL. 94.06)
66	2F-2017-08-66	E204	ELECTRICAL FLOOR PLAN - PUMPING STATION TUNNEL TO SERVICE BUILDING
67	2F-2017-08-67	E205	ELECTRICAL FLOOR PLAN - PUMPING STATION BASEMENT LEVEL SWITCHGEAR ROOM
68	2F-2017-08-68	E206	ELECTRICAL FLOOR PLAN - PUMPING STATION GROUND LEVEL (EL. 78.64)
69	2F-2017-08-69	E207	ELECTRICAL FLOOR PLAN - RMF & SERVICE BUILDING
70	2F-2017-08-70	E208	ELECTRICAL FLOOR PLAN - DETAIL 'A' - RMF & SERVICE BUILDING
71	2F-2017-08-71	E209	ELECTRICAL FLOOR PLAN - CHEMICALS ROOM, PIPE GALLERY
72	2F-2017-08-72	E211	ELECTRICAL FLOOR PLAN - SERVICE BUILDING BASEMENT
73	2F-2017-08-73	E212	ELECTRICAL FLOOR PLAN - LOWER FILTER PIPE GALLERY - WEST (EL. 94.06)
74	2F-2017-08-74	E213	ELECTRICAL FLOOR PLAN - LOWER FILTER PIPE GALLERY - EAST (EL. 94.06)

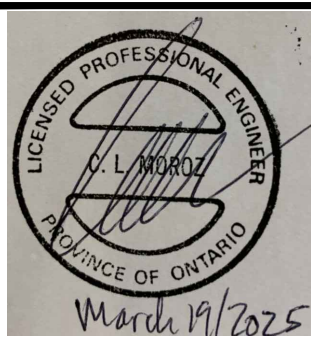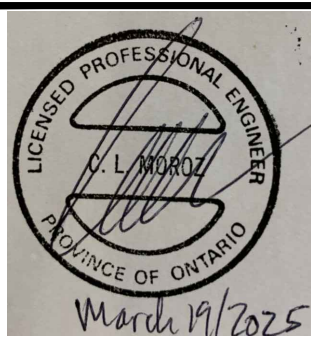
										TORONTO WATER		ENGINEERING AND CONSTRUCTION SERVICES		R.C. HARRIS WATER TREATMENT PLANT INSTALLATION OF A STANDBY GENERATOR FOR CRITICAL LOADS DRAWING INDEX - 1									
 100-175 GALAXY BOULEVARD TORONTO, ONTARIO, M9W 0G9 TEL 416 679 1930 FAX 416 675 4620 www.arcadis.com		COPYRIGHT: This drawing has been prepared solely for the intended use, thus any reproduction or distribution for any purpose other than authorized by ARCADIS is forbidden. Written dimensions shall have precedence over scaled dimensions. Contractors shall verify and be responsible for all dimensions and conditions on the job, and ARCADIS shall be informed of any variations from the dimensions and conditions shown on the drawing. Shop drawings shall be submitted to the Client for general confirmation before proceeding with fabrication. ARCADIS Professional Services (Canada) Inc.																					
		A	2025-03-18	ISSUED FOR TENDER		C.H.								DESIGN:	SS	DRAFTING:	SS	CHECK:	PD	CONTRACT No.	25ECS-MI-03HA		
														SCALE:	N.T.S.		DRAWING NUMBER:		2F-2017-08-2				
														DATE:	2024-09-30						G002		

Drawing: J: \MT6--0273 TOR_HARRISWTP--STANDBYGENERATOR\500_CAD\401--CAD\1--SS OR BU\SHEET\1 GENERAL\2F--2017--08--4_G0003.DWG
Layout Tab: G003
Date: 03/24/2025 Time: 04:11:47 PM

DRAWING INDEX			
ITEM	CITY DWG No.	DISCIPLINE	DRAWING DESCRIPTION
INSTRUMENTATION			
75	2F-2017-08-75	I001	LEGEND SHEET - 1
76	2F-2017-08-76	I002	LEGEND SHEET - 2
77	2F-2017-08-77	I003	LEGEND SHEET - 3
78	2F-2017-08-78	I004	PROCESS & INSTRUMENTATION DIAGRAM
79	2F-2017-08-79	I005	MECHANICAL CONTROL PANEL LAYOUT
80	2F-2017-08-80	I006	MECHANICAL CONTROL PANEL WIRING
81	2F-2017-08-81	I007	SPC-RPU-2022 PLC RACK LAYOUT
82	2F-2017-08-82	I008	SPC-RPU-2022 PLC PANEL LAYOUT
83	2F-2017-08-83	I009	SPC-RPU-2022 - PANEL POWER DISTRIBUTION 1
84	2F-2017-08-84	I010	SPC-RPU-2022 - RACK 0 SLOT 03 WIRING DIAGRAM
85	2F-2017-08-85	I011	SPC-RPU-2022 - RACK 0 SLOT 04 WIRING DIAGRAM
86	2F-2017-08-86	I012	SPC-RPU-2022 - RACK 0 SLOT 05 WIRING DIAGRAM
87	2F-2017-08-87	I013	SPC-RPU-2022 - RACK 0 SLOT 06 WIRING DIAGRAM
88	2F-2017-08-88	I014	SPC-RPU-2022 - RACK 0 SLOT 07 WIRING DIAGRAM
89	2F-2017-08-89	I015	SPC-RPU-2022 - RACK 1 SLOT 04 WIRING DIAGRAM
90	2F-2017-08-90	I016	SPC-RPU-1223 - PLC RACK LAYOUT
91	2F-2017-08-91	I017	SPC-RPU-1223 - PLC PANEL LAYOUT
92	2F-2017-08-92	I018	SPC-RPU-1223 - RACK 0 SLOT 06 WIRING DIAGRAM
93	2F-2017-08-93	I019	INSTRUMENTATION FLOOR PLAN
94	2F-2017-08-94	I020	INSTALLATION DETAILS - 1
95	2F-2017-08-95	I021	INSTALLATION DETAILS - 2
96	2F-2017-08-96	I101	FLT-UPS-0001 POWER FAILURE WIRING DIAGRAM
97	2F-2017-08-97	I102	FLT-UPS-0002 POWER FAILURE WIRING DIAGRAM
98	2F-2017-08-98	I103	MCC-0400 WIRING DETAIL
99	2F-2017-08-99	I104	TIE BREAKER WIRING
100	2F-2017-08-100	I105	FILTER CV SHUTOFF CONTROL PANEL LAYOUT AND WIRING
101	2F-2017-08-101	I106	FLT-CP-0005 CONTROL PANEL
102	2F-2017-08-102	I107	FLT-CP-0006 CONTROL PANEL

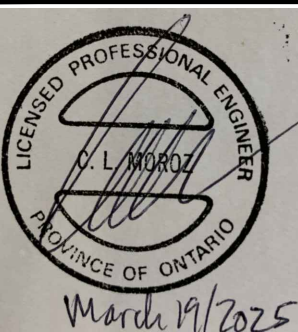									TORONTO WATER ENGINEERING AND CONSTRUCTION SERVICES				R.C. HARRIS WATER TREATMENT PLANT INSTALLATION OF A STANDBY GENERATOR FOR CRITICAL LOADS DRAWING INDEX - 2			
 100-175 GALAXY BOULEVARD TORONTO, ONTARIO, M9W 0C9 TEL 416 679 1830 FAX 416 675 4620 www.arcadis.com		COPYRIGHT: This drawing has been prepared solely for the intended use, thus any reproduction or distribution for any purpose other than authorized by ARCADIS is forbidden. Written dimensions shall have precedence over scaled dimensions. Contractors shall verify and be responsible for all dimensions and conditions on the job, and ARCADIS shall be informed of any variations from the dimensions and conditions shown on the drawing. Shop drawings shall be submitted to TSI Group for general conformance before proceeding with fabrication.								WILLIAM FERNANDES, P. ENG. DIRECTOR, WATER TREATMENT AND SUPPLY		SIMON HOPTON, P. ENG. DIRECTOR DESIGN & CONSTRUCTION MAJOR INFRASTRUCTURE				
		A		2025-03-18		ISSUED FOR TENDER		C.H.								
		NO.		DATE		REVISIONS		INITIAL		SIGNED						
												GENERAL				
DESIGN:		SS		DRAFTING:		SS		CHECK:		PD		CONTRACT No. 25ECS-MI-03HA				
SCALE:				N.T.S.				DRAWING NUMBER:		2F-2017-08-3		G003				
DATE:				2024-09-30												

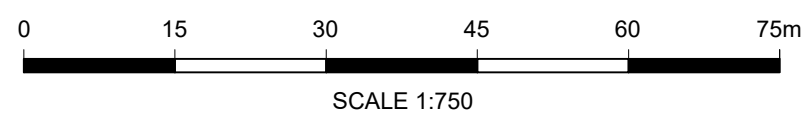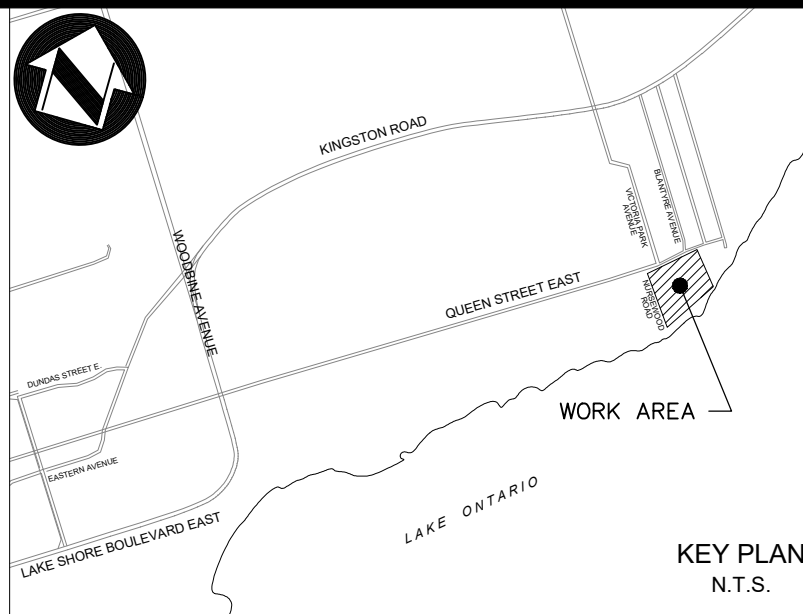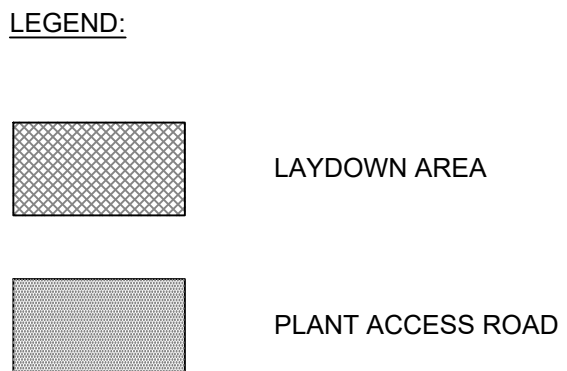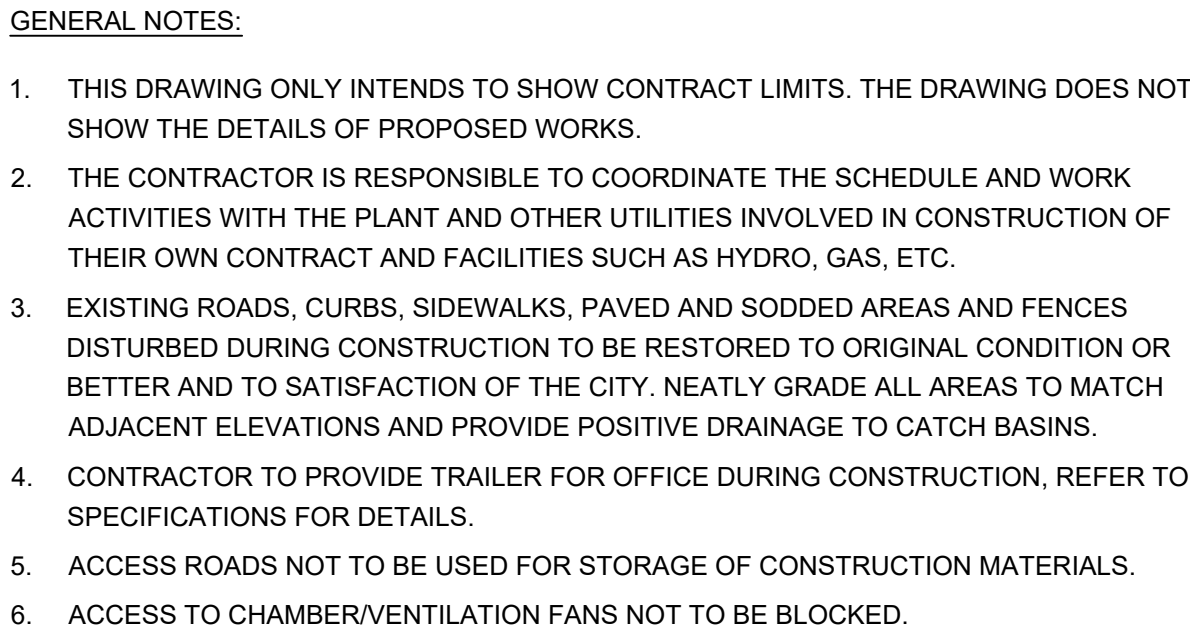

 											TORONTO WATER ENGINEERING AND CONSTRUCTION SERVICES		R.C. HARRIS WATER TREATMENT PLANT INSTALLATION OF A STANDBY GENERATOR FOR CRITICAL LOADS OVERALL SITE PLAN				
 100-175 GALAXY BOULEVARD TORONTO, ONTARIO, M5W 0G9 TEL 416 679 1930 FAX 416 675 4620 www.arcadis.com	COPYRIGHT: This drawing has been prepared solely for the intended use, thus any reproduction or distribution for any purpose other than authorized by ARCADIS is forbidden. Where dimensions shall have precedence over scaled dimensions. Contractors shall verify and be responsible for all dimensions and conditions on the job, and ARCADIS shall be informed of any variations from the dimensions and conditions shown on the drawing. Shop drawings shall be submitted to IBI Group for general confirmation before proceeding with fabrication.											CIVIL					
		A	2025-03-18	ISSUED FOR TENDER		C.H.				DESIGN:	A.P.	DRAFTING:	L.A.	CHECK:	A.P.	CONTRACT No.	25ECS-MI-03HA
										SCALE:		1:750					
		NO.	DATE	REVISIONS		INITIAL	SIGNED			DATE:		2024-09-30			DRAWING NUMBER:	2F-2017-08-4	G004

ONTARIO BUILDING CODE DATA MATRIX				
Part 11 - Renovation of Existing Building				
11.00	Building Code Version:	O. Reg 332/12.	Last Amendment	O. Reg 191/14
11.01	Project Type:	☐ ADDITION ☐ CHANGE OF USE Description: Upgrade of interior finishes	☒ RENOVATION	☐ ADDITION & RENOVATION
11.02	Major Occupancy Classification:	Occupancy: F3 Use: LOW HAZARD INDUSTRIAL		
11.03	Superimposed Major Occupancies:	☒ NO Description:	☐ YES	
11.05	No. of Streets:	1		
11.06	Building Size:	☐ SMALL ☐ MEDIUM ☐ LARGE ☒ >LARGE		
11.08	Existing Building Classification:	Change in Major Occupancy Construction Index Hazard Index Importance Category	☐ YES ☒ NOT APPLICABLE (no change in major occupancy) 1 4 ☐ LOW ☐ HIGH ☐ NORMAL ☒ POST DISASTER	
11.09	Renovation Type:	☒ BASIC RENOVATION ☐ EXTENSIVE RENOVATION		
11.12	Barrier Free Design:	☐ YES ☒ NO		
11.13	Reduction in Performance Level:	STRUCTURAL BY INCREASE IN OCCUPANT LOAD BY CHANGE OF MAJOR OCCUPANCY PLUMBING SEWAGE SYSTEMS EXTENSION OF COMBUSTIBLE CONSTRUCTION	☐ YES ☒ NO ☐ YES ☒ NO ☐ YES ☒ NO ☐ YES ☒ NO ☐ YES ☒ NO	
11.14	Compensating Construction:	☒ NO ☐ YES STRUCTURAL BY INCREASE IN OCCUPANT LOAD BY CHANGE OF MAJOR OCCUPANCY PLUMBING SEWAGE SYSTEMS EXTENSION OF COMBUSTIBLE CONSTRUCTION	☐ YES ☒ NO ☐ YES ☒ NO ☐ YES ☒ NO ☐ YES ☒ NO ☐ YES ☒ NO	
11.15	Compliance Alternatives Proposed:	☒ NO ☐ YES		
11.16	Notes:			

All references are to Division B of the OBC unless preceded by [A] for Division A or [C] for Division C

WALL TYPES						
MARK	LEGEND	DESCRIPTION	FRR	STC	ULC	REMARKS
W1		190mm CONCRETE MASONRY UNIT	1 HR	50	SB-3 TABLE 1	200mm MONOLITHIC CONC. CURB AT WALL BASE PER SB-2 TABLE 2.1.1

FIRE RESISTANCE RATING LEGEND	
	1 HOUR FIRE RATED SEPARATION

GENERAL NOTES

- THE CONSULTANT IS NOT RESPONSIBLE FOR INFORMATION CONCERNING THE SITE AND SURVEY INFORMATION PREPARED BY OTHERS.
- THE CONTRACTOR SHALL SITE VERIFY THE SURVEY INFORMATION PRIOR TO PROCEEDING WITH THE WORK. FAILURE TO REPORT ANY DISCREPANCIES SHALL CONSTITUTE ACCEPTANCE OF THE SITE CONDITIONS.
- THE CONTRACTOR SHALL REVIEW THE DRAWINGS FOR SCOPE OF DEMOLITION AND NEW WORK, INCLUDING ALL DISCIPLINES, AND SHALL COORDINATE WITH NEW WORK DRAWINGS FOR EXACT EXTENT OF ANY DEMOLITION REQUIRED.
- SCOPE OF WORK SHALL NOT BE LIMITED TO THAT SHOWN ON THE DRAWINGS AND SHALL INCLUDE WORK REQUIRED TO ELIMINATE ALL EXISTING, ABANDONED OR REDUNDANT COMPONENTS, AND TO FACILITATE PROPER EXECUTION OF THE WORK.
- ALL DIMENSIONS, INCLUDING EXISTING DIMENSIONS AND SETTING-OUT GEOMETRIES, SHALL BE SITE VERIFIED BY THE CONTRACTOR PRIOR TO PROCEEDING WITH THE WORK.
- REMOVAL AND DISPOSAL OF HAZARDOUS MATERIALS SHALL BE IN ACCORDANCE WITH LOCAL REGULATIONS AND AUTHORITIES HAVING JURISDICTION.
- UNLESS NOTED OTHERWISE, MAKE GOOD ALL AREAS DISTURBED BY EXCAVATION AND/OR INSTALLATION OF CIVIL, MECHANICAL AND ELECTRICAL SERVICES. REFER TO CIVIL, MECHANICAL, AND ELECTRICAL DRAWINGS.
- THE CONTRACTOR SHALL COORDINATE BASE BUILDING WORKS WITH WORK OF OTHER CONTRACTORS, INCLUDING TENANT WORKS AS REQUIRED TO FACILITATE PROPER INSTALLATION.
- ALL OMISSIONS OR CONFLICTS BETWEEN THE VARIOUS ELEMENTS OF THE CONTRACT DRAWINGS AND OR SPECIFICATIONS SHALL BE BROUGHT TO THE ATTENTION OF THE CONSULTANT BEFORE PROCEEDING WITH ANY WORK INVOLVED.
- ALL CONSTRUCTION SHALL BE IN ACCORDANCE TO THE LATEST EDITION OF THE ONTARIO BUILDING CODE.
- THE CONTRACTOR SHALL BE RESPONSIBLE FOR THE PROTECTION OF AND THE SAFETY IN AND AROUND THE WORKS' AREA AND OF ADJACENT PROPERTIES.
- CONTRACTOR SHALL KEEP LOADS ON THE STRUCTURE WITHIN THE LIMITS OF THE DESIGN BOTH DURING AND AFTER CONSTRUCTION.
- COMPLIANCE WITH CODES AND ORDINANCES GOVERNING THE WORK SHALL BE MADE AND ENFORCED BY THE GENERAL CONTRACTOR.
- GENERAL CONTRACTOR SHALL VERIFY ALL EXISTING CONDITIONS AND DIMENSIONS PRIOR TO CONSTRUCTION
- NOTE THAT ALL WRITTEN DIMENSIONS TAKE PRECEDENCE OVER SCALE.
- WORKMANSHIP THROUGHOUT SHALL BE OF THE BEST QUALITY OF THE TRADE INVOLVED AND THE GENERAL CONTRACTOR SHALL COORDINATE THE WORK OF THE VARIOUS TRADES TO EXPEDITE THE JOB IN A SMOOTH AND CONTINUOUS PROCESS.
- THE CONTRACTOR SHALL CONFINE HIS OPERATIONS ON THE SITE TO AREAS PERMITTED BY THE OWNER.
- PROVIDE TOUCH-UP PAINT IN THE EVENT THAT PATCH AND REPAIR IS REQUIRED. MATCH EXISTING PAINT.
- CONTRACTOR TO REMOVE AND DISPOSE OF ALL DEBRIS FROM THE PROJECT SITE.
- PROVIDE ALL NECESSARY BLOCKING, BACKING AND FRAMING FOR LIGHT FIXTURES, ELECTRIC UNITS, RECESSED ITEMS AND ALL OTHER ITEMS AS REQUIRED.
- MATERIAL STORED ON SITE SHALL BE PROTECTED TO PREVENT DAMAGE AND DETERIORATION.
- THE JOB SITE SHALL BE MAINTAINED IN A CLEAN AND ORDERLY CONDITION, FREE OF DEBRIS AND LITTER AND SHALL NOT BE UNREASONABLY ENCUMBERED WITH MATERIALS OR EQUIPMENT.
- CONTRACTOR NOT TO COMMENCE CONSTRUCTION WITHOUT THE SUBMITTAL AND REVIEW OF APPROPRIATE SHOP DRAWINGS.
- FIRE STOP ALL FLOOR PENETRATIONS, PENETRATIONS IN STAIR ENCLOSURES AND SIMILAR FIRE RATED SHAFTWAYS, PARTITIONS AND ENCLOSURES.
- PIPING, TUBING, DUCTS, CHIMNEYS, OPTICAL FIBRE CABLES, ELECTRICAL WIRES & CABLES, TOTALLY ENCLOSED NON-COMBUSTIBLE RACEWAYS, ELECTRICAL OUTLET BOXES AND OTHER SIMILAR BUILDING SERVICES THAT PENETRATE A MEMBRANE FORMING PART OF AN ASSEMBLY REQUIRED TO HAVE A FIRE RESISTANCE RATING OR A FIRE SEAPARATION SHALL BE SEALED WITH A FIRE STOP.
- AT ALL TRANSITIONS OF MATERIALS, JOINTS TO BE CAULKED C/W WITH BACKER ROD.
- ALL ULC RATED WALLS ARE TO BE INSTALLED USING THE ASSEMBLY AND MATERIALS LISTED IN THE REFERENCED ULC WALL AND FLOOR.
- ALL RATED PARTITIONS TO EXTEND TO U/S OF FLOOR OR ROOF ABOVE.
- PROVIDE COMPRESSIBLE JOINT FILLER CONTINUOUS AT TOP OF ALL BLOCK WALLS AND PARTITIONS, CAULK JOINTS WHERE EXPOSED. PROVIDE FIRESTOP AND SMOKE SEALS AT PERIMETER JOINTS AND PENETRATIONS IN FIRE RATED PARTITIONS.

DEMOLITION NOTES

- REPAIR CEILING, WALL AND FLOOR FINISHES DAMAGED BY DEMOLITION WORK TO MATCH EXISTING ADJACENT FINISHES.
- REPAIR WALLS DAMAGED BY DEMOLITION TO PROVIDE SMOOTH SURFACE, WITH PATCHES DRESSED FLUSH, SMOOTH AND READY TO RECEIVE FINISH MATERIAL.
- CONSTRUCTION IN AREAS TO BE RENOVATED SHALL BE CAREFULLY COORDINATED WITH PLANT OPS. THE CITY AND CONSULTANT PRIOR TO CONSTRUCTION. EXISTING EQUIPMENT WILL BE RELOCATED OR STORED AT OPS DIRECTION. EQUIPMENT AND/OR FURNISHINGS TO BE STORED SHALL BE PROTECTED FROM DAMAGE AND VANDALISM IN LOCATIONS ACCEPTABLE TO THE CITY AND PLANT OPS.
- COORDINATE DEMOLITION AND CONSTRUCTION OPERATIONS WITH PLANT OPS WHERE THEY AFFECT EXISTING WORK AREAS AND NORMAL OPERATING PROCEDURES.
- DEMOLITION EXPOSING THE INTERIOR OF THE BUILDING TO THE OUTSIDE ELEMENTS OR TO THE PUBLIC SHALL BE PROPERLY SEALED AND PROTECTED TO ELIMINATE DAMAGE FROM VANDALISM DURING CONSTRUCTION.
- PROVIDE SCREENINGS FROM DUST, FUMES, SMOKE, WATER AND NOISE WHERE DEMOLITION REQUIRES CONSTRUCTION TO BE EXPOSED TO NORMAL OPERATIONS OF THE OCCUPANTS.
- PATCH ALL WALL PENETRATIONS IN EXISTING FIRE RATED WALLS TO MAINTAIN THE SAME FIRE RATING OF THE EXISTING WALL/STRUCTURE. ITEMS TO REMAIN AND TO BE PROTECTED ARE DESIGNATED WITH CONTINUOUS LINES. IF DAMAGE OCCURS, PATCH, REFINISH OR REPLACE DAMAGED ITEMS AT NO COST TO THE CITY.
- GENERAL CONTRACTOR TO PROPERLY DEMOLISH AND DISPOSE OF SITE DEMOLITION ITEMS, UNLESS OTHERWISE NOTED. RETURN TO PLANT OPS.
- REFER TO DESIGNATED SUBSTANCE SURVEY AND FOLLOW ALL RECOMMENDED MEASURES INDICATED IN THE REPORT FOR ALL DEMOLITION WORK.



KEYPLAN


N.T.S

ABBREVIATIONS


ACT	ACOUSTICAL CEILING TILES
ALUM	ALUMINUM
CL	CENTER LINE
CMU	CONCRETE MASONRY UNIT
CONC	CONCRETE
CT	CERAMIC TILE
DIA	DIAMETER
DWGS	DRAWINGS
ELEC	ELECTRICAL
EPOX	EPOXY FLOOR COATING
EQ	EQUAL
EXT	EXTERIOR
FRR	FIRE RESISTANCE RATING
FD	FLOOR DRAIN
FL	FLOOR
GALV	GALVANIZED
GWB	GYP SUM WALL BOARD
MAX	MAXIMUM
MECH	MECHANICAL
MIN	MINIMUM
NIC	NOT IN CONTRACT
NTS	NOT TO SCALE
O.C.	ON CENTER
PART	PARTITION
PREF	PRE-FINISHED
PT	PAINTED
RO	ROUGH OPENING
RM	ROOM
SS	STAINLESS STEEL
SIM	SIMILAR
SPECS	SPECIFICATIONS
SQ M	SQUARE METER
STRUCT	STRUCTURAL
TYP	TYPICAL
U/S	UNDERSIDE
W/	WITH
WD	WOOD

SYMBOLS


Section Marker

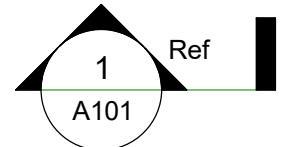

Elevation Marker

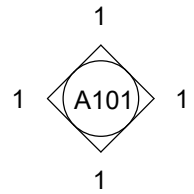


North Arrow

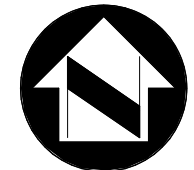


Elevation Datum Marker



Titelmark

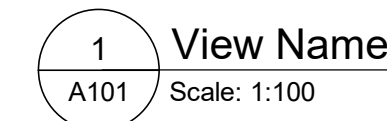


Grid

 


TAGS

 Room & Unit Tags




Wall Tags

 


Floor Tags



 
Door Tag



Keynote Tag

 

Finish Tags

 

COPYRIGHT:
This drawing has been prepared solely for the intended use, thus any reproduction or distribution for any purpose other than authorized by Arcadis is forbidden. Written dimensions shall have precedence over scaled dimensions. Contractors shall verify and be responsible for all dimensions and conditions on the job, and Arcadis shall be informed of any variations from the dimensions and conditions shown on the drawing. Shop drawings shall be submitted to Arcadis for general confirmation before proceeding with fabrication.
Arcadis Professional Services (Canada) Inc.

B	25-03-18
A	24-11-29
NO.	DATE

ISSUED FOR TENDER
ISSUED FOR PERMIT

C.H.	
C.H.	
NO.	DATE

REVISIONS	INITIAL	SIGNED
-----------	---------	--------



WILLIAM FERNANDES, P.ENG.
DIRECTOR,
WATER TREATMENT AND SUPPLY

SIMON HOPTON, P.ENG.
DIRECTOR,
DESIGN & CONSTRUCTION
MAJOR INFRASTRUCTURE

R.C. HARRIS WATER TREATMENT PLANT INSTALLATION OF STANDBY GENERATOR FOR CRITICAL LOADS GENERAL INFORMATION

ARCHITECTURAL					
DESIGN:	M. K.	DRAFTING:	D. M.	CHECK:	M. K.
SCALE:	As indicated			DRAWING NUMBER:	2F-2017-08-5
DATE:	2025-03-18				A001



B	25-03-18
A	24-11-29
NO.	DATE

C.H.	
C.H.	
INITIAL	SIGNED




TORONTO WATER
ENGINEERING AND CONSTRUCTION SERVICES

SIMON HOPTON, P.ENG DIRECTOR, DESIGN & CONSTRUCTION MAJOR INFRASTRUCTURE

ARCHITECTURAL

DESIGN:	M. K.	DRAFTING:	D. M.	CHECK:	M. K.	CONTRACT No.	25ECS-MI-03HA
SCALE:	As indicated			DRAWING NUMBER:	2F-2017-08-6		A100
DATE:	2025-03-18						


3/17/2025 8:29:44 AM

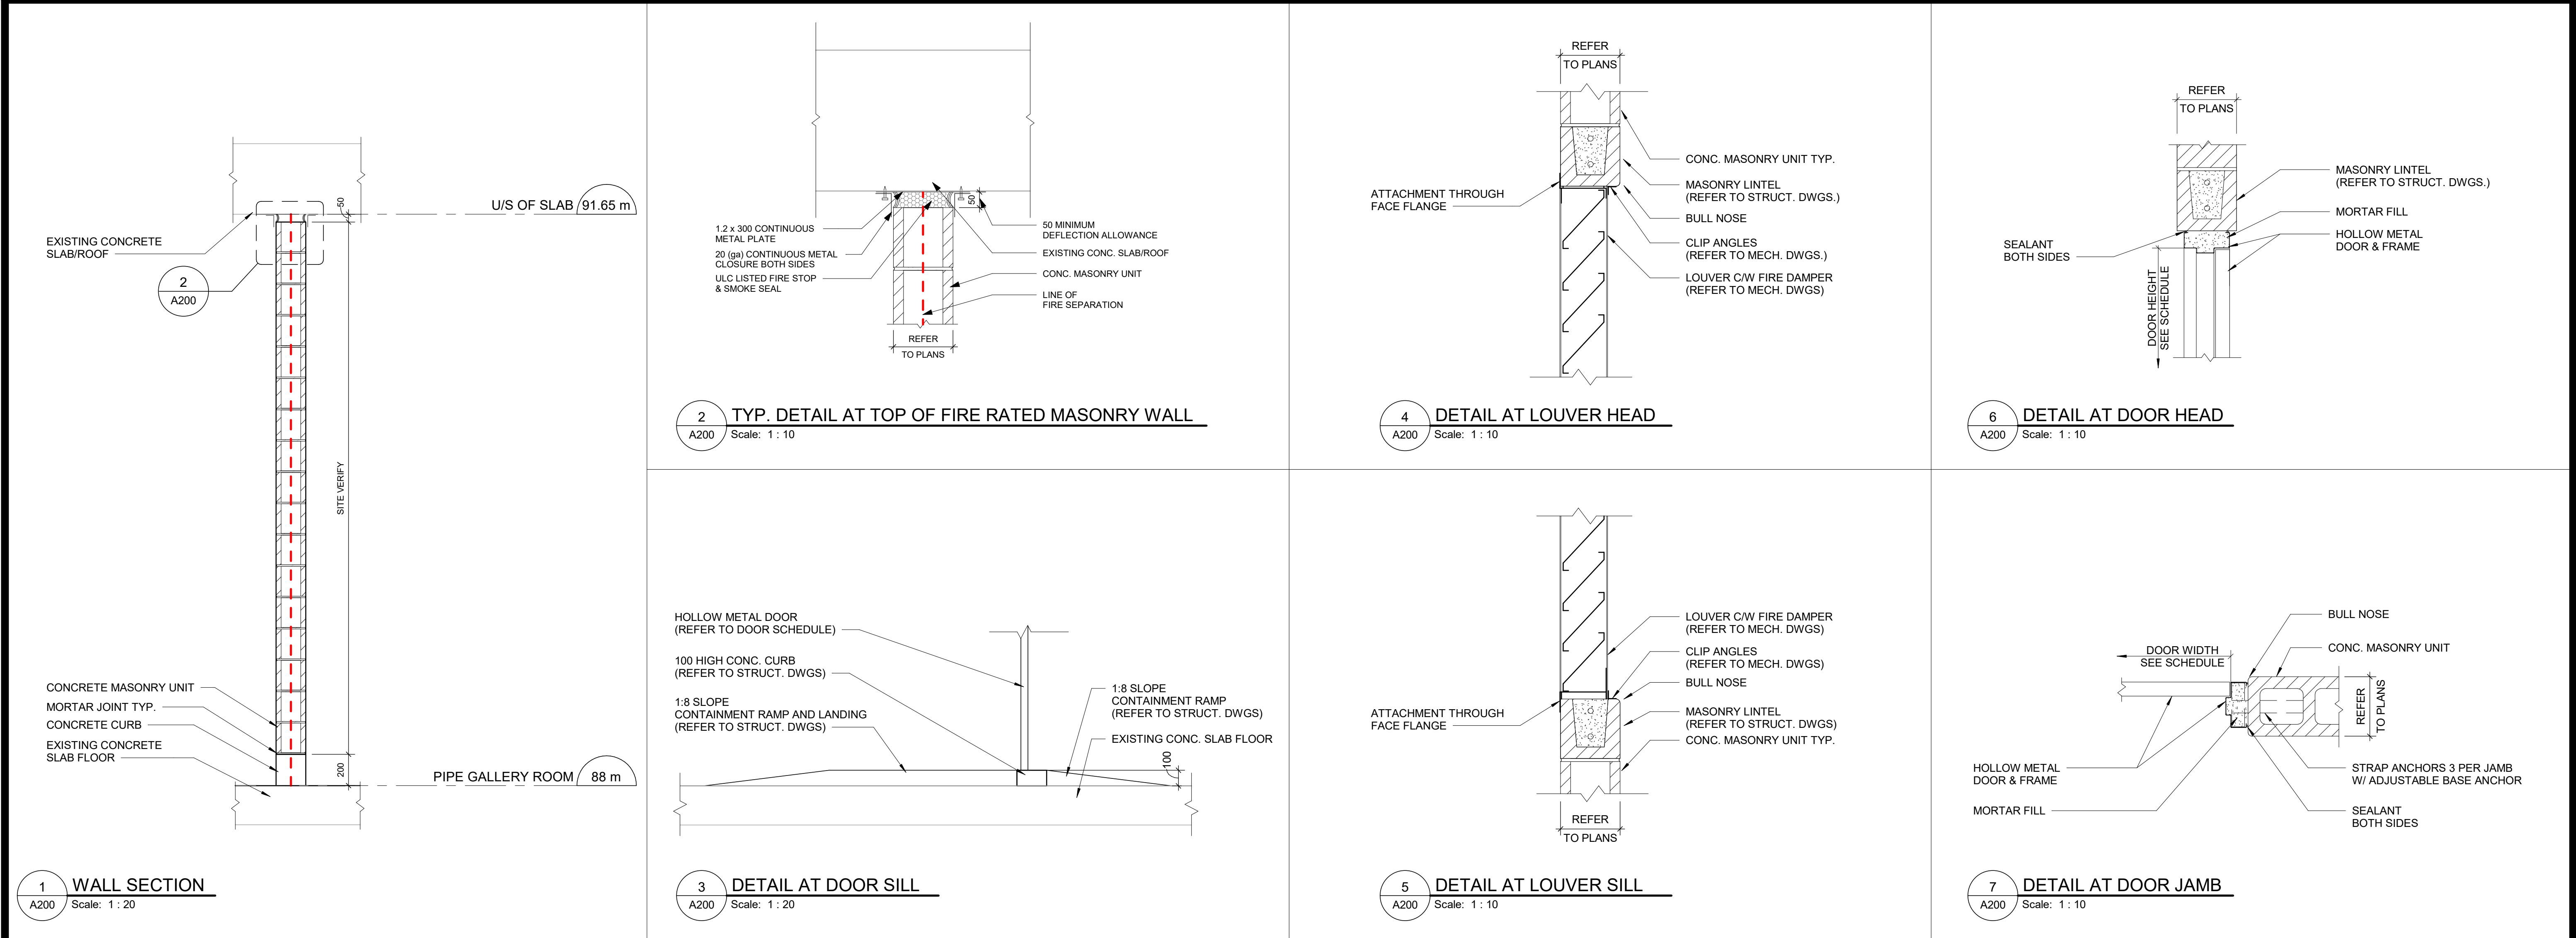

ROOM MATERIAL AND FINISH SCHEDULE												
ROOM NUMBER	ROOM NAME	FLOORS		WALLS								REMARKS
		MATERIAL	FINISH	NORTH		EAST		SOUTH		WEST		
				MATERIAL	FINISH	MATERIAL	E. WALL FINISH	MATERIAL	FINISH	MATERIAL	FINISH	
07-7001A	GENERATOR ROOM	CONC.	EPOX	CMU	PT	CMU	PT	CMU	PT	CMU	PT	EPOXY FINISH TO EXTEND BY 200mm UPSTAND AT WALLS

DOOR AND FRAME SCHEDULE												
NO.	LOCATION	DOOR	WIDTH	HEIGHT	THICKNESS	PANEL			FRAME		FIRE RATING	REMARKS
		TYPE				MATERIAL	FINISH	GLAZING	MATERIAL	FINISH		
D1	GENERATOR ROOM	AA	2 x 915	2150	45	HM	PT	N/A	HM	PT	3/4 H	

DOOR TYPES

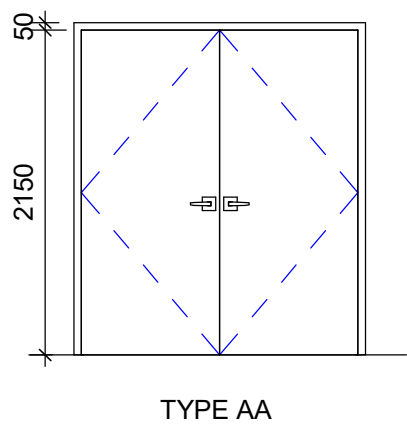

100 - 175 Galaxy Blvd
Toronto ON M9W 0C9 Canada
tel +1 416 679 1930
www.arcadis.com

COPYRIGHT:
This drawing has been prepared solely for the intended use, thus any reproduction or distribution for any purpose other than authorized by Arcadis is forbidden. Written dimensions shall have precedence over scaled dimensions. Contractors shall verify and be responsible for all dimensions and conditions on the job, and Arcadis shall be informed of any variations from the dimensions and conditions shown on the drawing. Shop drawings shall be submitted to Arcadis for general conformance before proceeding with fabrication.
Arcadis Professional Services (Canada) Inc.

TORONTO WATER
ENGINEERING AND CONSTRUCTION SERVICES

WILLIAM FERNANDES, P.ENG.
DIRECTOR,
WATER TREATMENT AND SUPPLY

SIMON HOPTON, P.ENG.
DIRECTOR,
DESIGN & CONSTRUCTION
MAJOR INFRASTRUCTURE

Issued For Tender

REVISIONS					
NO.	DATE	REVISIONS	INITIAL	SIGNED	
B	25-03-18	ISSUED FOR TENDER		C.H.	
A	24-11-29	ISSUED FOR PERMIT		C.H.	

R.C. HARRIS WATER TREATMENT PLANT
INSTALLATION OF STANDBY GENERATOR FOR CRITICAL LOADS
DETAILS AND SCHEDULES

ARCHITECTURAL					
DESIGN:	M. K.	DRAFTING:	D. M.	CHECK:	M. K.
SCALE:	As indicated			DRAWING NUMBER:	2F-2017-08-7
DATE:	2025-03-18				A200


CONTRACT No. 25ECS-MI-03HA




9 IMAGE OF TEST PIT
A400 NTS




8 IMAGE OF SLOPE ON LANDSCAPE
A400 NTS

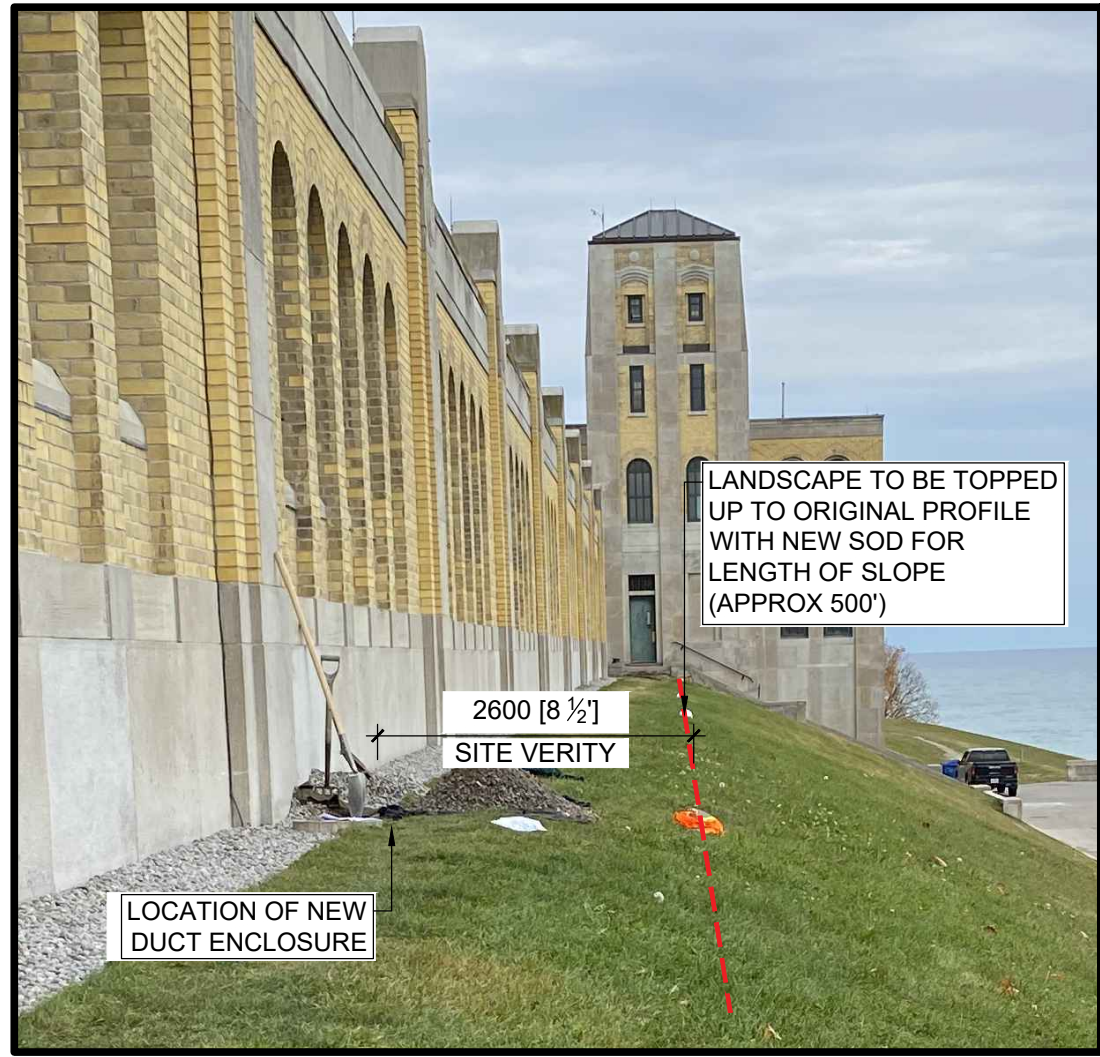


7 IMAGE OF SLOPE ON LANDSCAPE
A400 NTS

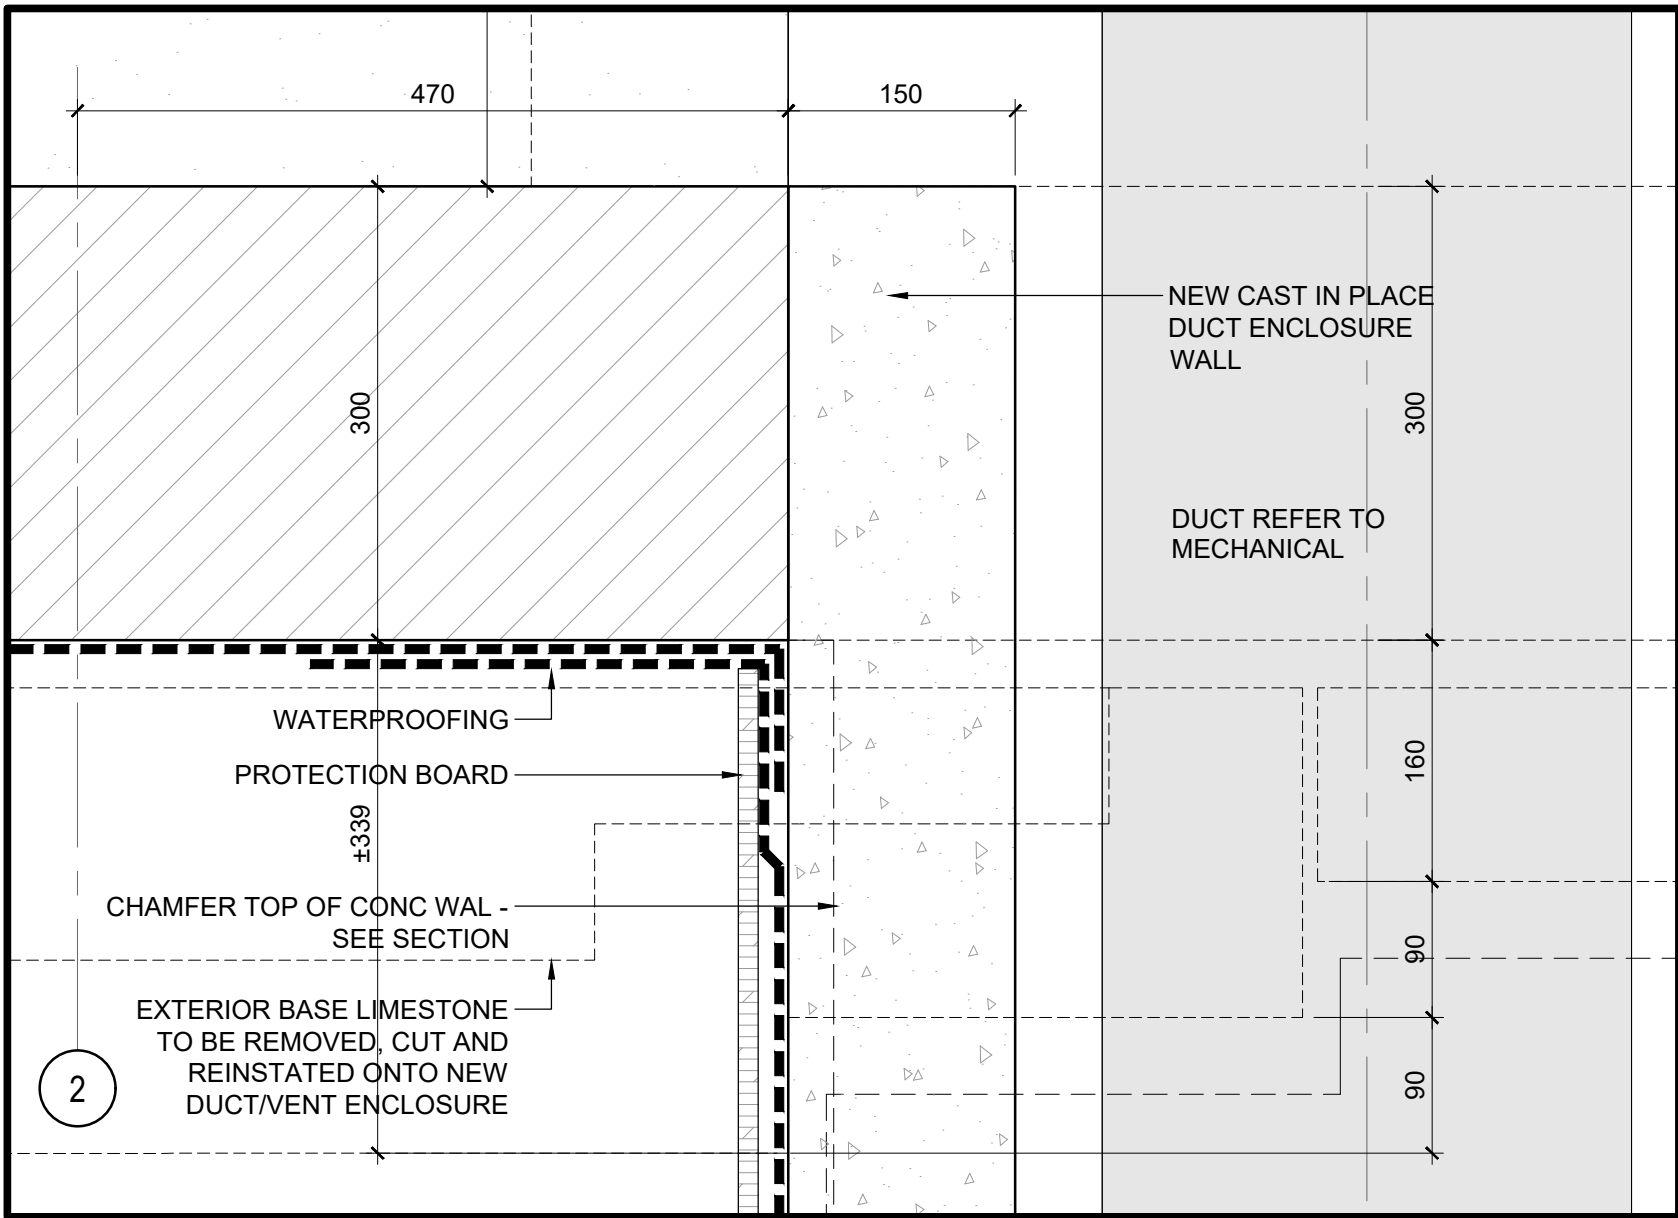


6 DETAIL PLAN
A400 SCALE : 1:5

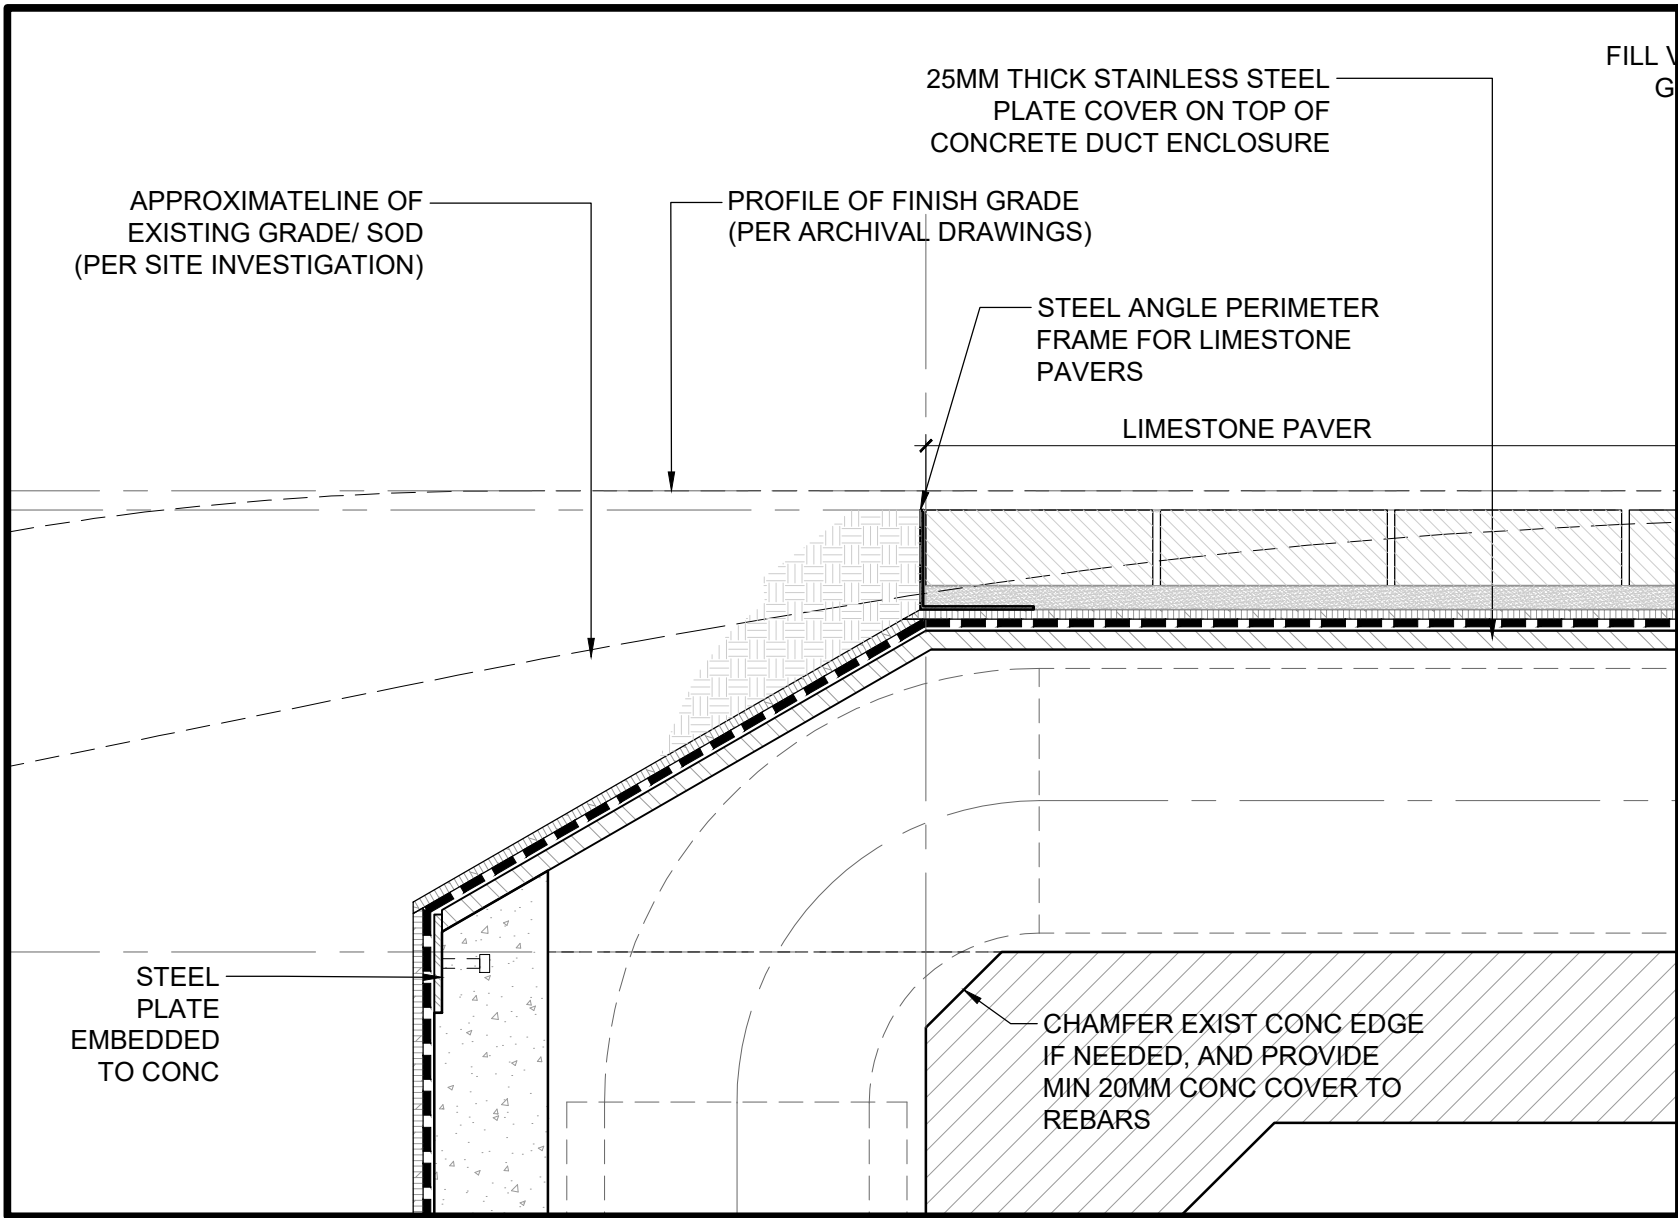


3 DETAIL SECTION
A400 SCALE : 1:5

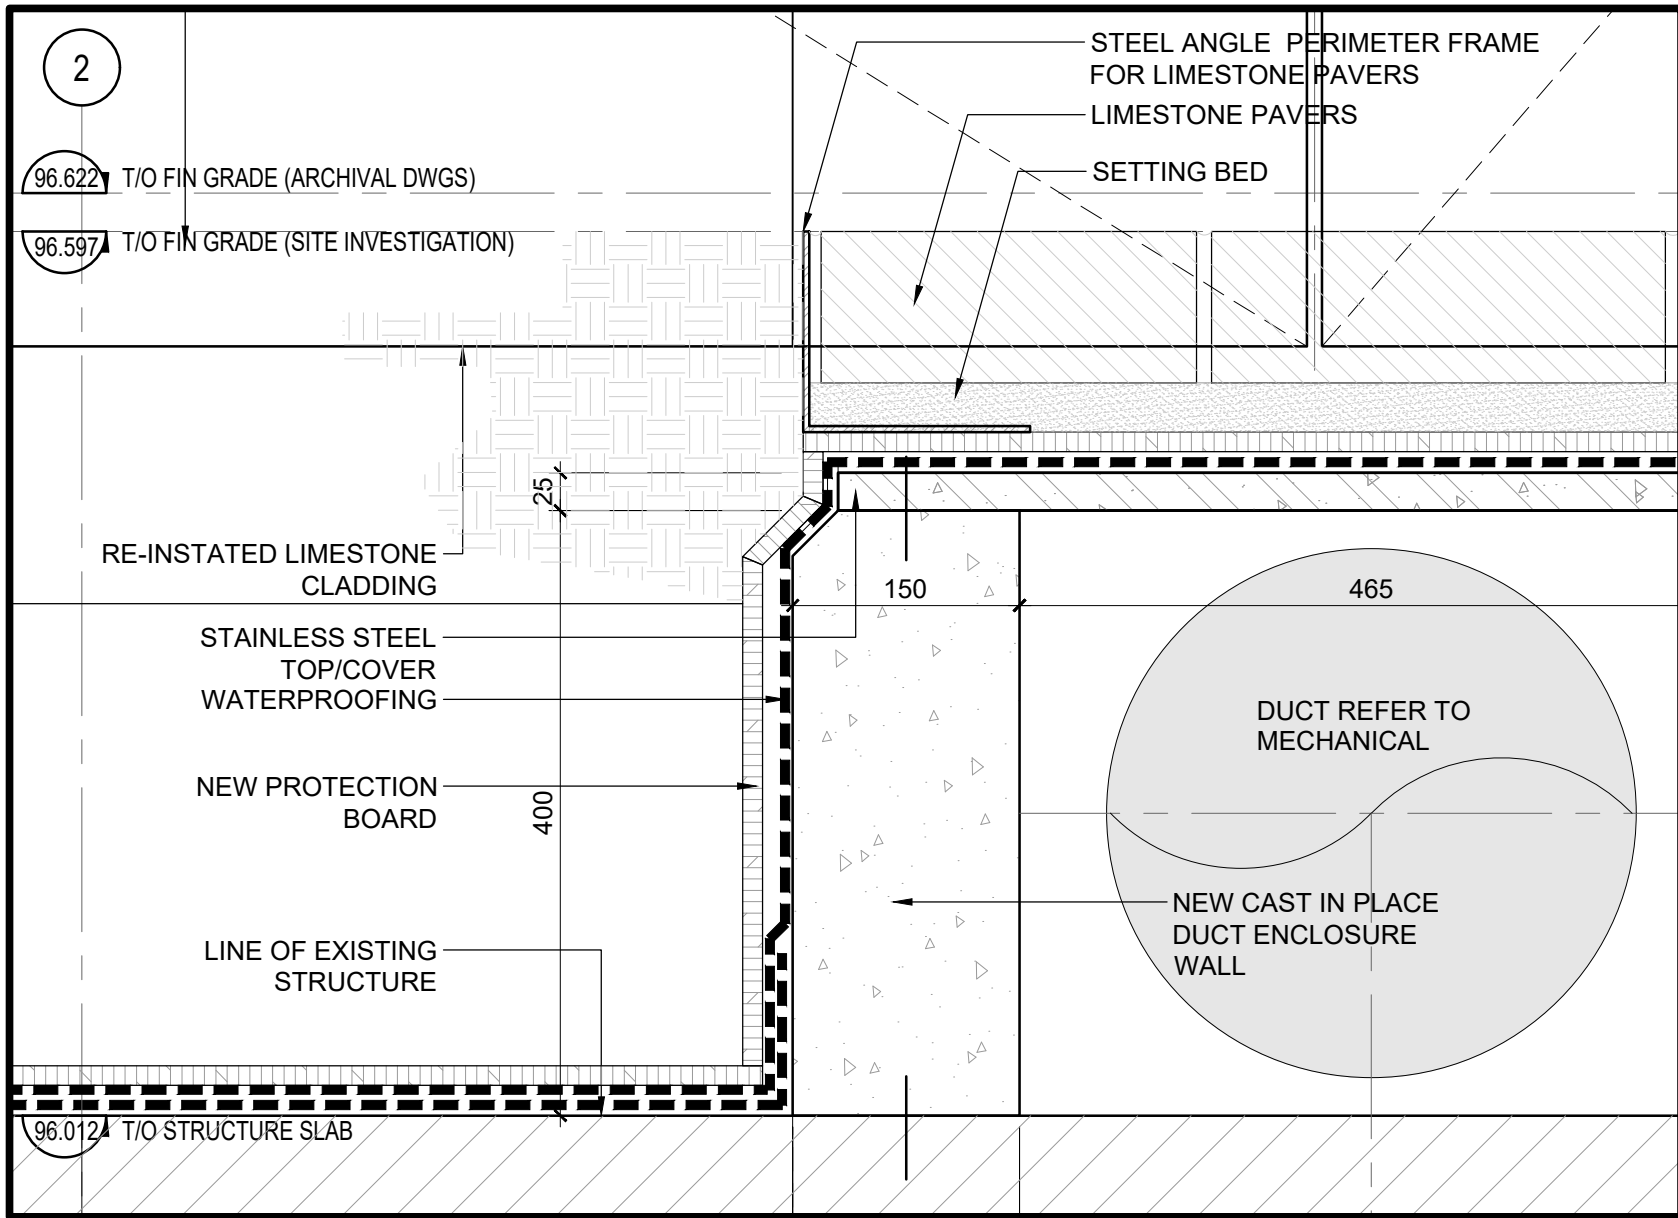


5 DETAIL PLAN
A400 SCALE : 1:5

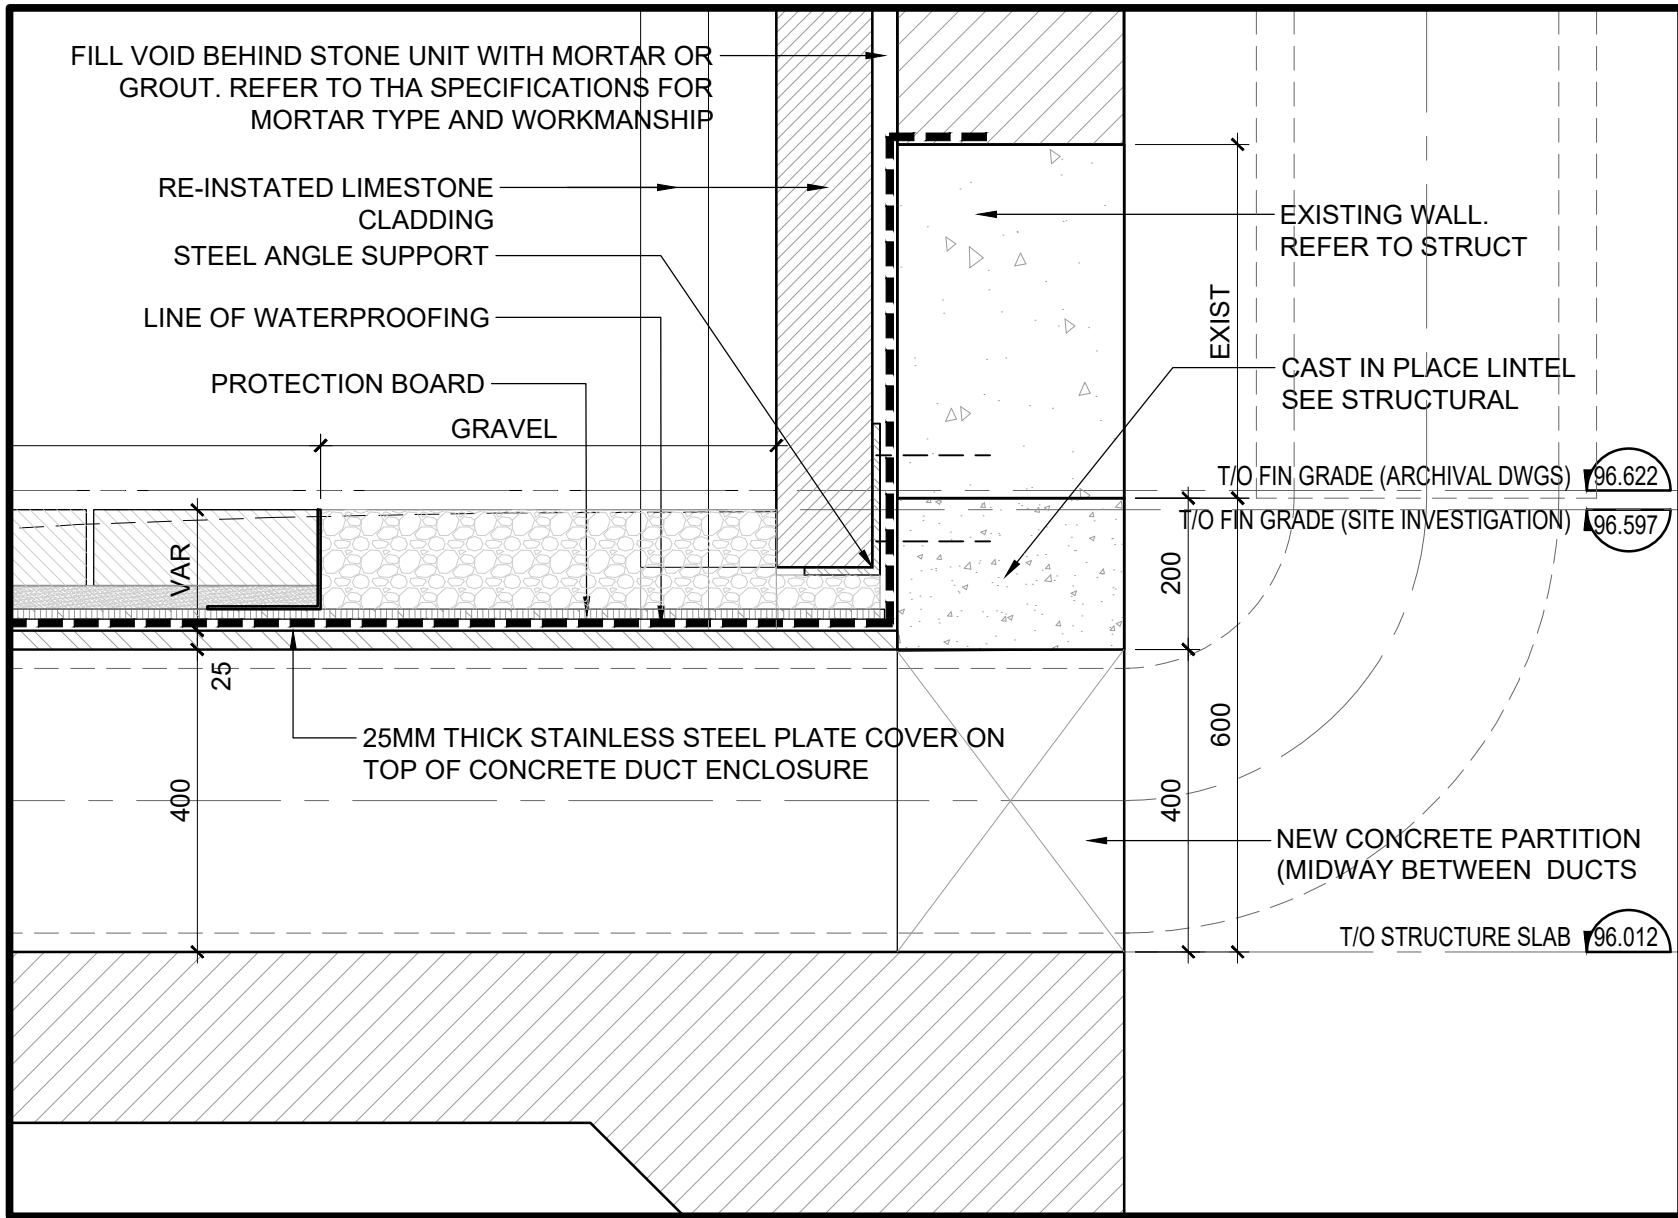

2 DETAIL SECTION
A400 SCALE : 1:5

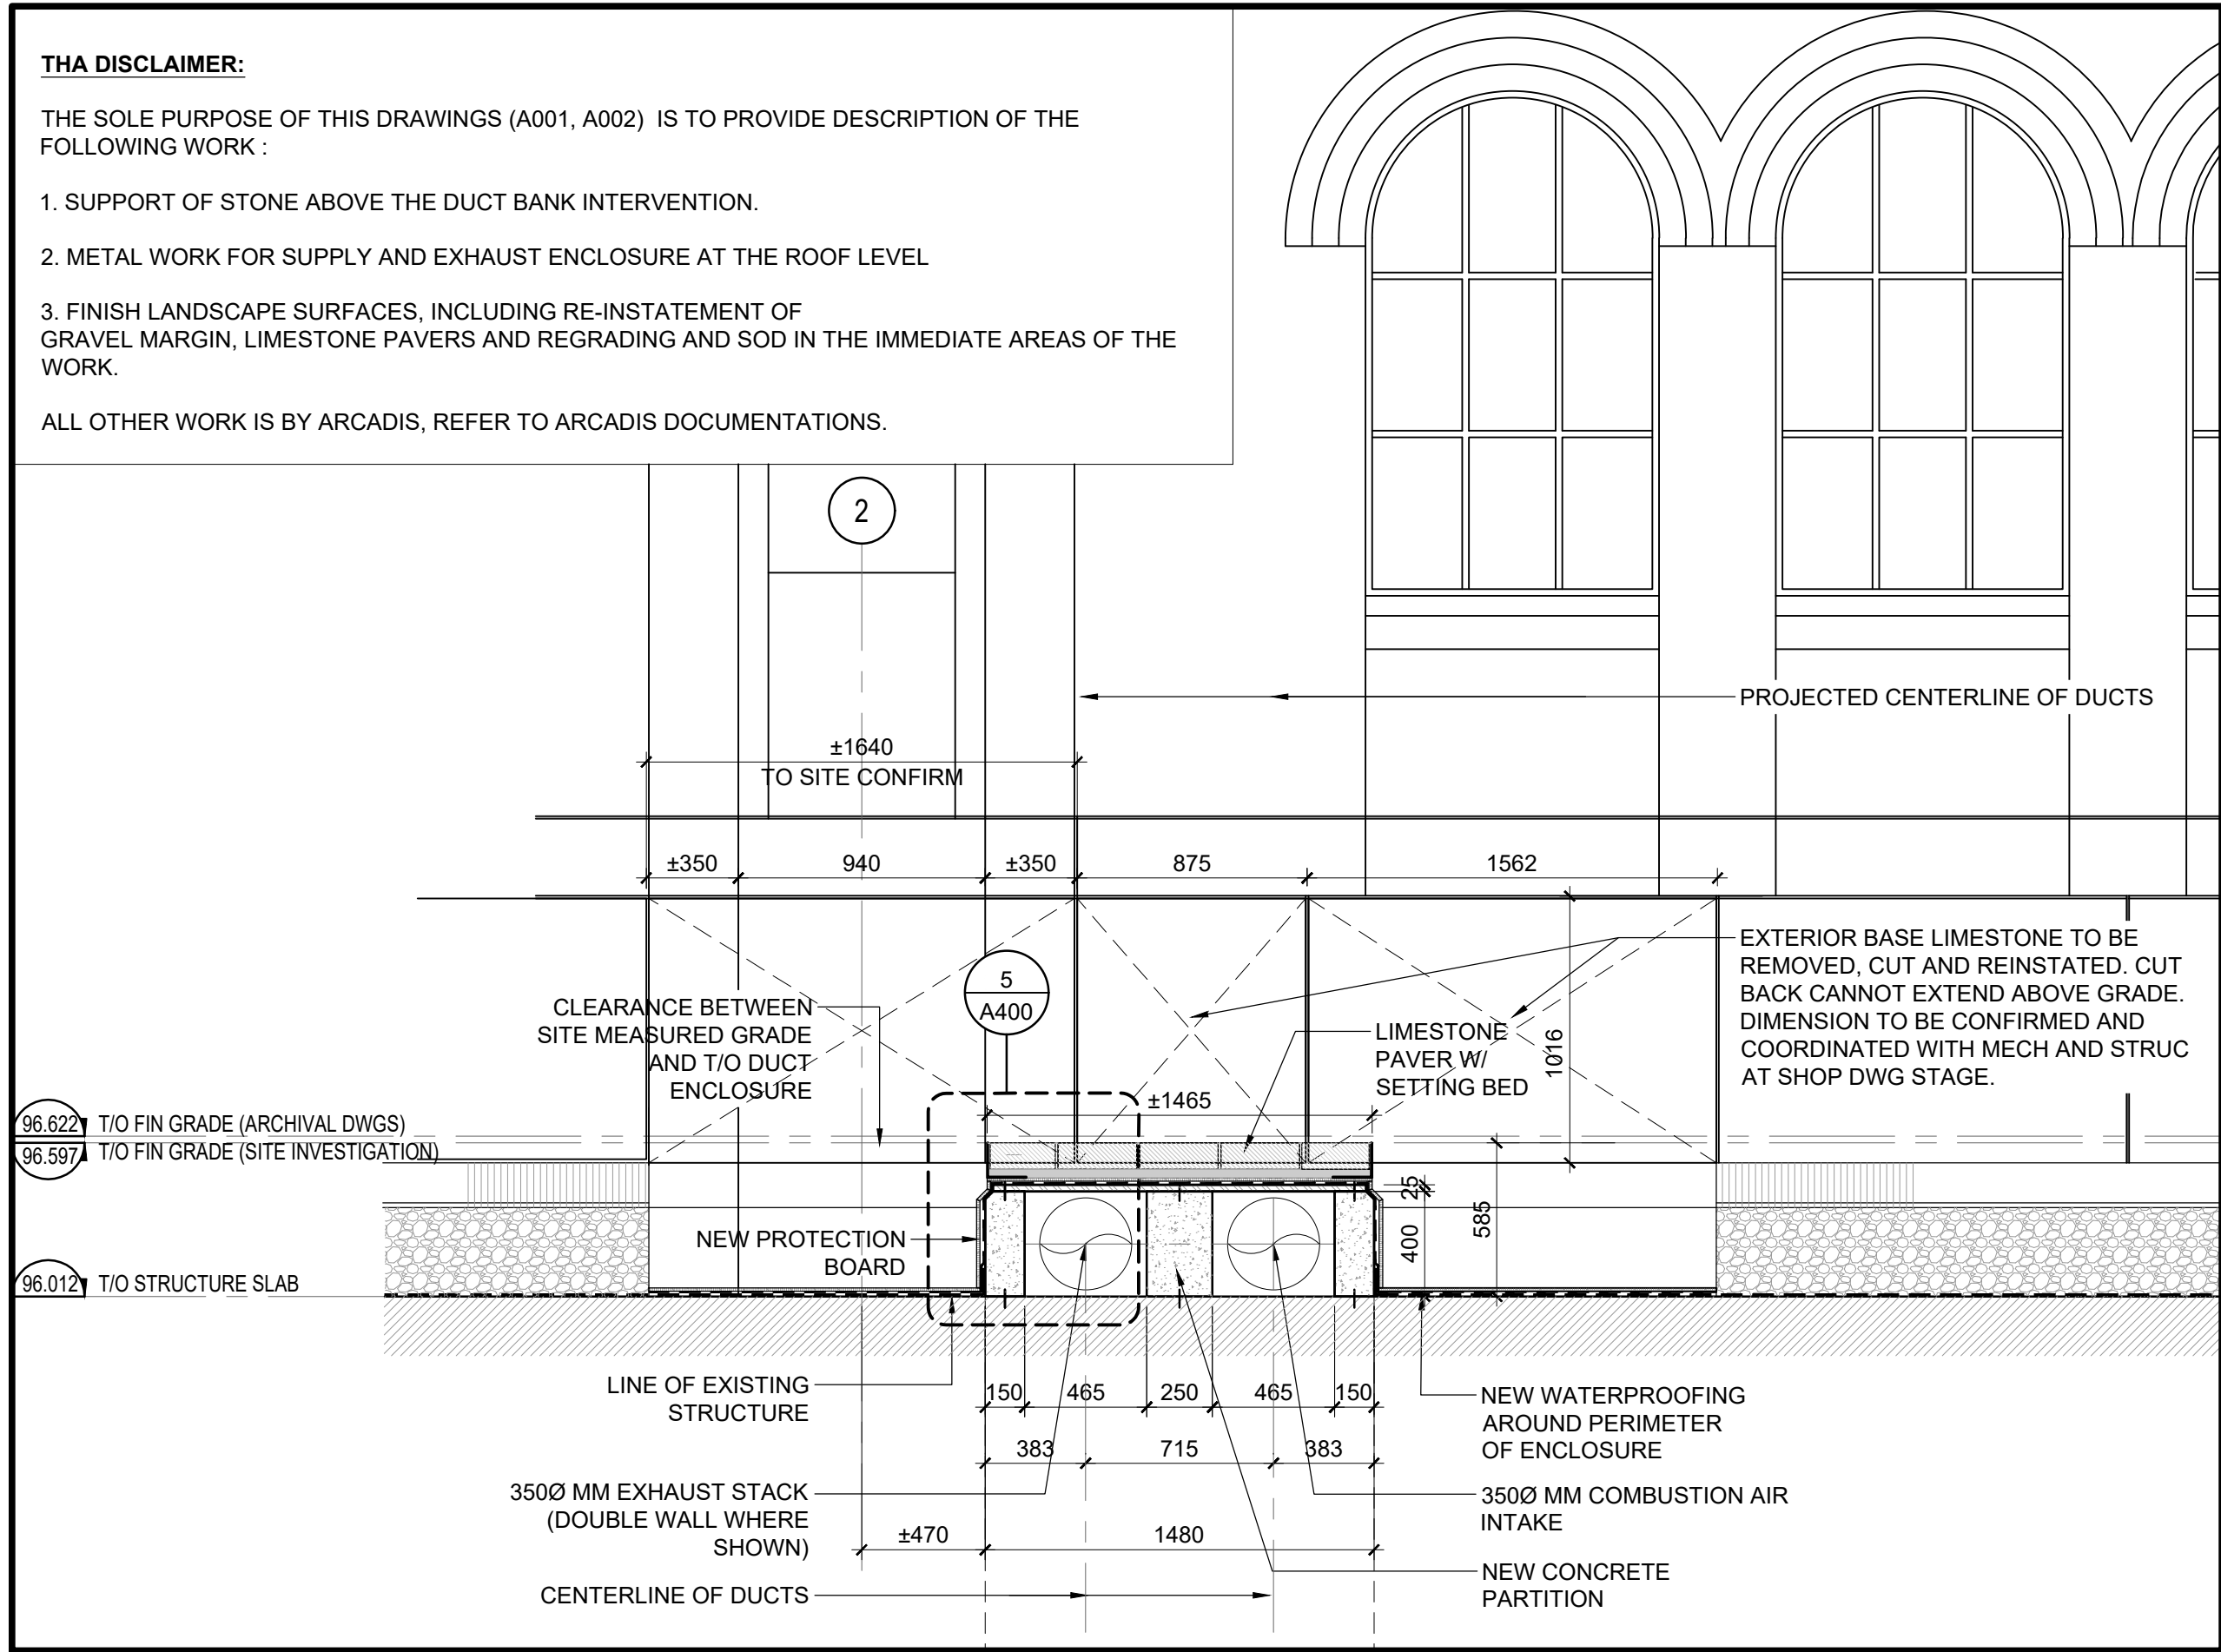

4 ELEVATION - REINSTATEMENT WORK
A400 SCALE : 1:25

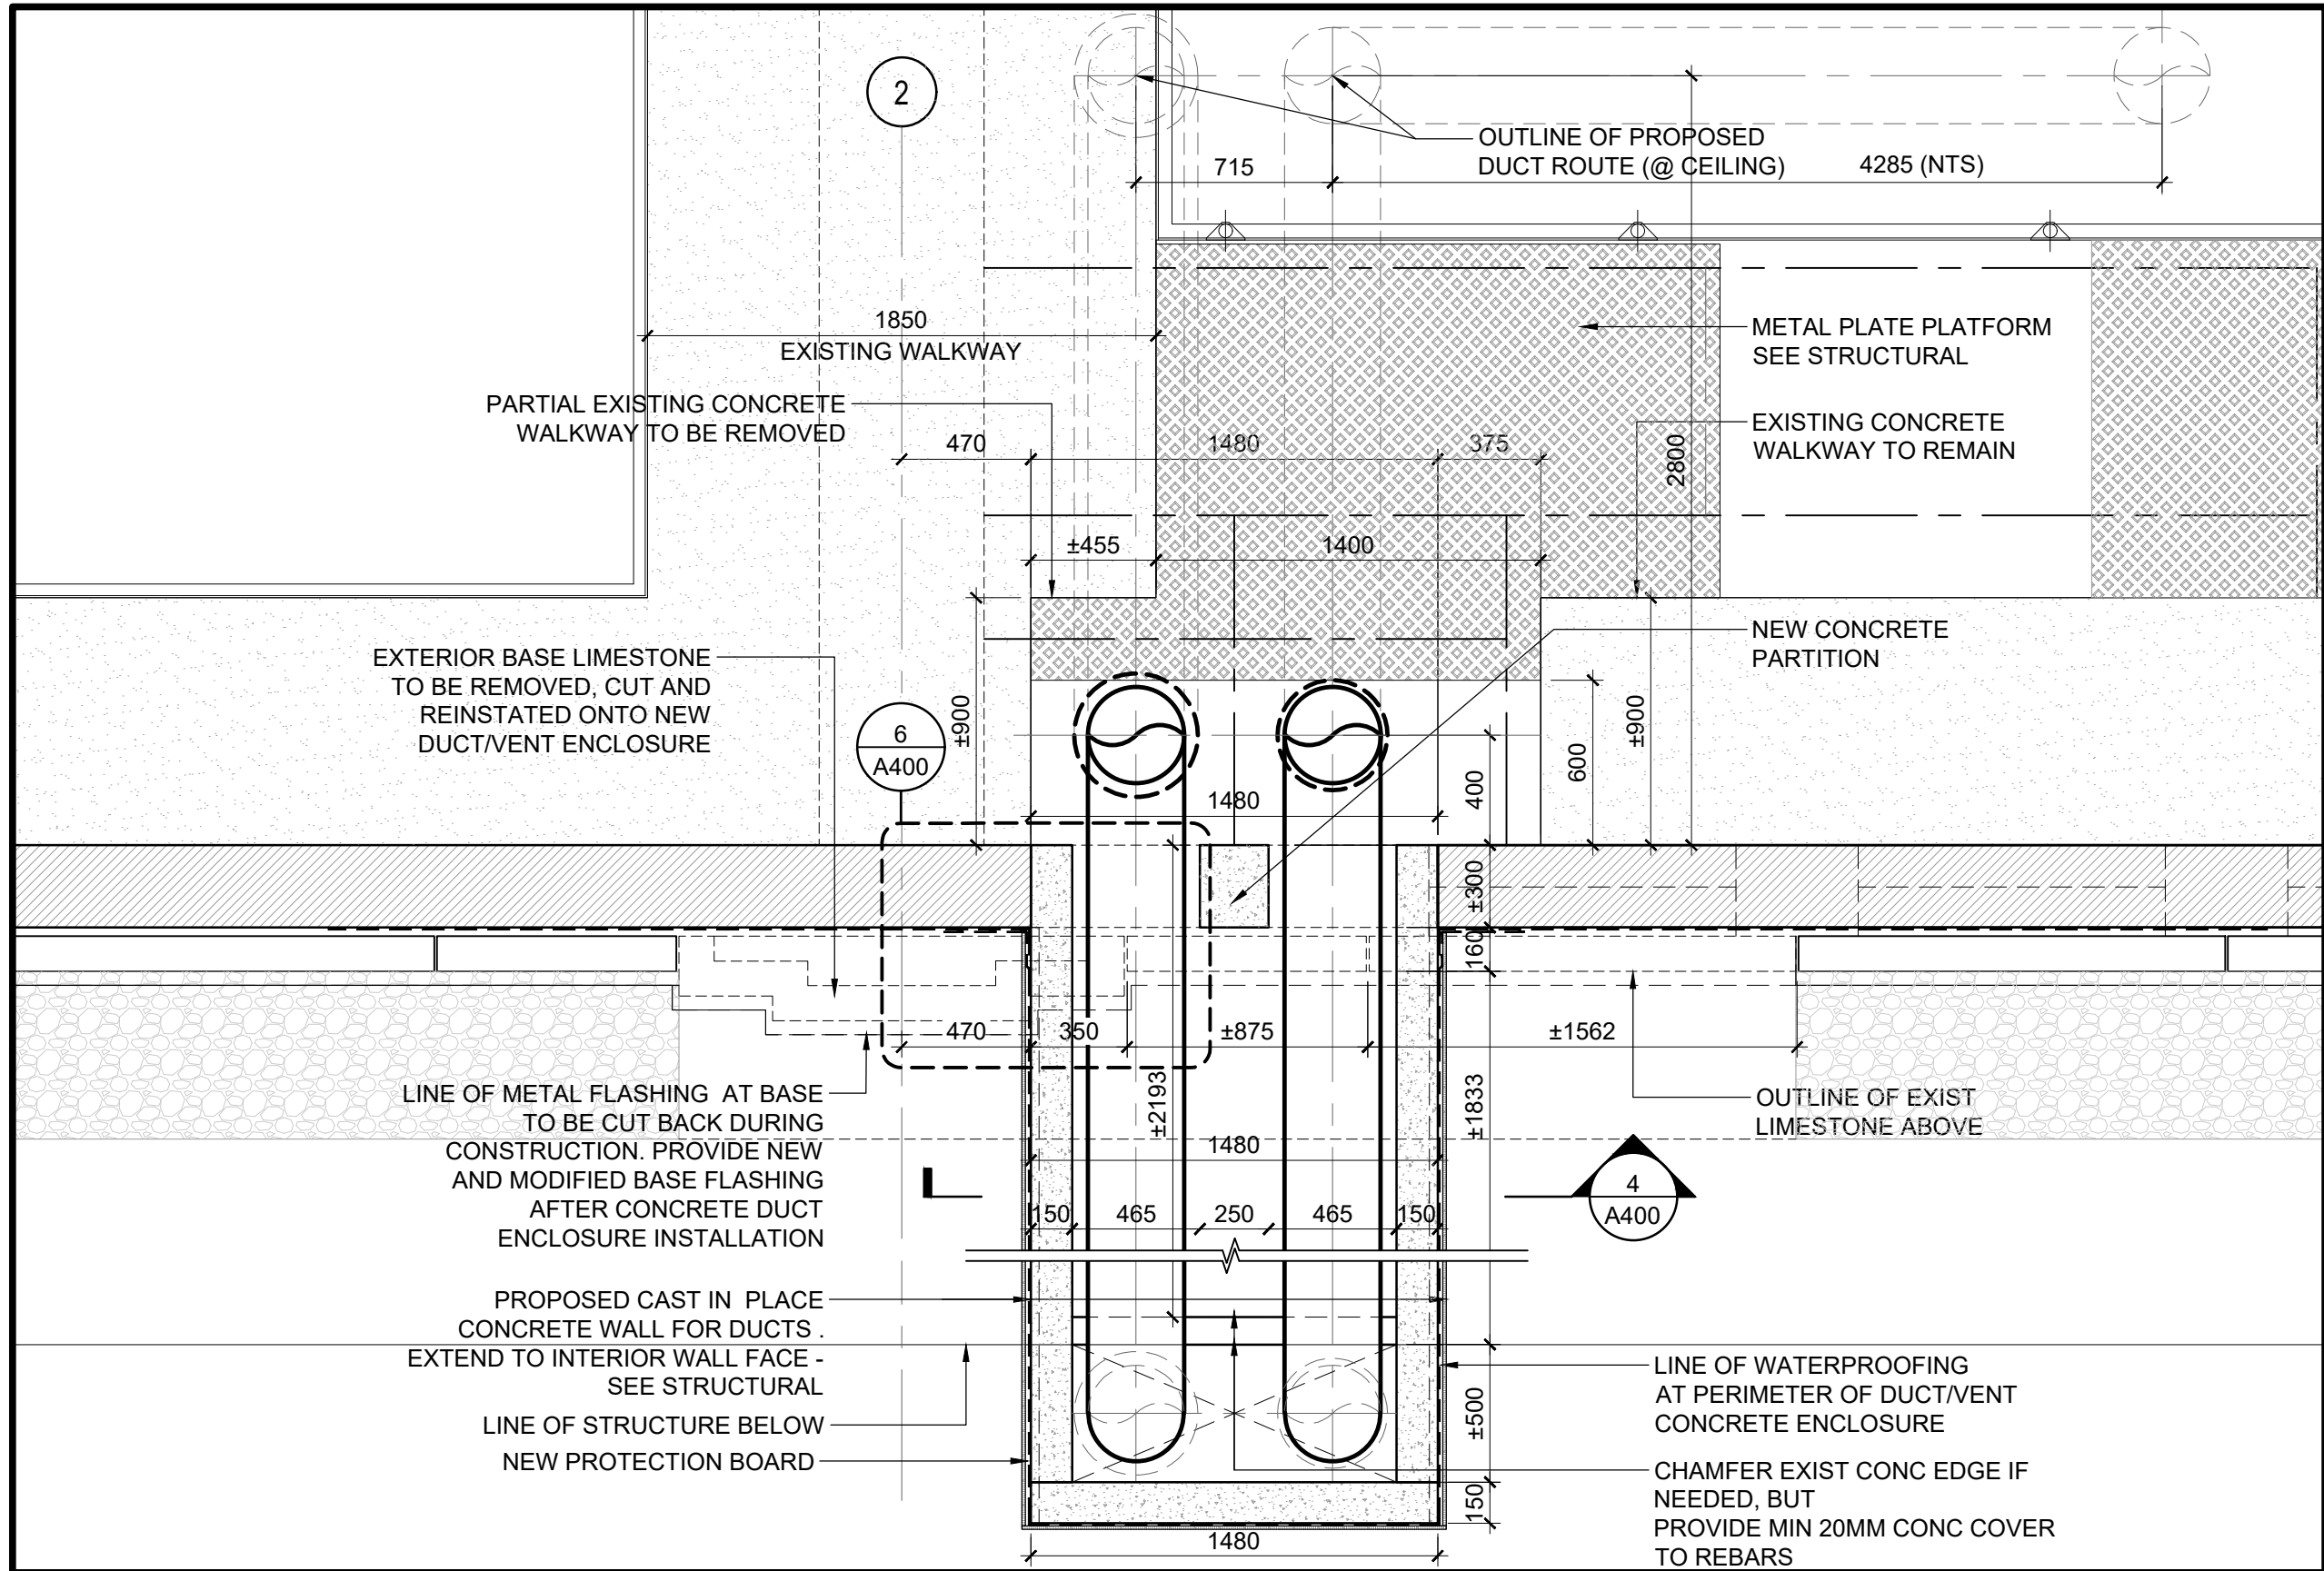

1 PLAN - REINSTATEMENT WORK
A400 SCALE : 1:25

				TORONTO WATER ENGINEERING AND CONSTRUCTION SERVICES		R.C. HARRIS WATER TREATMENT PLANT INSTALLATION OF STANDBY GENERATORS FOR CRITICAL LOADS	
				WILLIAM FERNANDES, P. ENG. DIRECTOR, WATER TREATMENT AND SUPPLY		SIMON HOPTON, P. ENG. DIRECTOR DESIGN & CONSTRUCTION MAJOR INFRASTRUCTURE	
100-175 GALAXY BOULEVARD TORONTO, ONTARIO, M9W 0C9 TEL 416 679 1930 FAX 416 675 4620 www.arcadis.com		ARCHITECTURAL		LOU DI GIRONIMO GENERAL MANAGER TORONTO WATER		ARCHITECTURAL	
COPYRIGHT: This drawing has been prepared solely for the intended use. No reproduction or distribution for any purpose other than authorized by ARCADIS is permitted. Written dimensions shall have precedence over scaled dimensions. Contractors shall verify and be responsible for all dimensions and conditions on the job, and ARCADIS shall be informed of any variations from the dimensions and conditions shown on the drawing. Shop drawings shall be submitted to B1 Group for general conformance before proceeding with fabrication.		B 25-03-18 A 24-11-29		ISSUED FOR TENDER ISSUED FOR PERMIT		DESIGN: DRAFTING: CHECK: CONTRACT No. 25ECS-MI-03HA	
ARCADIS Professional Services (Canada) Inc.		NO. DATE		REVISIONS		SCALE: DATE: 2024-09-30	
				C.H. C.H. INITIAL SIGNED		DRAWING NUMBER: 2F-2017-08-9	
						A400	

GENERAL NOTES:

1.

CONSTRUCTION TO BE IN ACCORDANCE WITH THE LATEST EDITION OF THE ONTARIO BUILDING CODE AND ALL HEALTH AND SAFETY REGULATIONS (OHSA).
2.

THE CONTRACTOR IS TO CHECK AND VERIFY ALL DIMENSIONS ON THE STRUCTURAL DRAWINGS WITH THE PIPING LAYOUT DRAWINGS AND ALL OTHER CONTRACT DOCUMENTS BEFORE CONSTRUCTION. ANY DISCREPANCIES OR ERRORS MUST BE REPORTED TO THE ENGINEER PRIOR TO COMMENCING OF WORK.
3.

PROVIDE ALL REQUIRED TEMPORARY BRACING AND SUPPORTS FOR ALL SLABS, BEAMS, WALLS AND FRAMES. TEMPORARY BRACING AND SUPPORTS MUST BE CAPABLE OF TRANSFERRING ALL IMPOSED CONSTRUCTION AND DEAD LOADS TO THE STRUCTURE WITHOUT EXCEEDING SPECIFIED DESIGN LOADS.
4.

BEFORE CASTING CONCRETE, ENSURE THAT ALL EMBEDDED ITEMS, SUCH AS ANCHOR BOLTS AND SLEEVES ARE IN POSITION AND SECURELY FASTENED IN PLACE TO THE SATISFACTION OF THE ENGINEER.
5.

COORDINATE ALL STRUCTURAL WORK WITH ALL OTHER DISCIPLINES INCLUDING MECHANICAL, ELECTRICAL AND CIVIL WORKS.
6.

CONTRACTOR TO PROVIDE NECESSARY MEASURES TO PROTECT PROPERTIES, STRUCTURES, EXISTING UTILITIES ADJACENT TO WORKS.
7.

DAMAGE TO ADJACENT STRUCTURES, UTILITIES SHALL BE PREVENTED DURING CONSTRUCTION. ANY DAMAGE CAUSED BY THE CONSTRUCTION WORK SHALL BE REPAIRED BY THE CONTRACTOR AT NO ADDITIONAL COST TO THE CONTRACT.
8.

CONTRACTOR TO REINSTATE DISTURBED AREA TO THE ORIGINAL CONDITION OR BETTER.

DESIGN CRITERIA:

1.

FOR DESIGN LOADS SEE GENERAL ARRANGEMENT PLAN PERTAINING TO EACH STRUCTURE.

- 1.1.

APPLICABLE BUILDING CODE: 2012 ONTARIO BUILDING CODE (OBC).
- 1.2.

OBC IMPORTANCE CATEGORY: POST-DISASTER

Is (ULS) = 1.25

Is (SLS) = 0.9

Iw (ULS) = 1.25

Iw (SLS) = 0.75

Ie (ULS) = 1.5

- 1.3.

SITE LOCATION: SCARBOROUGH, ONTARIO

- 1.4.

SNOW LOAD DATA:

GROUND SNOW LOAD,

Ss = 1.2 kPa

ASSOCIATED RAIN LOAD,

Si = 0.4 kPa

REFER TO ROOF PLANS FOR SNOW ACCUMULATION DIAGRAMS, IF APPLICABLE.

- 1.5.

RAIN LOAD DATA:

ONE DAY RAIN (1/50) = 92mm

- 1.6.

WIND LOAD DATA:

1/50 YEAR HOURLY WIND PRESSURE, qso = 0.47 kPa

EXPOSURE CATEGORY = OPEN TERRAIN

- 1.7.

SEISMIC LOAD DATA:

HORIZONTAL SPECTRAL ACCELERATION VALUES

Sa (0.2) = 0.219

Sa (0.5) = 0.116

Sa (1.0) = 0.06

Sa (2.0) = 0.029

PEAK GROUND ACCELERATION, PGA = 0.14

2.

DESIGN LOADS INDICATED ARE SERVICE LOADS.

3.

PIPE GALLERY AND GENERATOR ROOM

LIVE LOAD

9.6kPa

4.

TRUCK LOAD: WHEEL LOADS (AS NOTED ON PLAN).

5.

BACKFILL: FILL MATERIAL,

UNIT WEIGHT=21kN/m³

FRICTION ANGLE = 28°

NATIVE SOIL (SAND TO SANDY SILT/SILT SAND)

UNIT WEIGHT=22kN/m³

FRICTION ANGLE = 30°

MATERIALS:

1.

CONCRETE 28-DAY COMPRESSIVE STRENGTH: STRUCTURAL CONCRETE.
CLASS OF EXPOSURE: A-1
MAX. WATER-TO-CEMENTING MATERIAL RATIO: 0.4
56 DAY COMPRESSIBLE STRENGTH: 35MPa
MASS CONCRETE , FILL CONCRETE OR MUD SLAB:
28 DAYS COMPRESSIVE STRENGTH: 5MPa
UNSHRINKABLE FILL:
56 DAYS COMPRESSIVE STRENGTH: 35MPa
2.

A 50mm LEAN MIX CONCRETE MUD SLAB IS REQUIRED UNDER ALL CAST-IN-PLACE CONSTRUCTION AGAINST GROUND UNLESS NOTED OTHERWISE. EXTEND 300 MIN BEYOND FOUNDATIONS UNO.
3.

ALL EXPOSED CONCRETE EDGES TO HAVE 20mm CHAMFER UNO.

CAST-IN-PLACE CONCRETE:

1.

CONCRETE MATERIALS AND METHODS OF CONCRETE CONSTRUCTION CAN/CSA-A23.1 AND A23.2 (LATEST EDITIONS). CODE FOR THE DESIGN OF CONCRETE STRUCTURES CAN3-A23.3 (LATEST EDITION).
2.

FORMWORK AND TOLERANCES TO CONFORM TO CAN/CSA-A23.1.
3.

ALL REINFORCING BARS SHALL BE SUPPORTED IN THE FORMS AND SPACED WITH STANDARD ACCESSORIES SO THAT THERE IS NO MOVEMENT DURING CONCRETE PLACEMENT.
4.

REINFORCING IS TO BE GENERALLY DETAILED IN ACCORDANCE WITH R.S.I.C. MANUAL OF STANDARD PRACTICE (LATEST EDITION).
5.

THE CLEAR DISTANCE BETWEEN REINFORCING STEEL AND SURFACE OF CONCRETE SHALL REFER TO STRUCTURAL TYPICAL DETAILS.
FOR LOCATIONS WHERE 40mm AGGREGATE ARE USED, INCREASE CLEAR COVER FOR CAST-IN-PLACE CONCRETE TO 60mm.
6.

ALL REINFORCING STEEL IN PLACE TO BE INSPECTED BY ENGINEER BEFORE POURING THE CONCRETE.
7.

SUBMIT REINFORCING SHOP DRAWINGS BEFORE FABRICATION FOR REVIEW BY ENGINEER.
8.

PROTECT ALL AREAS WHERE CONCRETE IS TO BE POURED WITH A MINIMUM OF 50mm THICK "MUD" SLAB WHICH WILL FUNCTION AS A WORKING MAT ONLY AND WILL NOT BE CONSIDERED TO PROVIDE A CONTRIBUTION TO THE OVERALL SLAB THICKNESS.

CONSTRUCTION JOINTS:

1.

CONSTRUCTION JOINTS SHALL BE LOCATED SO AS NOT TO IMPAIR THE STRENGTH OF THE STRUCTURE. THE CONTRACTOR MUST SUBMIT THE PROPOSED CONSTRUCTION JOINTS LAYOUT TO THE ENGINEER FOR REVIEW AND APPROVAL PRIOR TO CONSTRUCTION.
2.

WHERE A CONSTRUCTION JOINT IS TO BE MADE, THE SURFACE OF THE SET CONCRETE SHALL BE THOROUGHLY CLEANED OF FOREIGN MATTER AND LAITANCE, SATURATED WITH WATER AND LEFT IN A DAMP CONDITION WITH NO FREE WATER ON THE SURFACE IMMEDIATELY BEFORE PLACING ADJACENT CONCRETE.
3.

REINFORCING STEEL PROJECTING THROUGH CONSTRUCTION JOINT SHALL BE THOROUGHLY CLEANED OF LOOSE FLAKY RUST, MUD, OIL, DRIED CONCRETE OR OTHER COATINGS WHICH WOULD REDUCE BOND.
4.

A CONTINUOUS 150 WIDE PVC WATERSTOP MUST BE PROVIDED AT ALL CONSTRUCTION JOINT LOCATIONS FOR WATER TIGHT CONNECTIONS AS INDICATED ON THE TYPICAL JOINT DETAILS.
5.

THE MAXIMUM SPACING OF THE CONSTRUCTION JOINTS IN CAST CONCRETE WALLS SHALL BE 11000mm. ANY VARIATION IN THIS LENGTH MUST BE APPROVED BY CONSULTANT. SUBMIT A FULL CONSTRUCTION JOINT LAYOUT PLAN FOR REVIEW BY ENGINEER.

MASONRY NOTES:

1.

MASONRY WORK SHALL COMPLY TO OBC 4.1 INCLUDING TESTING AND WORKMANSHIP.
2.

CONCRETE BLOCKS SHALL CONFORM TO CSA A165M H/15/A/M FOR LOAD BEARING WALLS EXPOSED TO THE WEATHER. USE HIGHER STRENGTH BLOCK WHERE SPECIFIED ON DRAWINGS.
3.

CONCRETE BLOCK SHALL CONFORM TO CSA A165M/H/15/A/O FOR INTERIOR LOAD BEARING WALLS. USE HIGHER STRENGTH BLOCK WHERE SPECIFIED ON DRAWINGS.
4.

CONCRETE BLOCK MIN. COMPRESSIVE STRENGTH Fm=15 MPa.
5.

REINFORCE EVERY HORIZONTAL (200mm o/c) JOINT WITH HEAVY DUTY (5mm Ø WIRE)
6.

REINFORCE ONE CELL ON EITHER SIDE OF CONTROL JOINT WITH 2-15M VERTICAL AND GROUT SOLID.
7.

REINFORCE TWO CORES UNDER STEEL BEAM BEARING WITH 2-15M VERTICAL EACH CORE FULL HEIGHT AND GROUT SOLID. PROVIDE 2 SOLID COURSES UNDER LINTEL BEARING. NO DUCT OR VOIDS ALLOWED ET BEARING.
8.

REINFORCE TWO CORES ON EITHER OF DOOR AND WINDOW OPENINGS WITH 2-15M VERTICAL EACH CORE FULL HEIGHT AND GROUT SOLID. THE 15M BARS SHALL EXTEND THROUGH BOND BEAM, CONTINUOUS TO TOP OF WALL.
9.

REINFORCE TWO CORES AT ALL WALL ENDS AND AT WALL JUNCTIONS WITH 2-15M VERTICAL EACH CORE FULL HEIGHT AND GROUT SOLID.
10.

MORTAR TYPE-S SHALL BE USED FOR ALL BLOCK WALLS. ALL CORE FILLS, LINTELS, PILASTERS AND BOND BEAMS TO BE FILLED WITH COARSE GROUT TO CSA A179 WITH COMPRESSIVE STRENGTH OF 12 MPa. CONTRACTOR TO TEST MORTAR AND GROUT FOR EACH WORKING DAY. MINIMUM COMPRESSIVE STRENGTH SHALL BE 12.4 MPa FOR TYPE S MORTAR AND 12.0 MPa FOR GROUT. FORWARD TEST RESULTS TO ENGINEER FOR REVIEW.

11.

LINTEL - INSTALL STEEL LINTEL. PROVIDE BLOCK LINTELS ONLY IN SPECIFIC AREAS SPECIFIED IN ARCHITECTURAL DRAWINGS. BLOCK LINTEL TO BE TWO COURSE (400mm) DEEP COMPLETE WITH 2-20M TOP AND BOTTOM FOR OPENINGS 2000mm OR LESS. EXTEND REINFORCING 400mm PAST OPENINGS BOTH SIDES.
12.

VERTICAL CORE FILLS TO BE CAST IN LIFTS OF 1200 (4'0") MAXIMUM. VERTICAL REINFORCING TO HAVE A MAXIMUM LENGTH OF 2000 (6'8") WITHOUT SPLICING. ALL LAPS AND ANCHORAGES IN REINFORCING TO BE 40 DIAMETER MINIMUM UNLESS NOTED OTHERWISE.
13.

THERE IS NO STRAP TIE CONNECTION ALLOWED BETWEEN MASONRY WALL AND STRUCTURAL COLUMNS.
14.

TEMPORARY BRACING AND SHORING TO BE PROVIDED DURING CONSTRUCTION. BRACING AND SHORING DESIGN IS THE CONTRACTORS RESPONSIBILITY.

REINFORCEMENT:

1.

SEE PROJECT SPECIFICATION FOR ALL MATERIAL REQUIREMENTS.
2.

THE WELDING SHALL CONFORM TO THE REQUIREMENTS OF CSA STANDARD W59 (LATEST EDITION) AND THE WELDING COMPANY AND WELDERS SHALL BE QUALIFIED UNDER THE REQUIREMENTS OF CSA STANDARD W47 (LATEST EDITION) FOR THE APPROPRIATE POSITION.
3.

THE MINIMUM YIELD STRESS FOR THE REINFORCING STEEL SHALL BE 400 MPa (60 ksi).
4.

ALL HOOKS SHOWN ON DRAWINGS TO BE STANDARD HOOKS CONFORMING TO CAN/CSA A23.3 UNO.

STRUCTURAL STEEL:

1.

DESIGN AND CONSTRUCTION OF NEW STEEL TO CONFORM TO THE FOLLOWING CODES/STANDARDS (LATEST EDITIONS/REVISIONS):

CSA S16 - DESIGN OF STEEL STRUCTURES
CSA W59 - WELDED STEEL CONSTRUCTION
2.

SUBMIT SHOP DRAWINGS FOR ALL NEW STEEL COMPONENTS SHOWN ON STRUCTURAL DRAWINGS.
3.

HOT DIP GALVANIZING IN ACCORDANCE WITH ASTM A123/A123M.
4.

STANDARD STRUCTURAL SECTIONS TO CSA G40.21M GRADE 350W. HOLLOW STRUCTURAL SECTIONS TO CSA G40.21M GRADE 350W CLASS 'H'. HOT ROLLED STEEL SHEET, PLATE AND STRIP USED IN THE FABRICATION OF WELDED ASSEMBLIES TO CSA G40.21M GRADE 300W.
5.

ALL MATERIAL USED FOR THIS PROJECT SHALL BE NEW, FREE FROM DEFECTS IMPAIRING STRENGTH, DURABILITY AND APPEARANCE.
6.

THE FABRICATOR SHALL BE FULLY-CERTIFIED IN ACCORDANCE WITH CSA W47.1.
7.

BOLTS TO CONFORM TO ASTM A325M UNLESS NOTED OTHERWISE. BOLTS TO BE SUPPLIED WITH HARDENED WASHERS TO ASTM F436 AND HEAVY HEX NUTS TO ASTM A563.
8.

HOT ROLLED STEEL SHEET, PLATE AND STRIP USED IN THE FABRICATION OF WELDED ASSEMBLIES TO CONFORM TO CSA STANDARD G40.21 GR 300W.
9.

ANCHOR BOLTS: ASTM A307, ASTM A325 OR ASTM A316L, AS NOTED ON THE DRAWINGS.
10.

ALL SHOP DRAWINGS SUBMITTED SHALL BEAR THE SIGNATURE AND STAMP OF A QUALIFIED PROFESSIONAL ENGINEER LICENSED IN THE PROVINCE OF ONTARIO.
11.

ALL FABRICATION AND CONSTRUCTION SHALL PROCEED FROM CONTRACT DRAWINGS CERTIFIED "ISSUED FOR CONSTRUCTION".

ALUMINUM:

1.

DESIGN OF ALUMINUM TO CSA S157-05/S157.1-05 (R2010) - STRENGTH DESIGN IN ALUMINUM.
2.

ALUMINUM ALLOY TYPE 6061-T6, UNLESS NOTED OTHERWISE.
3.

ALUMINUM IN CONTACT WITH CONCRETE OR MASONRY TO RECEIVE TWO COATS OF ALKALI RESISTANT BITUMINOUS PAINT. UPON INSTALLATION AND PRIOR TO CASTING CONCRETE THE ALUMINUM IN CONTACT WITH CONCRETE OR MASONRY SHALL RECEIVE ONE COAT OF ALKALI RESISTANT BITUMINOUS PAINT WHERE THE ORIGINAL COATING HAS BEEN DAMAGED.
4.

ALL ALUMINUM SHALL BE ANODIZED UNLESS NOTED OTHERWISE.

STAINLESS STEEL:

1.

DESIGN OF STAINLESS STEEL TO ASCE/SEI 8-02 SPECIFICATION FOR THE DESIGN OF COLD-FORMED STAINLESS STEEL STRUCTURAL MEMBERS (ASCE/SEI 8-02).
2.

STAINLESS STEEL ALLOY TYPE 316L, UNLESS NOTED OTHERWISE.

PRECAST CHANNELS:

1.

GENERAL:

A. INCLUDED:
I. PRECAST CHANNELS
II. REBAR CONNECTIONS.
III. GROUTING OF SLAB JOINTS.
2.

REFERENCE MATERIAL:

A. CSA A23, 4-09: PRECAST CONCRETE MATERIAL & CONSTRUCTION.
B. PRECAST CONCRETE INSTITUTE (PCI): MANUAL ON DESIGN OF CONNECTIONS FOR PRECAST.
C. PRECAST CONCRETE INSTITUTE (PCI): DESIGN HANDBOOK - PRECAST & PRESTRESSED CONCRETE.
3.

SHOP DRAWING:

A. APPROVAL DRAWINGS WILL REQUIRE A REVIEW BY THE CONTRACTOR & DESIGN FIRMS UNDER CONTRACT OF EACH PROJECT. DISCREPANCIES, QUESTIONS & VERIFICATION OF DESIGN IS REQUIRED AND RETURNED IN WRITING PRIOR TO COMMENCEMENT OF PRODUCTION.
B. PRODUCTION DRAWINGS WILL BEAR A SIGNED AND SEALED ENGINEER STAMP, SLAB LOCATIONS, IDENTIFICATION MARKS, CONNECTION DETAILS, DIMENSIONS, OPENINGS LARGER THAN 6" IN SIZE, LOADINGS AND OTHER RELATIVE INFORMATION.
4.

QUALITY ASSURANCE:

A. CONFORMITY TO PCI MANUAL ON DESIGN OF CONNECTION FOR PRECAST PRESTRESSED CONCRETE, PCI DESIGN HANDBOOK - PRECAST & PRESTRESSED CONCRETE, CSA A23.4.
5.

ACCESSORIES:

A. BEARING PADS: 1/8" THICK MASONITE HARDBOARD, SMOOTH SIDE UP.
B. STYROFOAM DISC: 2" THICK ON EXTERIOR WALLS ONLY IF REQUIRED.
C. HANGER FRAMES: WELDED ANGLES USED TO PROVIDE LARGE MECHANICAL OPENINGS THROUGH PRECAST. SIZE AND CONFIGURATION VARIES WITH OPENING.
6.

FINISHES:

A. TOP SURFACE:
I. EXTRUDED (STANDARD SURFACE FROM EXTRUDED METHOD)
II. RAKED (ROUGHENED SURFACE TO ALLOW IMPROVED BOND WITH CONCRETE TAPPING SUPPLIED BY OTHERS).

B. BOTTOM SURFACE:
I. "STANDARD" STEEL FORM FINISH.
7.

INSTALLATION:

A. INSTALL CHANNELS WITH CORRESPONDING IDENTIFICATION MARK AS INDICATED ON PRODUCTION / SHOP DRAWING.
B. PLACE BEARING PADS AND INSERT STYROFOAM DISCS IN CORES WHERE REQUIRED.
C. DRILL OR WELD TIE STEEL REBAR CONNECTIONS AS PER PRODUCTION / SHOP DRAWINGS.
D. GROUT JOINTS BETWEEN PRECAST SLABS.
E. DRILL HOLES FOR PLUMBING TRADE (LOCATED IN FIELD BY OTHERS). DO NOT CUT REINFORCING STRAND UNLESS ENGINEERED IN THE DESIGN.
F. LATEX CAULKING OF JOINTS BETWEEN PRECAST SLABS ON THE UNDERSIDE WHERE EXPOSED TO VIEW.
G. FLOOR PREPARATION WILL VARY DEPENDING ON FINAL FLOORING MATERIAL AND FINISH.
8.

INCLUDED ITEMS RELATED TO PRECAST AND INSTALLATION:

A. DRYPACKING / INFILL OF GAP BETWEEN PRECAT AND STRUCTURE.
B. PERIMETER CAULKING BETWEEN PRECAST AND STRUCTURE.
C. SITE / FIELD DIMENSIONS (CONTRACTOR AND PROJECT DESIGNERS RESPONSIBLE TO PROVIDE INFORMATION DURING SHOP DRAWING APPROVAL).

TEMPORARY EARTH RETENTION SYSTEM:

1.

CONTRACTOR SHALL FURNISH, ERECT, AND REMOVE AS NOTED ALL ELEMENTS OF THE TEMPORARY EARTH RETENTION SYSTEM NECESSARY TO SAFELY MAINTAIN THE REQUIRED OPEN-CUT EXCAVATION DURING THE CONSTRUCTION OF ALL BELOW GROUND WORK. ACTUAL SIZE AND LOCATION OF ALL ELEMENTS OF SYSTEM SHALL BE DETERMINED BY CONTRACTOR AND INDICATED ON SHOP DRAWINGS. CONTRACTOR DESIGN SHALL BE PERFORMED UNDER THE DIRECTION OF, AND SEALED BY, A LICENSED PROFESSIONAL ENGINEER EXPERIENCED IN THIS TYPE OF WORK. SHOP DRAWINGS, INCLUDING DETAILED SEQUENCE OF WORK, SHALL BE SUBMITTED TO ARCHITECT-ENGINEER FOR REVIEW PRIOR TO COMMENCEMENT OF ANY WORK.
2.


VERIFY LOCATION OF ALL UNDERGROUND UTILITIES. ELEMENTS OF RETENTION WALL SHALL BE DESIGNED, INSTALLED, AND REMOVED SO AS TO AVOID DAMAGE TO ANY EXISTING UTILITIES. CONTRACTOR SHALL PROVIDE TEMPORARY SUPPORT AND/OR PROTECTION OF EXISTING UTILITIES WITHIN OR ADJACENT TO EXCAVATED AREA DURING CONSTRUCTION PERIOD.
3.

PROVIDE SUFFICIENT CLEARANCE AROUND RETENTION SYSTEM TO ALLOW COMPLETION OF ALL WORK WITHIN EXCAVATION WITHOUT INTERFERENCE FROM ELEMENTS OF RETENTION SYSTEM.
4.


PROVIDE TIEBACKS AND WALES, AS REQUIRED, OF SUFFICIENT SIZE AND SPACING TO RESIST ALL LOADS.

ABBREVIATIONS:


ADDIT	ADDITIONAL
ADH	ADHESIVE
ALT	ALTERNATIVE
ALUM	ALUMINUM
APPROX B	APPROXIMATE
B#	BOTTOM
BH	CAST-IN-PLACE BEAM TAG
BL	BOREHOLE
BL	BOTTOM LOWER LAYER
BUL	BOTTOM UPPER LAYER
BM	BENCH MARK
CP	COLUMN TAG
CIP	CAST IN PLACE
CIRC	CIRCULAR
CTRL JT	CONTROL JOINT
COL	COLUMN
CONST JT	CONSTRUCTION JOINT
CONC	CONCRETE
CONTI	CONTINUOUS
C/W	COMPLETE WITH
CL	CLEARANCE
DIA	DIAMETER
DL	DEAD LOAD
DN	DOWN
EF	EACH FACE
EL	ELEVATION
EQ	EQUAL
EW	EACH WAY
EX	EXISTING
EXP JT	EXPANSION JOINT
EXT	EXTERIOR
F.F.	FINISHED FLOOR
FD	FLOOR DRAIN
FIN GR	FINISH GRADE
GALV	GALVANIZED
GRAN	GRANULAR
HOG	HOT-DIP GALVANIZED
HP	HIGH POINT
HOF	HORIZONTAL OUTSIDE FACE
HIF	HORIZONTAL INSIDE FACE
HEF	HORIZONTAL EACH FACE
L	LENGTH
LP	LOW POINT
PB#	PRECAST BEAM TAG
PL	PLATE
REINF	REINFORCING
SEP JT	SEPARATION JOINT
SIM	SIMILAR
SPMDD	STANDARD PROCTOR MAXIMUM
	DRY DENSITY
S.S.	STAINLESS STEEL
SLS	SERVICEABILITY LIMIT STATE
STIRRUP	STIRRUP
STD	STANDARD
SQ	SQUARE
T	TREAD
T&B	TOP AND BOTTOM
THK	THICK, THICKNESS
TLL	TOP LOWER LAYER
T/O	TOP OF
T/O CONC	TOP OF CONCRETE
TUL	TOP UPPER LAYER
TYP	TYPICAL
ULS	ULTIMATE LIMIT STATE
UNO	UNLESS NOTED OTHERWISE
U/S	UNDERSIDE
VERT	VERTICAL
VOF	VERTICAL OUTSIDE FACE
VIF	VERTICAL INSIDE FACE
VEF	VERTICAL EACH FACE
W/	WITH
W/O	WITHOUT
WS	WATERSTOP
WWF	WELDED WIRE FABRIC
&	AND
@	AT
€	CENTRELINE
#	NUMBER
%	PER CENT
Ø	DIAMETER
I.D.	INSIDE DIAMETER
O.D.	OUTSIDE DIAMETER

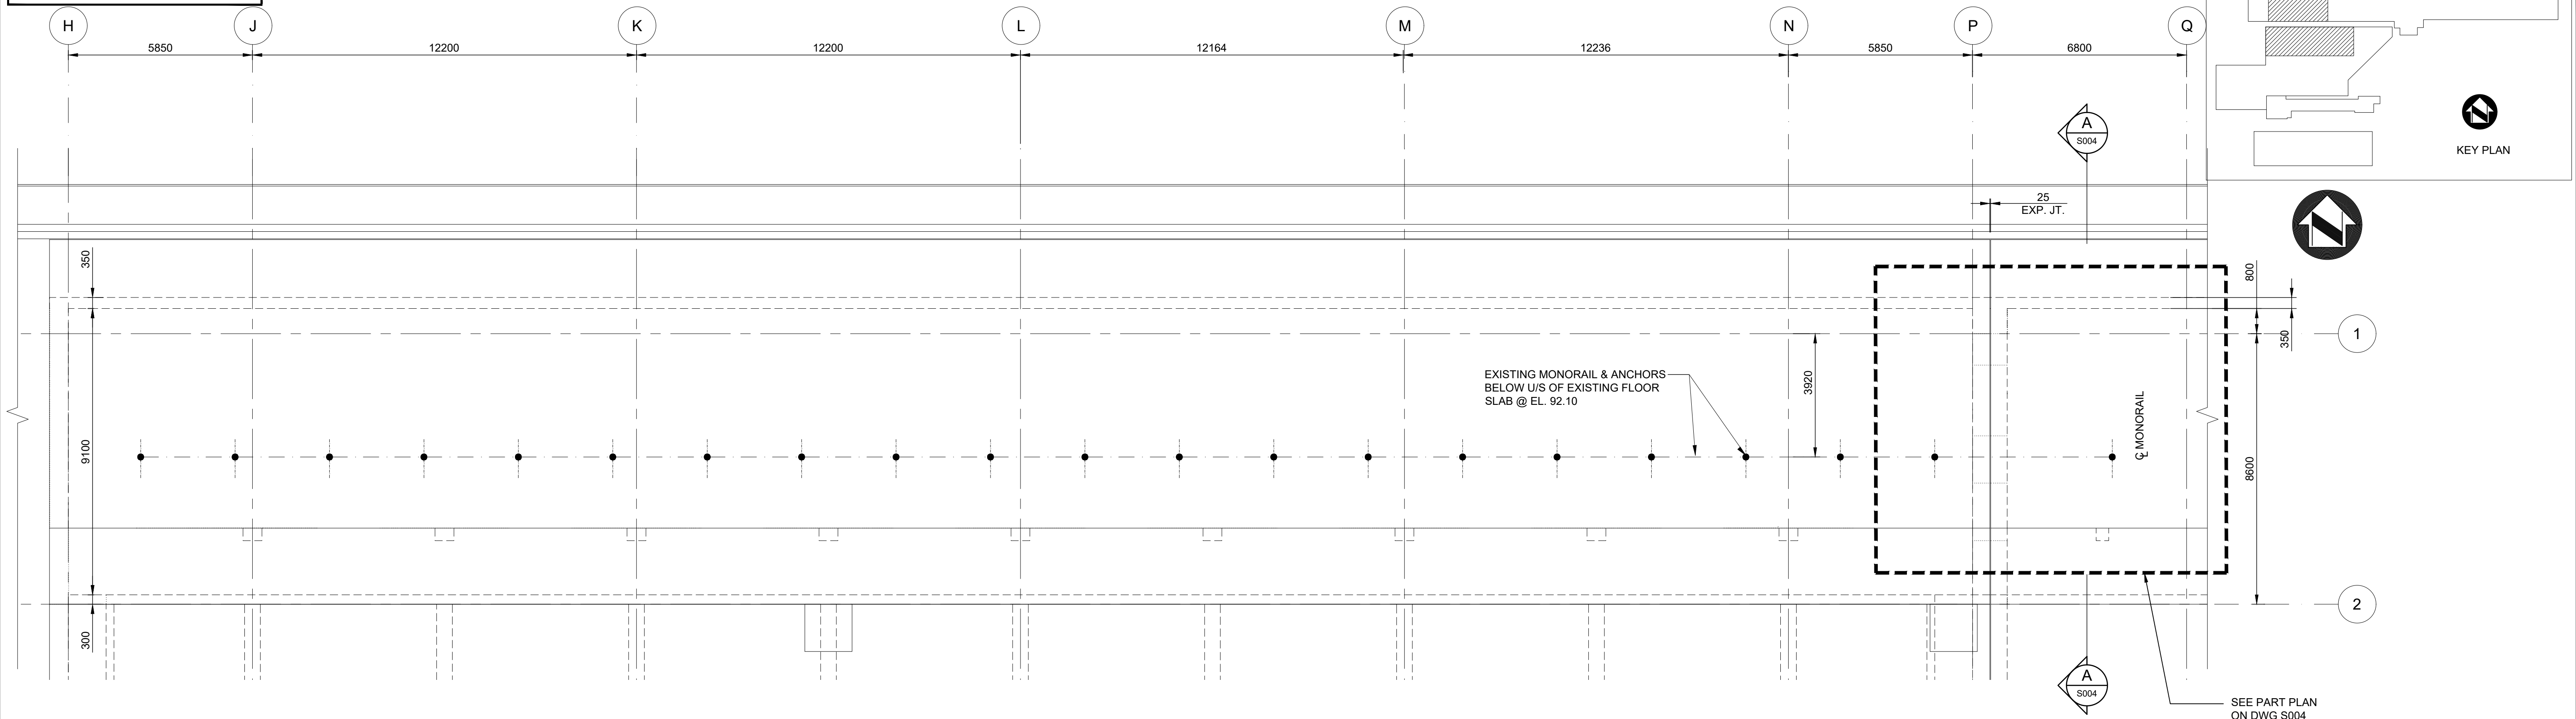


EXISTING ROOF PLAN AT EL. 92.10
1:100

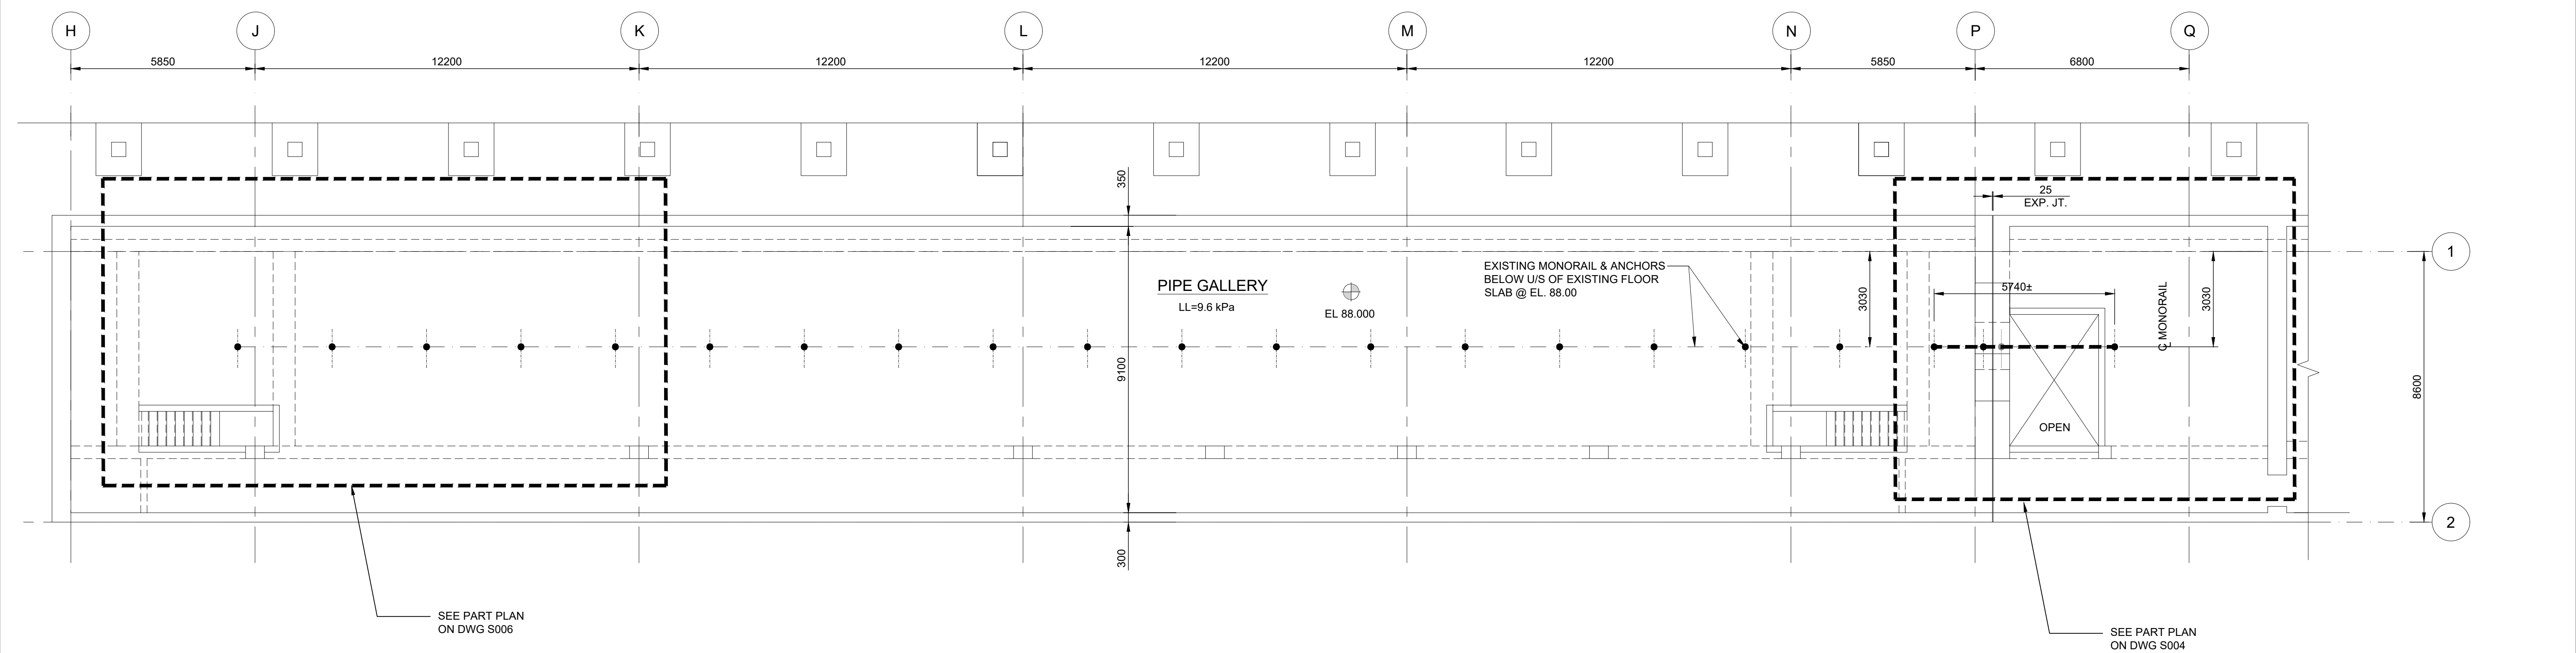


EXISTING PLAN AT EL. 88.00

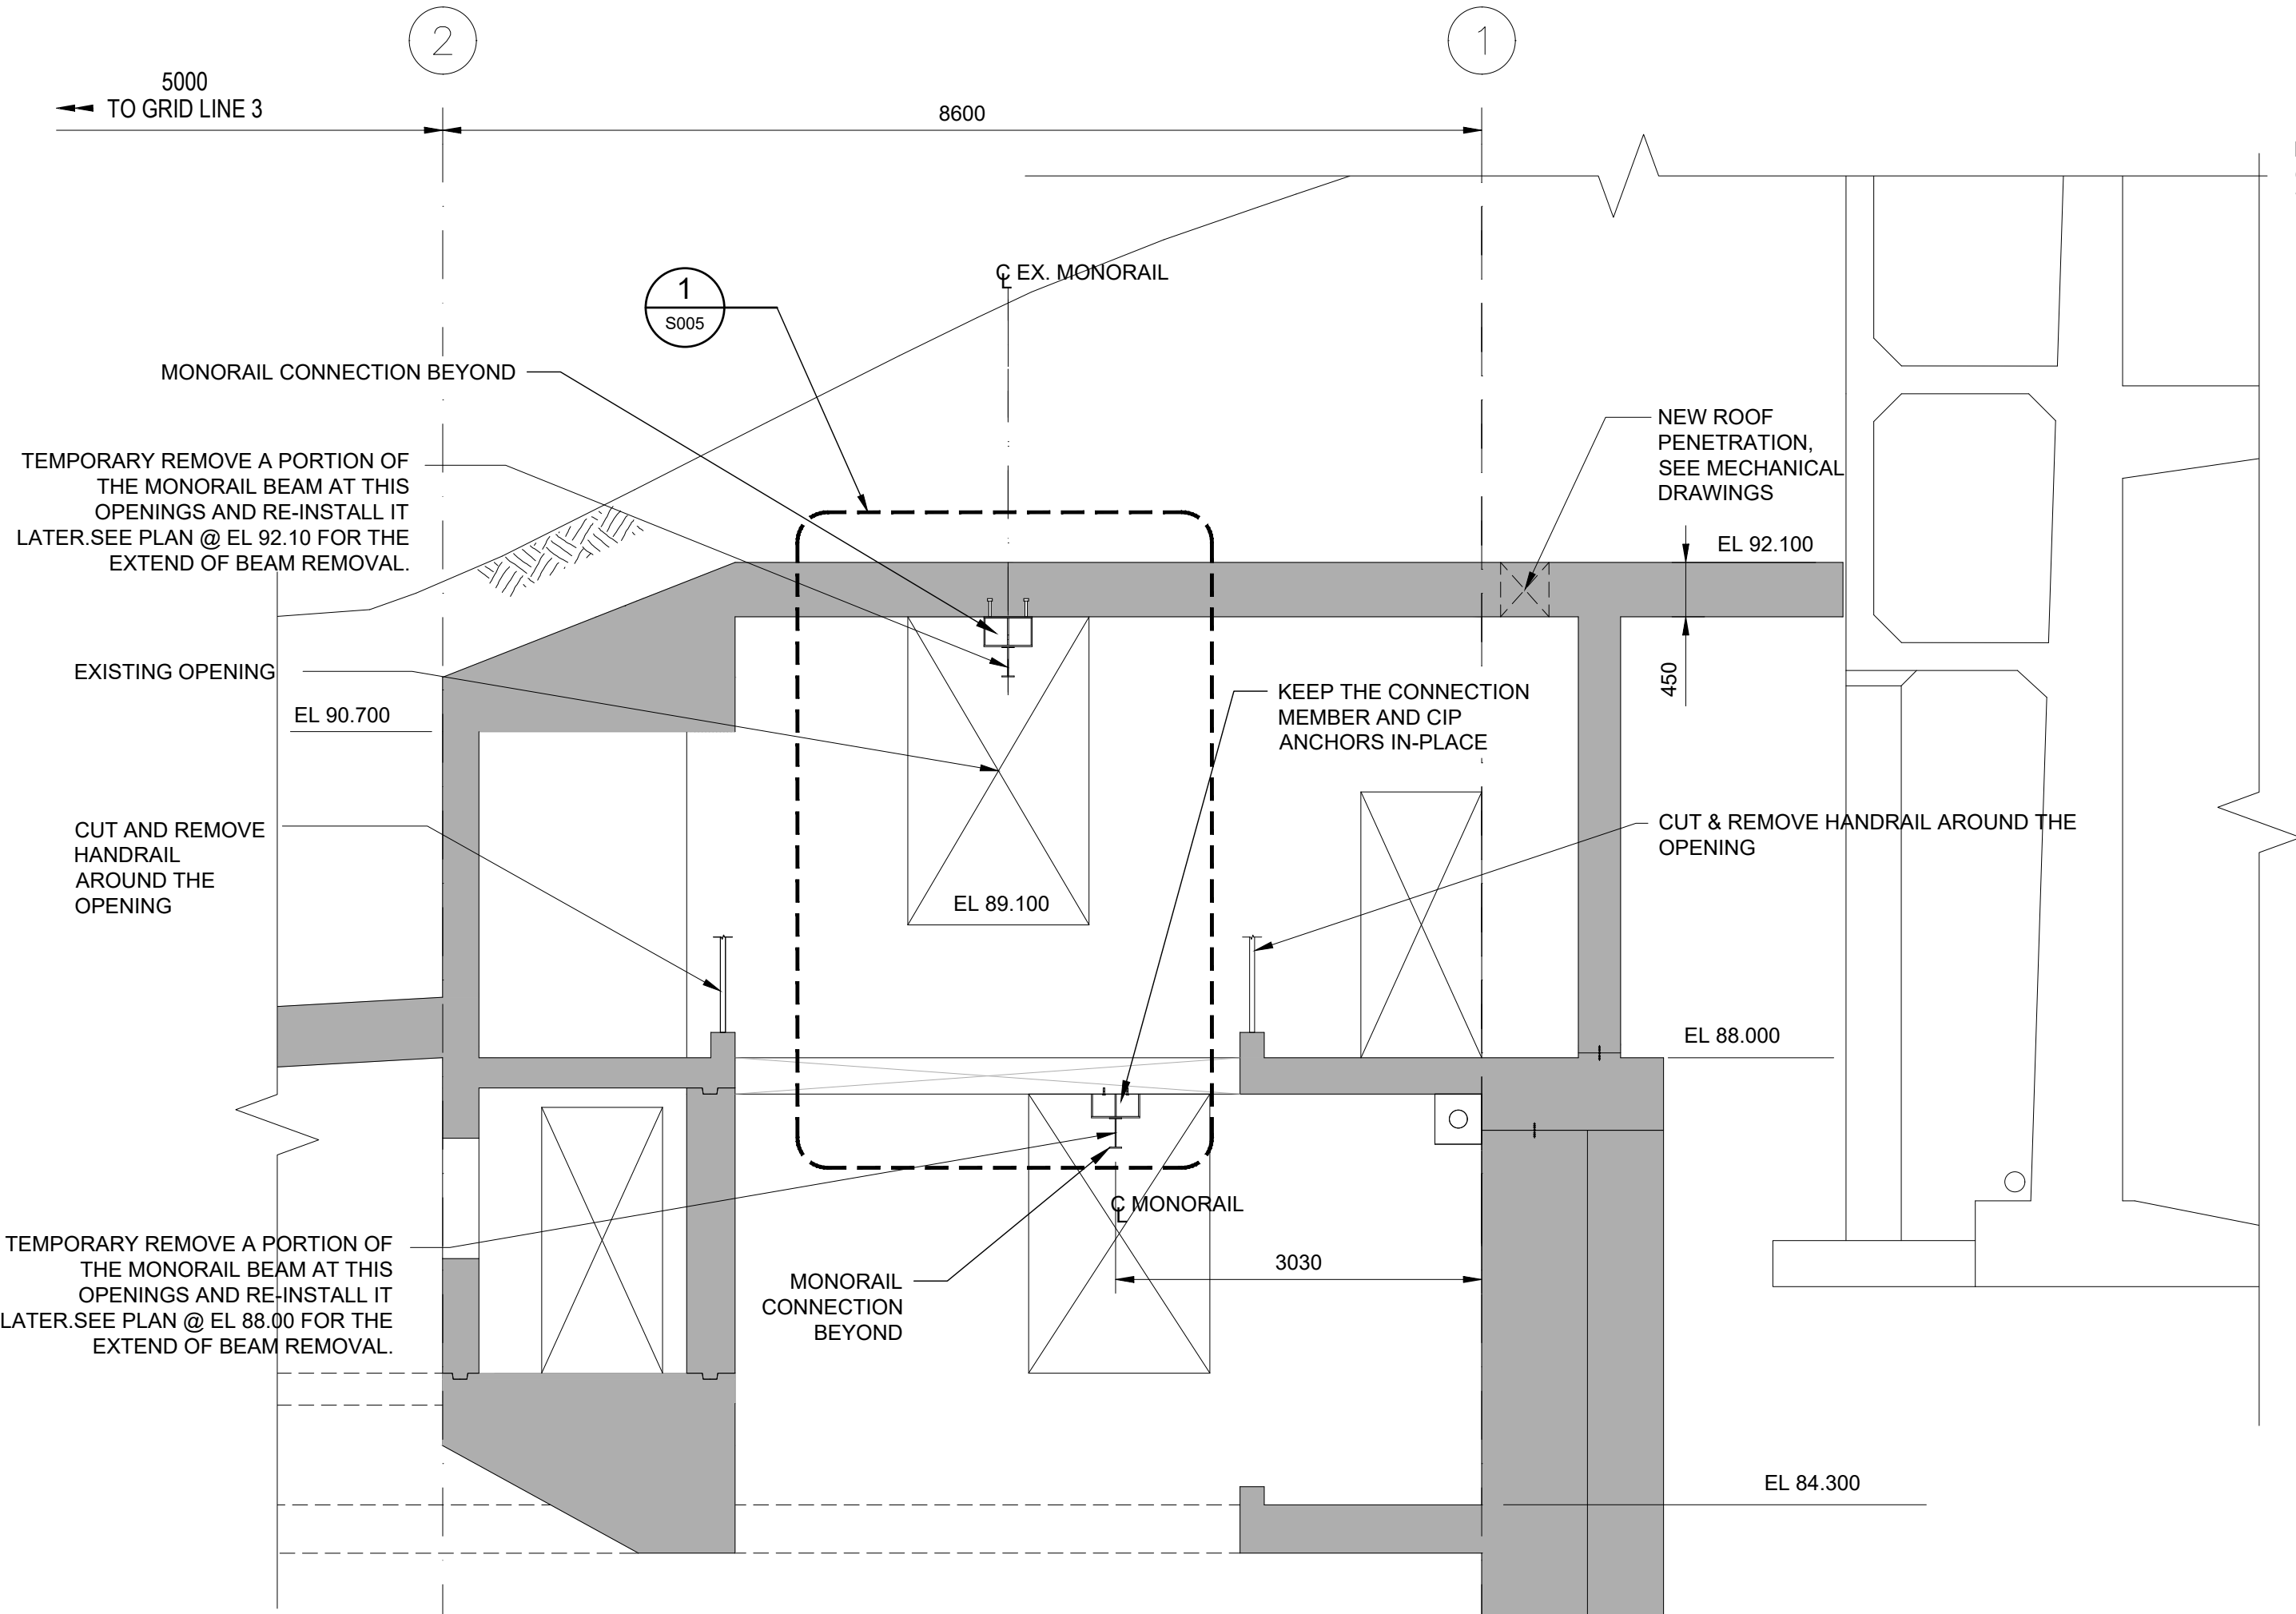

SECTION A
1:50

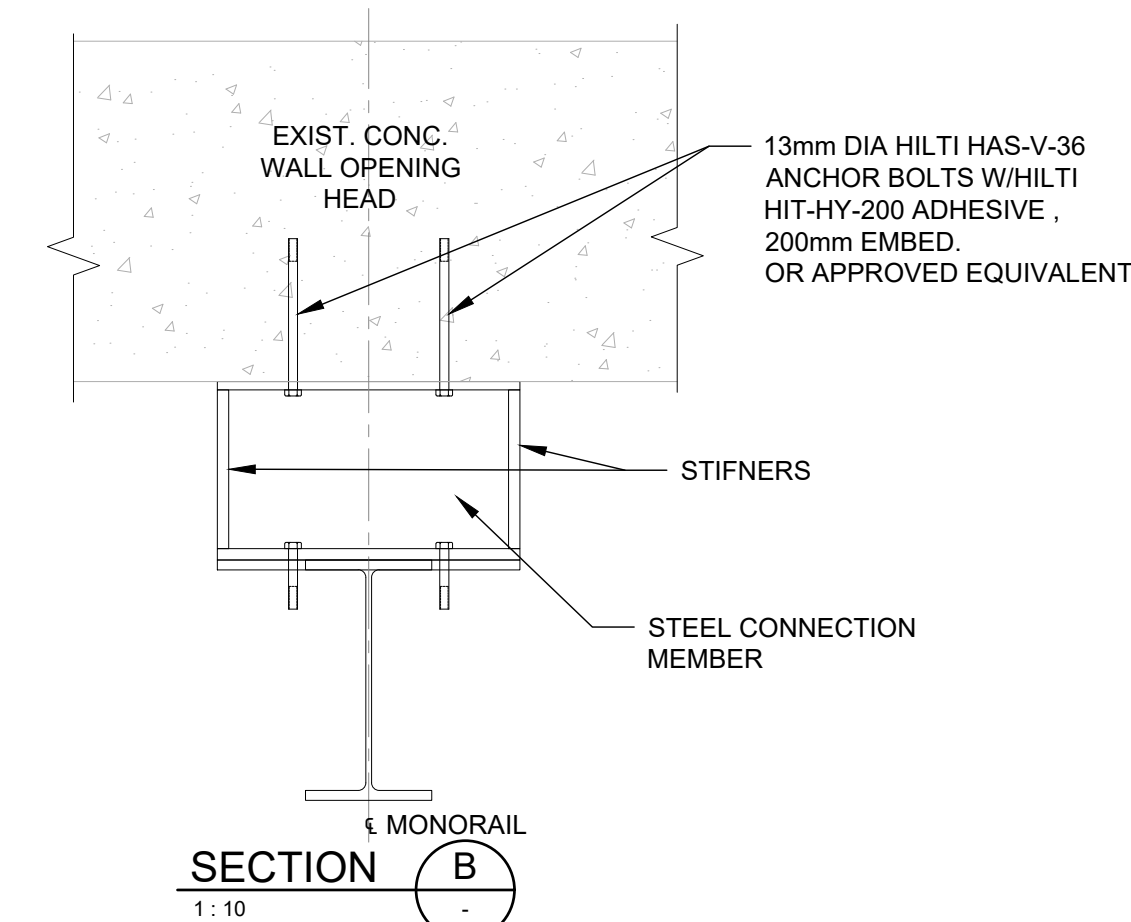

- NOTES:
- ALL DIMENSIONS AND EXIST. MEMBER SIZES AND ANCHOR BOLT SIZES ARE ASSUMED AND MUST BE VERIFIED ON SITE. NOTIFY ARCADIS OF ANY DISCREPANCY FOR FURTHER ASSESSMENT.
 - NEW POST INSTALLED ANCHORS ARE DESIGNED FOR A TENSILE CAPACITY OF 1800 TONS.
 - CONTRACTOR SHALL SCAN THE AREAS TO IDENTIFY THE EXISTING REINFORCEMENT PATTERNS BEFORE DRILLING. IN ORDER TO AVOID DRILLING INTO EXISTING REINFORCEMENT AND ADJUST BRACKETS ACCORDINGLY. THE CONTRACTOR SHALL SUBMIT THEIR FINDINGS TO THE ENGINEER FOR REVIEW.

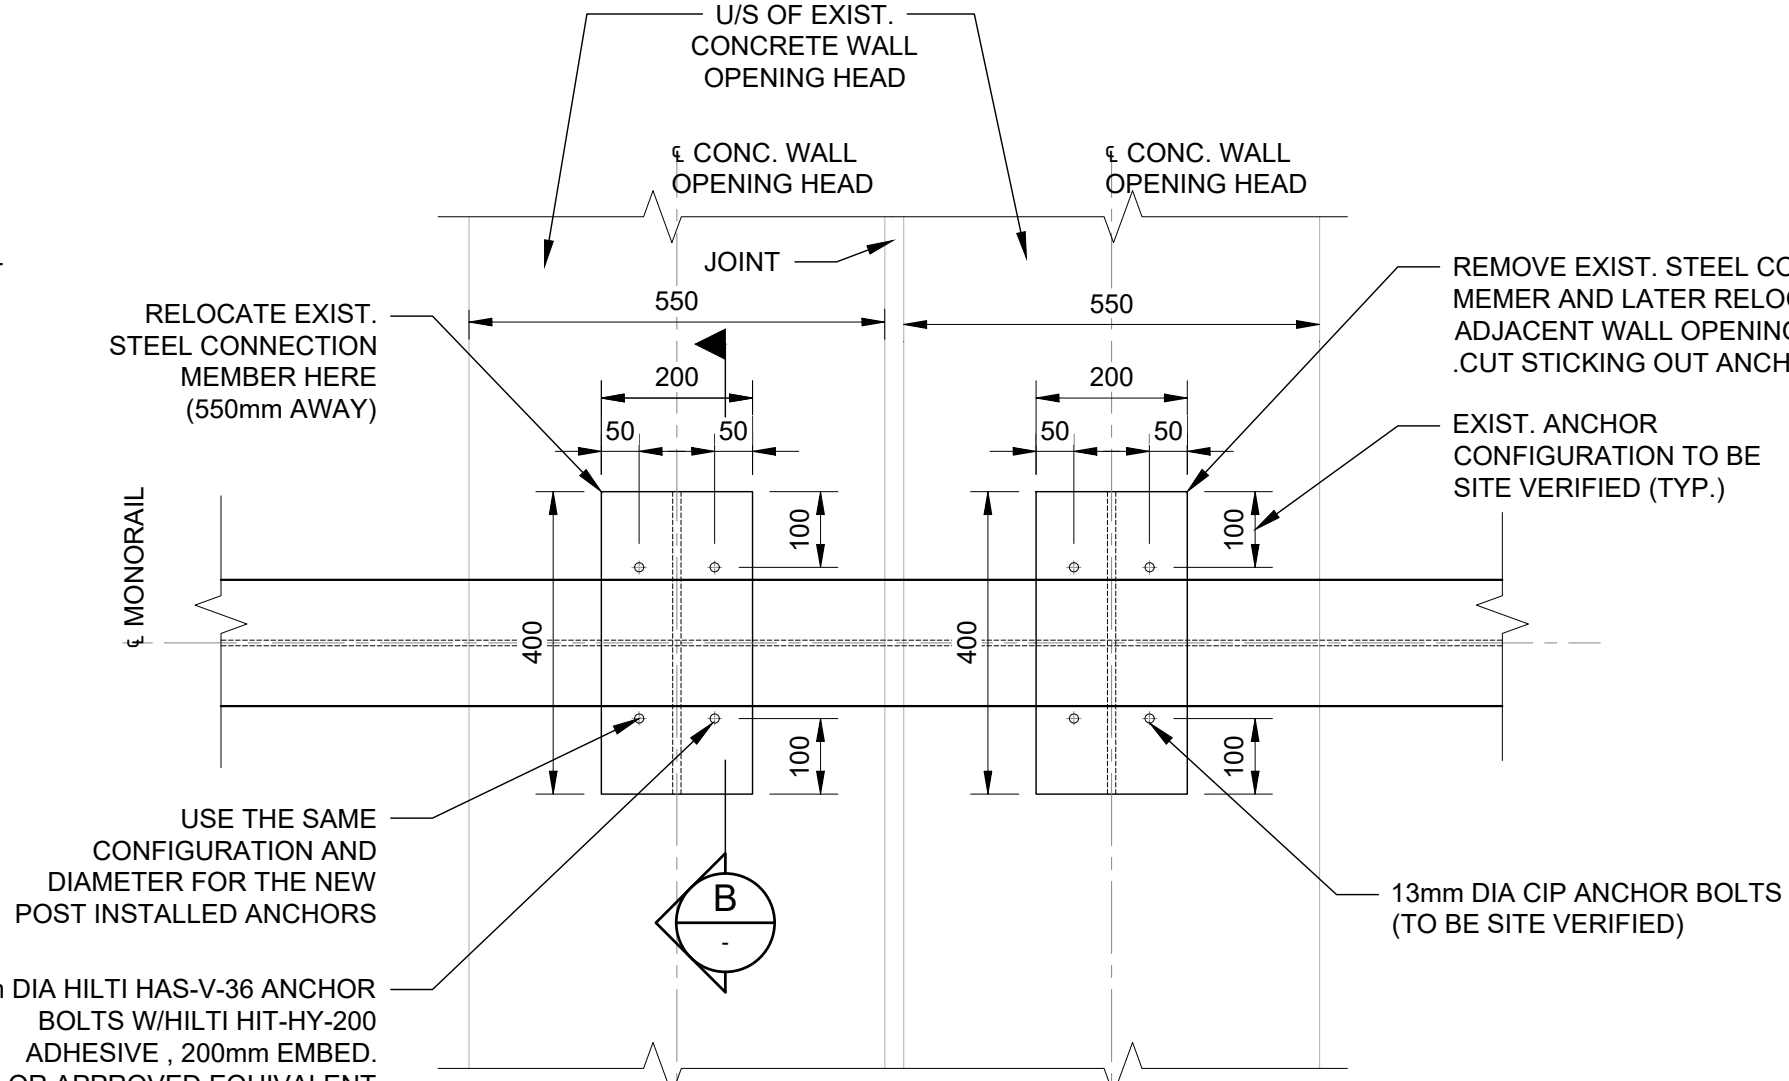


MONORAIL BEAM NEW POST-INSTALLED ANCHOR BOLTS DETAIL AT THE WALL OPENING IF REMOVING ANCHOR BOLTS ARE CONSIDERED

1
S003

EXISTING MONORAIL ANCHORED TO U/S OF EXISTING SLAB AT ELEVATION 88.00 TO REMAIN

1

2

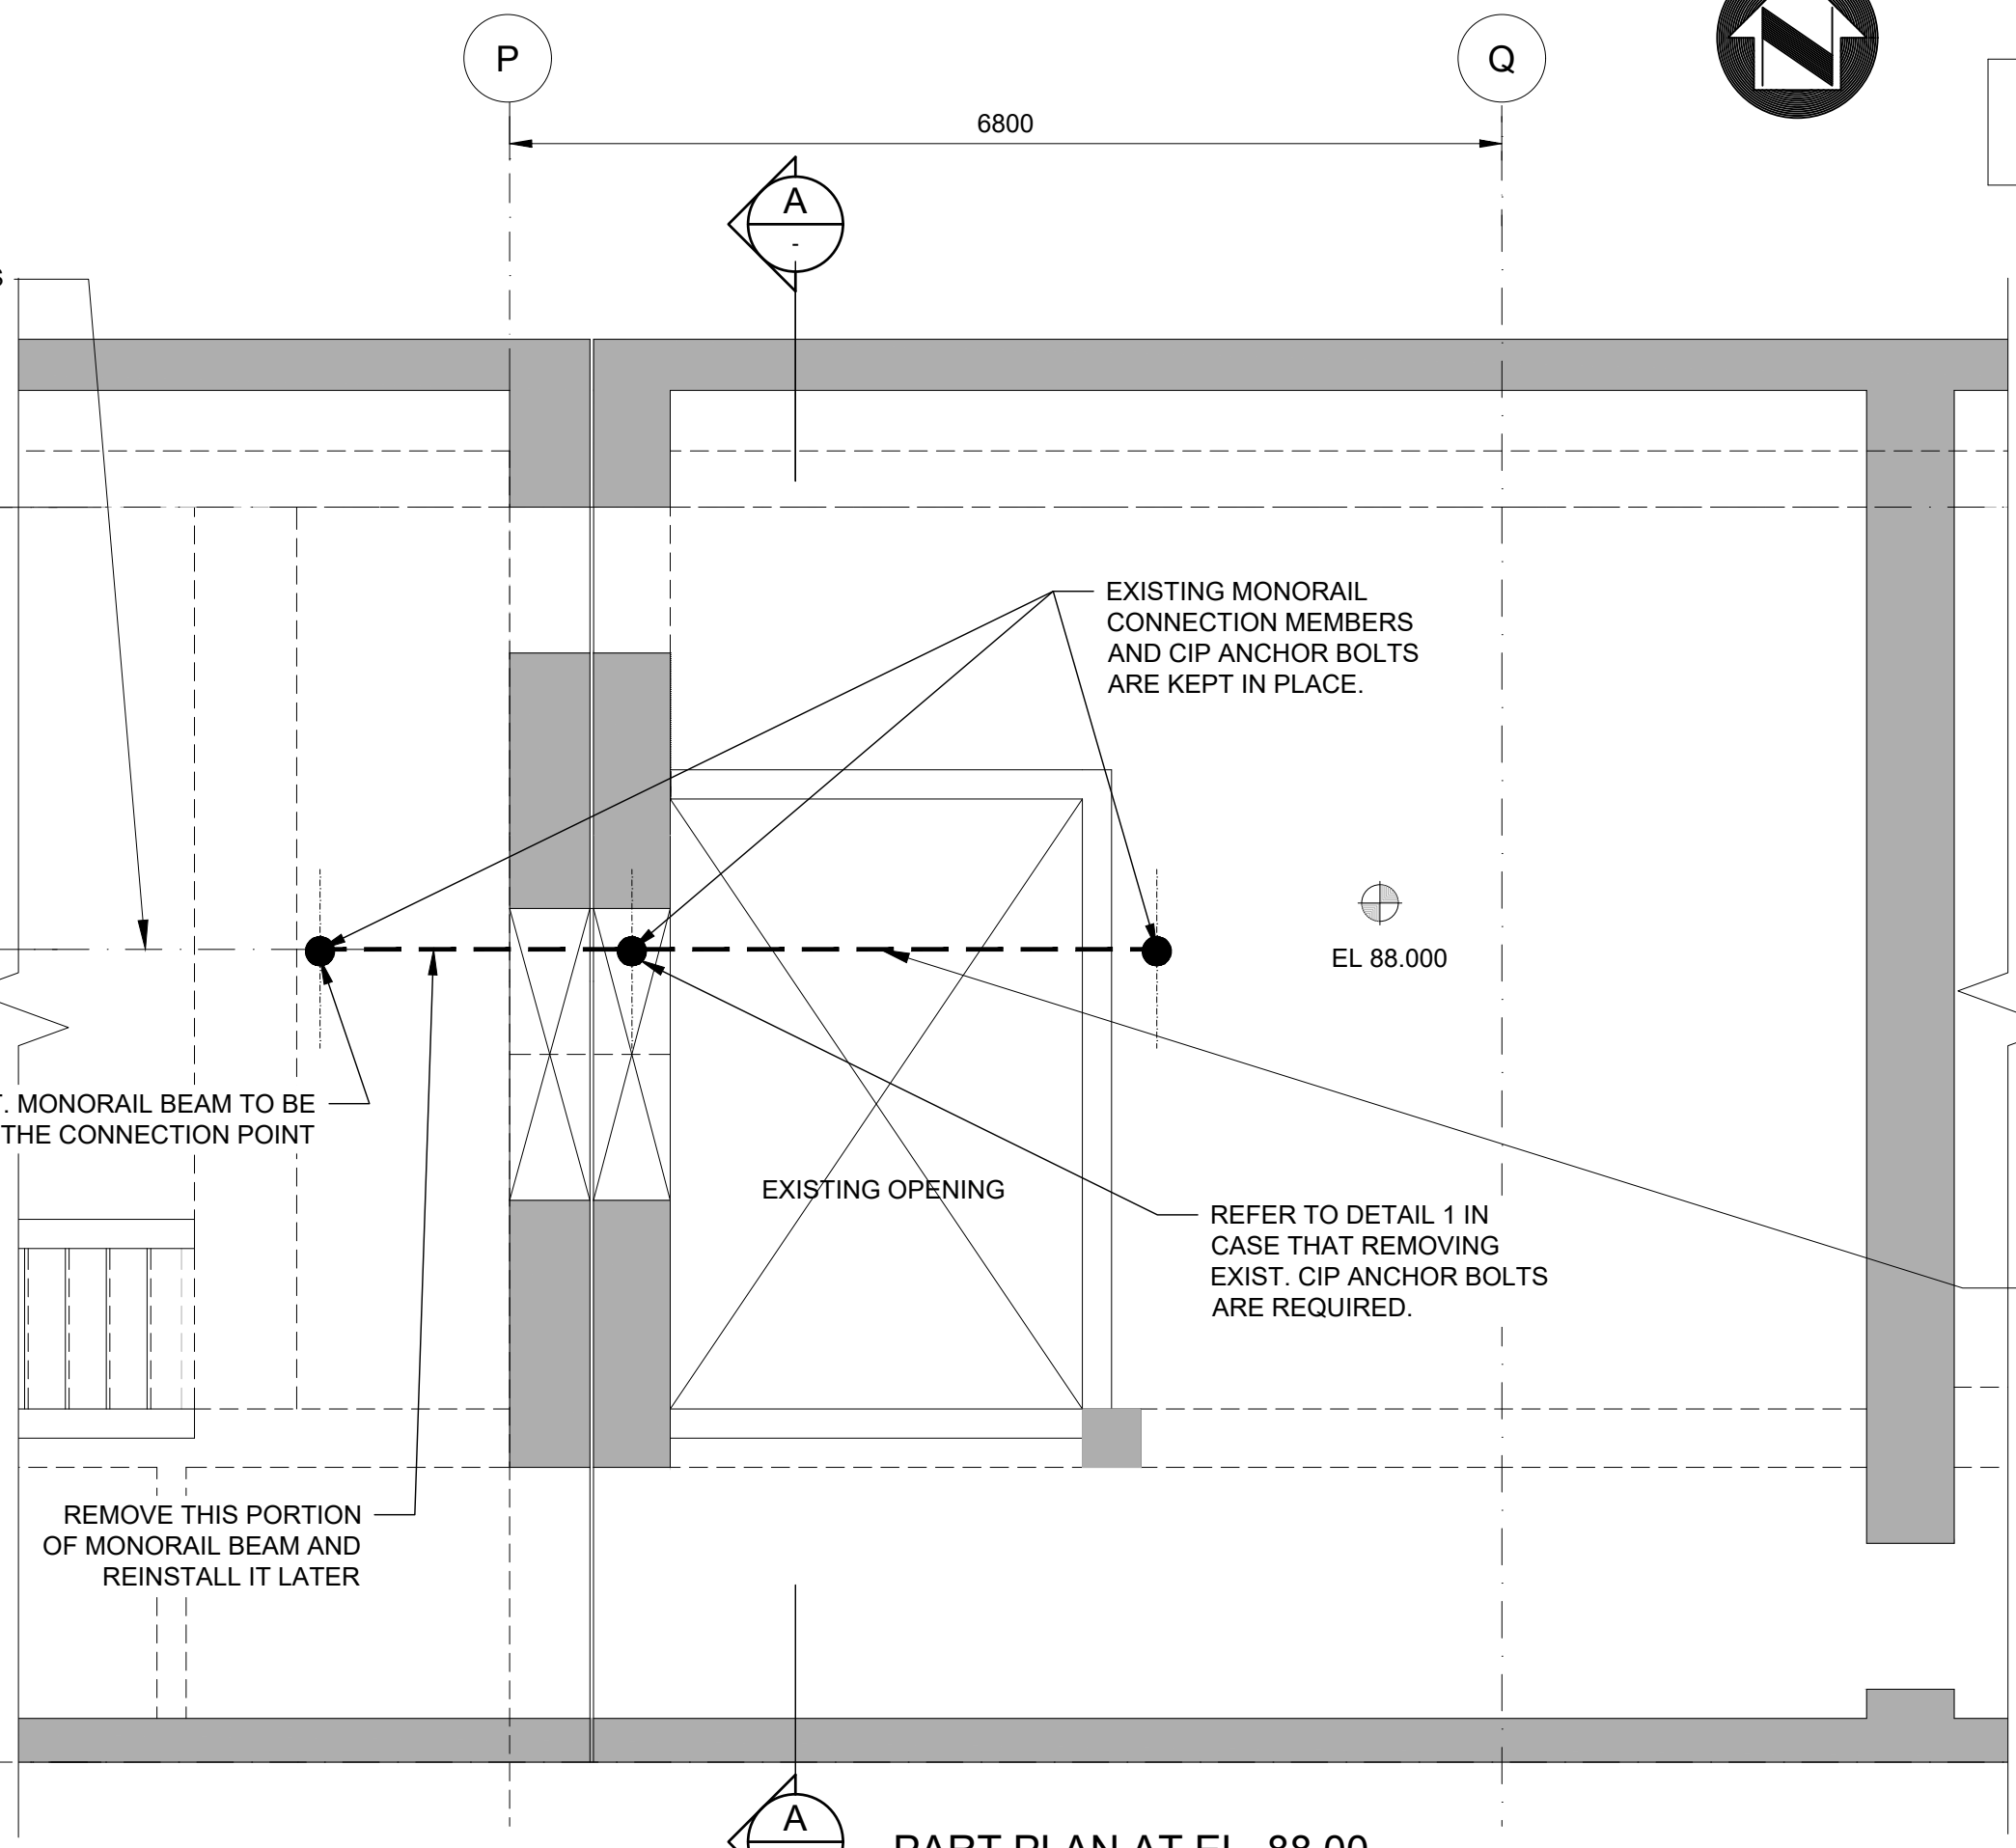


PART PLAN AT EL. 88.00
1:50

- TEMPORARILY REMOVE THIS PART OF EXISTING MONORAIL BELOW EXISTING SLAB. MAKE GOOD & DO NOT DAMAGE U/S OF EXISTING SLAB.
- REINSTALL THE REMOVED MONORAIL AFTER NEW GENERATOR IS MOVED TO THE PIPE GALLERY. THE RE-INSTALL MONORAIL SHALL BE CHECKED BY ORIGINAL MANUFACTURER AND CERTIFICATE SHALL BE ISSUED BY ORIGINAL MANUFACTURER. START-UP TEST SHALL BE COMPLETED SUCCESSFULLY PRIOR TO HANDING THE RE-INTALLED MONORAIL OVER BACK TO CITY.

1

2

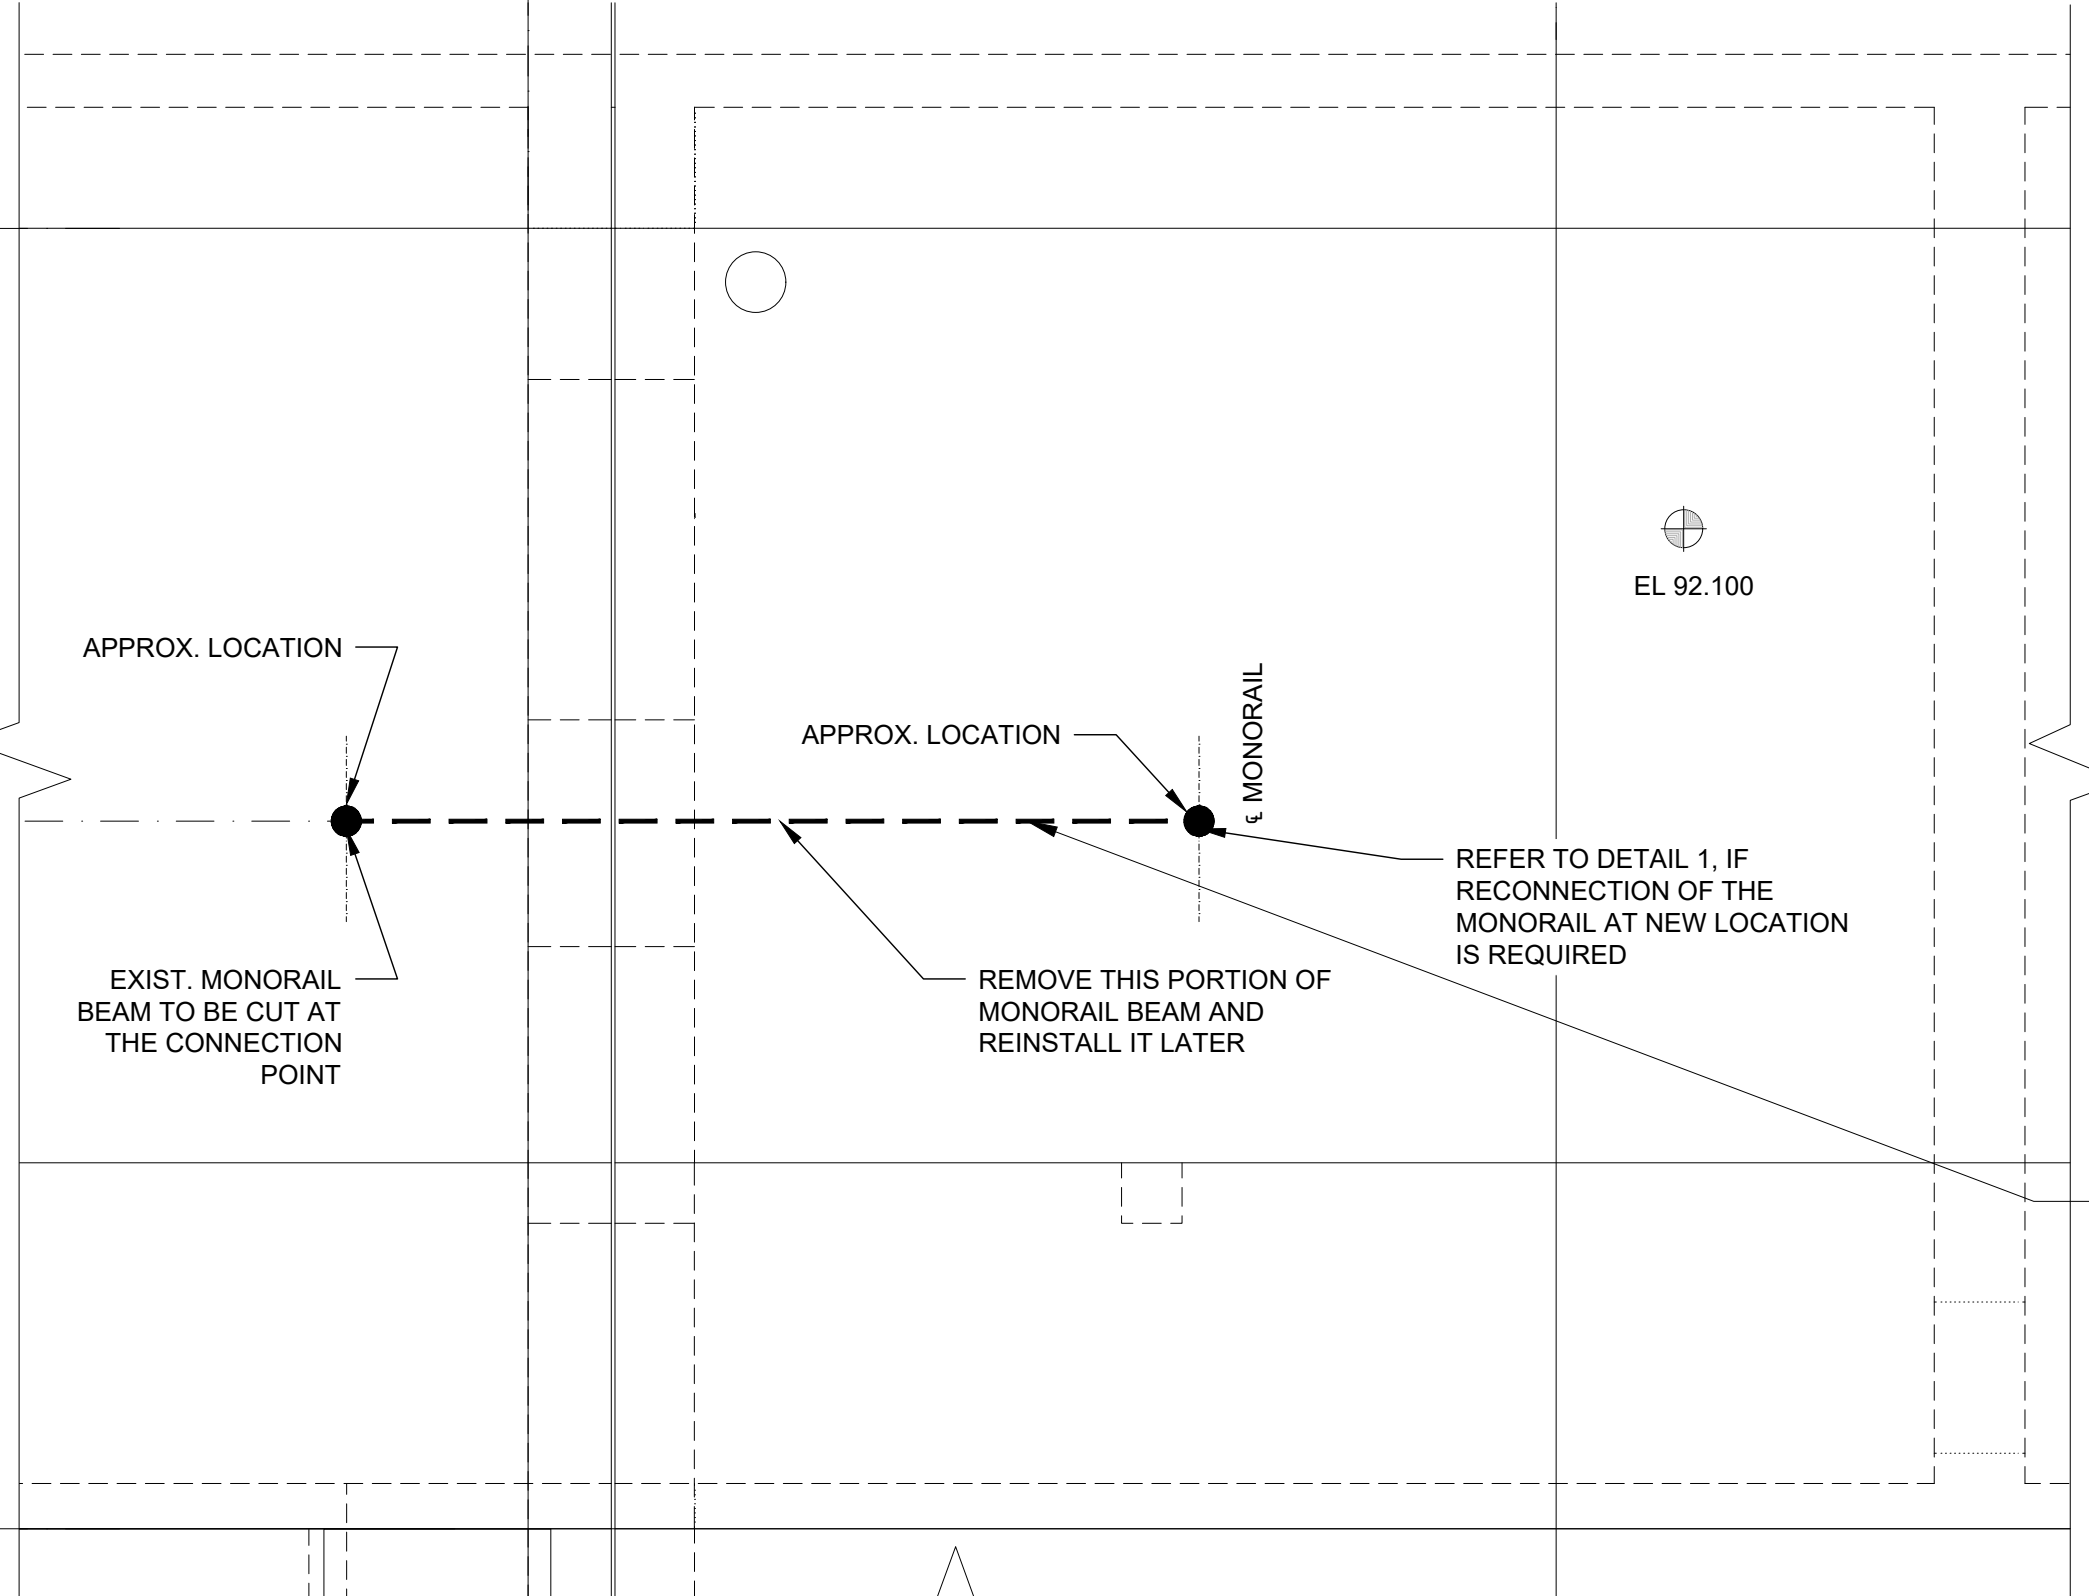

PART PLAN AT EL. 92.10
1:50

- TEMPORARILY REMOVE THIS PART OF EXISTING MONORAIL BELOW EXISTING SLAB. MAKE GOOD & DO NOT DAMAGE U/S OF EXISTING SLAB.
- REINSTALL THE REMOVED MONORAIL AFTER NEW GENERATOR IS MOVED TO THE PIPE GALLERY. THE RE-INSTALL MONORAIL SHALL BE CHECKED BY ORIGINAL MANUFACTURER AND CERTIFICATE SHALL BE ISSUED BY ORIGINAL MANUFACTURER. START-UP TEST SHALL BE COMPLETED SUCCESSFULLY PRIOR TO HANDING THE RE-INTALLED MONORAIL OVER BACK TO CITY.



COPYRIGHT:
This drawing has been prepared solely for the intended use, thus any reproduction or distribution for any purpose other than authorized by ARCADIS is forbidden. Written dimensions shall have precedence over scaled dimensions. Contractors shall verify and be responsible for all dimensions and conditions on the job, and ARCADIS shall be informed of any variations from the dimensions and conditions shown on the drawing. Shop drawings shall be submitted to TBT Group for general conformance before proceeding with fabrication.



ARCADIS Professional Services (Canada) Inc.

NO.	DATE	REVISIONS	INITIAL	SIGNED
A	2025-03-18	ISSUED FOR TENDER	C.H.	Issued for Tender




ENGINEERING AND CONSTRUCTION SERVICES	
WILLIAM FERNANDES, P. ENG. DIRECTOR, WATER TREATMENT AND SUPPLY	SIMON HOPTON, P. ENG. DIRECTOR DESIGN & CONSTRUCTION MAJOR INFRASTRUCTURE

R.C. HARRIS WATER TREATMENT PLANT INSTALLATION OF A STANDBY GENERATOR FOR CRITICAL LOADS RMF DEMOLITION - PART PLAN AT EL. 88.00 AND SECTION					
STRUCTURE					
DESIGN:	F.M.	DRAFTING:	S.P.	CHECK:	M.S.
SCALE:	AS SHOWN			DRAWING NUMBER:	2F-2017-08-13
DATE:	2024-09-30				S004

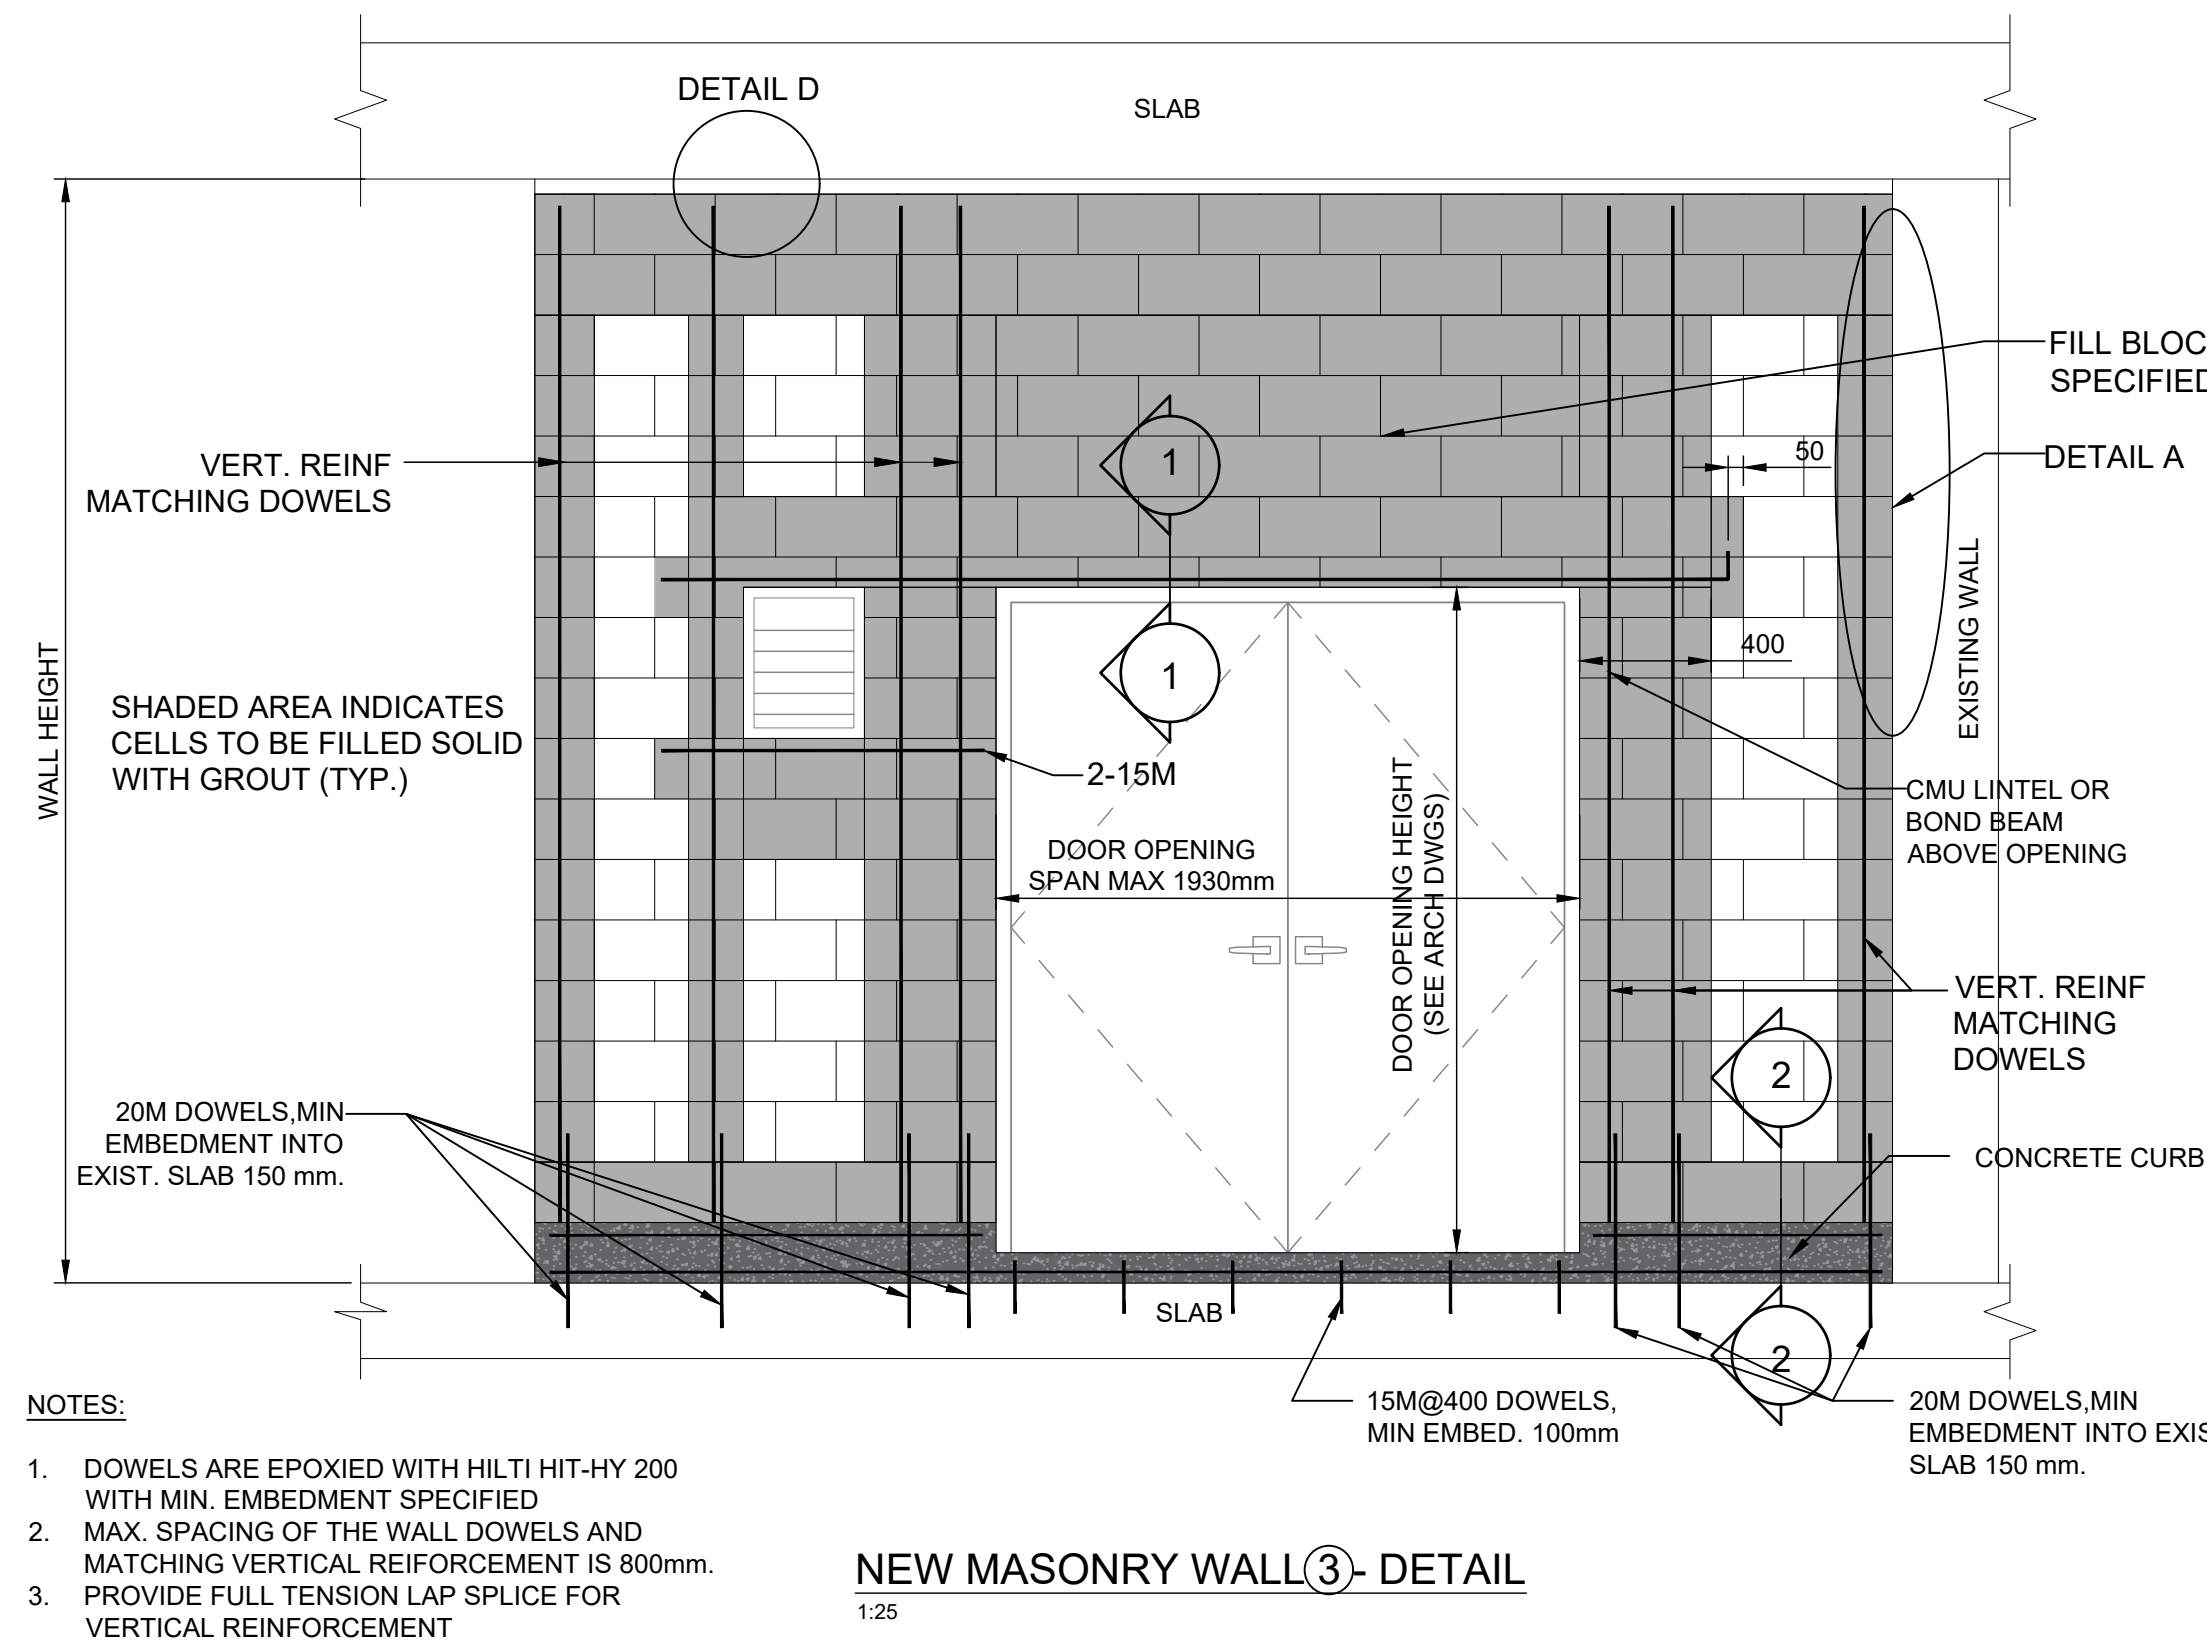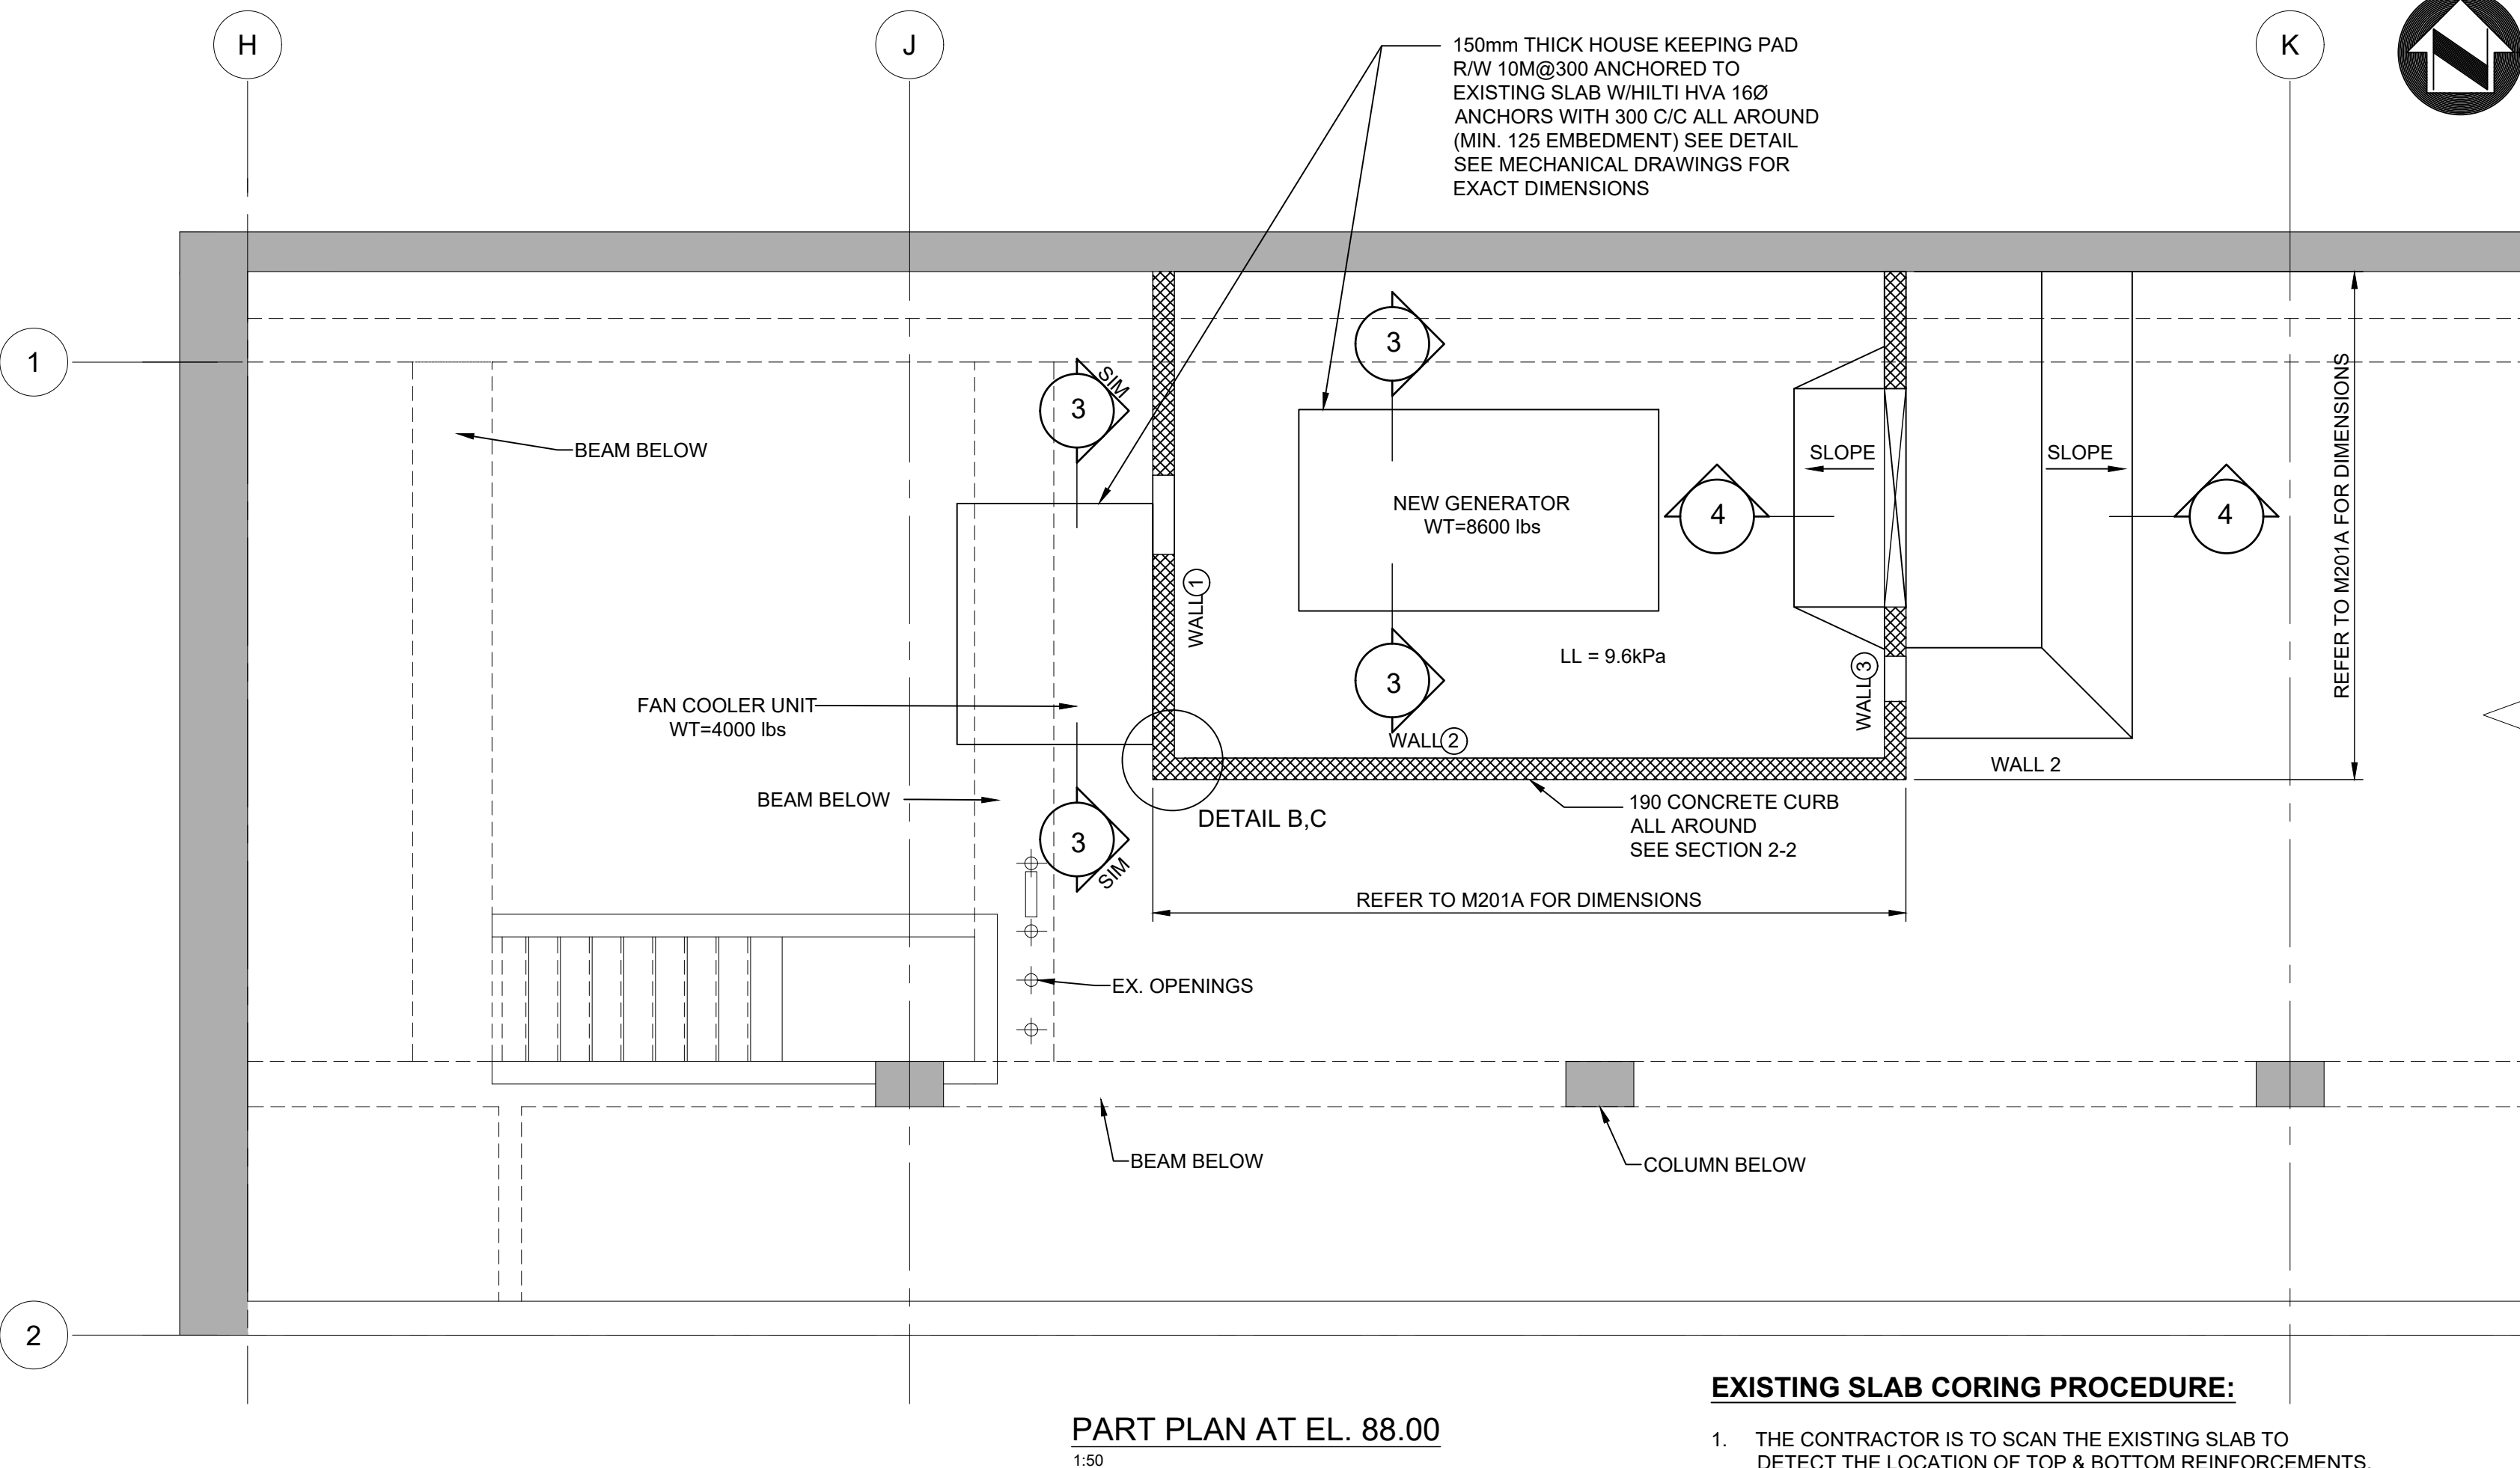


1. THE CONTRACTOR IS TO SCAN THE EXISTING SLAB TO DETECT THE LOCATION OF TOP & BOTTOM REINFORCEMENTS.
2. NO BARS ARE TO BE CUT PRIOR TO STRUCTURAL ENGINEER'S NOTIFICATION & REVIEW.
3. THE CONTRACTOR TO SUBMIT SCANNING REPORT WITH CLEAR INDICATION OF SCANNING AREA USING PROJECT DRAWINGS AS BACKGROUND ON THE PLANS OR SECTION TO INDICATED PROPOSED CORING SIZE WITH RESPOND TO EXISTING REINFORCEMENT OR OTHER EMBEDMENTS.

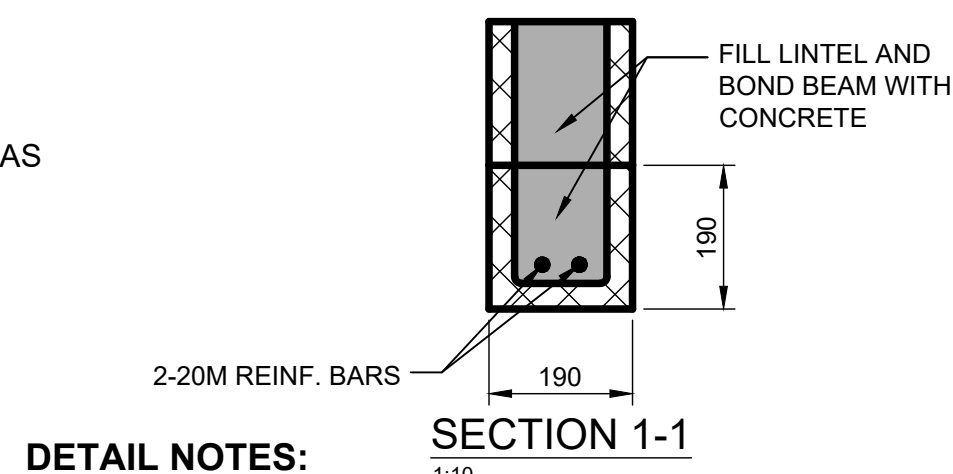


DETAIL NOTES:


1. BLOCKS ABOVE LINTELS TO BE FILLED SOLID WITH GROUT FOR HEIGHT EQUAL TO SPAN.
2. SHORE LINTELS UNTIL GROUT REACHES DESIGN STRENGTH.

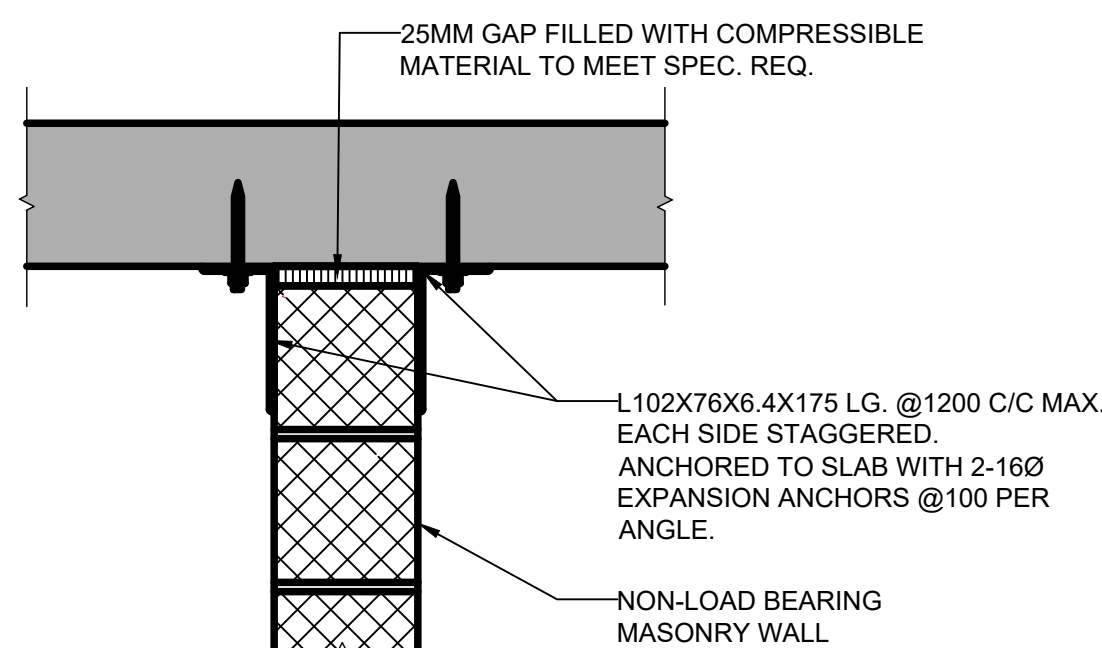

DETAIL D - LATERAL SUPPORT OF NON-LOAD BEARING MASONRY WALL

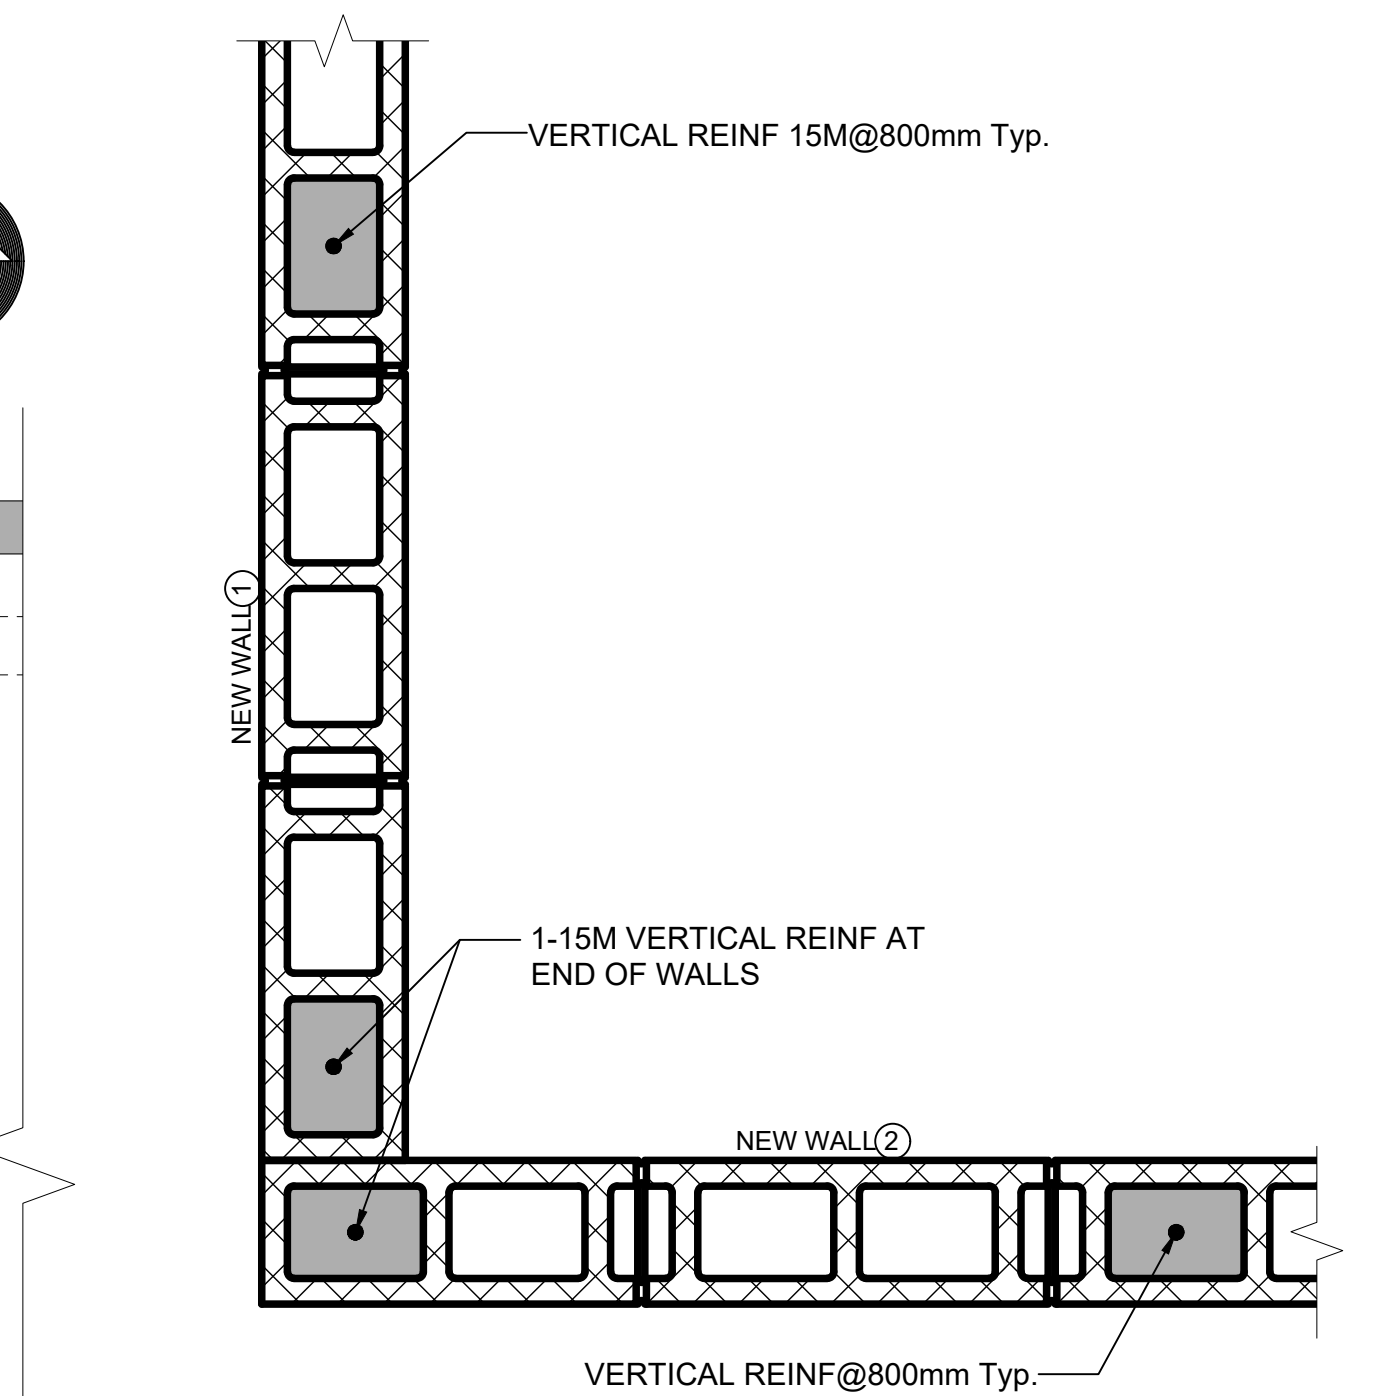


DETAIL C - TYPICAL REINFORCEMENT IN NEW CMU WALL ① AND ②

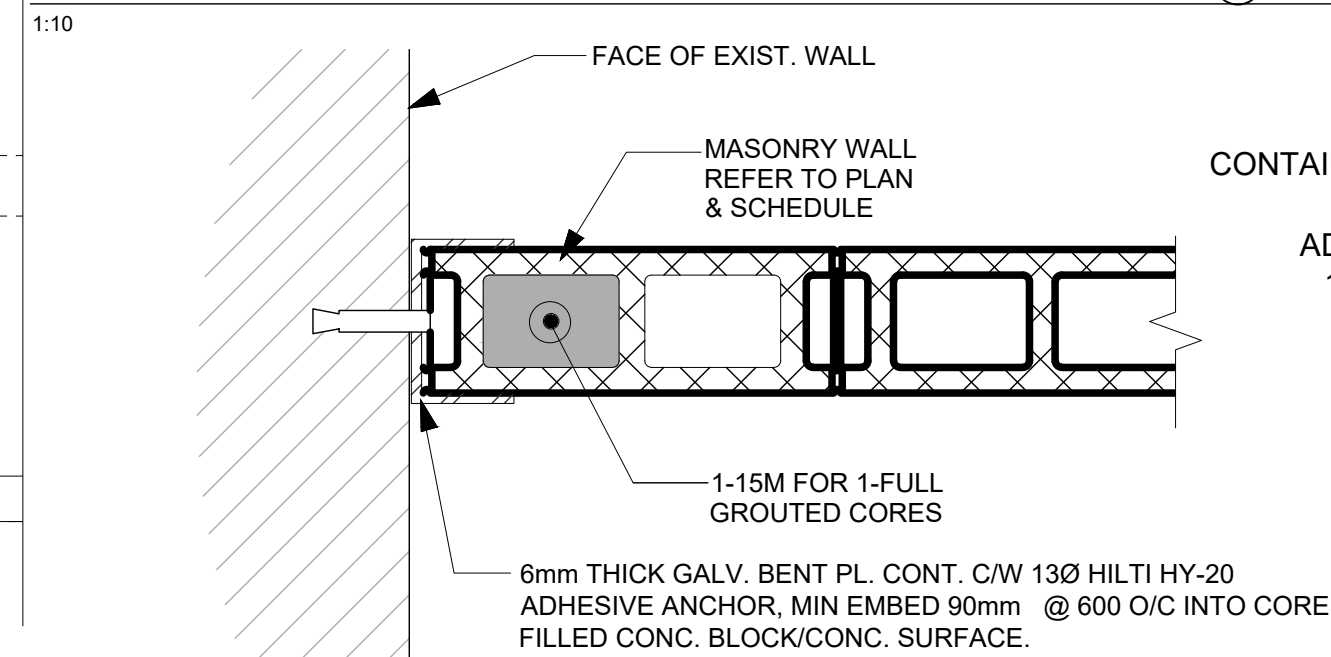


NOTE: CONTRACTOR SHALL SCAN THE AREAS TO IDENTIFY THE EXISTING REINFORCEMENT PATTERNS BEFORE DRILLING, IN ORDER TO AVOID DRILLING INTO EXISTING REINFORCEMENT AND ADJUST BRACKETS ACCORDINGLY. THE CONTRACTOR SHALL SUBMIT THEIR FINDINGS TO THE ENGINEER FOR REVIEW

DETAIL A-TYPICAL CMU CONNECTION TO EXISTING WALL

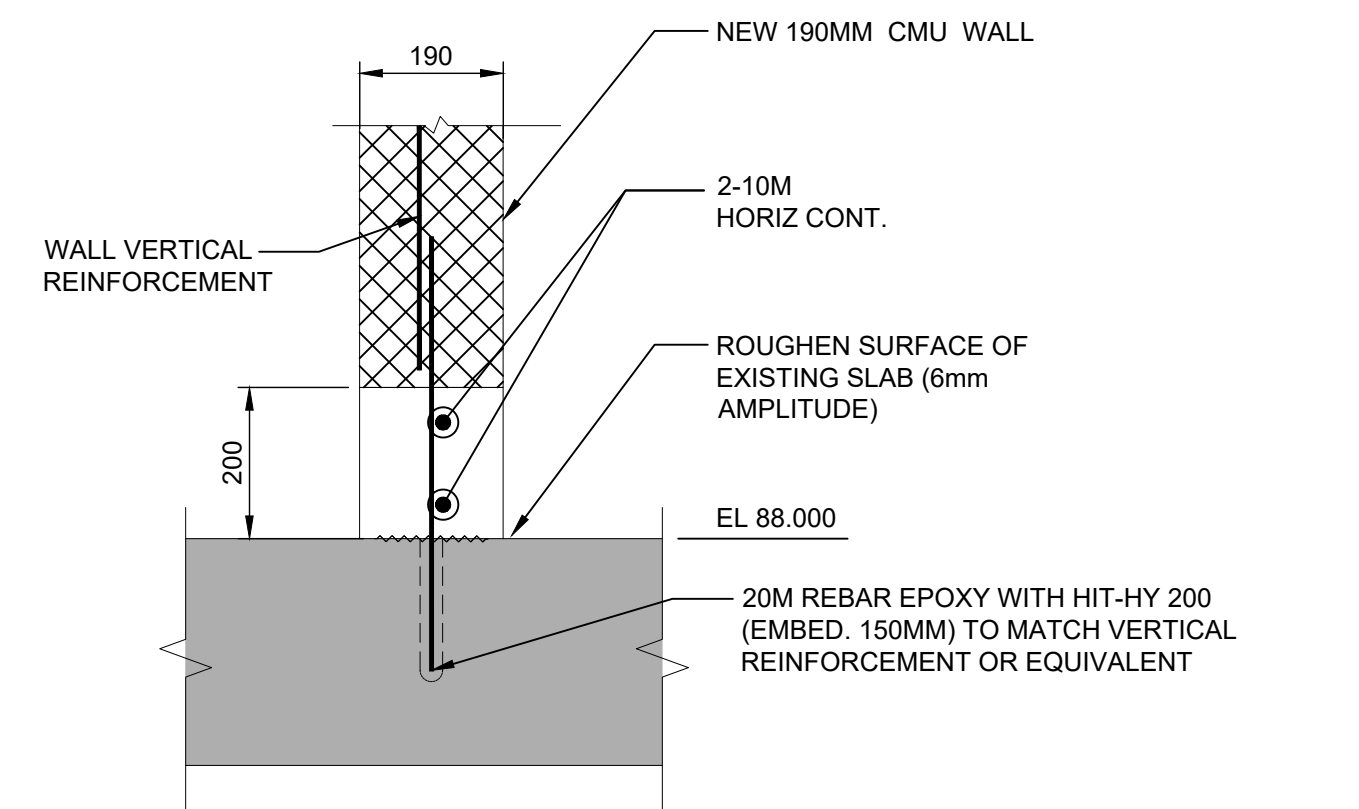


SECTION 2-2

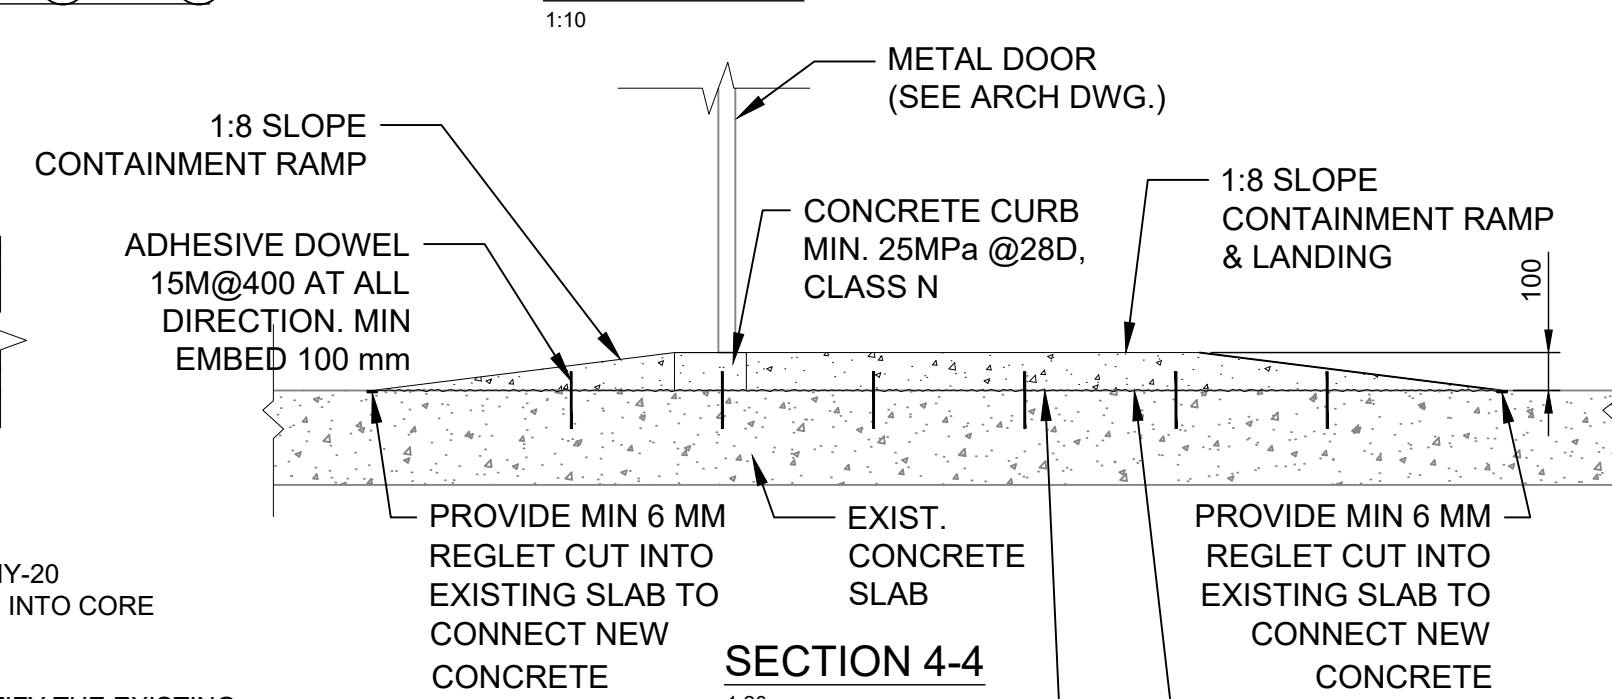

SECTION 4-4


APPLY BONDING AGENT PRIOR
TO CAST NEW CONCRETE.
SikaTop Armatex 110 OR
EQUIVALENT

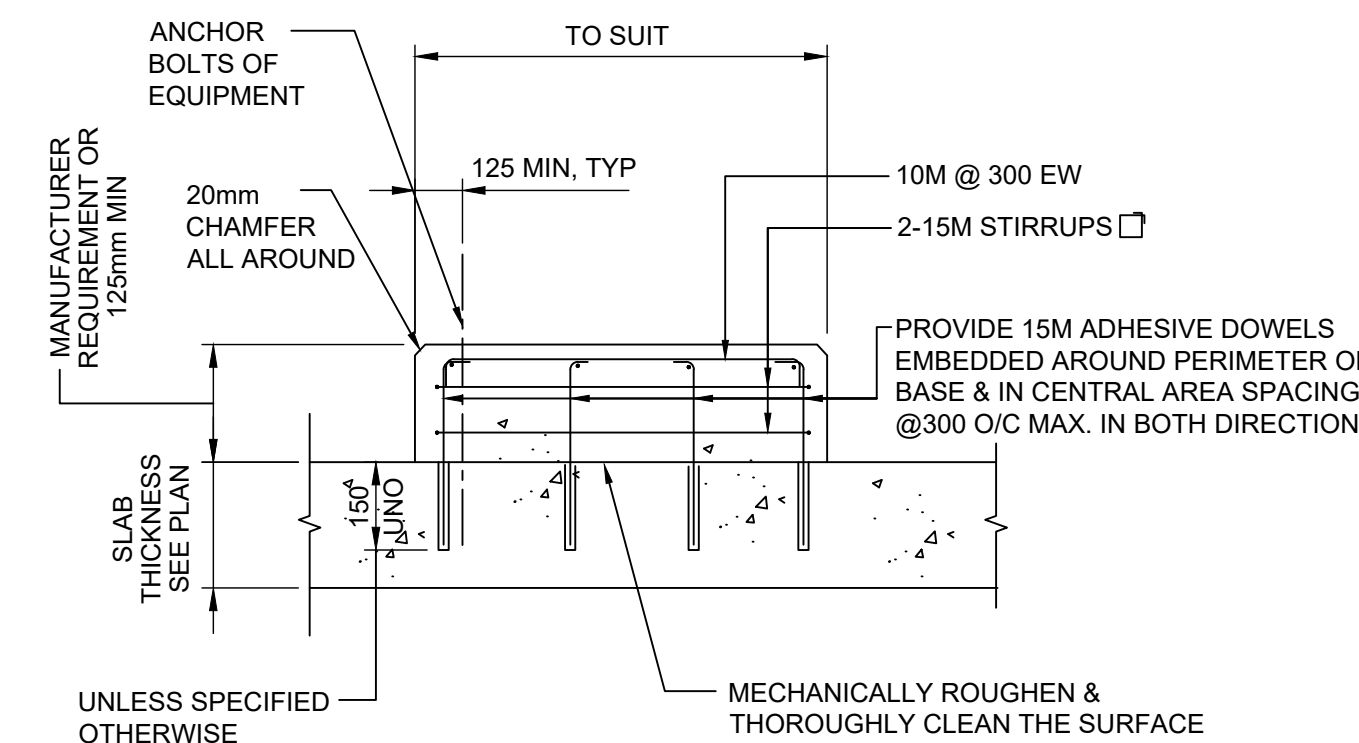


SECTION 3-3 - CONCRETE EQUIPMENT BASE

NOTES

1. DIMENSIONS OF BASES, ANCHOR BOLTS, SIZES AND LOCATIONS TO SUIT EQUIPMENT SUPPLIED AS STIPULATED BY EQUIPMENT MANUFACTURER. (SEE MECHANICAL/PROCESS DWGS)
2. ANCHOR BOLT EMBEDMENT DETAILS, PRE-STRESSING, ETC AS REQUIRED BY EQUIPMENT MANUFACTURER.
3. FOR PUMP BASES AND OTHER DYNAMICALLY LOADED STRUCTURES REVIEW BOLT LOCATION, DEPTH AND CAPACITY WITH THE ENGINEER BEFORE PROCEEDING WITH THE WORK.
4. USE CONCRETE WITH A SHRINKAGE COMPENSATING ADMIXTURE.
5. CONTRACTOR SHALL SCAN THE AREAS TO IDENTIFY THE EXISTING REINFORCEMENT PATTERNS BEFORE DRILLING, IN ORDER TO AVOID DRILLING INTO EXISTING REINFORCEMENT AND ADJUST BRACKETS ACCORDINGLY. THE CONTRACTOR SHALL SUBMIT THEIR FINDINGS TO THE ENGINEER FOR REVIEW.

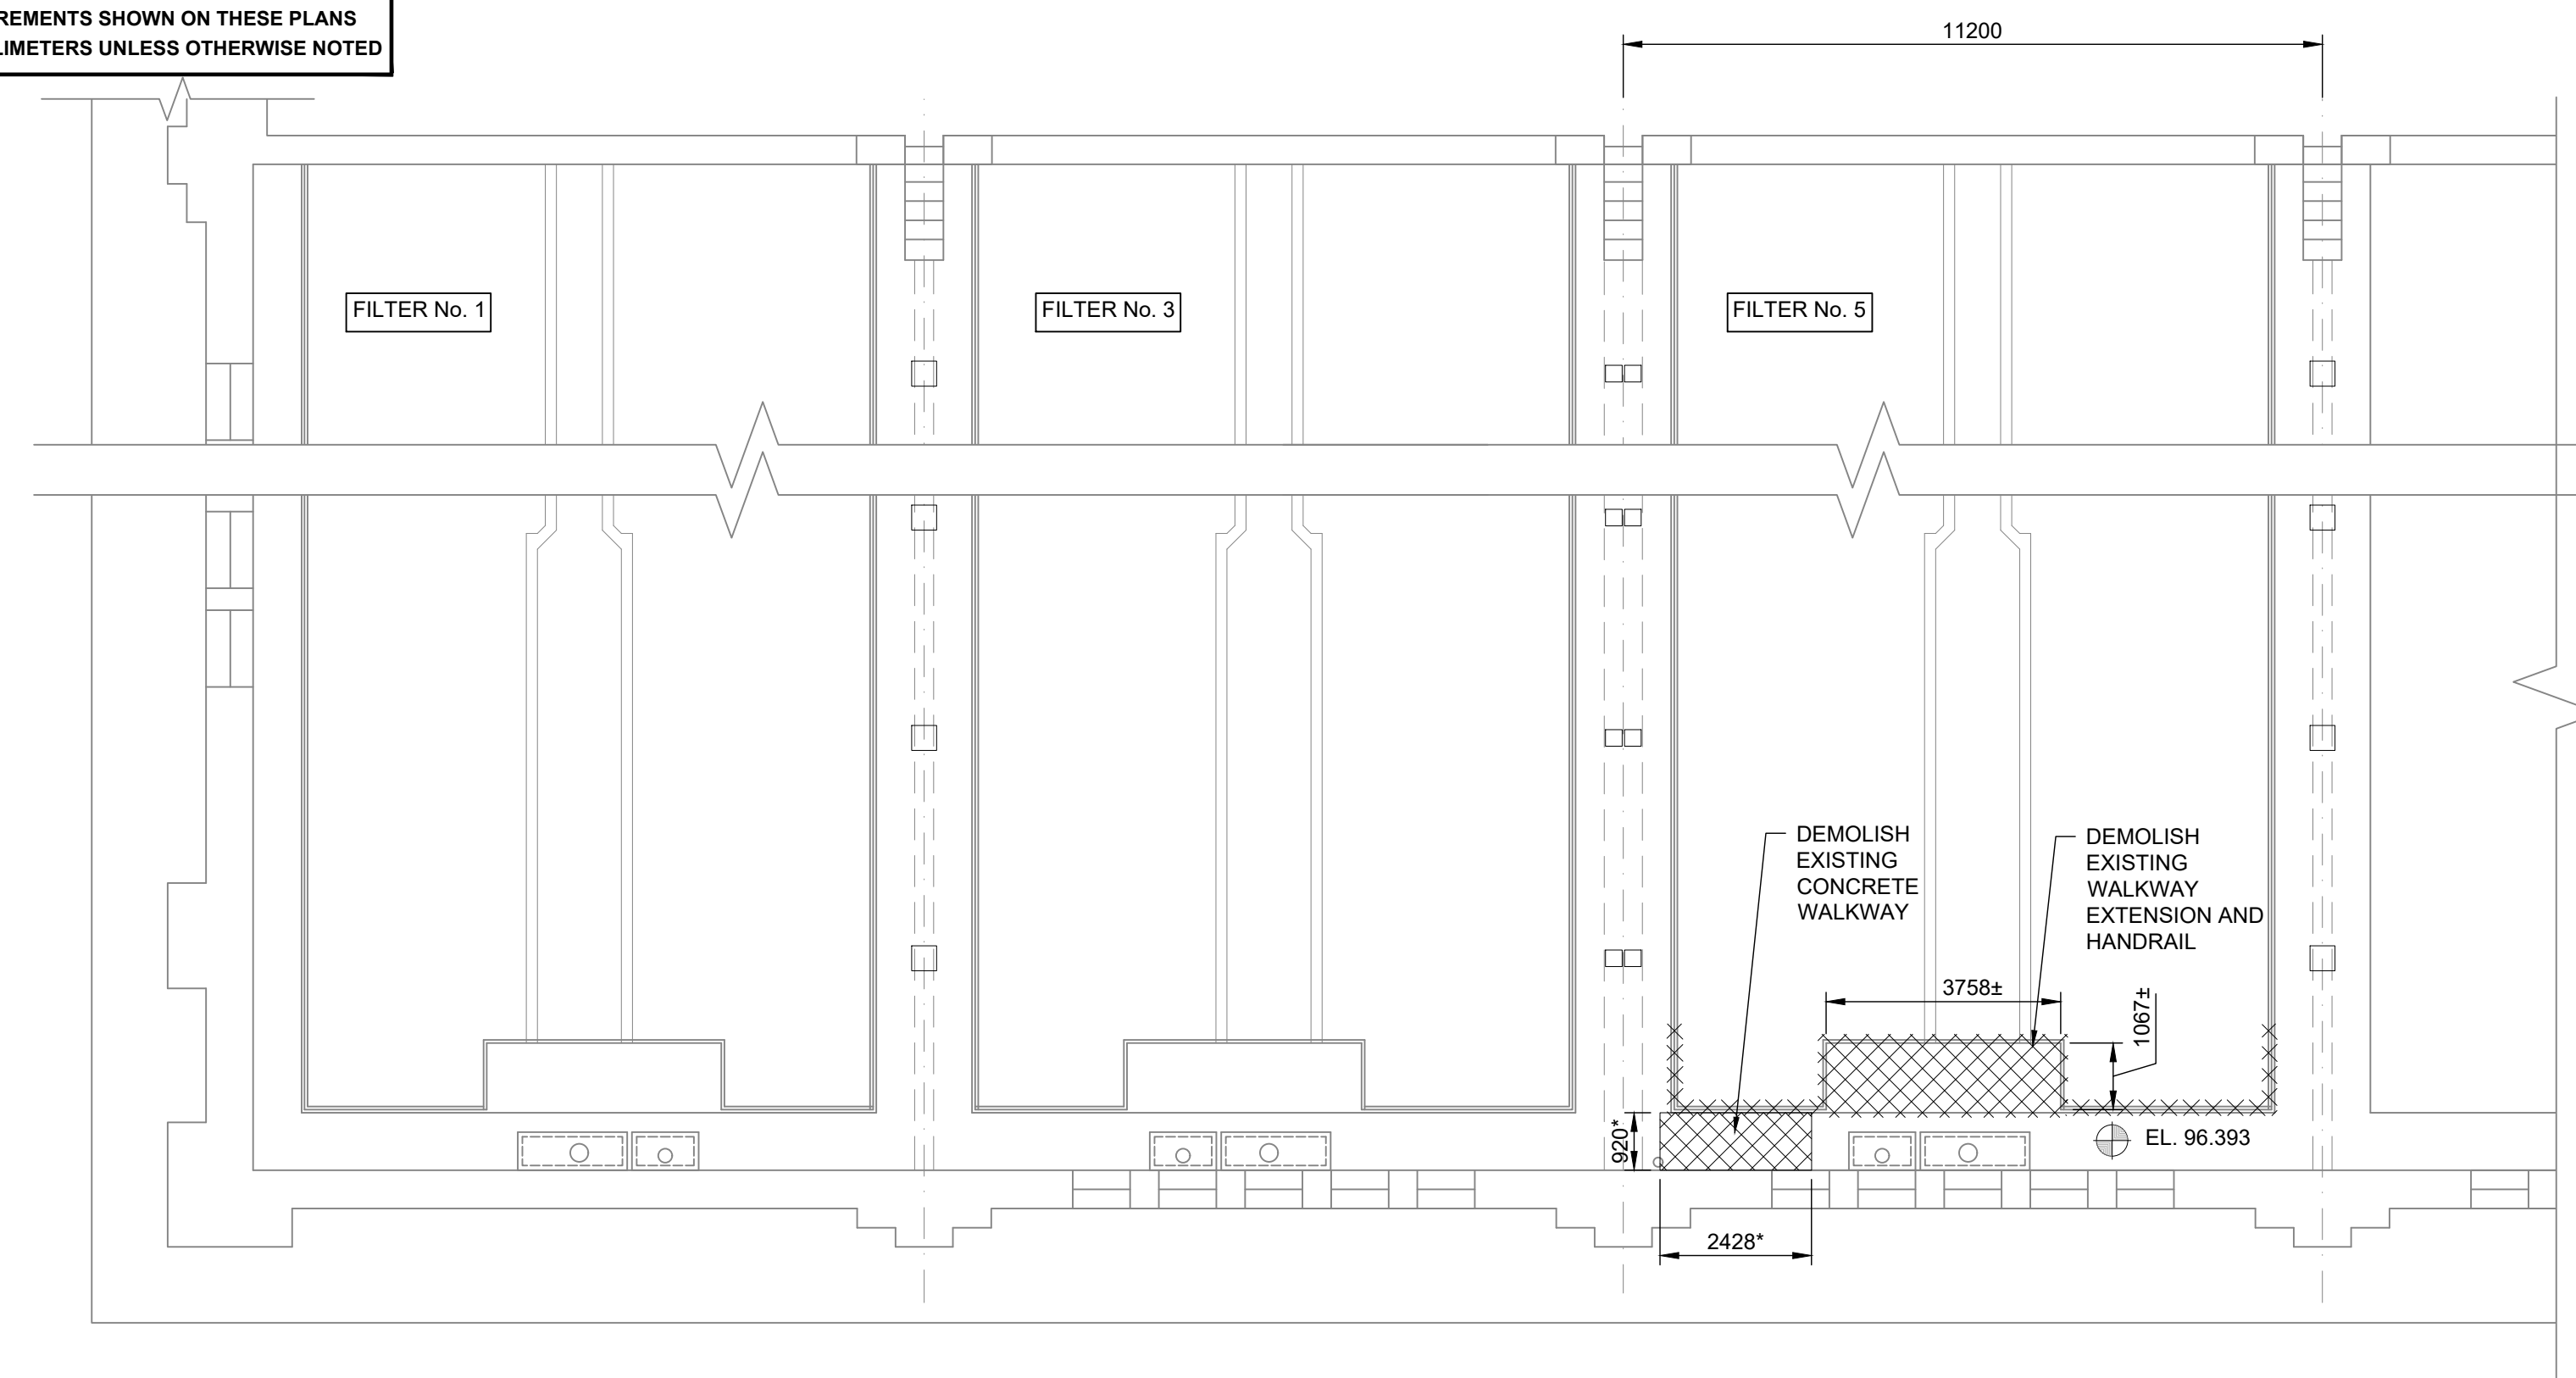


PART PLAN OF FILTER GALLERY - DEMOLITION PLAN

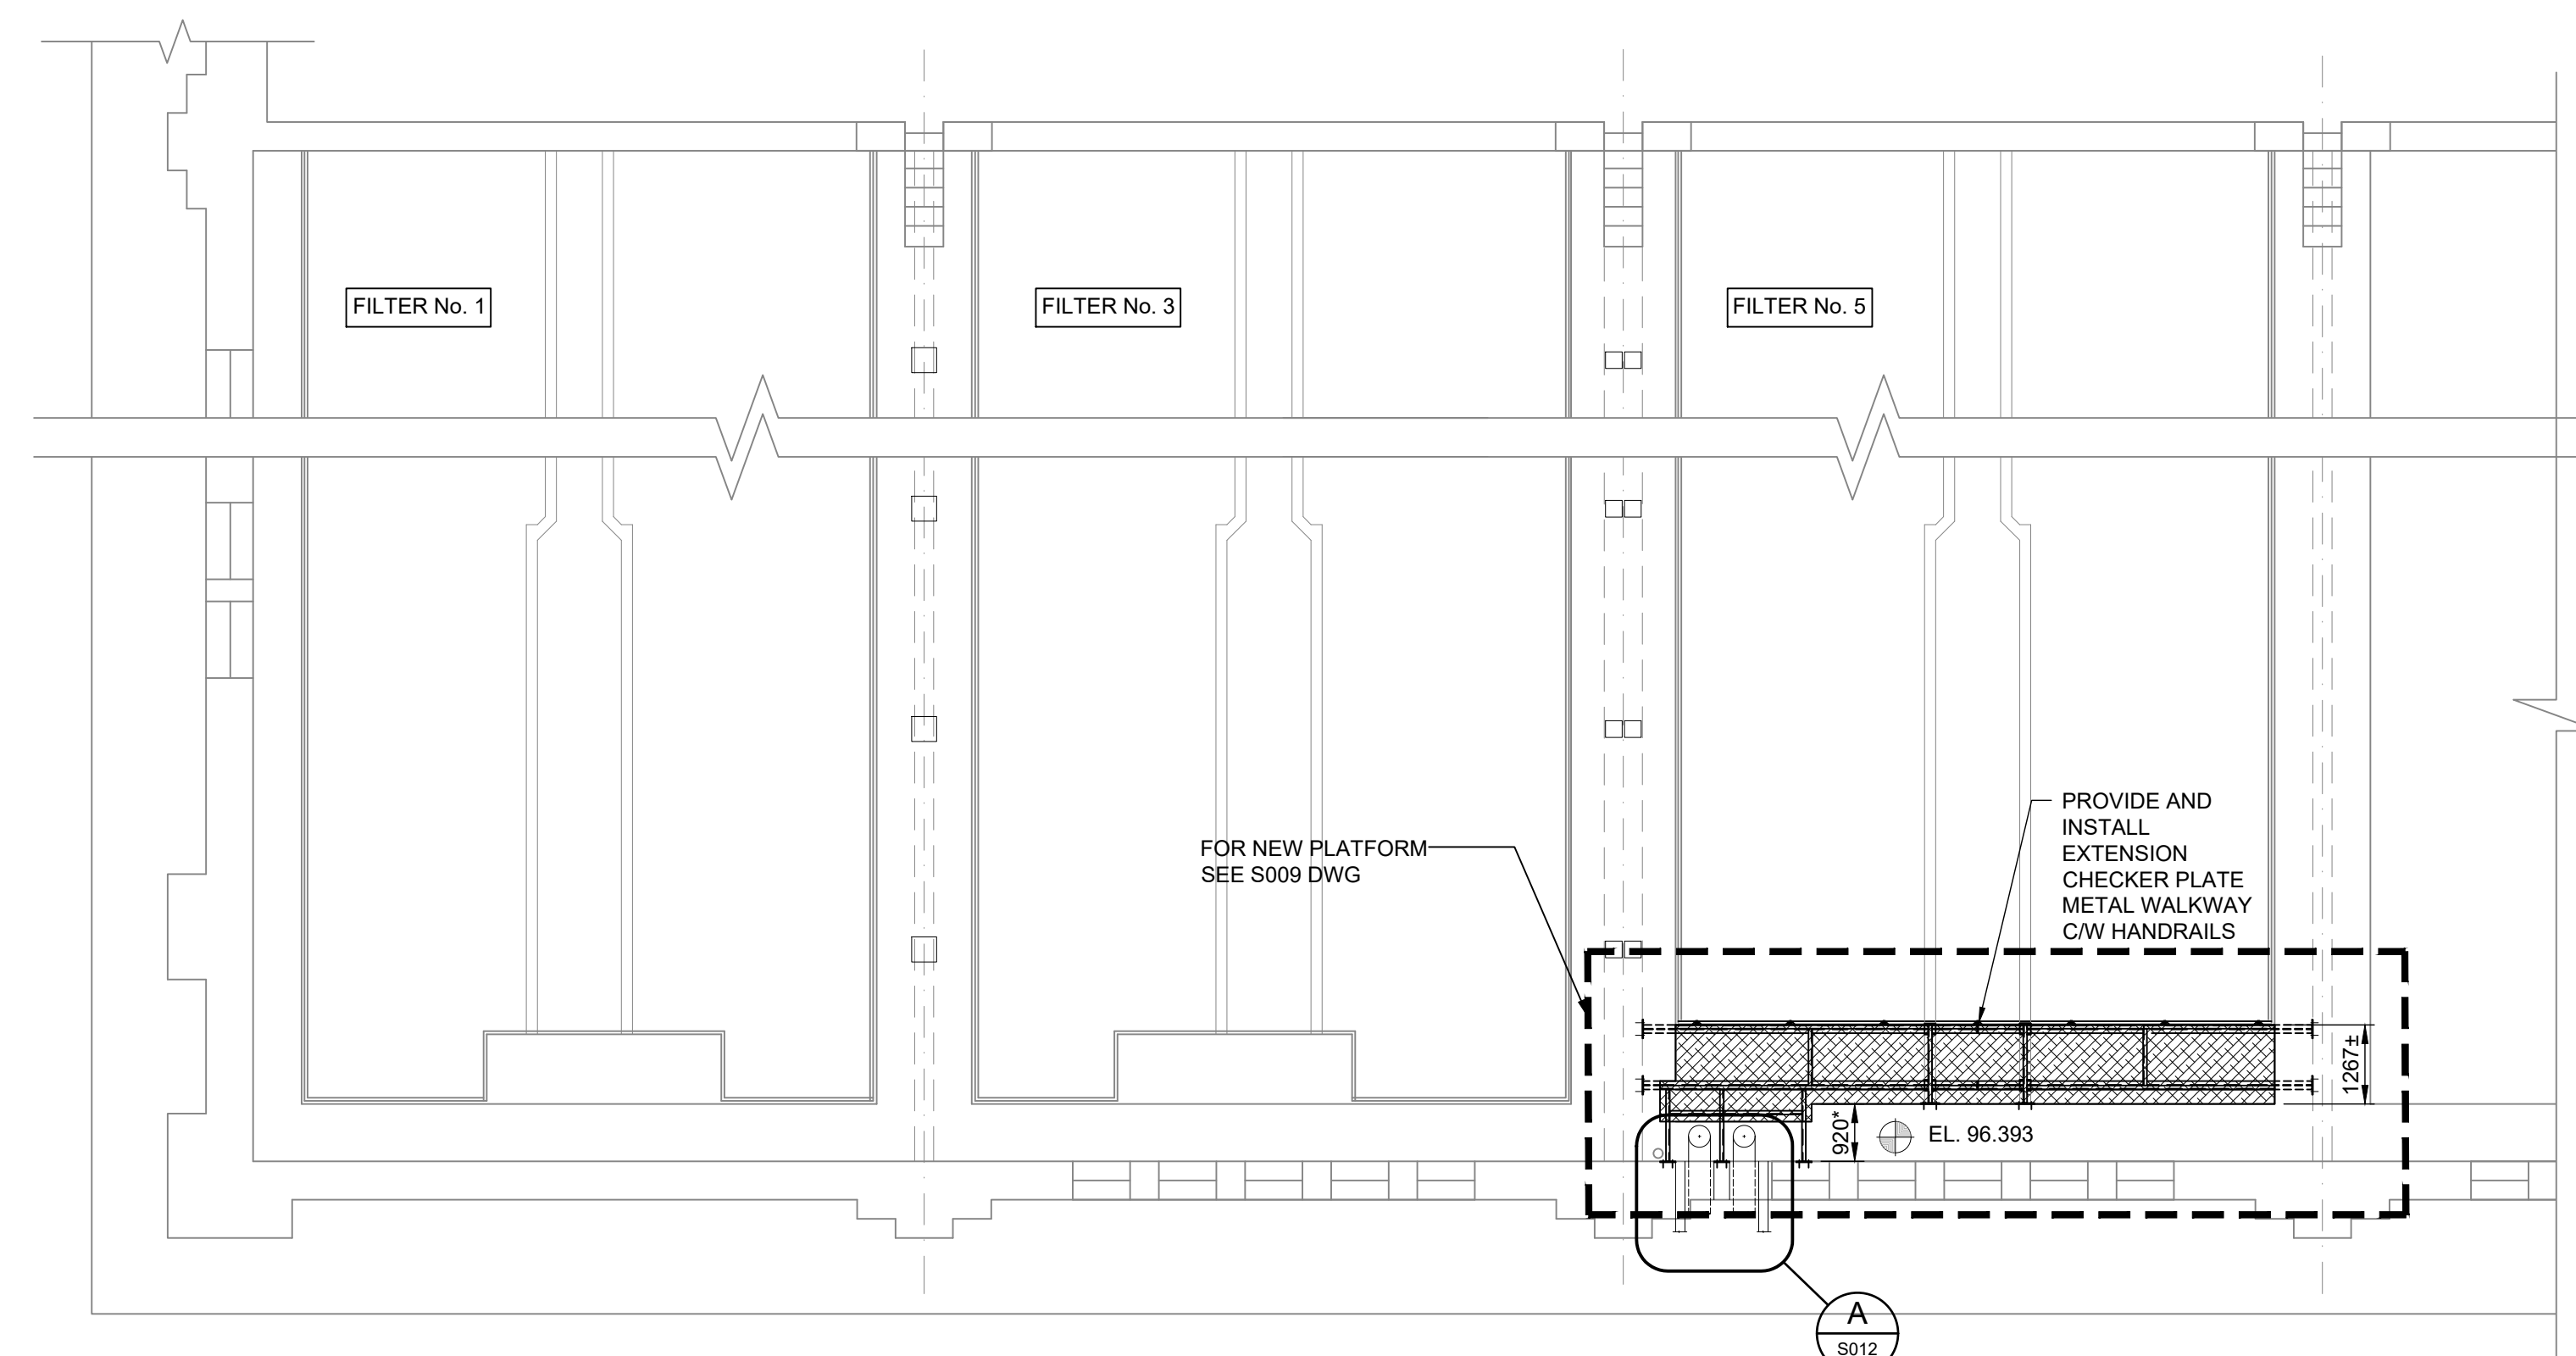


PART PLAN OF FILTER GALLERY


- NOTE:
1. LIVE LOAD ON STEEL PLATFORM IS 4.8 KPa U.N.O
 2. ALL STEEL MEMBERS ARE STAINLESS STEEL OR EQUIVALENT WELDED S.S. SECTION, U.N.O.
 3. * DENOTE SITE VERIFY DIMENSIONS

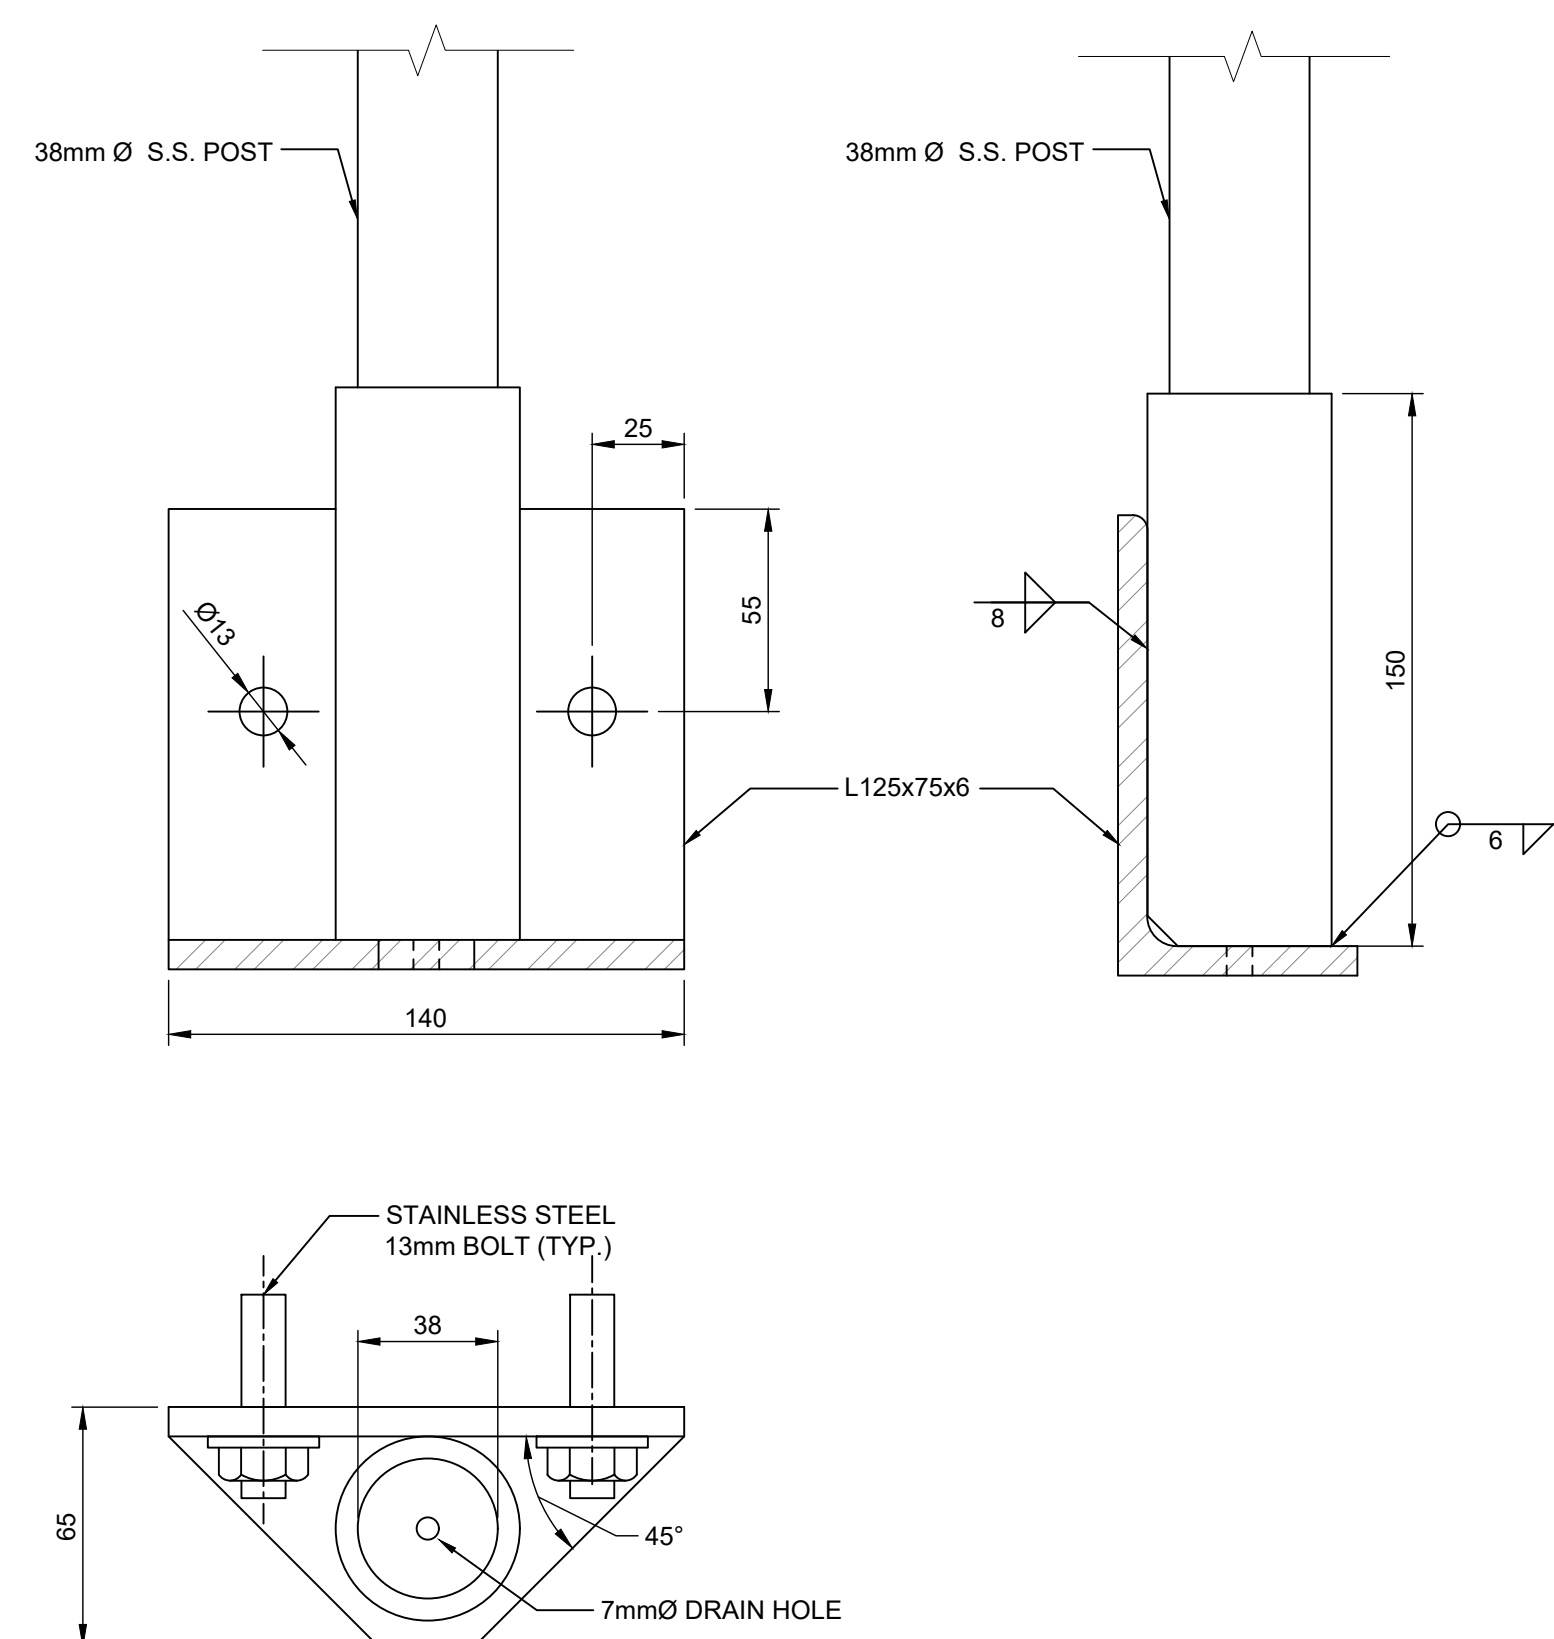

DETAIL OF POST HOLDER

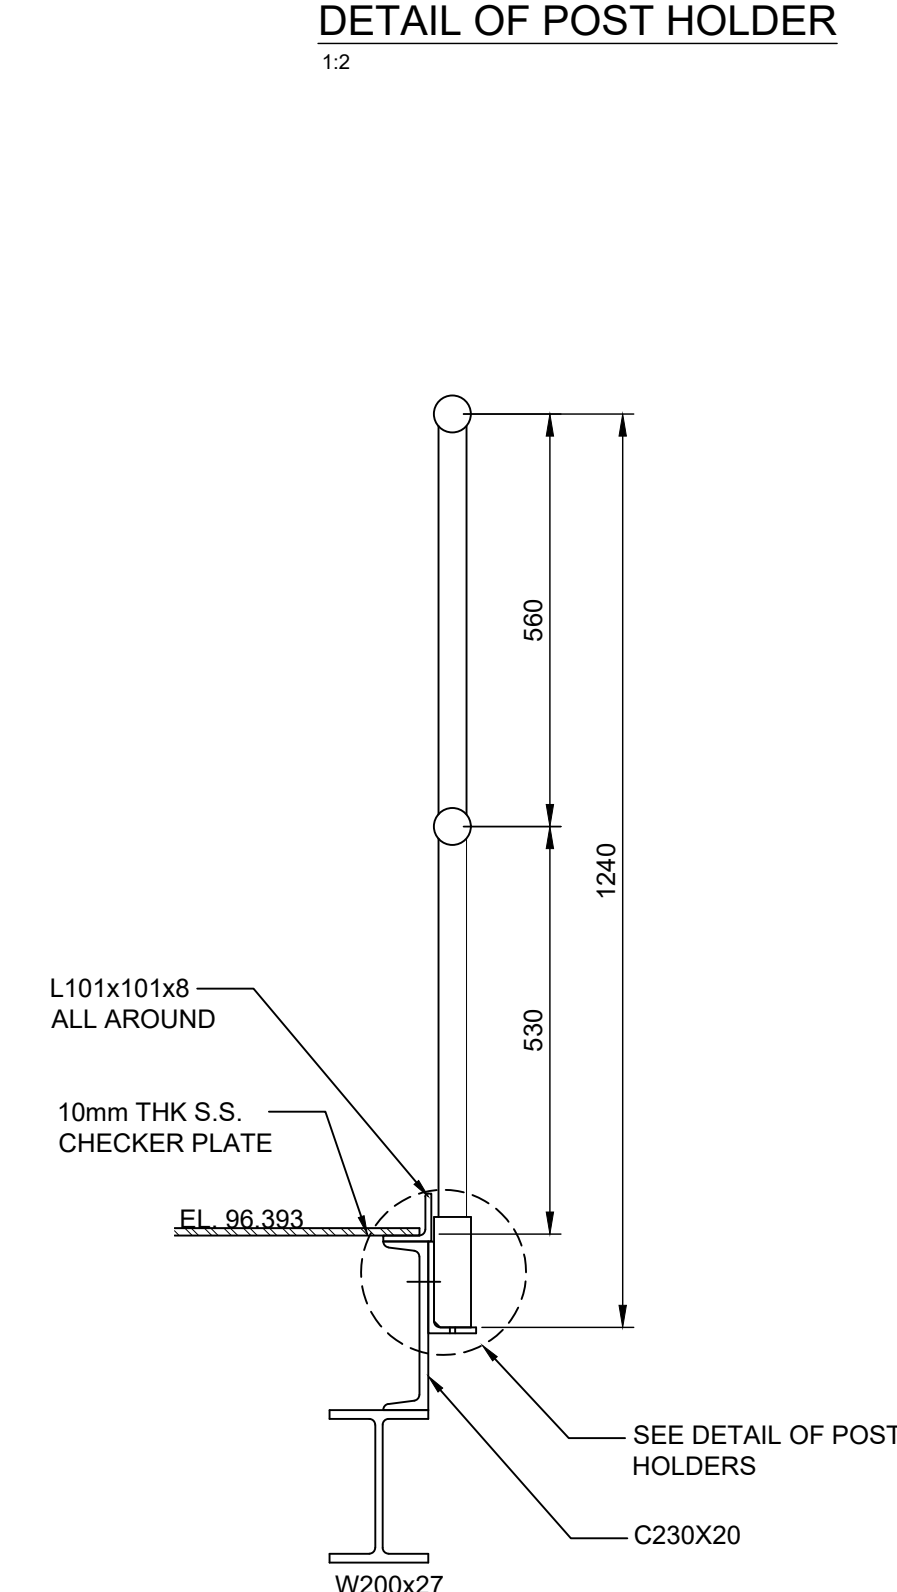


SECTION A
1 : 10

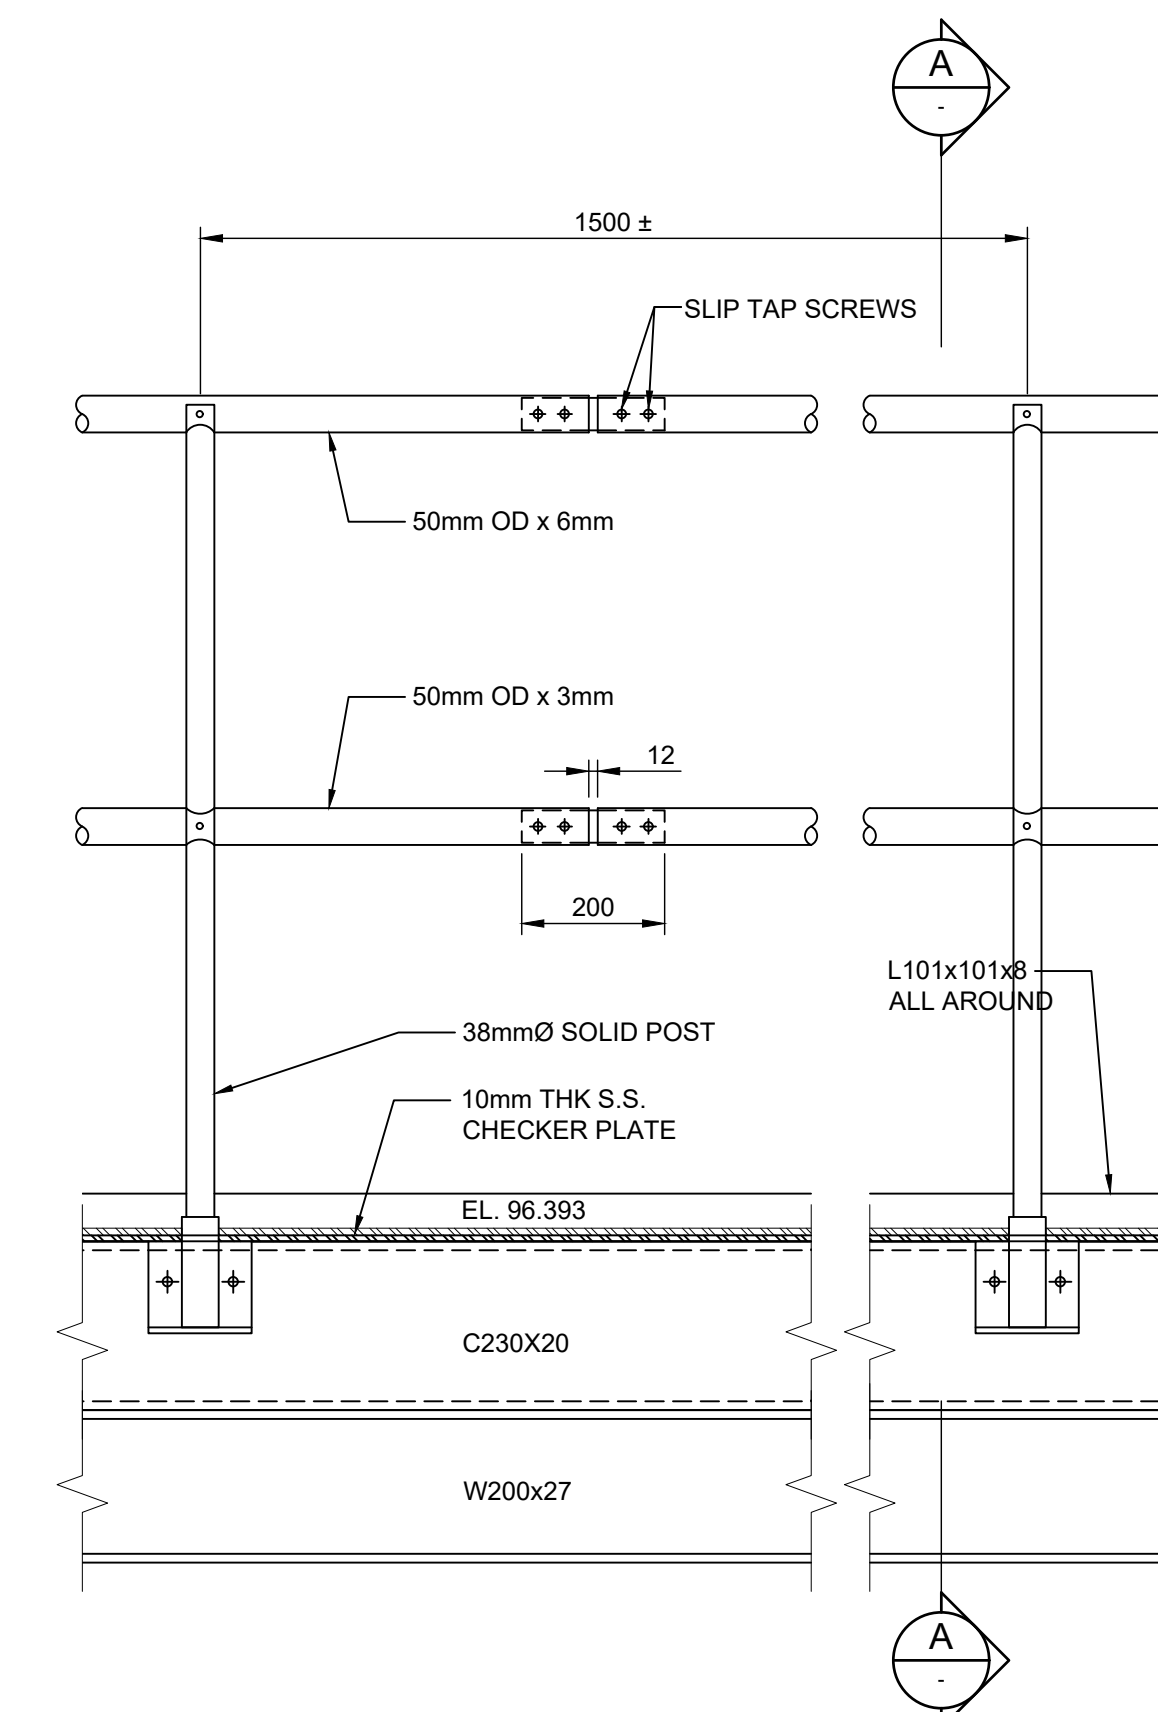


TYPICAL S.S. HANDRAIL ELEVATION

NOTE
NEW HAND RAIL SIZE & DIMENSION SHOULD MATCH EXISTING HANDRAIL

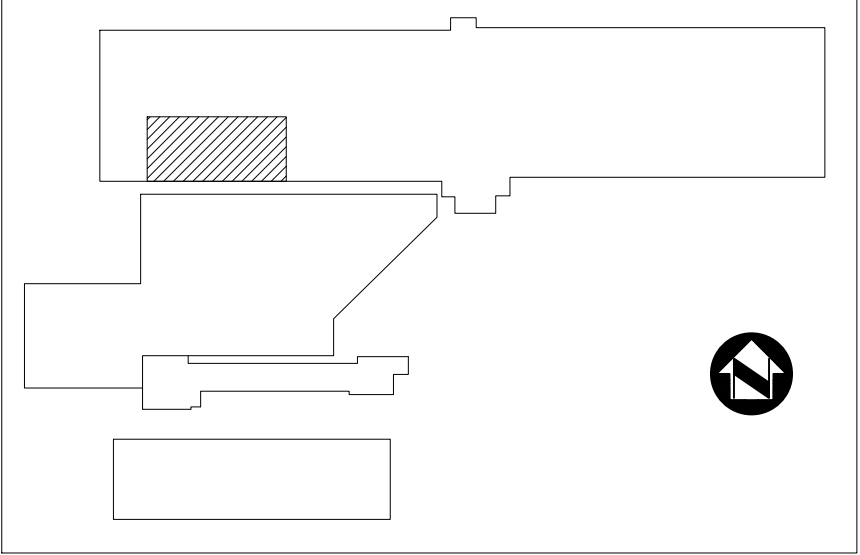

KEY PLAN

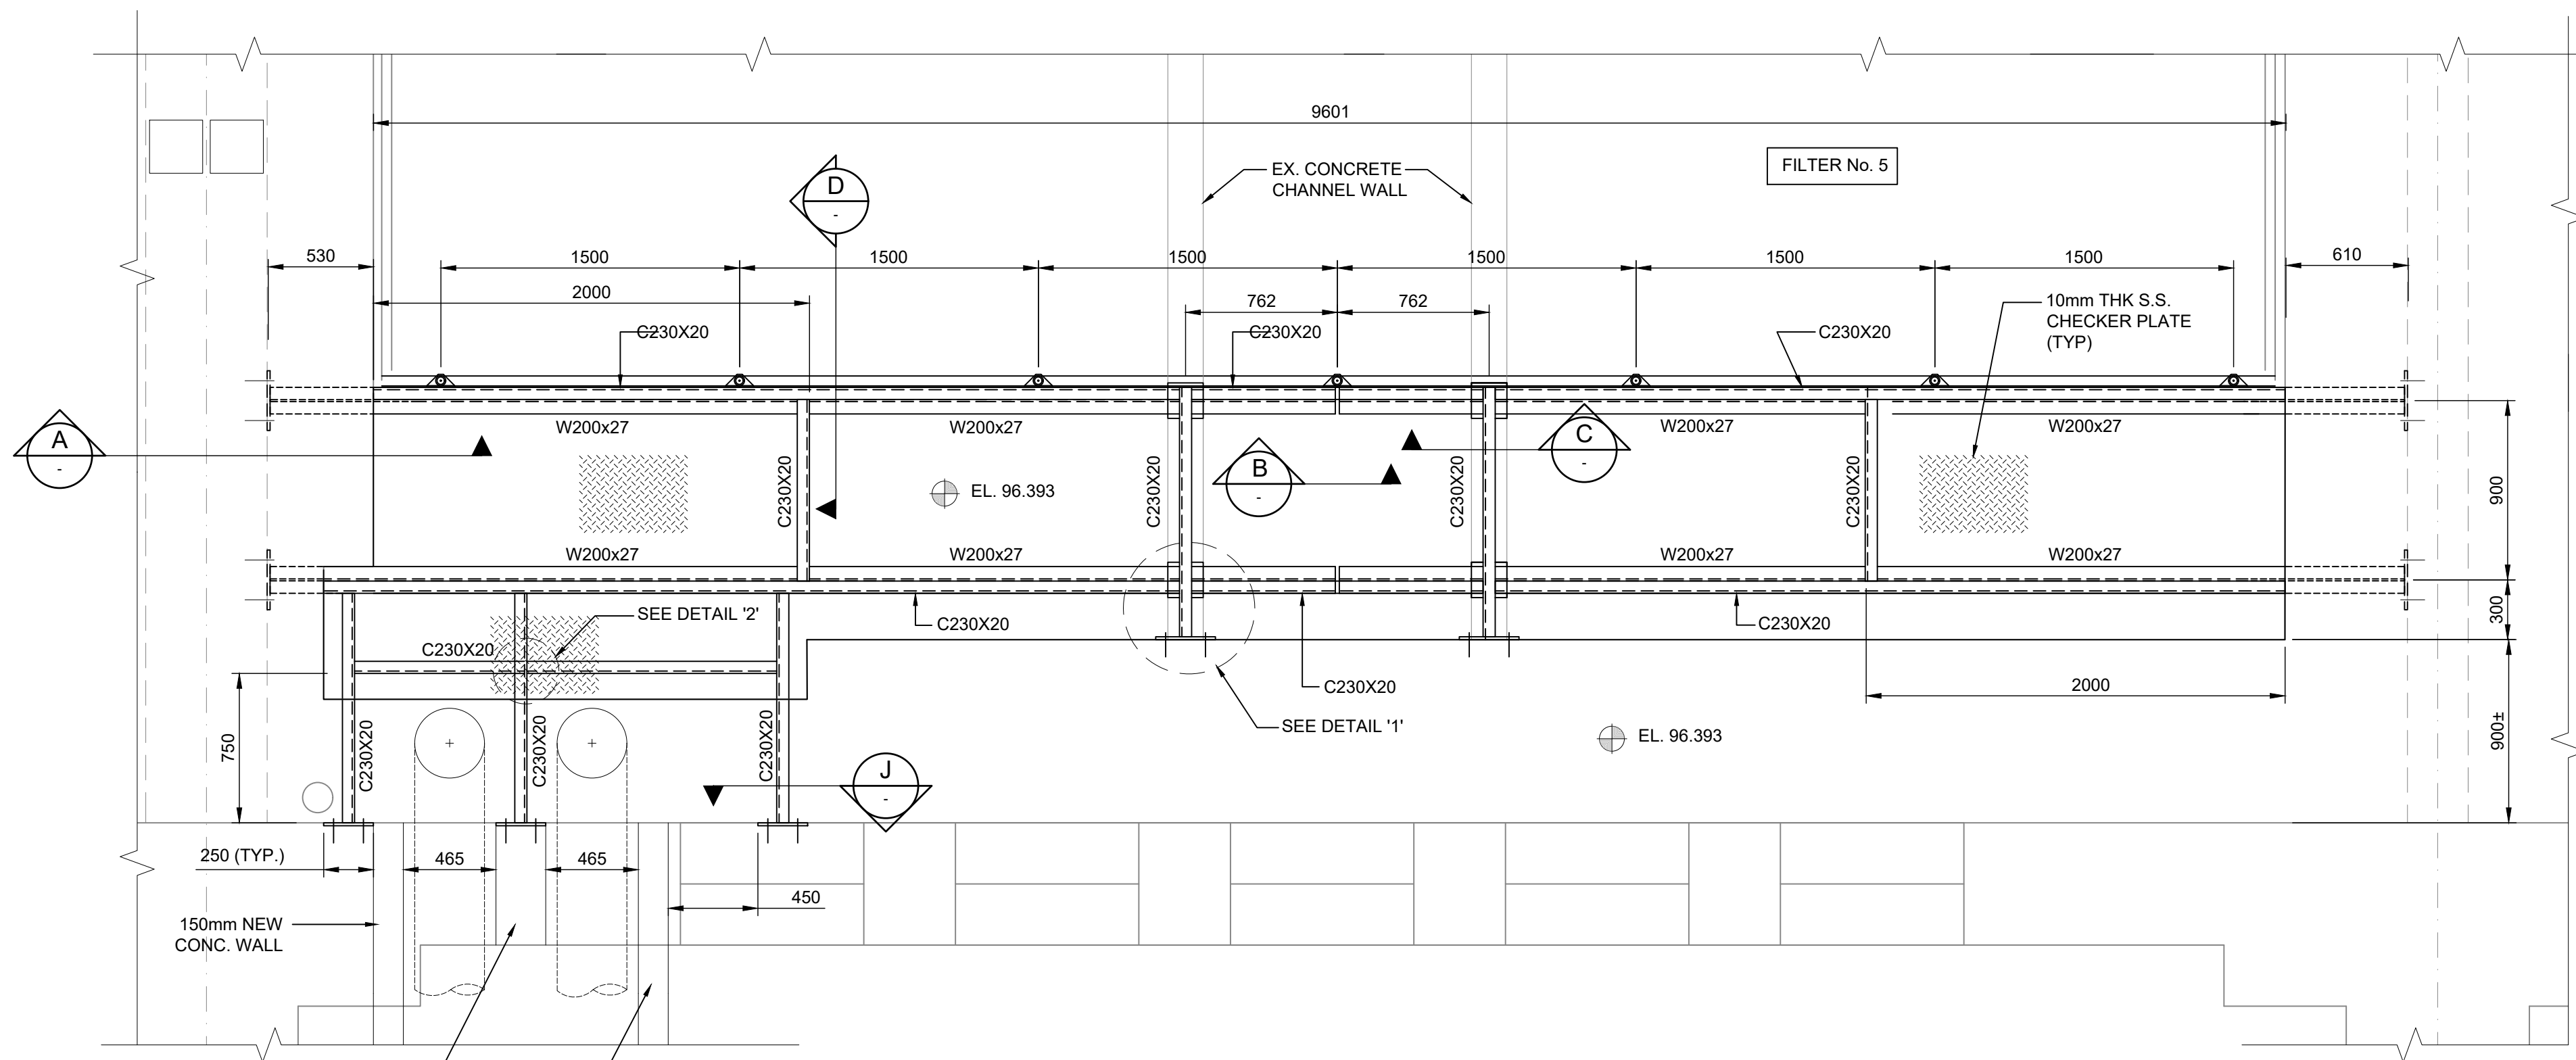


NEW PLATFORM - PART PLAN VIEW IN FILTER BUILDING


1:25

NOTE:


1. ALL NEW STRUCTURAL STEEL SHALL BE STAINLESS STEEL.
300x140x10mm THK S.S. CONNECTION PLATE W/8-M20 BOLTS

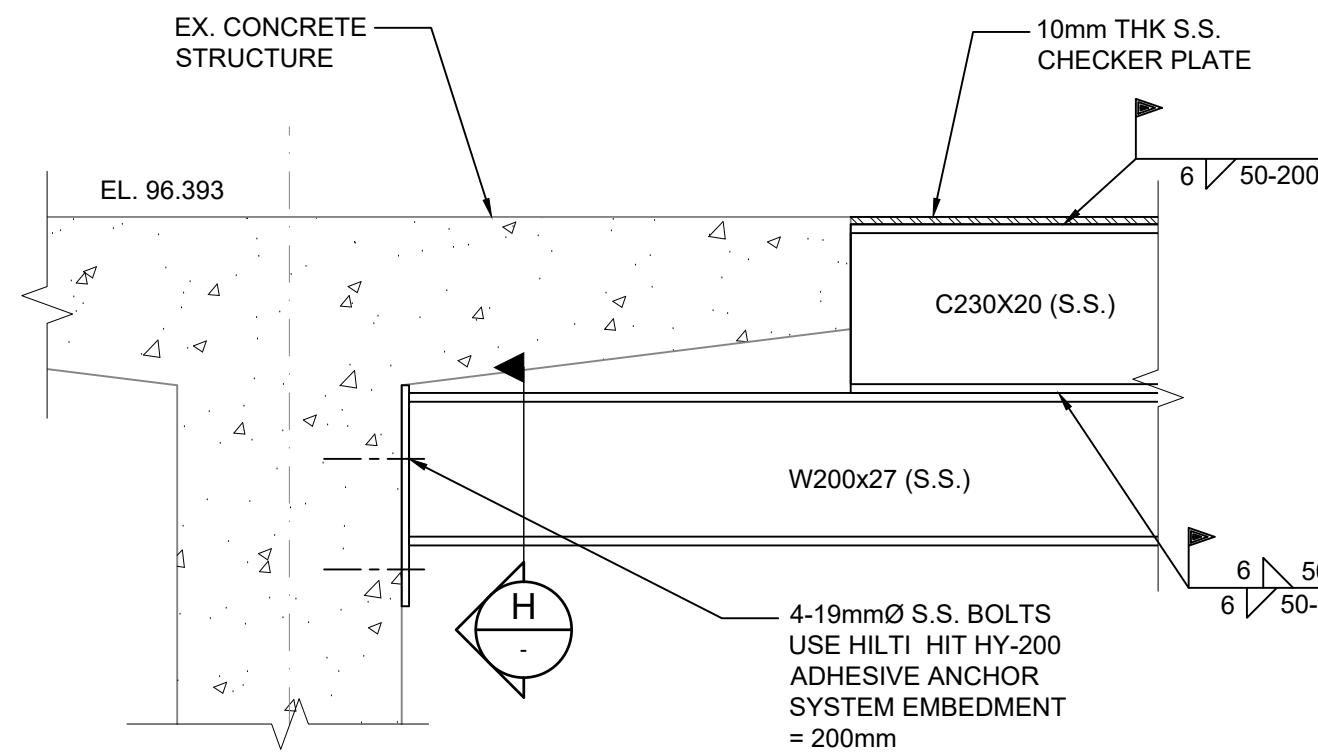


SECTION A
1:10

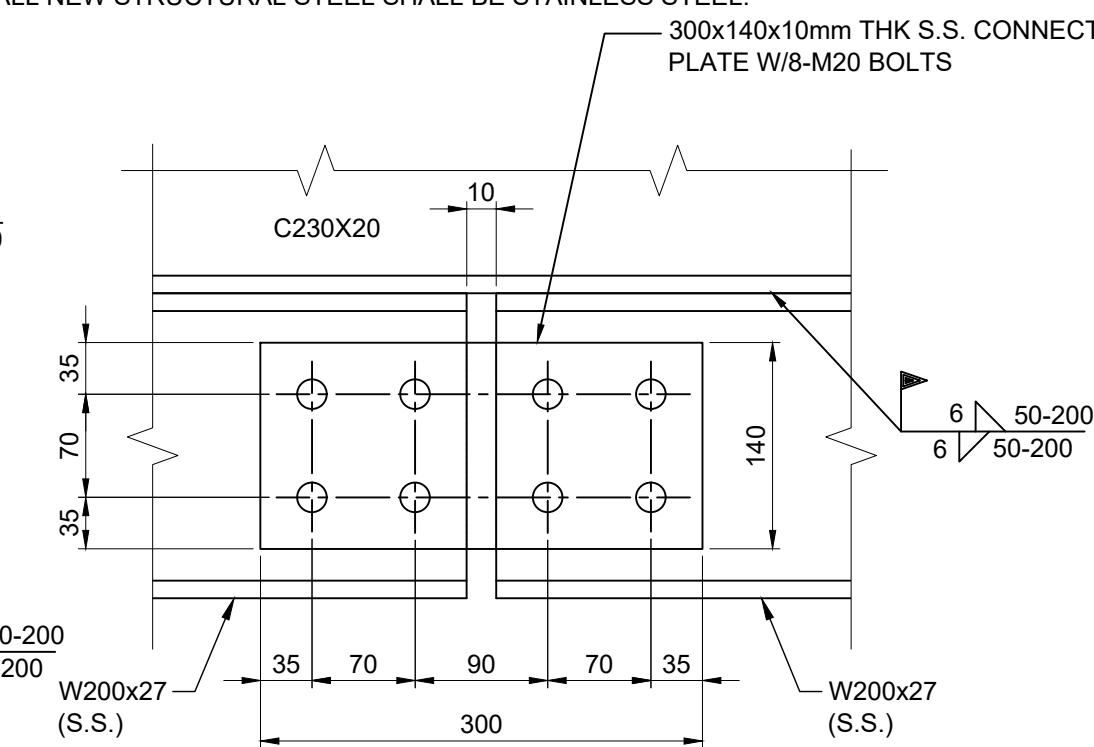


SECTION B
1:5

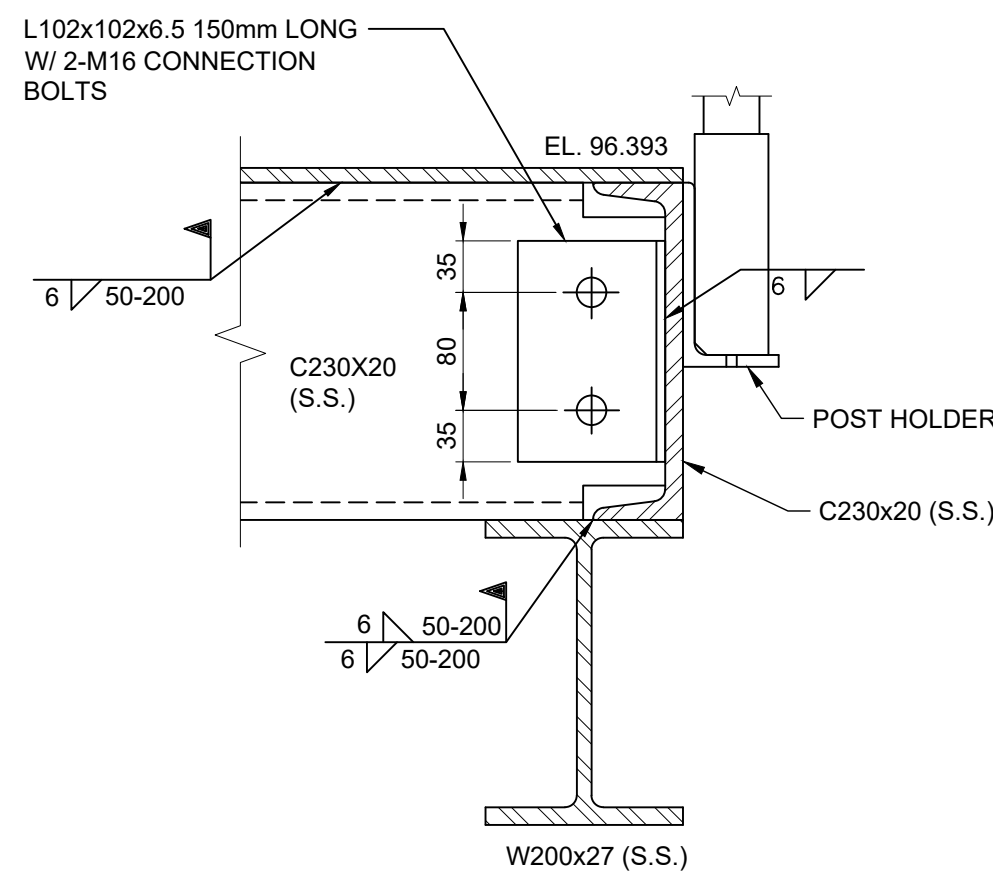


SECTION D
1:5

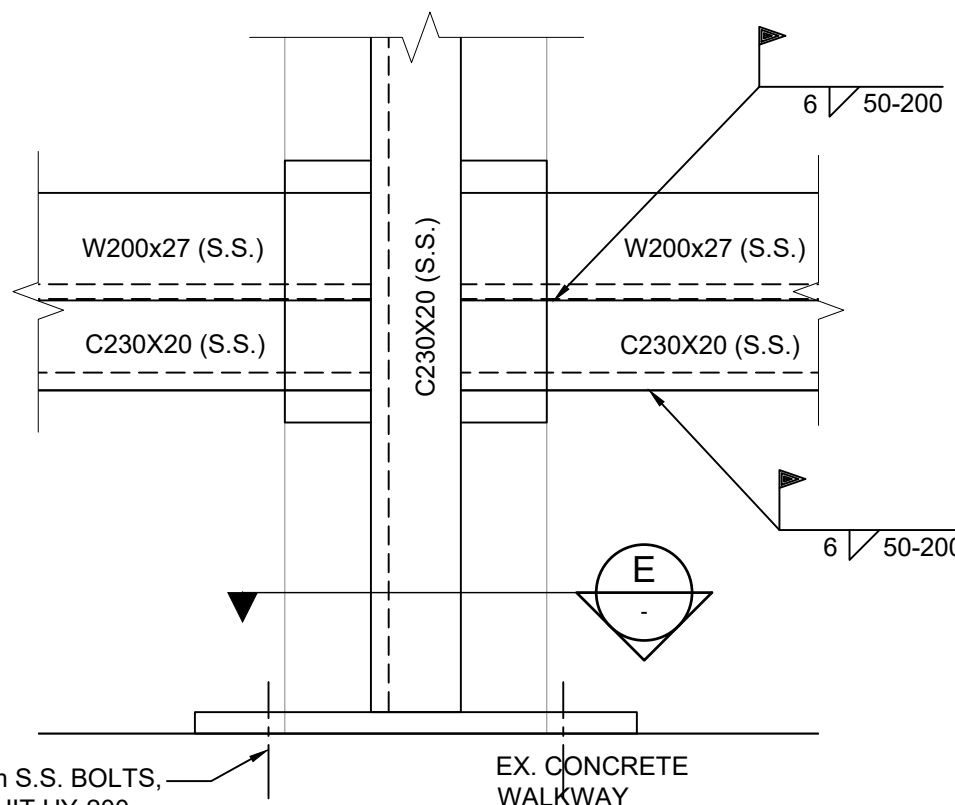


SECTION E
1:5

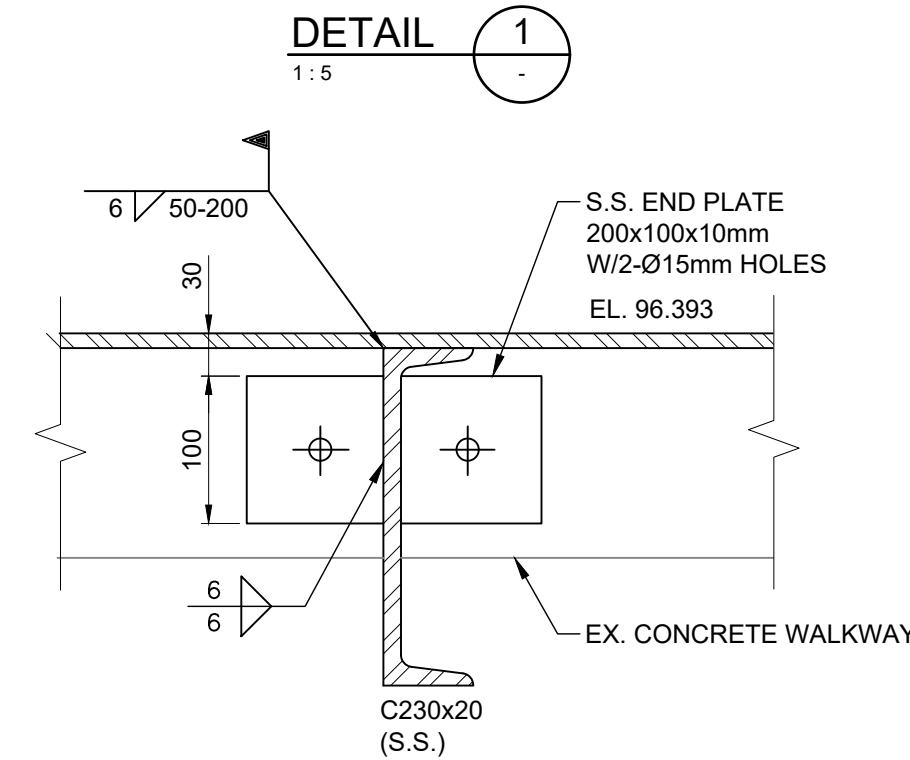


DETAIL 1
1:5

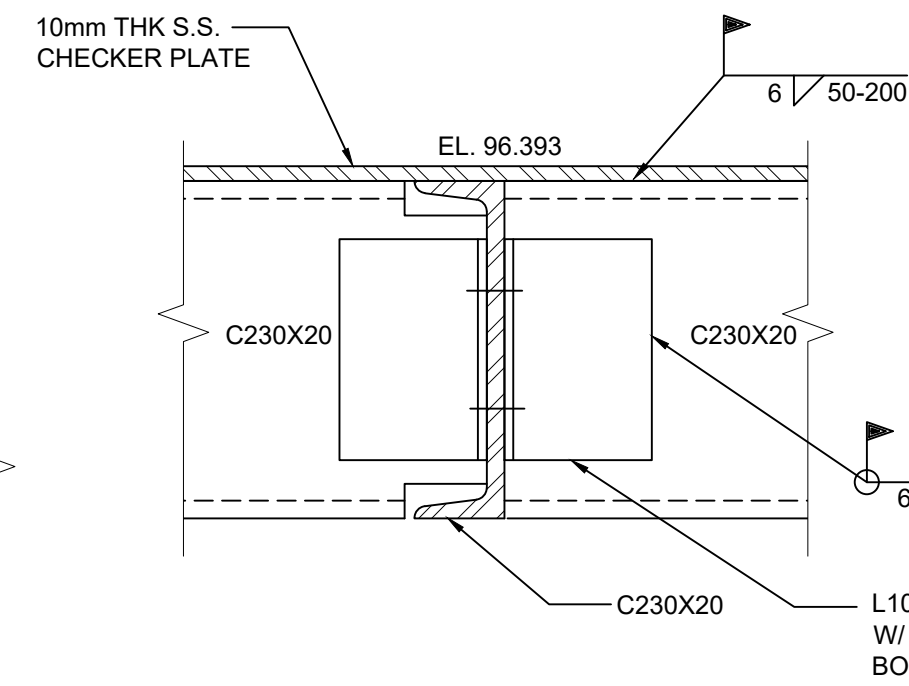


DETAIL 2
1:10

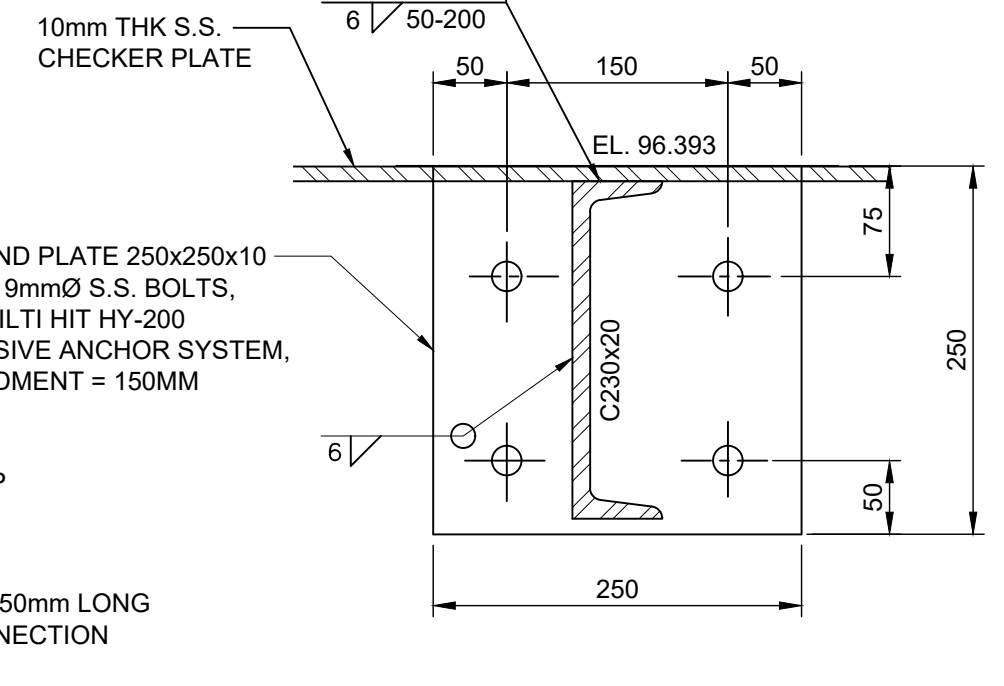


SECTION J
1:5

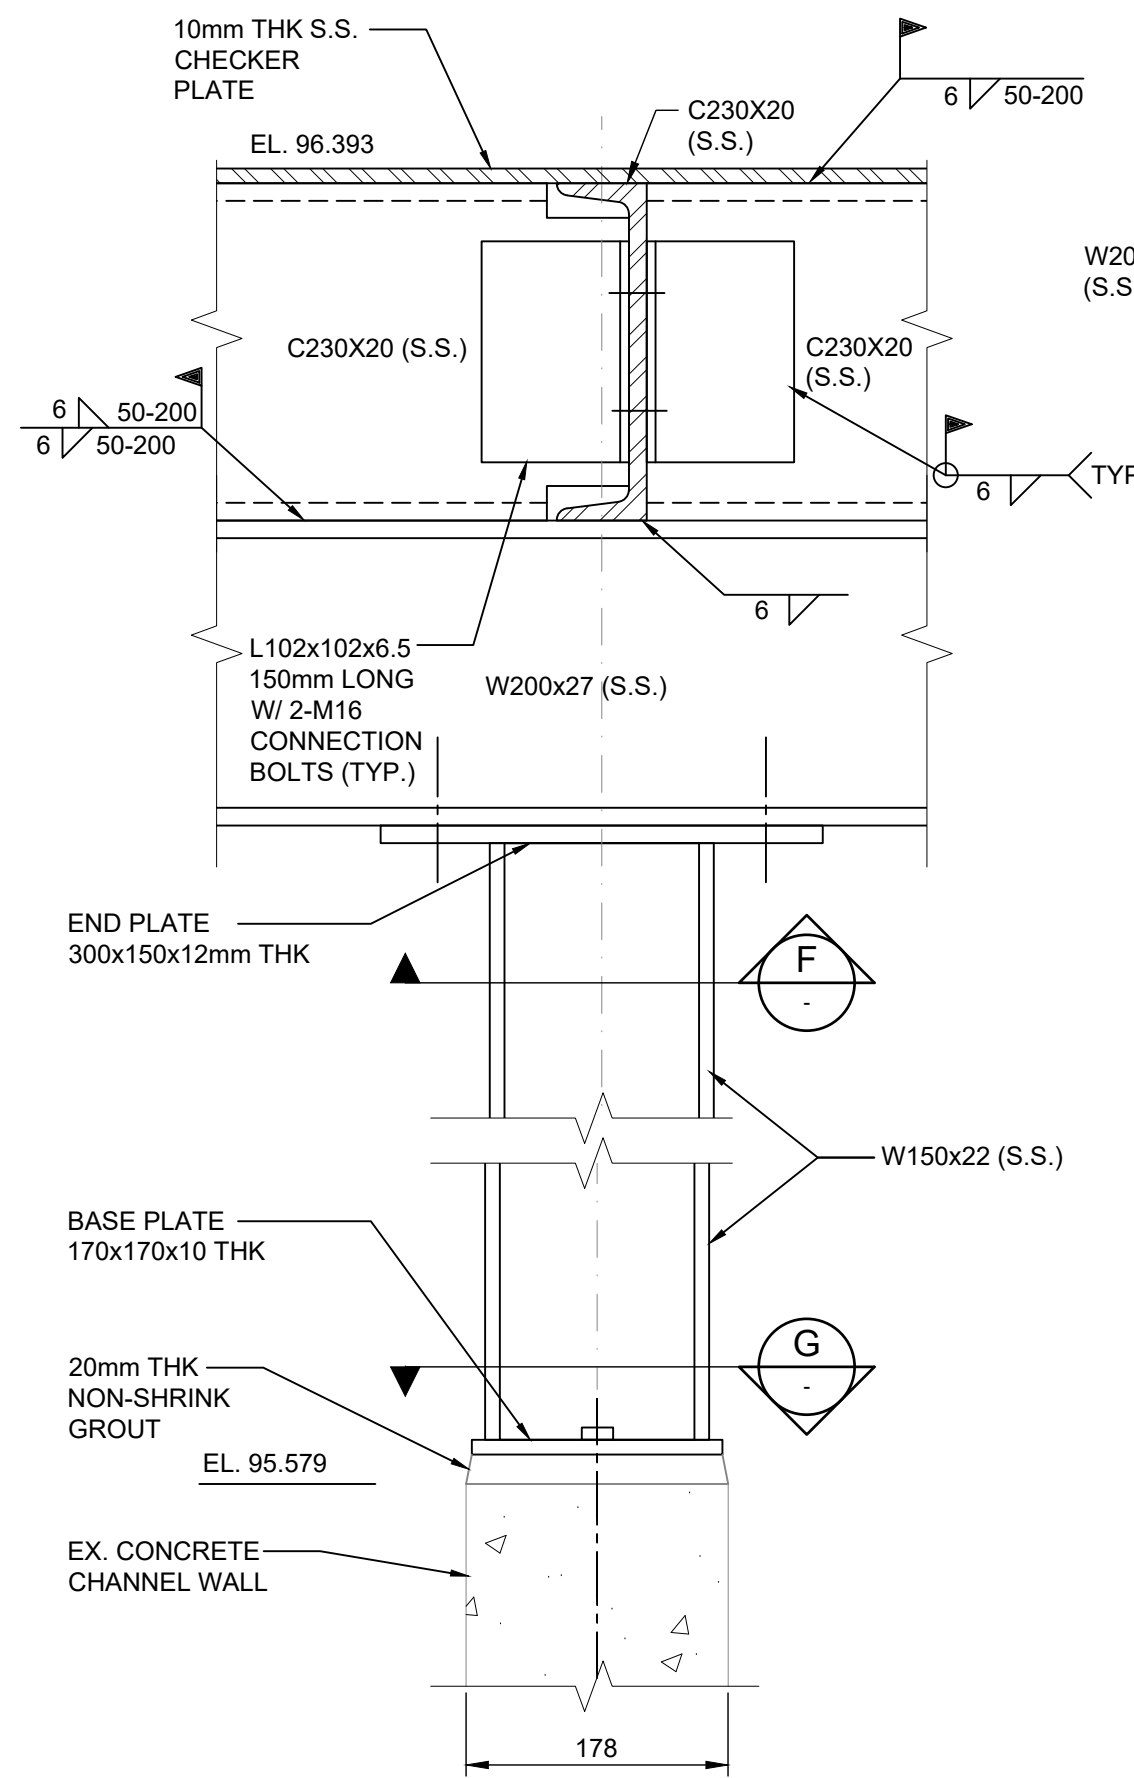

SECTION C
1:5

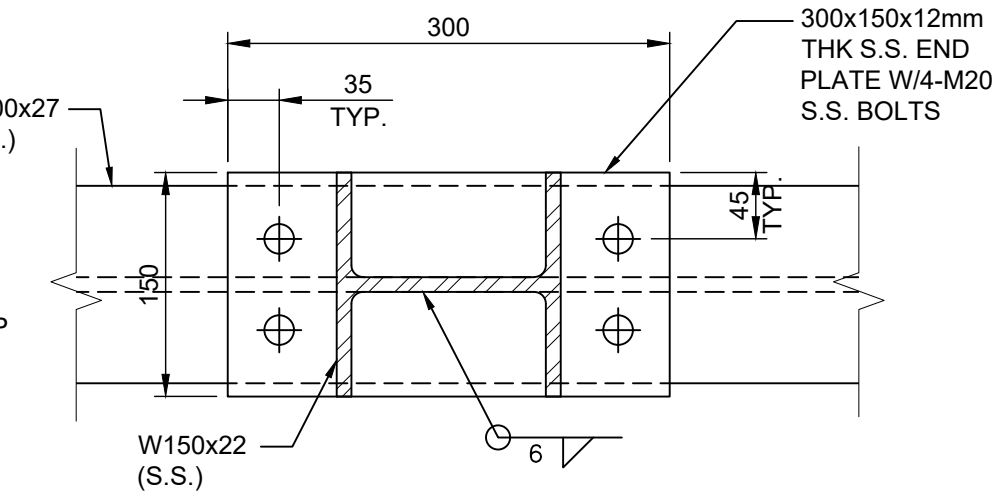

SECTION F
1:5

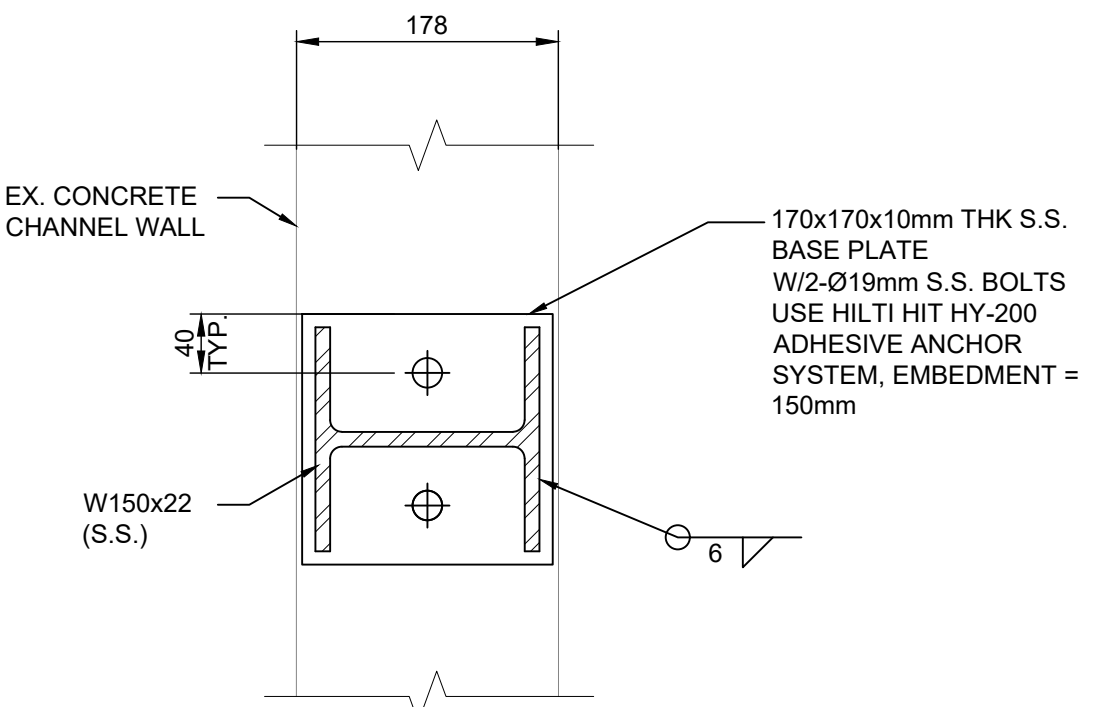

SECTION G
1:5



Issued for Tender

TORONTO WATER

ENGINEERING AND CONSTRUCTION SERVICES

WILLIAM FERNANDES, P. ENG.
DIRECTOR
WATER TREATMENT AND SUPPLY

SIMON HOPTON, P. ENG.
DIRECTOR
DESIGN & CONSTRUCTION
MAJOR INFRASTRUCTURE

R.C. HARRIS WATER TREATMENT PLANT
INSTALLATION OF A STANDBY GENERATOR FOR CRITICAL LOADS
FILTER GALLERY - NEW PLATFORM PLAN, SECTIONS AND DETAILS

STRUCTURE

DESIGN:	F.M.	DRAFTING:	S.P.	CHECK:	M.S.	CONTRACT No.	25ECS-MI-03HA
SCALE:	1:50			DRAWING NUMBER:	2F-2017-08-16		
DATE:	2024-09-30						S009






100-175 GALAXY BOULEVARD
TORONTO, ONTARIO, M9W 0C9
TEL 416 679 1930 FAX 416 675 4620
www.arcadis.com

COPYRIGHT:

This drawing has been prepared solely for the intended use, thus any reproduction or distribution for any purpose other than authorized by ARCADIS is forbidden. Written dimensions shall have precedence over scaled dimensions. Contractors shall verify and be responsible for all dimensions and conditions on the job, and ARCADIS shall be informed of any variations from the dimensions and conditions shown on the drawing. Shop drawings shall be submitted to RCI Group for general conformance before proceeding with fabrication.

ARCADIS Professional Services (Canada) Inc.

A	2025-03-18	ISSUED FOR TENDER	C.H.	
NO.	DATE	REVISIONS	INITIAL	SIGNED

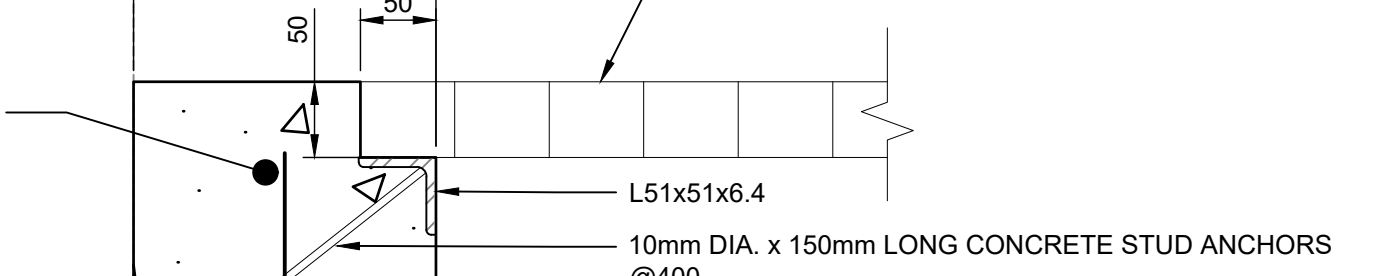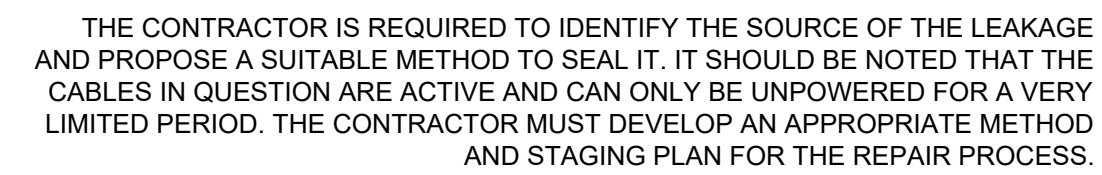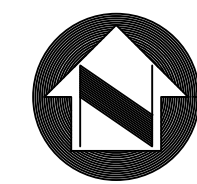

2-15M CONT.

200

50

50

GRATING

L51x51x6.4

10mm DIA. x 150mm LONG CONCRETE STUD ANCHORS @400

EXIST. SLAB ON GRADE

20M@400 DOWELS (MIN 4 EACH SIDE) WITH HIT-HY-200 ADHESIVE, 100mm EMBEDMENT OR EQUIVALENT (SEE SUMP PIT PLAN FOR DOWELS LOCATION)

200

50

200

50

2-15M CONT.

CONCRETE CURB

20M@400 DOWELS W/HILTI HIT-HY-200 ADHESIVE, 100mm EMBEDMENT OR EQUIVALENT

EXIST. REINFORCING REBARS TO BE ABRASIVE BLAST CLEANED AND LEFT IN PLACE

LOCALIZE CONCRETE REMOVAL BEHIND REINFORCING REBARS

25

25

25 mm SAW CUT ALL AROUND DAMAGED AREA

EXISTING CONCRETE SURFACE

1:1 SLOPE OR STEEPER

REMOVE SPALLED AND DELAMINATED CONCRETE AND APPLY CONCRETE BONDING AGENT (SIKA ARMATEC 110) TO THE PREPARED SURFACE AND REPLACE WITH 35MPa CONCRETE PATCH WITH SIKA WT-240P PERMEABILITY REDUCING ADMIXTURE OR EQUIVALENT

EXIST. CONCRETE STAIRS

EXIST. CONCRETE WALL

GRATING DESIGNED BY CONTRACTOR

200 50 50 200

NOTE:

1. FIBERGLASS ANGLE WALL CONTAINING PENETRATION TO FROM THE TUNNEL
2. FIBERGLASS ANGLE OPTIMIZED ON SITE EFFECTIVENESS

NOTE:

1. FIBERGLASS ANGLE TO BE INSTALLED ON THE WALL CONTAINING THE CABLE DUCT PENETRATION TO DIRECT LEAKAGE AWAY FROM THE TUNNEL AND TOWARD THE SUMP PIT
2. FIBERGLASS ANGLE LOCATION TO BE OPTIMIZED ON SITE FOR MAXIMUM EFFECTIVENESS

FINISHED GRADE
EL. 257.5

FINISHED FLOOR
EL. 258.0

REFER TO DETAIL C/S010 FOR CONCRETE REPAIR

EXIST. CONCRETE WALL

EXIST. CONCRETE SLAB

EXIST. TUNNEL

EXIST. SOG

EL. 234.75

3-10mm DIA. FIBERGLASS BOLTS
W/HIT-RE-500 ADHESIVE OR EQUIVALENT
70 mm EMBED.

167

600

16°

FIBERGLASS L75x75x4.8
MOUNTED ON WALL ADJACENT TO OPENING WALL

CONCRETE CURB ALL AROUND

EXIST. CONCRETE STAIRS

THE
MP PIT




A	2025-03-18	ISSUED FOR TENDER		C.H.
NO.	DATE	REVISIONS		SIGNED



SIMON HOPTON, P. ENG.
DIRECTOR
DESIGN & CONSTRUCTION
MAJOR INFRASTRUCTURE


DESIGN:	F.M.	DRAFTING:	S.P.	CHECK:	M.S.	CONTRACT No.	25ECS-MI-03HA
SCALE:	AS INDICATED			DRAWING NUMBER:	2F-2017-08-17		S010
DATE:	2024-09-30						

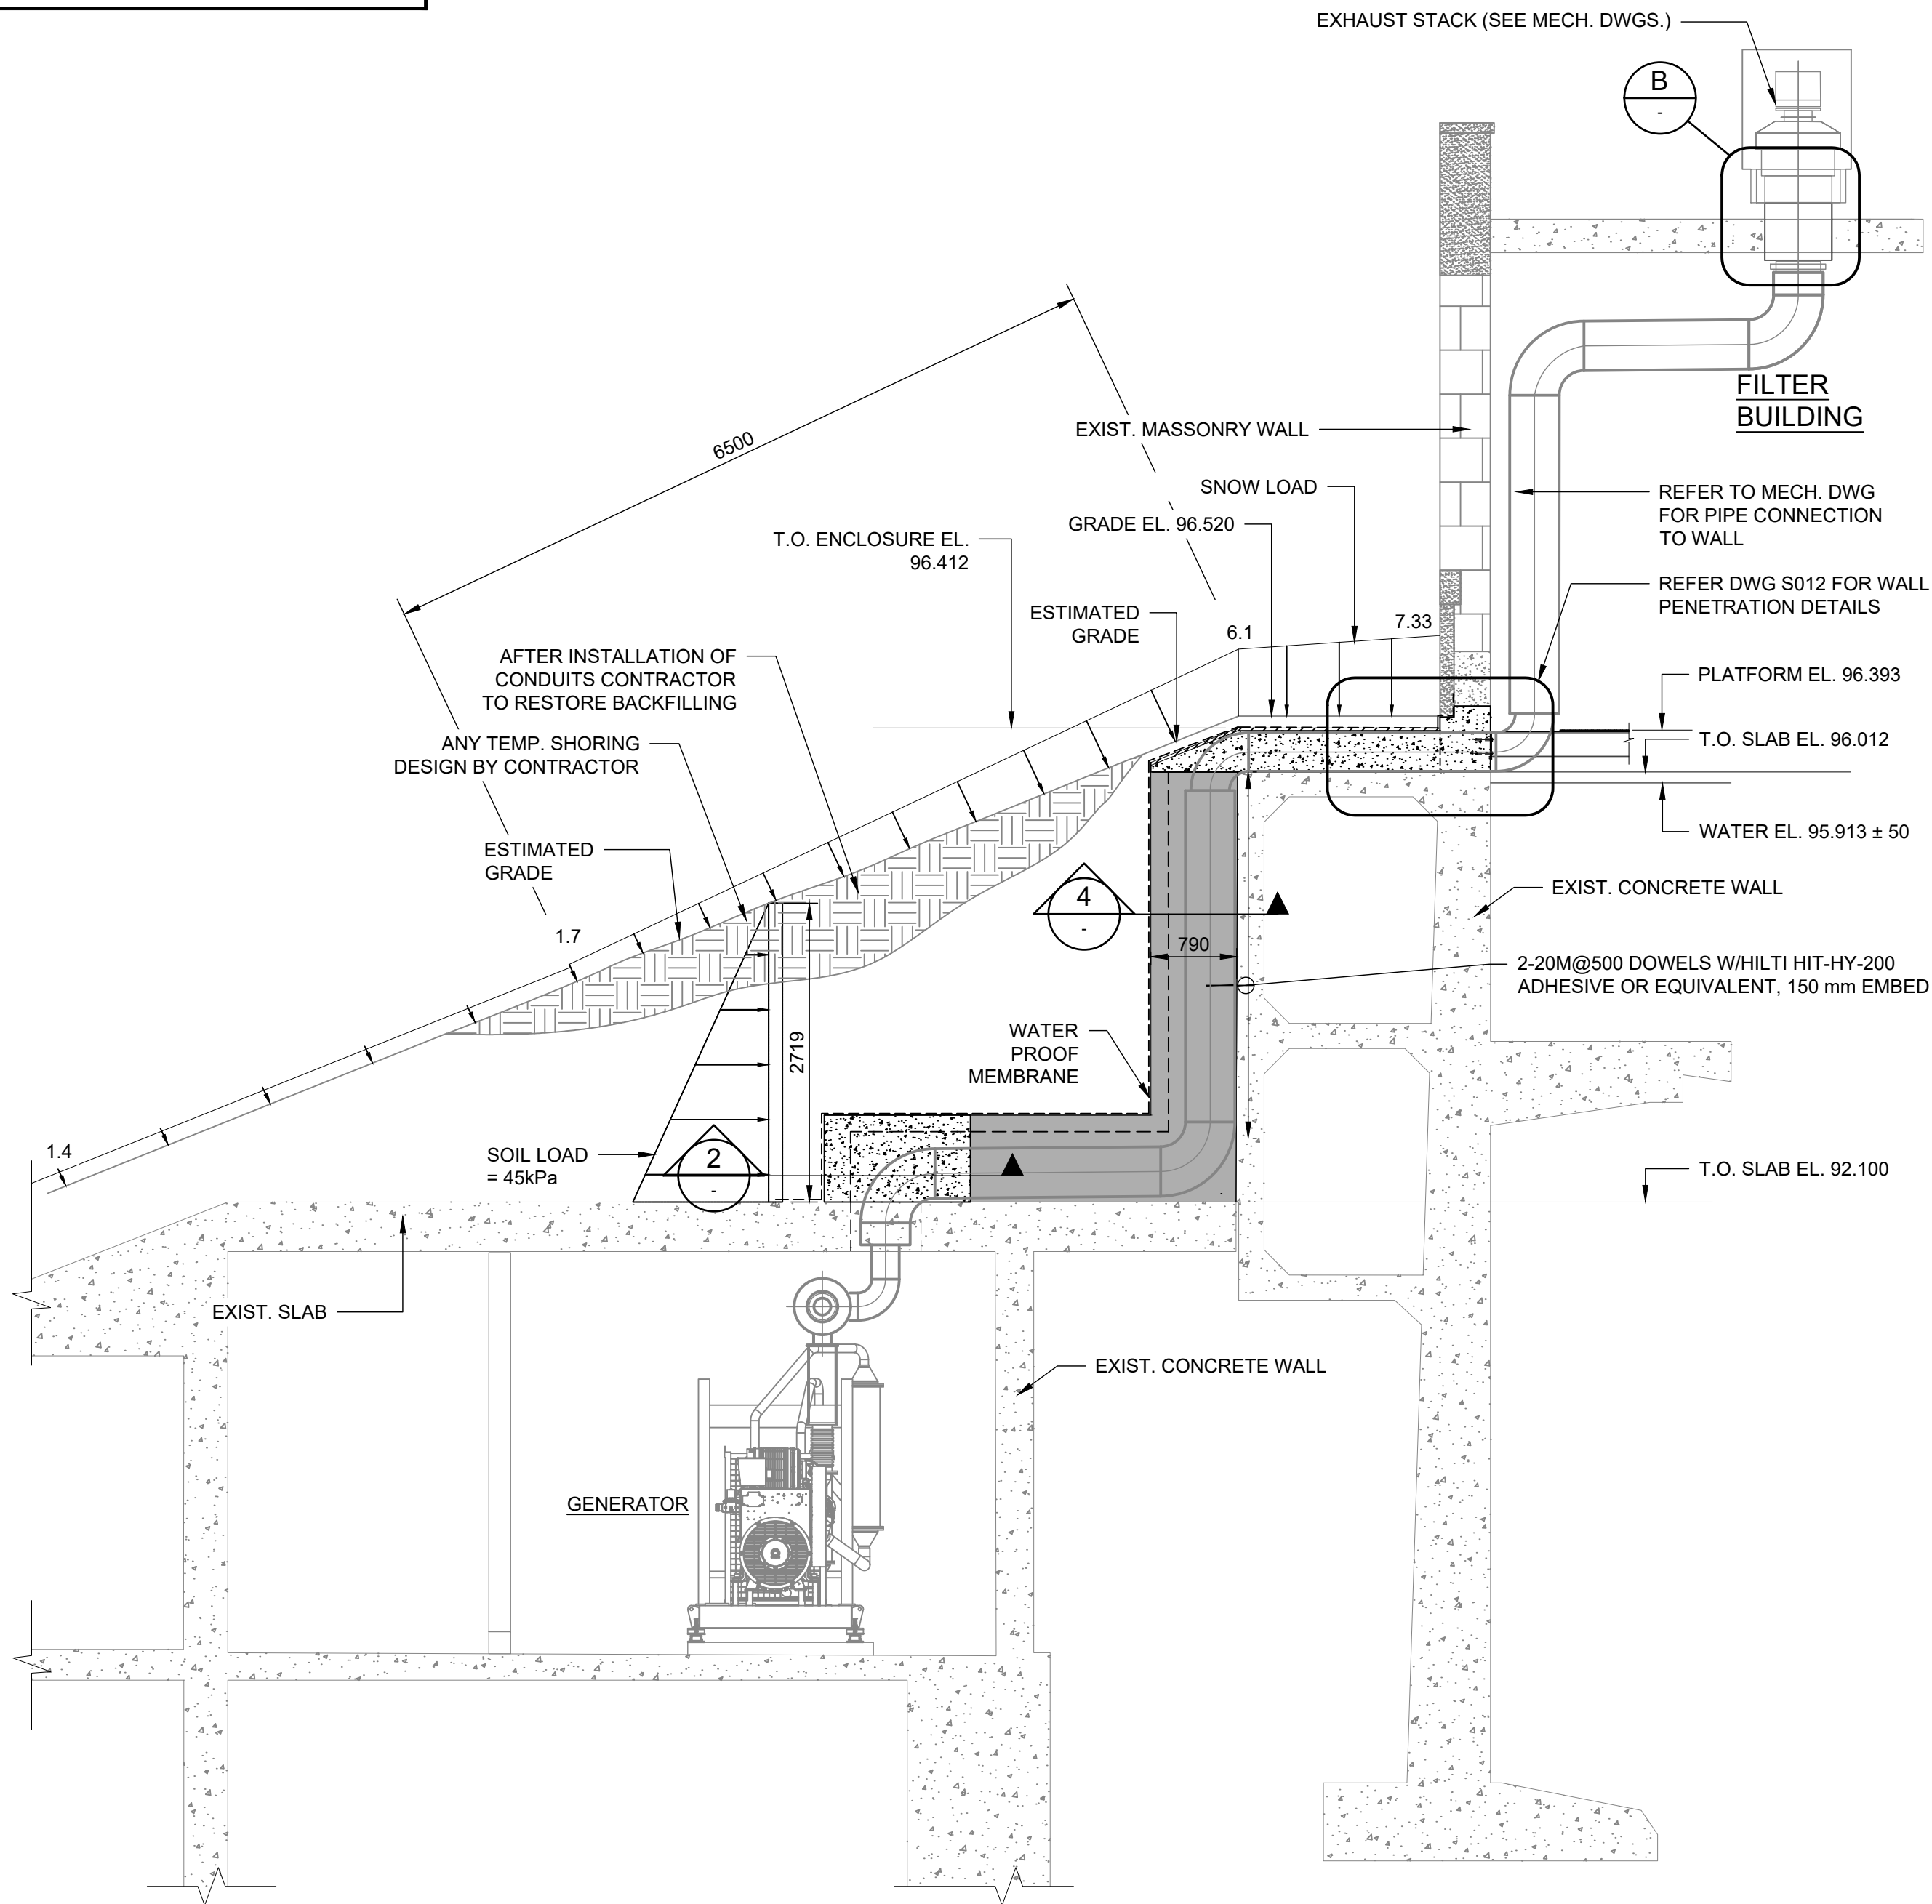

PIPE GALLERY, GENERATOR ROOM &
WATER CONDUIT - ELEVATION

1:50


1

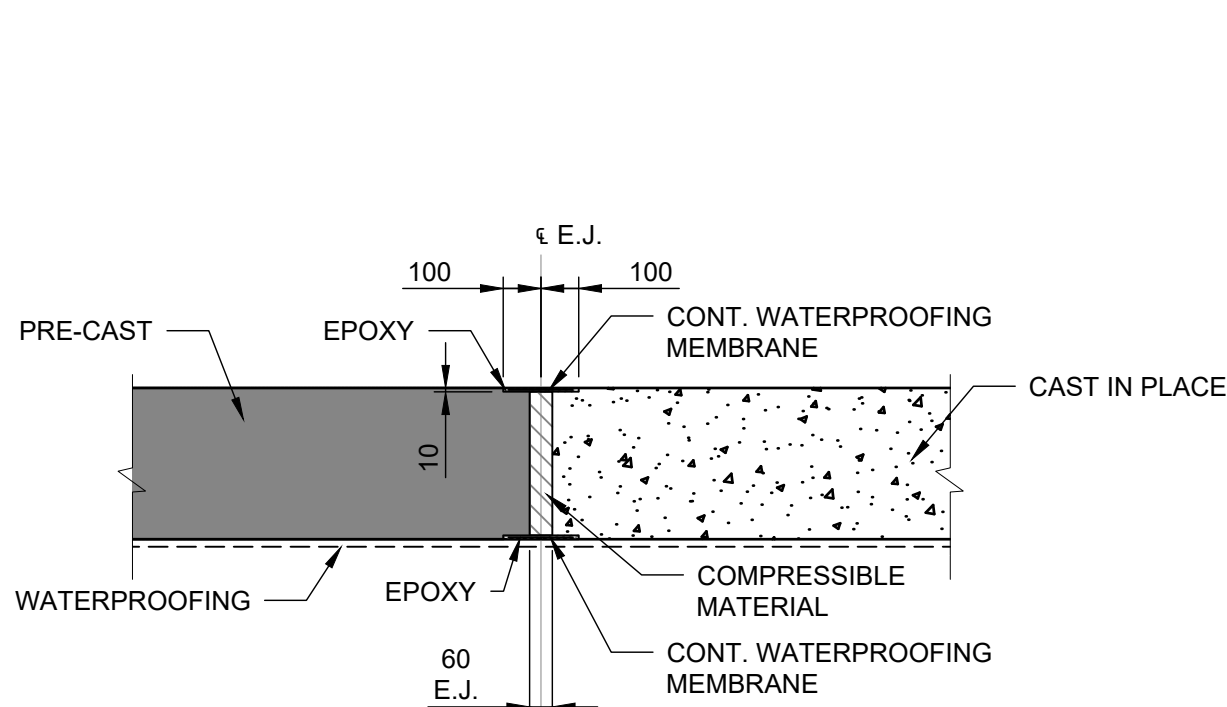

PRECAST AND CAST IN PLACE
JOINT DETAIL

N.T.S.


6

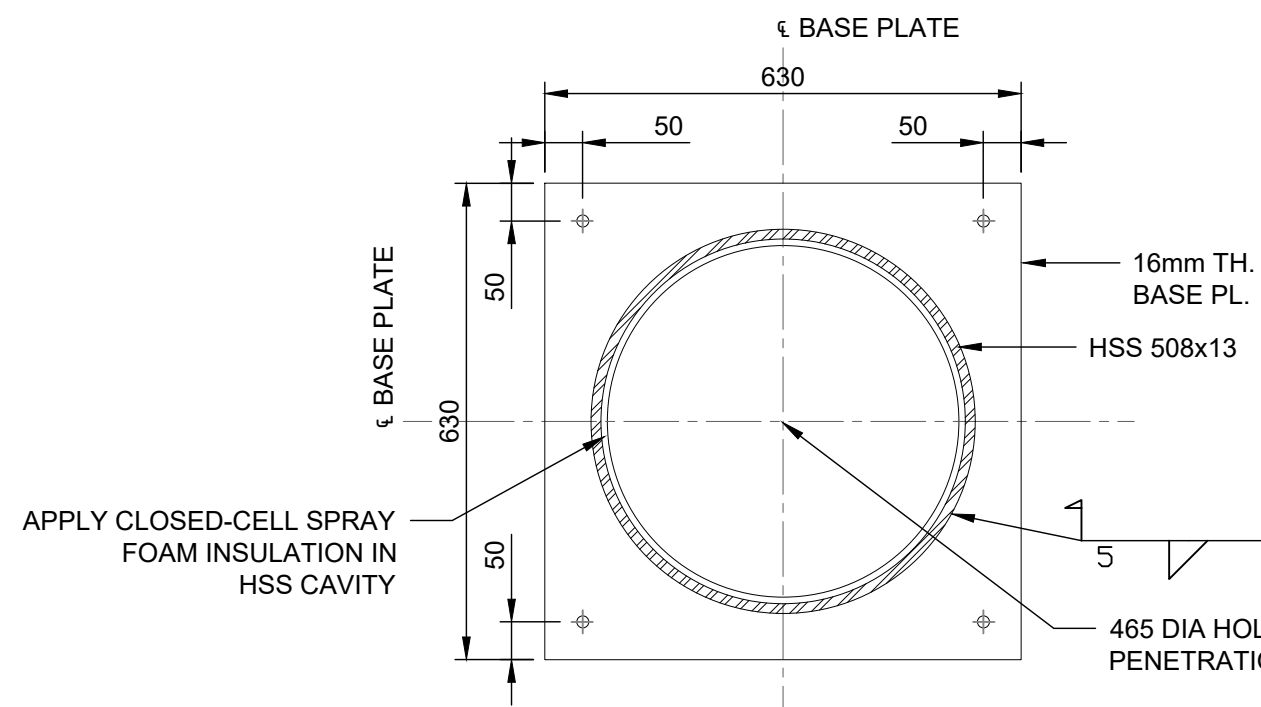

BASE PLATE DETAIL

1:10


5

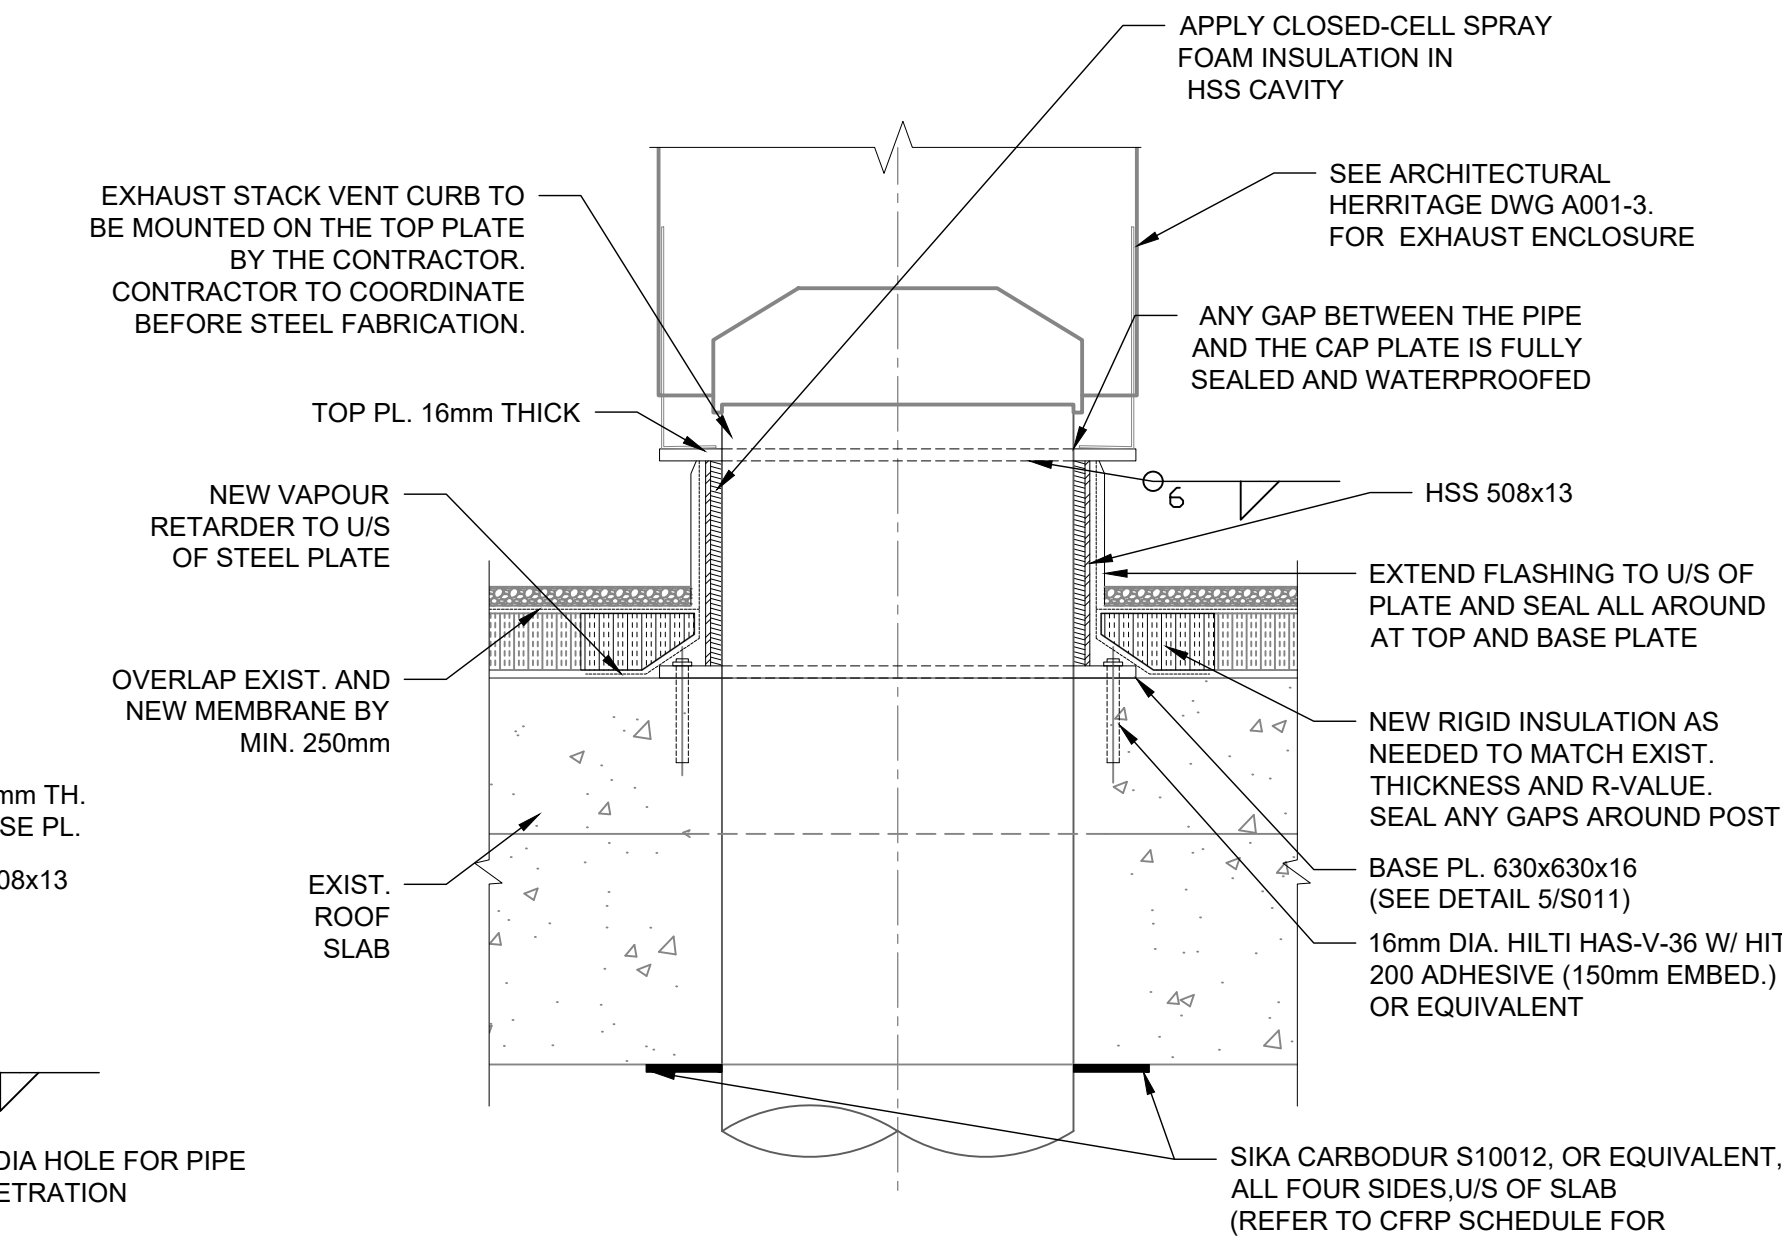

DETAIL OF PIPE PENETRATION
THROUGH ROOF SLAB AT EL. 101.08

1:10


B

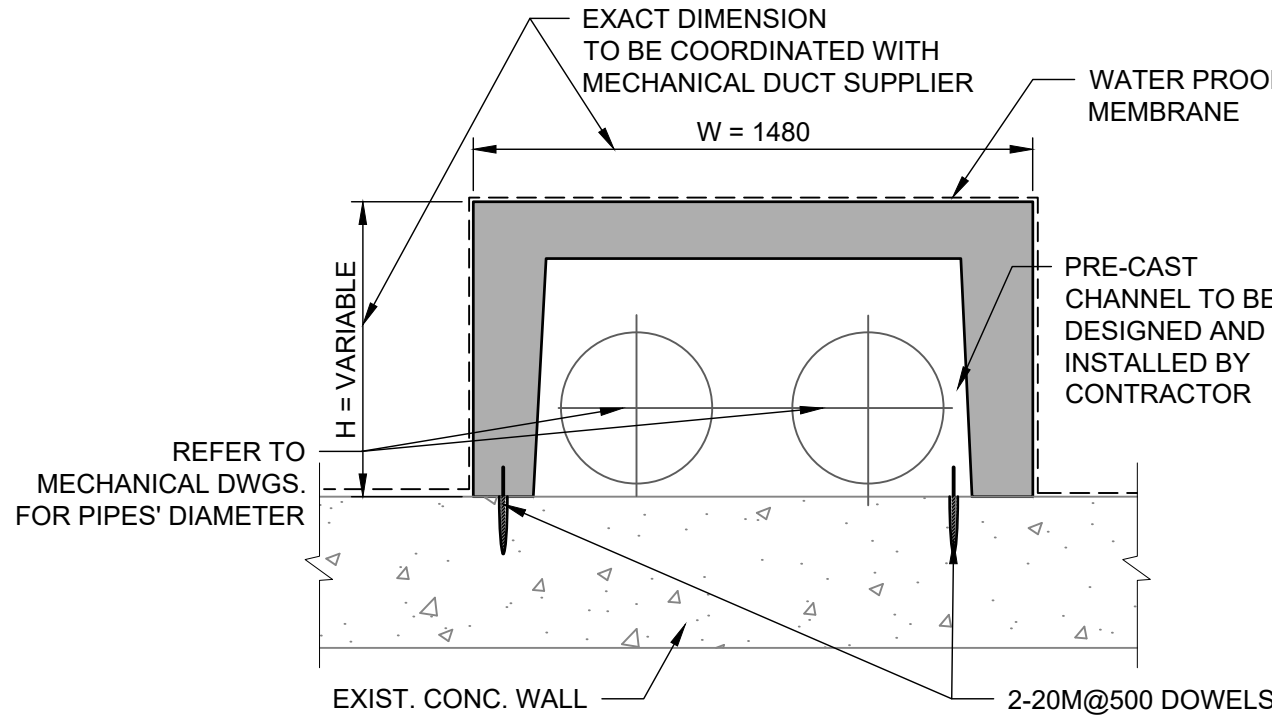

SECTION 4

1:20


4

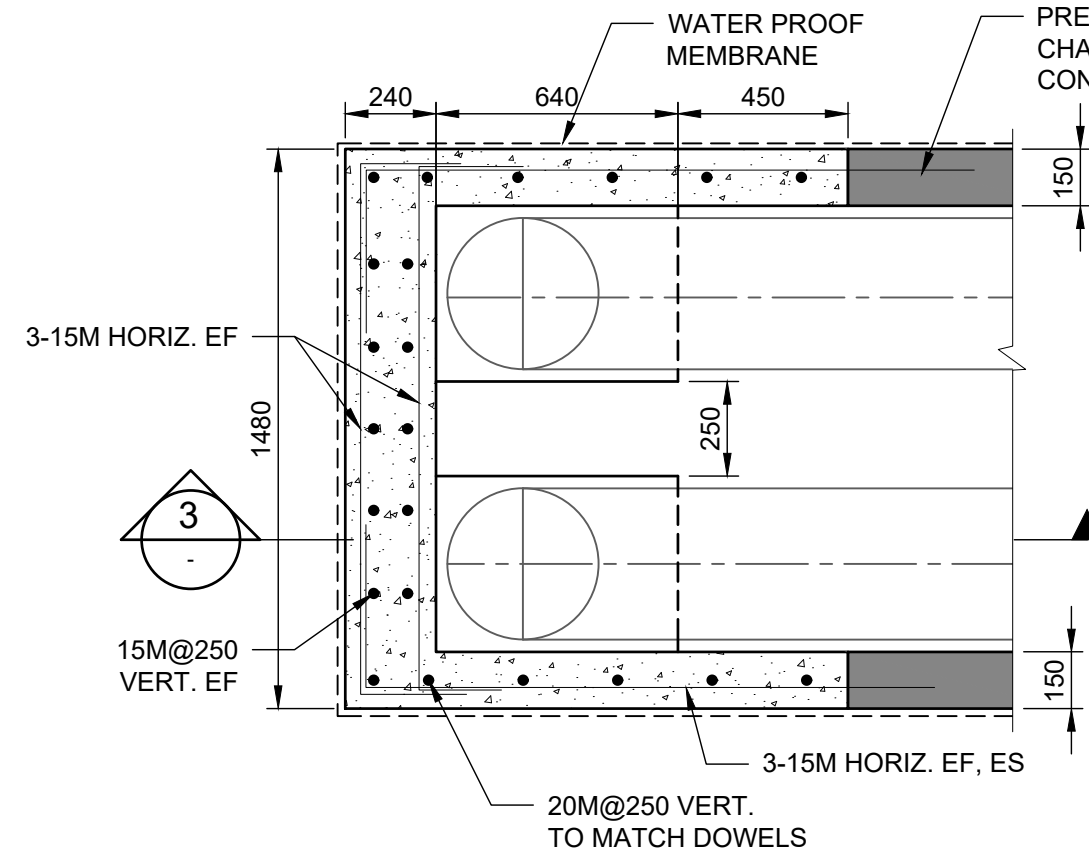

SECTION 2

1:20


2

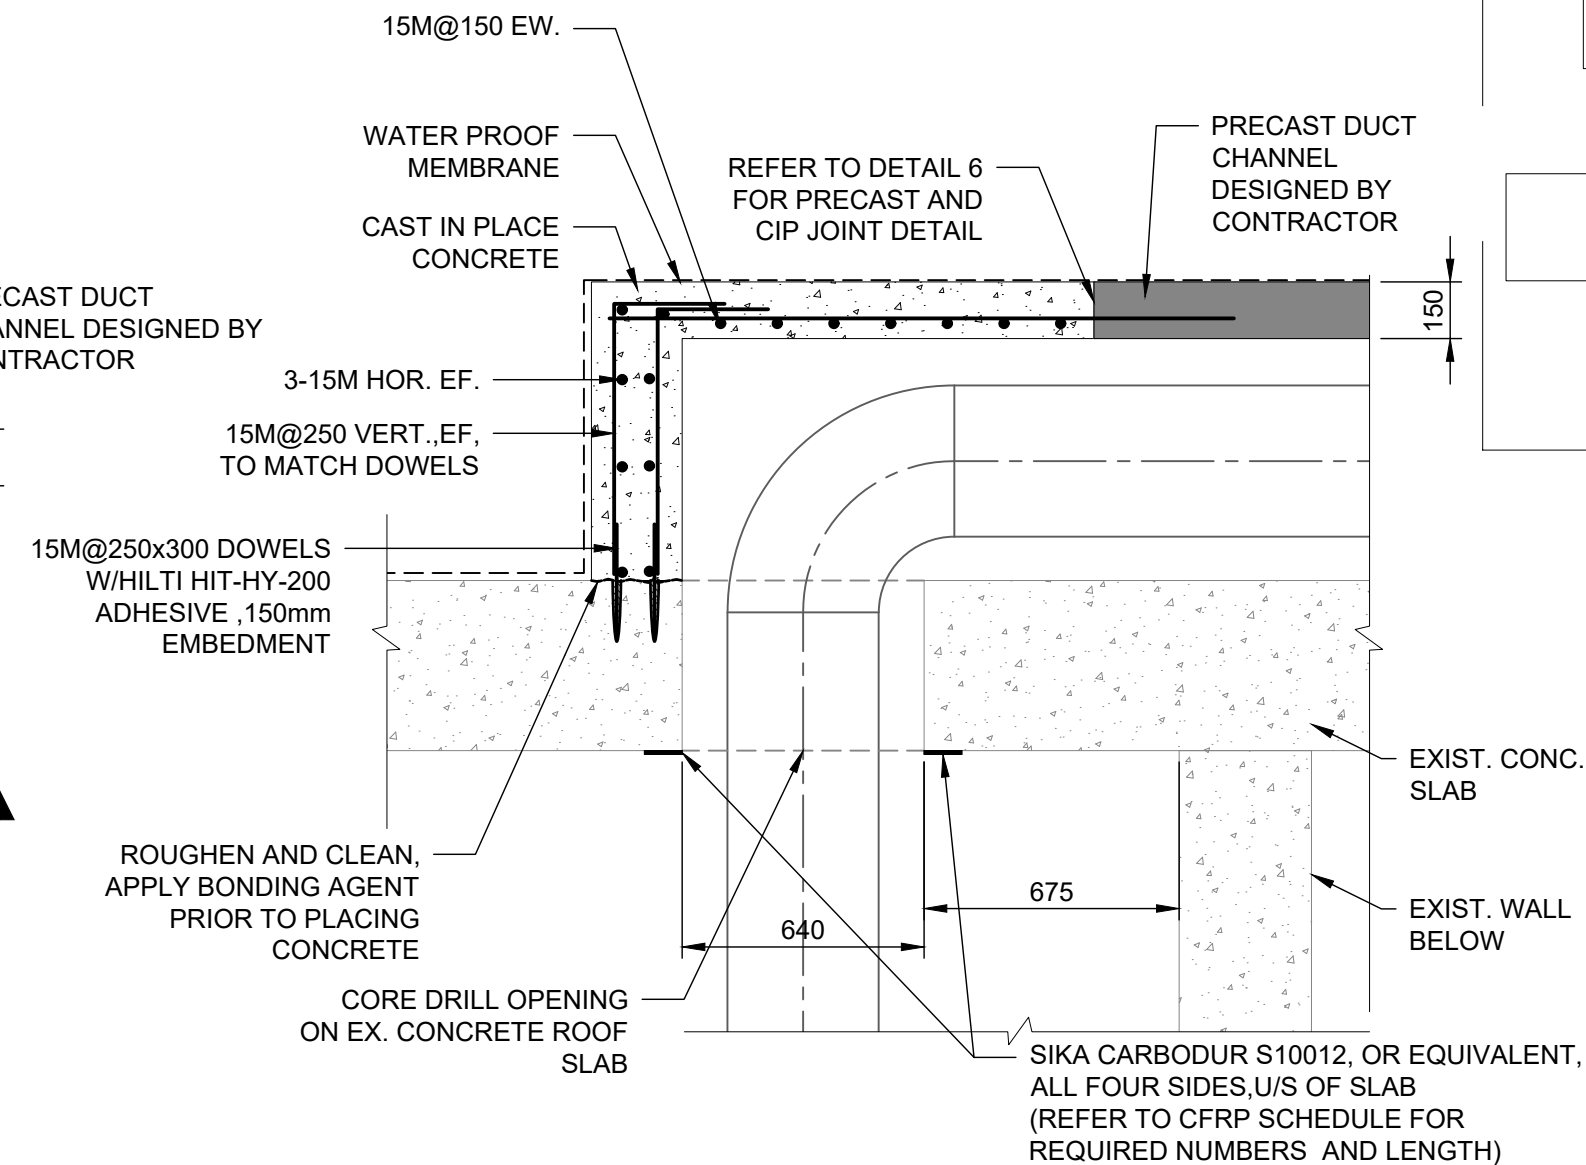

SECTION 3

1:20

3

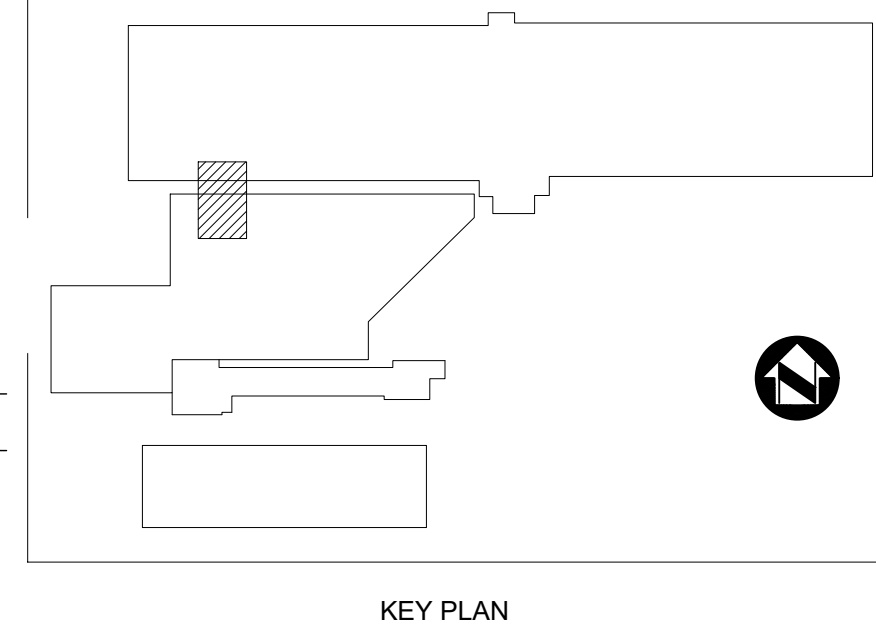

KEY PLAN

FRP SCHEDULE

CFRP REINFORCEMENT REQUIRED U/S OF ROOF SLABS, CORRESPONDING TO THE NUMBER AND SIZE OF THE CUT BOTTOM REBARS

NUMBER OF 25M REBARS CUT	NUMBER OF FRP STRIPS-S10012 REQUIRED ON EACH SIDE (PARALLEL TO CUT REBAR)	NUMBER OF 30M REBARS CUT	NUMBER OF FRP STRIPS-S10012 REQUIRED ON EACH SIDE (PARALLEL TO CUT REBAR)
1	1 STRIP ON EACH SIDE	1	1 STRIP ON EACH SIDE
2	1 STRIP ON EACH SIDE	2	2 STRIP ON EACH SIDE
3	2 STRIP ON EACH SIDE	3	2 STRIP ON EACH SIDE
4	2 STRIP ON EACH SIDE	4	3 STRIP ON EACH SIDE
5	3 STRIP ON EACH SIDE	5	4 STRIP ON EACH SIDE
6	3 STRIP ON EACH SIDE	6	4 STRIP ON EACH SIDE
7	4 STRIP ON EACH SIDE	7	5 STRIP ON EACH SIDE

NOTE:

- CFRP STRIPS SHALL EXTEND 300 MM BEYOND THE OPENING DIMENSIONS ON EACH SIDE.
- CFRP STRIPS HAVE AN OVERLAP OF 50mm.

NOTES:

- ROOF OPENING TO BE COORDINATED WITH EXHAUST STACK VENT MANUFACTURER REQUIREMENTS
- ALL COMPONENTS OF THE EXISTING ROOF ASSEMBLY REQUIRES TO BE SITE VERIFIED. SHOULD ANY DISCREPANCY ARISE, ARCADIS MUST BE INFORMED FOR NECESSARY ADJUSTMENT
- STEEL TOP PLATE DIMENSIONS SHALL BE DETERMINED TO SUIT STACK VENT REQUIREMENTS
- ASSUMED WALL/ROOF SLAB REINFORCEMENT SPACING IS 250mm.
- CONTRACTOR TO SCAN EXISTING CONCRETE SLAB/WALL FOR REINFORCEMENT DATA PRIOR TO ANY PENETRATION
- NO MORE THAN 7 REBARS (TOP & BOTTOM, VERTICAL & HORIZONTAL) ARE TO BE CUT ALONG THE OPENING LENGTH IN EACH WAY/FACE.
- NO MORE THAN 4 REBAR (TOP & BOTTOM, VERTICAL & HORIZONTAL) IS TO BE CUT ALONG THE OPENING WIDTH IN EACH WAY/FACE.
- ARCADIS MUST BE INFORMED FOR FURTHER ASSESSMENT IF ADDITIONAL REBAR CUTTING IS REQUIRED.
- AT LEAST 60 mm COVER SHALL BE KEPT FOR REMAINING REBARS.
- REFER TO MECH. DRAWINGS FOR STEEL PIPE SLEEVE DIAMETER.
- CONTRACTOR SHALL SCAN & MAP THE AREAS TO IDENTIFY THE EXISTING REINFORCEMENT PATTERNS BEFORE DRILLING. IN ORDER TO AVOID DRILLING INTO EXISTING REINFORCEMENT AND ADJUST BRACKETS ACCORDINGLY. THE CONTRACTOR SHALL SUBMIT THEIR FINDINGS TO THE ENGINEER FOR REVIEW.
- PRECAST DUCT CHANNEL SHALL BE DESIGNED BY CONTRACTOR.
- ALL STEEL TO BE HOT DIP GALVANIZED.
- EXISTING ASSEMBLY IS BASED ON AS-BUILT DRAWINGS. SITE VERIFY ALL COMPONENTS.



NO.	DATE	REVISIONS	INITIAL	SIGNED
A	2025-03-18	ISSUED FOR TENDER	C.H.	Issued for Tender



TORONTO WATER

ENGINEERING AND CONSTRUCTION SERVICES





WILLIAM FERNANDES, P. ENG.
DIRECTOR,
WATER TREATMENT AND SUPPLY

SIMON HOPTON, P. ENG.
DIRECTOR
DESIGN & CONSTRUCTION
MAJOR INFRASTRUCTURE

R.C. HARRIS WATER TREATMENT PLANT INSTALLATION OF A STANDBY GENERATOR FOR CRITICAL LOADS




PIPE GALLERY, GENERATOR ROOM & WATER CONDUIT - SECTION ELEVATION & DETAILS


STRUCTURE						
DESIGN:	F.M.	DRAFTING:	S.P.	CHECK:	M.S.	CONTRACT No. 25ECS-MI-03HA
SCALE:	AS INDICATED			DRAWING NUMBER:	2F-2017-08-18	
DATE:	2024-09-30				S011	

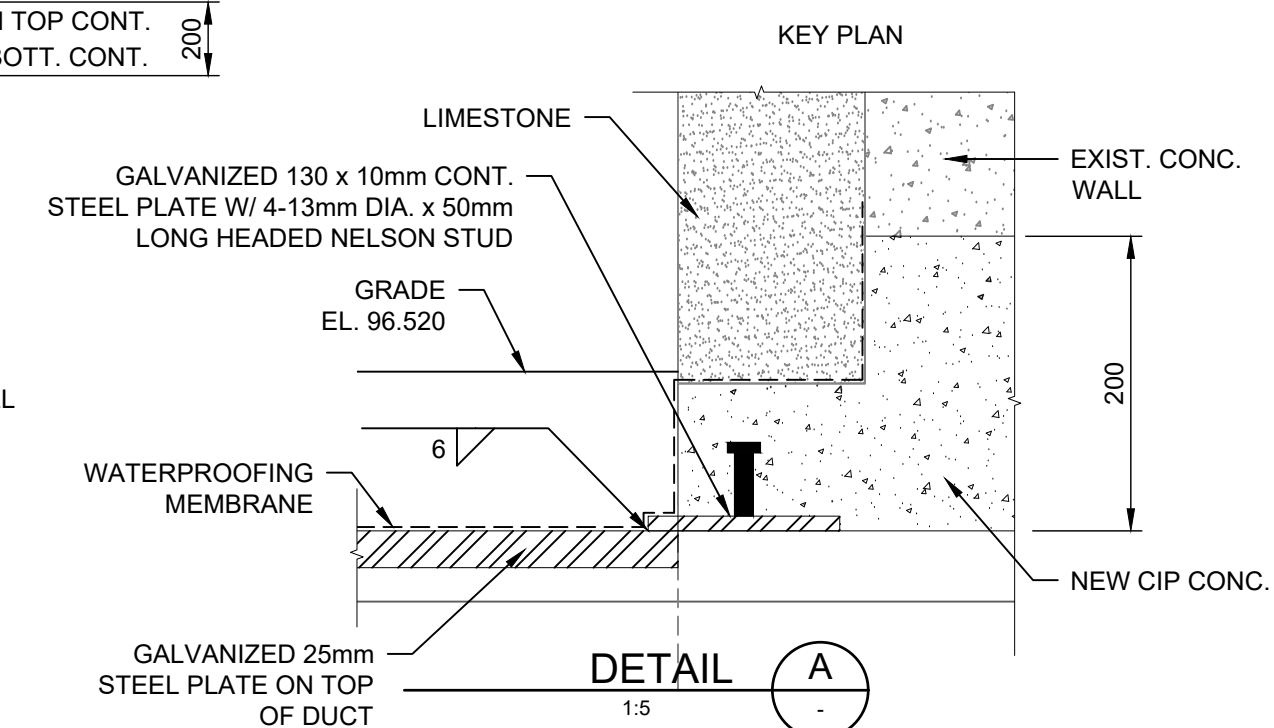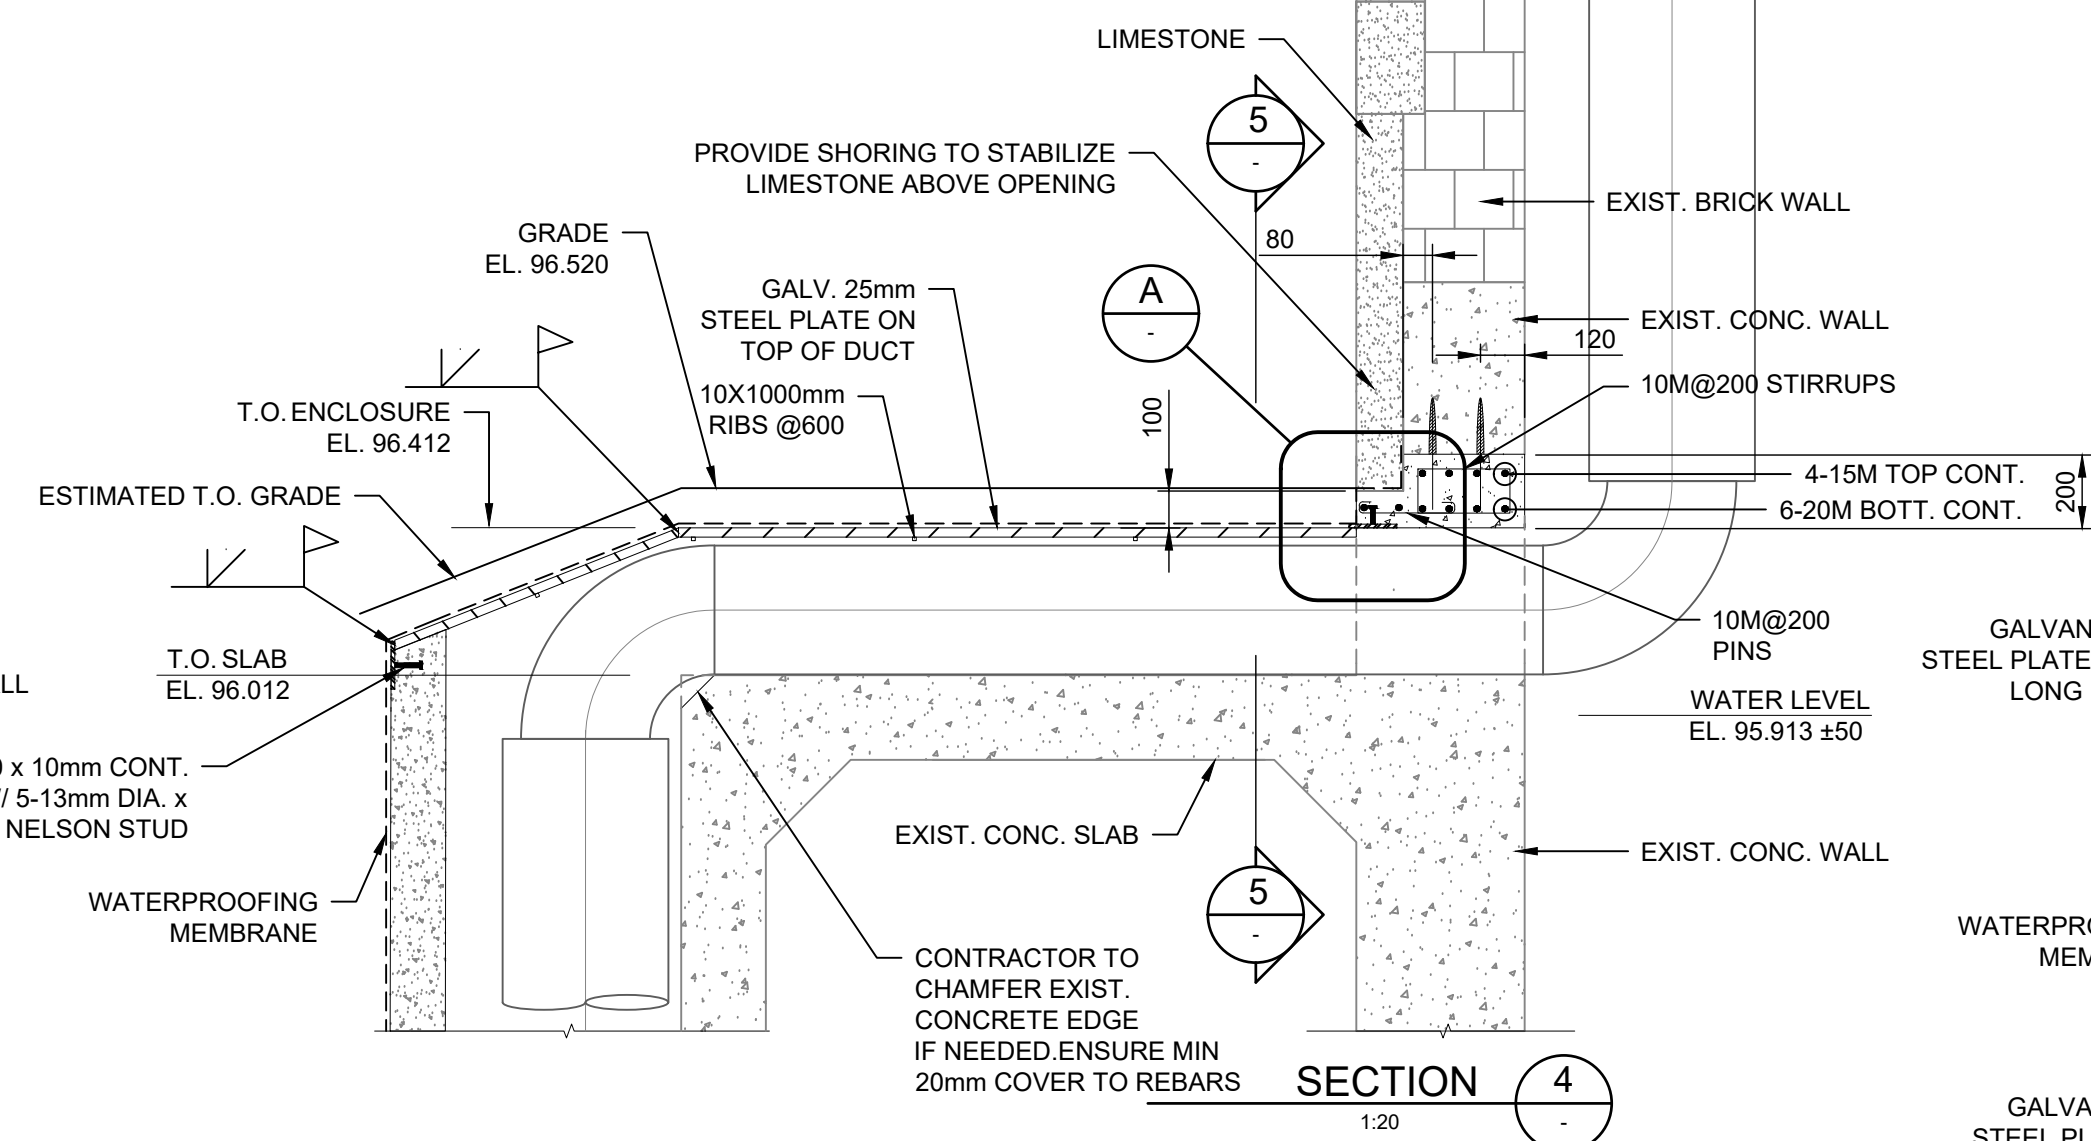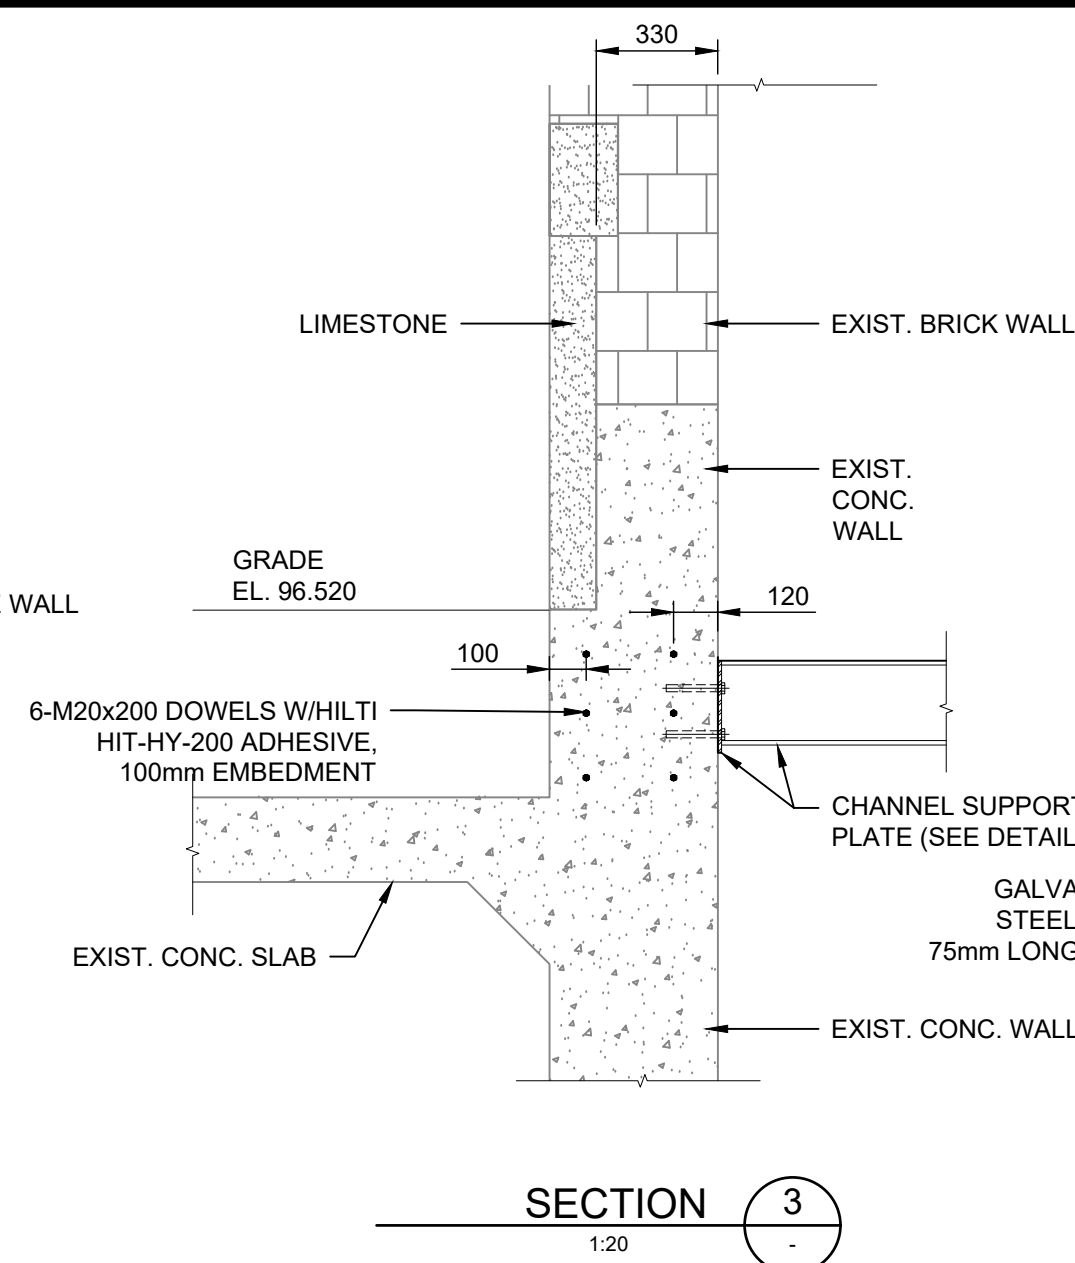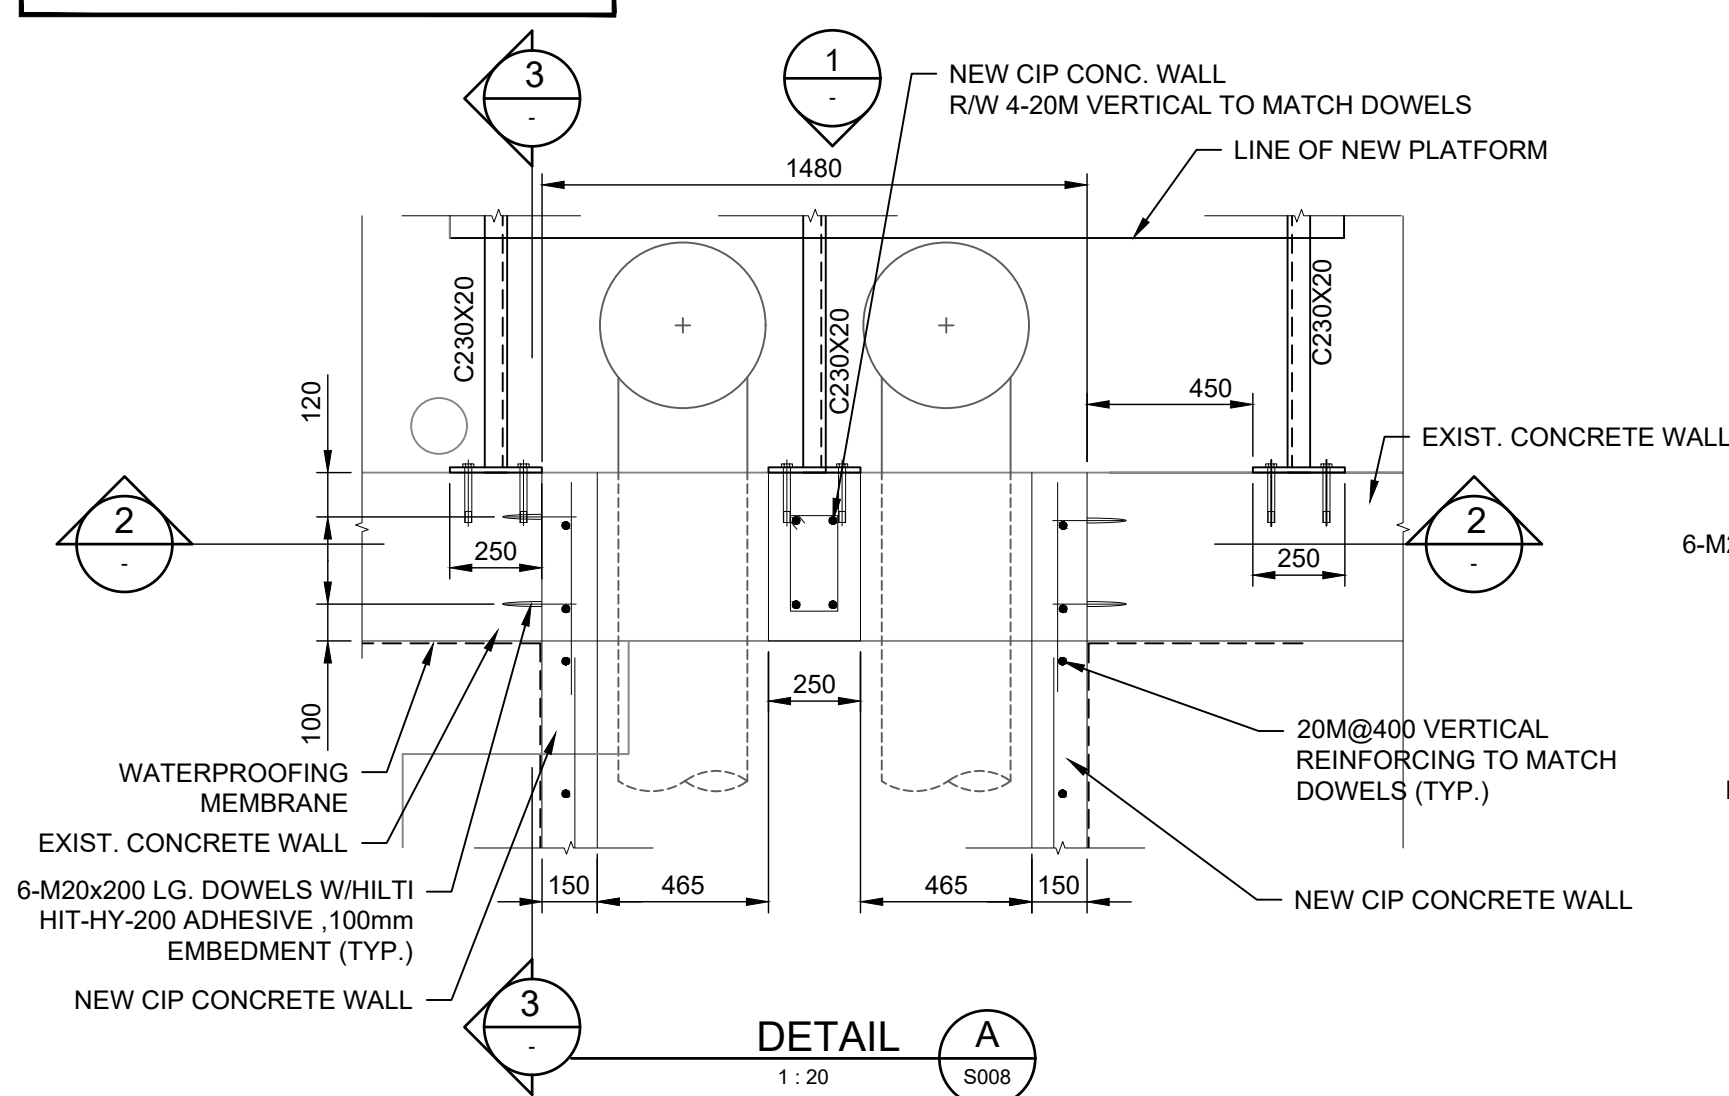

NOTE:

1. TOP OF CONCRETE ENCLOSURE AND PRECAST CHANNEL DUCT NOT TO EXCEED GRADE LEVEL

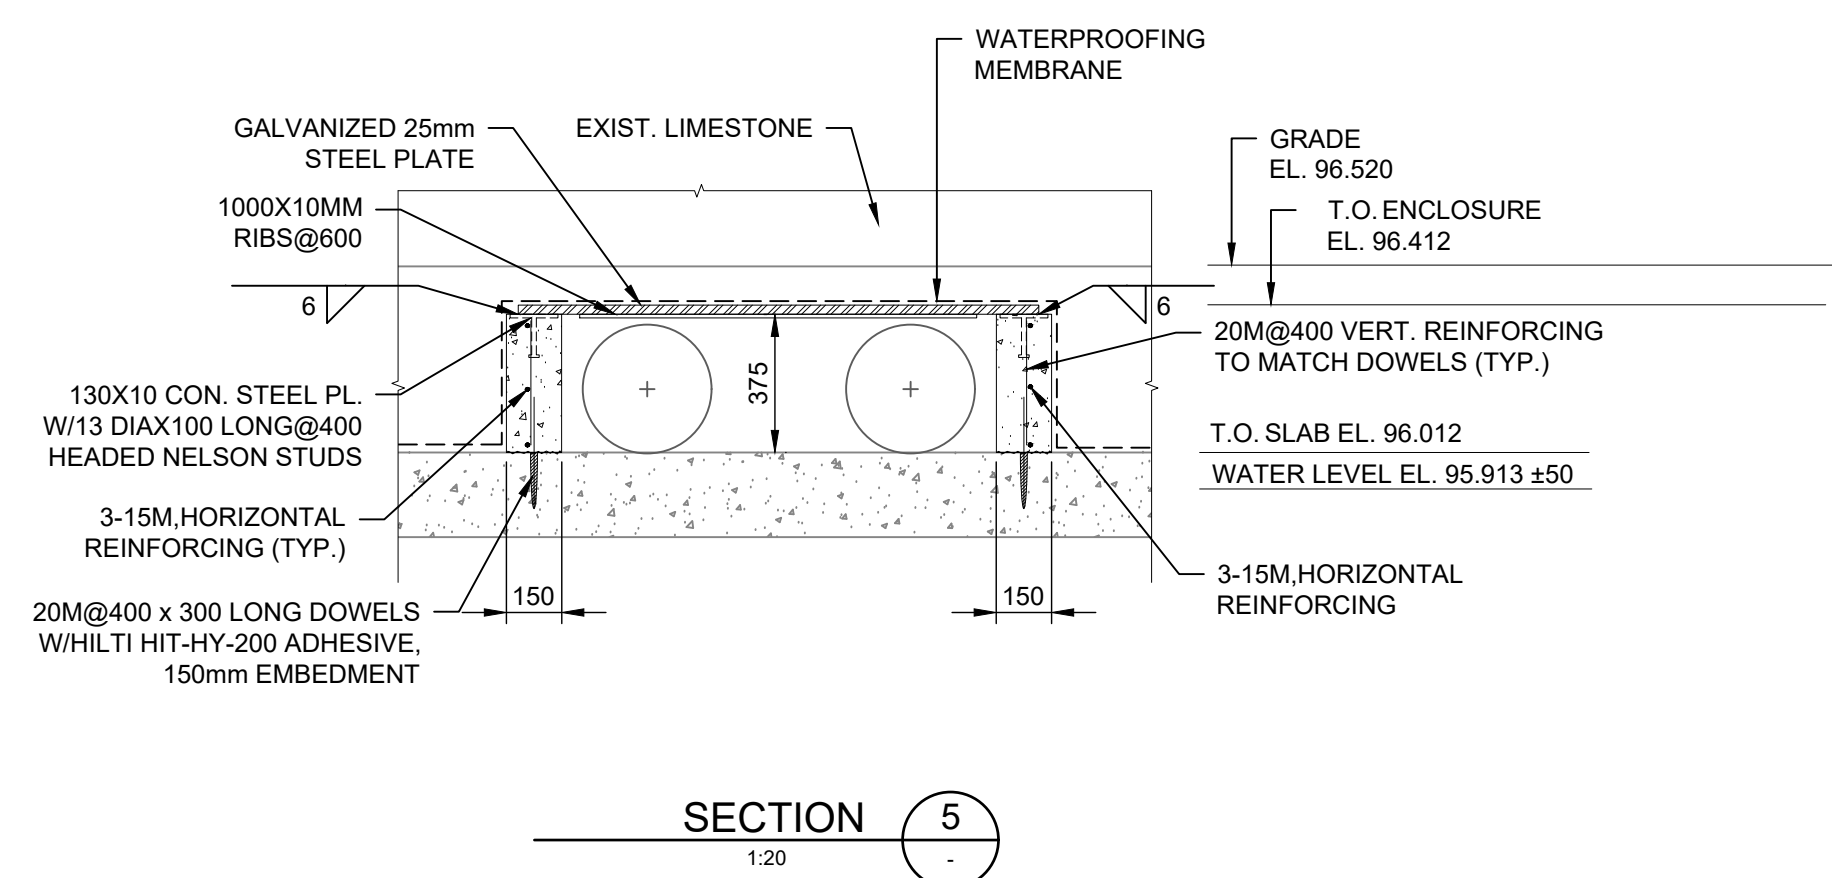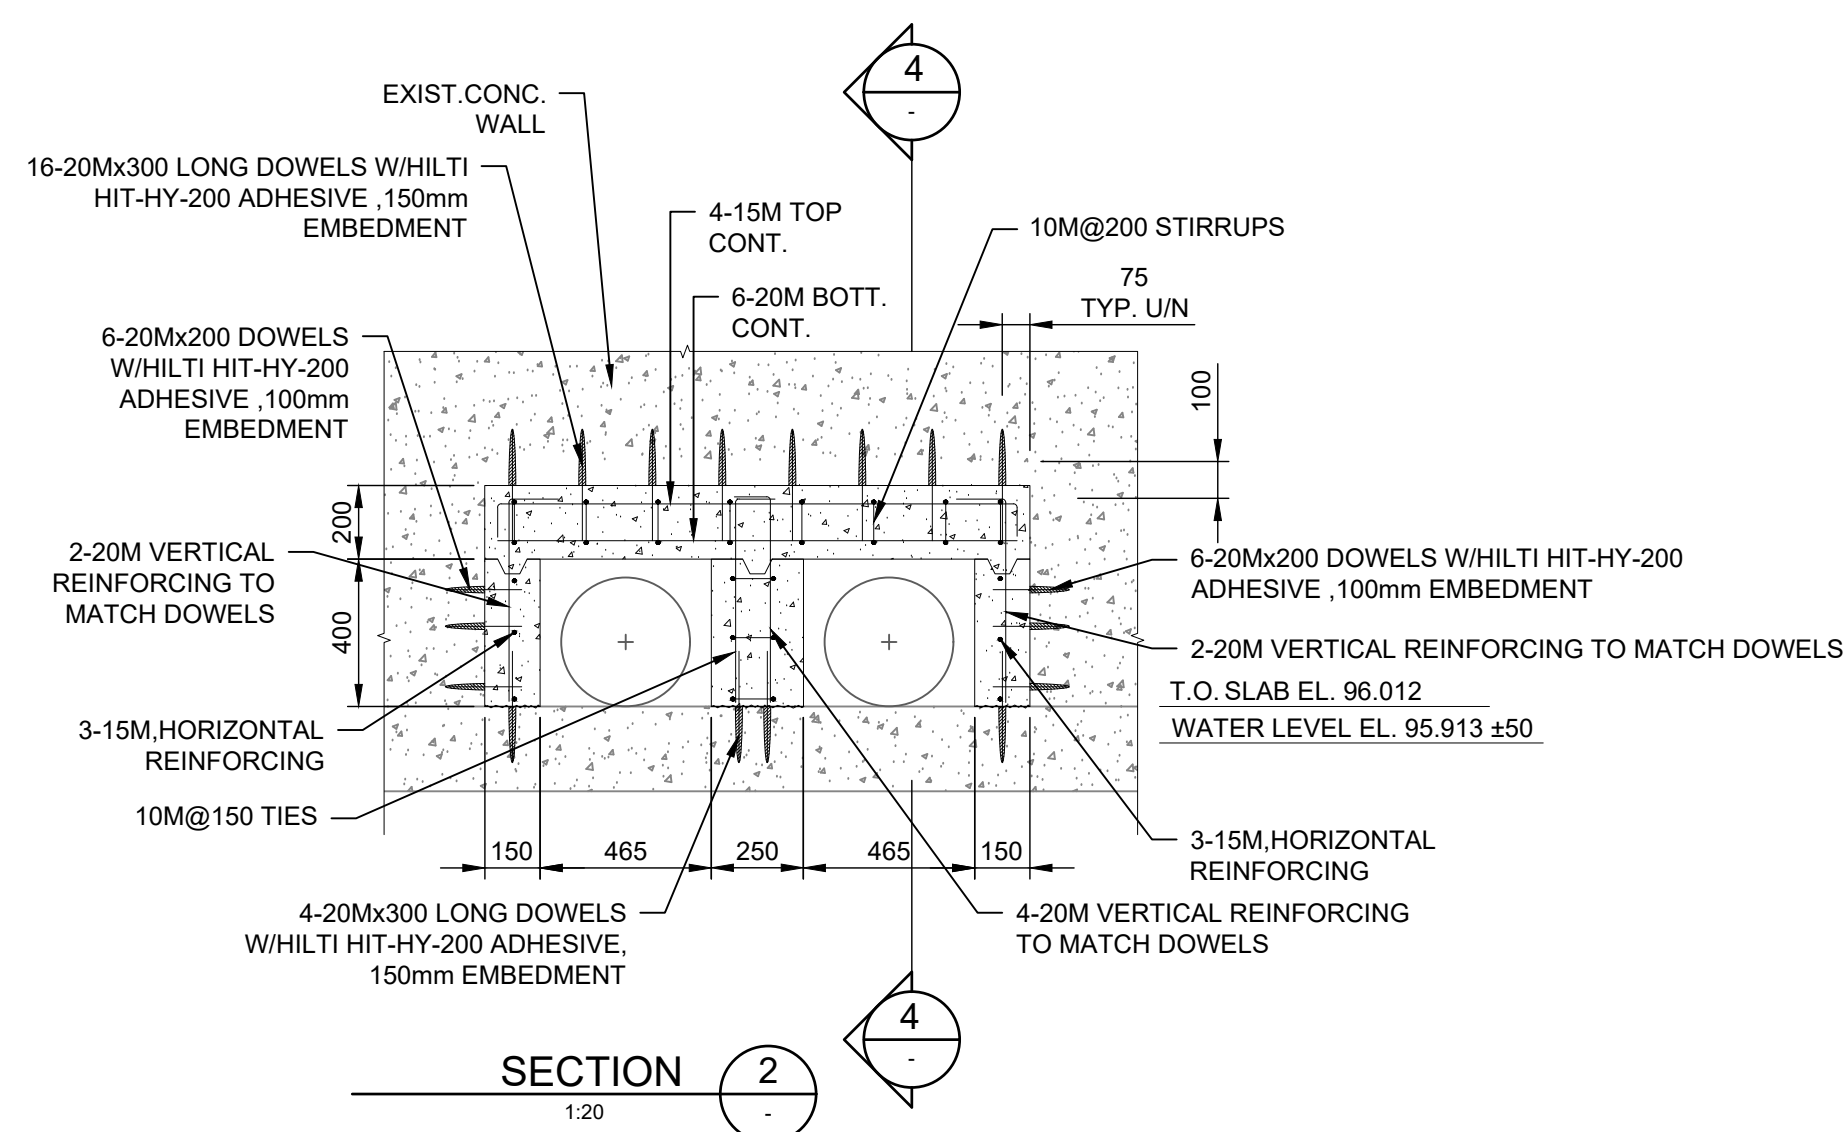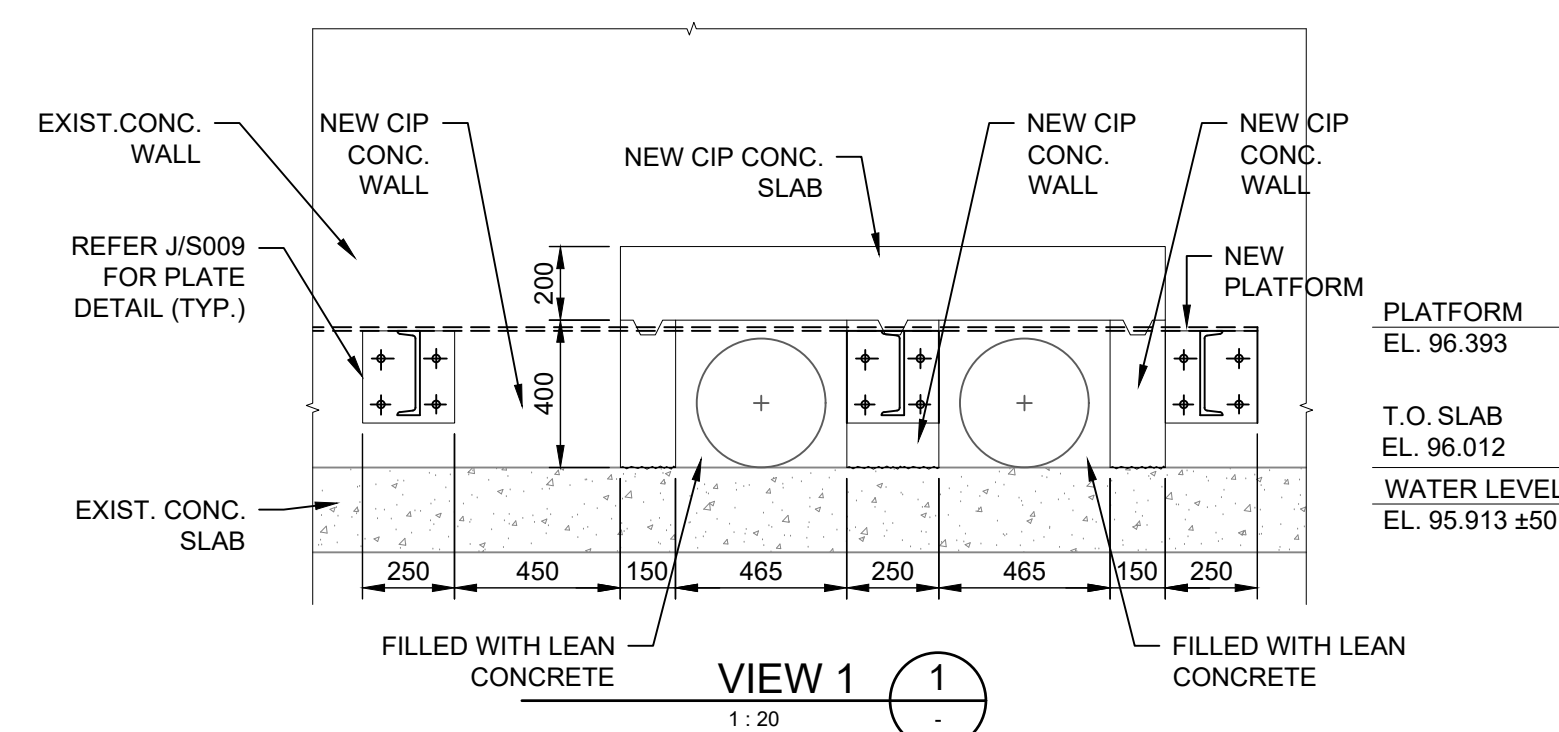

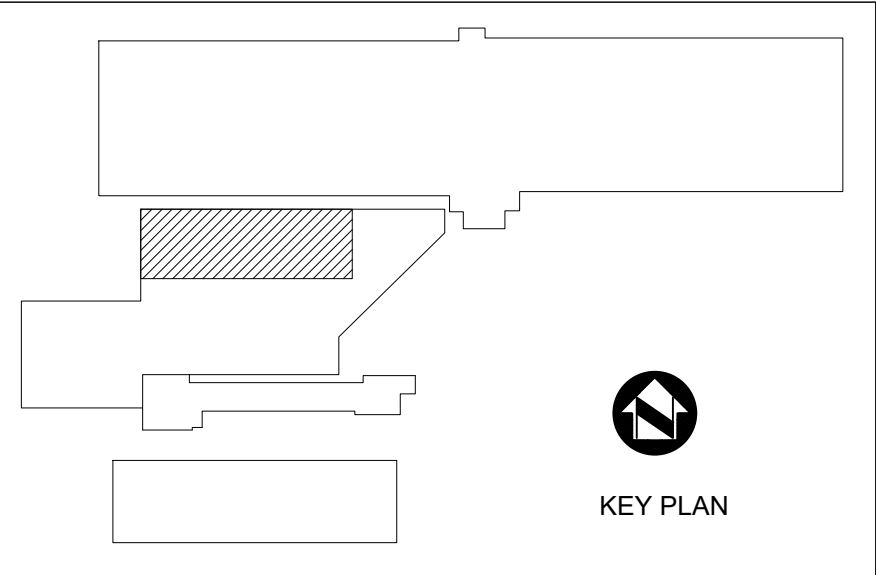

FAN COIL AND FAN SCHEDULE

DAMPER SCHEDULE										
DAMPER FUNCTION	DAMPER TAG	DAMPER ACTUATOR					MANUFACTURER	MODEL	SIZE (mm)	REMARKS
		OPR	CFM	VOLTAGE	PHASE	HZ				
COMBUSTION DAMPER	FLA-ACC-DM-6821	PARALLEL	700	24-240V	1	60	ARROW UNITED	AFDIT-25LT	500x500	FAIL OPEN, POWER CLOSE ACTUATOR C/W END SWITCH

SUMP PUMP SCHEDULE											
MARK NO.	SERVICE	PERFORMANCE						MOTOR			REMARKS
		FLUID	FLOW RATE	HEAD (FT)	MANUFACTURER	MODEL	PRESSURE (PSI)	HP	V/PH/HZ	AMPS	
SP-100	POWER TUNNEL	PUMPED NPW	549.6 L/HR	5	LITTLE GIANT	1-ABS	4.3	1/150	115/1/60	1.1	
SP-101	POWER TUNNEL	PUMPED NPW	30 L/MIN	15	LITTLE GIANT	5-ASP	9.1	1/6	115/1/60	5	INCLUDES SELF-CONTAINED SUMP CONTAINER

HEATER SCHEDULE												
MARK NO.	SERVICE	PERFORMANCE							MOTOR			REMARKS
		POWER	VOLTS	PHASE	AMPS	APPROX AIR TEMP RISE	MANUFACTURER	MODEL	HP	VOLTS	PHASE	
EUH03904	GENERATOR ROOM	5 KW	208	1	27	35°F (19°C)	HEATREX	238 SERIES	1/4	208	1	DISCONNECT CONTROLLED BY REMOTE THERMOSTAT, C/W SWIVEL BRACKET FOR WALL INSTALLATION, C/W PILOT LIGHT, C/W DISCONNECT SWITCH AND MAGNETIC CONTRACTOR
EUH03905	GENERATOR ROOM	5 KW	208	1	27	35°F (19°C)	HEATREX	238 SERIES	1/4	208	1	DISCONNECT CONTROLLED BY REMOTE THERMOSTAT, C/W SWIVEL BRACKET FOR WALL INSTALLATION, C/W PILOT LIGHT, C/W DISCONNECT SWITCH AND MAGNETIC CONTRACTOR

						 TORONTO WATER ENGINEERING AND CONSTRUCTION SERVICES								R.C. HARRIS WATER TREATMENT PLANT INSTALLATION OF A STANDBY GENERATOR FOR CRITICAL LOADS GENERAL LAYOUT						
 100-175 GALAXY BOULEVARD TORONTO, ONTARIO, M9W 0C9 TEL 416 675 1530 FAX 416 675 4620 www.arcadis.com COPYRIGHT: This drawing has been prepared solely for the intended use, thus any reproduction or distribution for any purpose other than authorized by ARCADIS is forbidden. Written dimensions shall have precedence over scaled dimensions. Contractors shall verify and be responsible for all dimensions and conditions on the job, and ARCADIS shall be informed of any variations from the dimensions and conditions shown on the drawing. Shop drawings shall be submitted to IBI Group for general conformance before proceeding with fabrication. ARCADIS Professional Services (Canada) Inc.						MECHANICAL														
						DESIGN:	J.S.	DRAFTING:	J.S.	CHECK:	J.H.	CONTRACT No.	25ECS-MI-03HA							
						SCALE:	1:500				DRAWING NUMBER:	2F-2017-08-20		M001						
						DATE:	2024-09-30													


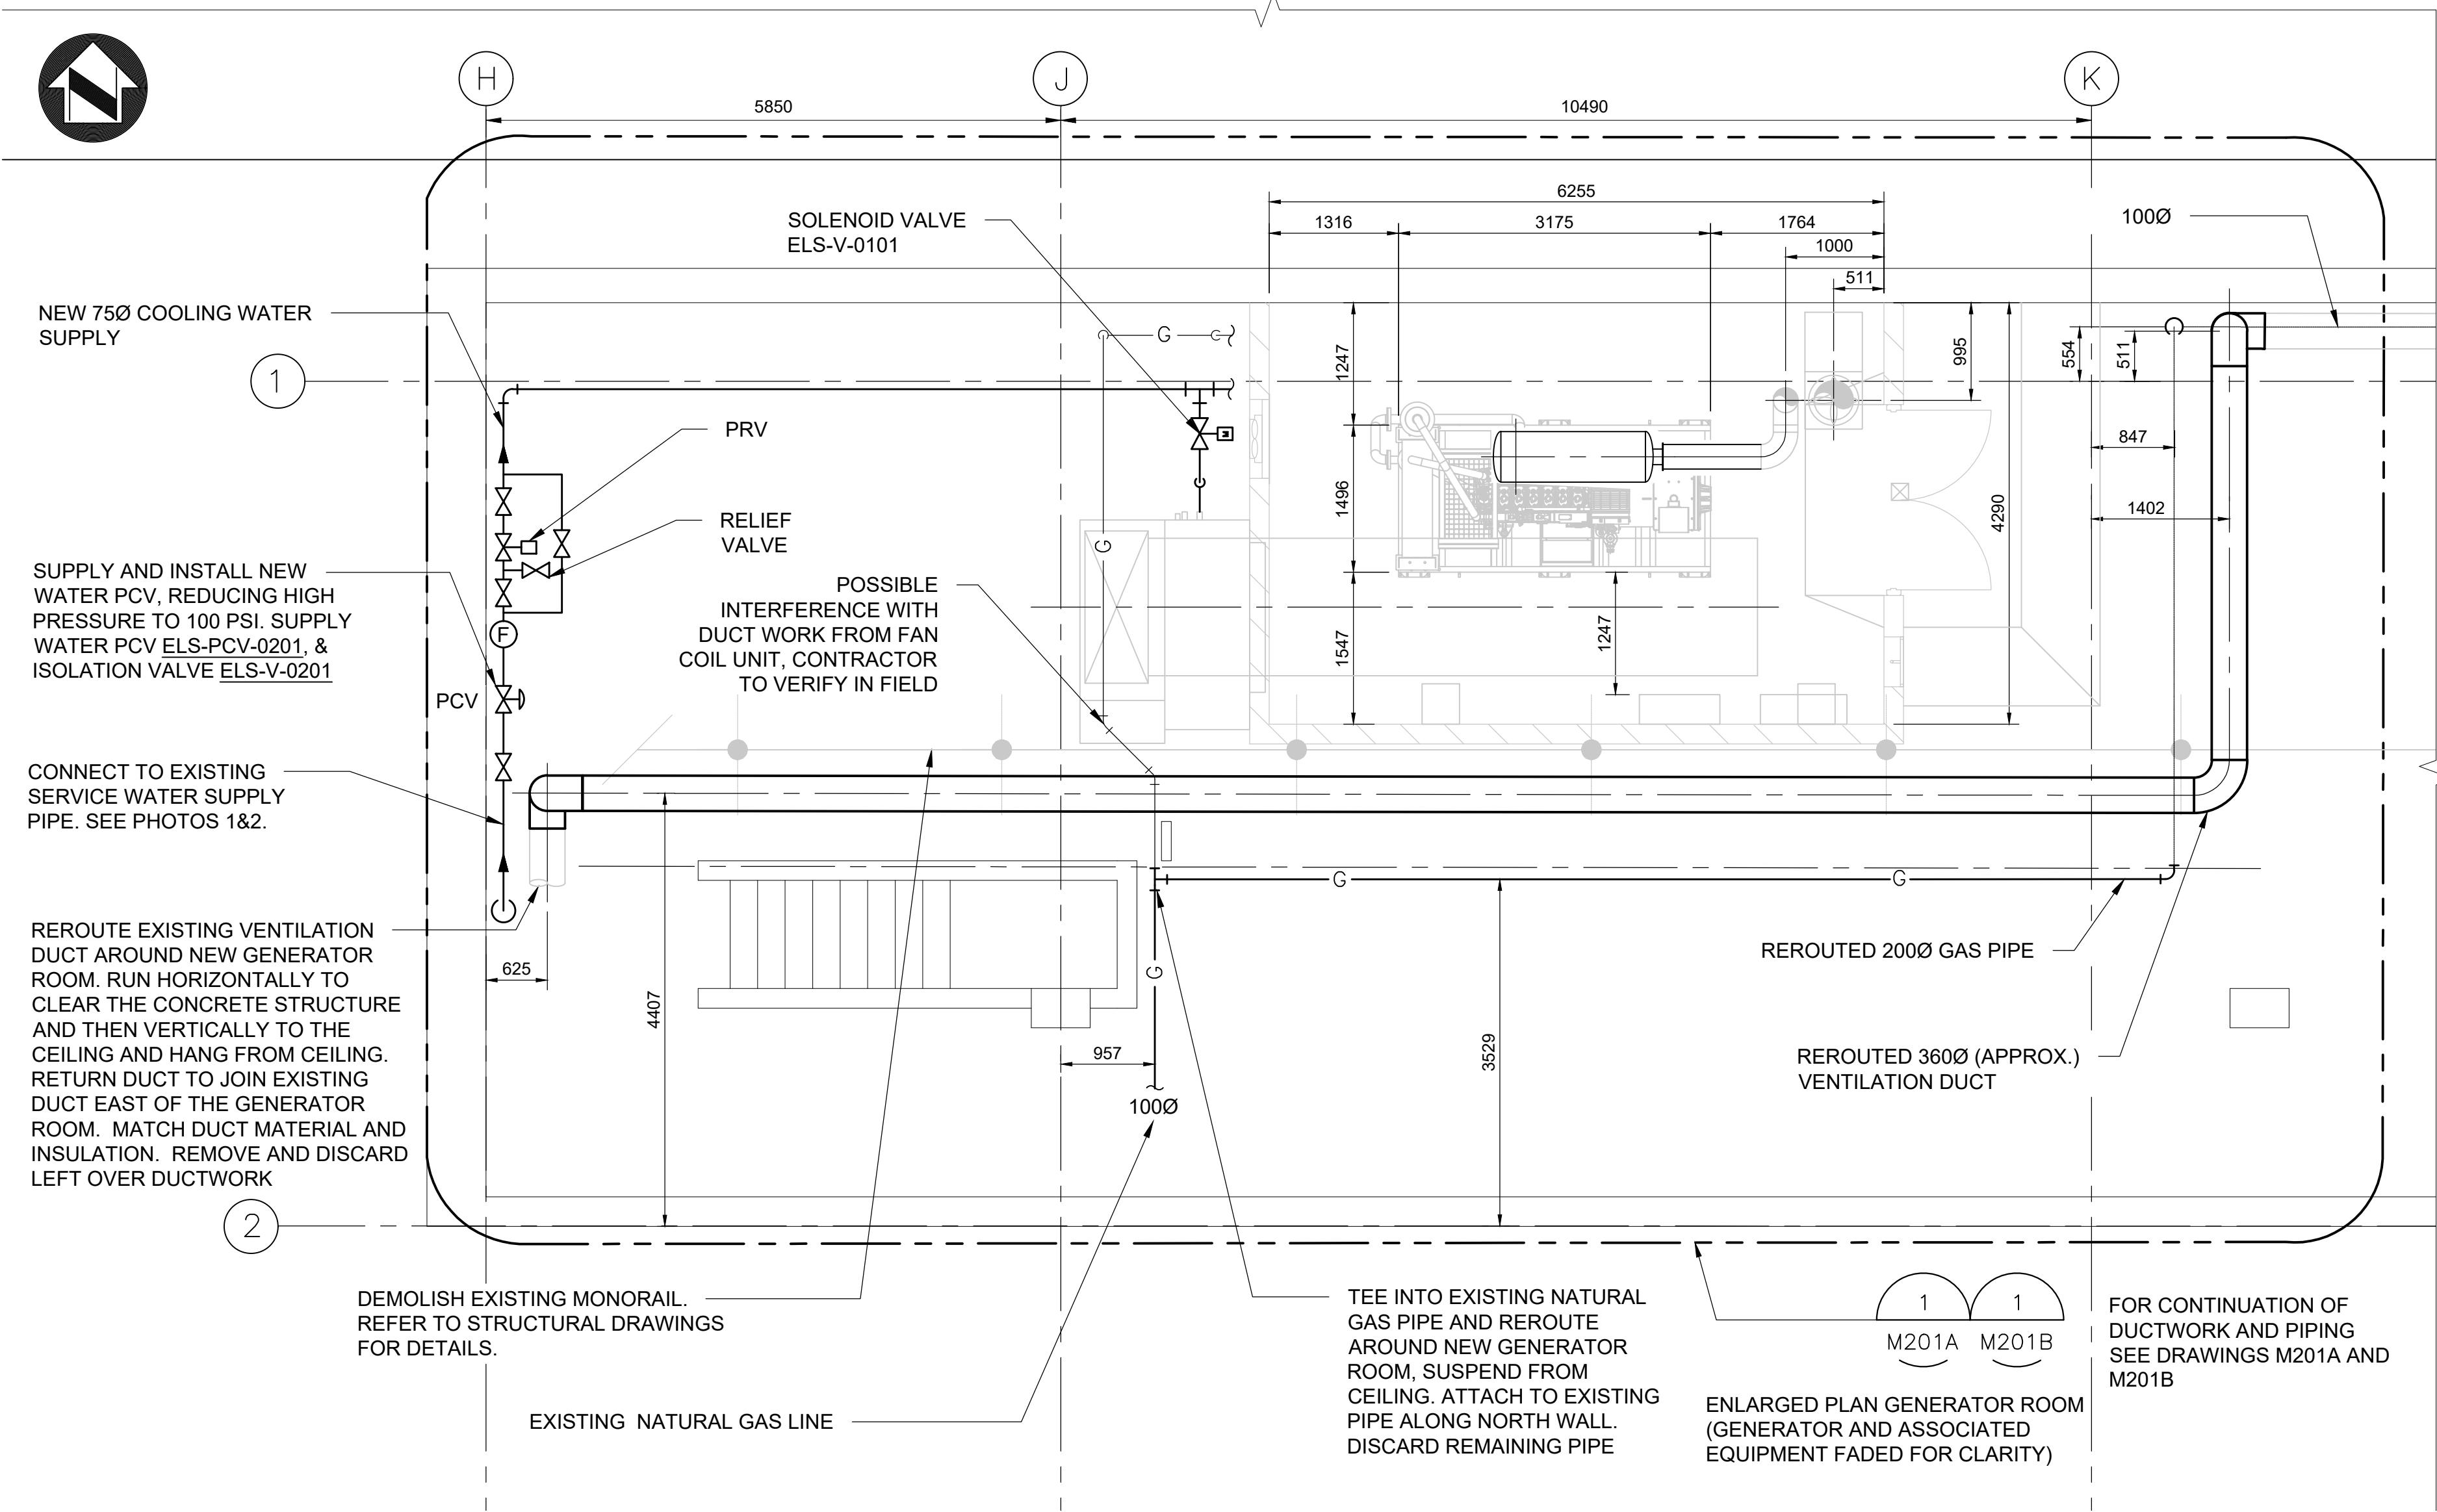


PHOTO 1 - SW CORNER OF PIPE GALLERY
N.T.S.




PHOTO 2 - SW CORNER - DETAIL
N.T.S.

- NOTE:
1. NATURAL GAS MODIFICATION TO BE DONE IN 2 DAYS DURING SPRING, SUMMER OR FALL OR 8 HOURS DURING THE WINTER AND COORDINATED WITH PLANT OPERATIONS.
 2. PROVIDE VENTLESS PCV FOR GAS SUPPLY TO GENERATOR.
 3. GAS PIPE TO BE PURGED OF AIR AFTER MODIFICATION.
 4. COOLING WATER SUPPLY CAPACITY OF MIN. 66 GPM AT 100 PSI.
 5. ALL DIMENSIONS PROVIDED SHALL BE FIELD VERIFIED BY CONTRACTOR PRIOR TO CARRYING OUT ANY WORK.

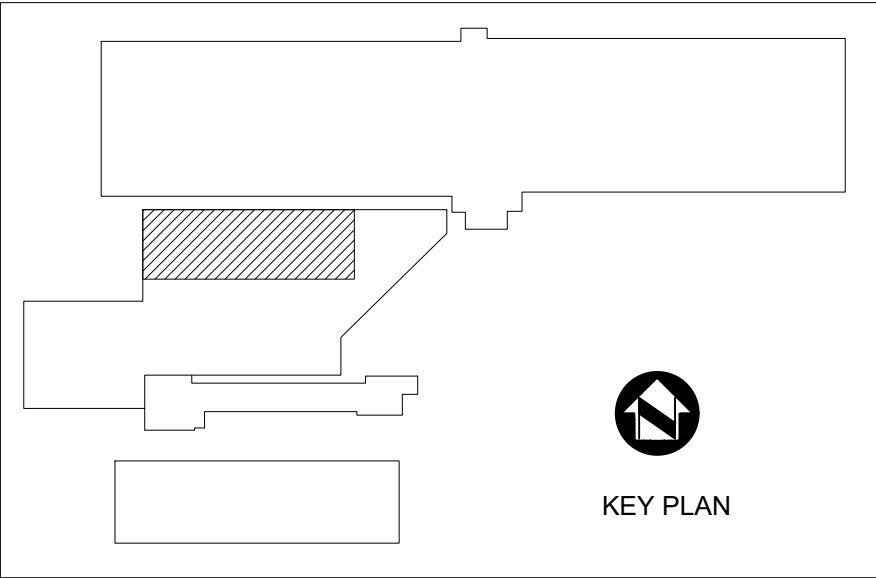

PIPING GALLERY RENOVATIONS AND DEMOLITION -
PLAN VIEW

1:50

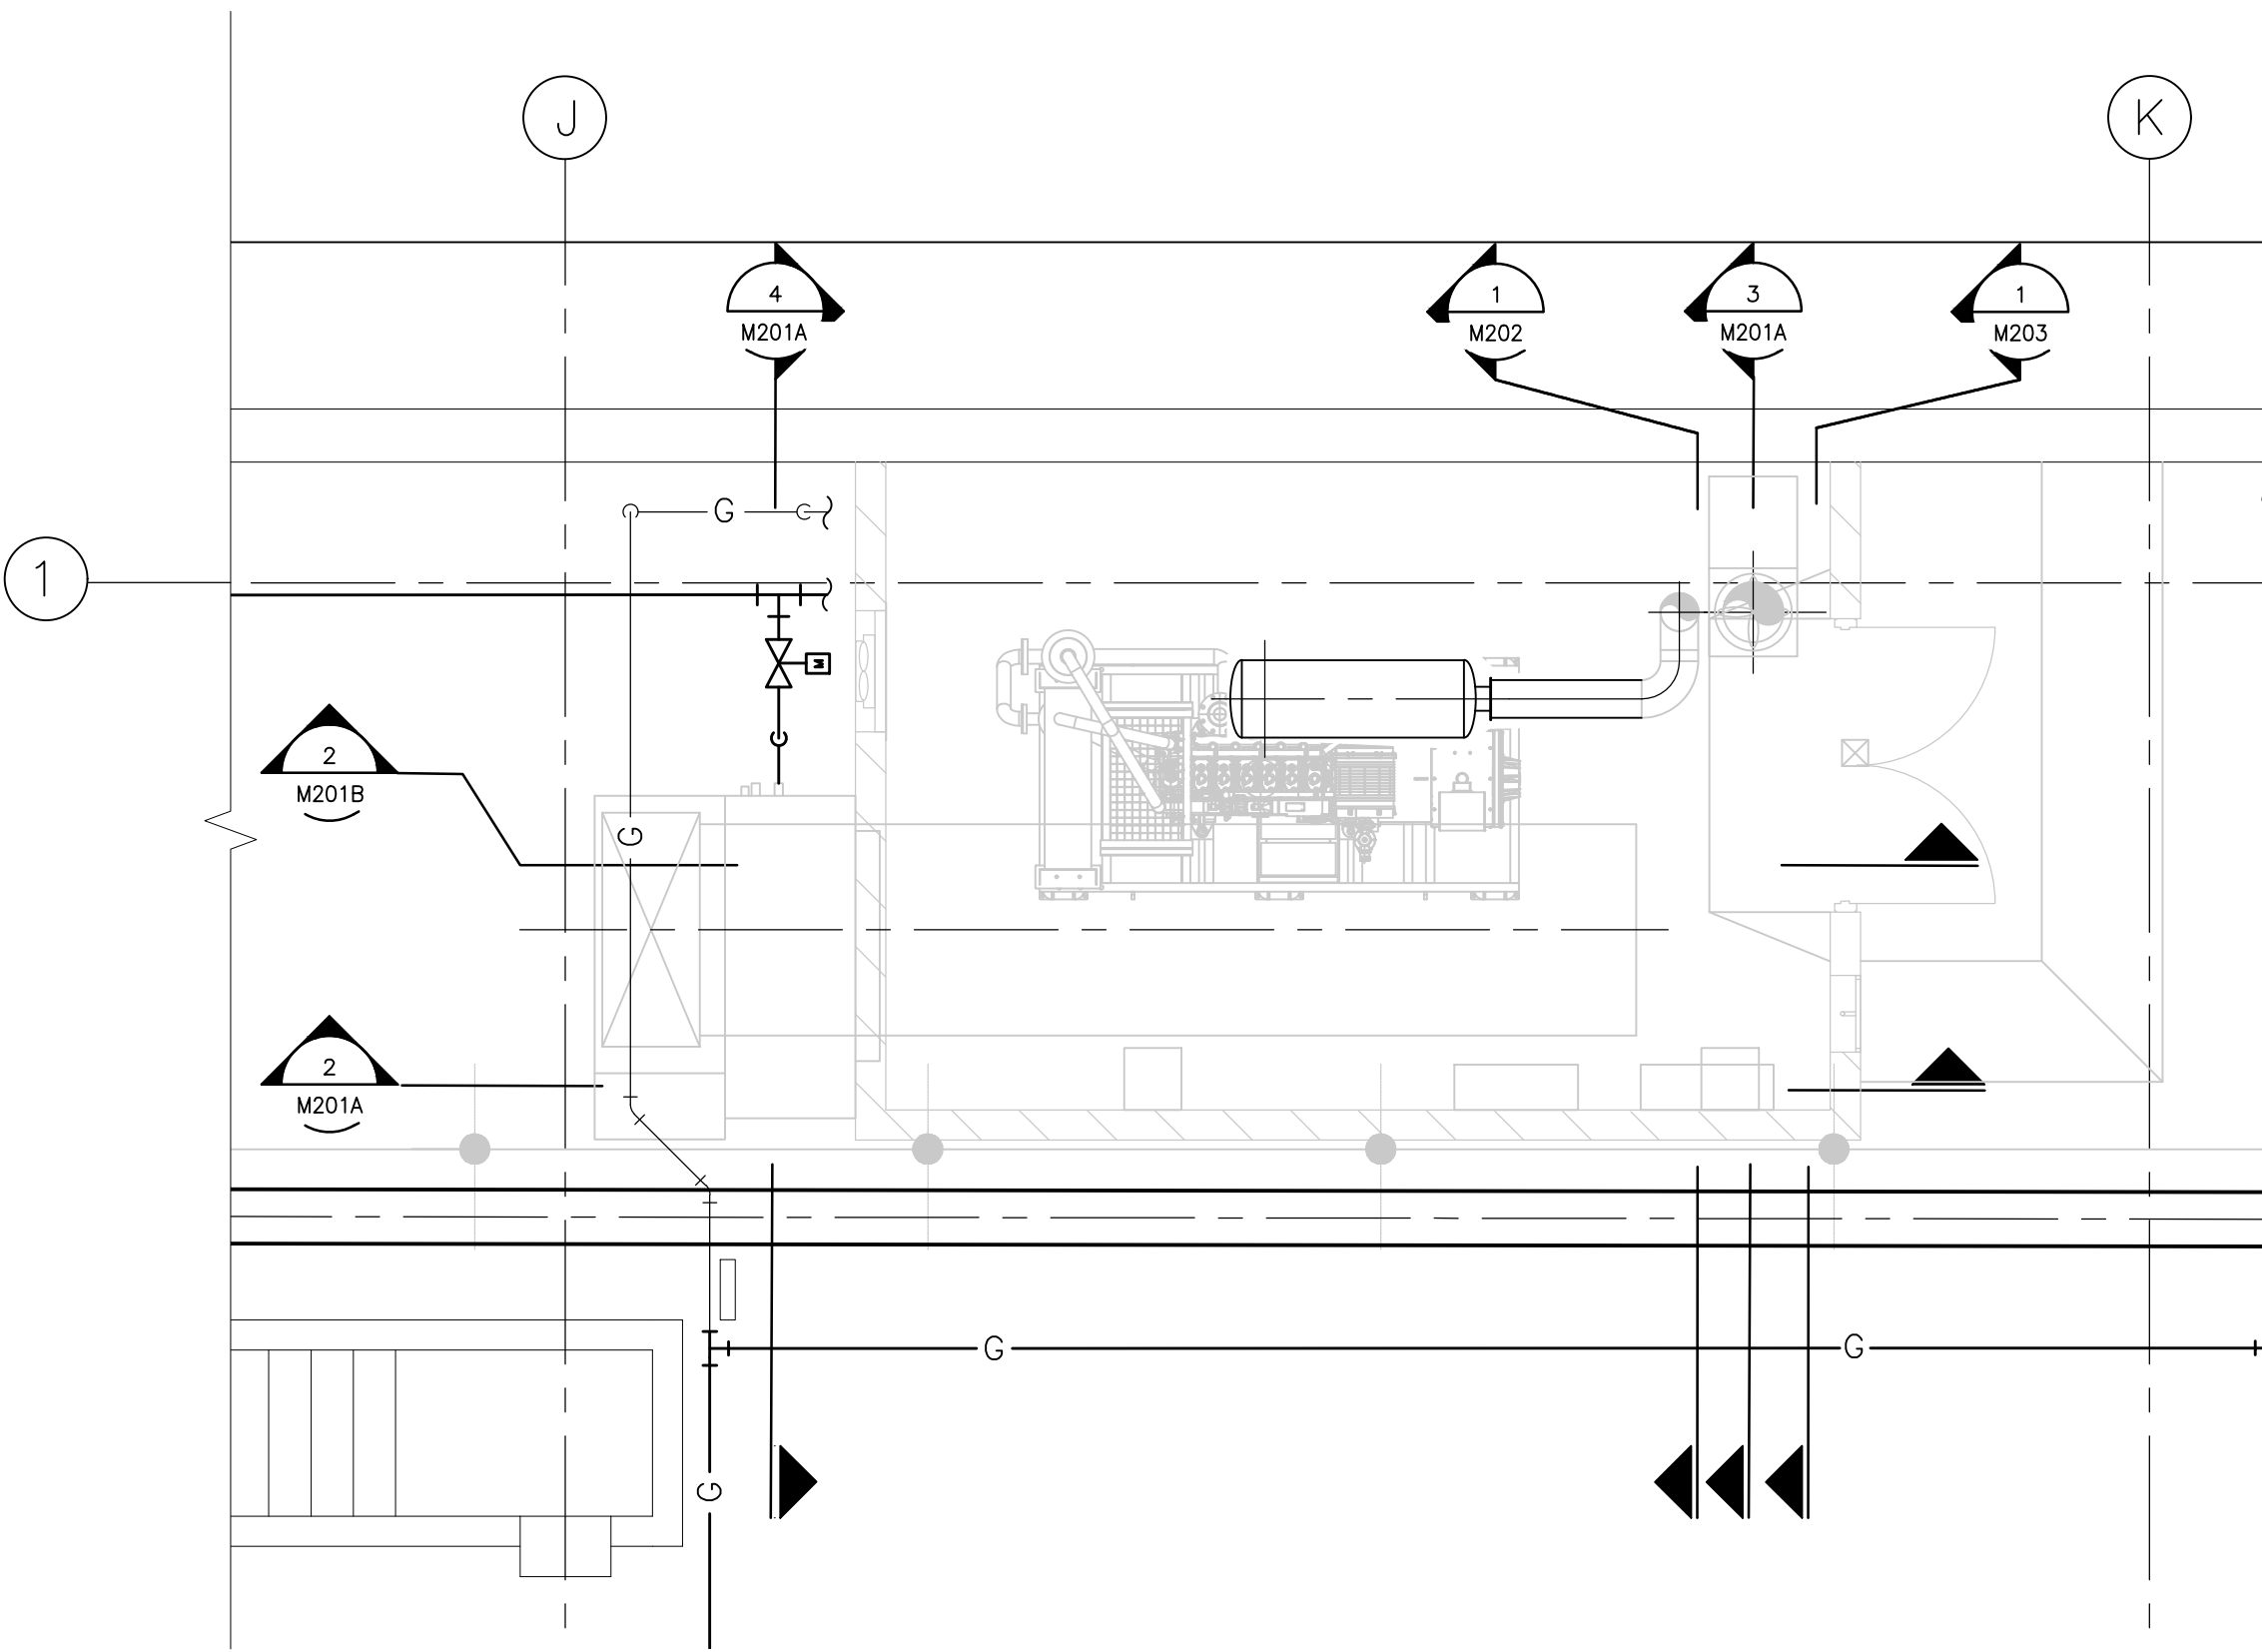


GENERATOR ROOM SECTIONS


1:50

Drawing: \\ARCADIS-LL\LOCAL\DFS\AIBL_P\TORONTO\1616-0273 TOR_HARRISWP-STANDBYGENERATOR\500_CAD\401-CAD\1-SS OR BU\SHEET\5 MECH\2F-2017-08-21_M201.DWG
Layout: 03/24/2025 03:25:34 PM
Date: 03/24/2025 Time: 03:25:34 PM

								TORONTO WATER		R.C. HARRIS WATER TREATMENT PLANT INSTALLATION OF A STANDBY GENERATOR FOR CRITICAL LOADS PIPE GALLERY RENOVATIONS AND DEMOLITION										
								ENGINEERING AND CONSTRUCTION SERVICES												
								WILLIAM FERNANDES, P. ENG. DIRECTOR, WATER TREATMENT AND SUPPLY		SIMON HOPTON, P. ENG. DIRECTOR DESIGN & CONSTRUCTION MAJOR INFRASTRUCTURE										
100-175 GALAXY BOULEVARD TORONTO, ONTARIO, M9W 0C9 TEL 416 679 1930 FAX 416 675 4620 www.arcadis.com		COPYRIGHT: This drawing has been prepared solely for the intended use, thus any reproduction or distribution for any purpose other than authorized by ARCADIS is forbidden. Written dimensions shall have precedence over scaled dimensions. Contractors shall verify and be responsible for all dimensions and conditions on the job, and ARCADIS shall be informed of any variations from the dimensions and conditions shown on the drawing. Shop drawings shall be submitted to IRI Group for general conformance before proceeding with fabrication.										MECHANICAL								
		A	2025-03-18	ISSUED FOR TENDER		K.C						DESIGN:	J.S.	DRAFTING:	J.S.	CHECK:	J.H.	CONTRACT No.	25ECS-MI-03HA	
		NO.	DATE	REVISIONS		INITIAL		SIGNED												
												SCALE:		1:50		DRAWING NUMBER:		2F-2017-08-21		
												DATE:		2024-09-30				M201		

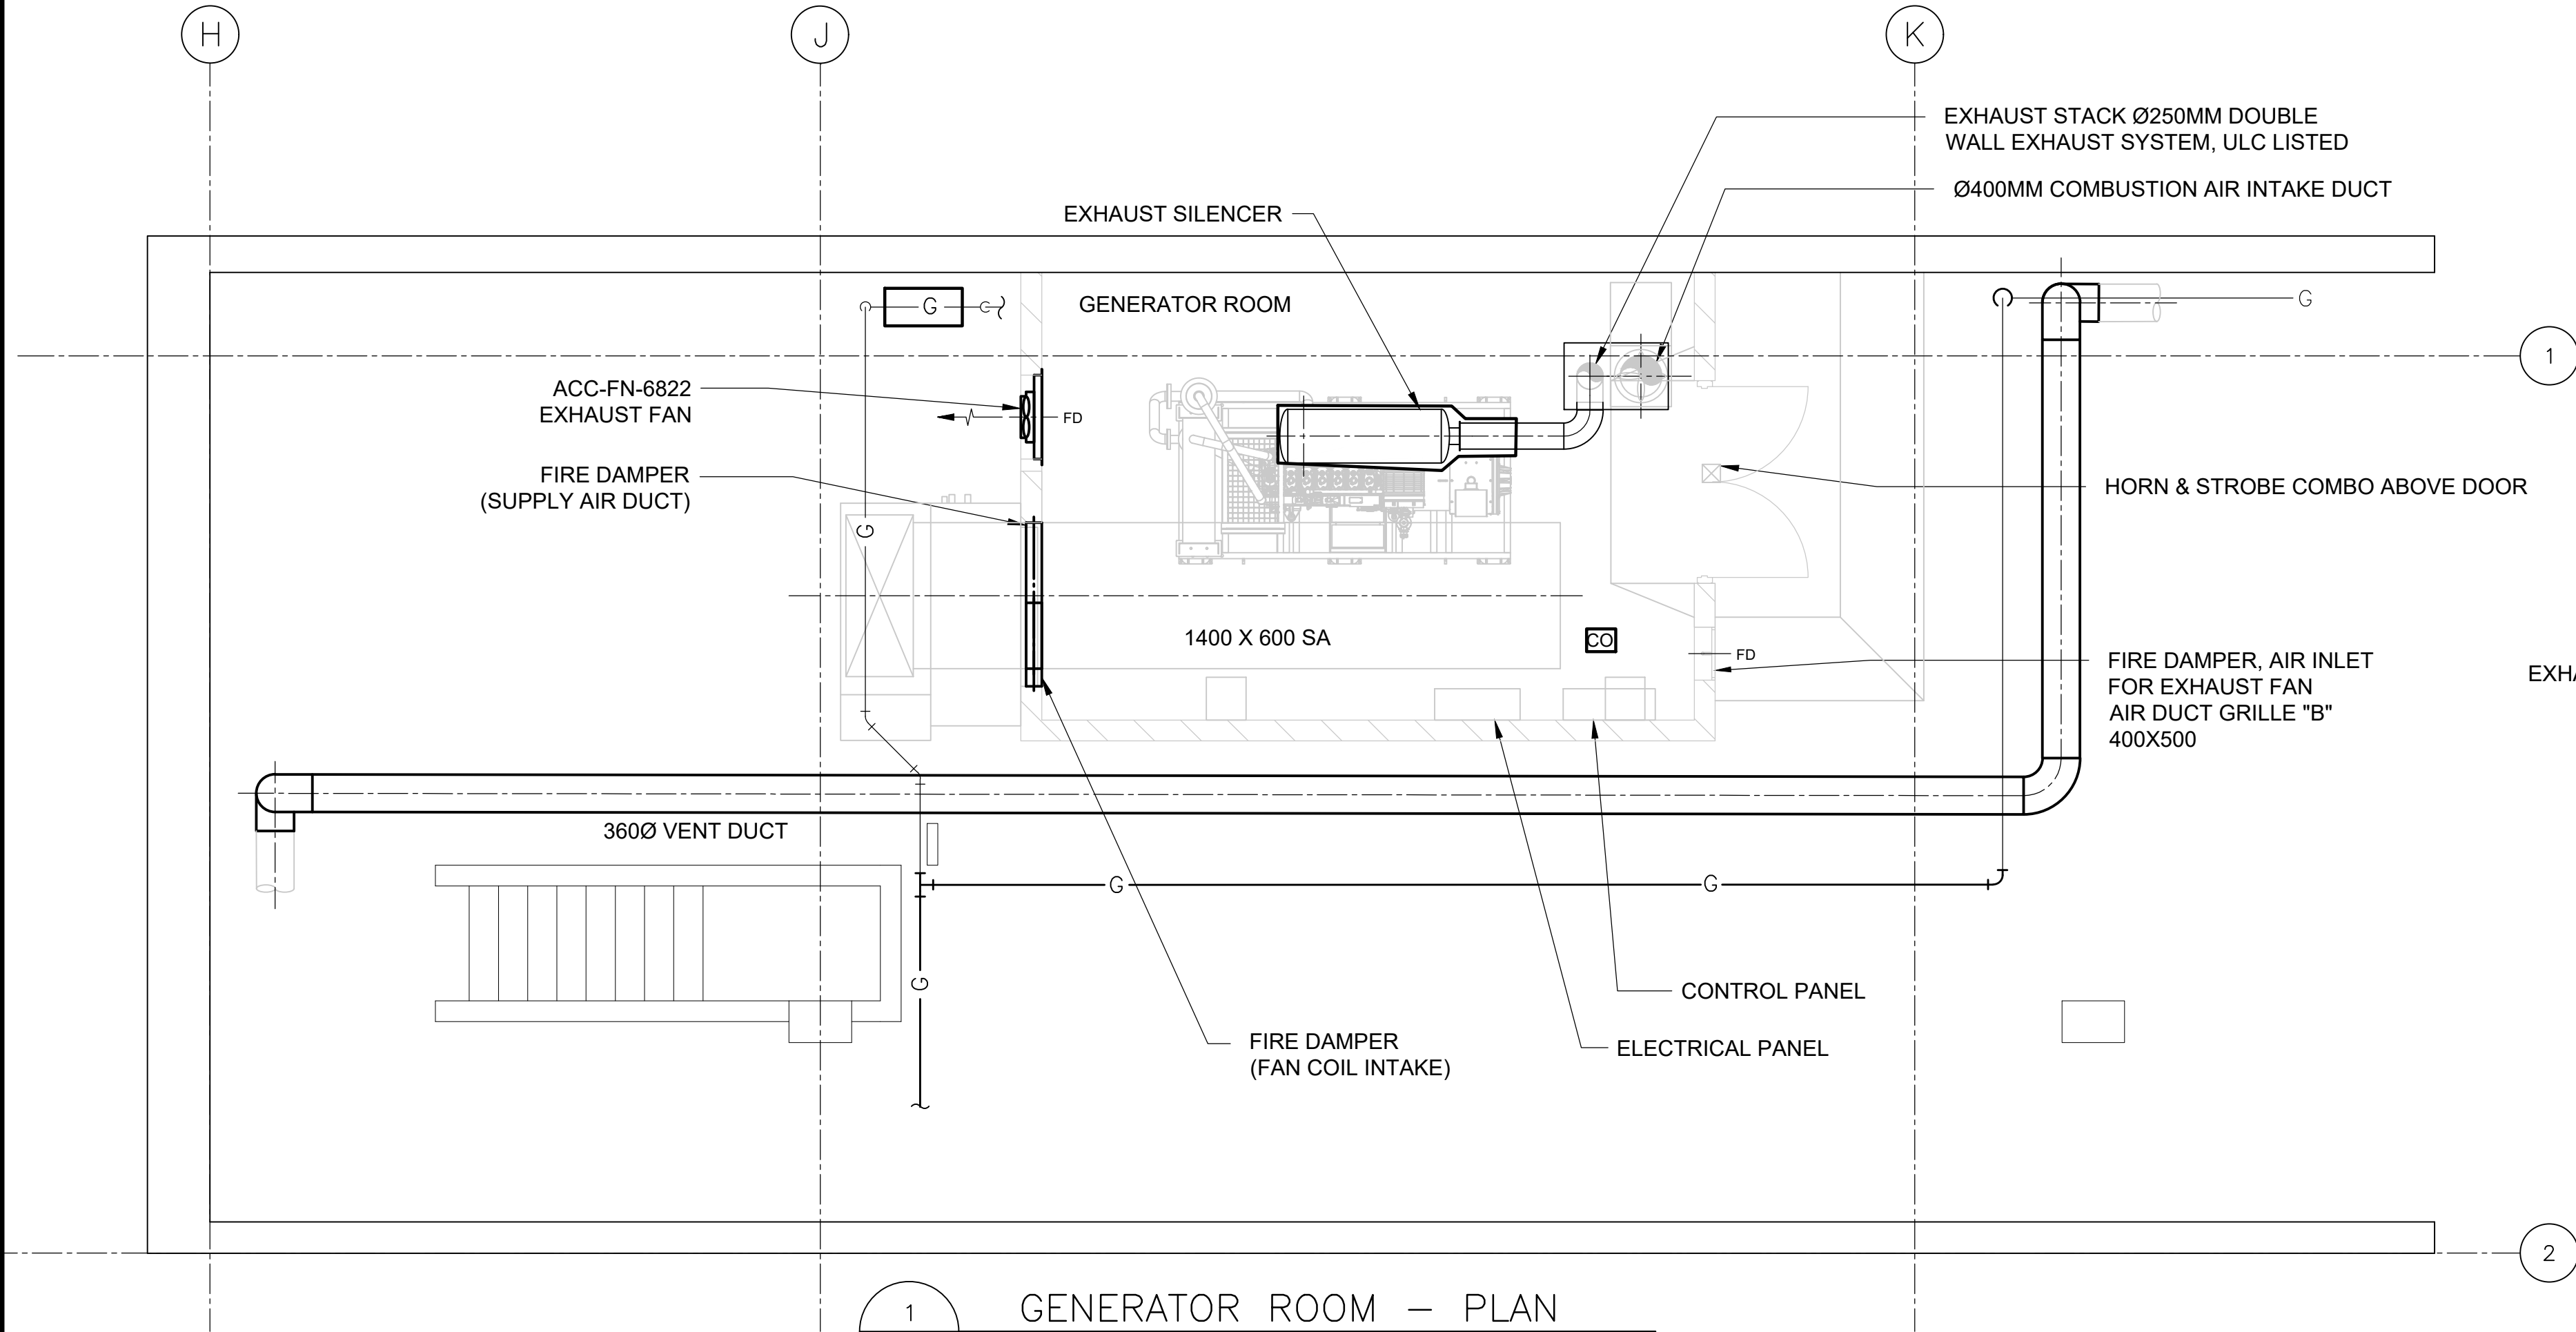


1 GENERATOR ROOM - PLAN
M201A SCALE 1:50

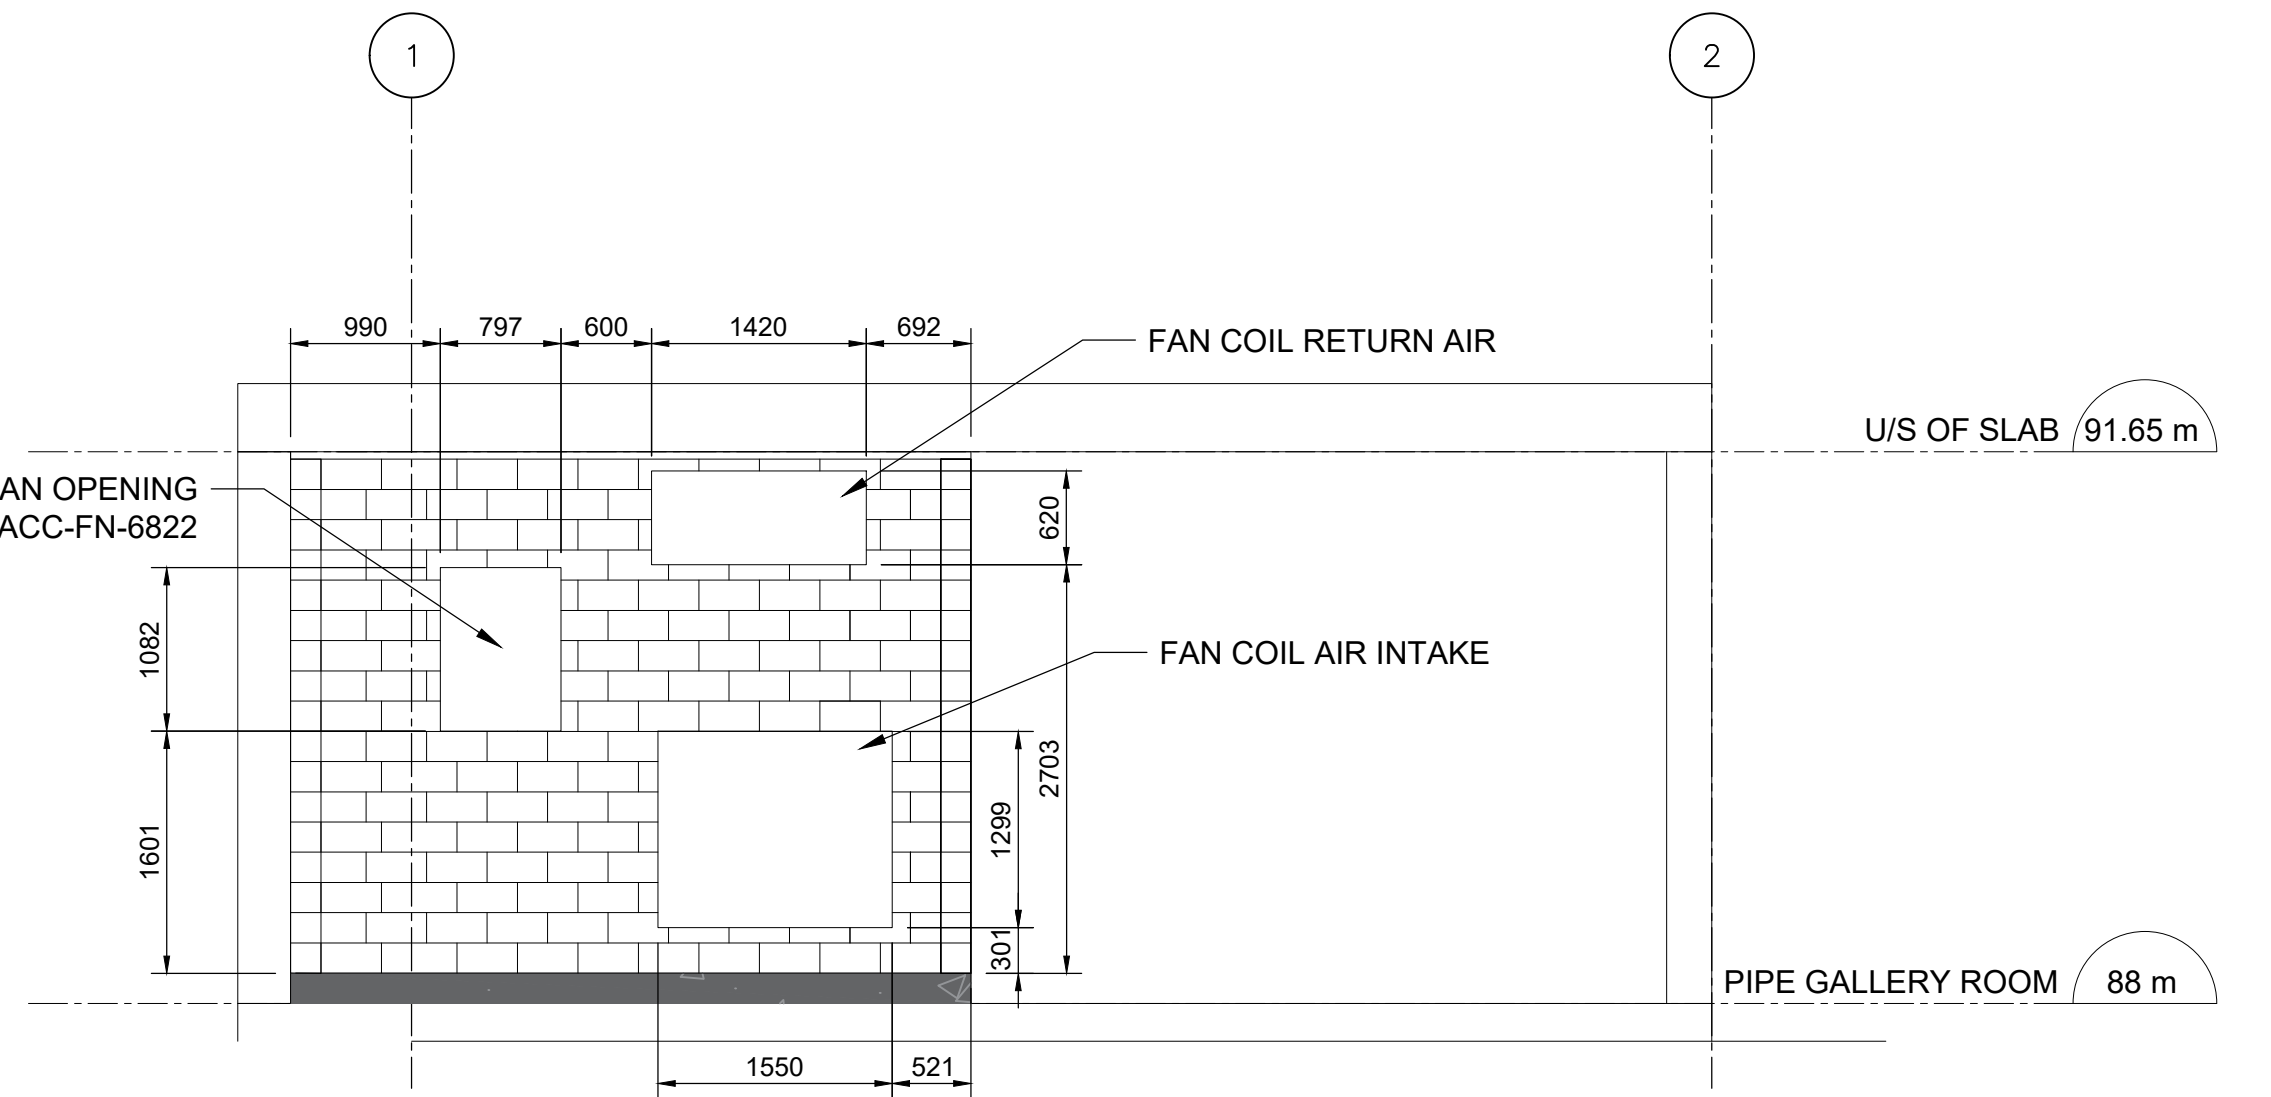


4 GENERATOR ROOM - MASONRY WALL DETAIL
M201A SCALE 1:50

NOTES:
• CONTRACTOR TO CONFIRM OPENING DIMENSIONS

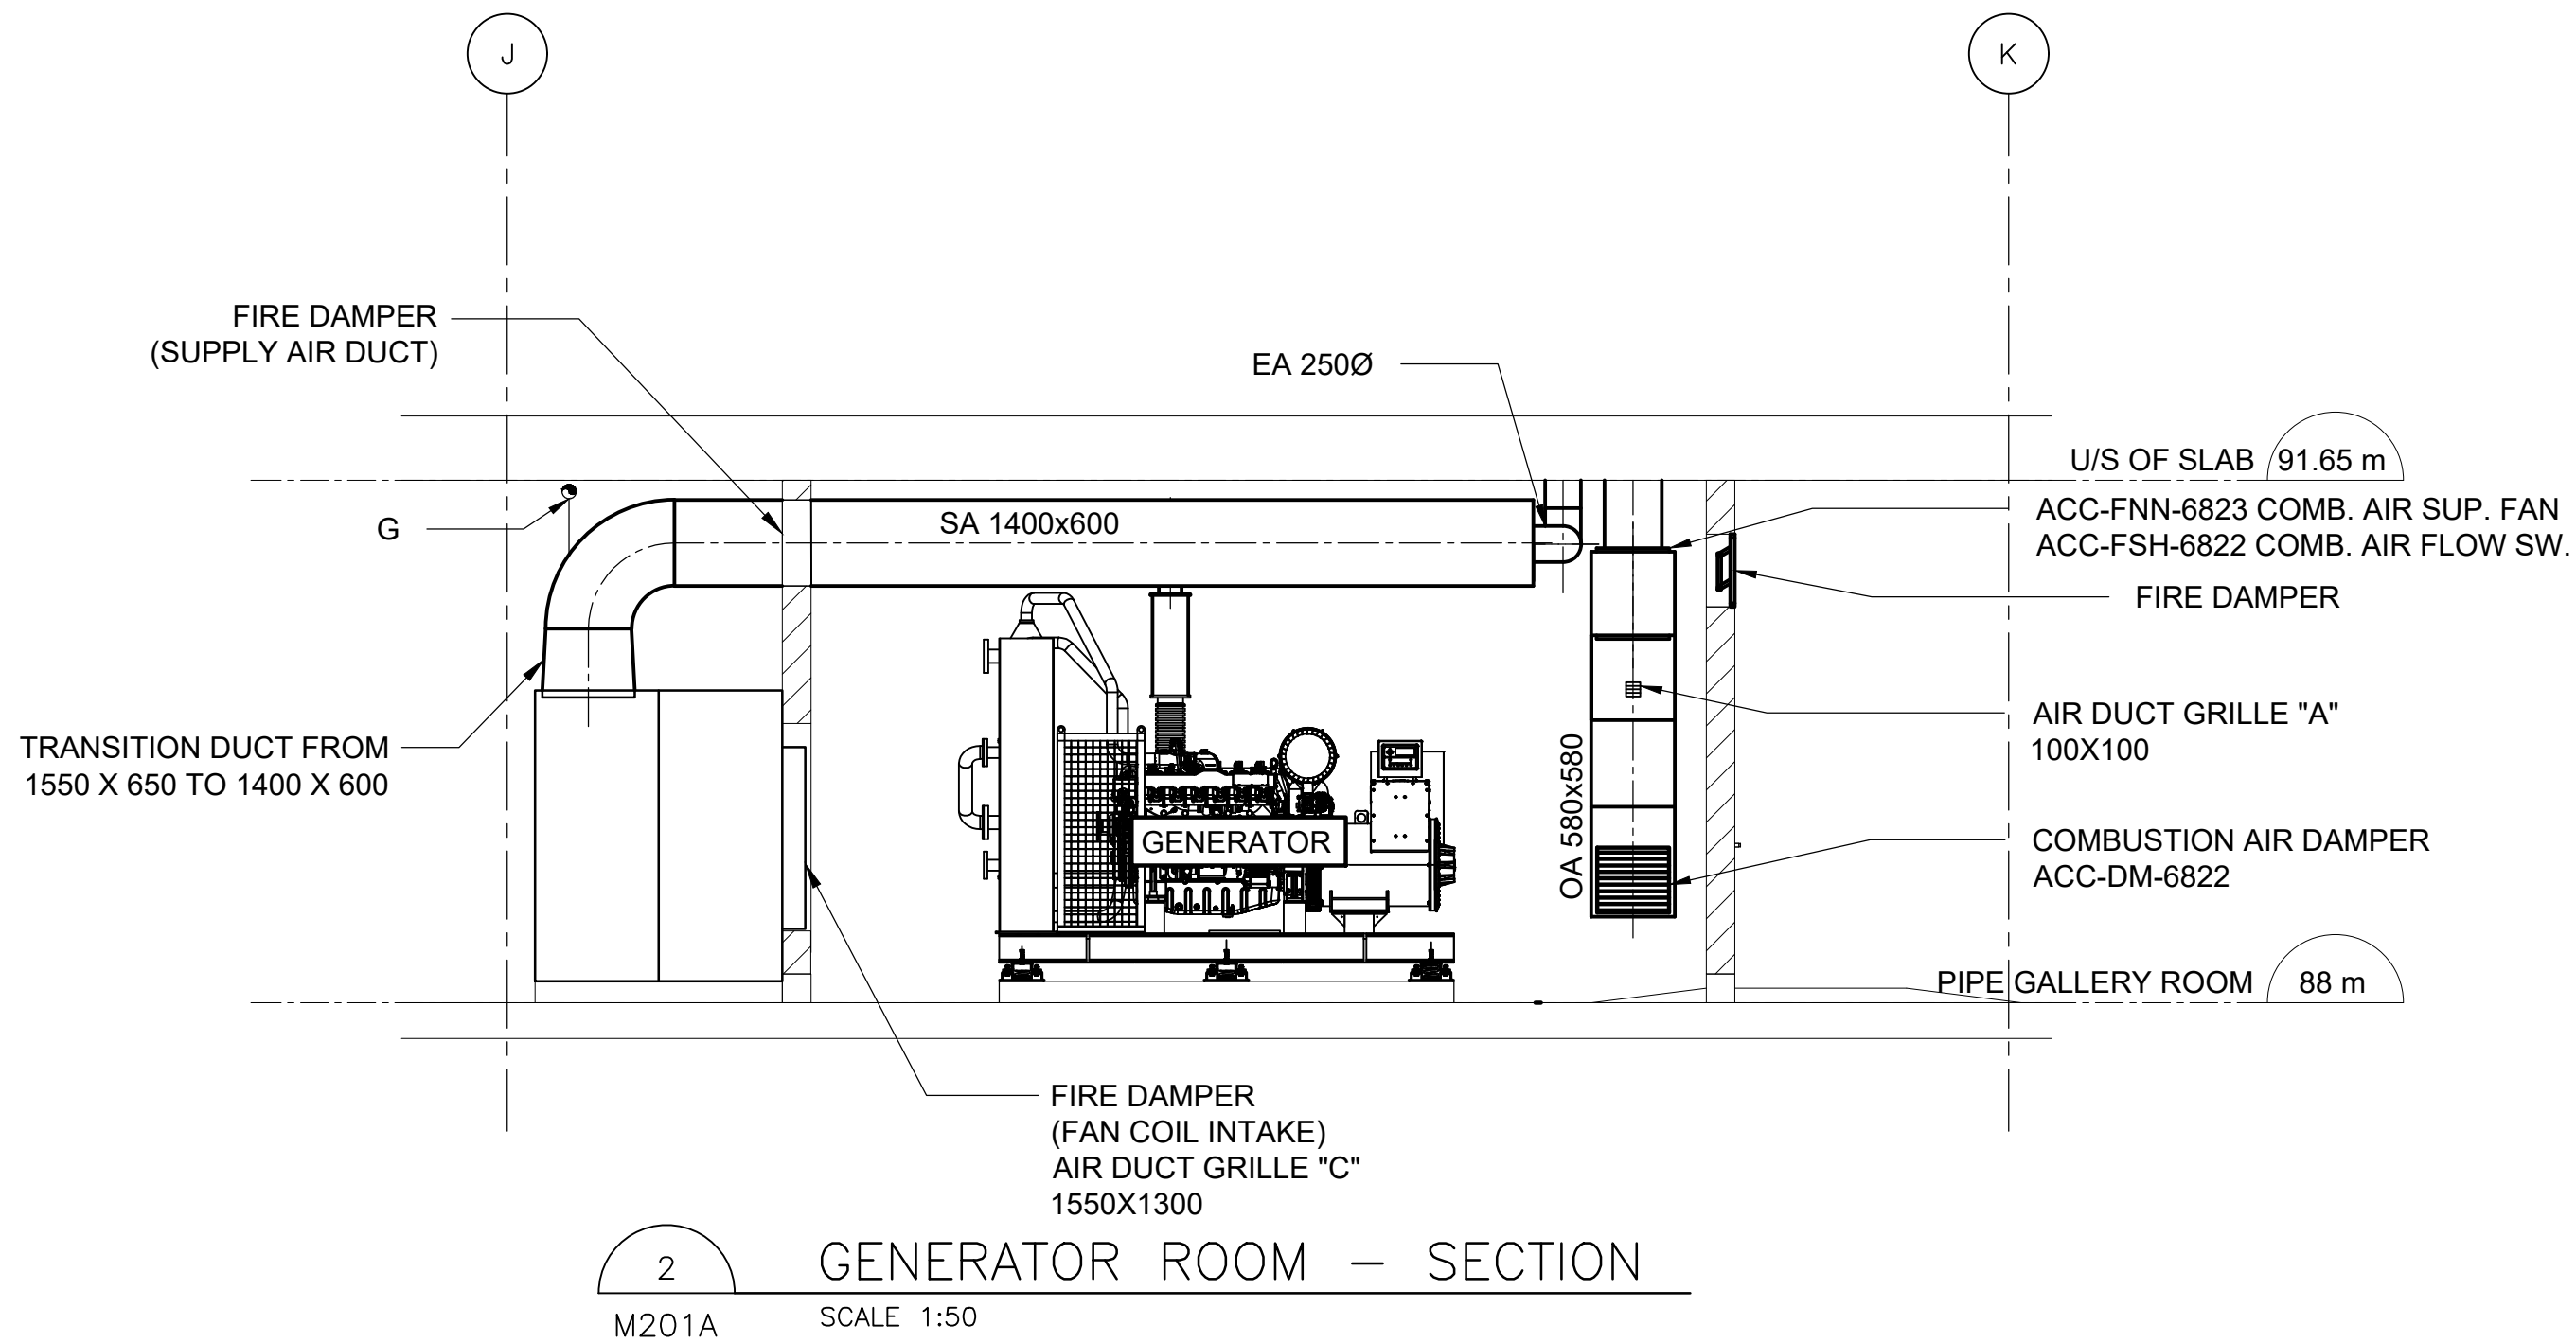

2 GENERATOR ROOM - SECTION
M201A SCALE 1:50

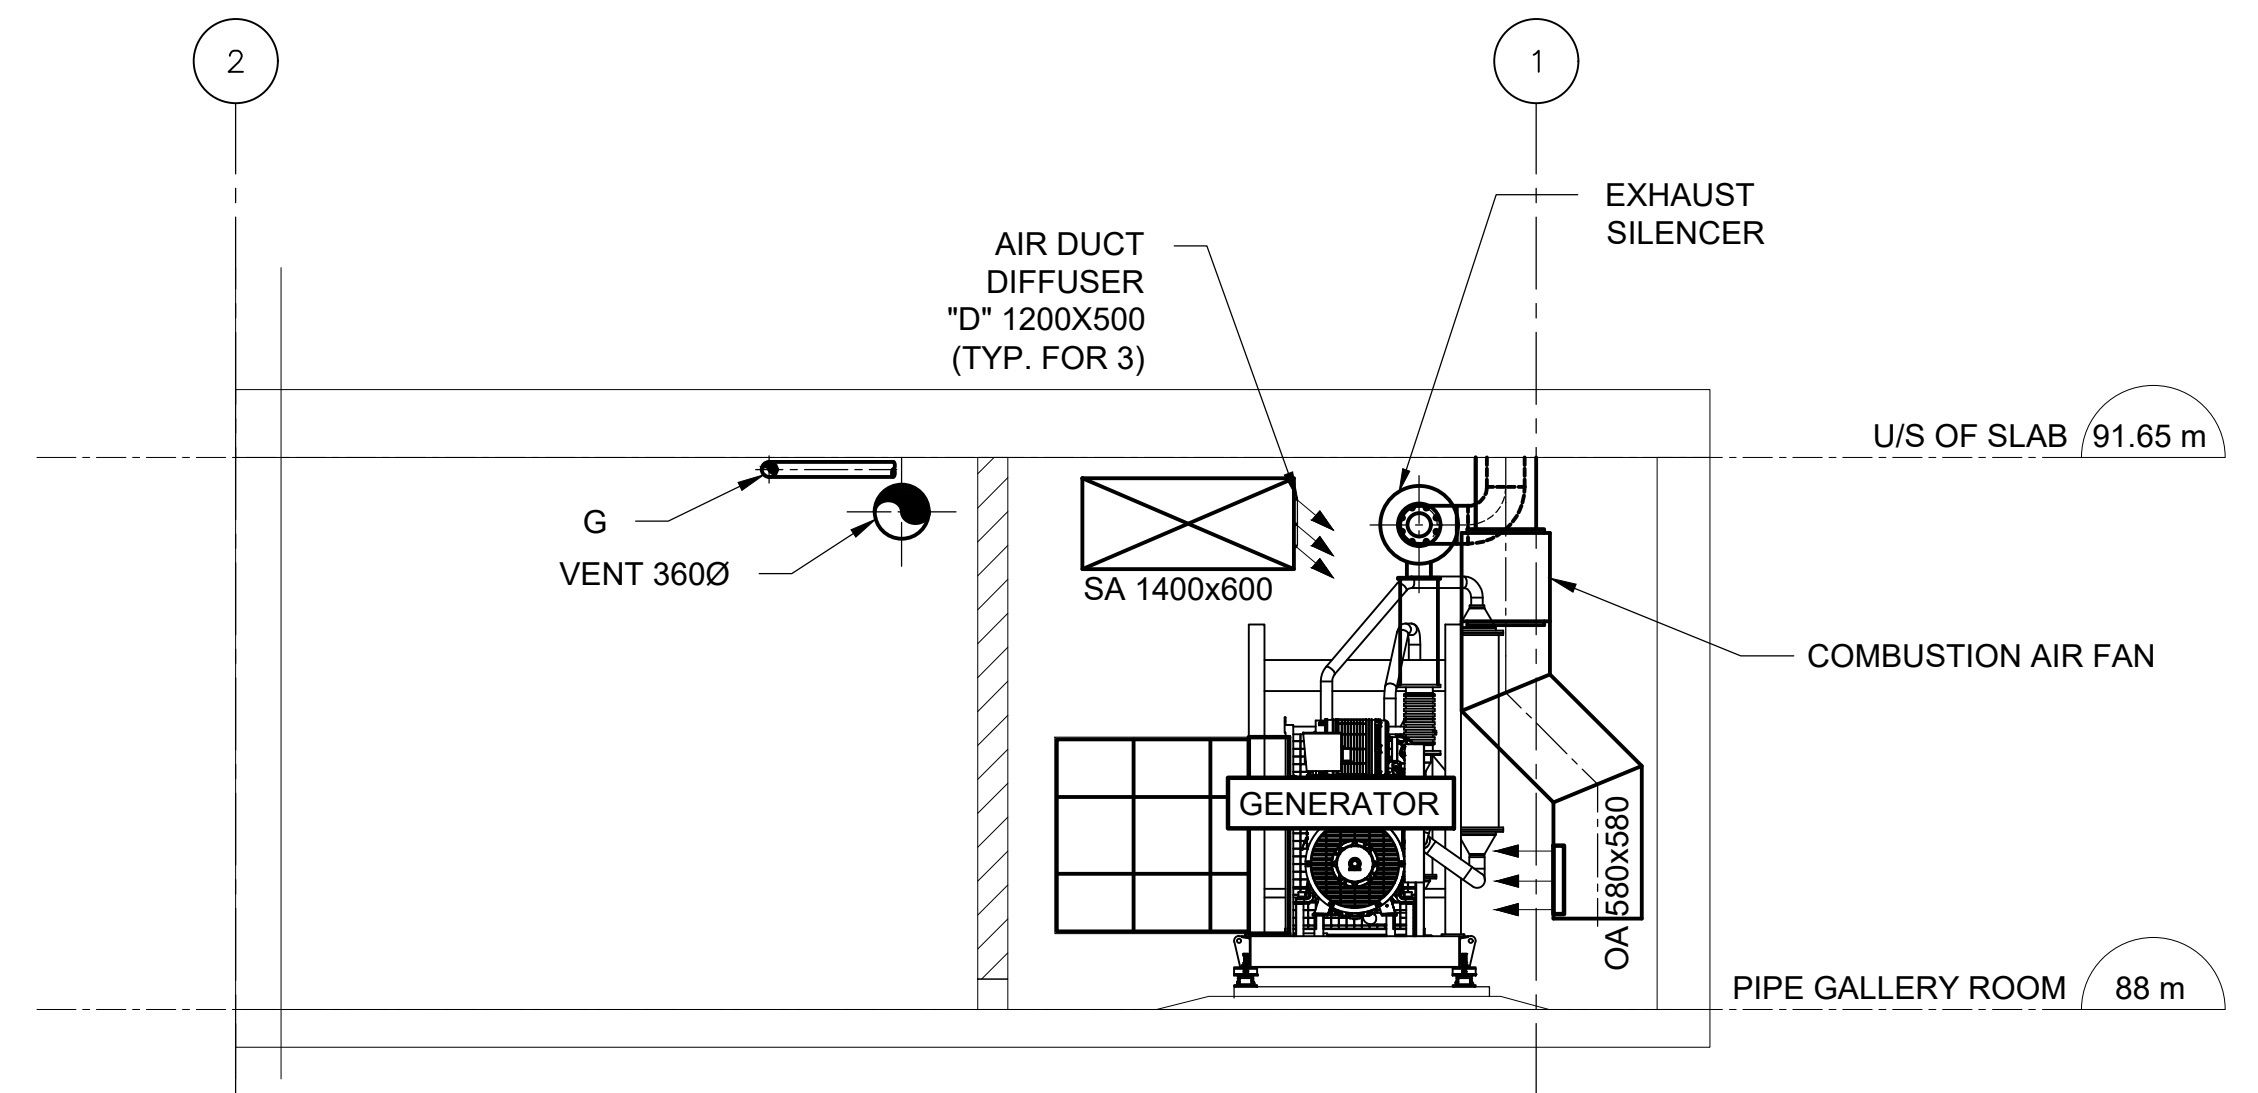


3 GENERATOR ROOM - SECTION
M201A SCALE 1:50



ARCADIS
100-175 GALAXY BOULEVARD
TORONTO, ONTARIO, M9W 0C9
TEL 416 679 1930 FAX 416 675 4620
www.arcadis.com

COPYRIGHT:
This drawing has been prepared solely for the intended use. No reproduction or distribution for any purpose other than authorized by ARCADIS is permitted. Written dimensions shall have precedence over scaled dimensions. Contractors shall verify and be responsible for all dimensions and conditions on the job, and ARCADIS shall be informed of any variations from the dimensions and conditions shown on the drawing. Shop drawings shall be submitted to IBI Group for general conformance before proceeding with fabrication.
ARCADIS Professional Services (Canada) Inc.

A	2025-03-18	ISSUED FOR TENDER	K.C.		
NO.	DATE	REVISIONS	INITIAL	SIGNED	

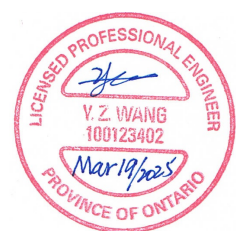


WILLIAM FERNANDES, P. ENG.
DIRECTOR
WATER TREATMENT AND SUPPLY


SIMON HOPTON, P. ENG.
DIRECTOR
DESIGN & CONSTRUCTION
MAJOR INFRASTRUCTURE

R.C. HARRIS WATER TREATMENT PLANT
INSTALLATION OF A STANDBY GENERATOR FOR CRITICAL LOADS
ENLARGED PLAN GENERATOR ROOM HVAC


MECHANICAL					
DESIGN:	B. BEALE	DRAFTING:	A. GILROY	CHECK:	B. BEALE
SCALE:	1:50			DRAWING NUMBER:	2F-2017-08-22
DATE:	2024-09-30				M201A

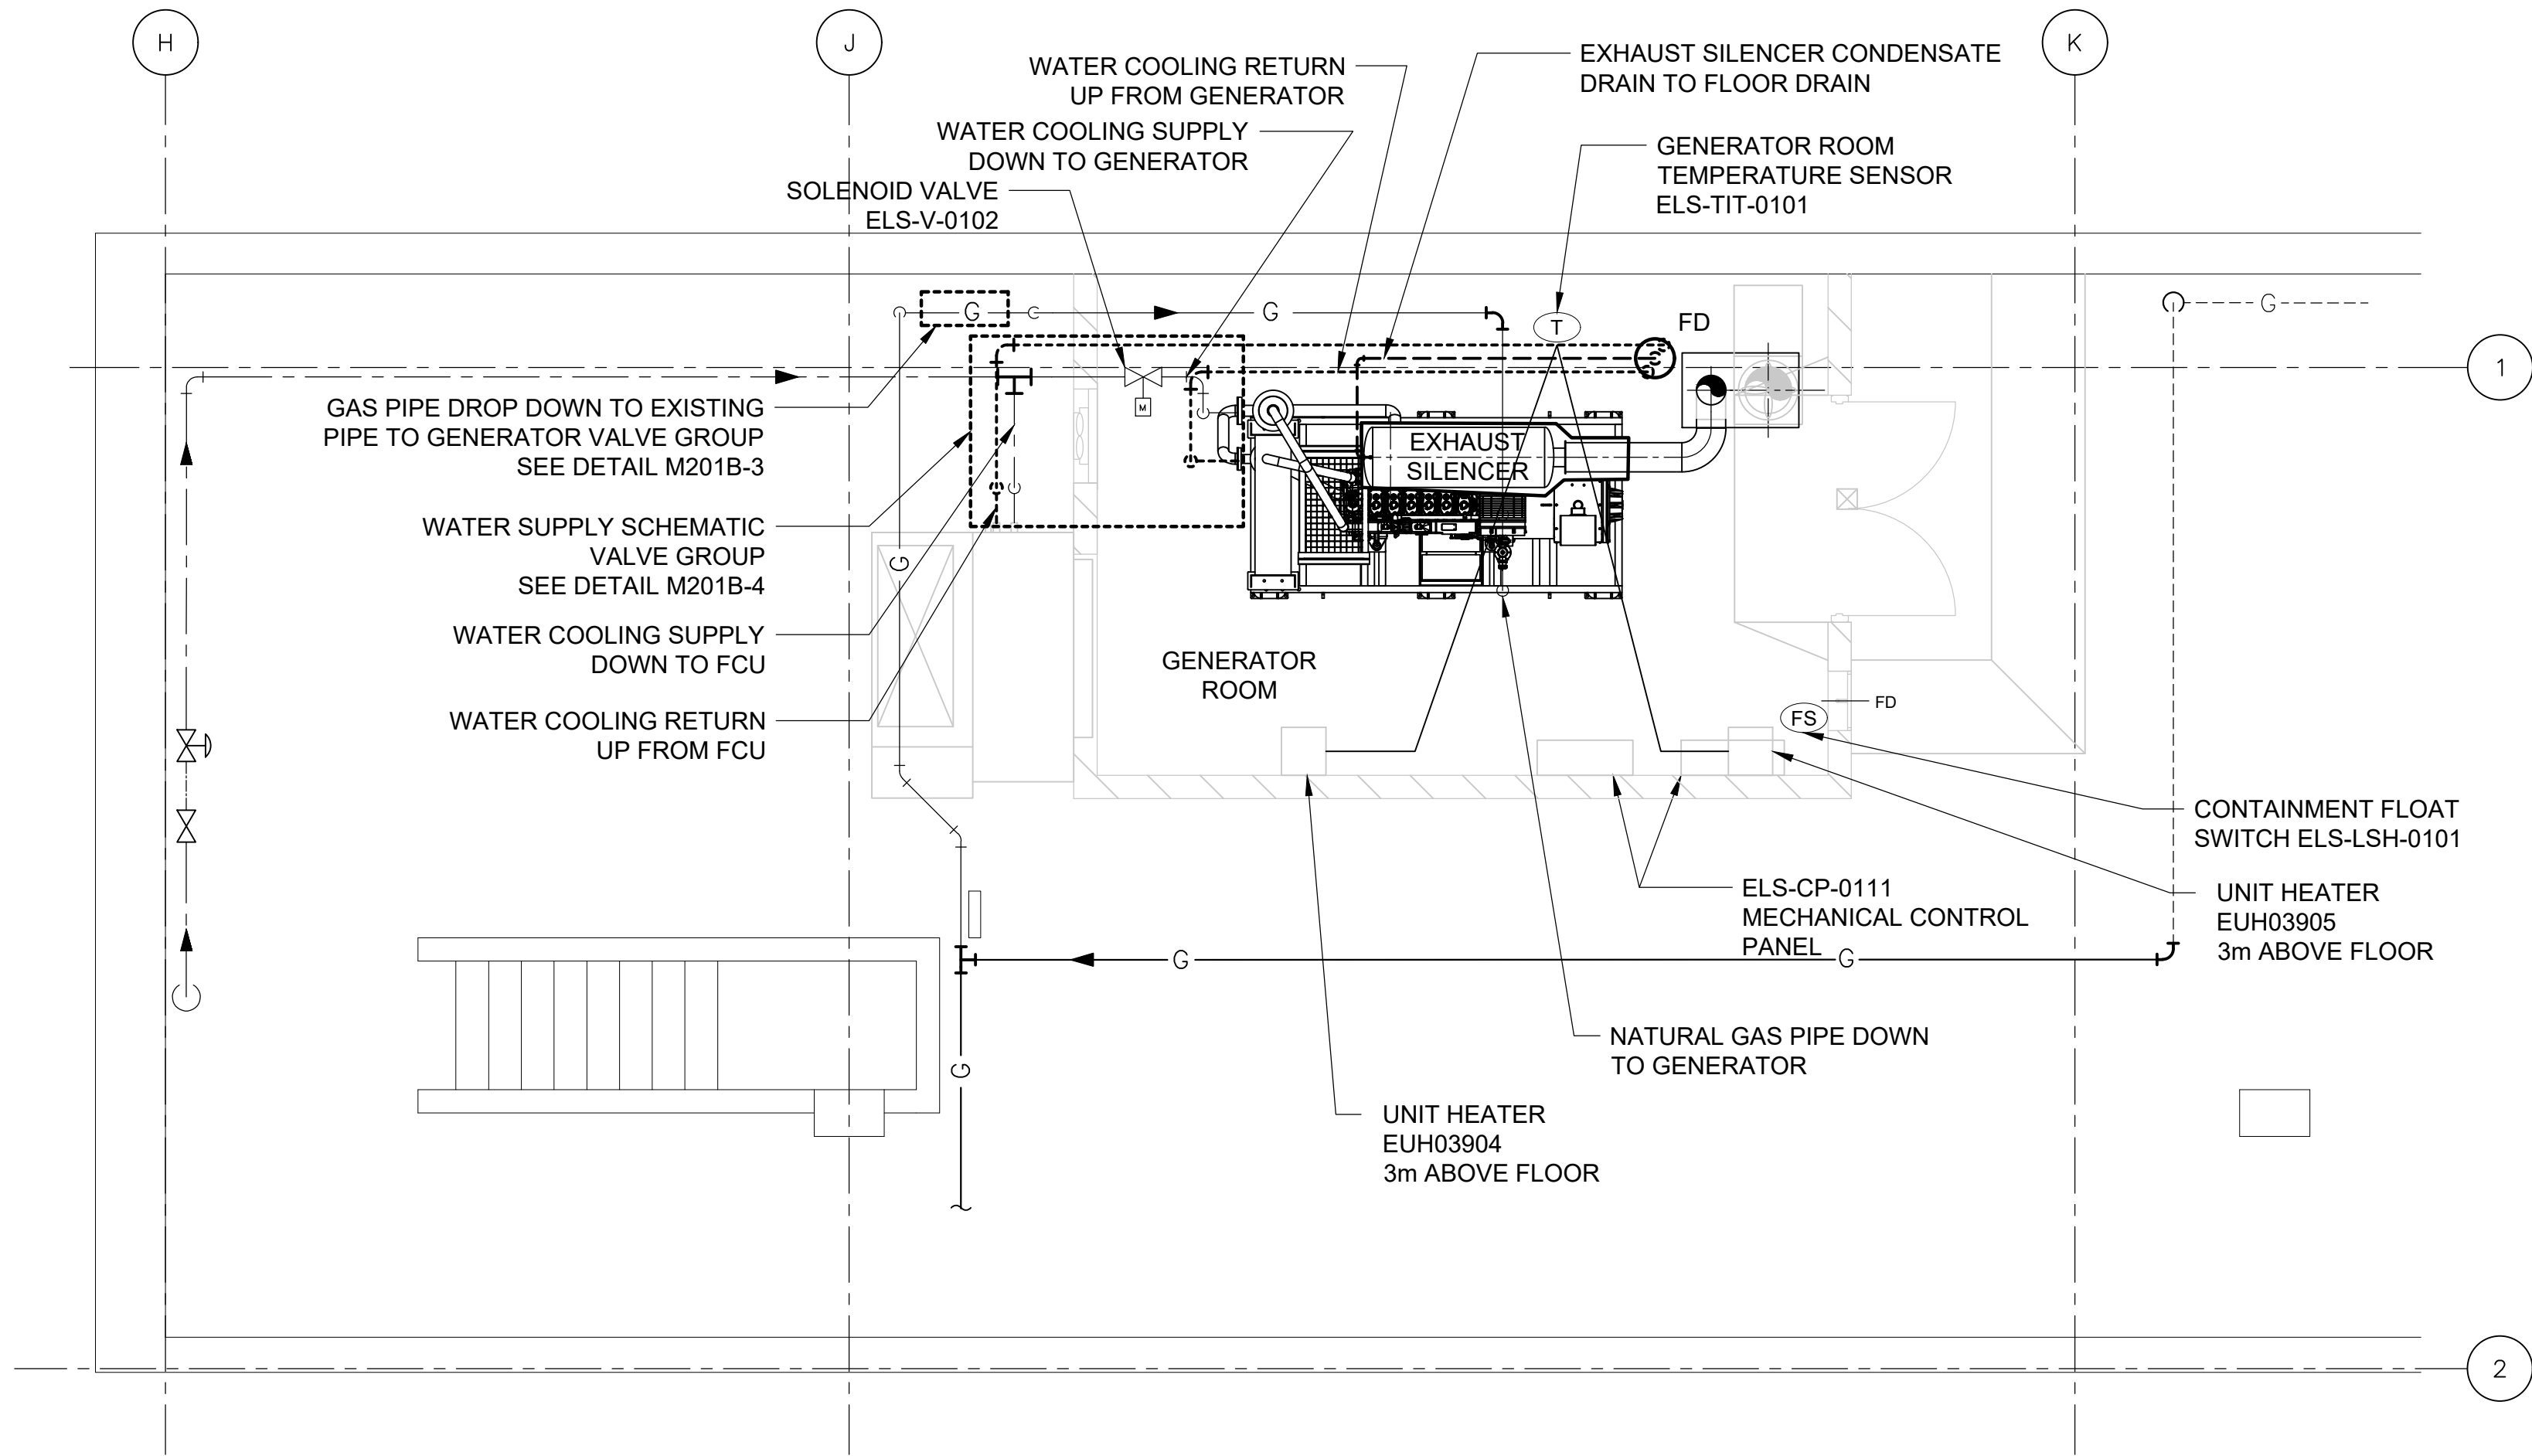


1 GENERATOR ROOM - PLAN
M201B SCALE 1:50

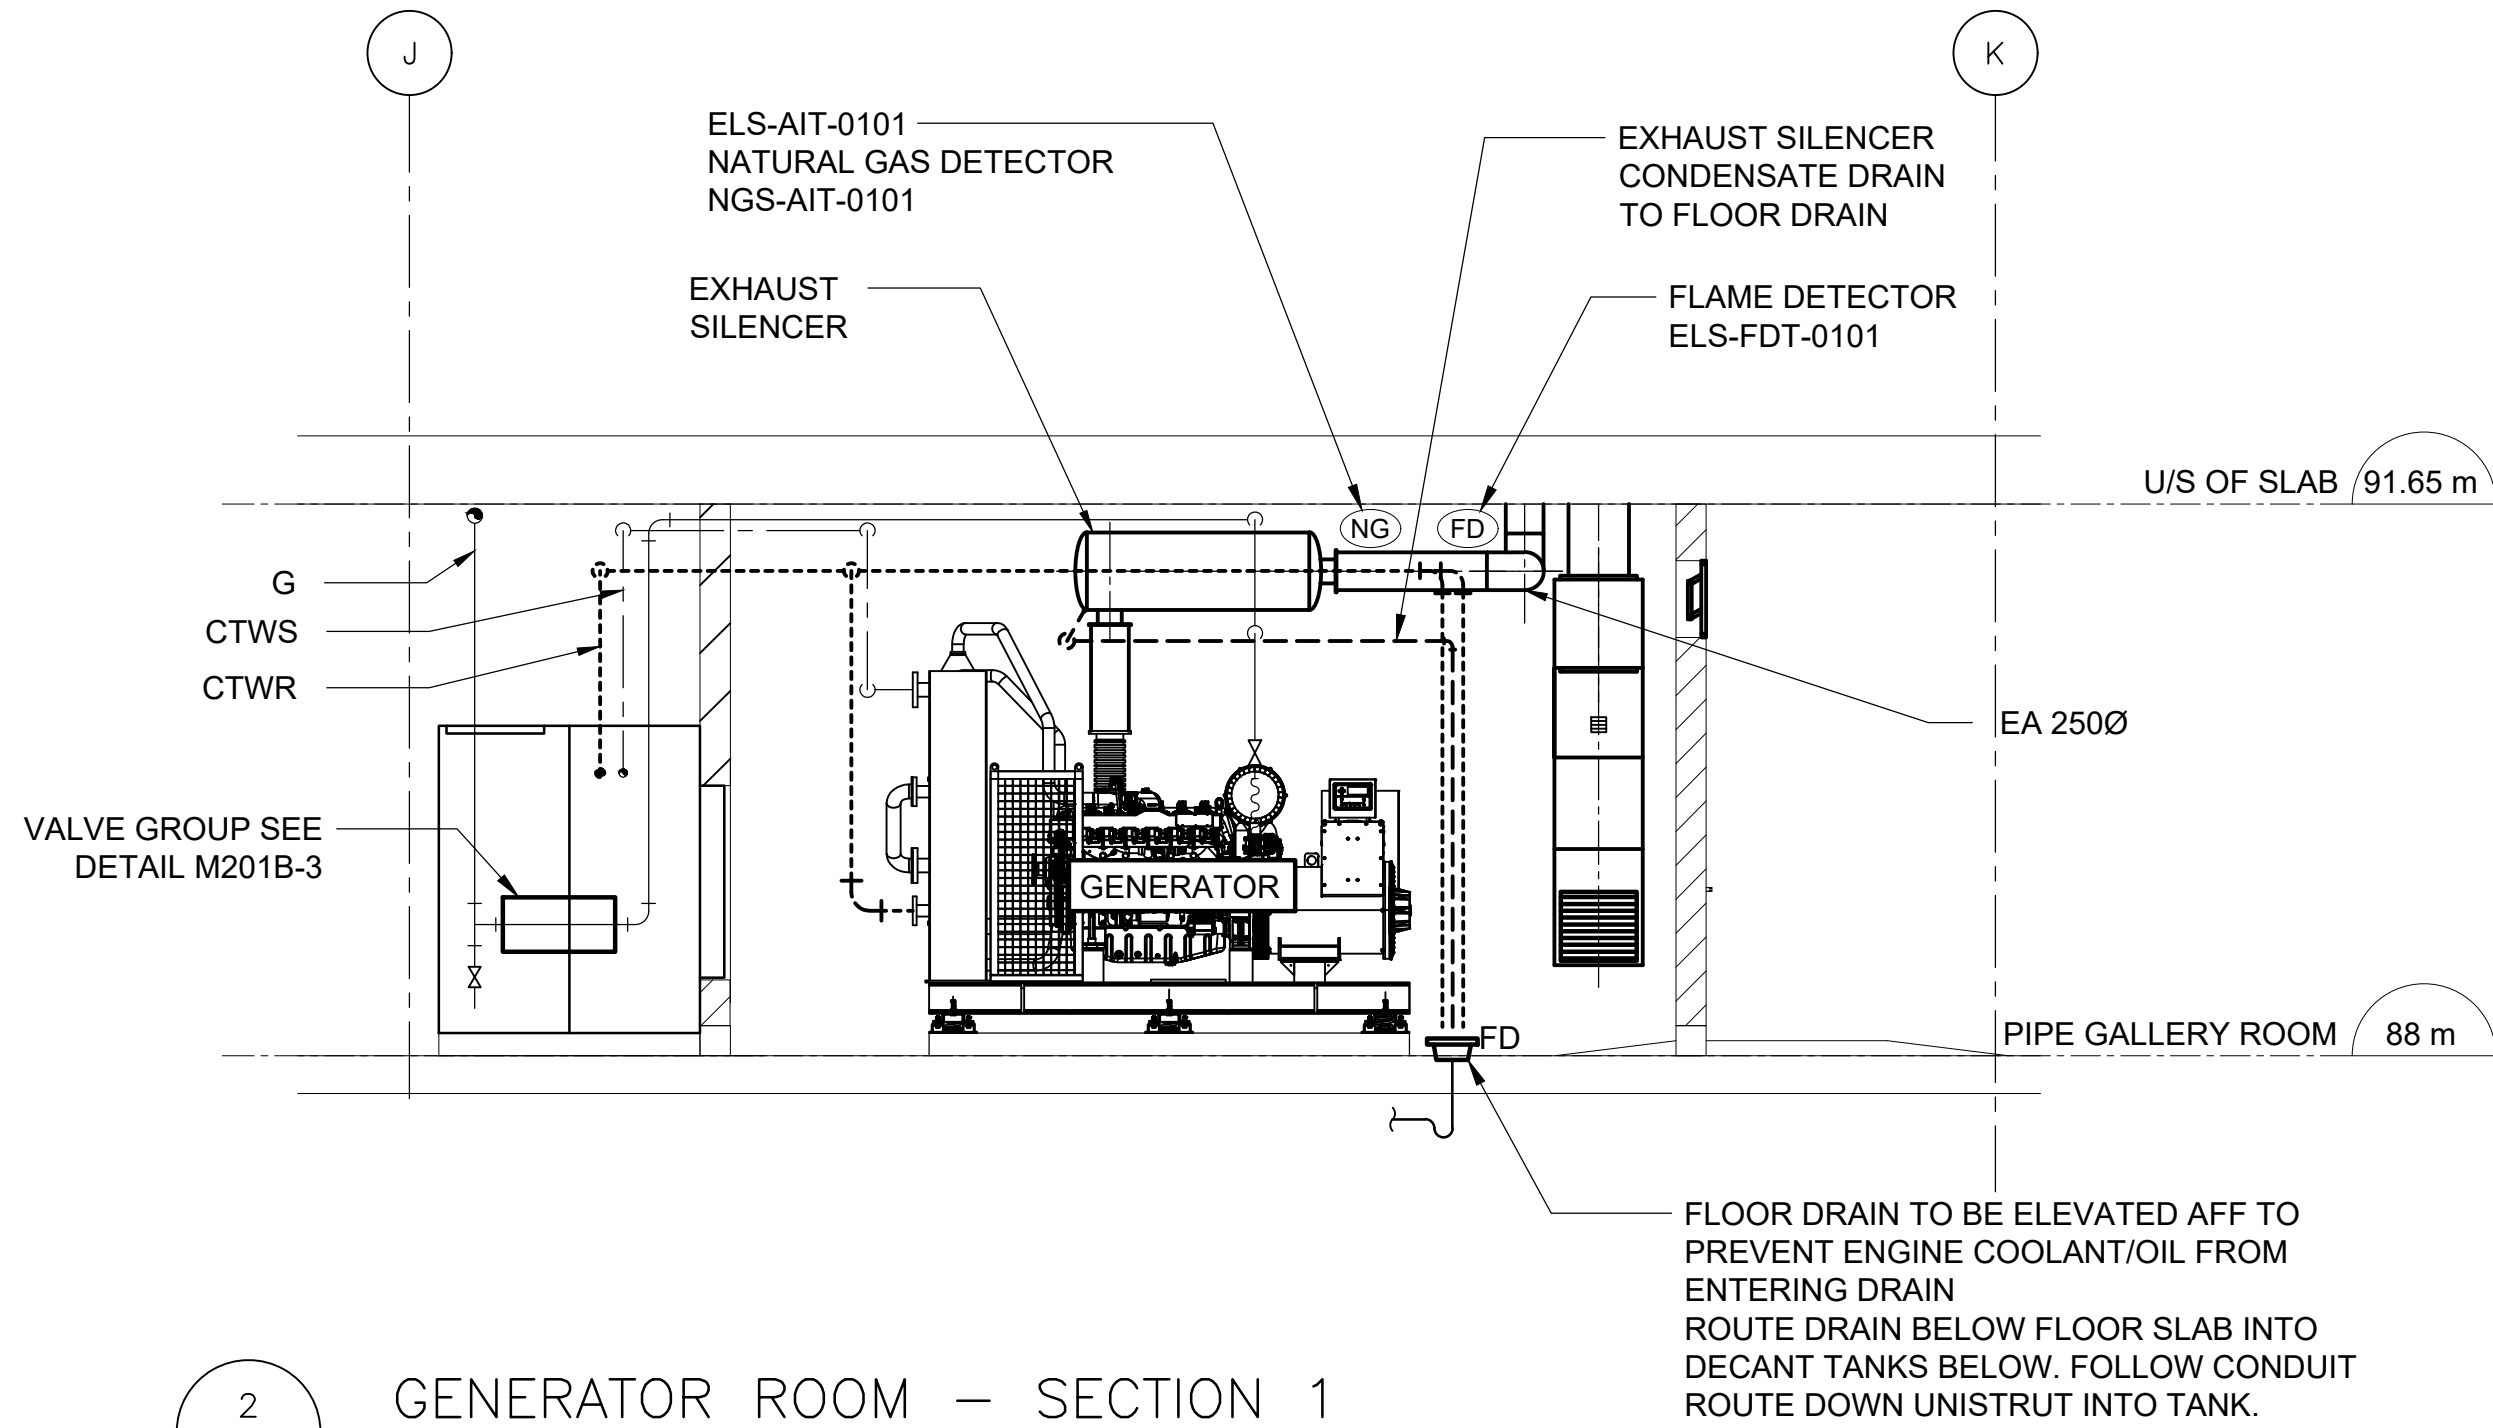


2 GENERATOR ROOM - SECTION 1
M201B SCALE 1:50

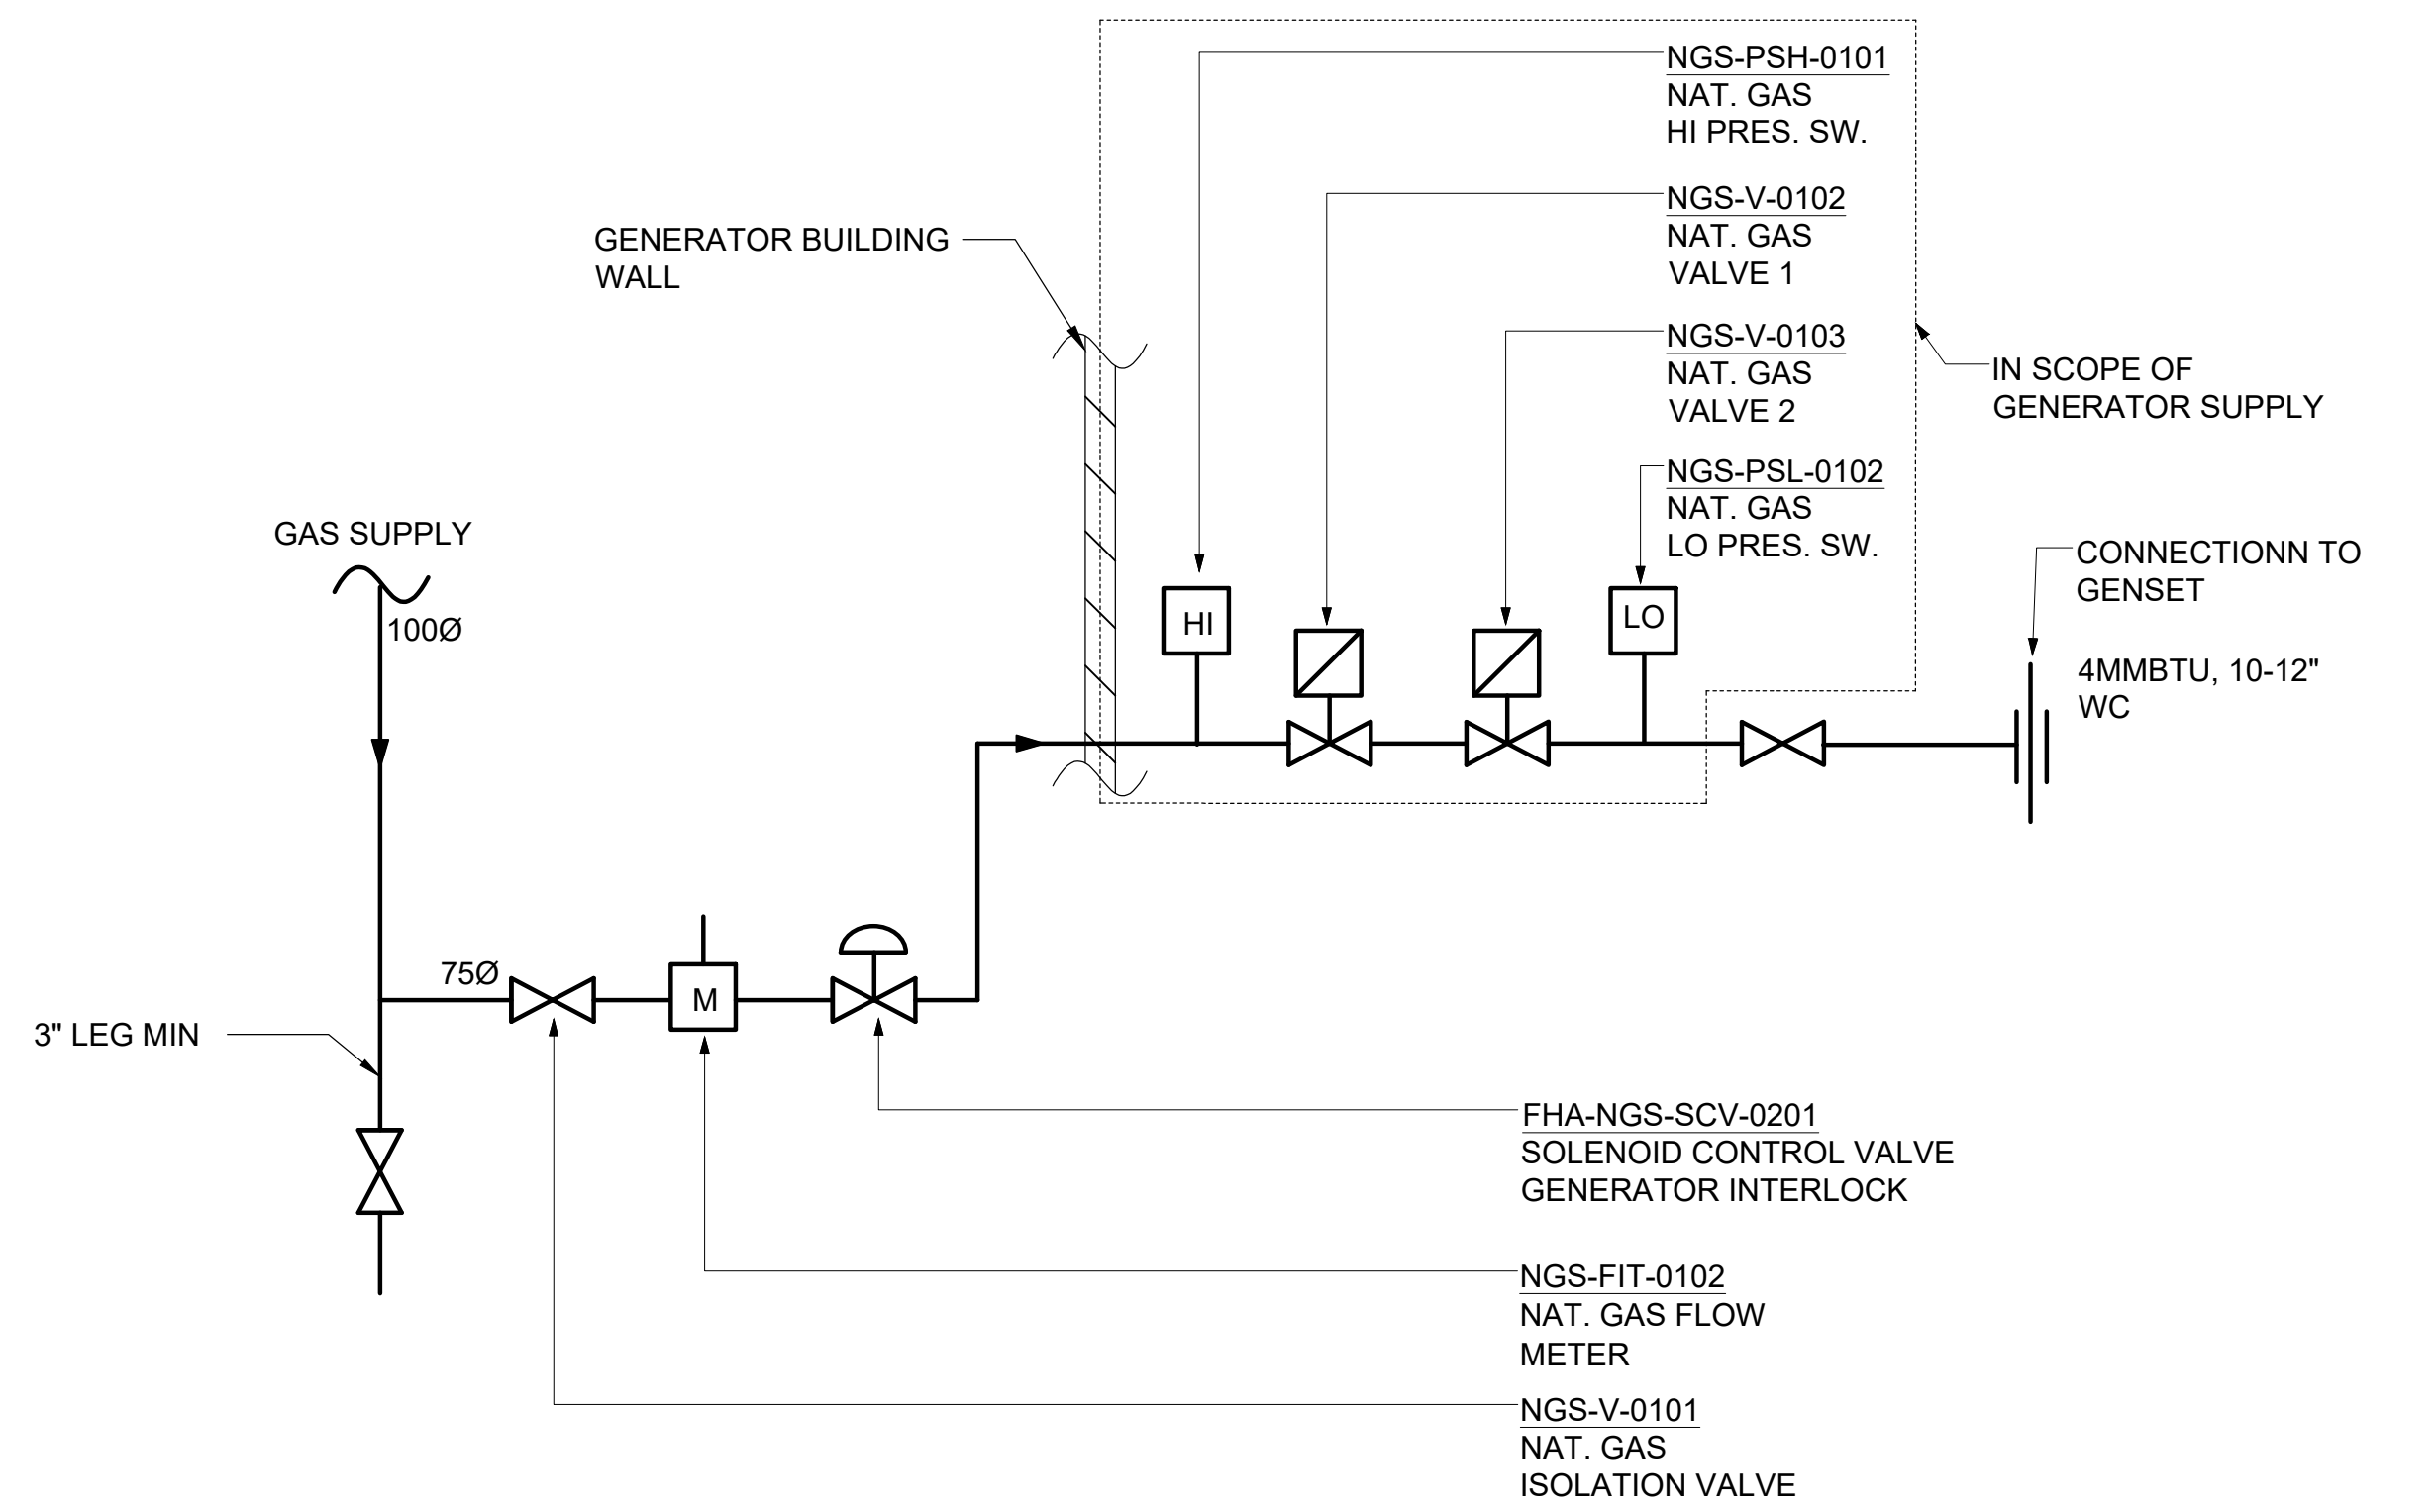

3 NATURAL GAS TO GENERATOR CONNECTION SCHEMATIC
M201B SCALE NTS

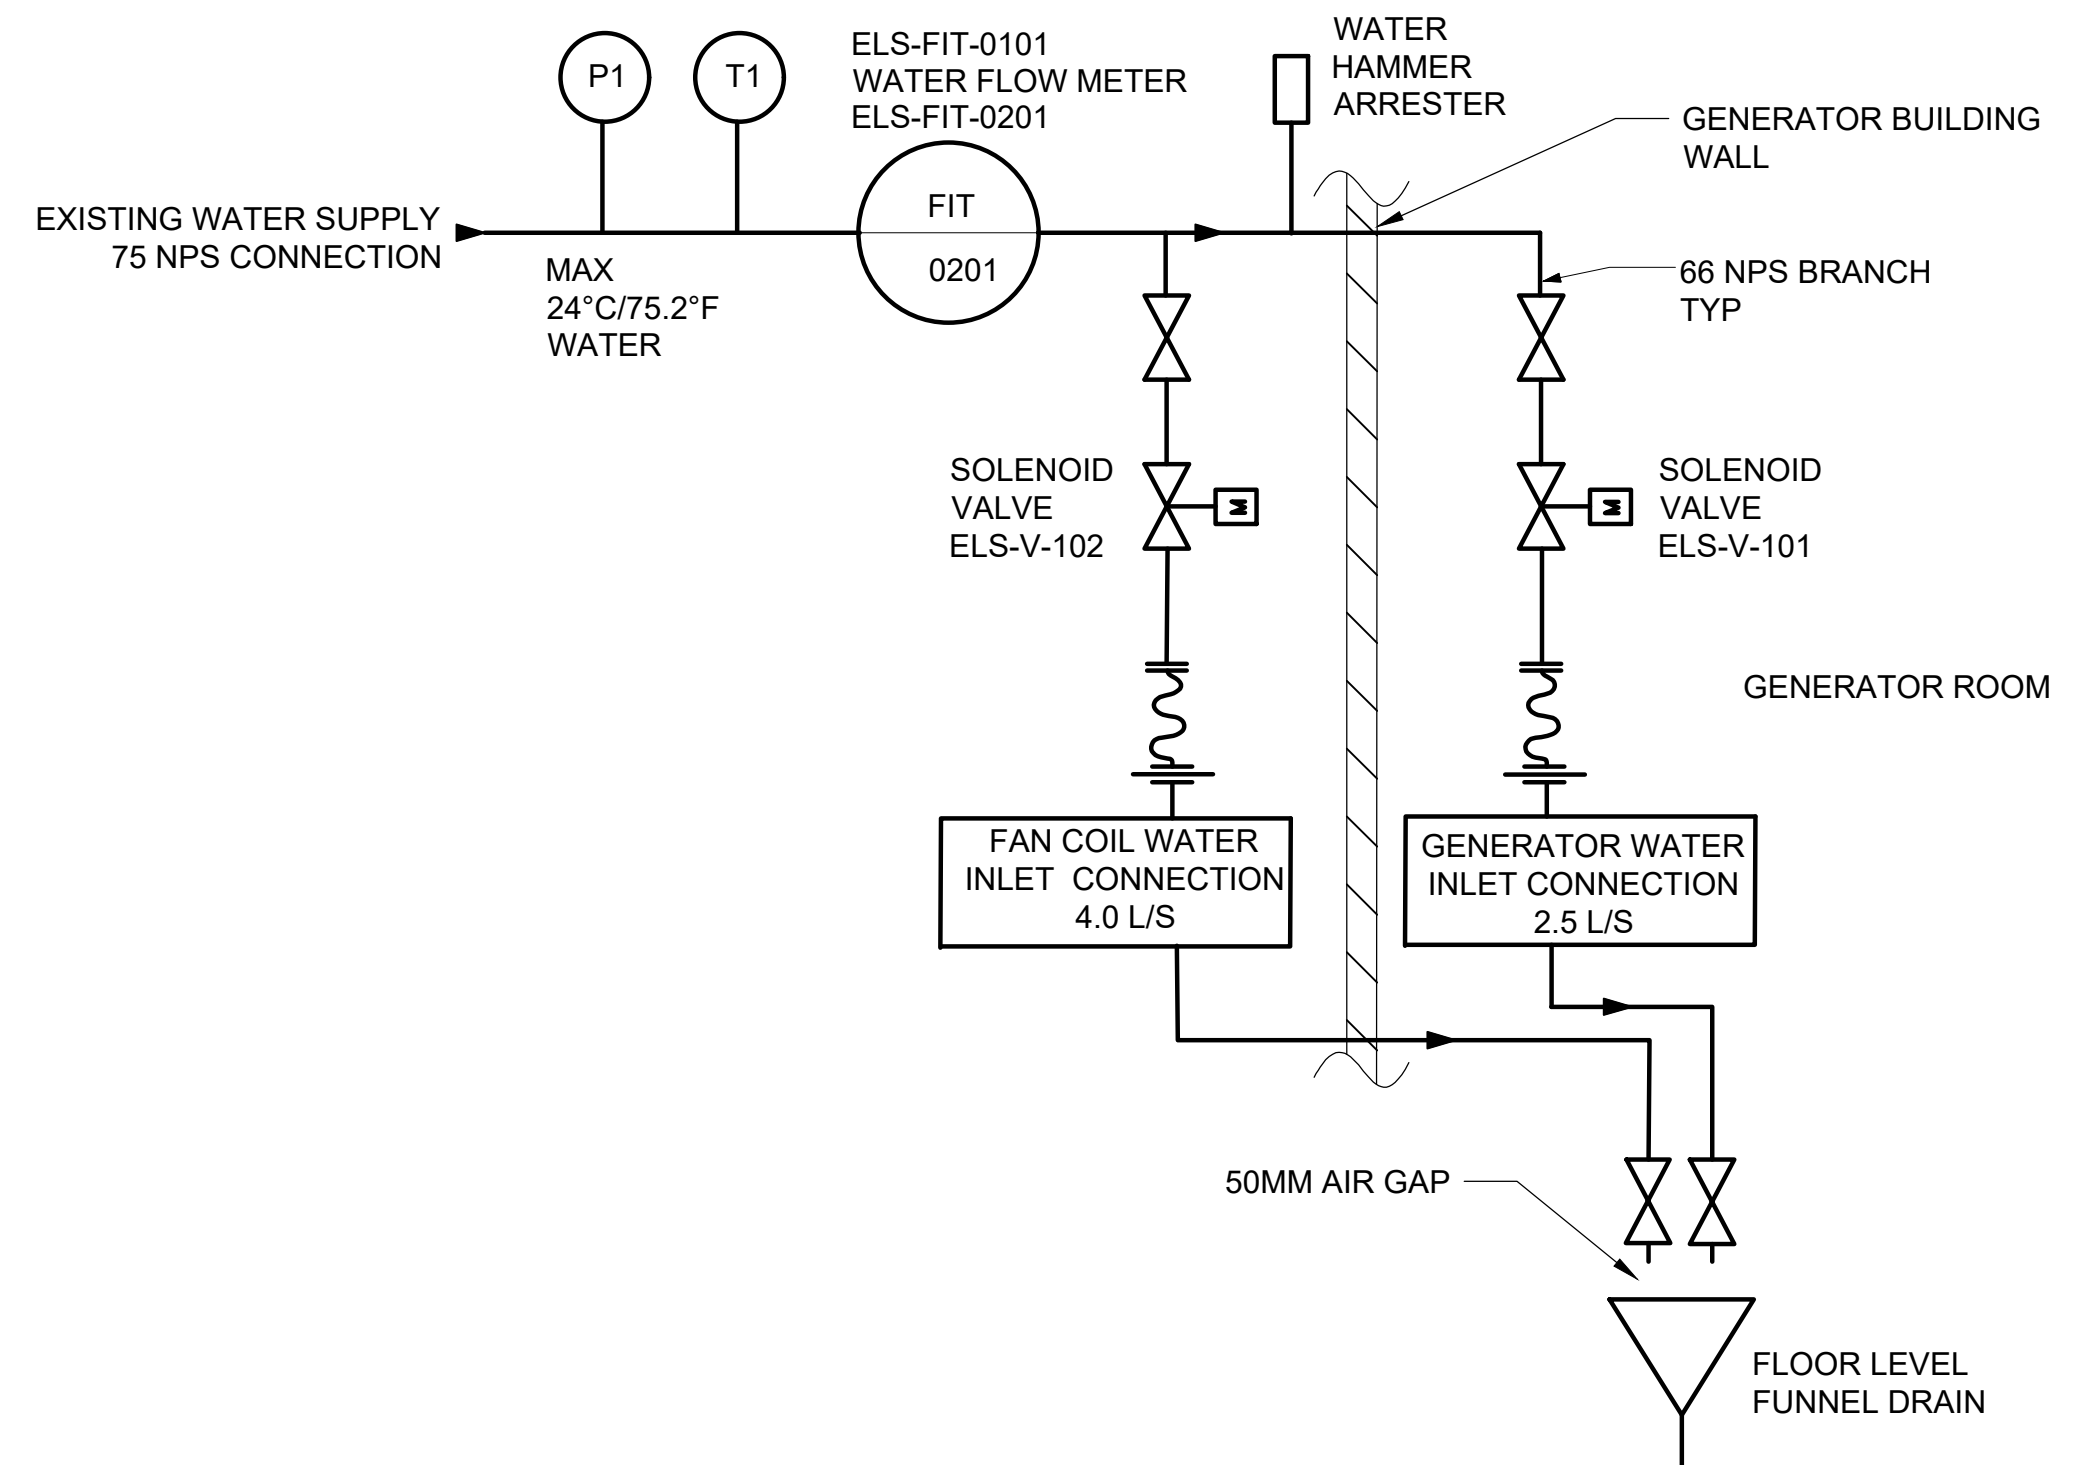

4 WATER SUPPLY SCHEMATIC FOR FAN COIL UNIT AND GENERATOR
M201B SCALE NTS

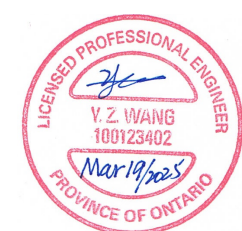

TORONTO WATER

ENGINEERING AND CONSTRUCTION SERVICES

WILLIAM FERNANDES, P. ENG.
DIRECTOR
WATER TREATMENT AND SUPPLY

SIMON HOPTON, P. ENG.
DIRECTOR
DESIGN & CONSTRUCTION
MAJOR INFRASTRUCTURE

R.C. HARRIS WATER TREATMENT PLANT
INSTALLATION OF A STANDBY GENERATOR FOR CRITICAL LOADS
ENLARGED PLAN GENERATOR ROOM PIPING



MECHANICAL

DESIGN:	B. BEALE	DRAFTING:	A. GILROY	CHECK:	B. BEALE	CONTRACT No.	25ECS-MI-03HA
SCALE:	1:50			DRAWING NUMBER:	2F-2017-08-23		
DATE:	2024-09-30						M201B

ARCADIS
100-175 GALAXY BOULEVARD
TORONTO, ONTARIO, M9W 0C9
TEL 416 679 1930 FAX 416 675 4620
www.arcadis.com

COPYRIGHT:
This drawing has been prepared solely for the intended use. No reproduction or distribution for any purpose other than authorized by ARCADIS is permitted. Written dimensions shall have precedence over scaled dimensions. Contractors shall verify and be responsible for all dimensions and conditions on the job, and ARCADIS shall be informed of any variations from the dimensions and conditions shown on the drawing. Shop drawings shall be submitted to IBI Group for general conformance before proceeding with fabrication.
ARCADIS Professional Services (Canada) Inc.


A	2025-03-18	ISSUED FOR TENDER	K.C.
NO.	DATE	REVISIONS	INITIAL
			SIGNED

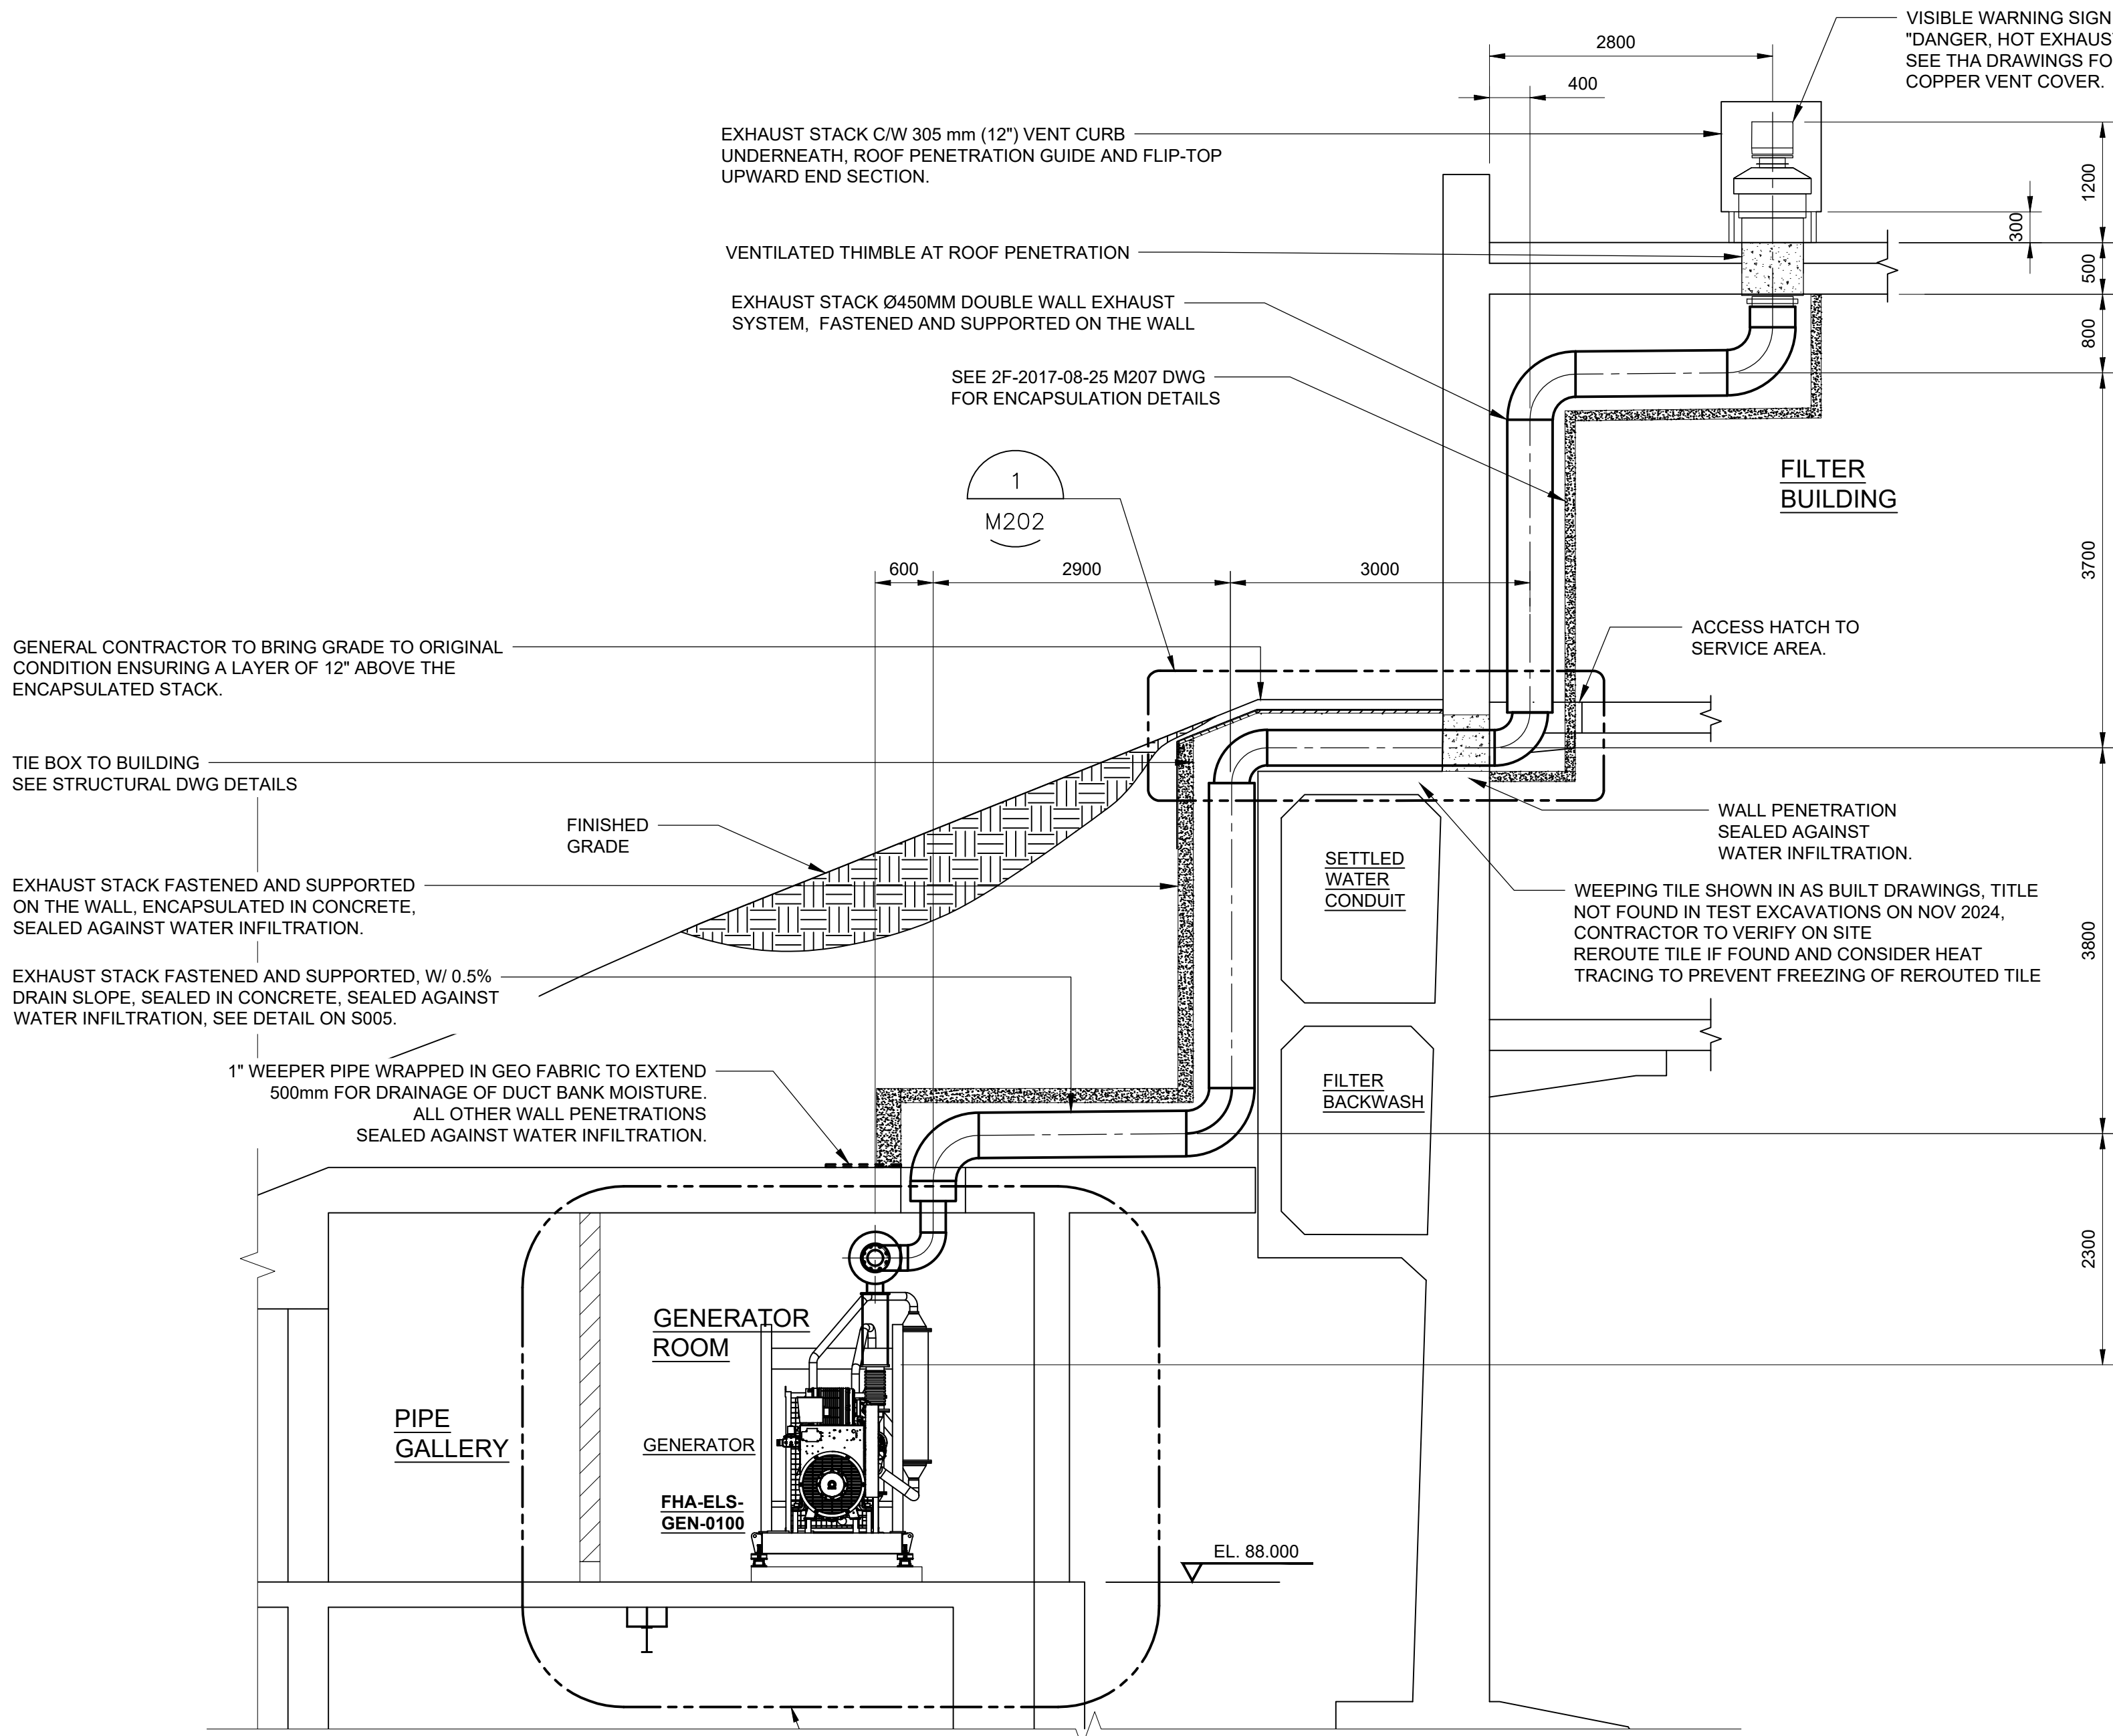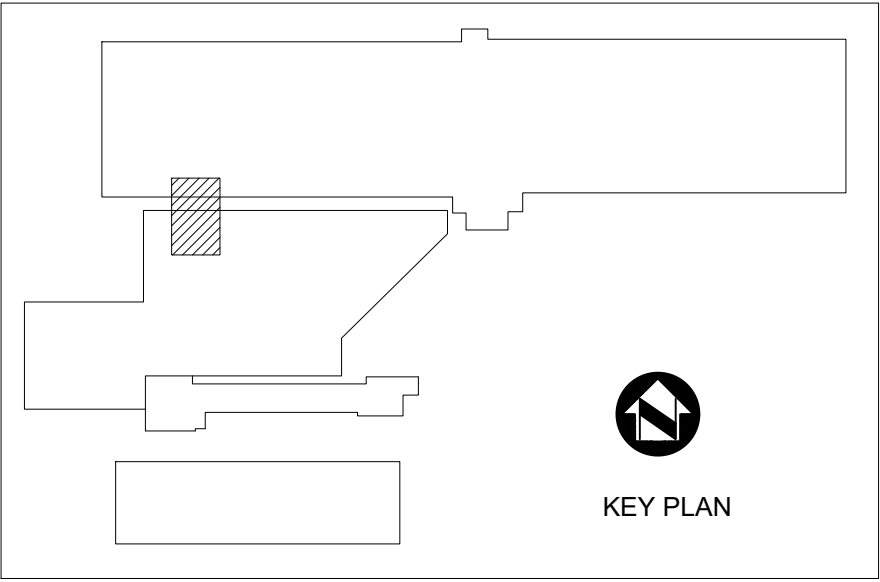

PIPE GALLERY GENERATOR - EXHAUST STACK ELEVATION
SECTION A - M207

1:50

1

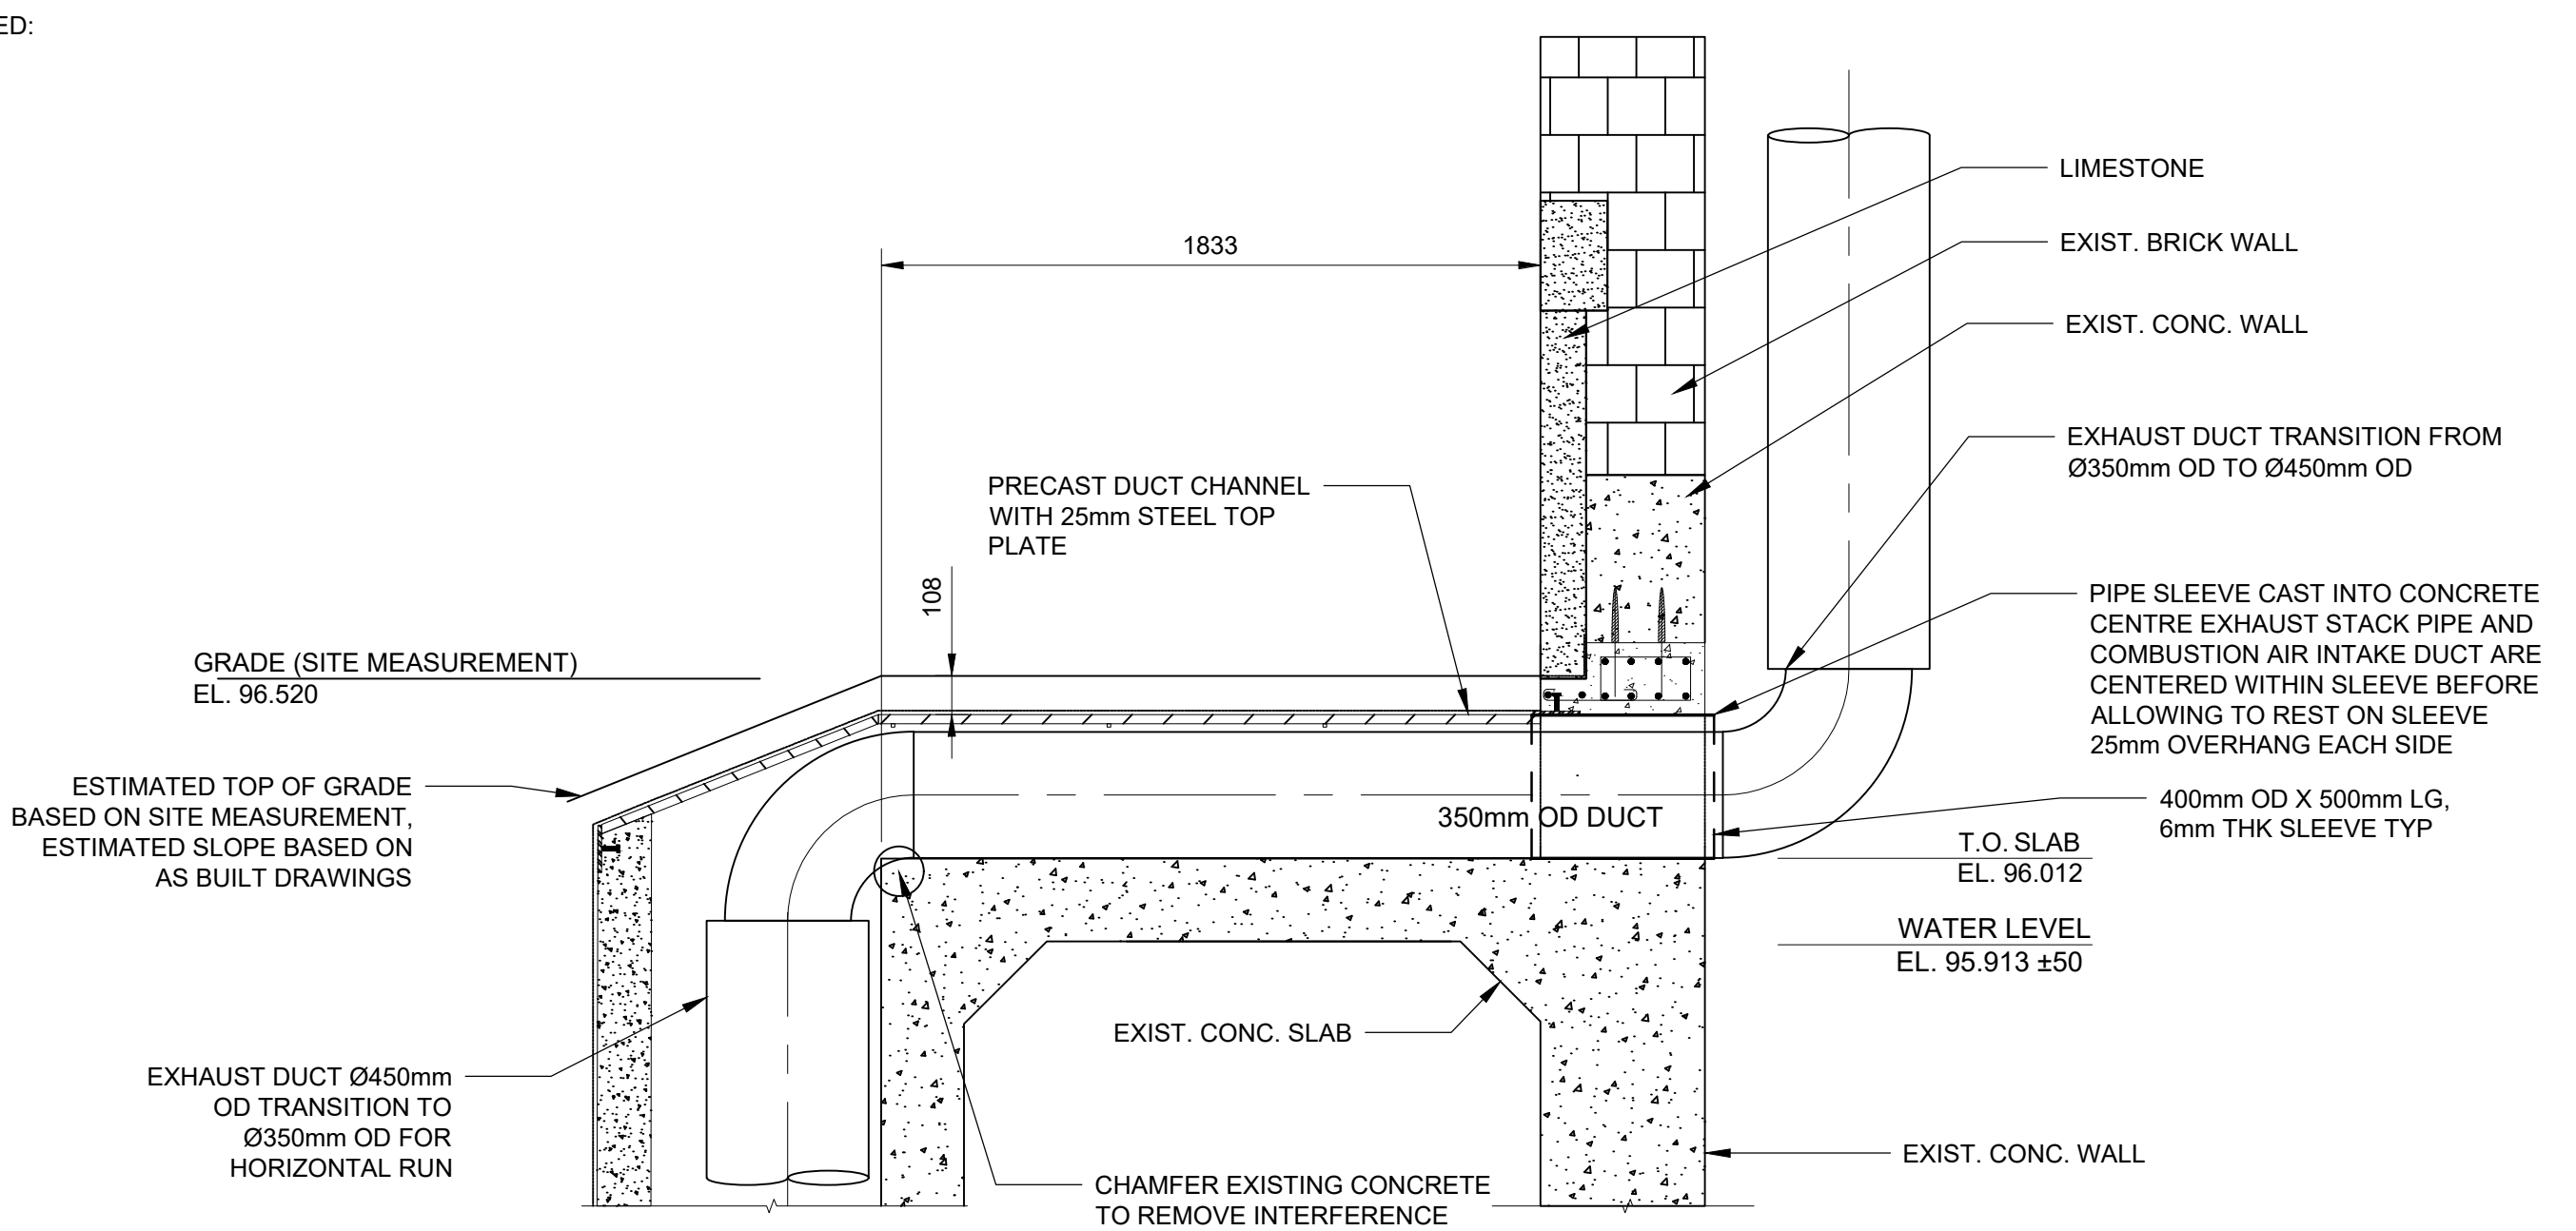


1
M202
FILTER GALLERY WALL PENETRATION DETAIL
SCALE 1:20

- NOTES:
- THE EXHAUST STACK SHALL NOT TERMINATE WITHIN 6 FT (1.8 M) OF AN AIR-SUPPLY INLET
 - A VENT USED IN A SPECIAL VENTING SYSTEM WITH POSITIVE VENT PRESSURE AND PASSING THROUGH THE ROOF SHALL EXTEND AT LEAST 18" (450 mm) AND THE SAME DISTANCE ABOVE ANY OBSTRUCTION WITHIN A HORIZONTAL DISTANCE OF 18" (450 mm).
 - THE EXHAUST STACK SHALL BE LISTED UNDER CSA 760°C (1400°F) INDUSTRIAL CHIMNEYS CAN/ULC-C959
 - EXHAUST STACK TO BE 450 mm (17.75") OD DOUBLE WALL EXHAUST SYSTEM, BASED ON DURAVENT DURASTACK PRO MODEL DIS4/2 C/W SUPPORTS AND ACCESSORIES, OR EQUIVALENT.
 - EXHAUST STACK INSTALLED UNDER GRADE IN PREFABRICATED CONCRETE DUCT BANK AND WATER SEALED.
 - EXHAUST GAS SYSTEM SHALL BE INSTALLED IN ACCORDANCE WITH MANUFACTURER'S INSTRUCTIONS AND LOCAL CODES.
 - ALL EXHAUST STACK SUPPORTS TO BE INSTALLED IN ACCORDANCE WITH MANUFACTURERS RECOMMENDATIONS AND APPLICABLE CODES.
 - CONTRACTOR TO SUPPLY AND INSTALL FRAMING FOR SILENCER SUPPORT, C/W VIBRATION ISOLATORS.
 - ALL PARTS, ACCESSORIES, SUPPORTS AND MATERIALS TO BE SUPPLIED BY THE SAME MANUFACTURER.
 - SEE DWGS S008, S011 & S012 FOR STRUCTURAL DETAILS.
 - ALL DIMENSIONS PROVIDED SHALL BE FIELD VERIFIED BY CONTRACTOR PRIOR TO CARRYING OUT ANY WORK.

Drawing: \\ARCADIS-NL\LOCAL\DFS\AIBL\PA\TORONTO\W16-0273 TOR_HARRISWTP-STANDBYGENERATOR\500_CAD\401-CAD\1-SS OR BU\SHEET\5 MECH\2F-2017-08-24_M202.DWG
Layout by: M202
Date: 03/24/2025 Time: 03:26:35 PM

									TORONTO WATER ENGINEERING AND CONSTRUCTION SERVICES				R.C. HARRIS WATER TREATMENT PLANT INSTALLATION OF A STANDBY GENERATOR FOR CRITICAL LOADS PIPE GALLERY - EXHAUST STACK SECTION, ELEVATION										
 100-175 GALAXY BOULEVARD TORONTO, ONTARIO, M9W 0C9 TEL 416 679 1930 FAX 416 675 4620 www.arcadis.com		COPYRIGHT: This drawing has been prepared solely for the intended use, thus any reproduction or distribution for any purpose other than authorized by ARCADIS is forbidden. Written dimensions shall have precedence over scaled dimensions. Contractors shall verify and be responsible for all dimensions and conditions on the job, and ARCADIS shall be informed of any variations from the dimensions and conditions shown on the drawing. Shop drawings shall be submitted to IRI Group for general conformance before proceeding with fabrication.							WILLIAM FERNANDES, P. ENG. DIRECTOR, WATER TREATMENT AND SUPPLY		SIMON HOPTON, P. ENG. DIRECTOR DESIGN & CONSTRUCTION MAJOR INFRASTRUCTURE		MECHANICAL										
		A		2025-03-18		ISSUED FOR TENDER							K.C.		DESIGN:	J.S.	DRAFTING:	J.S.	CHECK:	J.H.	CONTRACT No.	25ECS-MI-03HA	
		NO.		DATE		REVISIONS							INITIAL		SIGNED		SCALE:	1:50		DRAWING NUMBER:	2F-2017-08-24		M202
																	DATE:		2024-09-30				
		ARCADIS Professional Services (Canada) Inc.																					

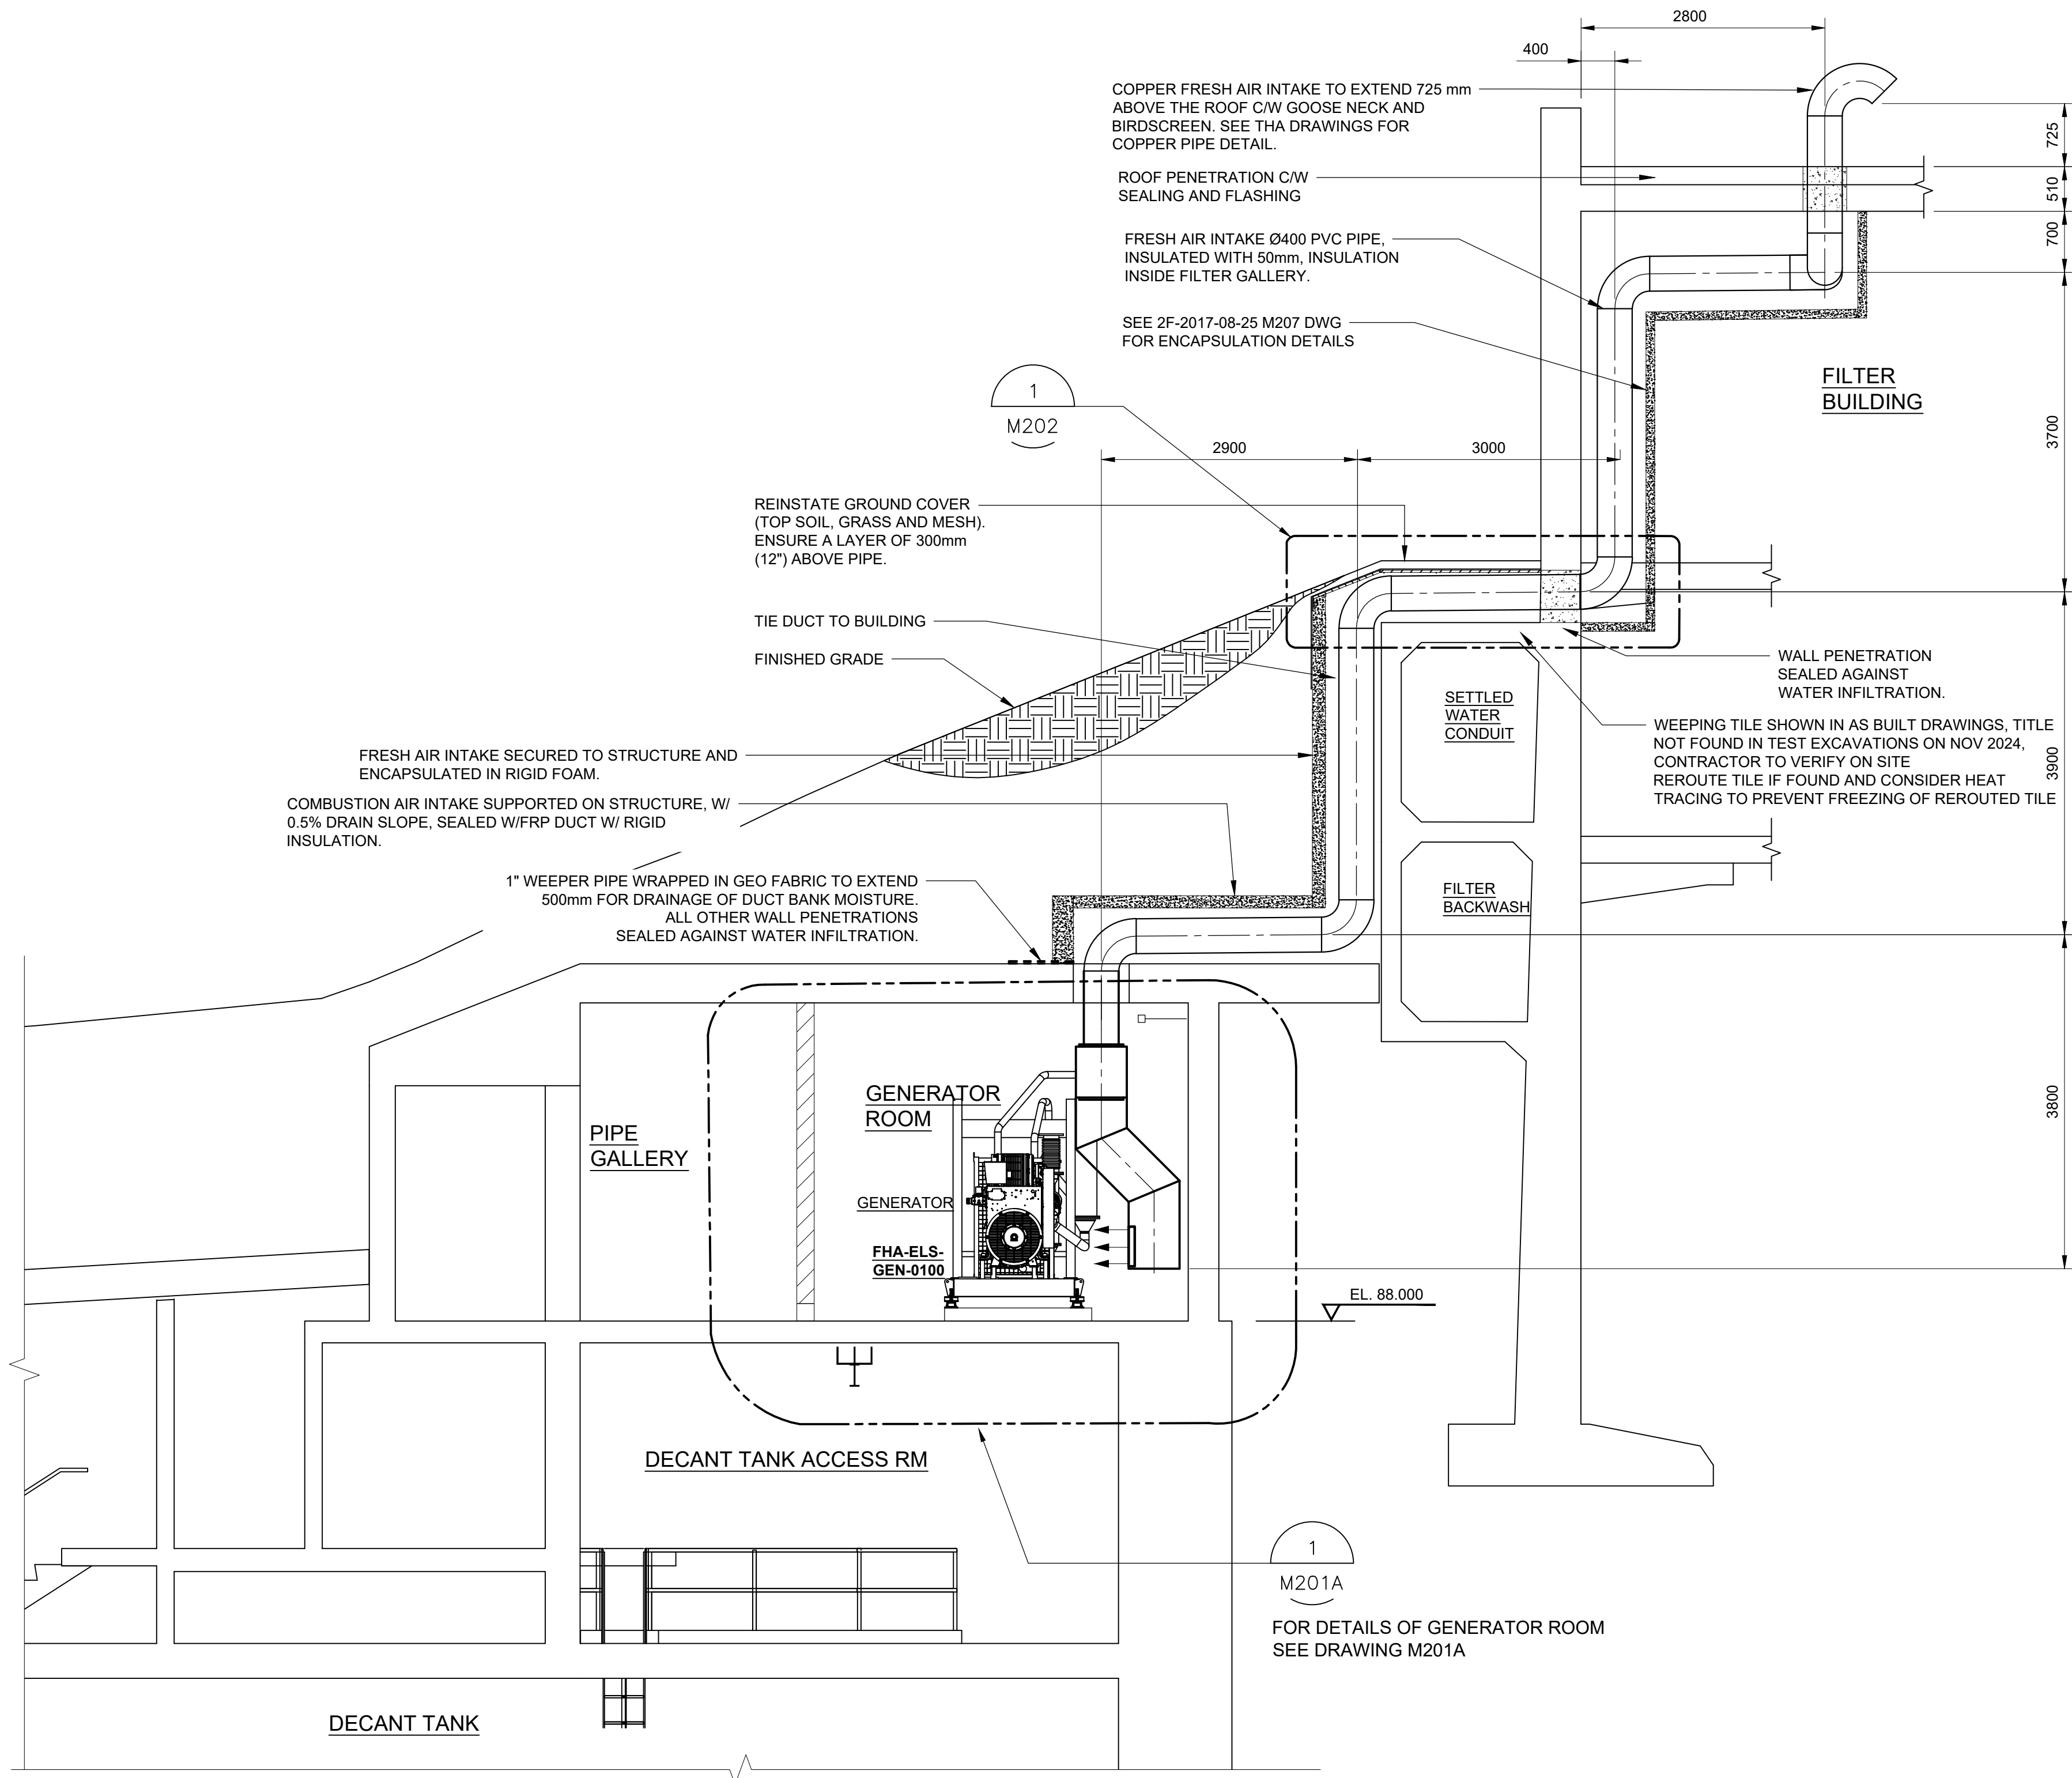



- NOTES:
- THE FRESH AIR INTAKE SHALL BE AT LEAST 16.4 FT (5 M) AWAY FROM ANY GENERATOR EXHAUST VENT.
 - ALL DIMENSIONS ARE APPROXIMATE, TO BE CONFIRMED BY THE CONTRACTOR BEFORE ORDERING OR CONSTRUCTION.
 - ALL DIMENSIONS PROVIDED SHALL BE FIELD VERIFIED BY CONTRACTOR PRIOR TO CARRYING OUT ANY WORK

PIPE GALLERY GENERATOR - FRESH AIR INTAKE
SECTION B - M207

1:50

1

												TORONTO WATER		R.C. HARRIS WATER TREATMENT PLANT INSTALLATION OF A STANDBY GENERATOR FOR CRITICAL LOADS PIPE GALLERY - COMBUSTION AIR INTAKE SECTION, ELEVATION					
												ENGINEERING AND CONSTRUCTION SERVICES							
 100-175 GALAXY BOULEVARD TORONTO, ONTARIO, M9W 9C9 TEL 416 679 1930 FAX 416 675 4620 www.arcadis.com		COPYRIGHT: This drawing has been prepared solely for the intended use, thus any reproduction or distribution for any purpose other than authorized by ARCADIS is forbidden. Written dimensions shall have precedence over scaled dimensions. Contractors shall verify and be responsible for all dimensions and conditions on the job, and ARCADIS shall be informed of any variations from the dimensions and conditions shown on the drawing. Shop drawings shall be submitted to the Group for general conformance before proceeding with fabrication.						WILLIAM FERNANDES, P. ENG. DIRECTOR, WATER TREATMENT AND SUPPLY		SIMON HOPTON, P. ENG. DIRECTOR DESIGN & CONSTRUCTION MAJOR INFRASTRUCTURE									
												MECHANICAL							
												DESIGN:	J.S.	DRAFTING:	J.S.	CHECK:	J.H.	CONTRACT No. 25ECS-MI-03HA	
												SCALE:	1:50		DRAWING NUMBER:		2F-2017-08-25		M203
												DATE:		2024-09-30					

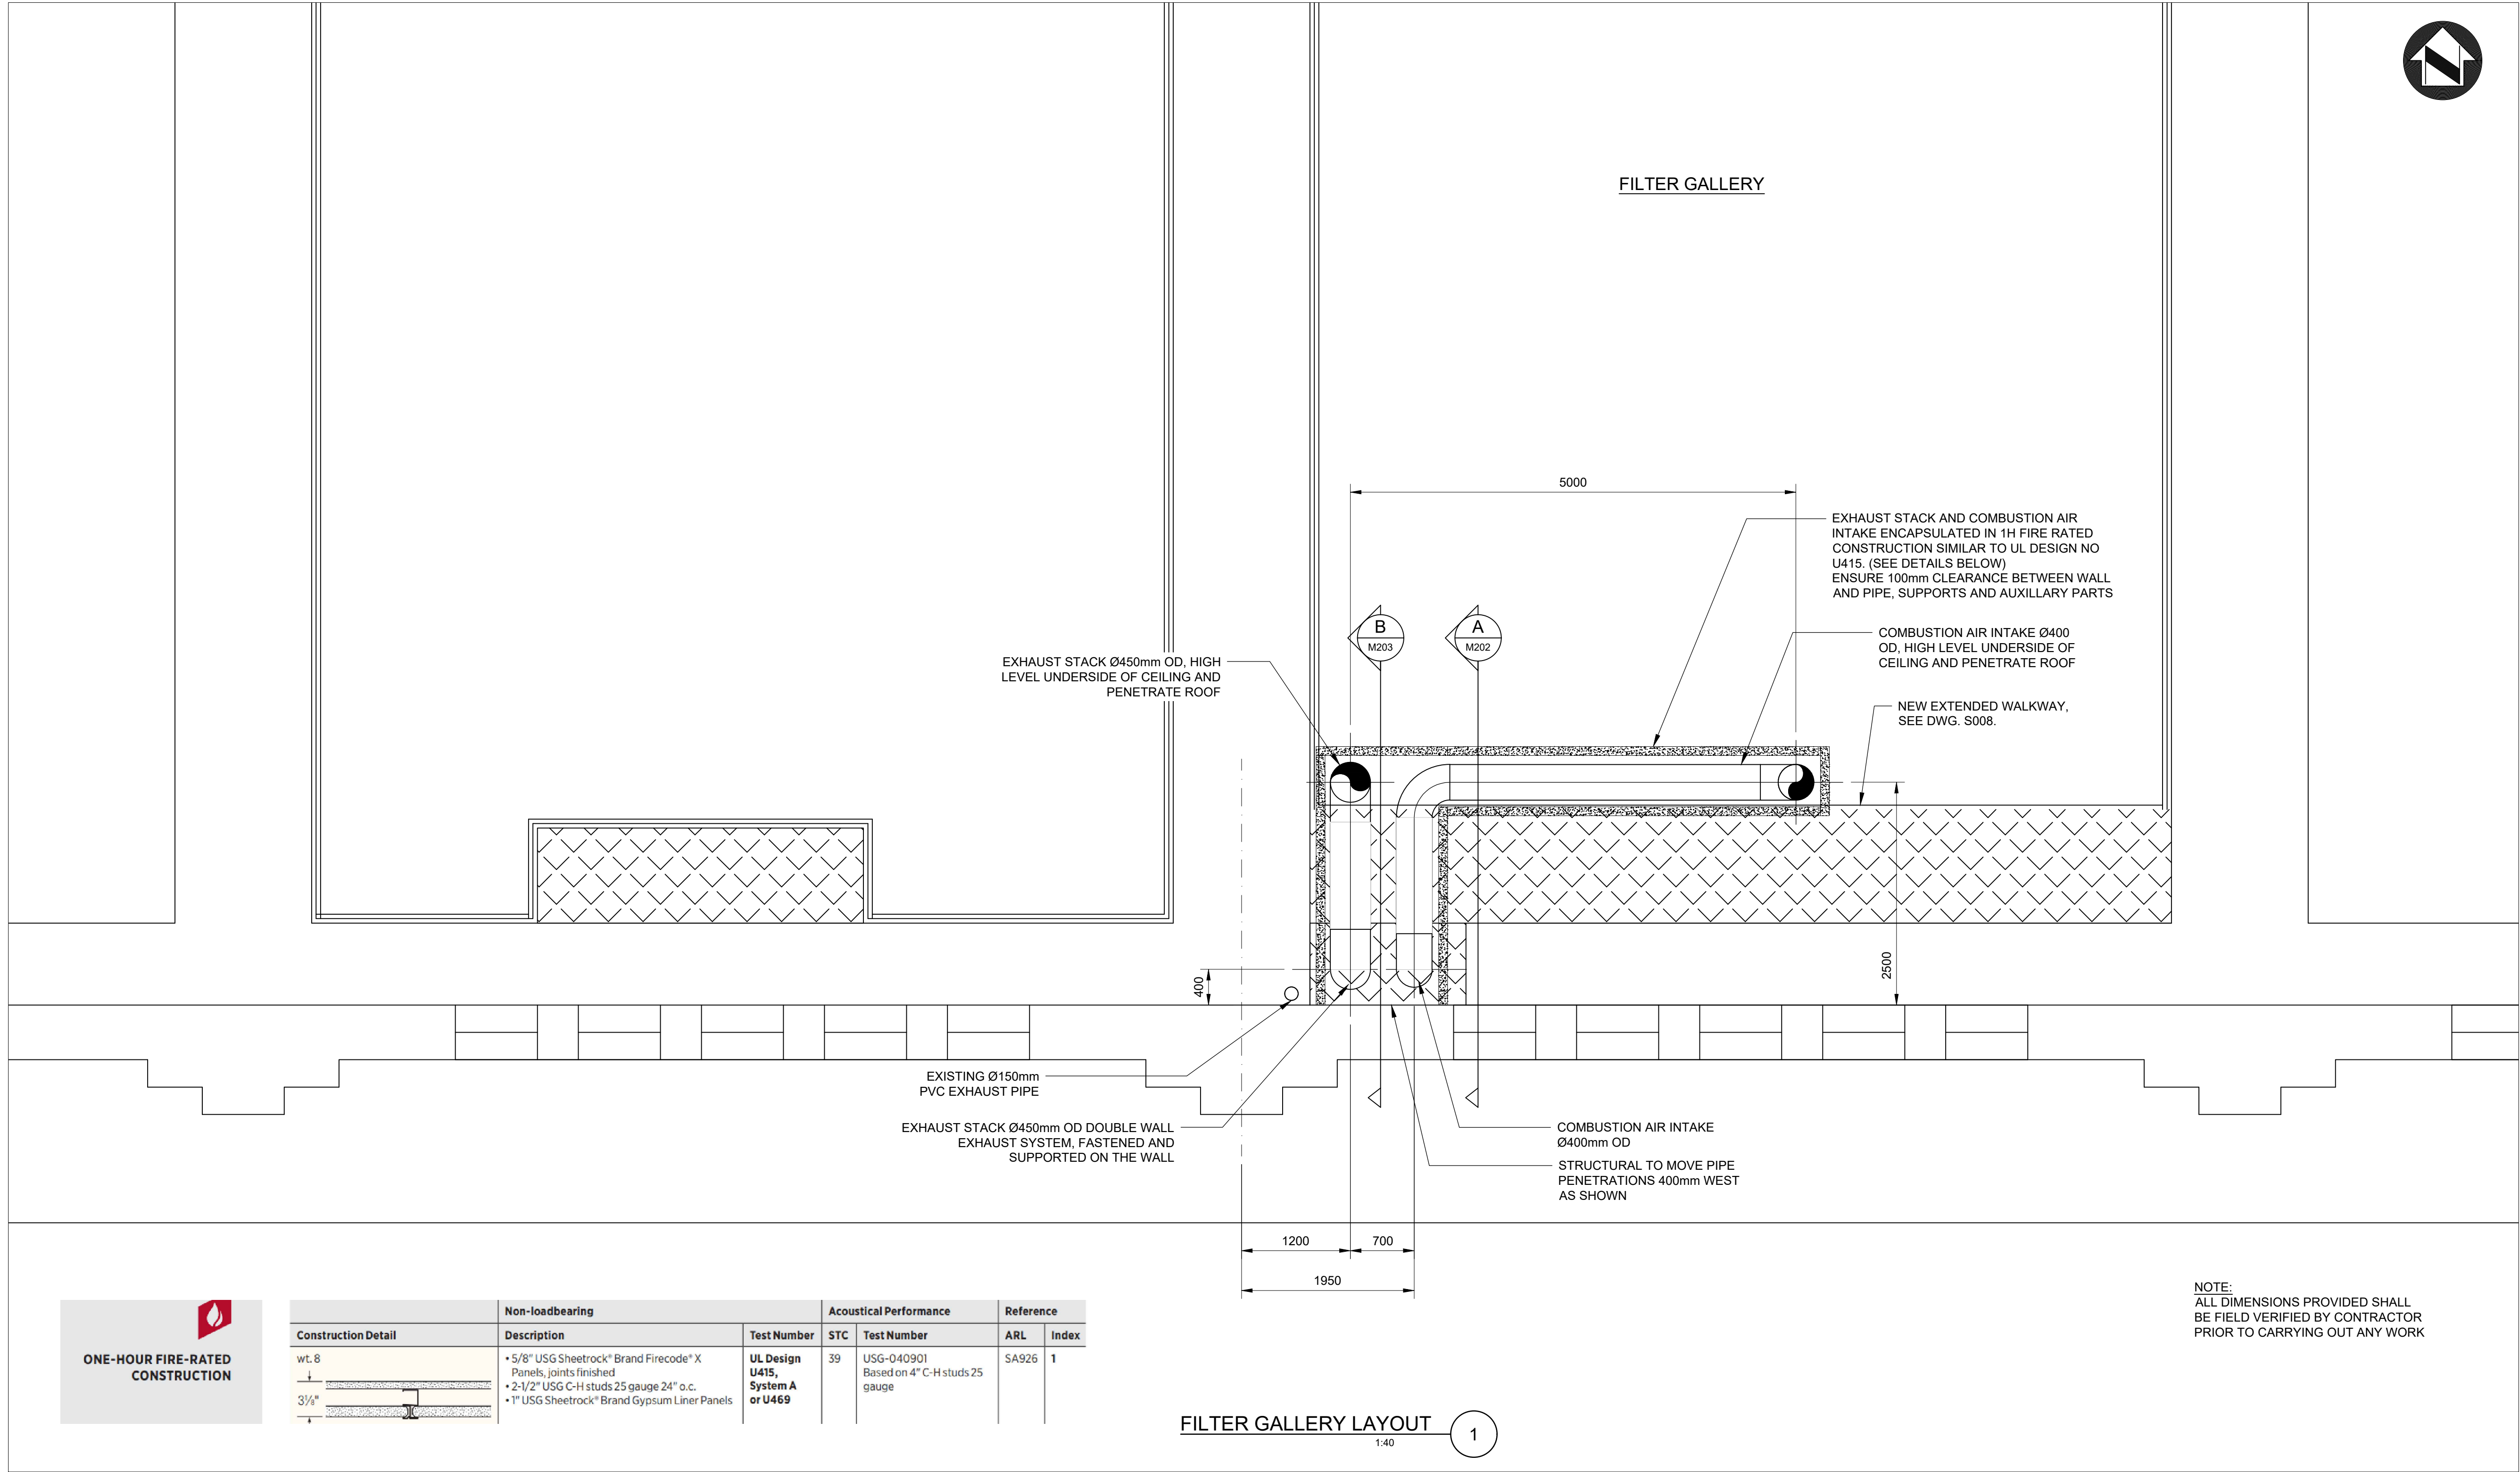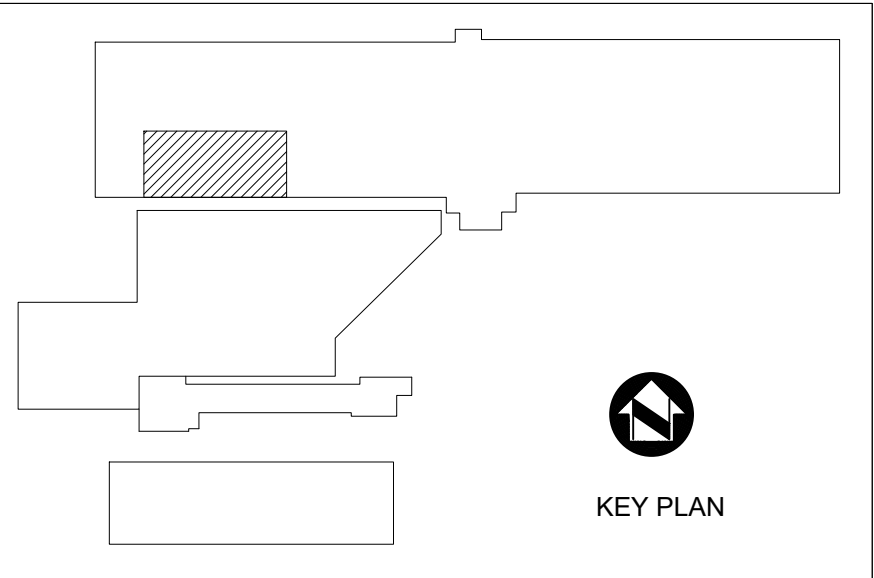


Non-loadbearing			Acoustical Performance		Reference	
Construction Detail	Description	Test Number	STC	Test Number	ARL	Index
wt. 8 3 1/4"	• 5/8" USG Sheetrock® Brand Firecode® X Panels, joints finished. • 2-1/2" USG C-H studs 25 gauge 24" o.c. • 1" USG Sheetrock® Brand Gypsum Liner Panels	UL Design U415, System A or U469	39	USG-O40901 Based on 4" C-H studs 25 gauge	SA926	1

NOTE:
ALL DIMENSIONS PROVIDED SHALL
BE FIELD VERIFIED BY CONTRACTOR
PRIOR TO CARRYING OUT ANY WORK

FILTER GALLERY LAYOUT
1:40

1

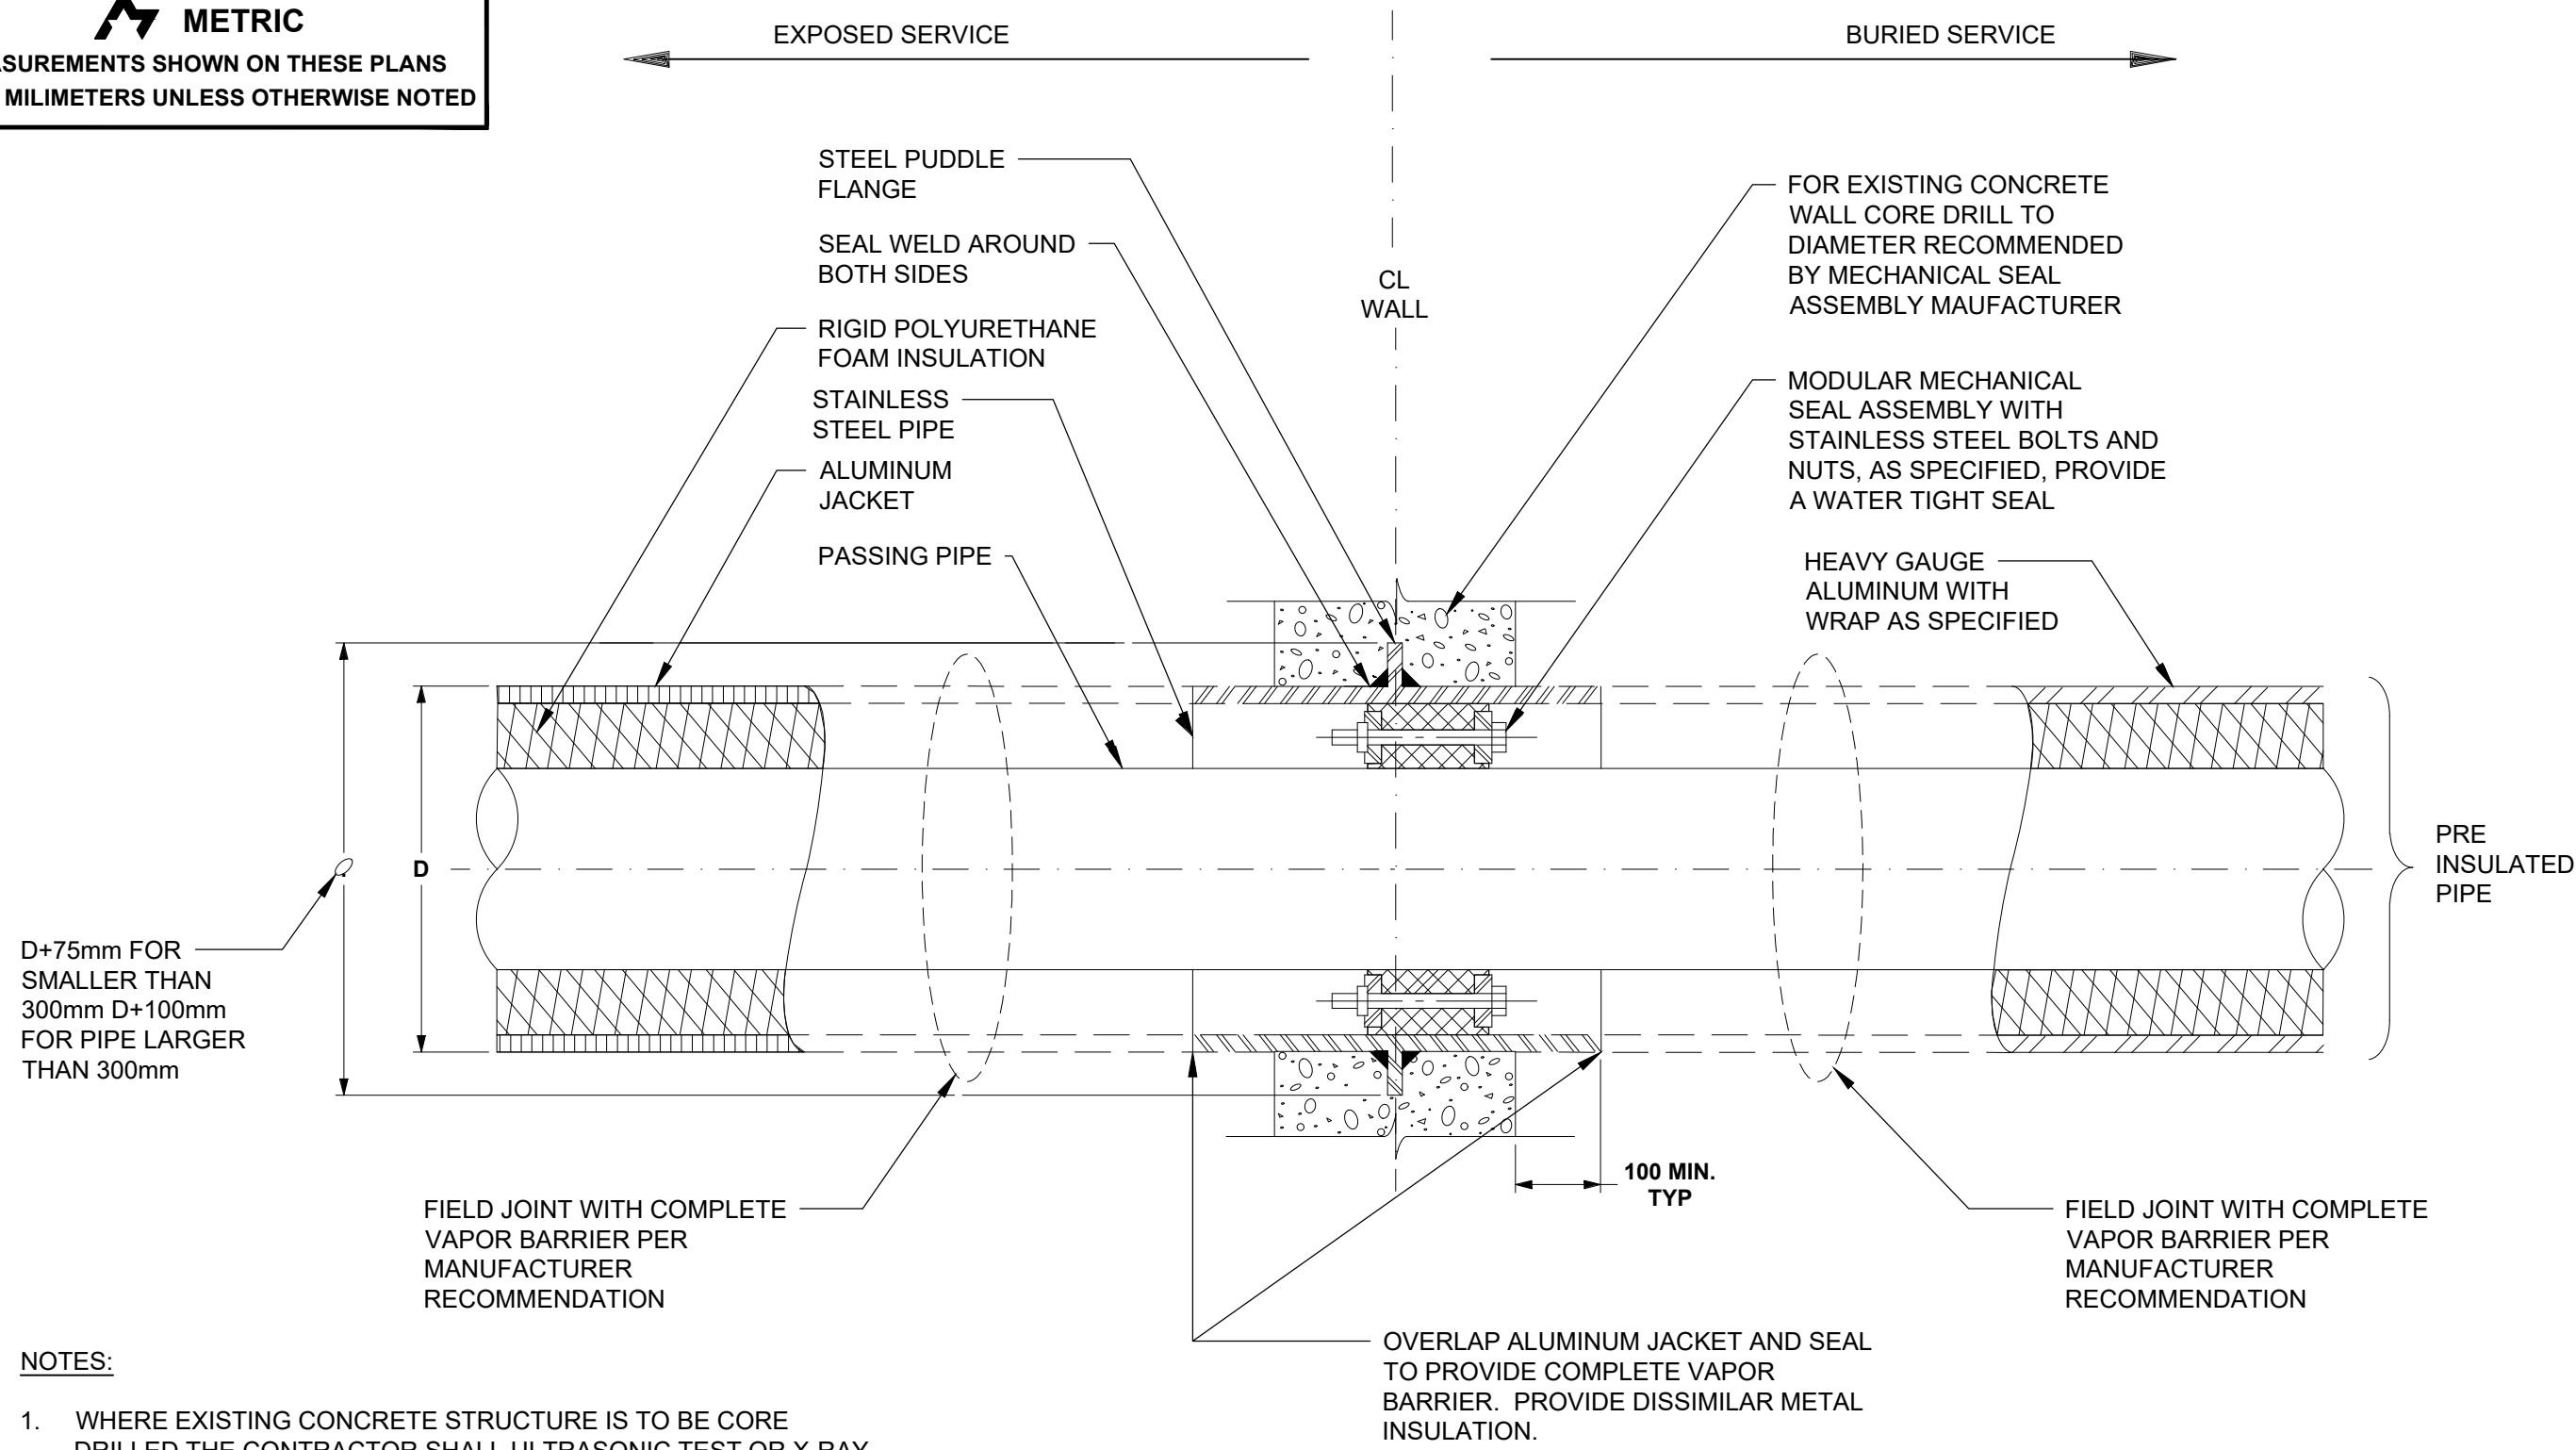


- NOTES:
- WHERE EXISTING CONCRETE STRUCTURE IS TO BE CORE DRILLED, THE CONTRACTOR SHALL ULTRASONIC TEST OR X-RAY THE AREA FOR EMBEDDED ITEMS BEFORE CORE DRILLING CAN PROCEED.
 - IF EMBEDDED ITEMS ARE FOUND, NOTIFY SITE SUPERVISOR IMMEDIATELY.

WALL PENETRATION SEAL

N.T.S.

1

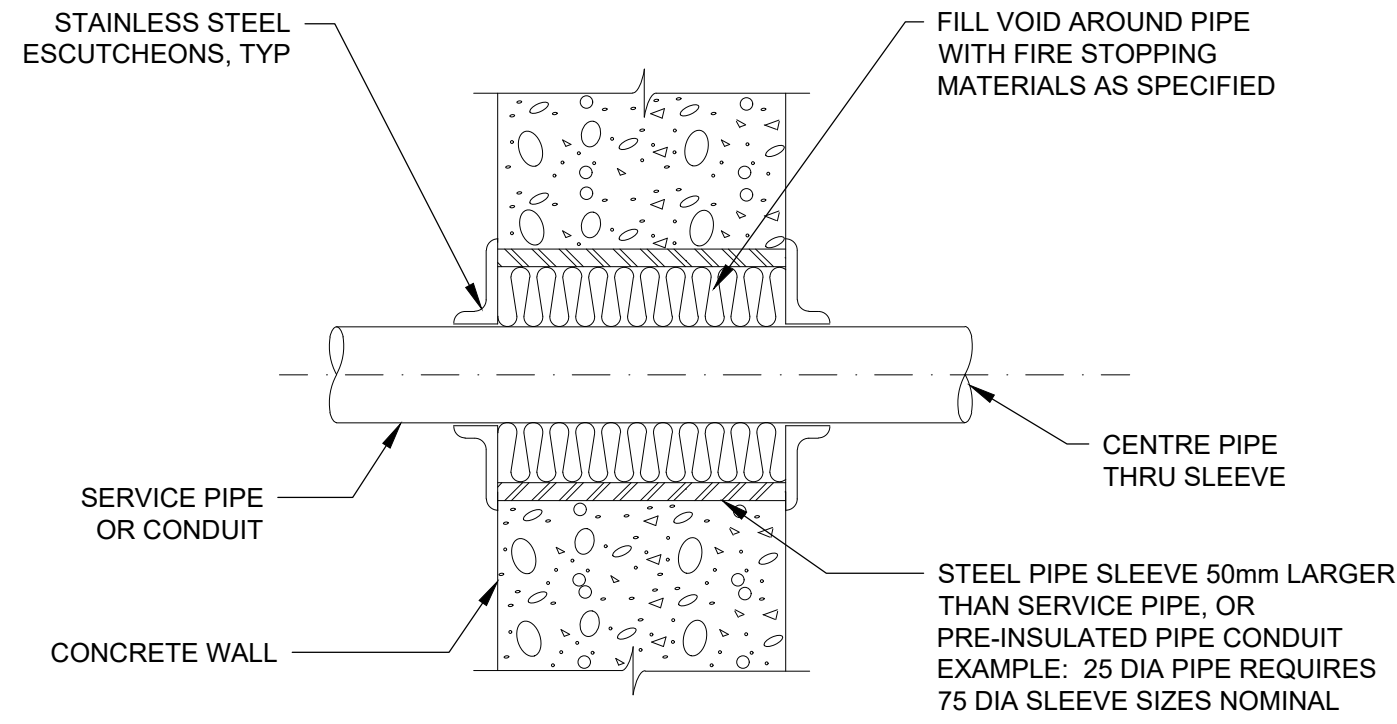


NOTES:

- DETAIL APPLIES TO PRE-INSULATED PIPE

PIPE WALL PENETRATION

N.T.S.


2

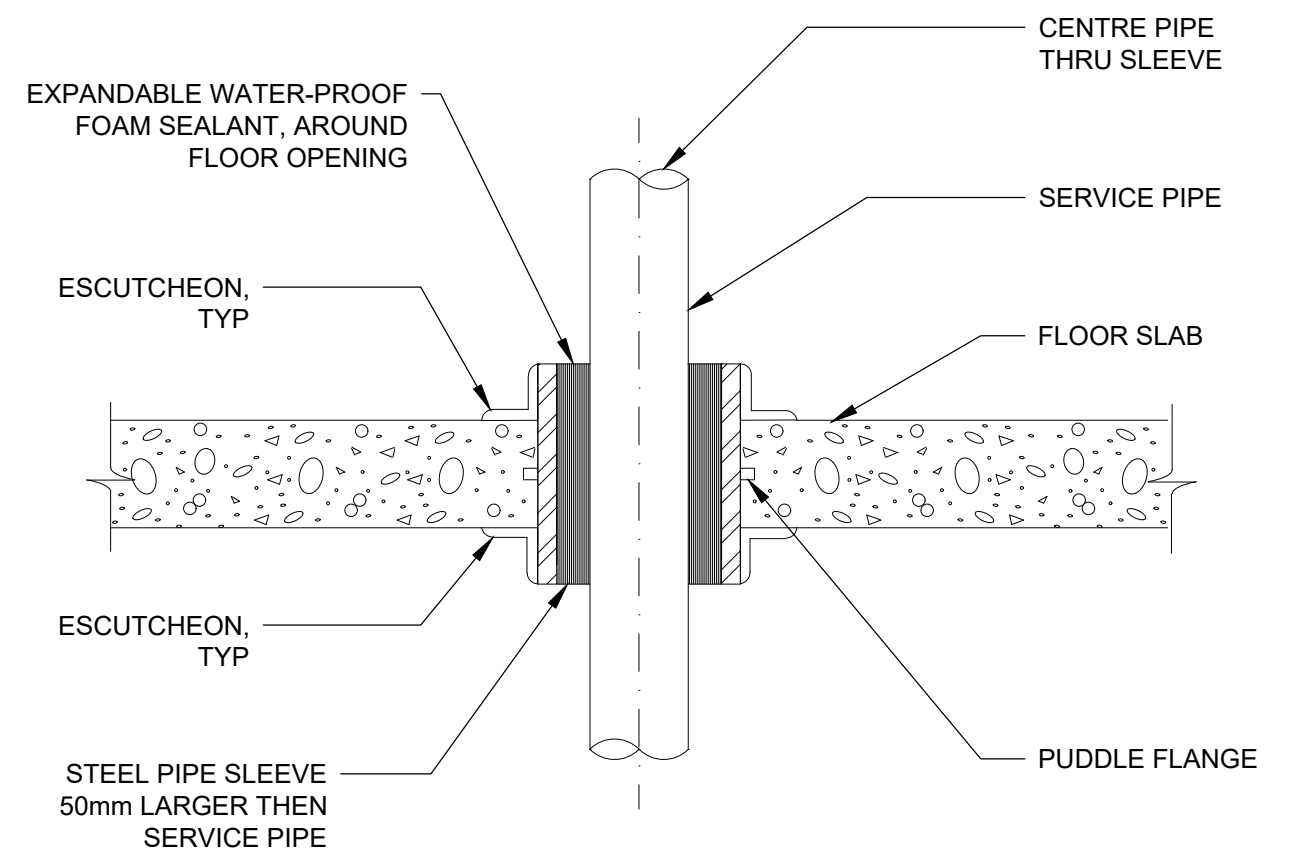

PIPE FLOOR PENETRATION

N.T.S.

3

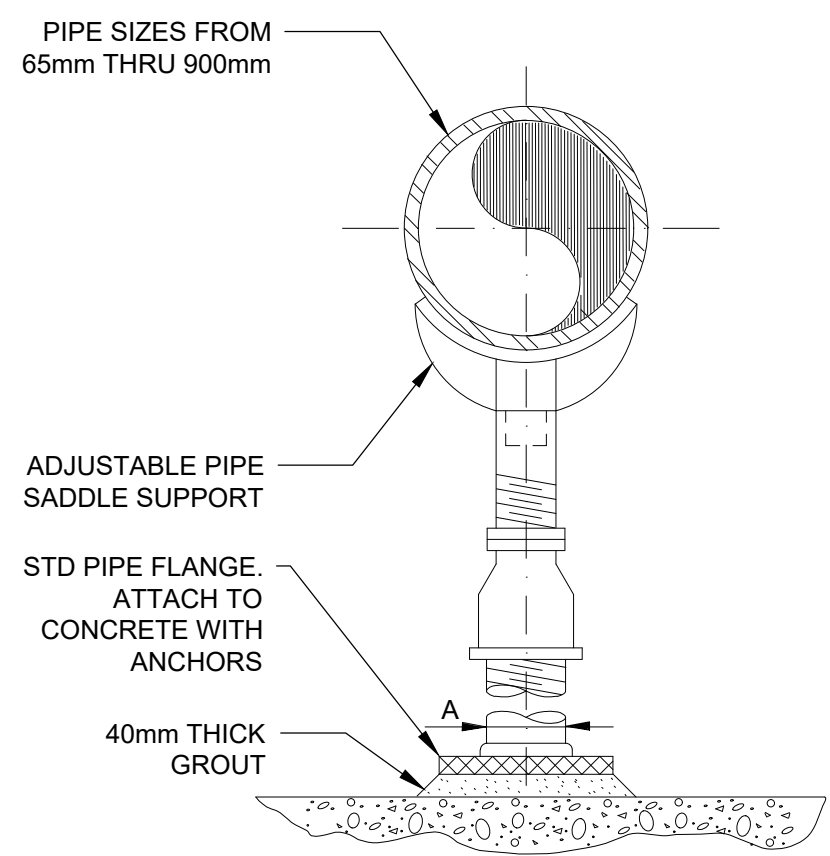


DIMENSION TABLE	
PIPE SIZE (DIA)	A (DIA)
65	65
80	65
100	75
150	75
200	75
250	75
300	75
350	100
400	100
500	150
600	150
750	150
900	150


PIPE SUPPORT - FLOOR MOUNTED

N.T.S.

4

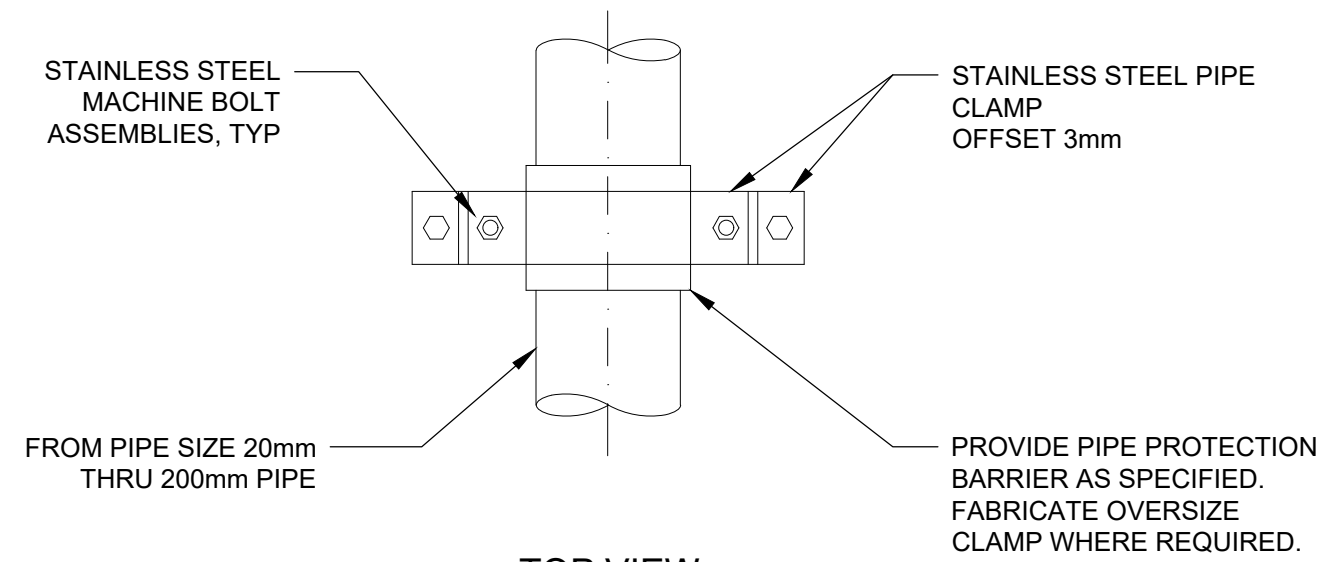

TOP VIEW

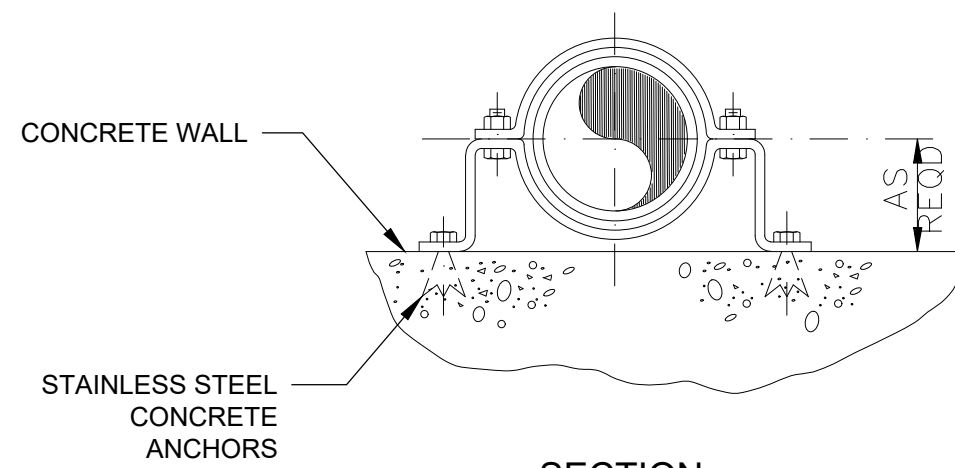


SECTION

PIPE SUPPORT - VERTICAL WALL MOUNTED

N.T.S.

5

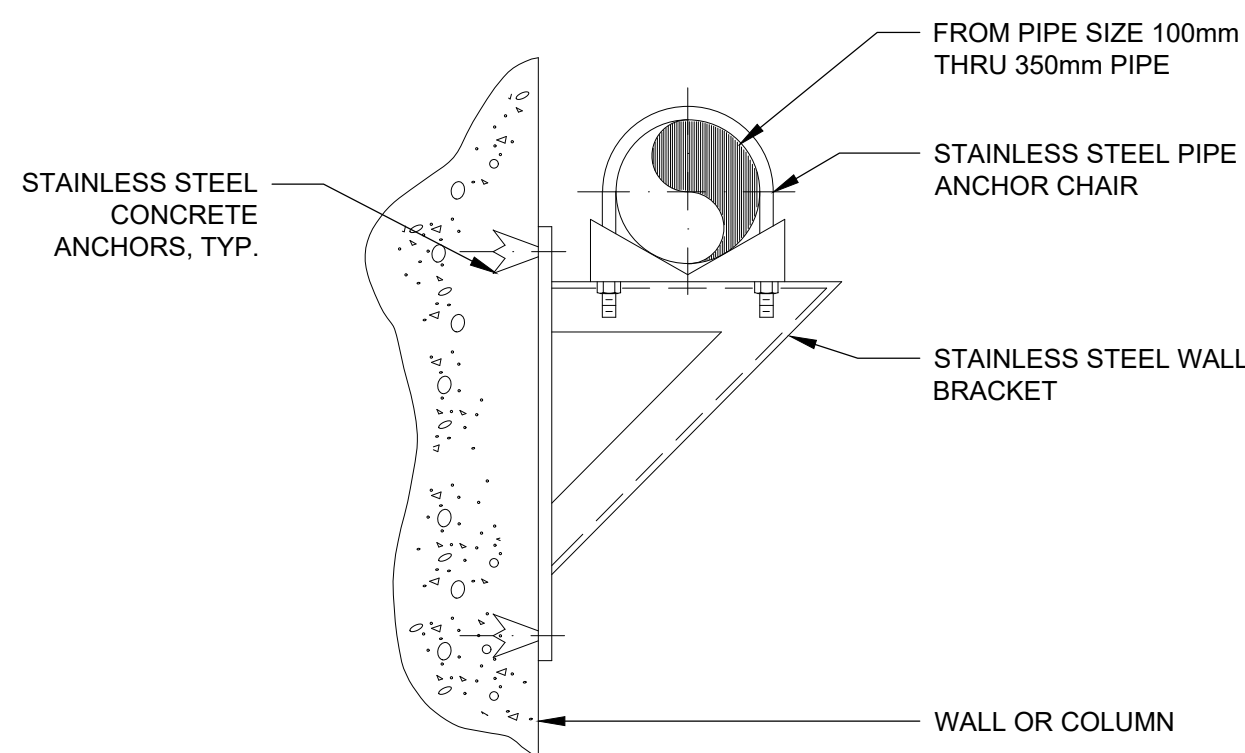


NOTES:

- WALL BRACKET SHALL BE MEDIUM OR HEAVY DUTY DEPENDING ON PIPE LOAD REQUIREMENTS.
- NOT FOR USE WITH PVC PIPE.

PIPE SUPPORT - HORIZONTAL WALL MOUNTED


N.T.S.

6

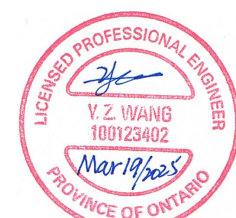


Drawing: \\ARCADIS-NTLOCAL\DFS\AIBL\PA\TORONTO\16-0273 TOR_HARRISWTP-STANDBYGENERATOR\500_CAD\401-CAD\1-SS OR BU\SHEET\5 MECH\2F-2017-08-28_M209.DWG
Layout tab: M209
Date: 03/24/2025 Time: 03:27:46 PM


METRIC
MEASUREMENTS SHOWN ON THESE PLANS
ARE IN MILLIMETERS UNLESS OTHERWISE NOTED

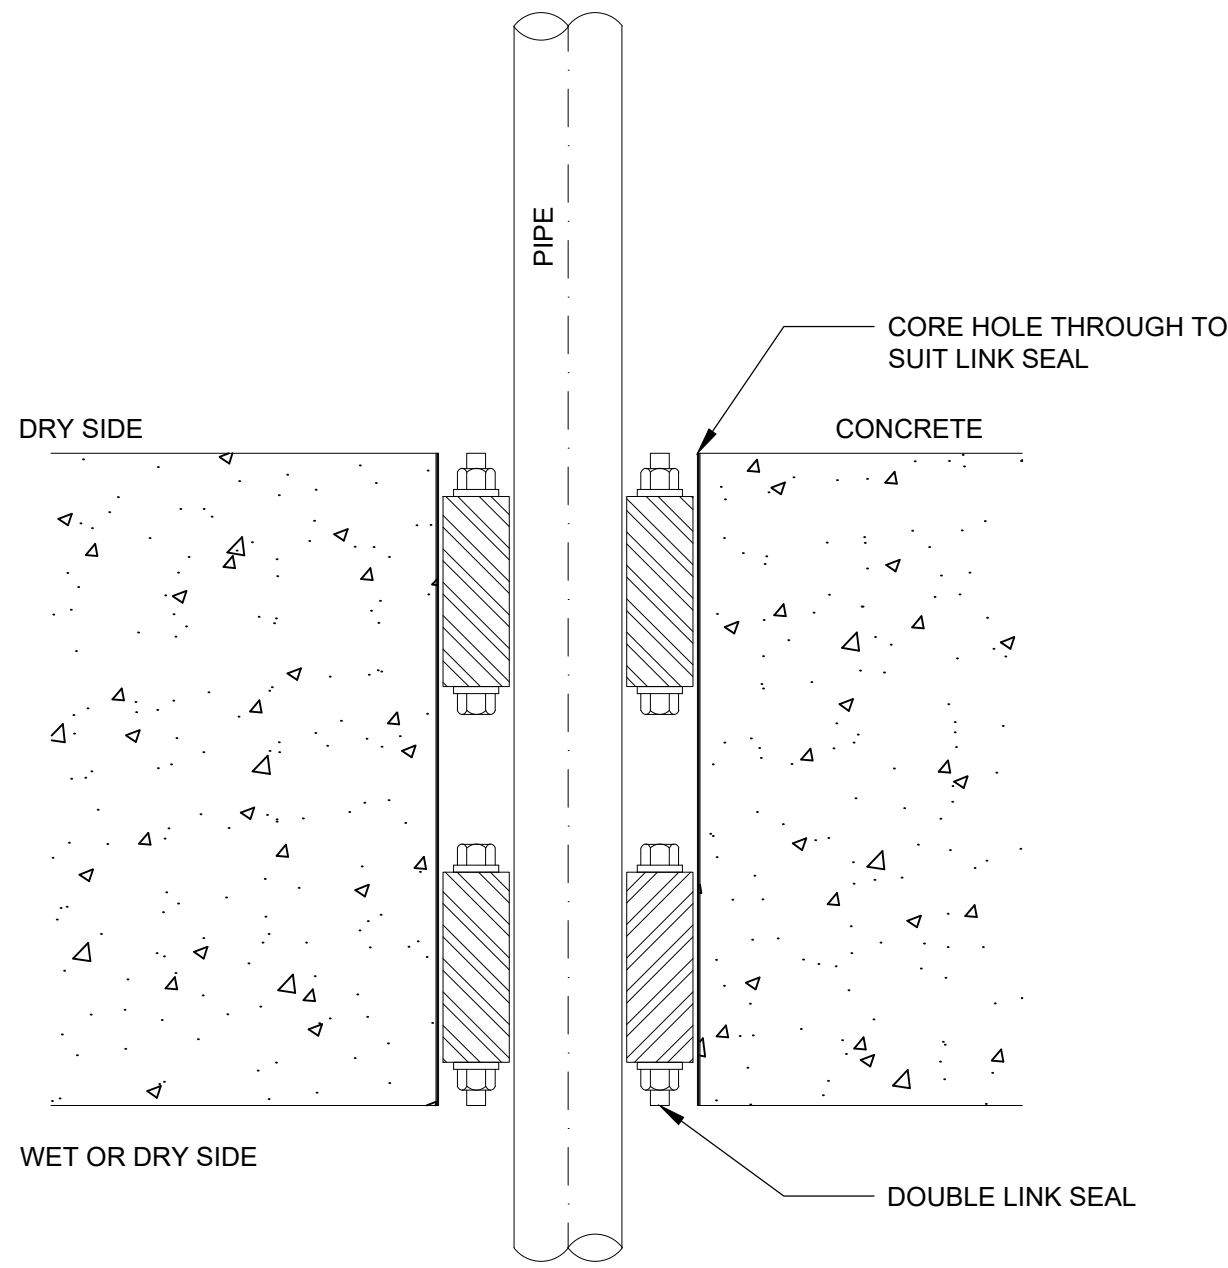

PIPE THROUGH FLOOR OR WALL W/ DOUBLE LINK SEAL
N.T.S. 1

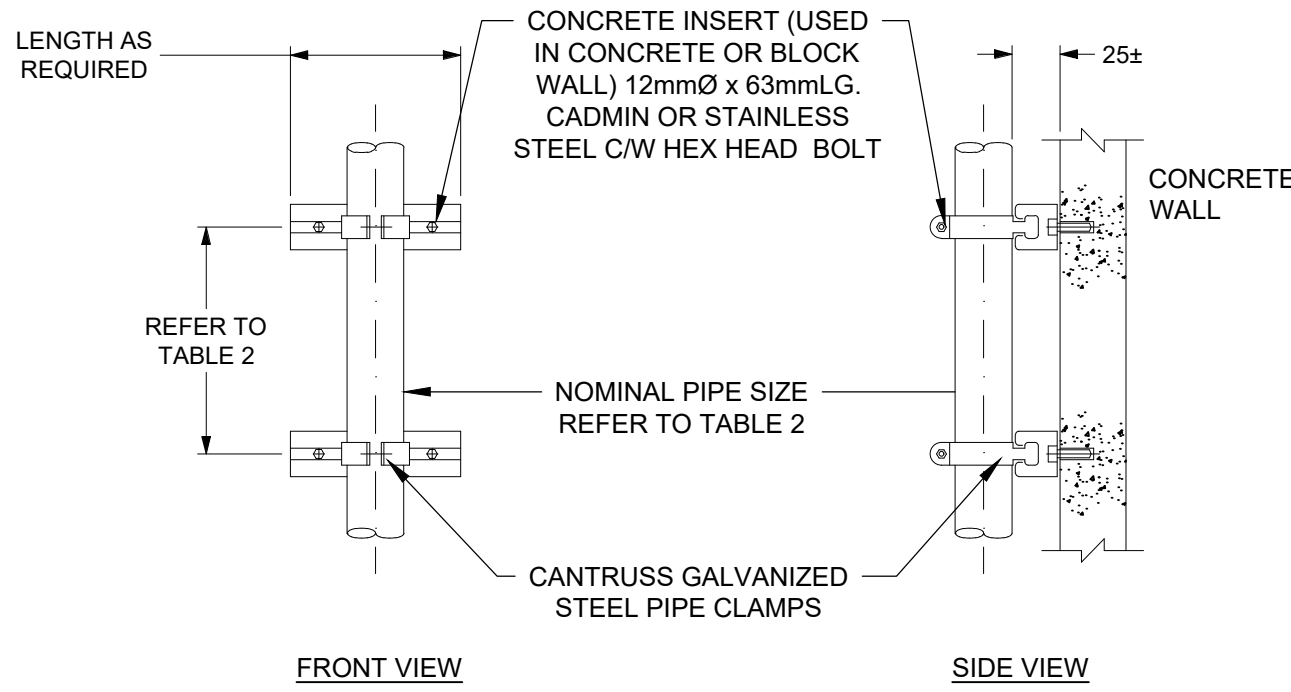

PIPE SUPPORT SPACING
N.T.S. 2

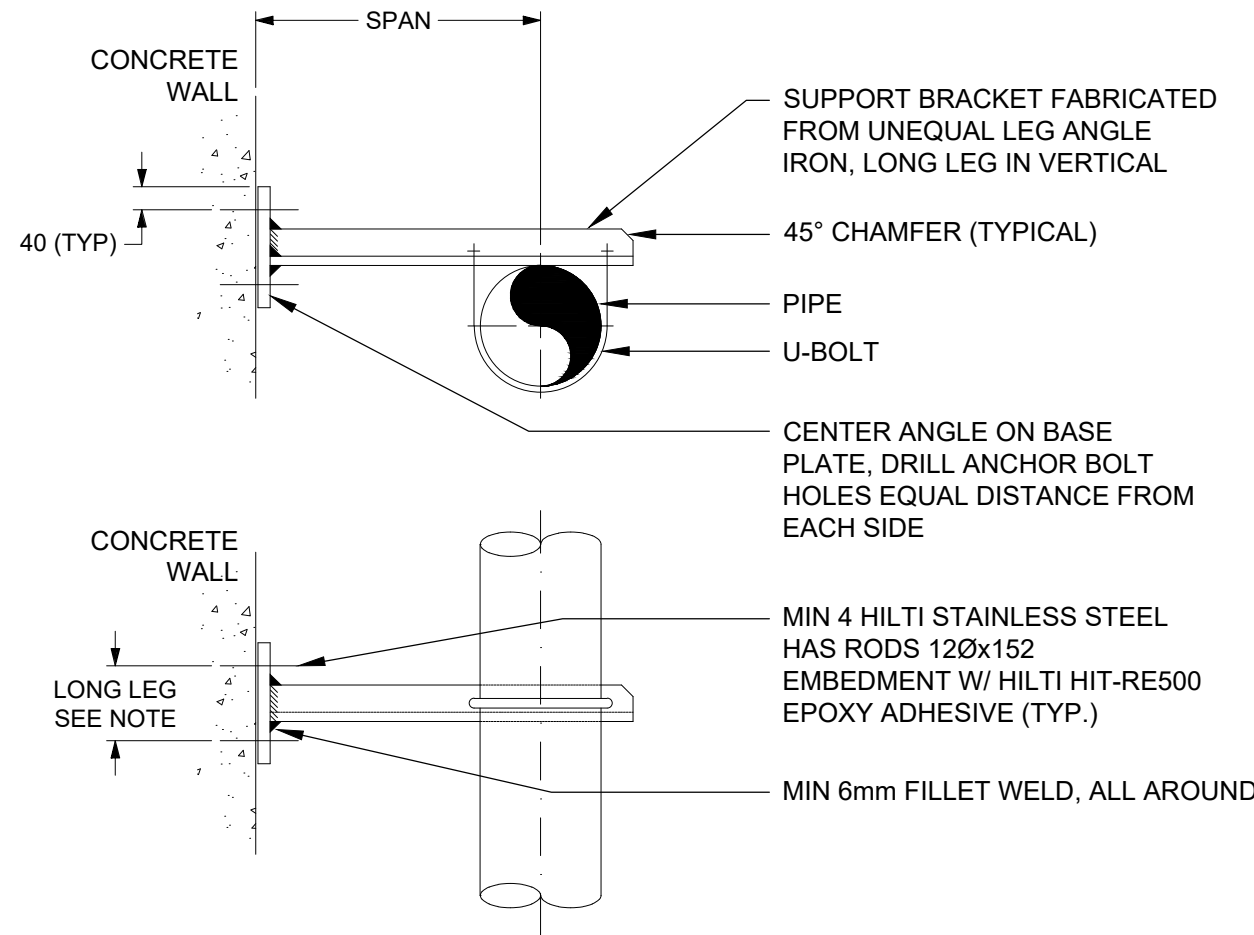


NOTES:

- CONCRETE INSERTS - 454kg. MAXIMUM RECOMMENDED LOAD IN GOOD CONCRETE PER INSERT ADJUST TO SUIT APPLICATION
- APPLICABLE FOR PIPES WALL MOUNTED IN THE HORIZONTAL OR VERTICAL POSITION
- REFER TO U-BOLT MANUFACTURERS DATA FOR CORRECT SIZE AND RECOMMENDED LOAD
- SAFE TOTAL LOAD IN KILOGRAMS WITH A MAXIMUM DEFLECTION OF 6mm
- ALL MATERIALS TO BE 316 STAINLESS STEEL, GRADE 2D
- FOR PVC PIPE USE 316 STAINLESS STEEL PIPE CLAMPS

ANGLE	150x100x10
BASE PLATE	300x200x10
RODS	12Øx135

PIPE SUPPORT
N.T.S. 3

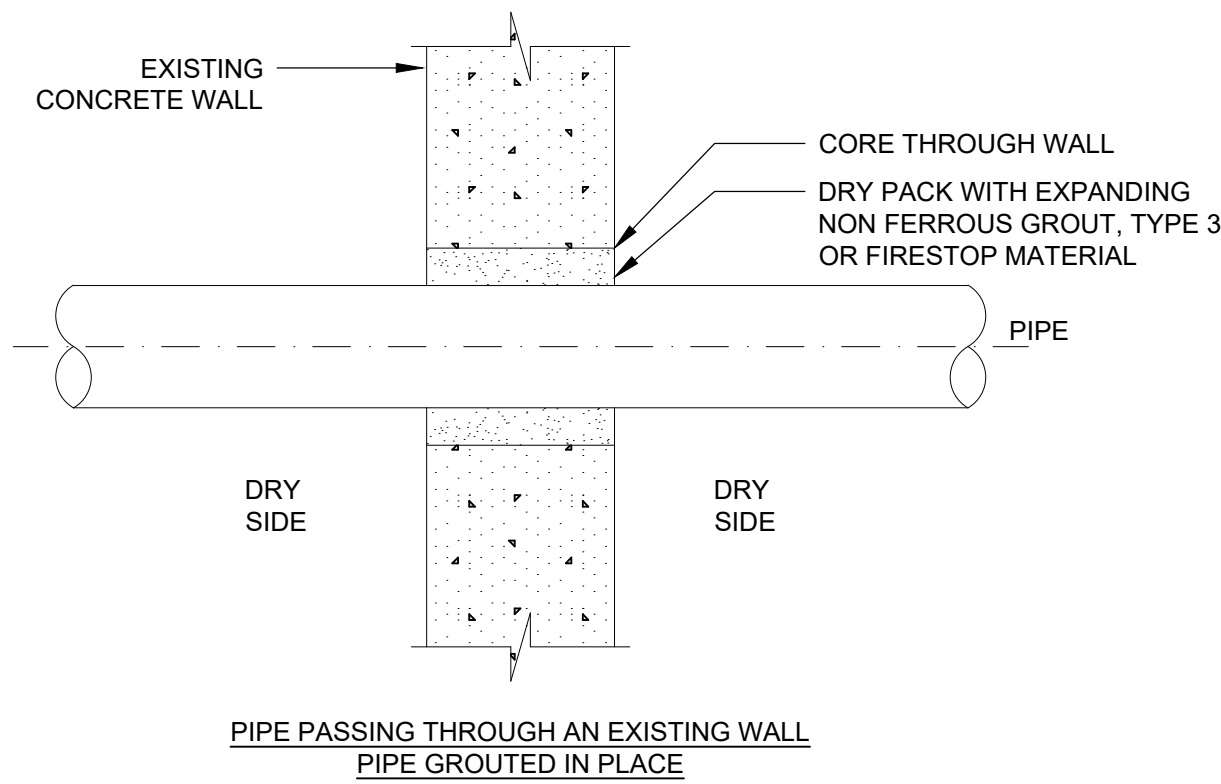

PIPE WALL PENETRATION
N.T.S. 4

TABLE 2:

NOMINAL PIPE DIA. (mm)	MAXIMUM DISTANCE BETWEEN PIPE SUPPORTS		
	STAINLESS STEEL	COPPER	PLASTIC
10 TO 20	1500	1500	CONTINUOUS
25	1500	1500	1500
32	1500	1500	1500
38	1500	1500	1500
50	3000	1500	1500
65	3000	1500	1500
75	3000	3000	1500
100	3000	3000	1500
150	4500	3000	1500

PIPE SUPPORT SPACING CHART
N.T.S. 5

Toronto Water

ARCADIS
100-175 GALAXY BOULEVARD
TORONTO, ONTARIO, M9W 9C9
TEL 416 679 1930 FAX 416 675 4620
www.arcadis.com

COPYRIGHT:
This drawing has been prepared solely for the intended use, thus any reproduction or distribution for any purpose other than authorized by ARCADIS is forbidden. Within dimensions shall have precedence over scaled dimensions. Contractors shall verify and be responsible for all dimensions and conditions on the job, and ARCADIS shall be informed of any variations from the dimensions and conditions shown on the drawing. Shop drawings shall be submitted to IBI Group for general conformance before proceeding with fabrication.
ARCADIS Professional Services (Canada) Inc.

A **2025-03-18**

ISSUED FOR TENDER

K.C


NO. **DATE**

REVISIONS

INITIAL

SIGNED

Toronto

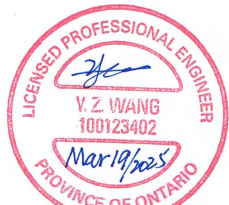


WILLIAM FERNANDES, P. ENG.
DIRECTOR,
WATER TREATMENT AND SUPPLY

SIMON HOPTON, P. ENG.
DIRECTOR
DESIGN & CONSTRUCTION
MAJOR INFRASTRUCTURE


R.C. HARRIS WATER TREATMENT PLANT
INSTALLATION OF A STANDBY GENERATOR FOR CRITICAL LOADS
MECHANICAL DETAILS - 2

MECHANICAL

DESIGN:	J.S.	DRAFTING:	J.S.	CHECK:	J.H.	CONTRACT No.	25ECS-MI-03HA
SCALE:	N.T.S.				DRAWING NUMBER:	2F-2017-08-28	M209
DATE:	2024-09-30						

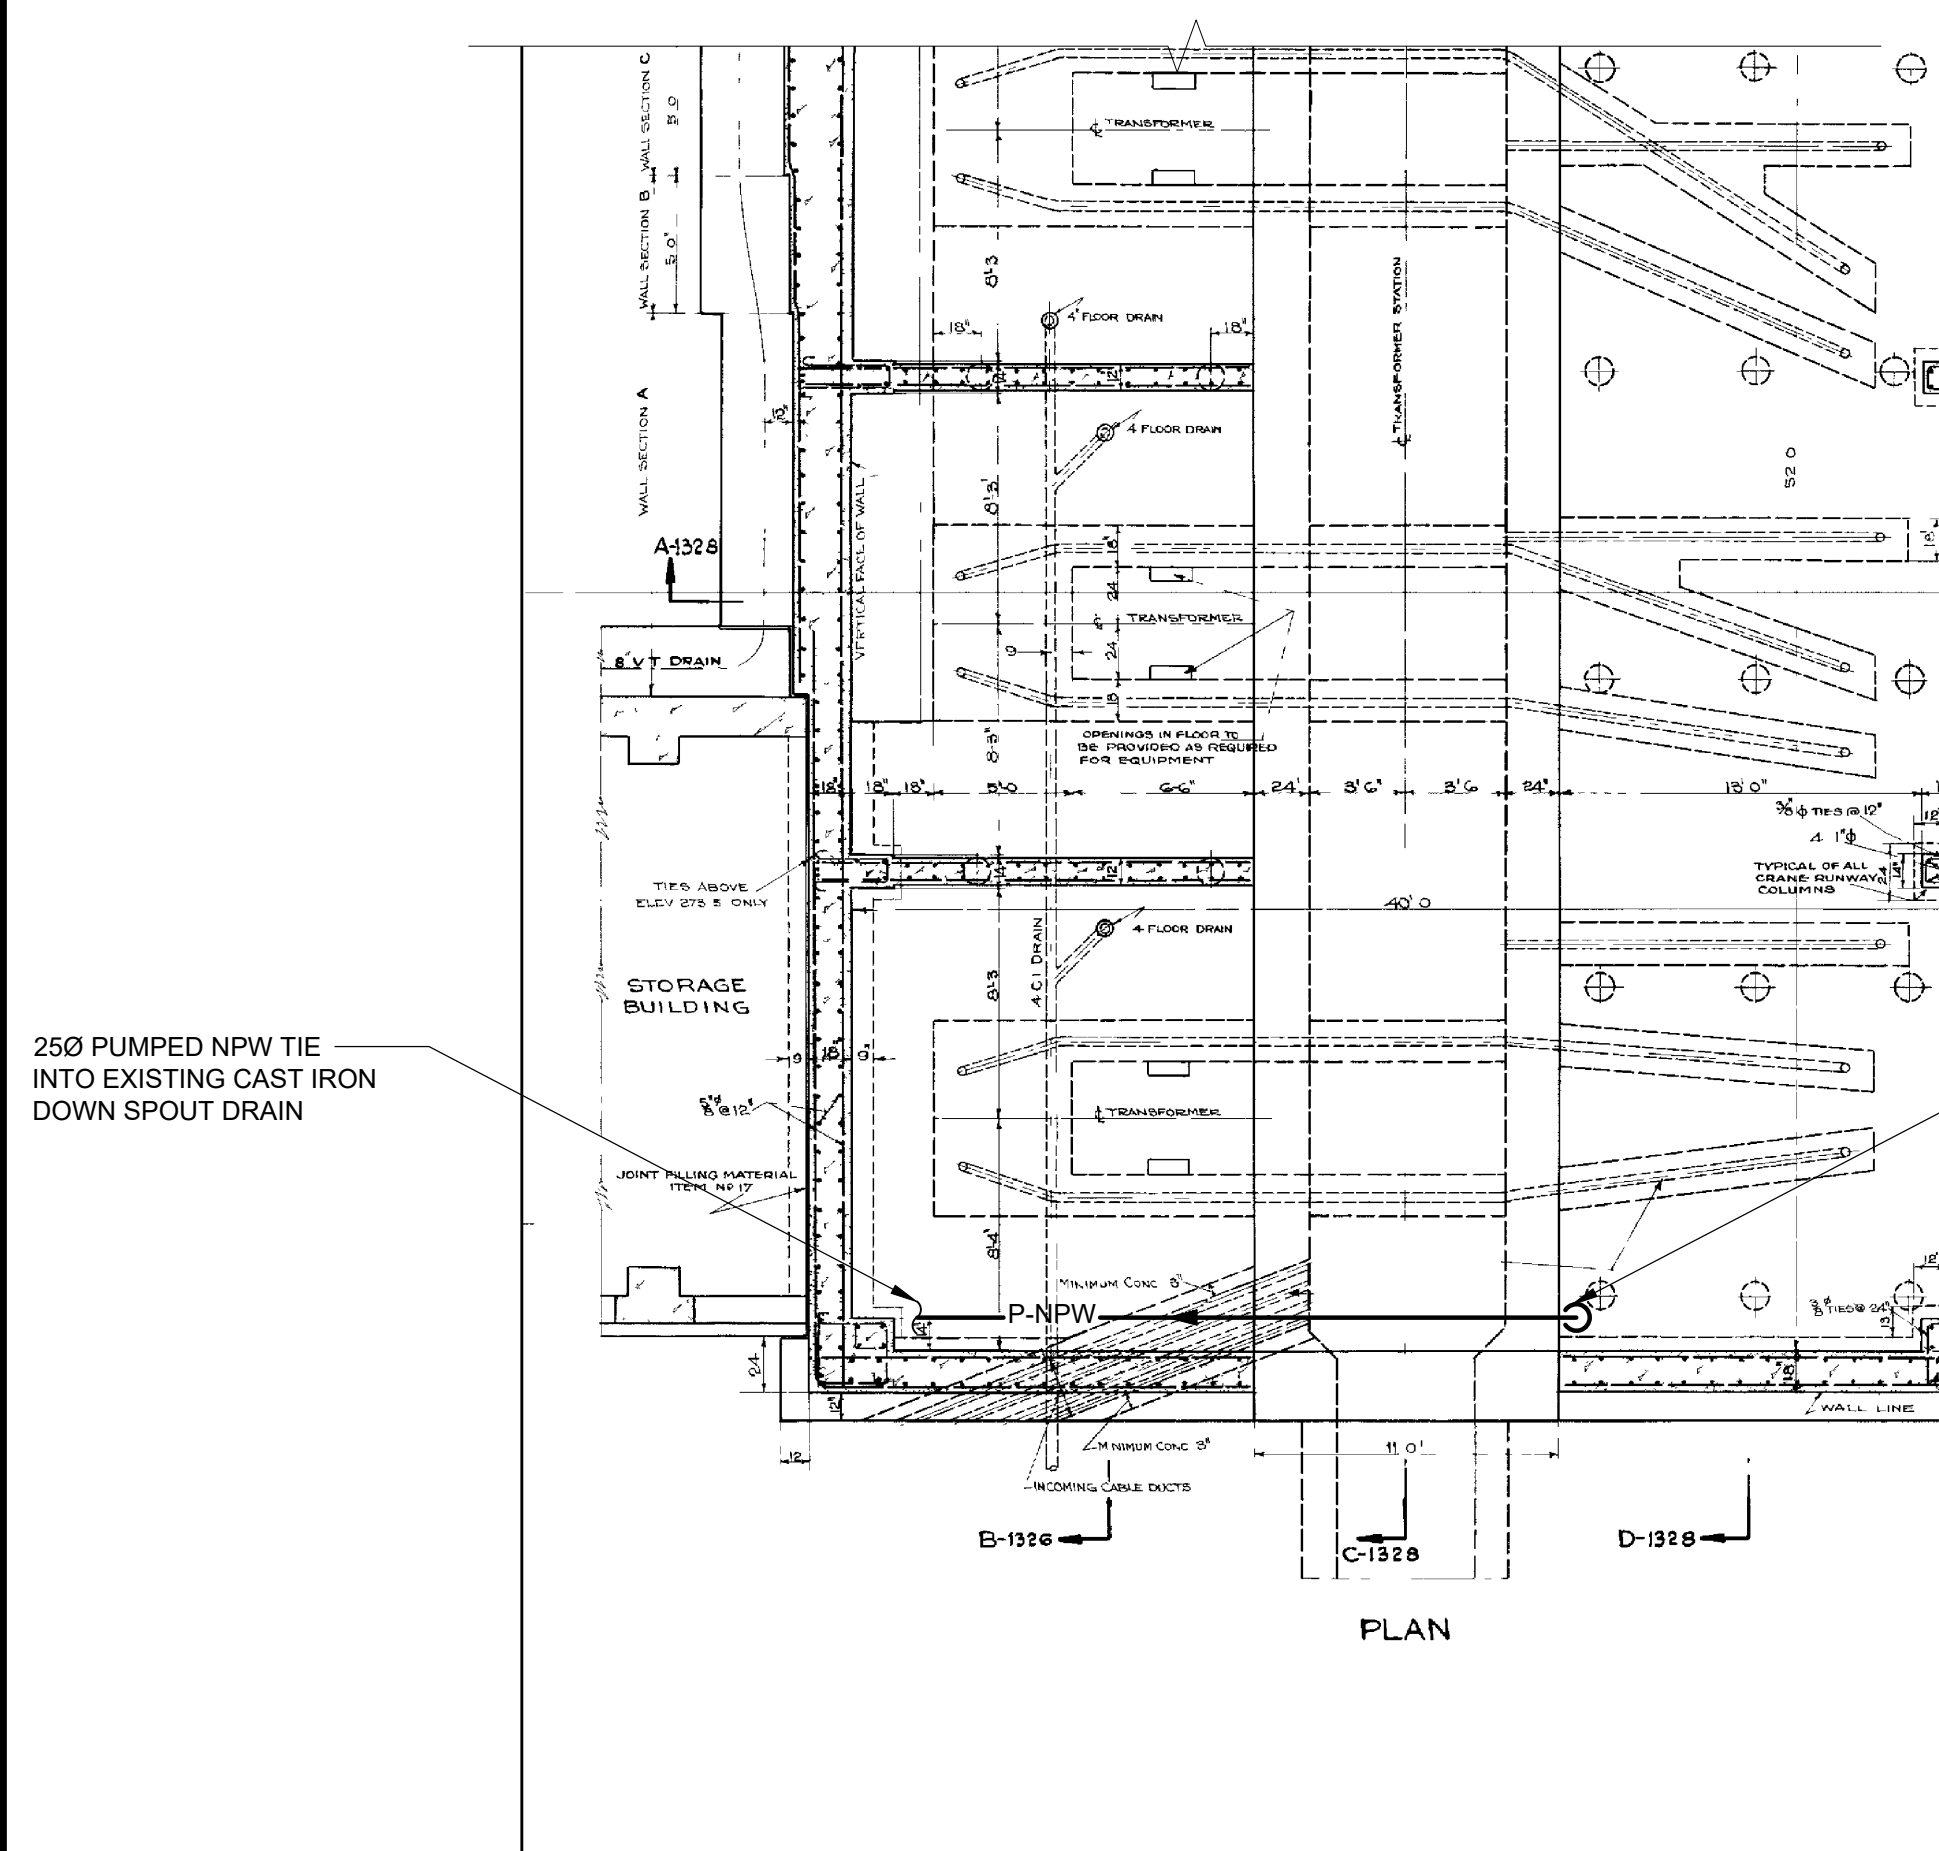

1:50

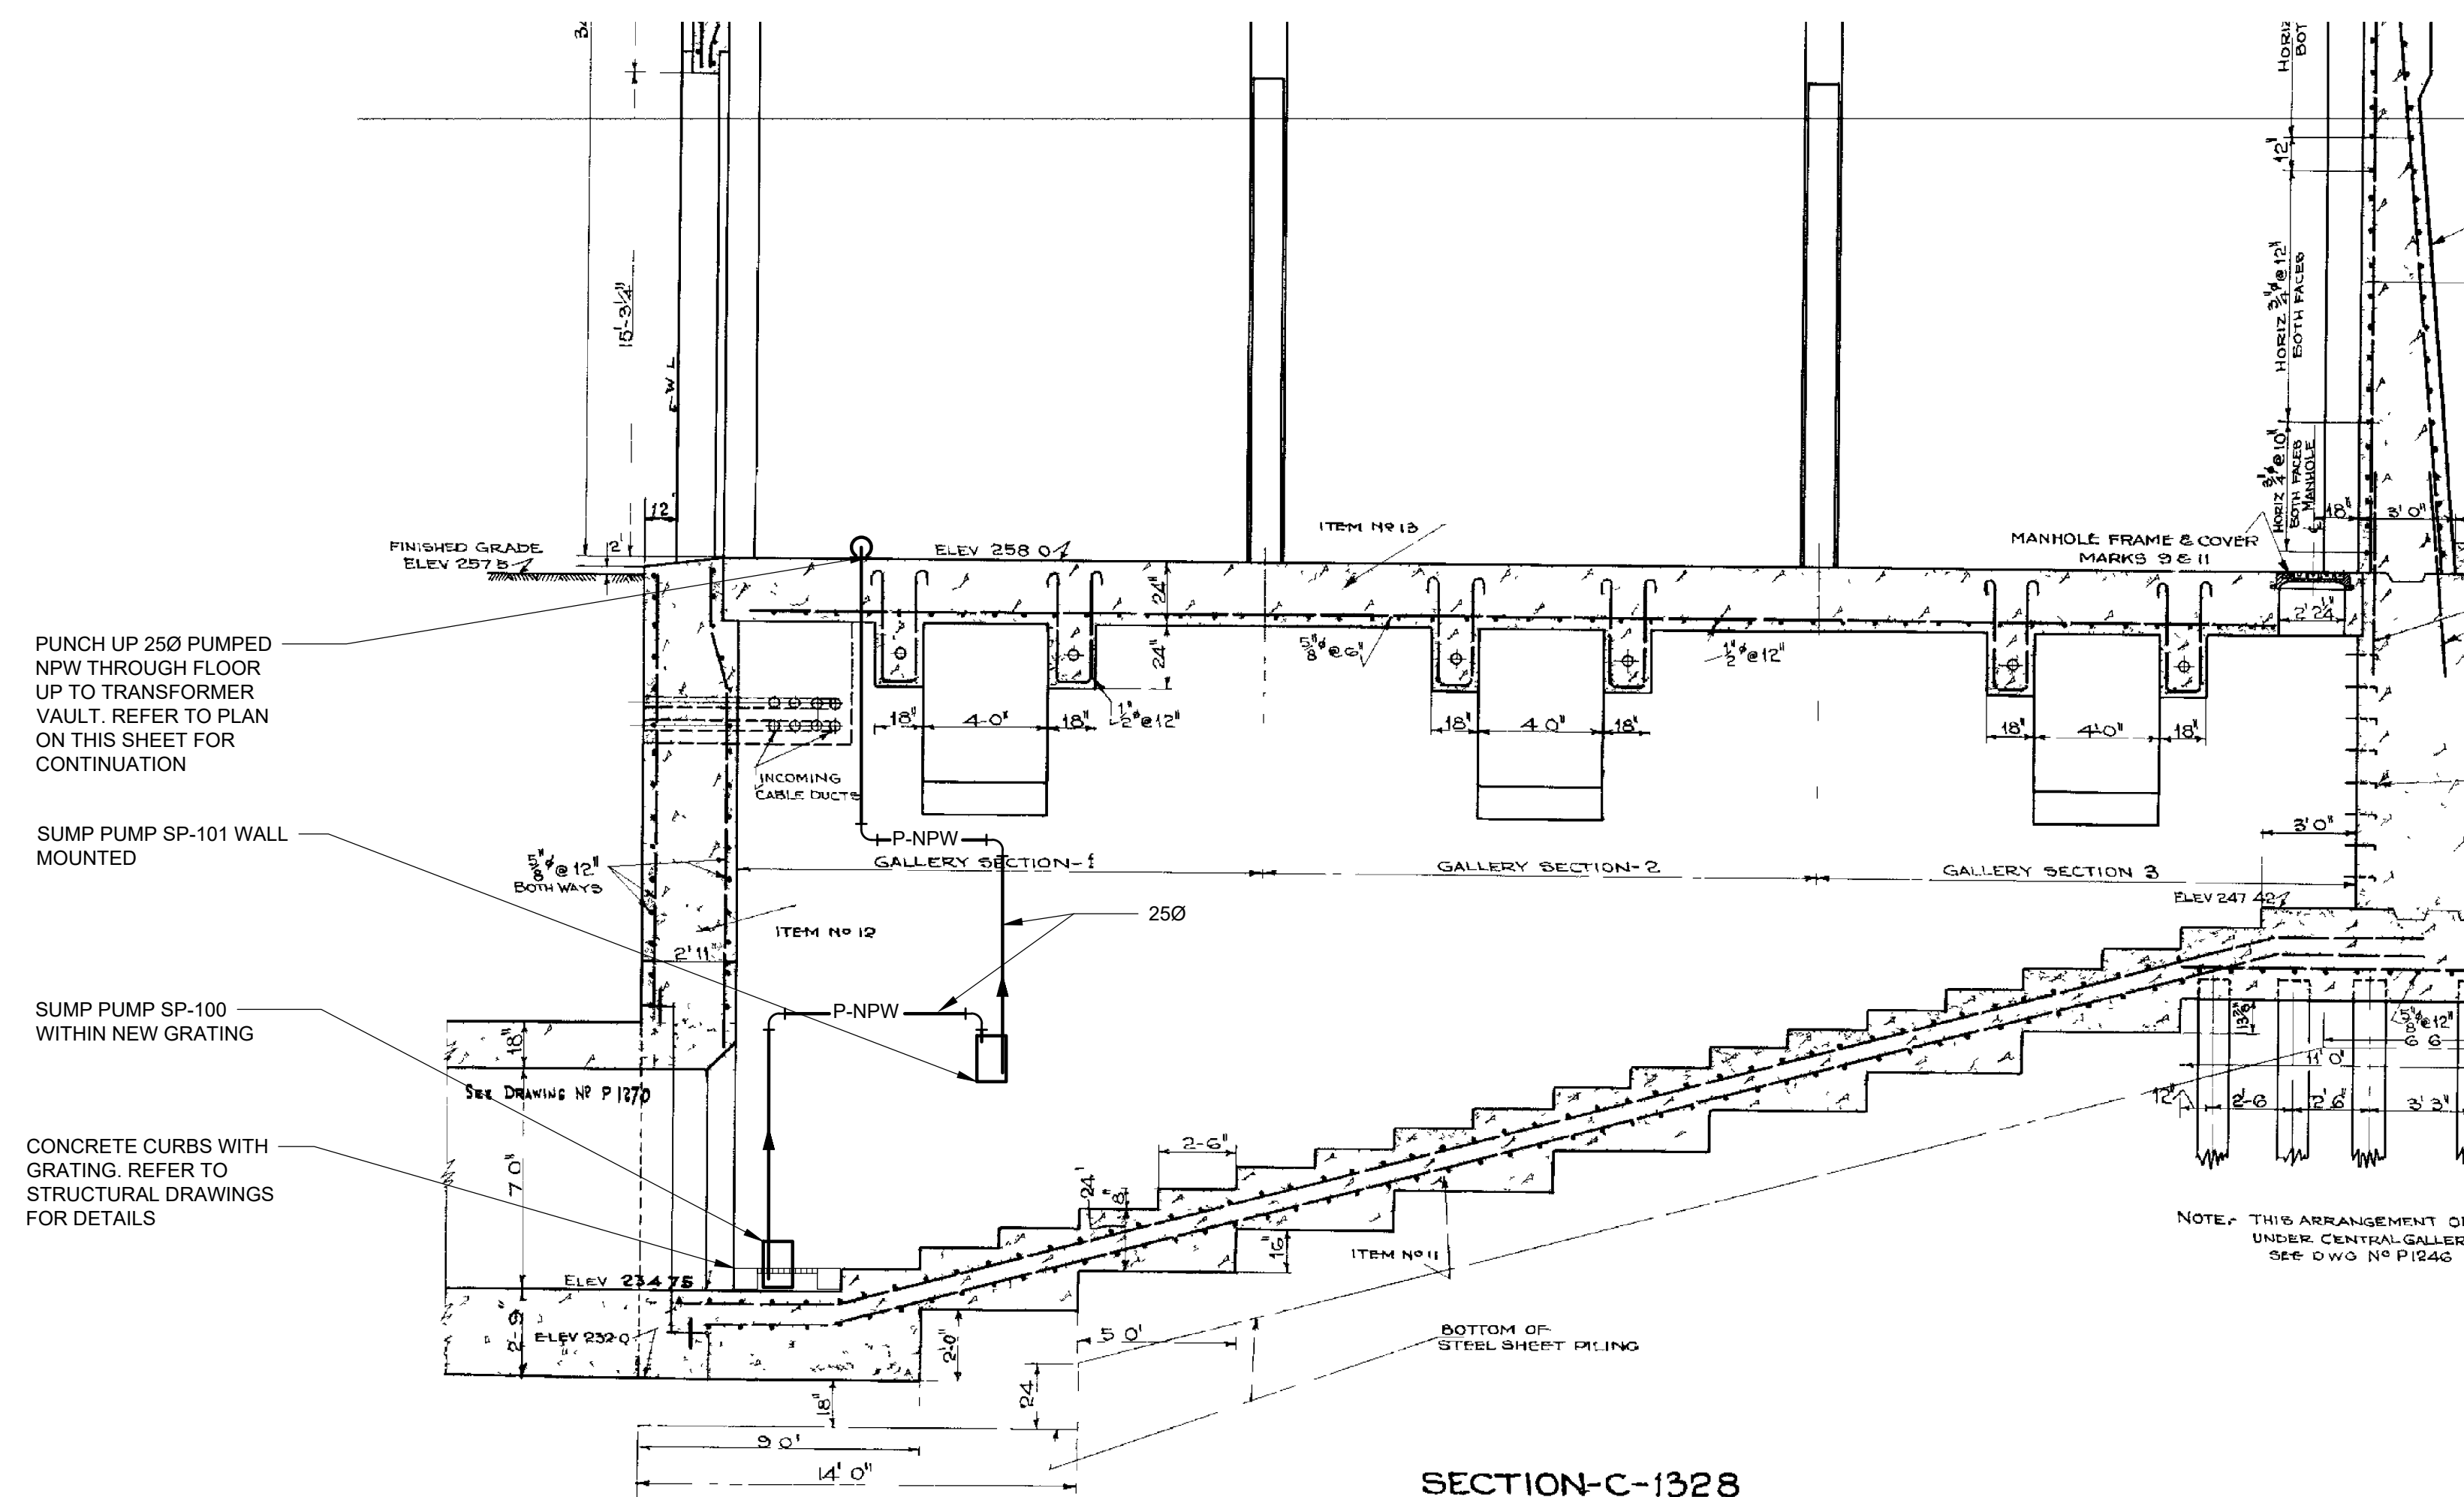

1.5)

Drawing: C:\USERS\TUNG7~1\APPPDATA\LOCAL\TEMP\ACPUBLISH_3536\2F-2017-08-30-E001.DWG
Layout: 03/19/2025 Time: 12:31:27 PM

METRIC MEASUREMENTS SHOWN ON THESE PLANS ARE IN MILLIMETERS UNLESS OTHERWISE NOTED	
TERMINAL BLOCK LEGEND	
	DEVICE TERMINAL TB DT
	TERMINAL BLOCK IN MCC / SWITCHGEAR TB MCC
	TERMINAL BLOCK IN LOCAL PANEL TB P
	TERMINAL BLOCK IN RPU (PLC) TB PLC
	TERMINAL BLOCK IN CENTRAL BACKUP PANEL (CBP) TB CBP
	TERMINAL BLOCK IN AREA CONTROL PANEL (ACP) TB ACP
	TERMINAL BLOCK IN TERMINAL (JUNCTION) BOX TB JB
	TERMINAL BLOCK OF FIRE ALARM DETECTOR IN SWITCHGEAR TB FA

COIL CONTACTS	
	CONTACT, NORMALLY OPEN TB CO
	CONTACT, NORMALLY CLOSED TB CC
	NORMALLY OPEN CONTACT TIME DELAY CLOSING CO TD C
	NORMALLY CLOSED CONTACT TIME DELAY OPENING CO TD O
	NORMALLY OPEN CONTACT TIME DELAY OPENING WHEN DE-ENERGIZED CO TD O.DE-ENRG
	NORMALLY CLOSED CONTACT TIME DELAY CLOSING WHEN DE-ENERGIZED CC TD C.DE-ENRG

RELAY COILS	
	CONTROL RELAY CR
	MOTOR STARTER M
	PNEUMATIC TIMER WITH ADJUSTABLE TIMING RANGE AS SHOWN TR
	ELECTRIC TIMER WITH ADJUSTABLE TIMING RANGE AS SHOWN TR EL
	SOLENOID SC
	LATCHING RELAY LR
	THERMAL OVERLOAD OL

PUSHBUTTONS & SWITCHES	
	FOOT SWITCH NORMALLY OPEN XS O
	FOOT SWITCH NORMALLY CLOSED XS C
	TOGGLE SWITCH XT
	MECHANICAL CONNECTION MC
	MECHANICAL CONNECTION WITH INTERLOCK MC INT
	NORMALLY OPEN PUSHBUTTON PB O
	NORMALLY CLOSED PUSHBUTTON PB C
	NORMALLY OPEN MUSHROOM HEAD PUSHBUTTON PB O MH
	NORMALLY CLOSED MUSHROOM HEAD PUSHBUTTON PB C MH
	TWO POSITION SELECTOR SWITCH OPENED SS 2O
	TWO POSITION SELECTOR SWITCH CLOSED SS 2C
	SPRING RETURN SELECTOR SWITCH OPENED SS SR O
	SPRING RETURN SELECTOR SWITCH CLOSED SS SR C
	THREE POSITION SELECTOR SWITCH OPENED SS 3O
	THREE POSITION SELECTOR SWITCH CLOSED SS 3C
ADDITIONAL CONTACT:	
	NORMALLY OPEN CONTACT OF SELECTOR SWITCH / PUSHBUTTON HS O
	NORMALLY CLOSED CONTACT OF SELECTOR SWITCH / PUSHBUTTON HS C
NOTE: "XXX" : MAINTENANCE, LOCAL, MANUAL, HAND, START, OPEN "YYY" : REMOTE, AUTO, STOP, CLOSE "ZZZ" : OFF, LOCAL(ONLY WHEN "XXX" USED FOR MAINTENANCE), STOP(ONLY WHEN "YYY" USED FOR VALVE CLOSE) 1. ANY OTHER COMBINATION SHOULD BE APPROVED BY CITY. 2. USE ADDITIONAL CONTACT AS MUCH AS NEEDED.	

PUSHBUTTONS & SWITCHES (FOR ELECTRICAL DRAWING)	
	3 POSITION SELECTOR SWITCH SS 3P TOP
	2 POSITION SELECTOR SWITCH SS 2P TOP
	PUSH BUTTON N.O., MOMENTARY CONTACT PB NO
	PUSH BUTTON N.C., MOMENTARY CONTACT PB NC
	PUSH BUTTON, MOMENTARY CONTACT, WITH N.O. & N.C. CONTACTS PB NO+NC
	SELECTOR SWITCH, 2 POSITION SS 2P
MISCELLANEOUS	
	CIRCUIT BREAKER CB
	FUSE FU
	CONTROL TRANSFORMER VOLTAGE & RATING INDICATED AS APPLICABLE CTV
	BATTERY BT
	AUDIBLE DEVICE HN
	WIRE DESIGNATOR W D
	ELAPSED TIME METER KI
	RESISTOR WITH OHMS INDICATOR RR
	SCR SCR
	RECTIFIER, DIODE R DIODE
	CAPACITOR, GENERAL CAP.GEN
LIMIT SWITCHES	
	NORMALLY OPEN ZS O
	NORMALLY CLOSED ZS C
	HELD CLOSED NORMALLY OPEN ZS HC
	HELD OPEN NORMALLY CLOSED ZS HO
	MAINTAINED OPEN ZS MO
	MAINTAINED CLOSED ZLS MC

INPUT/OUTPUT STATIC DEVICES	
	NORMALLY OPEN ISOLATED DIGITAL OUTPUT M DENOTES MOMENTARY DO O.ISO.
	NORMALLY CLOSED ISOLATED DIGITAL OUTPUT M DENOTES MOMENTARY DO C.ISO.
	NORMALLY OPEN NON-ISOLATED DIGITAL OUTPUT M DENOTES MOMENTARY DO O.NON-ISO.
	NORMALLY CLOSED NON-ISOLATED DIGITAL OUTPUT M DENOTES MOMENTARY DO C.NON-ISO.
	DIGITAL INPUT ISOLATED DI ISO
	DIGITAL INPUT NON-ISOLATED DI NON-ISO
	ANALOG INPUT 4-20MA UNLESS NOTED AI
	ANALOG OUTPUT 4-20MA UNLESS NOTED AO
	PULSE INPUT ISOLATED PI ISO.
	PULSE INPUT NON-ISOLATED PI NON-ISO.
	PULSE OUTPUT ISOLATED PO ISO.
	PULSE OUTPUT NON-ISOLATED PO NON-ISO.
TEMPERATURE ELEMENTS	
	THERMOCOUPLE TE
	SINGLE ELEMENT RTD TE SINGLE
	DUAL ELEMENT RTD TE DUAL





































PROCESS SWITCHES	
	TORQUE SWITCH NORMALLYCLOSED OPEN ON INCREASE TORQUE WS C
	TORQUE SWITCH NORMALLY OPEN CLOSE ON INCREASE TORQUE WS O
	LIQUID LEVEL SWITCH NORMALLY OPEN CLOSE ON RISE LS O
	LIQUID LEVEL SWITCH NORMALLY CLOSED OPEN ON RISE LS C
	FLOW SWITCH NORMALLY OPEN CLOSE ON INCREASE FLOW FS O
	FLOW SWITCH NORMALLY CLOSED OPEN ON INCREASE FLOW FS C
	PRESSURE SWITCH NORMALLY OPEN CLOSE ON RISE PS O
	PRESSURE SWITCH NORMALLY CLOSED OPEN ON RISE PS C
	TEMPERATURE SWITCH NORMALLY OPEN CLOSE ON RISE TS NC O ON RISE
	TEMPERATURE SWITCH NORMALLY CLOSED OPEN ON RISE TS NC O ON RISE
	VIBRATION SWITCH NORMALLY CLOSED OPEN ON FAILURE VS NC O ON FAIL
PILOT LIGHTS & METERS	
	ANNUNCIATOR AL
	PILOT LIGHT PL
	PUSH TO TEST PILOT LIGHT PL PUSH
LETTER(S) INSIDE SYMBOL INDICATES COLOR AS FOLLOWS: A = AMBER G = GREEN R = RED B = BLUE O = ORANGE W = WHITE C = CLEAR OP = OPALESCENT	
	METER
LETTER(S) INSIDE SYMBOL INDICATES ELECTRICAL DEVICE AS FOLLOWS: AM = AMMETER VAR = VARMETER AH = AMPERE HOUR VARH = VARHOUR METER PF = POWER FACTOR W = WATTMETER V = VOLTMETER WH = WATTHOUR METER VA = VOLT AMMETER	

CONDUCTORS	
	CONDUCTOR
	CONDUCTORS NOT CONNECTED
	CONDUCTORS CONNECTED
	CONDUCTOR SHIELD
	CONDUCTOR SHIELD
	CONDUCTOR SHIELD, TWISTED PAIR
	EARTH GROUND
	CHASSIS GROUND
	NEUTRAL
	SEPARABLE CONNECTOR
	EXISTING
	REMOVE
	NEW

										TORONTO WATER ENGINEERING AND CONSTRUCTION SERVICES		R.C. HARRIS WATER TREATMENT PLANT INSTALLATION OF A STANDBY GENERATOR FOR CRITICAL LOADS ELECTRICAL LEGEND & ABBREVIATIONS - 1						
										WILLIAM FERNANDES, P.ENG DIRECTOR WATER TREATMENT AND SUPPLY		SIMON HOPTON, P. ENG. DIRECTOR DESIGN & CONSTRUCTION MAJOR INFRASTRUCTURE						
100-175 GALAXY BOULEVARD TORONTO, ONTARIO, M9W 0C9 TEL 416 679 1930 FAX 416 675 4620 www.arcadis.com		COPYRIGHT: This drawing has been prepared solely for the intended use. Thus, any reproduction or distribution for any purpose other than authorized by ARCADIS is forbidden. Written dimensions shall have precedence over scaled dimensions. Contractors shall verify and be responsible for all dimensions and conditions on the job, and ARCADIS shall be informed of any variations from the dimensions and conditions shown on the drawing. Shop drawings shall be submitted to IRI Group for general conformance before proceeding with fabrication.		A		2025-03-18		ISSUED FOR TENDER		T.S.		ELECTRICAL						
NO.		DATE		REVISIONS		INITIAL		SIGNED		DESIGN:		SC	DRAFTING:	SC	CHECK:	TS	CONTRACT No.	25ECS-MI-03HA
										SCALE:		N.T.S.		DRAWING NUMBER:		2F-2017-08-30		E001
										DATE:		2024-09-30						

METRIC
MEASUREMENTS SHOWN ON THESE PLANS
ARE IN MILLIMETERS UNLESS OTHERWISE NOTED

                                    ELECTRICAL SYMBOLS – SINGLE LINE DIAGRAM

	BUS DUCT		INVERTER
	BREAKER, MEDIUM AND HIGH VOLTAGE		DIODE
	CIRCUIT BREAKER		MOTOR STARTER
	HIGH AND MEDIUM VOLTAGE DRAWOUT CIRCUIT BREAKER		MANUAL STARTER
	HIGH VOLTAGE FUSED INTERRUPTER SWITCH		OVERLOAD
	FUSE DISCONNECT TERMINAL BLOCK		CONTACTOR
	HIGH VOLTAGE UNFUSED INTERRUPTER SWITCH		REVERSE CONTACTOR
	DRAWOUT OR PLUG-IN CONNECTION		CAPACITOR OR REACTOR
	DRAWOUT CIRCUIT BREAKER (LOW VOLTAGE)		INDUCTOR
	DISCONNECT SWITCH		SOLENOID
	DISCONNECT SWITCH FUSED		LIGHTNING ARRESTER
	DISCONNECT SWITCH NON-INSULATED		SURGE PROTECTION
	DISCONNECT SWITCH WITH GROUNDING		TRANSIENT VOLTAGE SURGE SUPPRESSOR
	FUSE		SURGE CAPACITOR
	SWITCH		HEATER
	TRANSFER SWITCH		BATTERY
	METER		DELTA CONNECTION
	DIGITAL METER		WYE CONNECTION
	TRANSFORMER, POWER AND DISTRIBUTION		SOLID GROUNDED NEUTRAL
	TRANSFORMER		RESISTOR GROUNDED NEUTRAL
	AUTOTRANSFORMER		GROUND
	CONTROL TRANSFORMER		CABLE POTHEAD
	POTENTIAL TRANSFORMER		WIRE CONNECTION
	CURRENT TRANSFORMER		WIRES NOT CONNECTED
	ZERO SEQUENCE CURRENT TRANSFORMER		RESISTANCE TEMPERATURE DETECTOR
	BUSHING CURRENT TRANSFORMER		KEY INTERLOCK
	MOTOR INDUCTION TYPE		ELECTRICAL INTERLOCK
	MOTOR SYNCHRONOUS TYPE		MECHANICAL INTERLOCK
	VARIABLE FREQUENCY DRIVE		GENERATOR
	SOFT STARTER (BLOCK)		RESISTOR OR HEATER
	SOFT STARTER		VARIABLE RESISTOR
	RECTIFIER		POWER CIRCUIT BREAKER WITH ELECTRONIC TRIP UNIT LETTERS DENOTE PROTECTION FUNCTIONS
			MOTOR STARTER WITH INSTANTANEOUS TRIP CIRCUIT PROTECTOR, CONTACTOR AND THERMAL OVERLOAD RELAY. THE CONTINUOUS CURRENT RATING AND STARTER SIZE AS INDICATED

ELECTRICAL ABBREVIATIONS

AC	ALTERNATING CURRENT	MTR	METER
A/C	AIR CONDITIONING	MTS	MANUAL TRANSFER SWITCH
ACT	ACTUATOR	N	NEUTRAL
AF	AMPERE FRAME	NC	NORMALLY CLOSED
ANN	ANNUNCIATOR	NO	NORMALLY OPENED
AT	AMPERE TRIP	NEC	NATIONAL ELECTRICAL CODE
ATS	AUTOMATIC TRANSFER SWITCH	O/L	OVERLOAD
AWG	AMERICAN WIRE GAUGE	ONAN	OIL NATURAL AIR NATURAL
BAT	BATTERY	ONAF	OIL NATURAL AIR FORCE
BKR	BREAKER	P	PUMP
C	CONDUCTOR	PB	PUSH BUTTON
CAP	CAPACITOR	P&ID	PROCESS AND INSTRUMENTATION DIAGRAM
CB	CIRCUIT BREAKER	PDP	POWER DISTRIBUTION PANEL
CCT	CIRCUIT	PM	POWER METERING
CP	CONTROL PANEL	PNL	PANEL
CPT	CONTROL POWER TRANSFORMER	PNLB	PANELBOARD
CR	CONTROL RELAY	PLC	PROGRAMMABLE LOGIC CONTROLLER
CT	CURRENT TRANSFORMER	PS	POWER SUPPLY
DC	DIRECT CURRENT	PT	POTENTIAL TRANSFORMER
DG	DIESEL GENERATOR	RPV	REMOTE PROCESSING UNIT
DM	DIGITAL METERING	RTD	RESISTANCE TEMPERATURE DETECTOR
DS	DISCONNECT SWITCH	RTU	REMOTE TERMINAL UNIT
EF	EXHAUST FAN	SEN	SENSOR
ELU	EMERGENCY LIGHTING UNIT	SHLD	SHIELDED
EP	EXPLOSION PROOF	SN	SOLID NEUTRAL
ESTOP	EMERGENCY STOP	SOL	SOLENOID
ETM	ELAPSED TIME METER	S/S	SUBSTATION
F	FUSE	SW	SWITCH
FA	FIRE ALARM	SWG	SWITCHGEAR
FPR	FEDER PROTECTION RELAY	TB	TIE BREAKER
FVR	FULL VOLTAGE REVERSING	TDR	TIME DELAY RELAY
FVNR	FULL VOLTAGE NON REVERSING	TR	TRANSFORMER
GEN	GENERATOR	TS	TRANSFER SWITCH
GFI	GROUND FAULT INTERRUPTER	UPS	UNINTERRUPTIBLE POWER SUPPLY
GND	GROUND	VFD	VARIABLE FREQUENCY DRIVE
GPR	GENERATOR PROTECTION RELAY	VT	VOLTAGE TRANSFORMER
H—O—A	HAND OFF AUTOMATIC	WP	WEATHER PROOF
HTR	HEATER	XFMR	TRANSFORMER

STANDARD FUNCTION NUMBERS

27	UNDER VOLTAGE RELAY
37	UNDER CURRENT/UNDER POWER RELAY
38	BEARING RTD RELAY
46	CURRENT UNBALANCE RELAY
47	PHASE REVERSAL RELAY
49	STATOR RTD RELAY
50	INSTANTANEOUS OVERCURRENT
50G	INSTANTANEOUS GROUND FAULT
51	AC TIME OVERCURRENT
51G	AC TIME GROUND FAULT
52	AC CIRCUIT BREAKER
59	OVERVOLTAGE RELAY
81	FREQUENCY RELAY
86	LOCK-OUT RELAY

								TORONTO WATER								R.C. HARRIS WATER TREATMENT PLANT INSTALLATION OF A STANDBY GENERATOR FOR CRITICAL LOADS ELECTRICAL LEGEND & ABBREVIATIONS - 2							
									ENGINEERING AND CONSTRUCTION SERVICES														
											WILLIAM FERNANDES, P.ENG DIRECTOR WATER TREATMENT AND SUPPLY		SIMON HOPTON, P. ENG. DIRECTOR DESIGN & CONSTRUCTION MAJOR INFRASTRUCTURE										
 100-175 GALAXY BOULEVARD TORONTO, ONTARIO, M9W 0C9 TEL. 416 679 1930 FAX 416 675 4620 www.arcadis.com		COPYRIGHT: This drawing has been prepared solely for the intended use, thus any reproduction or distribution for any purpose other than authorized by ARCADIS is forbidden. Written dimensions shall have precedence over scaled dimensions. Contractors shall verify and be responsible for all dimensions and conditions on the job, and ARCADIS shall be informed of any variations from the drawings and conditions shown on the drawing. Shop drawings shall be submitted to IBI Group for general conformance before proceeding with fabrication.																					
		A	2025-03-18		ISSUED FOR TENDER			T.S.															
		NO.	DATE	REVISIONS			INITIAL	SIGNED															
		ARCADIS Professional Services (Canada) Inc.																					

Drawing: J:\M16-0273 TOR_HARRISWTP-STANDBYGENERATOR\500_CAD\CAD\401-CAD\1-SS OR BU\Sheet\6 ELEC\2F-2017-08-32-E003.DWG
Layout: 03/19/2025 12:31:54 PM
Date: 03/19/2025 Time: 12:31:54 PM

 **METRIC**
MEASUREMENTS SHOWN ON THESE PLANS
ARE IN MILLIMETERS UNLESS OTHERWISE NOTED

ELECTRICAL SYMBOLS

 
ELECTRICAL LAYOUT

 TR
kVA TRANSFORMER

 TR
kVA WALL MOUNTED TRANSFORMER

 WALL MOUNTED TRANSFORMER AND PANELBOARD

 PB WALL MOUNTED PANELBOARD

 PB FLUSH WALL MOUNTED PANELBOARD

 M MOTOR

 P PUMP

 MV MOTORIZED VALVE

 MD MOTORIZED DAMPER

 MS MOTOR STARTER

 SW DISCONNECT SWITCH

 CONTROL STATION

 JB JUNCTION BOX / PULL BOX (PB)

 
 LP-XX LIGHTING PANEL

 TYPE LIGHT FIXTURE

 LIGHT FIXTURE

 CEILING MOUNTED FIXTURE

 WALL MOUNTED FIXTURE

 EMERGENCY LIGHTING UNIT

 EMERGENCY LIGHTING UNIT (REMOTE)

 CEILING FAN

 WALL MOUNTED FAN

 SUPPLY FAN

 EXHAUST FAN

 UNIT HEATER

 FLOAT SWITCH

 CABLE STRESS CONE

 MH MANHOLE

 HYDRO POLE

 SINGLE RECEPTACLE

 DUPLEX RECEPTACLE

 DUPLEX RECEPTACLE SPLIT

 WELDING RECEPTACLE

 SPECIAL PURPOSE RECEPTACLE

 COUNTERTOP RECEPTACLE DUPLEX

 COUNTERTOP SPLIT RECEPTACLE DUPLEX

 \$ SINGLE POLE SWITCH (LIGHT)

 DISCONNECT HANDLE

 SELECTOR SWITCH

 EMERGENCY PUSH BUTTON

 H HUMIDISTAT

 T THERMOSTAT

 CCTV SECURITY CAMERA

 PC PHOTO CELL

 TYPE SENSOR

 MOTION SENSOR

 CARD READER / KEY PAD (KP)

 SP SECURITY ALARM PANEL

 S SPEAKER

 BUZZER

 BELL

 SA SOUND ALARM

 KP KEYPAD

 ES ELECTRIC STRIKE

 C DOOR CONTACT

 C_E DOOR CONTACT EXPLOSION PROOF

 C OVERHEAD DOOR CONTACT

 FIRE ALARM PULL STATION

 STROBE / HORN FIRE ALARAM

 FAP FIRE ALARM PANEL

 CP CONTROL PANEL

 LP LIGHTING PANEL

 HEAT DETECTOR

 SMOKE DETECTOR

 SA SMOKE ALARM

 CO FIRE DETECTOR

 FD STROBE LIGHT

 STR CARBON MONOXIDE

 TELEPHONE OUTLET

 TV CABLE OUTLET

 TELEPHONE DATA OUTLET



 DATA OUTLET

GENERAL NOTE:

THIS IS A GENERAL ELECTRICAL
SYMBOL SHEET. SOME SYMBOLS
OR NOTATIONS MAY NOT BE USED
ON THIS PROJECT.

																																																																																																																																																																																																																																																																																																																																																																																																																																																																																																																																																																																																																																																																																																																																																																																																																																																																																																																																																																																																																																																																																																																																																																																																																																																																																																																																																																																																																											
---	--	--	

Drawing: J:\M16-0273 TOR_HARRISWTP-STANDBYGENERATOR\500_CAD\401-CAD\1-SS OR BU\SHEET\6 ELEC\2F-2017-08-33-E004.DWG
Layout: 03/19/2025
Date: 03/19/2025
Time: 12:32:11 PM

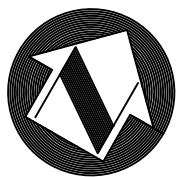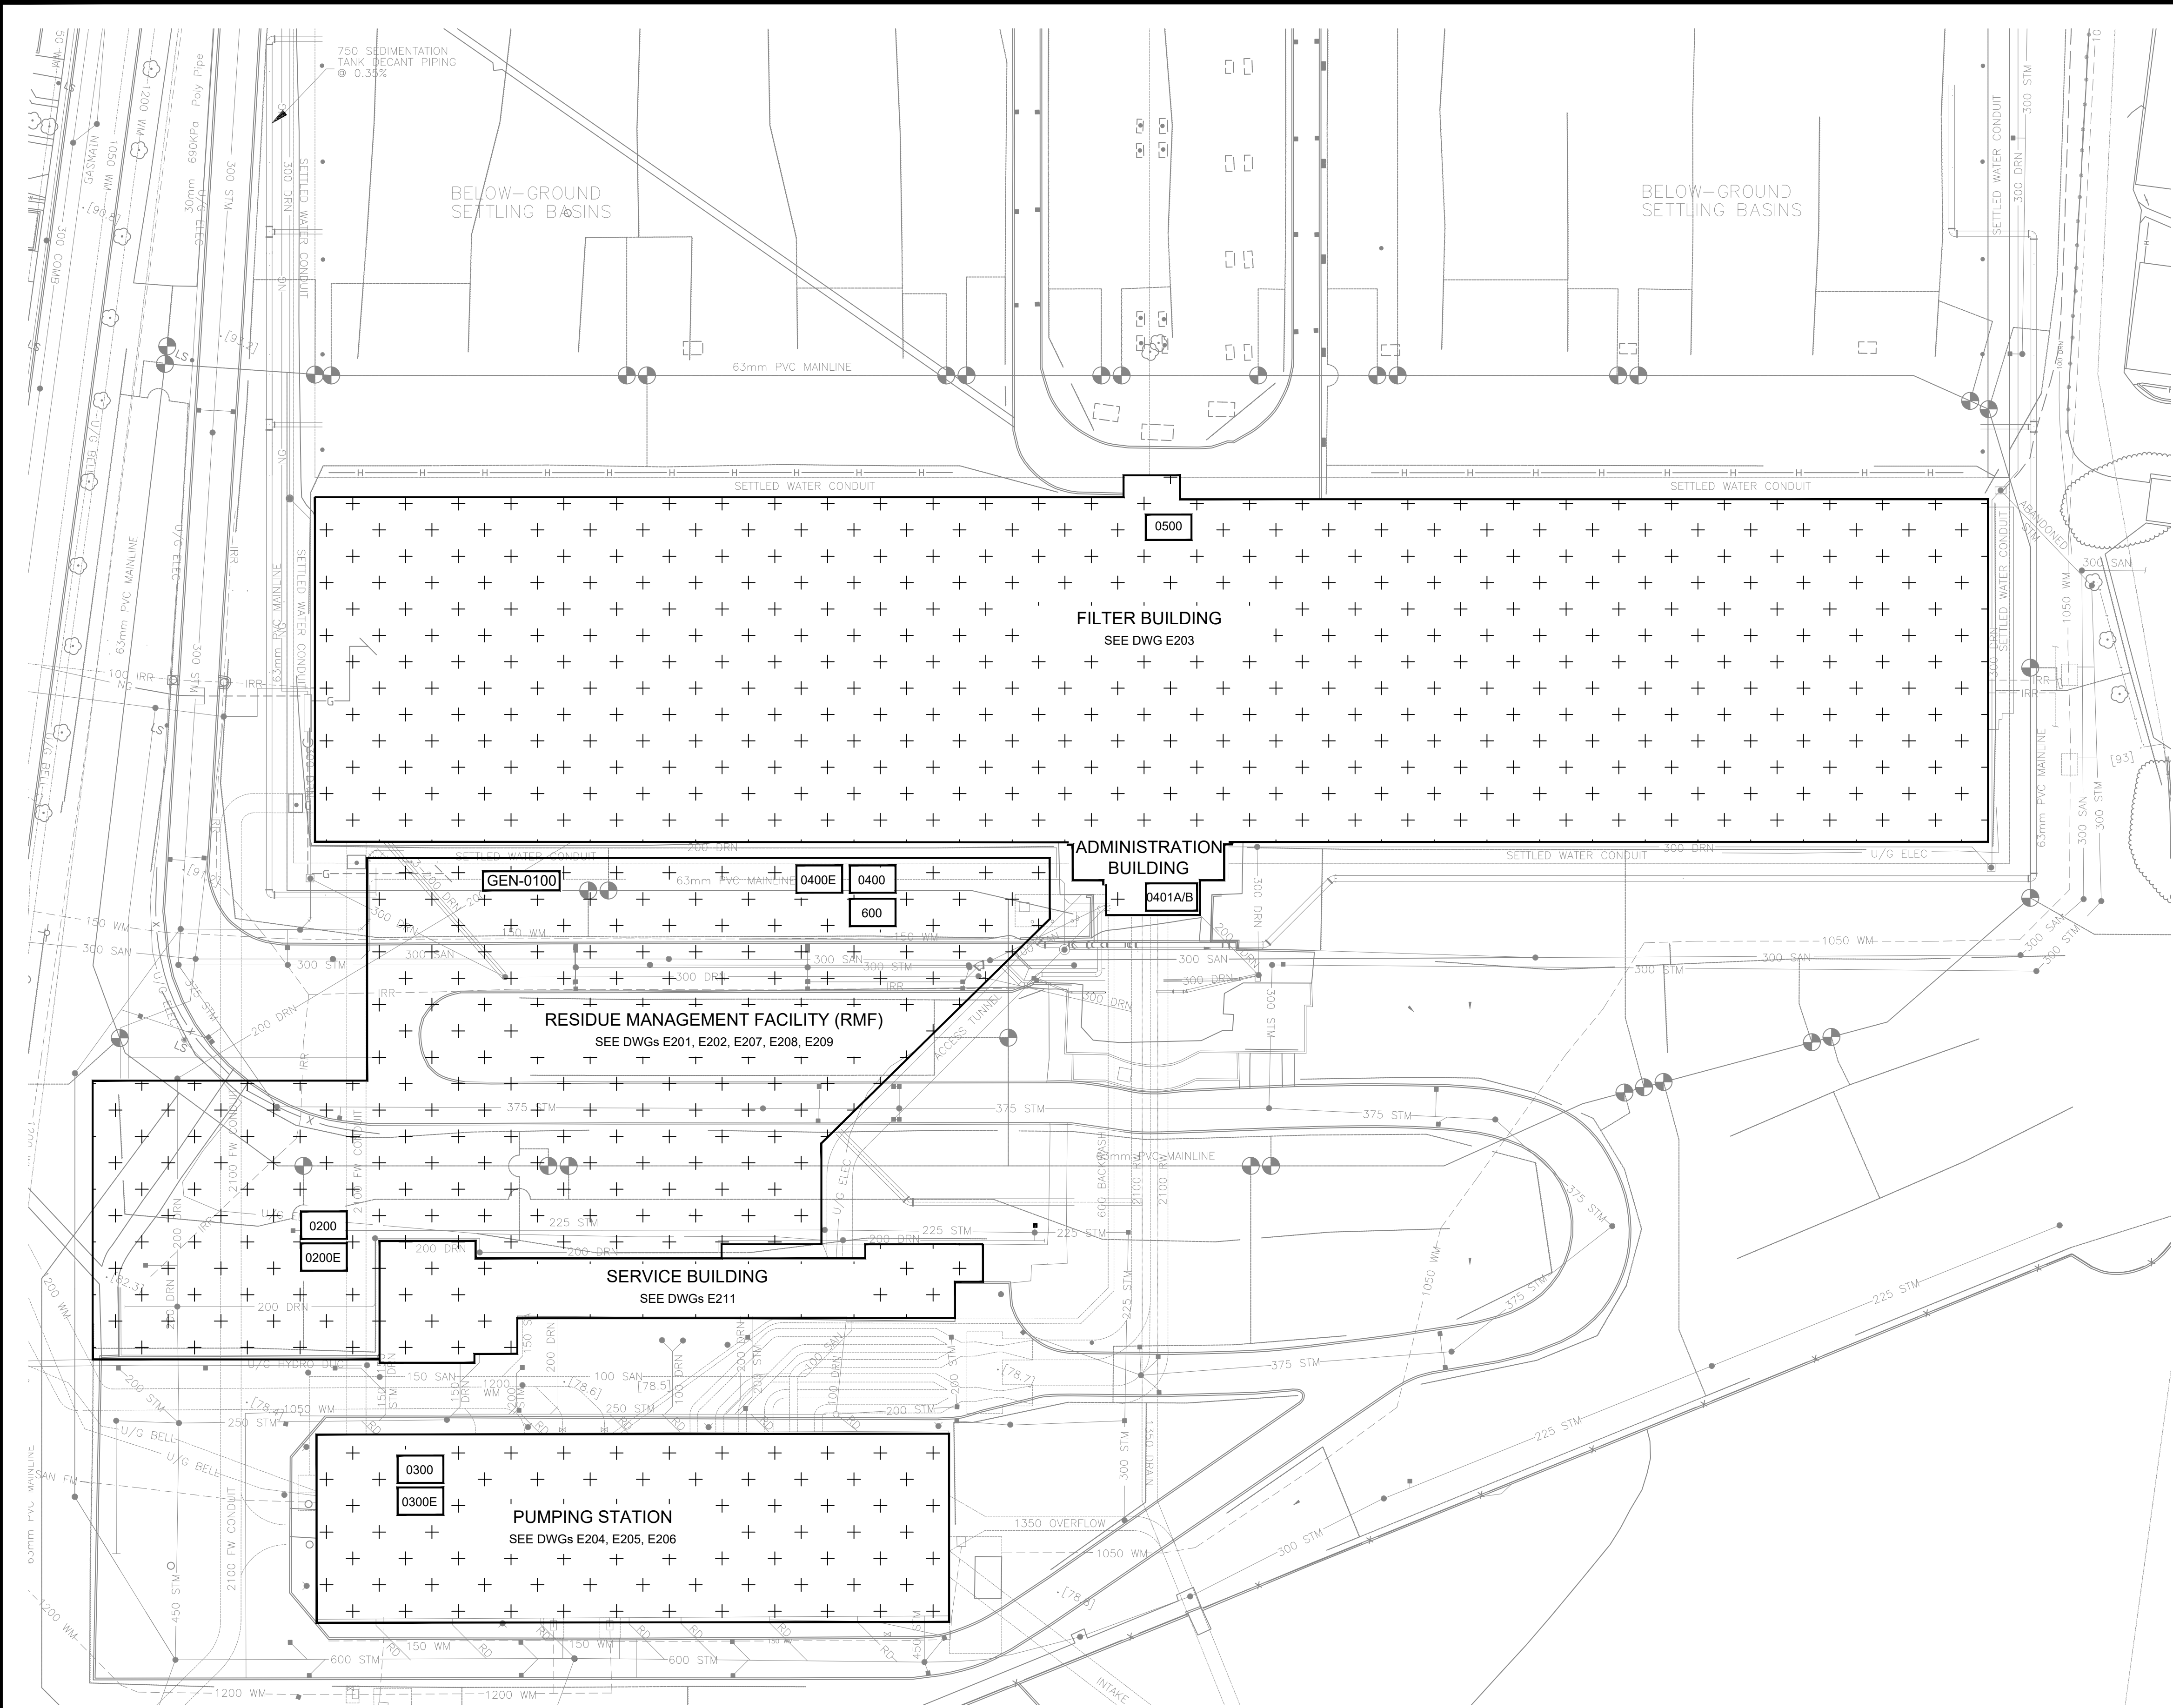

- 0200 EXISTING FHA-ELS-MCC-0200 IN RESIDUE MANAGEMENT FACILITY (RMF) REFER TO DWG E207 FOR LOCATION DETAILS.
- 0200E NEW FHA-ELS-PDP-0200E IN RESIDUE MANAGEMENT FACILITY (RMF) REFER TO DWG E207 FOR LOCATION DETAILS.
- 0300 EXISTING FHA-ELS-PDP-0300 IN PUMPING STATION - SWITCHGEAR ROOM REFER TO DWG E205 FOR LOCATION DETAILS.
- 0300E NEW FHA-ELS-PDP-0300E IN PUMPING STATION - SWITCHGEAR ROOM REFER TO DWG E205 FOR LOCATION DETAILS.
- 0400 EXISTING FHA-ELS- MCC-0400 IN RESIDUE MANAGEMENT FACILITY (RMF) - ELECTRICAL ROOM REFER TO DWG E202 FOR LOCATION DETAILS.
- 0400E NEW FHA-ELS- PDP-0400E IN RESIDUE MANAGEMENT FACILITY (RMF) - ELECTRICAL ROOM REFER TO DWG E202 FOR LOCATION DETAILS.
- 0401A/B NEW FHA-ELS- PDP-0401A/B IN ADMIN BLDG BASEMENT LEVEL - ELECTRICAL ROOM REFER TO DWG E203 FOR LOCATION DETAILS.
- 0500 EXISTING FHA-ELS-PDP-0500 IN FILTER BUILDING REFER TO DWG E203 FOR LOCATION DETAILS.
- 0600 EXISTING FHA-ELS-MCC-0600 IN RESIDUE MANAGEMENT FACILITY (RMF) - ELECTRICAL ROOM REFER TO DWG E202 FOR LOCATION DETAILS.
- GEN-0100 NEW NATURAL GAS STANDBY GENERATOR FHA-ELS-GEN-0200 LOCATED IN PIPE GALLERY REFER TO DWG E201 FOR LOCATION DETAILS

- EXISTING
- NEW
- REMOVAL, TO BE REPLACED WITH NEW CABLES & INSTALLED COMPLETE

													TORONTO WATER				R.C. HARRIS WATER TREATMENT PLANT													
													ENGINEERING AND CONSTRUCTION SERVICES				INSTALLATION OF A STANDBY GENERATOR FOR CRITICAL LOADS													
																	WILLIAM FERNANDES, P. ENG. DIRECTOR WATER TREATMENT AND SUPPLY		SIMON HOPTON, P. ENG. DIRECTOR DESIGN & CONSTRUCTION MAJOR INFRASTRUCTURE		OVERALL SITE PLAN									
																					ELECTRICAL									
																	DESIGN:		SC	DRAFTING:	SC	CHECK:	TS	CONTRACT No.		25ECS-MI-03HA				
																	SCALE:		N.T.S.				DRAWING NUMBER:		2F-2017-08-33				E004	
																	DATE:		2024-09-30											
		COPYRIGHT: This drawing has been prepared solely for the intended use, thus any reproduction or distribution for any purpose other than authorized by ARCADIS is forbidden. Written dimensions shall have precedence over scaled dimensions. Contractors shall verify and be responsible for all dimensions and conditions on the job, and ARCADIS shall be informed of any variations from the dimensions and conditions shown on the drawing. Shop drawings shall be submitted to IBI Group for general conformance before proceeding with fabrication.																												

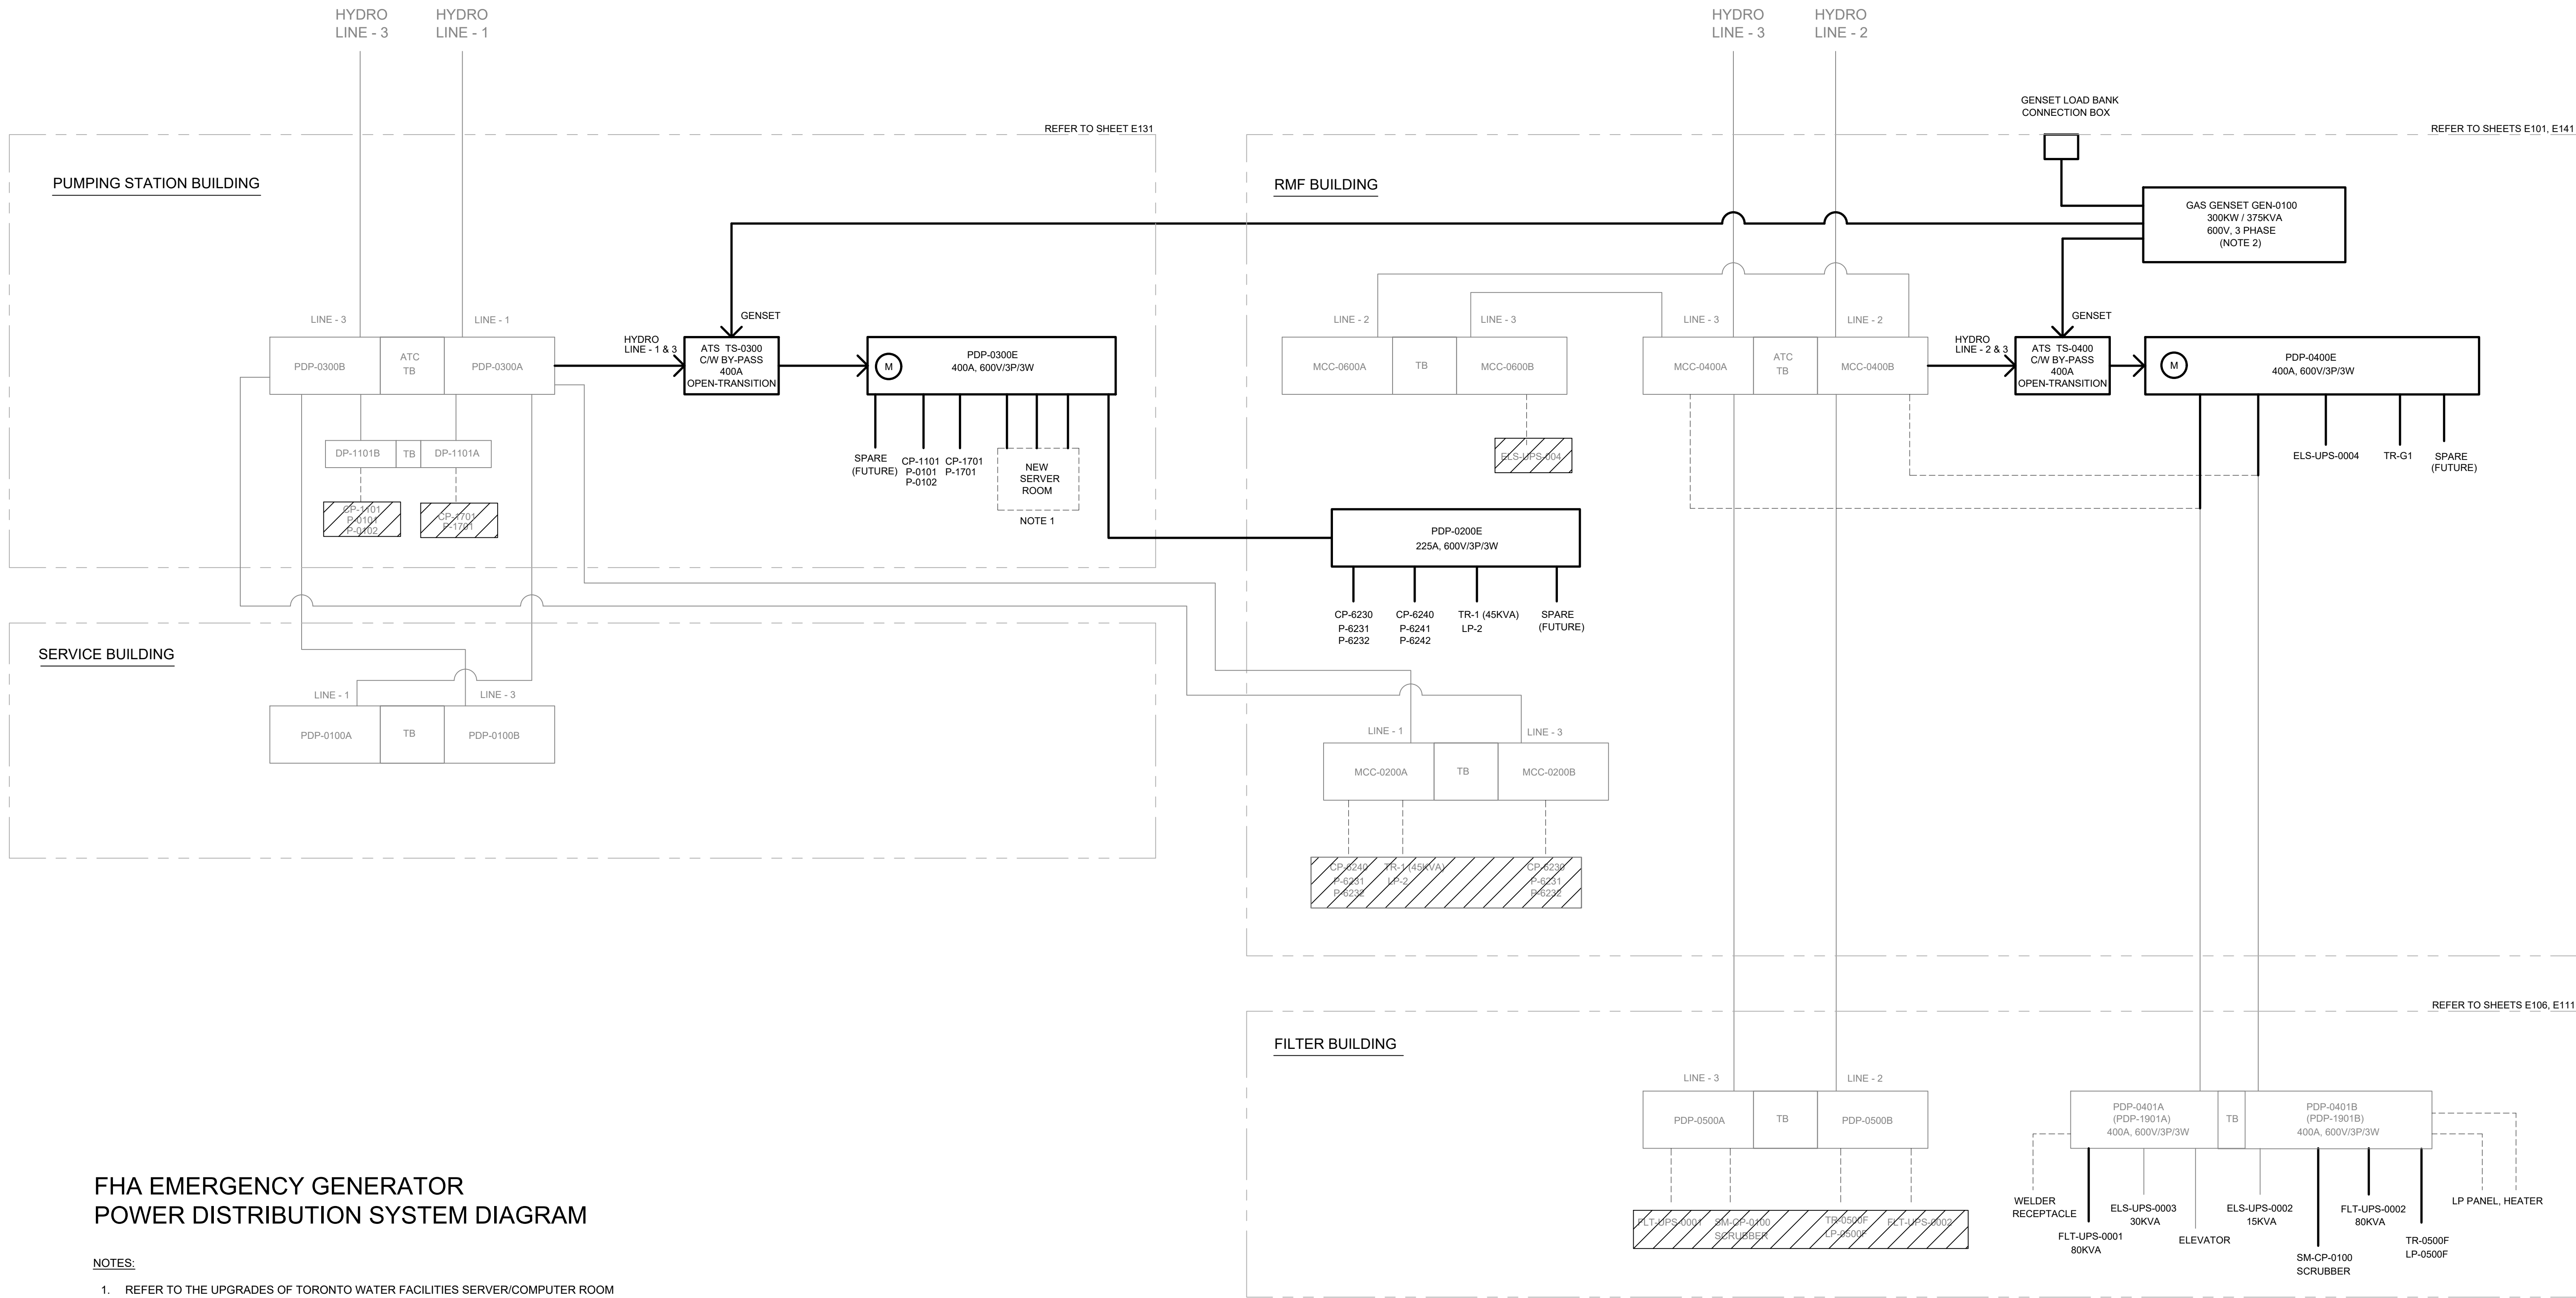

FHA EMERGENCY GENERATOR
POWER DISTRIBUTION SYSTEM DIAGRAM

NOTES:


- REFER TO THE UPGRADES OF TORONTO WATER FACILITIES SERVER/COMPUTER ROOM DRAWINGS E210, E211, E212, E213 AND E220.
- THIS GENERATOR WILL NOT BE OPERATED IN PARALLEL WITH UTILITY AND WILL NOT BE USED FOR LOAD DISPLACEMENT PURPOSES.

Drawing: J:\M16-0273 TOR_HARRISWTP-STANDBYGENERATOR\500_CAD\CAD\1-SS OR BU\SHEET\6 ELEC\2F-2017-08-34-E010.DWG
Layout: 03/19/2025 10:00 AM
Date: 03/19/2025 Time: 12:32:23 PM


										TORONTO WATER				R.C. HARRIS WATER TREATMENT PLANT											
										ENGINEERING AND CONSTRUCTION SERVICES				INSTALLATION OF A STANDBY GENERATOR FOR CRITICAL LOADS											
														MASTER POWER SYSTEM BLOCK DIAGRAM											
														ELECTRICAL											
										WILLIAM FERNANDES, P. ENG DIRECTOR WATER TREATMENT AND SUPPLY				SIMON HOPTON, P. ENG. DIRECTOR DESIGN & CONSTRUCTION MAJOR INFRASTRUCTURE				DESIGN: SC		DRAFTING: SC		CHECK: TS		CONTRACT No. 25ECS-MI-03HA	
																		SCALE: N.T.S.		DRAWING NUMBER: 2F-2017-08-34		E010			
																		DATE: 2024-09-30							

**** NEW DESIGN STARTS HERE
(DOWNSTREAM)**

125V DC
POWER SUPPLY

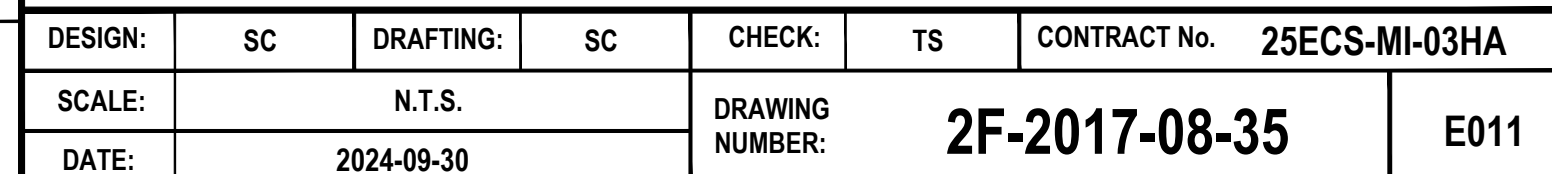

THIS DRAWING IS INTENDED TO SHOW OVERALL INTERCONNECTION BUT NOT NEW PDP INTERIOR DETAILS.

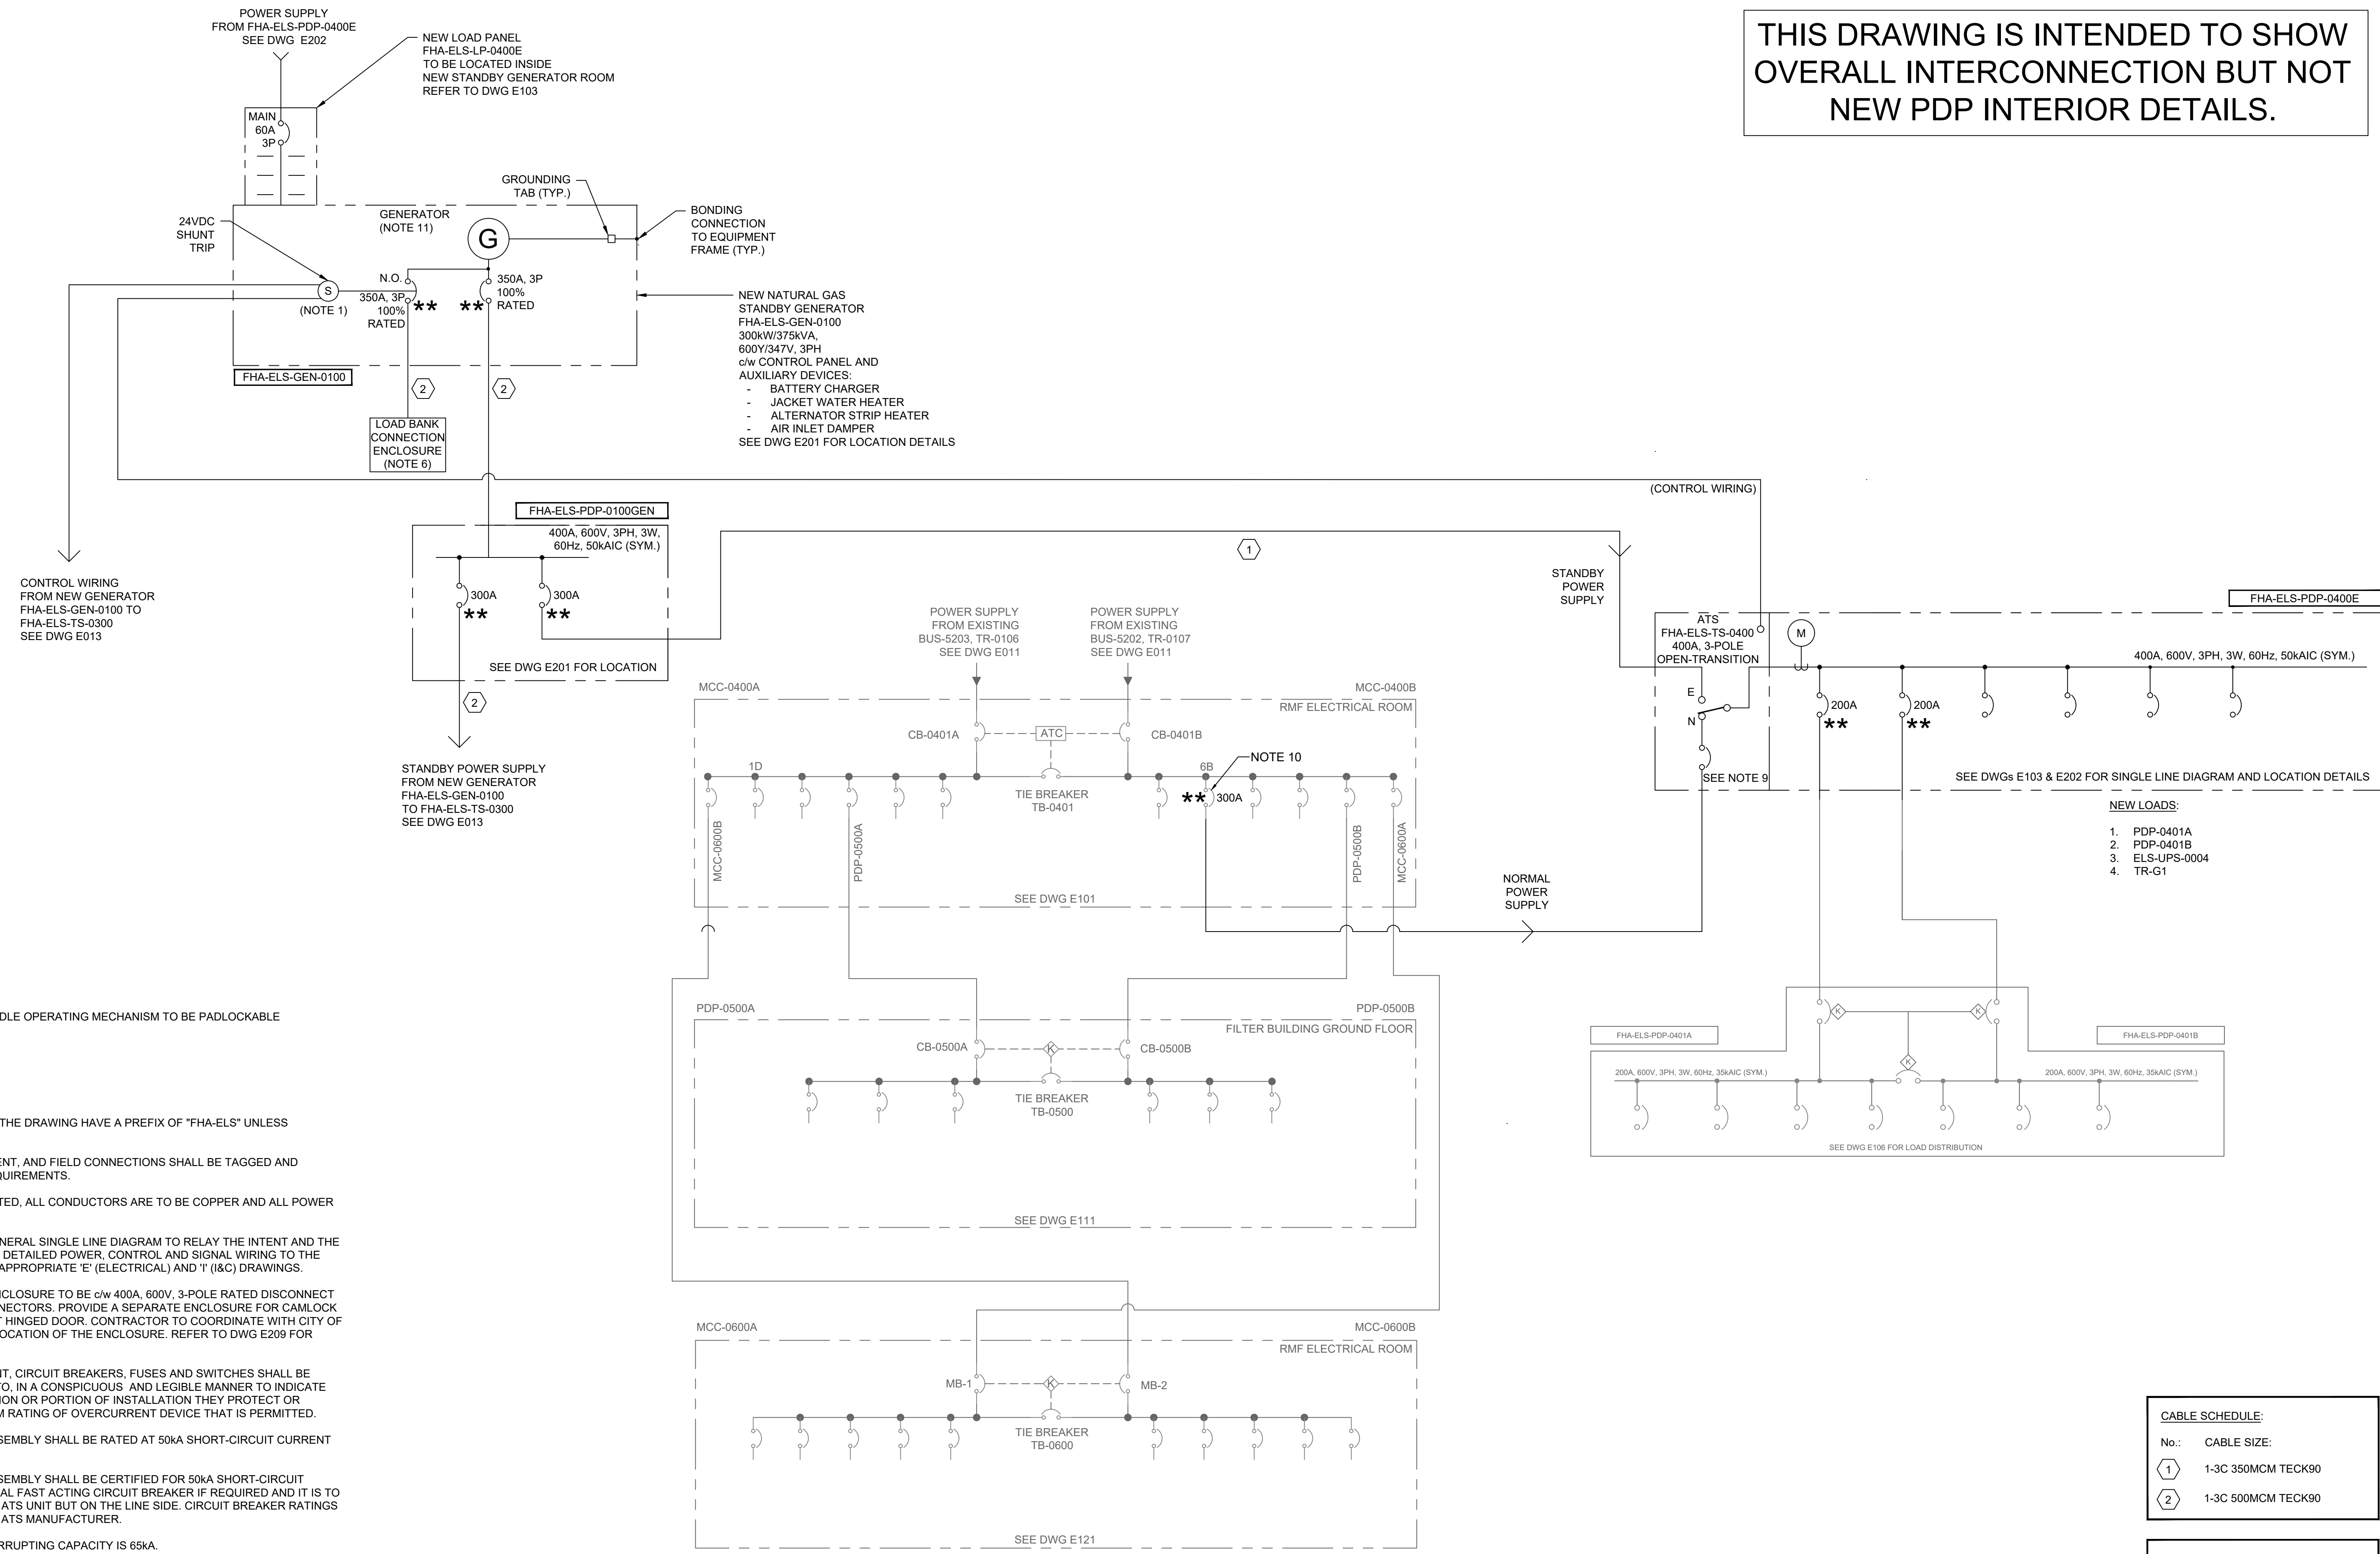

OVERALL GENERAL SINGLE LINE DIAGRAM 1

- **** CIRCUIT BREAKER's HANDLE OPERATING MECHANISM TO BE PADLOCKABLE IN THE 'OFF' POSITION.
- NOTES:**
- 'S' DENOTES SHUNT TRIP.
 - ALL TAG NAMES SHOWN ON THE DRAWING HAVE A PREFIX OF 'FHA-ELS' UNLESS OTHERWISE NOTED.
 - ALL CONDUCTORS, EQUIPMENT, AND FIELD CONNECTIONS SHALL BE TAGGED AND IDENTIFIED AS PER CITY REQUIREMENTS.
 - UNLESS OTHERWISE INDICATED, ALL CONDUCTORS ARE TO BE COPPER AND ALL POWER CABLES ARE TO BE TECK90.
 - THIS DRAWING SHOWS A GENERAL SINGLE LINE DIAGRAM TO RELAY THE INTENT AND THE SCOPE OF WORK ONLY. FOR DETAILED POWER, CONTROL AND SIGNAL WIRING TO THE PLANT PLCs, REFER TO THE APPROPRIATE 'E' (ELECTRICAL) AND 'I' (I&C) DRAWINGS.
 - LOAD BANK CONNECTION ENCLOSURE TO BE c/w 400A, 600V, 3-POLE RATED DISCONNECT SWITCH AND CAMLOCK CONNECTORS. PROVIDE A SEPARATE ENCLOSURE FOR CAMLOCK CONNECTIONS AND A FRONT HINGED DOOR. CONTRACTOR TO COORDINATE WITH CITY OF TORONTO FOR THE EXACT LOCATION OF THE ENCLOSURE. REFER TO DWG E209 FOR LOCATION DETAILS.
 - AT EACH DISTRIBUTION POINT, CIRCUIT BREAKERS, FUSES AND SWITCHES SHALL BE MARKED, ADJACENT THERETO, IN A CONSPICUOUS AND LEGIBLE MANNER TO INDICATE CLEARLY WHICH INSTALLATION OR PORTION OF INSTALLATION THEY PROTECT OR CONTROL AND THE MAXIMUM RATING OF OVERCURRENT DEVICE THAT IS PERMITTED.
 - EACH NEW ATS AND PDP ASSEMBLY SHALL BE RATED AT 50KA SHORT-CIRCUIT CURRENT RATING.
 - EACH NEW ATS AND PDP ASSEMBLY SHALL BE CERTIFIED FOR 50KA SHORT-CIRCUIT CURRENT RATING. ADDITIONAL FAST ACTING CIRCUIT BREAKER IF REQUIRED AND IT IS TO BE PLACED INSIDE THE NEW ATS UNIT BUT ON THE LINE SIDE. CIRCUIT BREAKER RATINGS TO BE AS REQUIRED BY THE ATS MANUFACTURER.
 - THE CIRCUIT BREAKER INTERRUPTING CAPACITY IS 65KA.
 - THIS GENERATOR WILL NOT BE OPERATED IN PARALLEL WITH UTILITY AND WILL NOT BE USED FOR LOAD DISPLACEMENT PURPOSES.


CABLE SCHEDULE:	
No.:	CABLE SIZE:
1	1-3C 350MCM TECK90
2	1-3C 500MCM TECK90

—	EXISTING
—	NEW

Drawing: J:\M16-0273 TOR_HARRISWTP-STANDBYGENERATOR\500_CAD\401-CAD\1-SS OR BU\SHEET\6 ELEC\2F-2017-08-36-E012.DWG
Layout: E012
Date: 03/19/2025 Time: 12:32:53 PM

				TORONTO WATER ENGINEERING AND CONSTRUCTION SERVICES		R.C. HARRIS WATER TREATMENT PLANT INSTALLATION OF A STANDBY GENERATOR FOR CRITICAL LOADS OVERALL GENERAL SINGLE LINE DIAGRAM 1	
				WILLIAM FERNANDES, P.ENG DIRECTOR WATER TREATMENT AND SUPPLY	SIMON HOPTON, P. ENG. DIRECTOR DESIGN & CONSTRUCTION MAJOR INFRASTRUCTURE		
COPYRIGHT: This drawing has been prepared solely for the intended use. Thus, any reproduction or distribution for any purpose other than authorized by ARCADIS is forbidden. Written dimensions shall have precedence over scaled dimensions. Contractors shall verify and be responsible for all dimensions and conditions on the job, and ARCADIS shall be informed of any variations from the dimensions and conditions shown on the drawing. Shop drawings shall be submitted to IRI Group for general conformance before proceeding with fabrication.		A 2025-03-18 ISSUED FOR TENDER T.S.		ELECTRICAL			
ARCADIS Professional Services (Canada) Inc.		NO. DATE REVISIONS INITIAL SIGNED		DESIGN: SC	DRAFTING: SC	CHECK: TS	CONTRACT No. 25ECS-MI-03HA
				SCALE: N.T.S.	DRAWING NUMBER: 2F-2017-08-36		E012
				DATE: 2024-09-30			

THIS DRAWING IS INTENDED TO SHOW
OVERALL INTERCONNECTION BUT NOT
NEW PDP INTERIOR DETAILS.

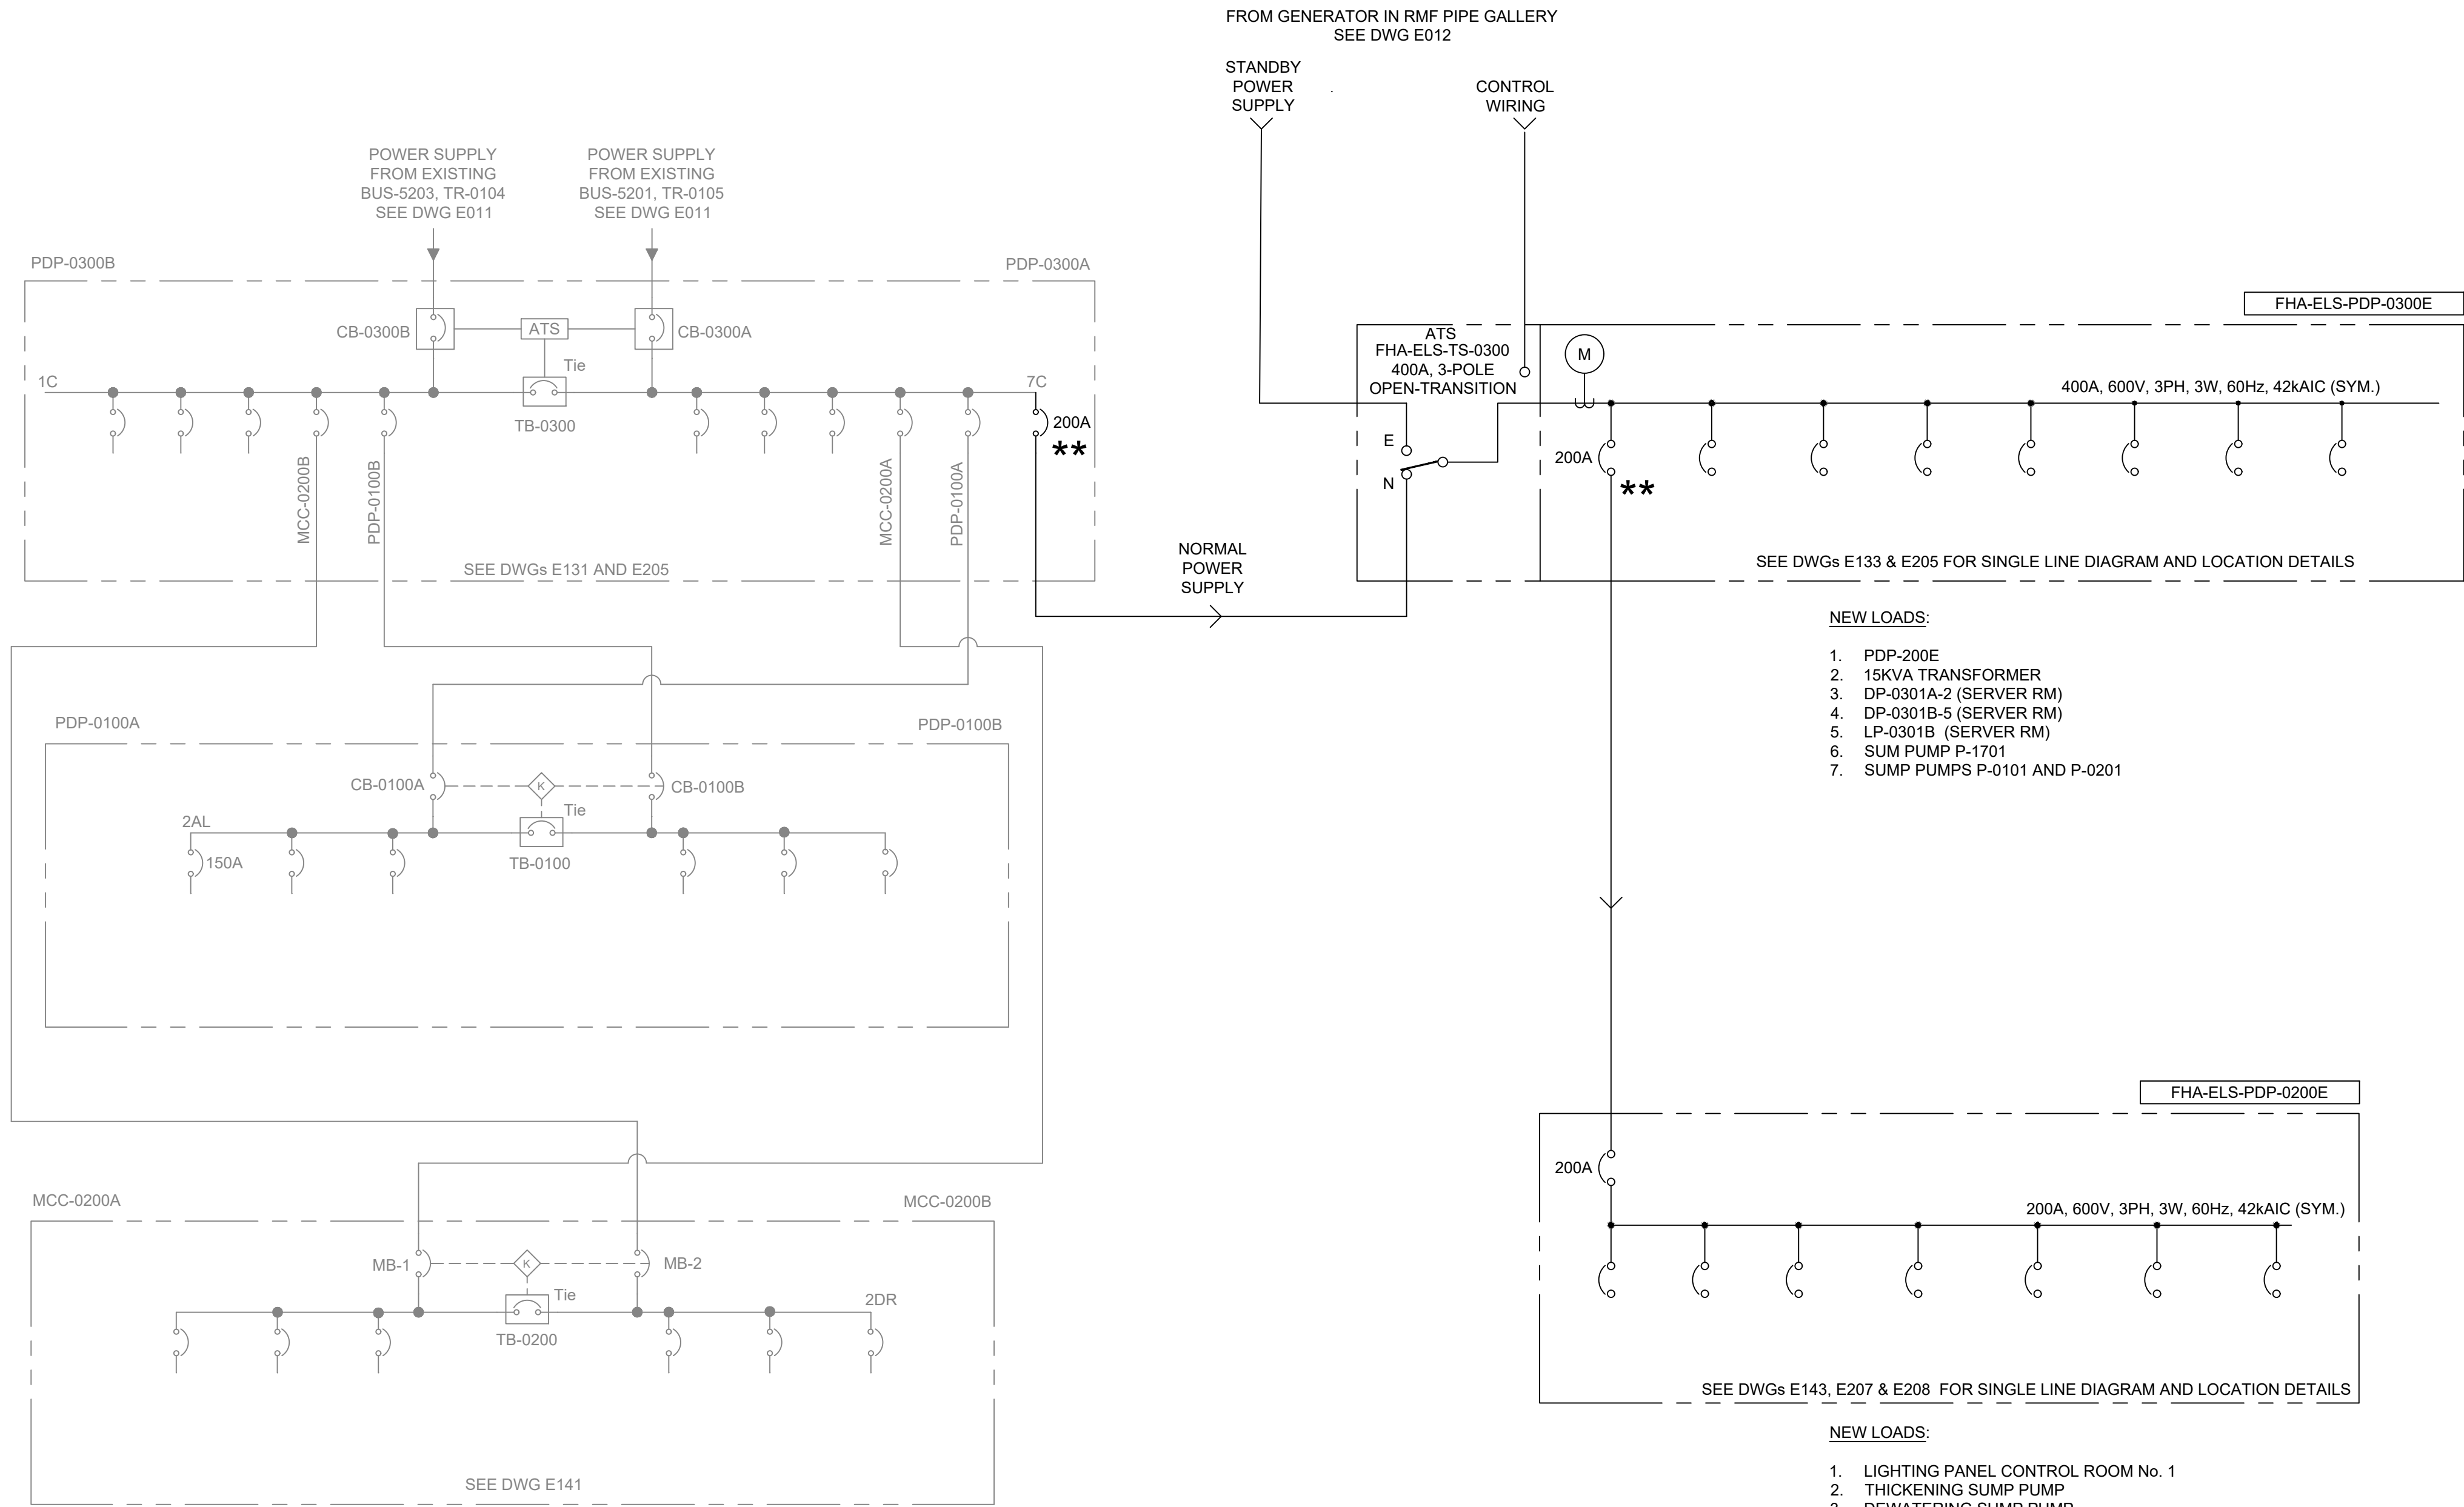


★★ CIRCUIT BREAKER's HANDLE OPERATING MECHANISM TO BE PADLOCKABLE IN THE 'OFF' POSITION.

NOTES:

1. 'S' DENOTES SHUNT TRIP.
2. ALL TAG NAMES SHOWN ON THE DRAWING HAVE A PREFIX OF "FHA-ELS" UNLESS OTHERWISE NOTED.
3. ALL CONDUCTORS, EQUIPMENT, AND FIELD CONNECTIONS SHALL BE TAGGED AND IDENTIFIED AS PER CITY REQUIREMENTS.
4. UNLESS OTHERWISE INDICATED, ALL CONDUCTORS ARE TO BE COPPER AND ALL POWER CABLES ARE TO BE TECK90.
5. THIS DRAWING SHOWS A GENERAL SINGLE LINE DIAGRAM TO RELAY THE INTENT AND THE SCOPE OF WORK ONLY. FOR DETAILED POWER, CONTROL AND SIGNAL WIRING TO THE PLANT PLCs, REFER TO THE APPROPRIATE 'E' (ELECTRICAL) AND 'I' (I&C) DRAWINGS.
6. AT EACH DISTRIBUTION POINT, CIRCUIT BREAKERS, FUSES AND SWITCHES SHALL BE MARKED, ADJACENT THERETO, IN A CONSPICUOUS AND LEGIBLE MANNER TO INDICATE CLEARLY WHICH INSTALLATION OR PORTION OF INSTALLATION THEY PROTECT OR CONTROL AND THE MAXIMUM RATING OF OVERCURRENT DEVICE THAT IS PERMITTED. RULE 2-100(3).


OVERALL GENERAL SINGLE LINE DIAGRAM 2

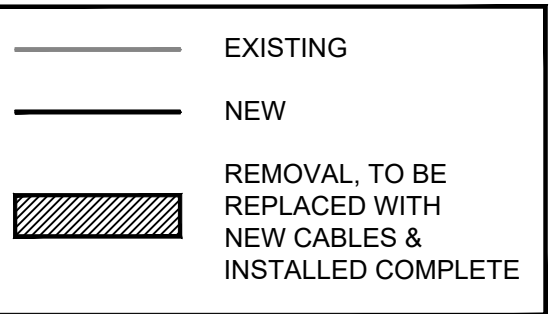

											TORONTO WATER				R.C. HARRIS WATER TREATMENT PLANT INSTALLATION OF A STANDBY GENERATOR FOR CRITICAL LOADS OVERALL GENERAL SINGLE LINE DIAGRAM 2						
											ENGINEERING AND CONSTRUCTION SERVICES										
 100-175 GALAXY BOULEVARD TORONTO, ONTARIO, M9W 0C9 TEL 416 679 1930 FAX 416 675 4620 www.arcadis.com		COPYRIGHT: This drawing has been prepared solely for the intended use, thus any reproduction or distribution for any purpose other than authorized by ARCADIS is forbidden. Written dimensions shall have precedence over scaled dimensions. Contractors shall verify and be responsible for all dimensions and conditions on the job, and ARCADIS shall be informed of any variations from the dimensions and conditions shown on the drawing. Shop drawings shall be submitted to the Client for general conformance before proceeding with fabrication.										WILLIAM FERNANDES, P. ENG DIRECTOR WATER TREATMENT AND SUPPLY		SIMON HOPTON, P. ENG. DIRECTOR DESIGN & CONSTRUCTION MAJOR INFRASTRUCTURE							
							ELECTRICAL														
		DESIGN:		SC	DRAFTING:		SC	CHECK:								TS	CONTRACT No.		25ECS-MI-03HA		
		SCALE:		N.T.S.					DRAWING NUMBER:							2F-2017-08-37			E013		
		A		2025-03-18		ISSUED FOR TENDER		T.S.													
		NO.		DATE		REVISIONS		INITIAL		SIGNED											

Drawing: J:\M16-0273 TOR_HARRISWTP-STANDBYGENERATOR\500_CAD\401-CAD-OR BU\SHEET\6 ELEC\2F-2017-08-37-E013.DWG
Layout: 03/19/2025
Date: 03/19/2025
Time: 12:33:05 PM

Drawing: J:\M16-0273 TOR_HARRISWTP-STANDBYGENERATOR\500_CAD\401-CAD\1-SS OR BU\SHEET\6 ELEC\2F-2017-08-38-E014.DWG
Layout: E014
Date: 03/19/2025 Time: 12:33:15 PM

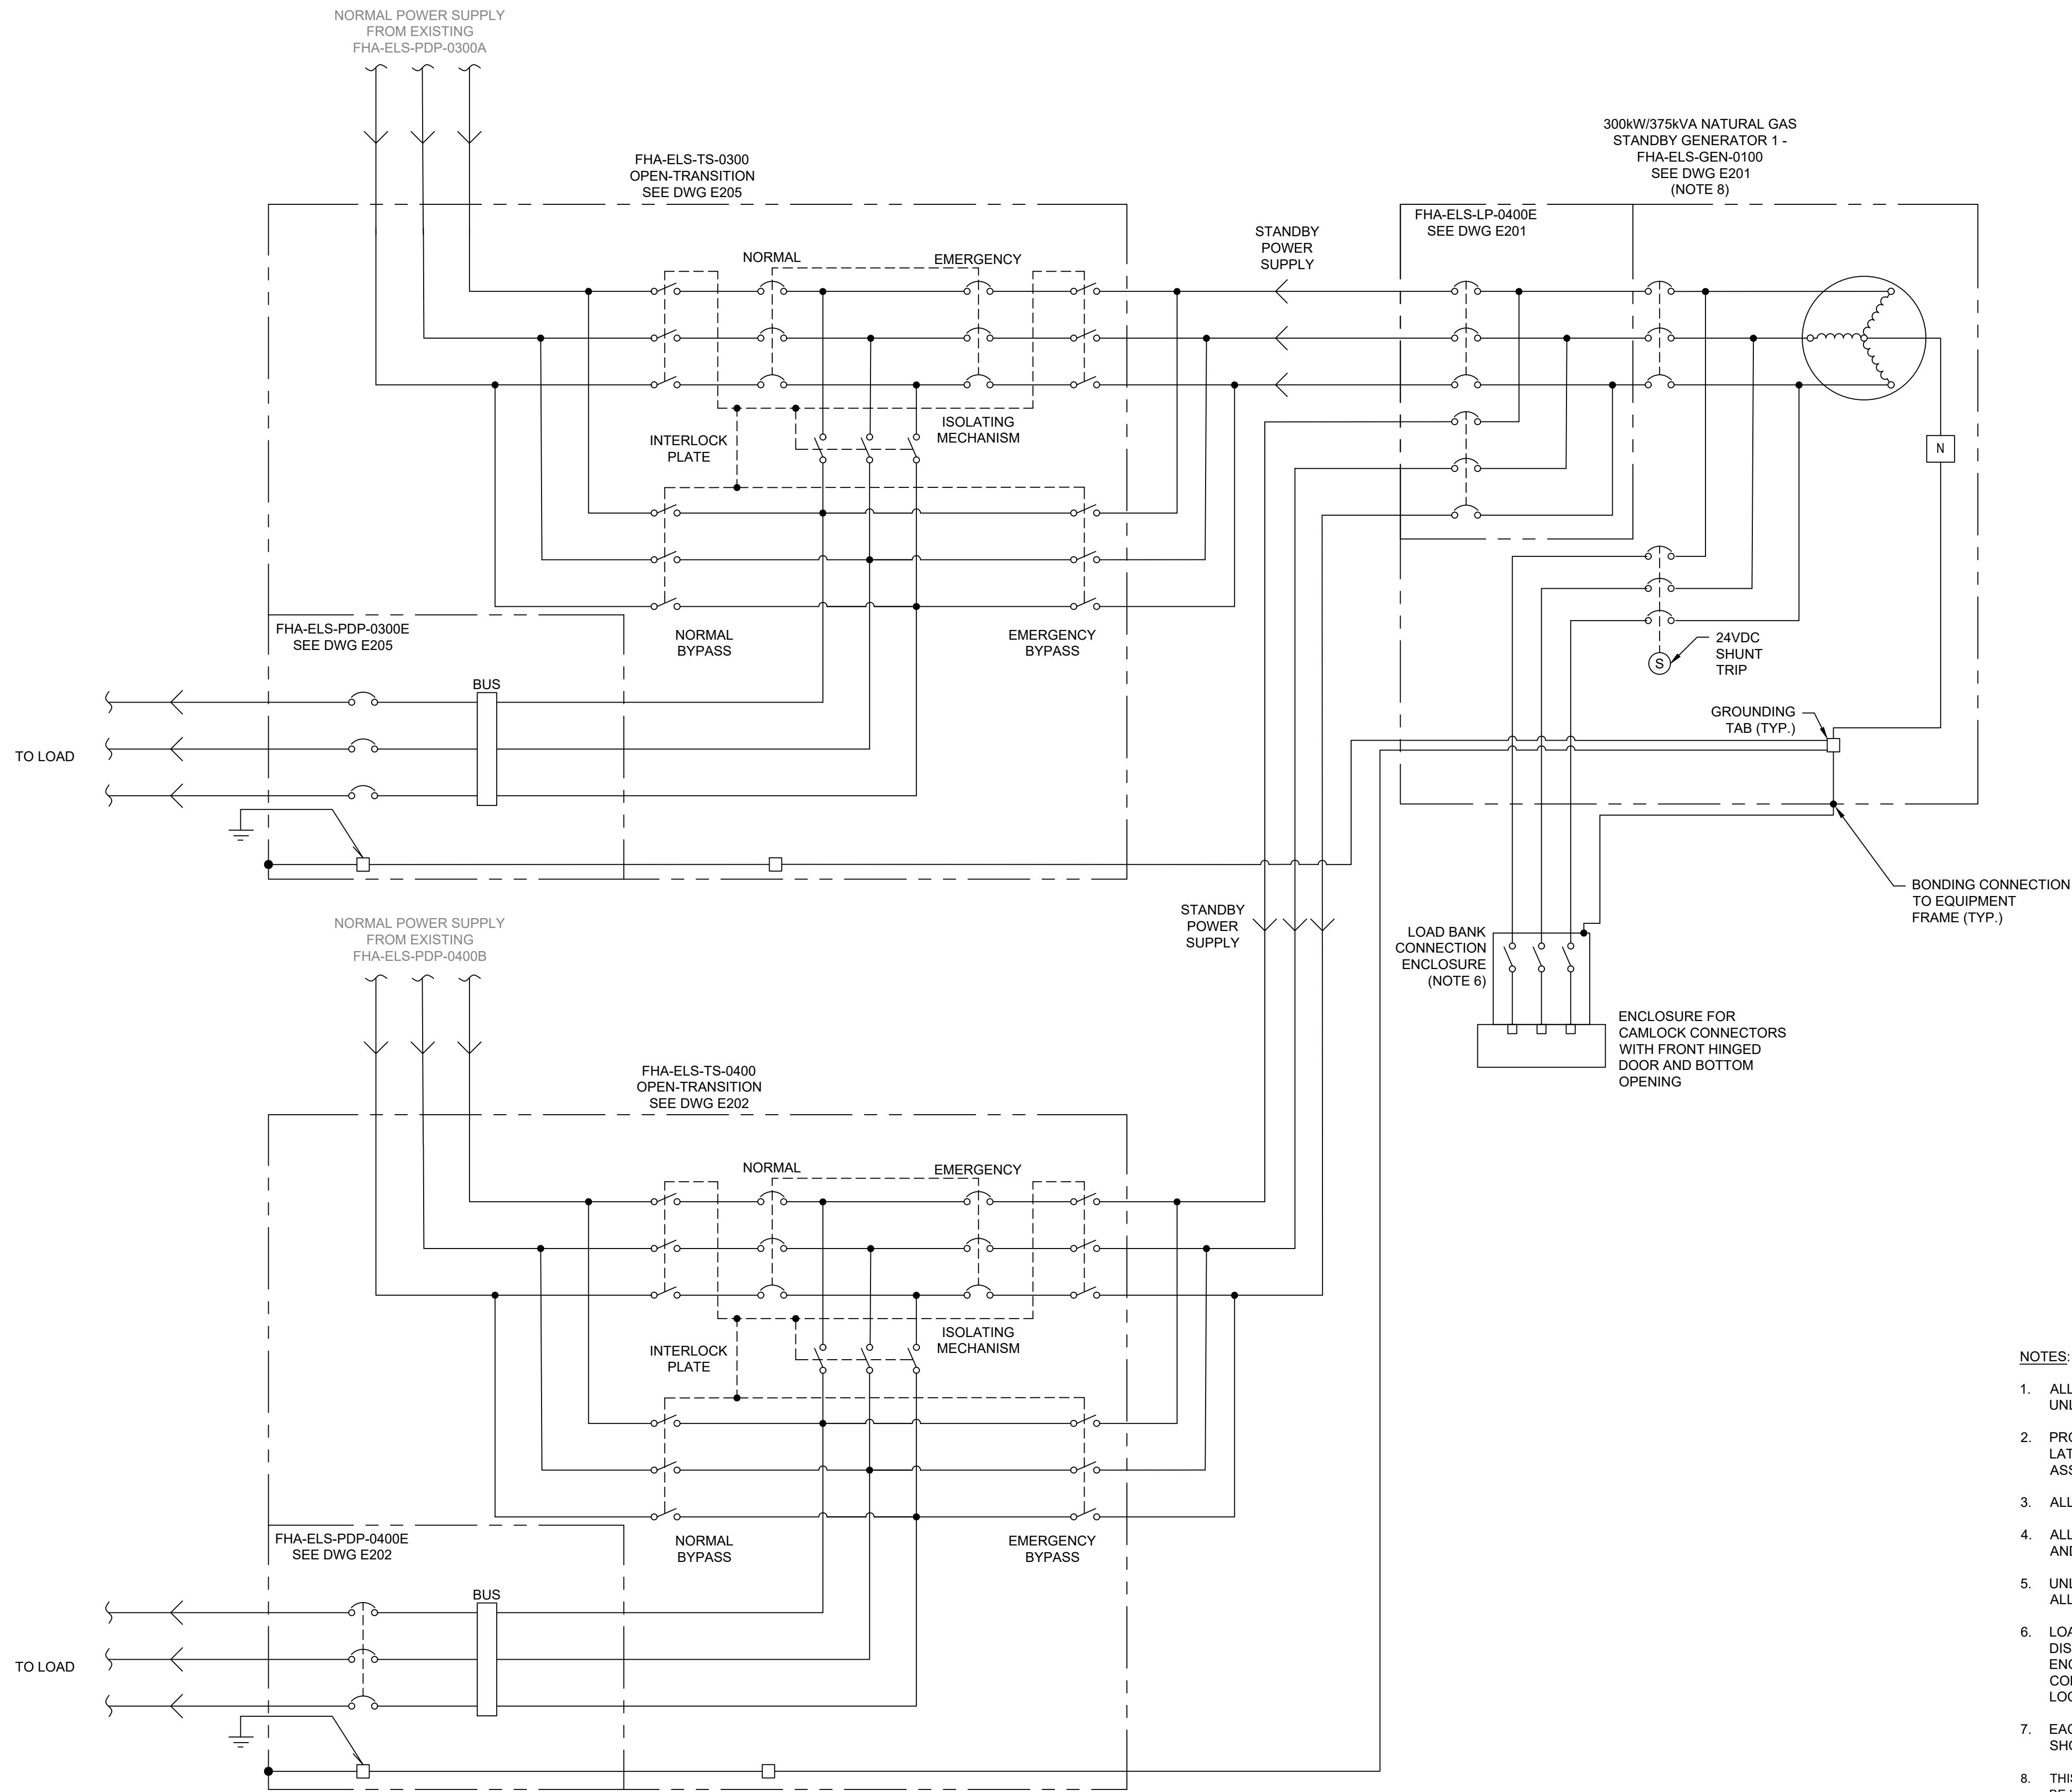

- NOTES:**
- ALL TAG NAMES SHOWN ON THE DRAWING HAVE A PREFIX OF "FHA-ELS" UNLESS OTHERWISE NOTED.
 - PROVIDE COMPLETE GROUNDING SYSTEM FOR ALL EQUIPMENT AS PER THE LATEST EDITION OF THE ONTARIO ELECTRICAL SAFETY CODE AND ASSOCIATED BULLETINS.
 - ALL NEW ATS UNITS TO BE PROVIDED WITH DOUBLE SIDED BYPASS ISOLATION.
 - ALL CONDUCTORS, EQUIPMENT, AND FIELD CONNECTIONS SHALL BE TAGGED AND IDENTIFIED AS PER CITY REQUIREMENTS.
 - UNLESS OTHERWISE INDICATED, ALL CONDUCTORS ARE TO BE COPPER AND ALL POWER CABLES ARE TO BE TECK90.
 - LOAD BANK CONNECTION ENCLOSURE TO BE c/w 400A, 600V, 3-POLE RATED DISCONNECT SWITCH AND CAMLOCK CONNECTORS. PROVIDE A SEPARATE ENCLOSURE FOR CAMLOCK CONNECTIONS AND A FRONT HINGED DOOR. CONTRACTOR TO COORDINATE WITH CITY OF TORONTO FOR THE EXACT LOCATION OF THE ENCLOSURE. REFER TO DWG E209 FOR LOCATION DETAILS.
 - EACH NEW ATS AND PDP ASSEMBLY SHALL BE CERTIFIED FOR 50kA SHORT-CIRCUIT CURRENT RATING.
 - THIS GENERATOR WILL NOT BE OPERATED IN PARALLEL WITH UTILITY AND WILL NOT BE USED FOR LOAD DISPLACEMENT PURPOSES.

ATS (DOUBLE SIDED BYPASS ISOLATION) & STANDBY GENERATOR WIRING SCHEMATIC

—	EXISTING
—	NEW

								TORONTO WATER				R.C. HARRIS WATER TREATMENT PLANT INSTALLATION OF A STANDBY GENERATOR FOR CRITICAL LOADS ATS & STANDBY GENERATOR WIRING SCHEMATIC													
								ENGINEERING AND CONSTRUCTION SERVICES																	
									WILLIAM FERNANDES, P. ENG DIRECTOR WATER TREATMENT AND SUPPLY		SIMON HOPTON, P. ENG. DIRECTOR DESIGN & CONSTRUCTION MAJOR INFRASTRUCTURE														
												ELECTRICAL													
												DESIGN:	SC	DRAFTING:	SC	CHECK:	TS	CONTRACT No. 25ECS-MI-03HA							
												SCALE:	N.T.S.				DRAWING NUMBER:	2F-2017-08-38				E014			
												DATE:	2024-09-30												
 100-175 GALAXY BOULEVARD TORONTO, ONTARIO, M9W 0C9 TEL 416 679 1930 FAX 416 675 4620 www.arcadis.com		COPYRIGHT: This drawing has been prepared solely for the intended use, thus any reproduction or distribution for any purpose other than authorized by ARCADIS is forbidden. Written dimensions shall have precedence over scaled dimensions. Contractors shall verify and be responsible for all dimensions and conditions on the job, and ARCADIS shall be informed of any variations from the dimensions and conditions shown on the drawing. Shop drawings shall be submitted to IBI Group for general conformance before proceeding with fabrication.						A 2025-03-18		ISSUED FOR TENDER		T.S.													
		NO.	DATE	REVISIONS				INITIAL		SIGNED															

SEQUENCE OF OPERATION

NORMAL CONDITIONS:

- HYDRO UTILITY POWER IS PROVIDED TO THE PLANT THROUGH THREE (3) INDEPENDENT LINES;
 - TWO (2) DEDICATED FEEDERS LINE 1 AND LINE 2, AND ONE (1) NON-DEDICATED FEEDER LINE 3.
1. LINE 1 SUPPLIES POWER TO BUS-5201 WHICH SUPPLIES POWER TO PDP-300A THROUGH TRANSFORMER TR-0105. LINE 2 SUPPLIES POWER TO BUS-5202, WHICH SUPPLIES POWER TO MCC-0400B THROUGH TRANSFORMER TR-0107. LINE 3 SUPPLIES POWER TO BUS-5203, WHICH SUPPLIES POWER TO PDP-0300B & MCC-0400A THROUGH TRANSFORMER TR-104 & TR-0106 RESPECTIVELY.
 2. PDP-0300A (HYDRO LINE 1) SUPPLIES POWER TO NEW PDP-0300E & PDP-0200E.
 3. MCC-0400B (HYDRO LINE 2) SUPPLIES POWER TO NEW PDP-0400E & PDP-0401A/B.
 4. THE NEW STANDBY GENERATOR IS OFF AND SET TO AUTO.
 5. THE AUTOMATIC TRANSFER SWITCHES TS-0300 & TS-0400 ARE SET TO AUTO AND THEIR UTILITY SIDE (NORMAL) CIRCUIT BREAKER IS CLOSED.
 6. TS-0300 IS POWERED THROUGH AND MONITOR POWER AT PDP-0300A.
 7. TS-0400 IS POWERED THROUGH AND MONITOR POWER AT MCC-0400B.
 8. PDP-0300's TIE BREAKER TB-0300 IS OPEN.
 9. MCC-0400's TIE BREAKER TB-0401 IS OPEN.

EMERGENCY CONDITIONS 1 (GENERATOR REMAINS OFF):

- THE NEW STANDBY GENERATOR IS OFF AND SET TO AUTO.
- THE AUTOMATIC TRANSFER SWITCHES TS-0300 & TS-0400 ARE SET TO AUTO AND THEIR UTILITY SIDE CIRCUIT BREAKER IS CLOSED.

SCENARIOS:

1. **HYDRO UTILITY POWER LINE 3 (OFF) - LINE 1 (ON) - LINE 2 (ON):**
 - 1.1. POWER INTERRUPTION TO PDP-0300B. NO INTERRUPTION TO PDP-0300A. TIE BREAKER TB-0300 CLOSSES AFTER A TIME DELAY OF APPROXIMATELY 5-10 SECONDS AND POWER IS RESTORED TO PDP-0300B VIA PDP-0300A THROUGH LINE 1 ALONE. TS-0300 DETECTS POWER RESTORATION ON PDP-0300A WITHIN 45 SECONDS TIME DELAY. STANDBY GENERATOR STAYS OFF.
 - 1.2. POWER INTERRUPTION TO MCC-0400A. NO INTERRUPTION TO MCC-0400B & PDP-0400E. TIE BREAKER TB-0401 CLOSSES AFTER A TIME DELAY OF APPROXIMATELY 5-10 SECONDS AND POWER IS RESTORED TO MCC-0400A VIA MCC-0400B THROUGH LINE 2 ALONE. TS-0400 DETECTS POWER RESTORATION ON PDP-0400A WITHIN 45 SECONDS TIME DELAY. STANDBY GENERATOR STAYS OFF.
2. **HYDRO UTILITY POWER LINE 3 (ON) - LINE 1 (OFF) - LINE 2 (ON):**
 - 2.1. POWER INTERRUPTION TO PDP-300A & PDP-300E. NO INTERRUPTION TO PDP-0300B. TS-0300 DETECTS LOSS OF POWER ON PDP-0300A AND ATS 45 SECONDS (ADJUSTABLE) TIME DELAY COUNT STARTS. TIE BREAKER TB-0300 CLOSSES AFTER A TIME DELAY OF APPROXIMATELY 5-10 SECONDS AND POWER IS RESTORED TO PDP-0300A & PDP-0300E VIA PDP-0300B THROUGH LINE 3 ALONE. TS-0300 DETECTS POWER RESTORATION ON PDP-0300A WITHIN 45 SECONDS TIME DELAY. STANDBY GENERATOR STAYS OFF.
3. **HYDRO UTILITY POWER LINE 3 (ON) - LINE 1 (ON) - LINE 2 (OFF):**
 - 3.1. POWER INTERRUPTION TO MCC-0400B & PDP-0400E. NO INTERRUPTION TO MCC-0400A. TS-0400 DETECTS LOSS OF POWER ON MCC-0400B AND ATS 45 SECONDS (ADJUSTABLE) TIME DELAY COUNT STARTS. TIE BREAKER TB-0400 CLOSSES AFTER A TIME DELAY OF APPROXIMATELY 5-10 SECONDS AND POWER IS RESTORED TO MCC-0400B & PDP-0400E VIA MCC-0400A THROUGH LINE 3 ALONE. TS-0300 DETECTS POWER RESTORATION ON MCC-0400B WITHIN 45 SECONDS TIME DELAY. STANDBY GENERATOR STAYS OFF.
4. **HYDRO UTILITY POWER LINE 3 (ON) - LINE 1 (OFF) - LINE 2 (OFF):**
 - 4.1. POWER INTERRUPTION TO PDP-300A & PDP-300E. NO INTERRUPTION TO PDP-0300B. TS-0300 DETECTS LOSS OF POWER ON PDP-0300A AND ATS 45 SECONDS (ADJUSTABLE) TIME DELAY COUNT STARTS. TIE BREAKER TB-0300 CLOSSES AFTER A TIME DELAY OF APPROXIMATELY 5-10 SECONDS AND POWER IS RESTORED TO PDP-0300A & PDP-0300E VIA PDP-0300B THROUGH LINE 3 ALONE. TS-0300 DETECTS POWER RESTORATION ON PDP-0300A WITHIN 45 SECONDS TIME DELAY. STANDBY GENERATOR STAYS OFF.
 - 4.2. POWER INTERRUPTION TO MCC-0400B & PDP-0400E. NO INTERRUPTION TO MCC-0400A. TS-0400 DETECTS LOSS OF POWER ON MCC-0400B AND ATS 45 SECONDS (ADJUSTABLE) TIME DELAY COUNT STARTS. TIE BREAKER TB-0400 CLOSSES AFTER A TIME DELAY OF APPROXIMATELY 5-10 SECONDS AND POWER IS RESTORED TO MCC-0400B & PDP-0400E VIA MCC-0400A THROUGH LINE 3 ALONE. TS-0300 DETECTS POWER RESTORATION ON MCC-0400B WITHIN 45 SECONDS TIME DELAY. STANDBY GENERATOR STAYS OFF.


EMERGENCY CONDITIONS 2 (GENERATOR POWERS PART ESSENTIAL LOAD):

- THE NEW STANDBY GENERATOR IS OFF AND SET TO AUTO.
- THE AUTOMATIC TRANSFER SWITCHES TS-0300, TS-0400 ARE SET TO AUTO AND THEIR UTILITY SIDE CIRCUIT BREAKER IS CLOSED.
- TS-0300 IS POWERED THROUGH AND MONITOR POWER AT PDP-0300A.
- TS-0400 IS POWERED THROUGH AND MONITOR POWER AT MCC-0400B.

SCENARIOS:

1. **HYDRO UTILITY POWER LINE 3 (OFF) - LINE 1 (OFF) - LINE 2 (ON):**
 - 1.1. POWER INTERRUPTION TO PDP-0300A/B & PDP-0300E. TIE BREAKER TB-0300 CLOSSES AFTER A TIME DELAY OF APPROXIMATELY 5-10 SECONDS. TS-0300 DETECTS LOSS OF POWER ON PDP-0300A, ATS 45 SECONDS (ADJUSTABLE) TIME DELAY COUNT STARTS. AFTER APPROXIMATELY 45 SECONDS (ADJUSTABLE), IF POWER IS STILL UNDETECTED, TS-0300 WILL SEND A SIGNAL TO THE STANDBY GENERATOR TO START. ONCE THE GENERATOR REACHES OPTIMUM PERFORMANCE TS-0300 UTILITY (NORMAL) SIDE WILL OPEN FIRST, THEN THE EMERGENCY SIDE WILL CLOSE, PROVIDING POWER TO PDP-0300E FROM THE STANDBY GENERATOR.
 - 1.2. POWER INTERRUPTION TO MCC-0400A. NO INTERRUPTION TO MCC-0400B & PDP-0400E. TIE BREAKER TB-0401 CLOSSES AFTER A TIME DELAY OF APPROXIMATELY 5-10 SECONDS AND POWER IS RESTORED TO MCC-0400A VIA MCC-0400B THROUGH LINE 2 ALONE. TS-0400 DETECTS POWER RESTORATION ON PDP-0400A WITHIN 45 SECONDS TIME DELAY. STANDBY GENERATOR STAYS OFF.
2. **HYDRO UTILITY POWER LINE 3 (OFF) - LINE 1 (ON) - LINE 2 (OFF):**
 - 2.1. POWER INTERRUPTION TO MCC-400A/B & PDP-400E. TIE BREAKER TB-0401 CLOSSES AFTER A TIME DELAY OF APPROXIMATELY 5-10 SECONDS. TS-0400 DETECTS LOSS OF POWER ON MCC-0400B, ATS 45 SECONDS (ADJUSTABLE) TIME DELAY COUNT STARTS. AFTER APPROXIMATELY 45 SECONDS (ADJUSTABLE), IF POWER IS STILL UNDETECTED, TS-0400 WILL SEND A SIGNAL TO THE STANDBY GENERATOR TO START. ONCE THE GENERATOR REACHES OPTIMUM PERFORMANCE TS-0400 UTILITY (NORMAL) SIDE WILL OPEN FIRST, THEN THE EMERGENCY SIDE WILL CLOSE, PROVIDING POWER TO PDP-0400E FROM THE STANDBY GENERATOR.
 - 2.2. POWER INTERRUPTION TO PDP-0300B. NO INTERRUPTION TO PDP-0300A. TIE BREAKER TB-0300 CLOSSES AFTER A TIME DELAY OF APPROXIMATELY 5-10 SECONDS AND POWER IS RESTORED TO PDP-0300B VIA PDP-0300A THROUGH LINE 1 ALONE. TS-0300 DETECTS POWER RESTORATION ON PDP-0300A WITHIN 45 SECONDS TIME DELAY. STANDBY GENERATOR STAYS OFF.
3. **HYDRO UTILITY POWER LINE 3 (ON) - LINE 1 (OFF) - LINE 2 (ON) - TB-0300 (FAULT)**
 - 3.1. POWER INTERRUPTION TO PDP-0300A & PDP-0300E. NO INTERRUPTION TO PDP-0300B & MCC-0400A/B. TS-0300 DETECTS LOSS OF POWER ON PDP-0300A, ATS 45 SECONDS (ADJUSTABLE) TIME DELAY COUNT STARTS. TIE BREAKER TB-0300 FAILS TO CLOSE AFTER A TIME DELAY OF APPROXIMATELY 5-10 SECONDS. AFTER APPROXIMATELY 45 SECONDS (ADJUSTABLE), IF POWER IS STILL UNDETECTED ON PDP-0300A, TS-0300 WILL SEND A SIGNAL TO THE STANDBY GENERATOR TO START. ONCE THE GENERATOR REACHES OPTIMUM PERFORMANCE TS-0300 UTILITY (NORMAL) SIDE WILL OPEN FIRST, THEN THE EMERGENCY SIDE WILL CLOSE, PROVIDING POWER TO PDP-0300E FROM THE STANDBY GENERATOR.
4. **HYDRO UTILITY POWER LINE 3 (ON) - LINE 1 (ON) - LINE 2 (OFF) - TB-0400 (FAULT):**
 - 4.1. POWER INTERRUPTION TO MCC-0400B & PDP-400E. NO INTERRUPTION TO MCC-0400A & PDP-0300A/B. TS-0400 DETECTS LOSS OF POWER ON MCC-0400B, ATS 45 SECONDS (ADJUSTABLE) TIME DELAY COUNT STARTS. TIE BREAKER TB-0400 FAILS TO CLOSE AFTER A TIME DELAY OF APPROXIMATELY 5-10 SECONDS. AFTER APPROXIMATELY 45 SECONDS (ADJUSTABLE), IF POWER IS STILL UNDETECTED ON MCC-0400B, TS-0400 WILL SEND A SIGNAL TO THE STANDBY GENERATOR TO START. ONCE THE GENERATOR REACHES OPTIMUM PERFORMANCE TS-0400 UTILITY (NORMAL) SIDE WILL OPEN FIRST, THEN THE EMERGENCY SIDE WILL CLOSE, PROVIDING POWER TO PDP-0400E FROM THE STANDBY GENERATOR.
5. **HYDRO UTILITY POWER LINE 3 (ON) - LINE 1 (OFF) - LINE 2 (OFF) - TB-0300 (FAULT) OR TB-0400 (FAULT):**
 - 5.1. POWER INTERRUPTION TO PDP-300A & PDP-300E, MCC-400B & PDP-400E. NO INTERRUPTION TO PDP-0300B & MCC-400A. TS-0300 & TS-0400 DETECT LOSS OF POWER ON PDP-0300A & MCC-0400B RESPECTIVELY, ATS 45 SECONDS (ADJUSTABLE) TIME DELAY COUNT STARTS. TIE BREAKER TB-0300 OR TB-0400 FAILS TO CLOSE AFTER A TIME DELAY OF APPROXIMATELY 5-10 SECONDS. AFTER APPROXIMATELY 45 SECONDS (ADJUSTABLE), IF POWER IS STILL UNDETECTED ON PDP-0300A OR MCC-0400B, TS-0300 OR TS-0400 WILL SEND A SIGNAL TO THE STANDBY GENERATOR TO START. ONCE THE GENERATOR REACHES OPTIMUM PERFORMANCE, TS-0300 OR TS-0400 UTILITY (NORMAL) SIDE WILL OPEN FIRST, THEN THE EMERGENCY SIDE WILL CLOSE, PROVIDING POWER TO PDP-0300E OR PDP-0400E RESPECTIVELY FROM THE STANDBY GENERATOR.

REFER TO DWG MECHANICAL DRAWNGS FOR LOCATION DETAILS

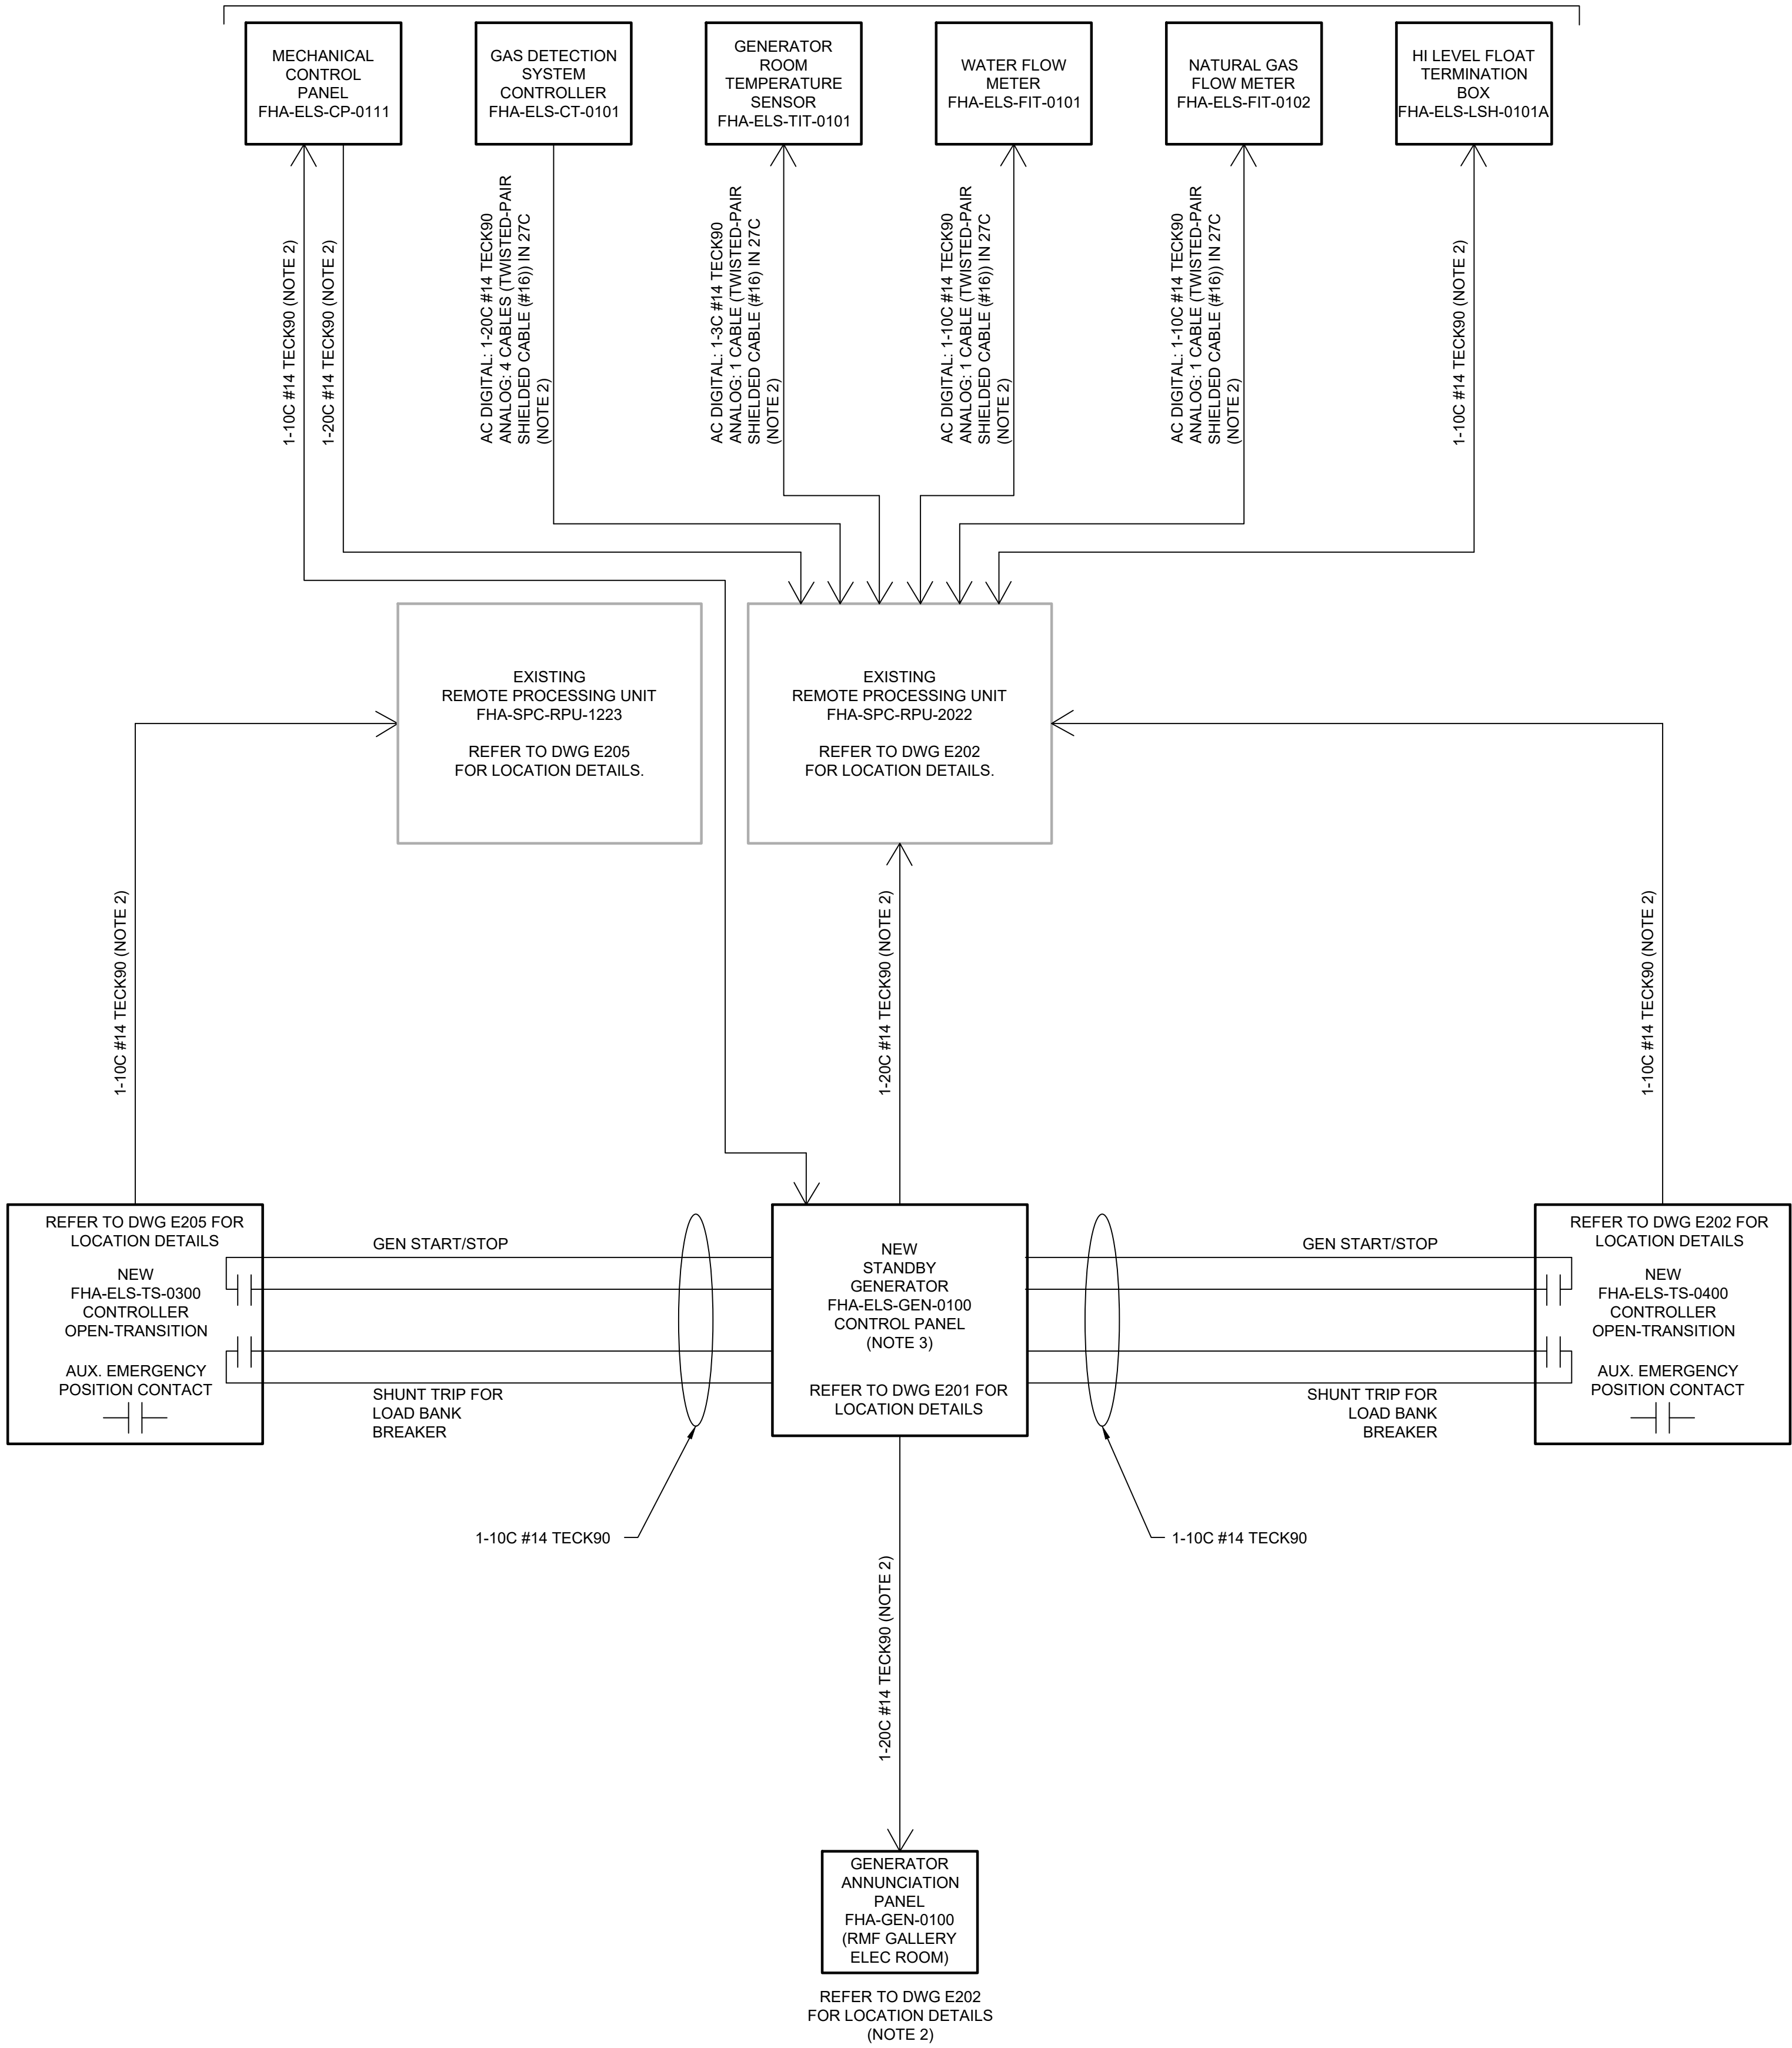

TYPICAL BLOCK DIAGRAM FOR CONTROL WIRING

NOTES:

1. ALL TAG NAMES SHOWN ON THE DRAWING HAVE A PREFIX OF "FHA-ELS" UNLESS OTHERWISE NOTED.
2. REFER TO I&C DRAWING I004 FOR TERMINAL & SIGNAL DETAIL REQUIREMENTS.
3. THIS GENERATOR WILL NOT BE OPERATED IN PARALLEL WITH UTILITY AND WILL NOT BE USED FOR LOAD DISPLACEMENT PURPOSES.

SEQUENCE OF OPERATION (CONT'D)

EMERGENCY CONDITIONS 3 (GENERATOR POWERS FULL ESSENTIAL LOAD):

- THE NEW STANDBY GENERATOR IS OFF AND SET TO AUTO.
- THE AUTOMATIC TRANSFER SWITCHES TS-0300, TS-0400, ARE SET TO AUTO AND THEIR UTILITY SIDE CIRCUIT BREAKER IS CLOSED.
 - TS-0300 IS POWERED THROUGH AND MONITOR POWER AT PDP-0300A.
 - TS-0400 IS POWERED THROUGH AND MONITOR POWER AT MCC-0400B.

SCENARIOS:

1. **HYDRO UTILITY POWER LINE 3 (OFF) - LINE 1 (OFF) - LINE 2 (OFF):**
 - 1.1. POWER INTERRUPTION TO PDP-300A/B & PDP-300E, MCC-400A/B & PDP-400E. TS-0300 & TS-0400 DETECT LOSS OF POWER ON PDP-0300A & MCC-0400B RESPECTIVELY. ATS 45 SECOND (ADJUSTABLE) TIME DELAY COUNT STARTS. AFTER APPROXIMATELY 45 SECONDS (ADJUSTABLE), IF POWER IS STILL UNDETECTED ON PDP-0300A AND MCC-0400B, TS-0300 AND TS-0400 WILL SEND A SIGNAL TO THE STANDBY GENERATOR TO START. ONCE THE GENERATOR REACHES OPTIMUM PERFORMANCE, TS-0300 AND TS-0400 UTILITY (NORMAL) SIDE WILL OPEN FIRST, THEN THE EMERGENCY SIDE WILL CLOSE, PROVIDING POWER TO PDP-0300E AND PDP-0400E FROM THE STANDBY GENERATOR.
2. **HYDRO UTILITY POWER LINE 3 (ON) - LINE 1 (OFF) - LINE 2 (OFF) - TB-0300 (FAULT) - TB-0401 (FAULT):**
 - 2.1. POWER INTERRUPTION TO PDP-300A & PDP-300E, MCC-400B & PDP-400E. NO INTERRUPTION TO PDP-0300B & MCC-400A. TS-0300 & TS-0400 DETECT LOSS OF POWER ON PDP-0300A & MCC-0400B RESPECTIVELY. ATS 45 SECONDS (ADJUSTABLE) TIME DELAY COUNT STARTS. TIE BREAKERS TB-0300 AND TB-0400 FAIL TO CLOSE AFTER A TIME DELAY OF APPROXIMATELY 5-10 SECONDS. AFTER APPROXIMATELY 45 SECONDS (ADJUSTABLE), IF POWER IS STILL UNDETECTED ON PDP-0300A AND MCC-0400B, TS-0300 AND TS-0400 WILL SEND A SIGNAL TO THE STANDBY GENERATOR TO START. ONCE THE GENERATOR REACHES OPTIMUM PERFORMANCE TS-0300 AND TS-0400 UTILITY (NORMAL) SIDE WILL OPEN FIRST, THEN THE EMERGENCY SIDE WILL CLOSE, PROVIDING POWER TO PDP-0300E AND PDP-400E FROM THE STANDBY GENERATOR.

NORMAL POWER RETURNS:


1. WHEN ONE OR TWO, OR ALL OF THE UTILITY LINES (LINE 1, LINE 2 AND/OR LINE 3) RETURN, POWER TO PDP-0300A AND/OR PDP-0300B, MCC-0400A AND/OR MCC-0400B IS RESTORED.
2. IF TS-0300 AND/OR TS-0400 DETECT(S) UTILITY (NORMAL) POWER THE CORRESPONDING ATS WILL SWITCH TO NORMAL POSITION (OPEN-TRANSITION TRANSFER) AFTER A SHORT TIME DELAY.
3. WHEN BOTH TS-0300 AND TS-0400 HAVE TRANSITIONED TO UTILITY (NORMAL) POWER FOR A PERIOD OF TIME (ADJUSTABLE), THE STANDBY GENERATOR WILL START ITS NORMAL SHUT DOWN SEQUENCE.
4. WHEN ALL ATS'S HAVE DISCONNECTED FROM THE STANDBY GENERATOR, THE GENERATOR WILL RUN FOR A SHORT TIME APPROXIMATELY 5-10 MINUTES TO COOL OFF, AND THEN IT WILL SHUT DOWN

FOR MAINTENANCE:

1. AFTER THE GENERATOR SYSTEM IS TESTED AND COMMISSIONED, PROPER LOCK-OUT PROCEDURES SHOULD BE DEVELOPED AND PUT IN PLACE BY PLANT ELECTRICAL MAINTENANCE AND OPERATORS IN ORDER TO ISOLATE POWER TO THE EMERGENCY SYSTEM BUSES WHEN MAINTENANCE IS BEING PERFORMED ON THEM AND/OR OTHER EQUIPMENT:
 - a. TS-0300 AND TS-0400 SHOULD BE IN THE OFF POSITION.
 - b. ALL ASSOCIATED UPSTREAM MAIN BREAKERS TO THE STANBY BUSES SHALL BE LOCKED OUT ALL THE WAY UP TO THE RELEVANT GENERATOR FEEDER BREAKER(S).


LOAD TESTING:

1. DURING LOAD TESTING IF ANY ATS DETECTS UTILITY POWER LOSS, A SIGNAL WILL BE SENT TO OPEN LOAD BANK SHUNT TRIP BREAKER TO DISCONNECT THE LOAD BANK FROM GENERATOR.

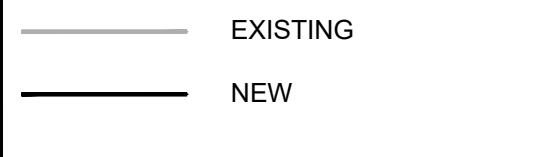

				TORONTO WATER ENGINEERING AND CONSTRUCTION SERVICES		R.C. HARRIS WATER TREATMENT PLANT INSTALLATION OF A STANDBY GENERATOR FOR CRITICAL LOADS ATS & GENERATOR CONTROL WIRING BLOCK DIAGRAM	
						ELECTRICAL	
100-175 GALAXY BOULEVARD TORONTO, ONTARIO M9W 0C9 TEL 416 679 1930 FAX 416 675 4620 www.arcadis.com		COPYRIGHT: This drawing has been prepared solely for the intended use. Thus, any reproduction or distribution for any purpose other than authorized by ARCADIS is prohibited. Written dimensions shall have precedence over scaled dimensions. Contractors shall verify and be responsible for all dimensions and conditions on the job, and ARCADIS shall be informed of any variations from the dimensions and conditions shown on the drawing. Shop drawings shall be submitted to R/C Group for general conformance before proceeding with fabrication.				DESIGN: SC DRAFTING: SC CHECK: TS CONTRACT No. 25ECS-MI-03HA	
ARCADIS Professional Services (Canada) Inc.		A 2025-03-18 ISSUED FOR TENDER T.S.				SCALE: N.T.S. DRAWING NUMBER: 2F-2017-08-39 E015	
		NO. DATE REVISIONS INITIAL SIGNED				DATE: 2024-09-30	

Drawing: J:\M16-0273 TOR_HARRISWTP-STANDBYGENERATOR\500_CAD\401-CAD\1-SS OR BU\SHEET\6 ELEC\2F-2017-08-40-E016.DWG
Layout: 03/19/2025 12:33:39 PM

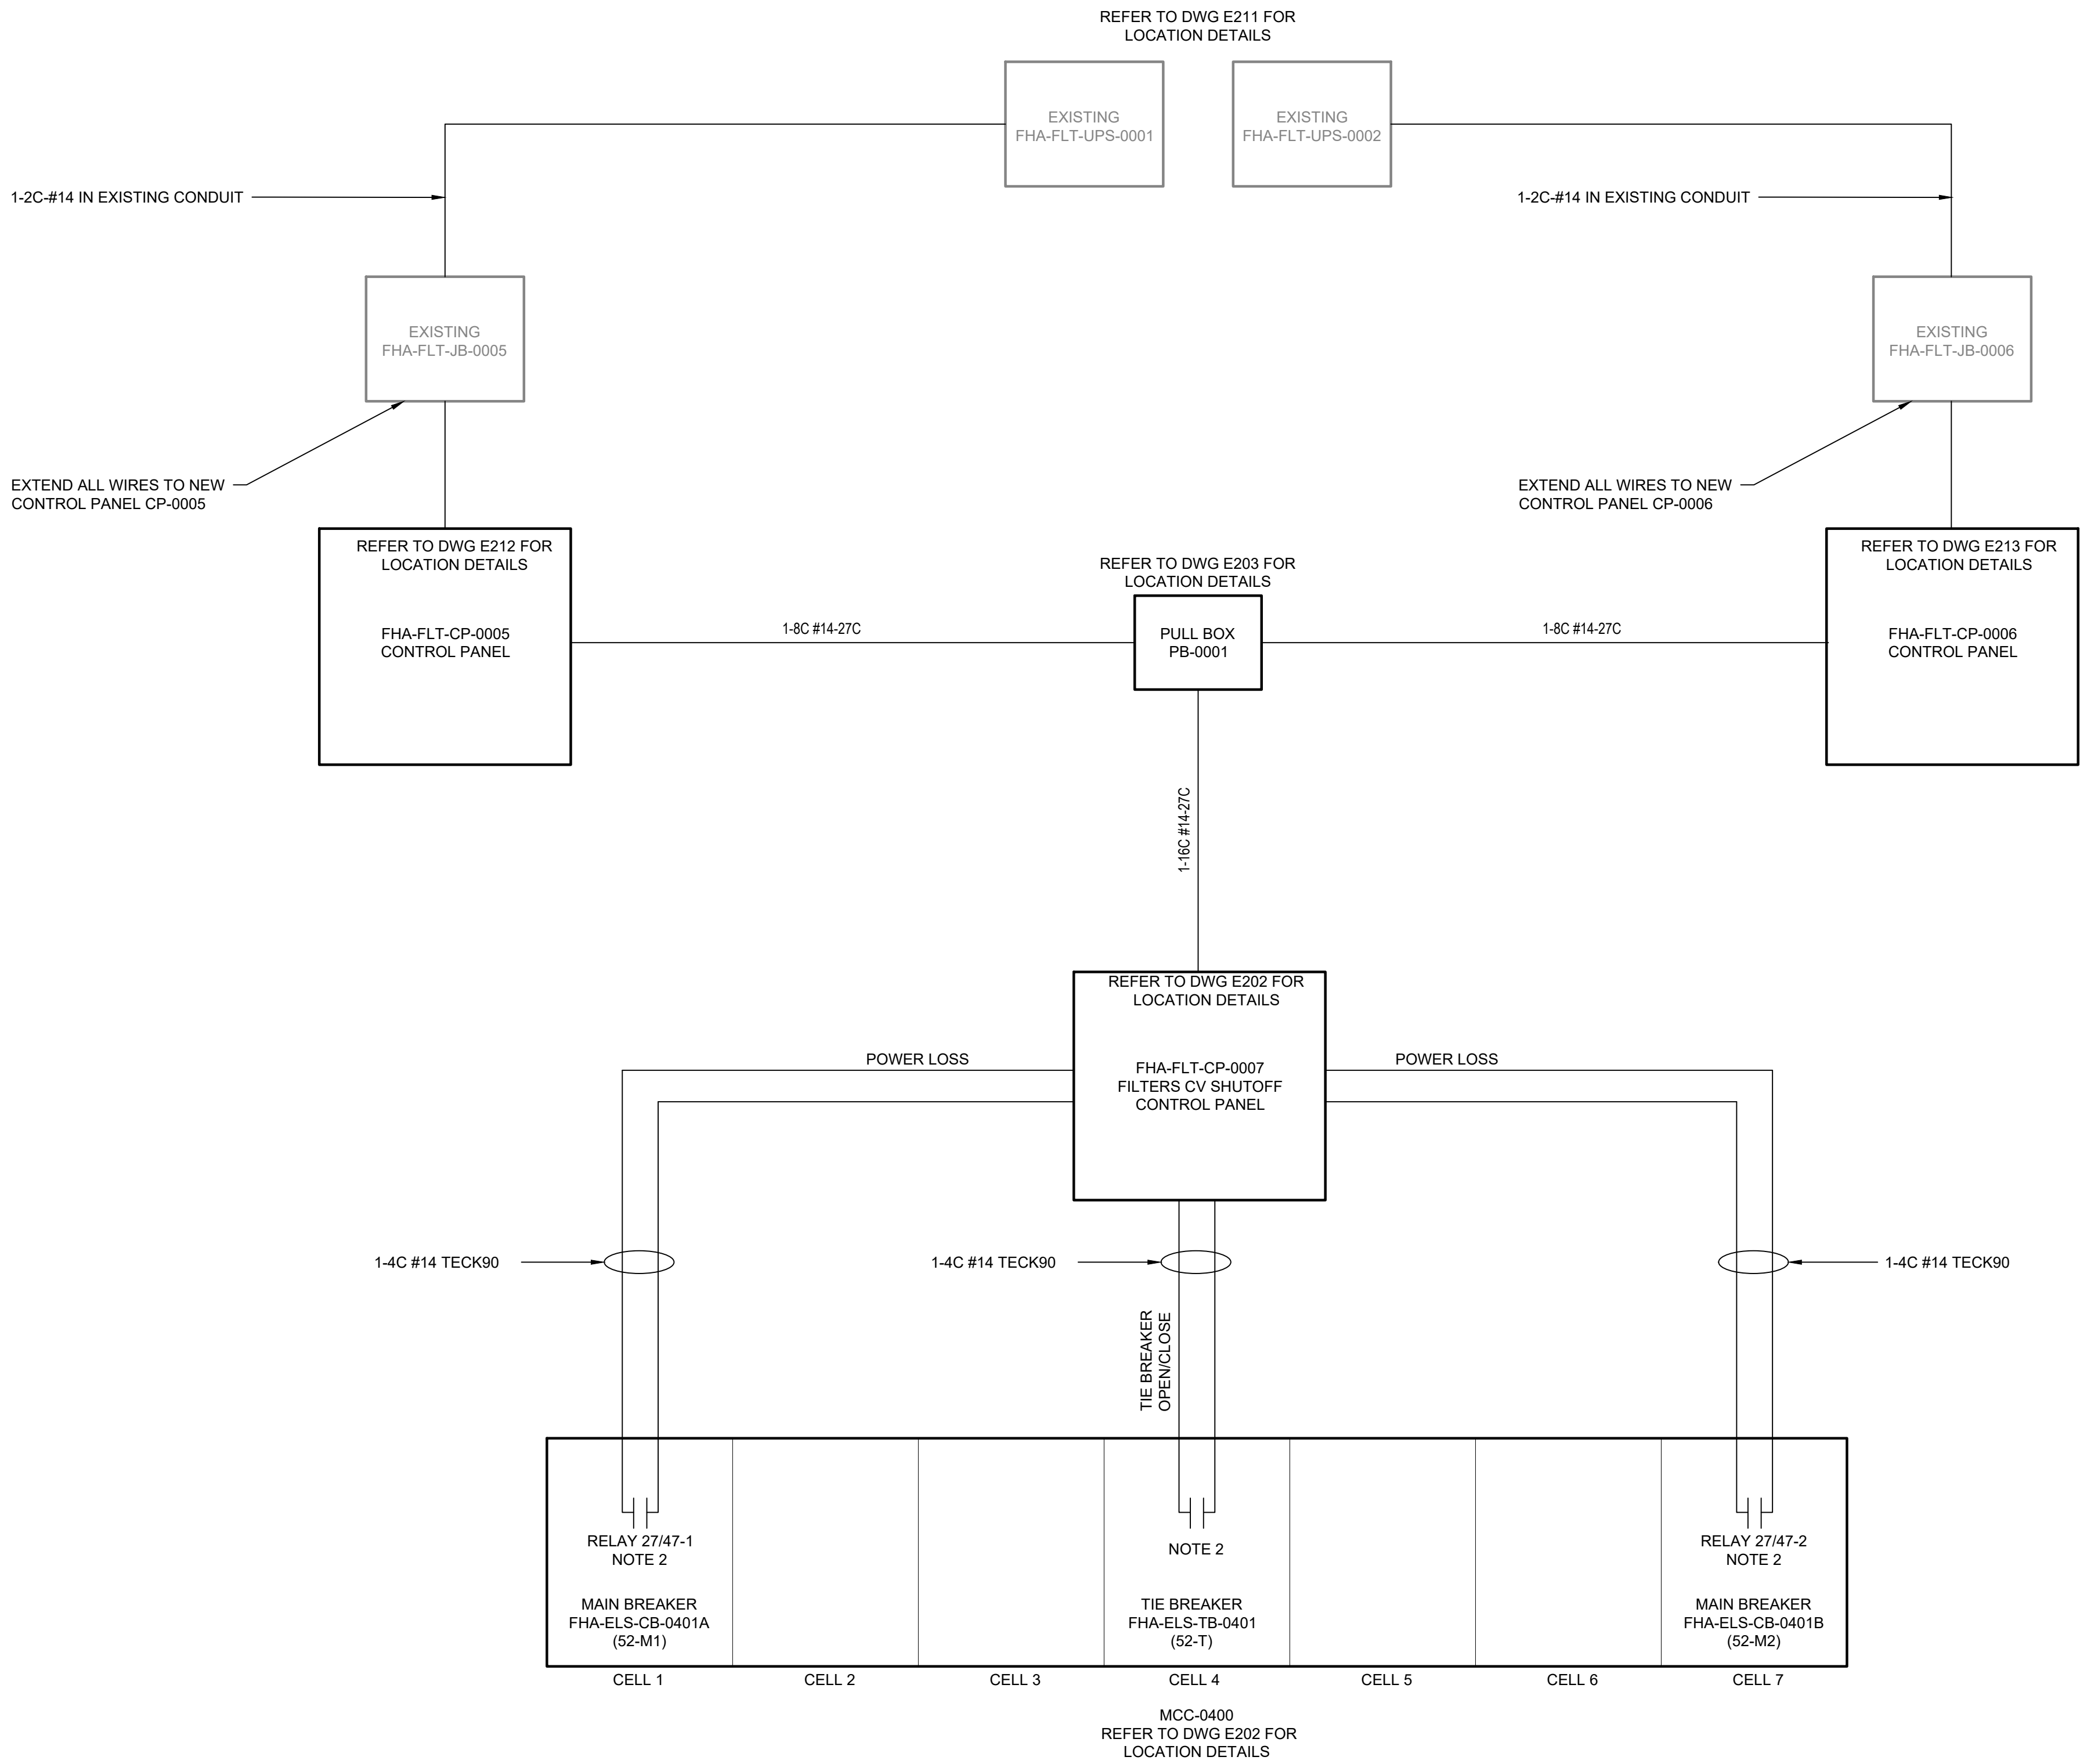


- NOTES:**
- REFER TO THE FOLLOWING I&C DRAWINGS FOR TERMINAL & SIGNAL DETAIL REQUIREMENTS.
I105: FILTER CV PANEL
I106: FHA-FLT-CP-0005
I107: FHA-FLT-CP-0006
 - CONTRACTOR TO COORDINATE WITH MCC-0400 MANUFACTURER (EATON) TO PROVIDE FOLLOWING (3) N.O. DRY CONTACTS. REFER TO EXISTING MCC-0400 SHOP DRAWING IN APPENDIX AND I&C DRAWINGS I103, I104 FOR REFERENCE. PROVIDE UPDATED MCC-0400 SHOP DRAWING.
 - POWER SOURCE #1 : LOSS OF UTILITY POWER VOLTAGE (VA VOLTAGE MONITORING RELAY 27/47-1)
 - POWER SOURCE #2 : LOSS OF UTILITY POWER VOLTAGE (VA VOLTAGE MONITORING RELAY 27/47-2).
 - TIE BREAKER 52-T: OPEN/CLOSE

TYPICAL BLOCK DIAGRAM FOR CONTROL WIRING

EXISTING
NEW

												TORONTO WATER		R.C. HARRIS WATER TREATMENT PLANT															
												ENGINEERING AND CONSTRUCTION SERVICES		INSTALLATION OF A STANDBY GENERATOR FOR CRITICAL LOADS															
																WILLIAM FERNANDES, P. ENG. DIRECTOR WATER TREATMENT AND SUPPLY		SIMON HOPTON, P. ENG. DIRECTOR DESIGN & CONSTRUCTION MAJOR INFRASTRUCTURE		FILTER CV PANEL CONTROL WIRING BLOCK DIAGRAM									
																				ELECTRICAL									
																		DESIGN:		SC	DRAFTING:	SC	CHECK:	TS	CONTRACT No.		25ECS-MI-03HA		
																		SCALE:		N.T.S.		DRAWING NUMBER:		2F-2017-08-40		E016			
																		DATE:		2024-09-30									
																				</									

Drawing: J:\M16-0273 TOR_HARRIS\WTP-STANDBYGENERATOR\500_CAD\CAD\1-SS OR BU\SHEET\6 ELEC\2F-2017-08-41-E101.DWG
Layout: 03/19/2025
Date: 03/19/2025
Time: 12:33:49 PM

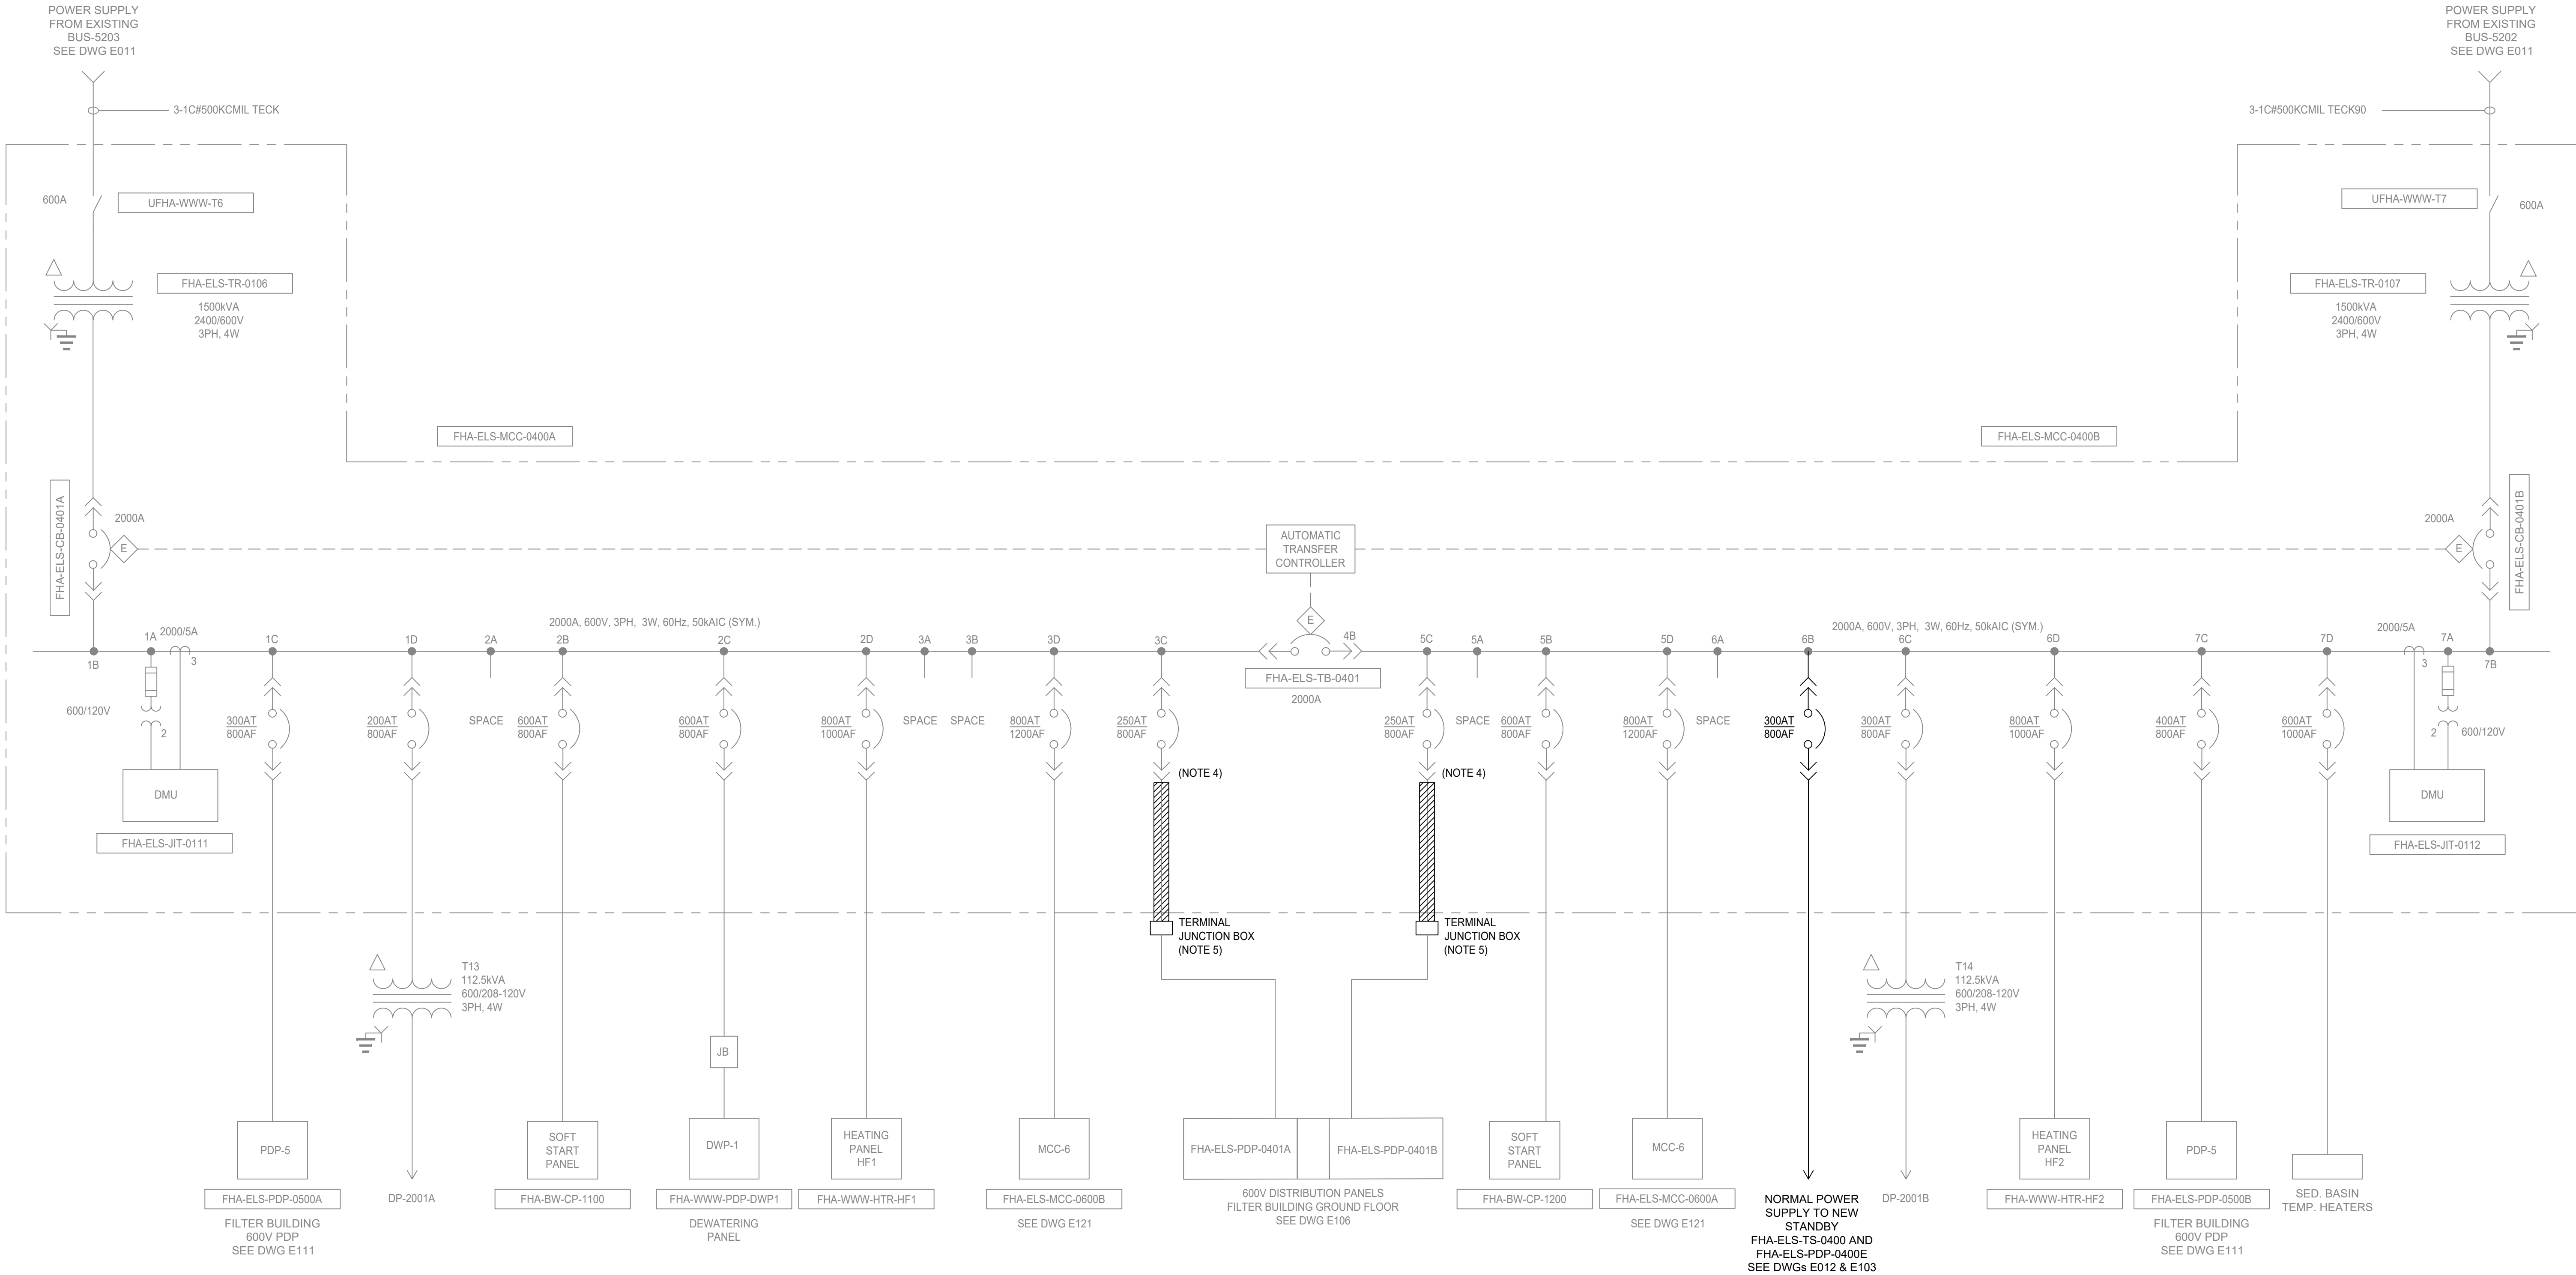

⌘⌘ CIRCUIT BREAKER's HANDLE OPERATING MECHANISM TO BE PADLOCKABLE IN THE 'OFF' POSITION.

NOTES:

- CELLS 2A, 3A, 3B, 5A, 6A ARE FOR SPACE.
- EXISTING CIRCUIT BREAKER TO BE SET TO 300A TRIP.
- WHEN RELOCATING OR REMOVING EQUIPMENT, SHOULD ANY CIRCUITS BE ABANDONED,THE CONDUCTORS TO THESE CIRCUITS MUST BE REMOVED OR PROPERLY TERMINATED AS DETAILED IN RULE 2-130, RULE 12-114, RULE 12-3000 AND BULLETIN 12-25-1.
- MCC CUBICLE TO BE SPARE.
- DISCONNECT EXISTING FHA-ELS-PDP-0401A/B FEEDER CABLES FROM EXISTING FHA-ELS-MCC-0400A/B. PROVIDE TERMINAL JUNCTION BOXES TO EXTEND EXISTING FEEDER CABLES TO THE ADJACENT NEW FHA-ELS-PDP-0400E VIA 250KCMIL CABLES. SEE DRAWING E103.

CABLE SCHEDULE:

No.: CABLE SIZE:

1 1-3C 400MCM TECK90

EXISTING


NEW

REMOVAL, TO BE REPLACED WITH NEW CABLES & INSTALLED COMPLETE


FHA-ELS-MCC-0400A/B SINGLE LINE DIAGRAM - MODIFICATIONS

						TORONTO WATER		R.C. HARRIS WATER TREATMENT PLANT INSTALLATION OF A STANDBY GENERATOR FOR CRITICAL LOADS FHA-ELS-MCC-0400A/B SINGLE LINE DIAGRAM - MODIFICATIONS									
						ENGINEERING AND CONSTRUCTION SERVICES											
100-175 GALAXY BOULEVARD TORONTO, ONTARIO, M9W 0C9 TEL 416 679 1930 FAX 416 675 4620 www.arcadis.com		COPYRIGHT: This drawing has been prepared solely for the intended use. Thus, any reproduction or distribution for any purpose other than authorized by ARCADIS is forbidden. Written dimensions shall have precedence over scaled dimensions. Contractors shall verify and be responsible for all dimensions and conditions on the job, and ARCADIS shall be informed of any variations from the dimensions and conditions shown on the drawing. Shop drawings shall be submitted to IRI Group for general conformance before proceeding with fabrication.								WILLIAM FERNANDES, P.ENG DIRECTOR WATER TREATMENT AND SUPPLY		SIMON HOPTON, P. ENG. DIRECTOR DESIGN & CONSTRUCTION MAJOR INFRASTRUCTURE					
A		2025-03-18				ISSUED FOR TENDER				T.S.		ELECTRICAL		DESIGN: SC DRAFTING: SC CHECK: TS CONTRACT No. 25ECS-MI-03HA			
NO.		DATE				REVISIONS				INITIAL		SIGNED		DRAWING NUMBER: 2F-2017-08-41		E101	

Drawing: J:\M16-0273 TOR_HARRIS\WP-STANDBYGENERATOR\500_CAD\CAD\401-CAD\1-SS OR BU\SHEET\6 ELEC\2F-2017-08-42-E102.DWG
Layout: 03/19/2025 12:33:59 PM
Date: 03/19/2025 Time: 12:33:59 PM

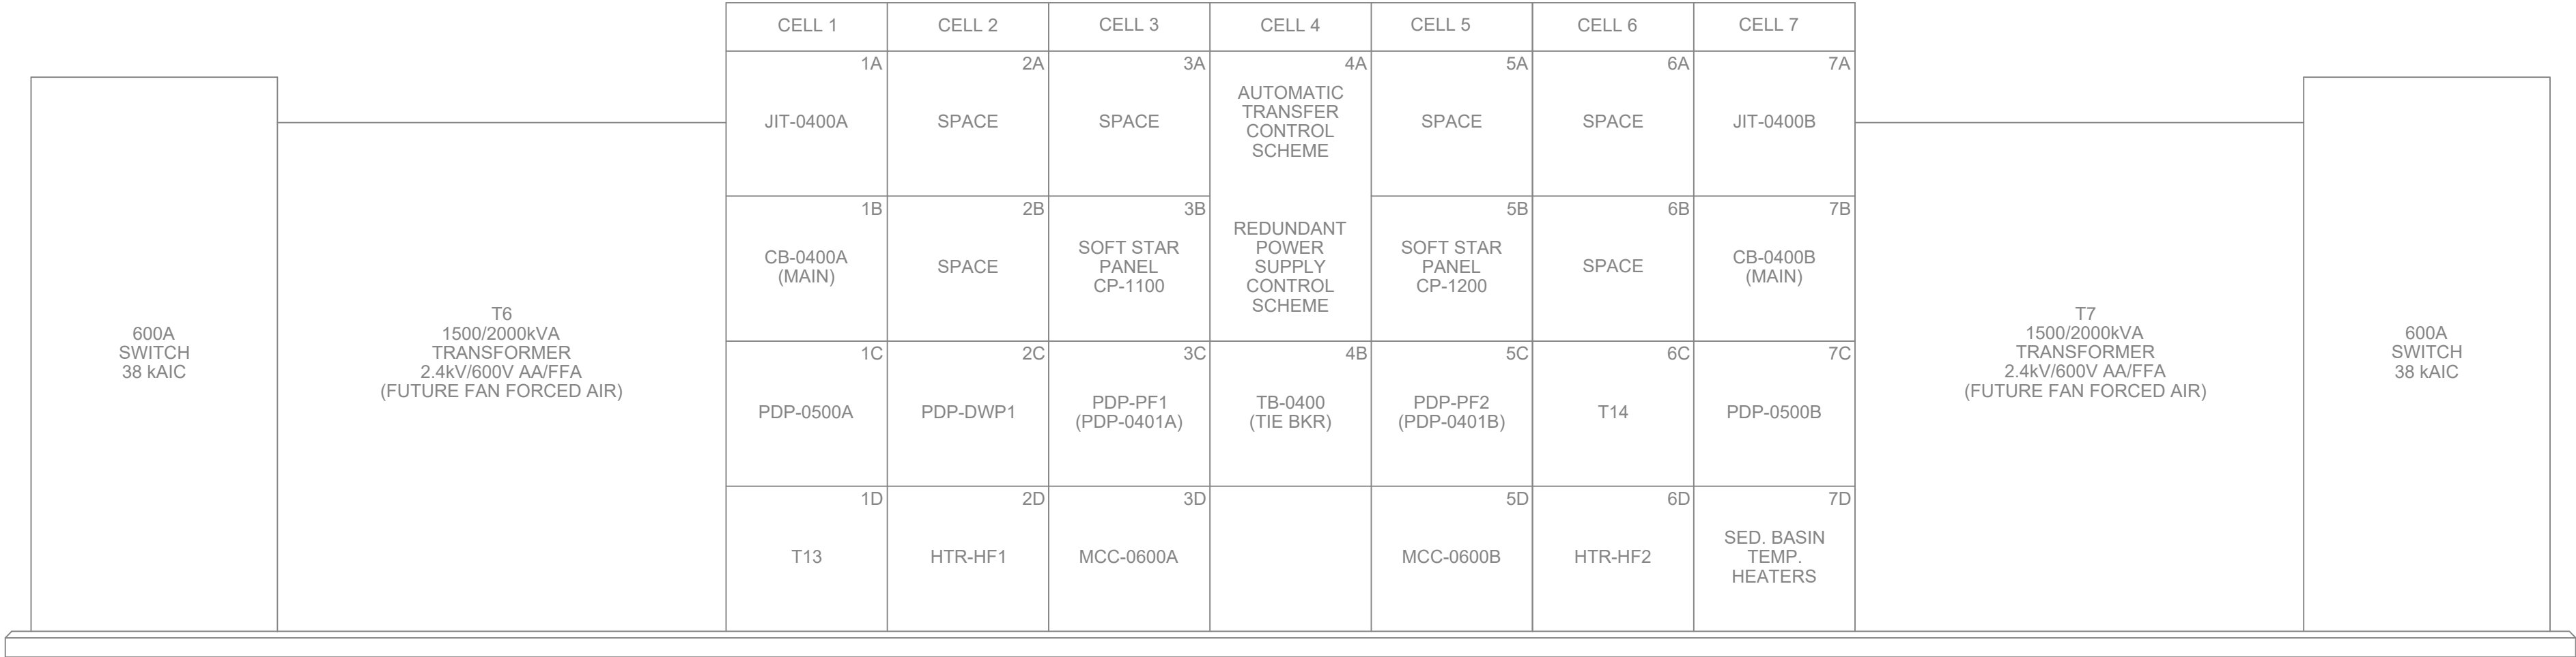

EXISTING

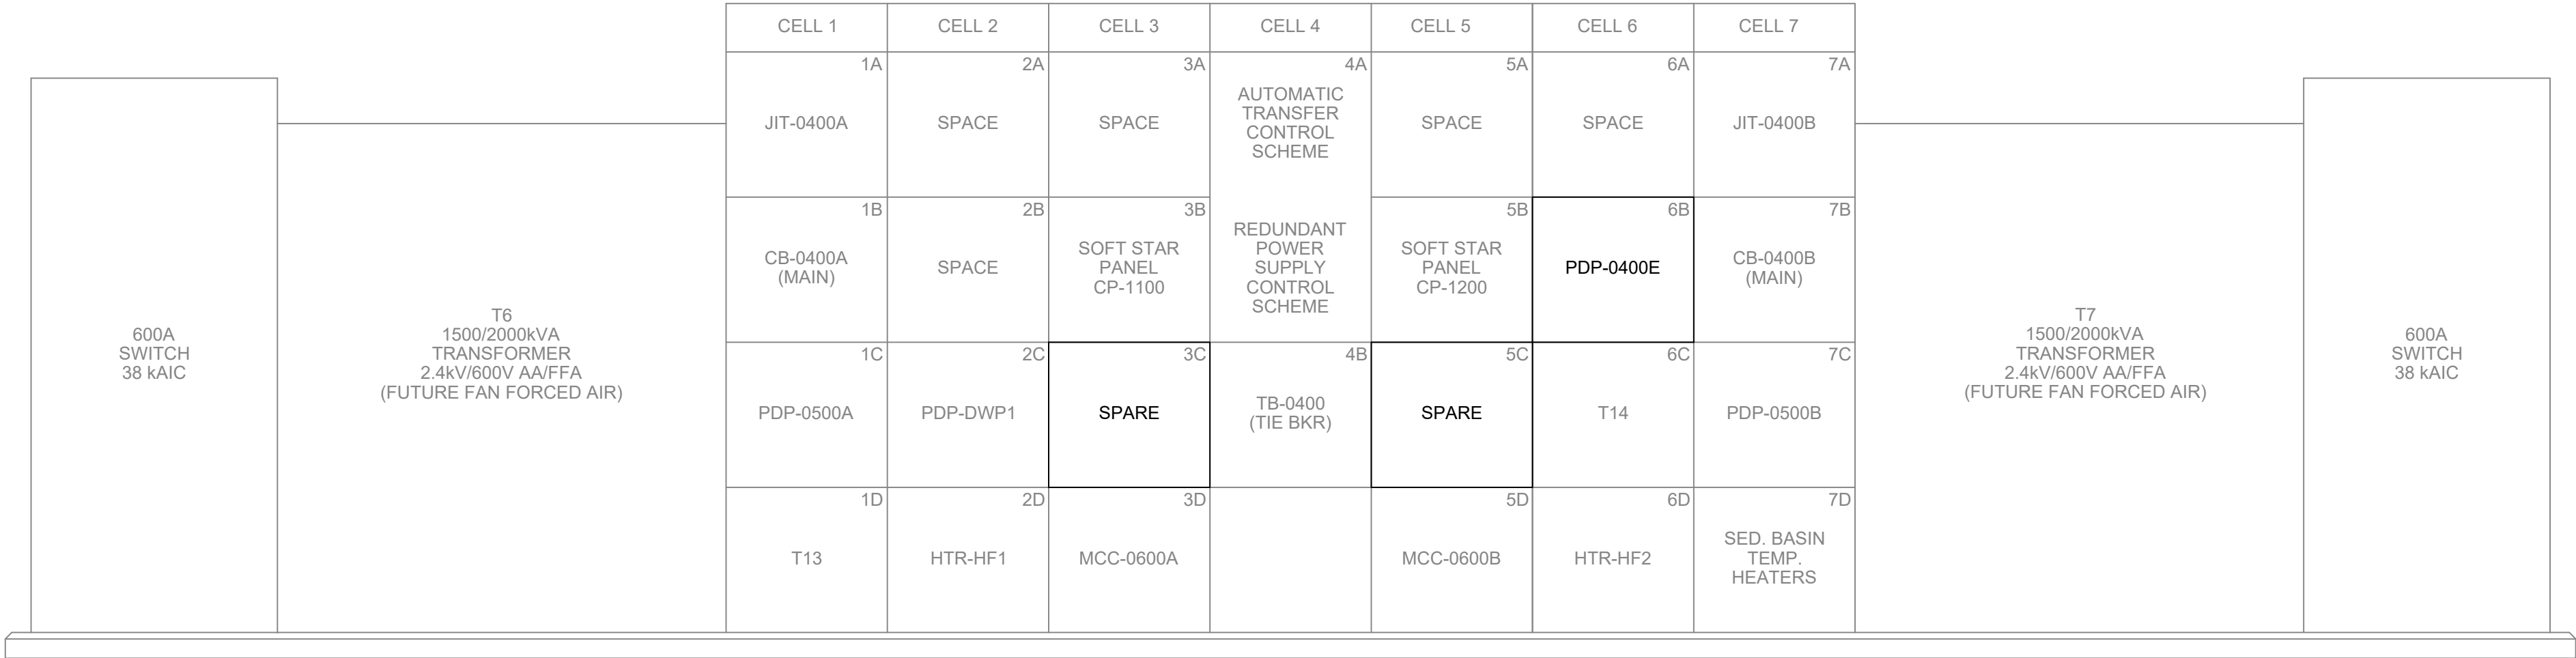

MODIFICATIONS

ELECTRICAL CHARACTERISTICS:


600 VOLTS MAIN BUS 2000A
3 PH SCCR: 50kAIC (SYM.)
3 WIRE BUS BRACING: 50kAIC (SYM.)
60 Hz ENCLOSURE TYPE: CSA II SPRINKLER PROOF

NOTES:

- REFER TO DWG E202 FOR LOCATION DETAILS.
- ALL CONDUCTORS, EQUIPMENT, AND FIELD CONNECTIONS SHALL BE TAGGED AND IDENTIFIED AS PER CITY REQUIREMENTS.


FHA-ELS-MCC-0400A/B ELEVATION LAYOUT - EXISTING AND MODIFICATIONS

N.T.S.

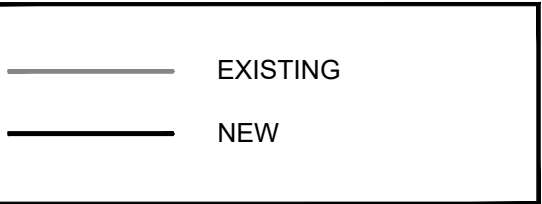

										TORONTO WATER ENGINEERING AND CONSTRUCTION SERVICES				R.C. HARRIS WATER TREATMENT PLANT INSTALLATION OF A STANDBY GENERATOR FOR CRITICAL LOADS FHA-ELS-MCC-0400A/B ELEVATION LAYOUT - EXISTING AND MODIFICATIONS			
COPYRIGHT: This drawing has been prepared solely for the intended use. Thus, any reproduction or distribution for any purpose other than authorized by ARCADIS is forbidden. Written dimensions shall have precedence over scaled dimensions. Contractors shall verify and be responsible for all dimensions and conditions on the job, and ARCADIS shall be informed of any variations from the dimensions and conditions shown on the drawing. Shop drawings shall be submitted to the Group for general conformance before proceeding with fabrication.		A 2025-03-18 ISSUED FOR TENDER T.S.												ELECTRICAL			
100-175 GALAXY BOULEVARD TORONTO, ONTARIO, M9W 0C9 TEL 416 679 1930 FAX 416 675 4620 www.arcadis.com		NO. DATE REVISIONS INITIAL SIGNED												DESIGN: SC DRAFTING: SC CHECK: TS CONTRACT No. 25ECS-MI-03HA			
														SCALE: N.T.S. DRAWING NUMBER: 2F-2017-08-42 E102			
														DATE: 2024-09-30			

Drawing: J:\M16-0273 TOR_HARRIS\WP-STANDBYGENERATOR\500_CAD\401-CAD\1-SS OR BU\SHEET\6 ELEC\2F-2017-08-43-E103.DWG
Layout: 03/19/2025 10:03:00 AM
Date: 03/19/2025 Time: 12:34:09 PM

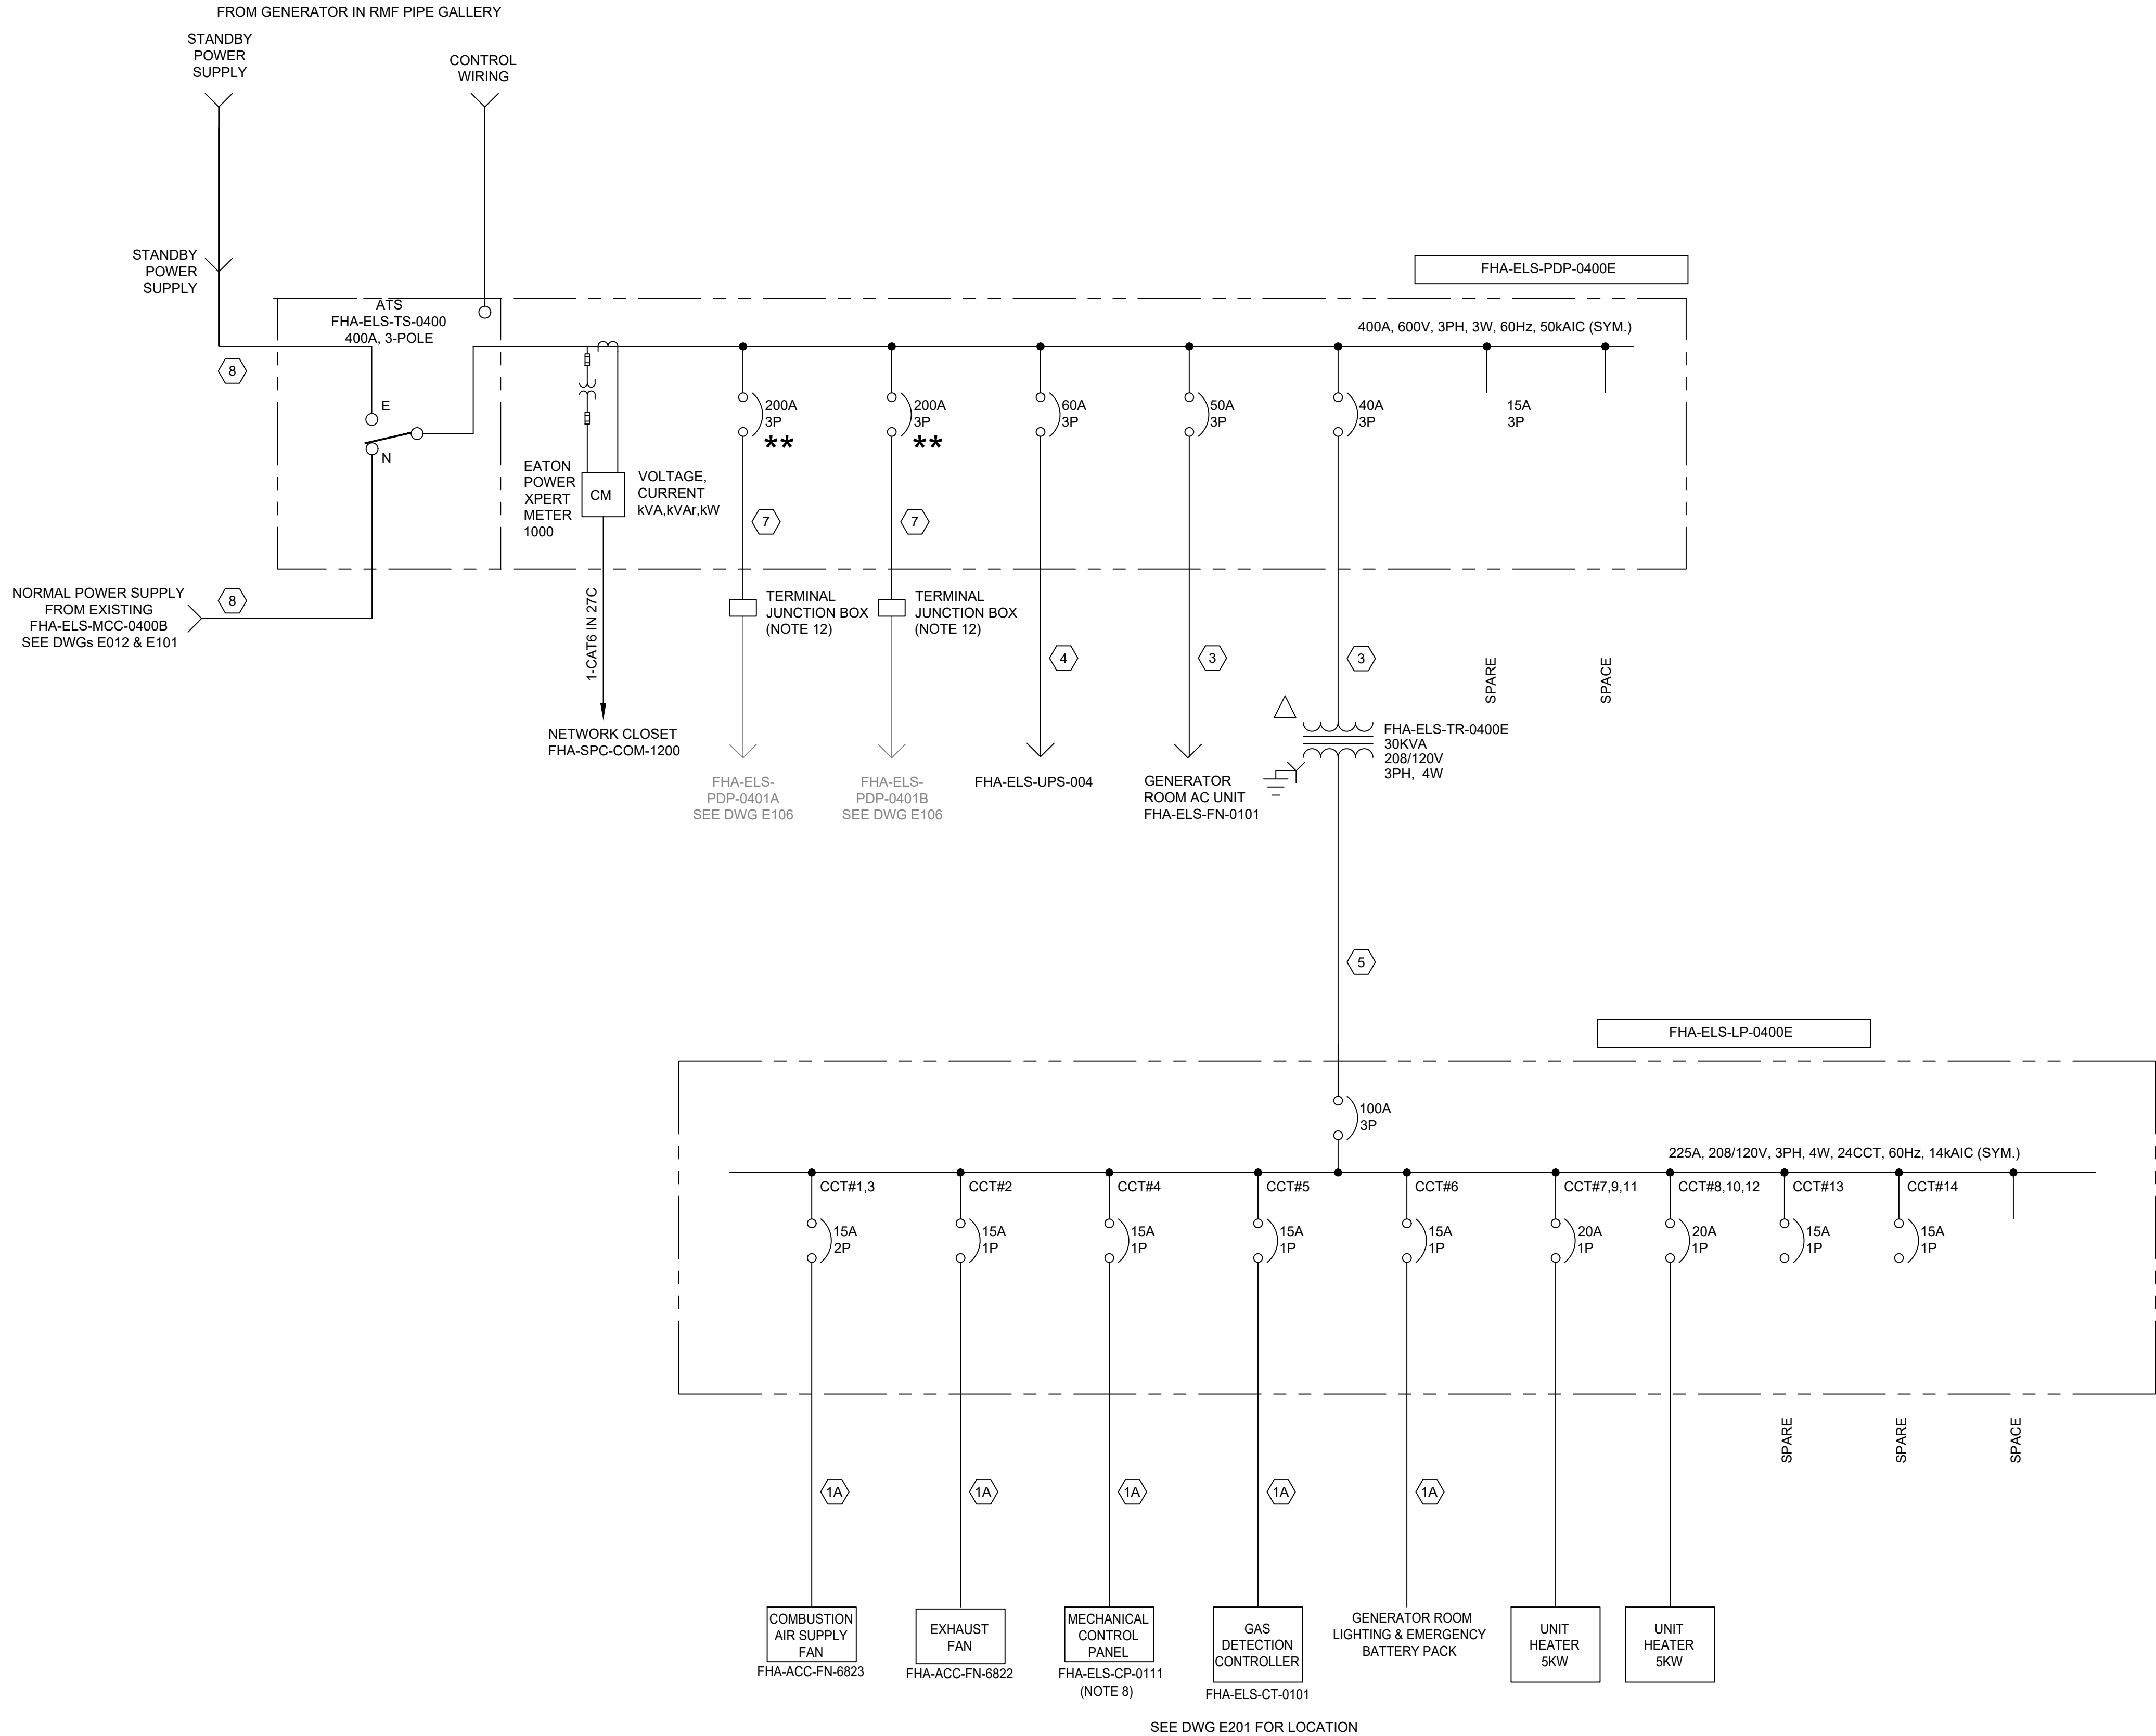

FEEDER AND CONDUIT SCHEDULE		
NUMBER	SIZE	RATING (A)
1	1-3C #12 AWG TECK90	20
1A	1-4C #12 AWG + #12GND - 21C	20
2	1-3C #10 AWG TECK90	30
3	1-3C #8 AWG TECK90	50
3A	1-4C #8 AWG + #10GND - 21C	50
4	1-3C #6 AWG TECK90	65
4A	1-3C #6 AWG + #8GND - 27C	65
5	1-4C #2 AWG + #8AWG - 35C	115
6	1-3C #2/0 AWG TECK90	175
7	1-3C #3/0 AWG TECK90	200
8	1-3C 400 MCM TECK90	335
9	1-3C 500 MCM TECK90	500


** CIRCUIT BREAKER's HANDLE OPERATING MECHANISM TO BE PADLOCKABLE IN THE 'OFF' POSITION.

- NOTES:
- 'S' DENOTES SHUNT TRIP.
 - ALL TAG NAMES SHOWN ON THE DRAWING HAVE A PREFIX OF "FHA-ELS" UNLESS OTHERWISE NOTED.
 - REFER TO DWG E015 FOR CONTROL WIRING.
 - ALL CONDUCTORS, EQUIPMENT, AND FIELD CONNECTIONS SHALL BE TAGGED AND IDENTIFIED AS PER CITY REQUIREMENTS.
 - UNLESS OTHERWISE INDICATED, ALL CONDUCTORS ARE TO BE COPPER AND ALL POWER CABLES ARE TO BE TECK90.
 - REFER TO DWG E104 FOR NEW STANDBY PDP ELEVATION LAYOUT.
 - REFER TO DWGS E202 AND E203 FOR LOCATION DETAILS OF EACH NEW EQUIPMENT.
 - ONE (1) NEW LOAD BANK (ON WHEELS) TO BE PROVIDED FOR EACH GENERATOR AS SPECIFIED.
 - REFER TO DWG E106 FOR LOAD DISTRIBUTION.
 - AT EACH DISTRIBUTION POINT, CIRCUIT BREAKERS, FUSES AND SWITCHES SHALL BE MARKED, ADJACENT THERETO, IN A CONSPICUOUS AND LEGIBLE MANNER TO INDICATE CLEARLY WHICH INSTALLATION OR PORTION OF INSTALLATION THEY PROTECT OR CONTROL AND THE MAXIMUM RATING OF OVERCURRENT DEVICE THAT IS PERMITTED.
 - EACH NEW ATS AND PDP ASSEMBLY SHALL BE CERTIFIED FOR 50kA SHORT-CIRCUIT CURRENT RATING.
 - PROVIDE TERMINAL JUNCTION BOXES TO EXTEND EXISTING FHA-ELS-PDP-0401A/B FEEDER CABLES FROM ADJACENT EXISTING FHA-ELS-MCC-0400A/B VIA 250KCMIL CABLES. SEE DRAWING E101.

—	EXISTING
—	NEW


FHA-ELS-PDP-0400E SINGLE LINE DIAGRAM - NEW STANDBY BUS

								TORONTO WATER ENGINEERING AND CONSTRUCTION SERVICES		R.C. HARRIS WATER TREATMENT PLANT INSTALLATION OF A STANDBY GENERATOR FOR CRITICAL LOADS FHA-ELS-PDP-0400E SINGLE LINE DIAGRAM - NEW STANBY BUS			
								WILLIAM FERNANDES, P. ENG DIRECTOR WATER TREATMENT AND SUPPLY	SIMON HOPTON, P. ENG. DIRECTOR DESIGN & CONSTRUCTION MAJOR INFRASTRUCTURE				
COPYRIGHT: This drawing has been prepared solely for the intended use. Thus, any reproduction or distribution for any purpose other than authorized by ARCADIS is forbidden. Written dimensions shall have precedence over scaled dimensions. Contractors shall verify and be responsible for all dimensions and conditions on the job, and ARCADIS shall be informed of any variations from the dimensions and conditions shown on the drawing. Shop drawings shall be submitted to IRI Group for general conformance before proceeding with fabrication.										ELECTRICAL			
100-175 GALAXY BOULEVARD TORONTO, ONTARIO, M9W 0C9 TEL 416 679 1930 FAX 416 675 4620 www.arcadis.com		A 2025-03-18 ISSUED FOR TENDER T.S.								DESIGN: SC	DRAFTING: SC	CHECK: TS	CONTRACT No. 25ECS-MI-03HA
ARCADIS Professional Services (Canada) Inc.										SCALE: N.T.S.	DRAWING NUMBER: 2F-2017-08-43		E103
										DATE: 2024-09-30			

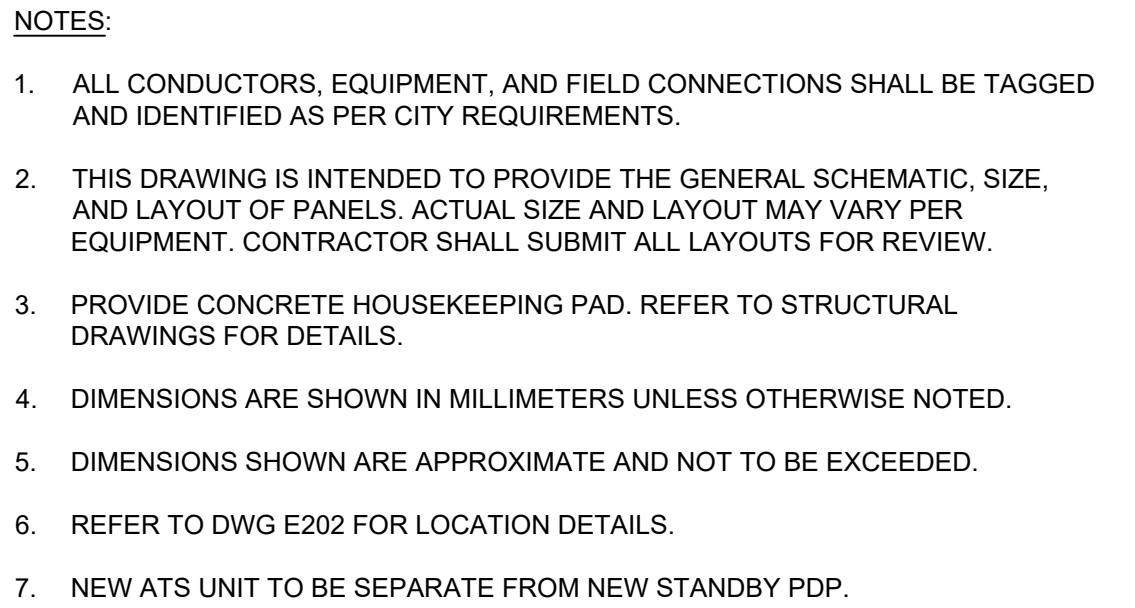

EXISTING

NEW

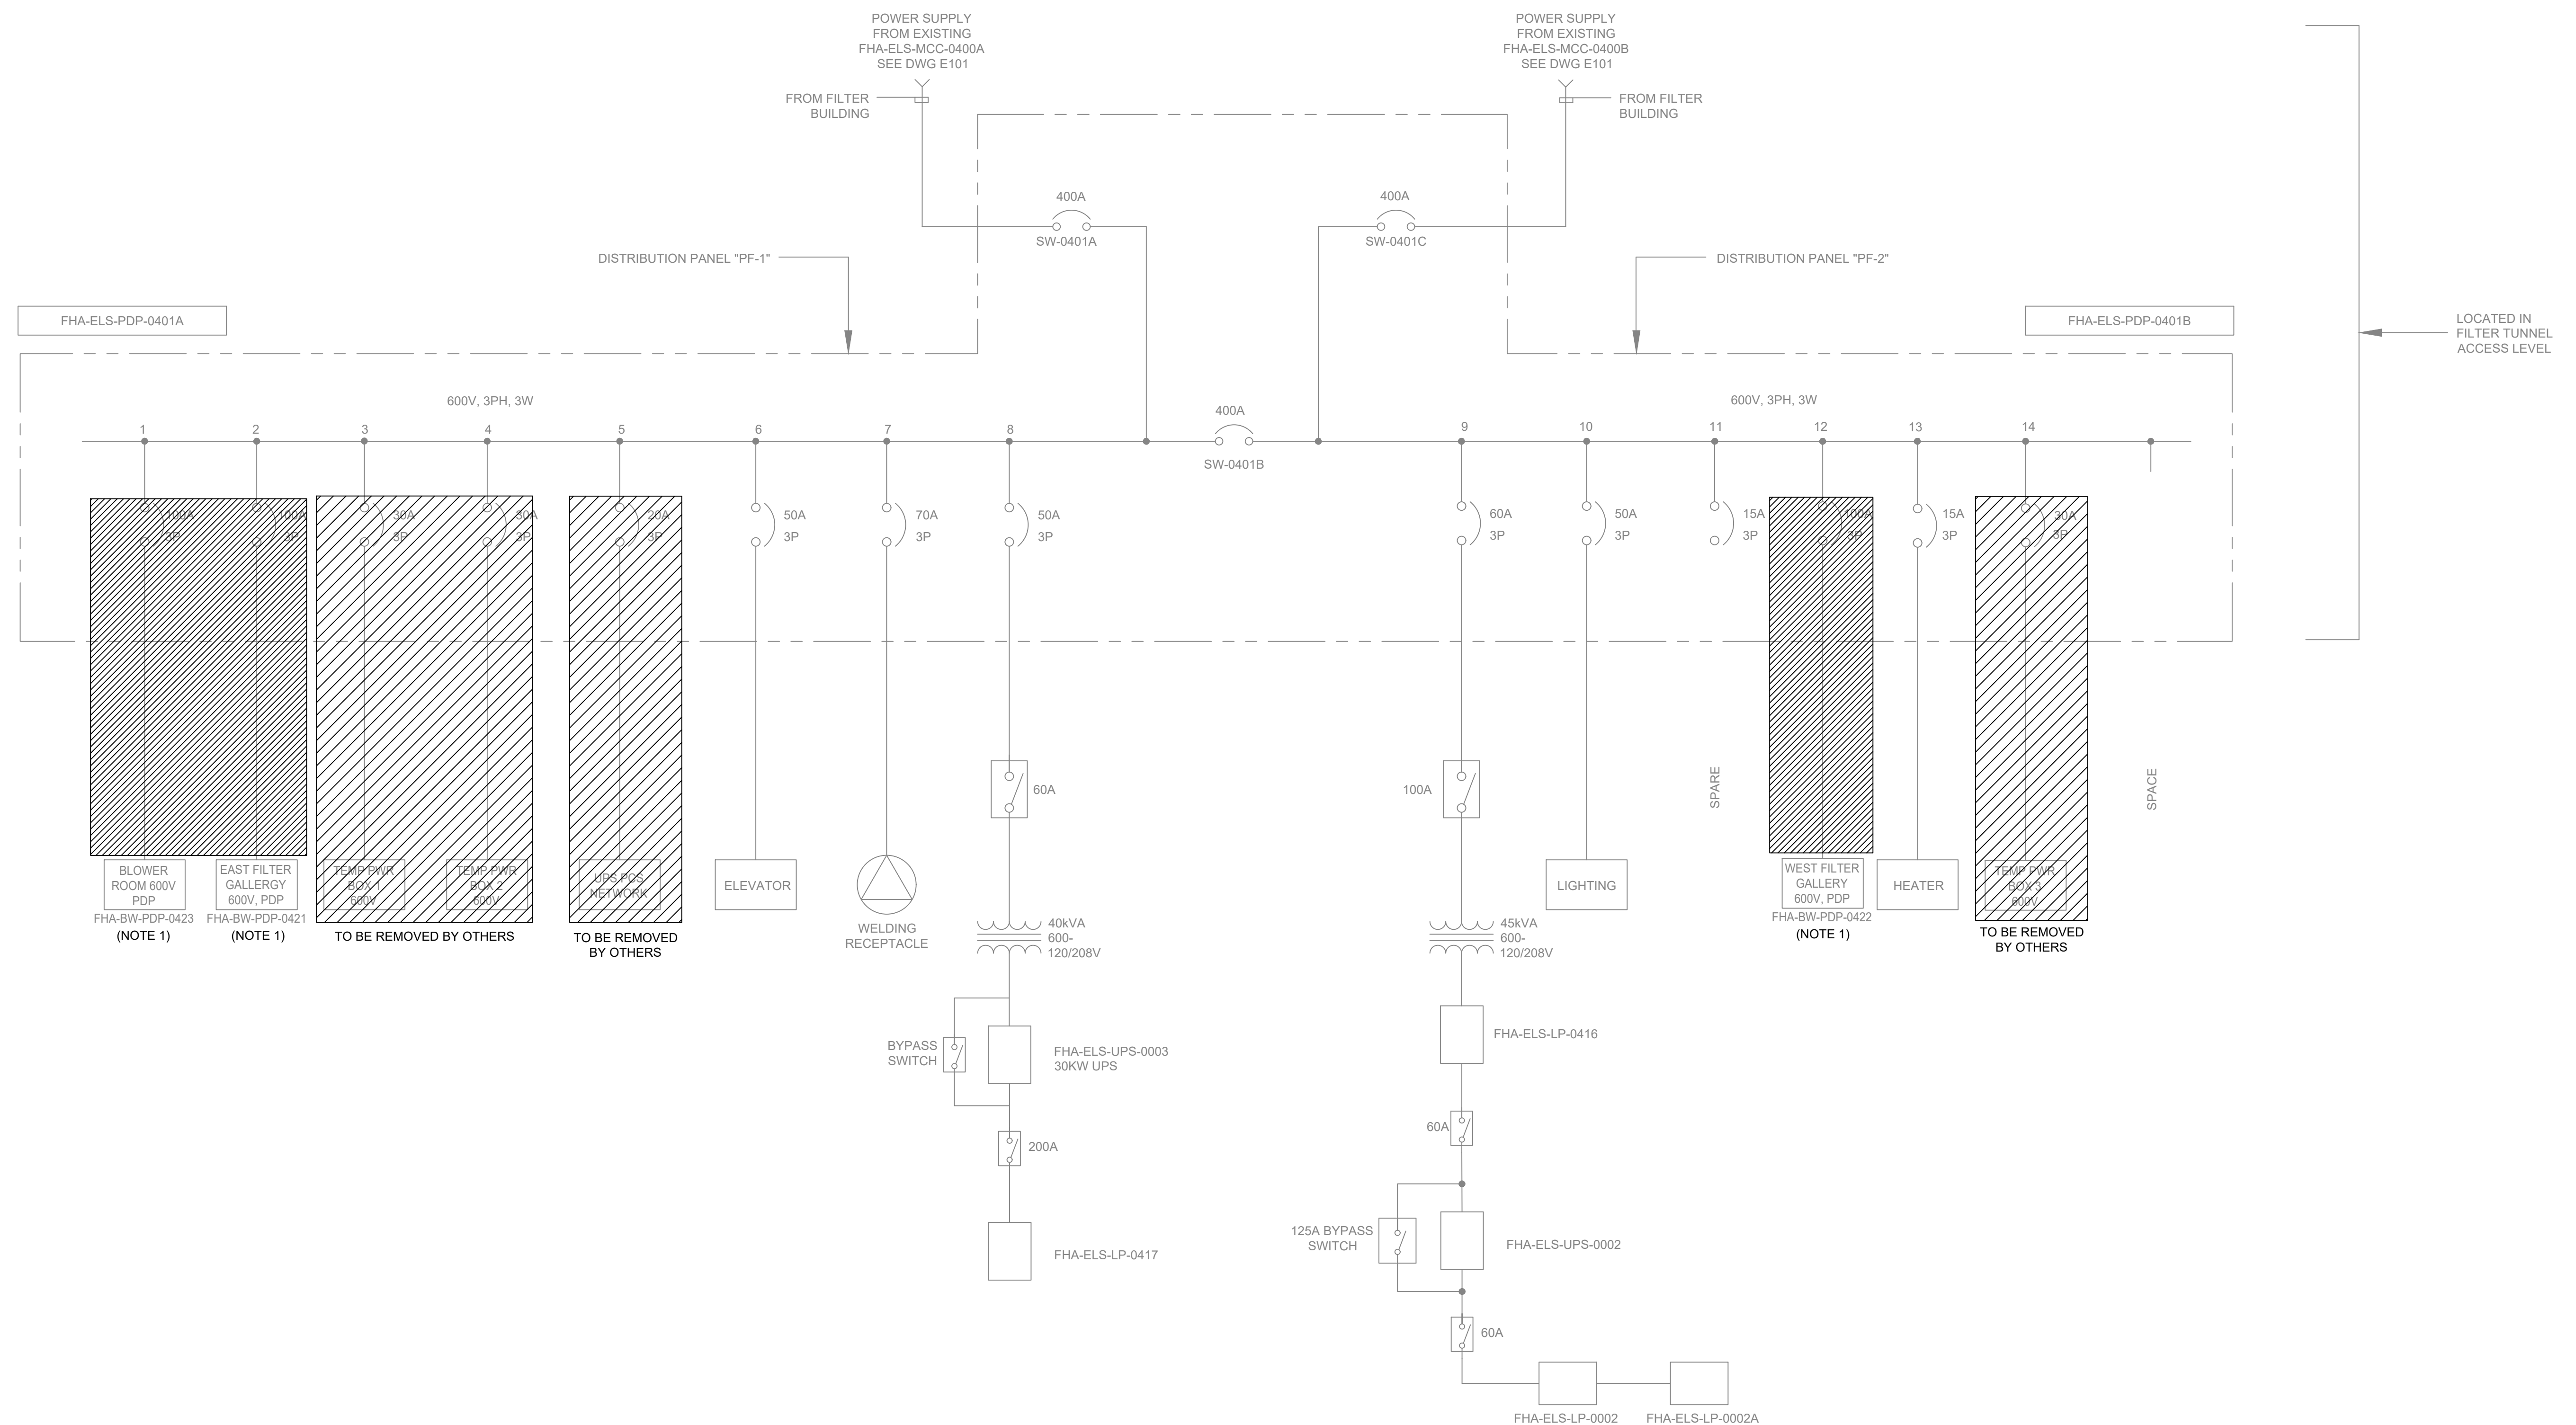

- NOTES:
1. REFEEED FROM FHA-ELS-PDP-0506. SEE DRAWING E108.
 2. WHEN RELOCATING OR REMOVING EQUIPMENT, SHOULD ANY CIRCUITS BE ABANDONED THE CONDUCTORS TO THESE CIRCUITS MUST BE REMOVED OR PROPERLY TERMINATED AS DETAILED IN RULE 2-130, RULE 12-114, RULE 12-3000 AND BULLETIN 12-25-".


FHA-ELS-PDP-401A/B SINGLE LINE DIAGRAM - EXISTING
N.T.S.

 EXISTING
 NEW
 REMOVAL

[illegible]

Drawing: J:\M16-0273 TOR_HARRIS\WP-STANDBYGENERATOR\500_CAD\401-CAD\1-SS OR BU\SHEET\6 ELEC\2F-2017-08-46-E106.DWG
Layout: 03/19/2025 12:34:43 PM
Date: 03/19/2025 Time: 12:34:43 PM

FEEDER AND CONDUIT SCHEDULE		
NUMBER	SIZE	RATING (A)
1	1-4C #12 AWG TECK90	20
2	1-4C #6 AWG TECK90	65
3	1-4C #3 AWG TECK90	100

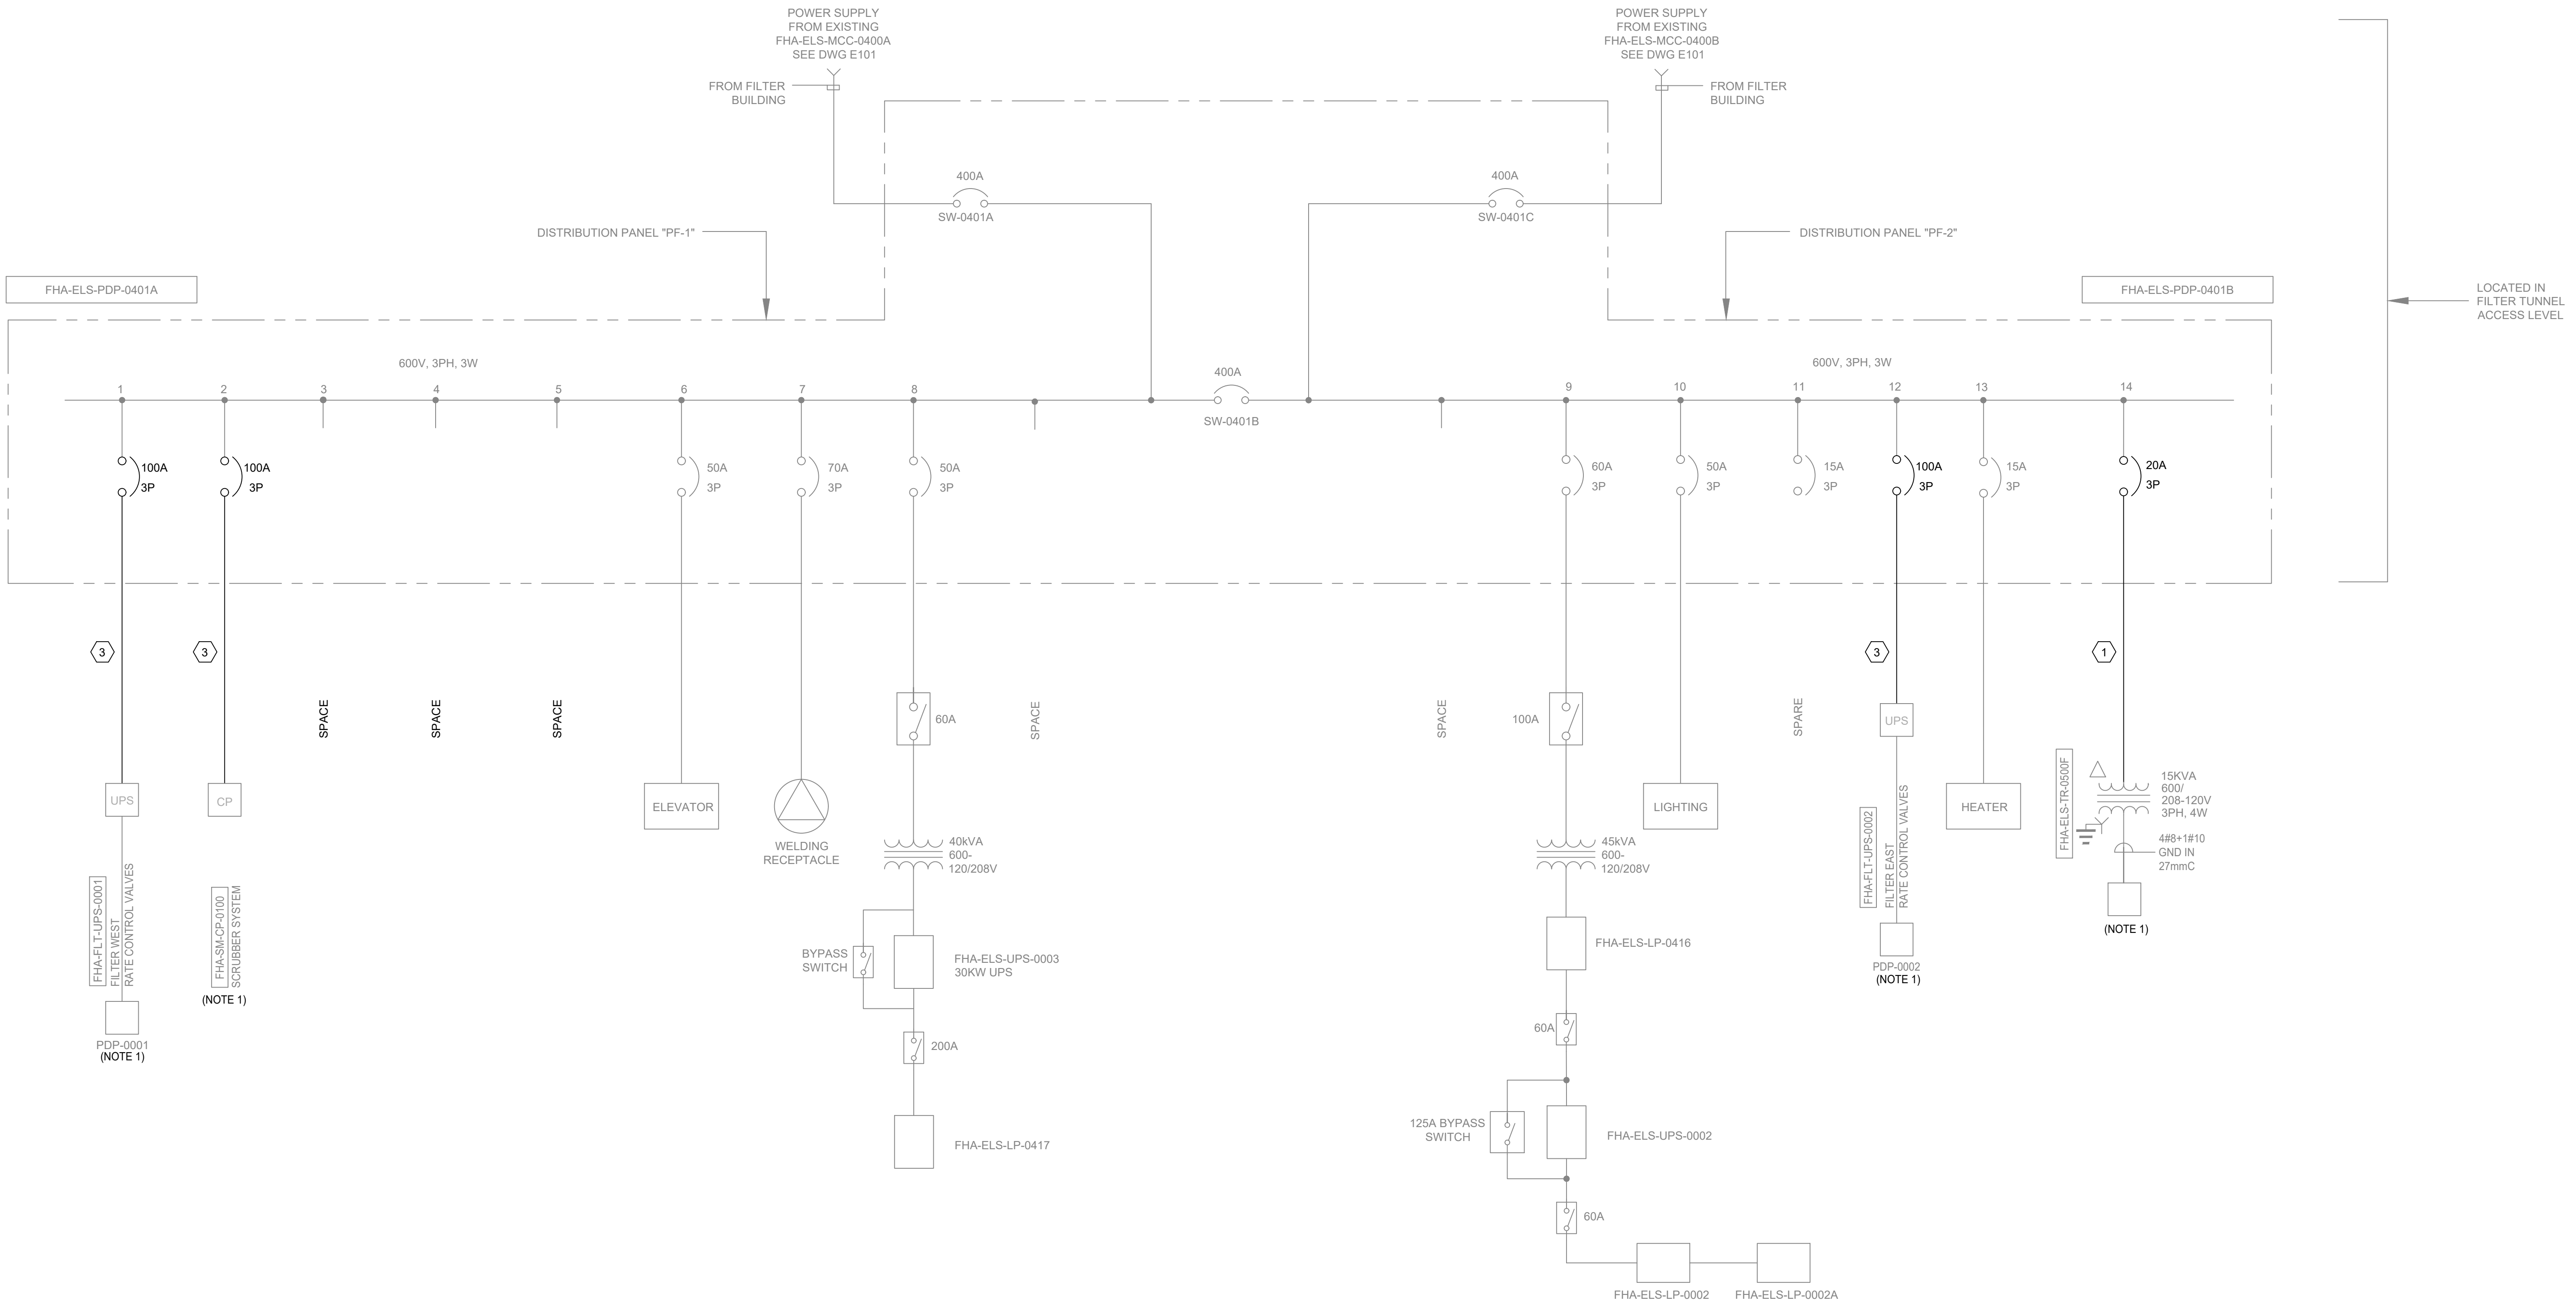

- NOTES:
- EXISTING EQUIPMENT FEEDER RELOCATED FROM MCC-0500. SEE DWG E111, E112.
 - WHEN RELOCATING OR REMOVING EQUIPMENT, SHOULD ANY CIRCUITS BE ABANDONED,THE CONDUCTORS TO THESE CIRCUITS MUST BE REMOVED OR PROPERLY TERMINATED.

FHA-ELS-PDP-401A/B SINGLE LINE DIAGRAM - MODIFICATIONS
N.T.S.


—	EXISTING
—	NEW
▨	REMOVAL

						TORONTO WATER ENGINEERING AND CONSTRUCTION SERVICES				R.C. HARRIS WATER TREATMENT PLANT INSTALLATION OF A STANDBY GENERATOR FOR CRITICAL LOADS FHA-ELS-PDP-0401A/B SINGLE LINE DIAGRAM - MODIFICATIONS			
						WILLIAM FERNANDES, P. ENG. DIRECTOR WATER TREATMENT AND SUPPLY				SIMON HOPTON, P. ENG. DIRECTOR DESIGN & CONSTRUCTION MAJOR INFRASTRUCTURE			
100-175 GALAXY BOULEVARD TORONTO, ONTARIO, M9W 0C9 TEL 416 679 1930 FAX 416 675 4620 www.arcadis.com		COPYRIGHT: This drawing has been prepared solely for the intended use. Thus, any reproduction or distribution for any purpose other than authorized by ARCADIS is forbidden. Written dimensions shall have precedence over scaled dimensions. Contractors shall verify and be responsible for all dimensions and conditions on the job, and ARCADIS shall be informed of any variations from the dimensions and conditions shown on the drawing. Shop drawings shall be submitted to full Group for general conformance before proceeding with fabrication.								ELECTRICAL			
A		2025-03-18				ISSUED FOR TENDER				DESIGN: SC DRAFTING: SC CHECK: TS CONTRACT No. 25ECS-MI-03HA			
NO.		DATE				REVISIONS				SCALE: N.T.S. DRAWING NUMBER: 2F-2017-08-46			
						INITIAL				E106			
						SIGNED							


Drawing: J:\M16-0273 TOR_HARRIS\WP-STANDBYGENERATOR\500_CAD\401-CAD\1-SS OR BU\SHEET\6 ELEC\2F-2017-08-47-E107.DWG
Layout: 03/19/2025 12:34:56 PM
Date: 03/19/2025 Time: 12:34:56 PM

METRIC

MEASUREMENTS SHOWN ON THESE PLANS
ARE IN MILLIMETERS UNLESS OTHERWISE NOTED

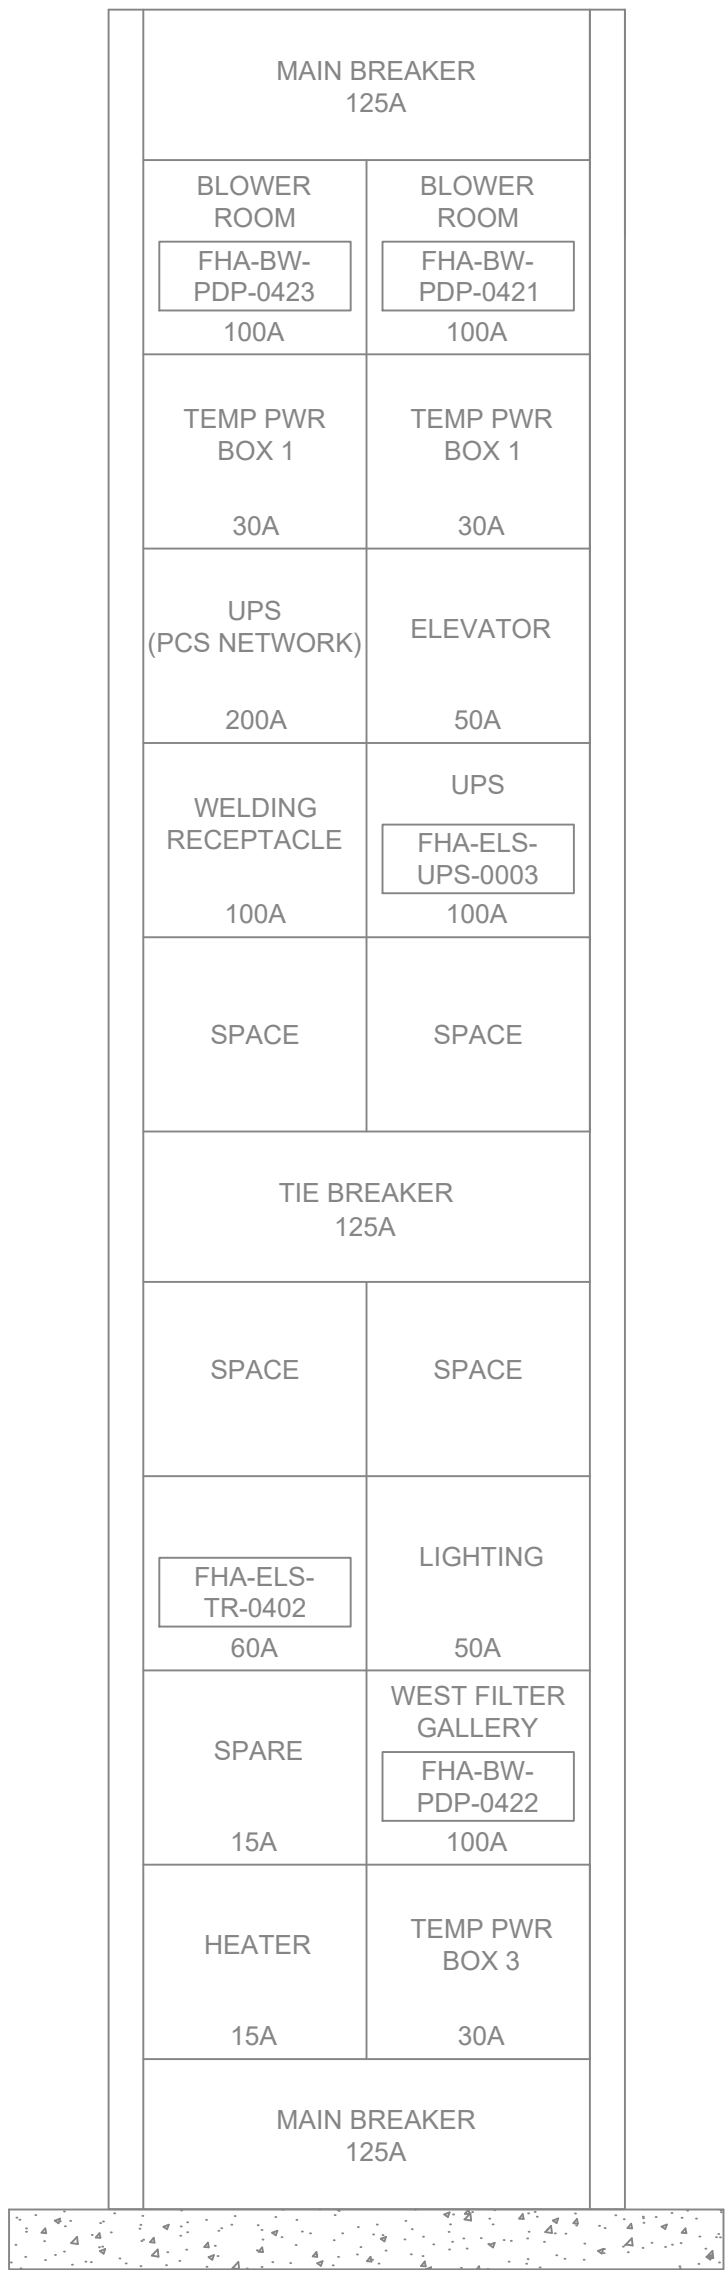

EXISTING

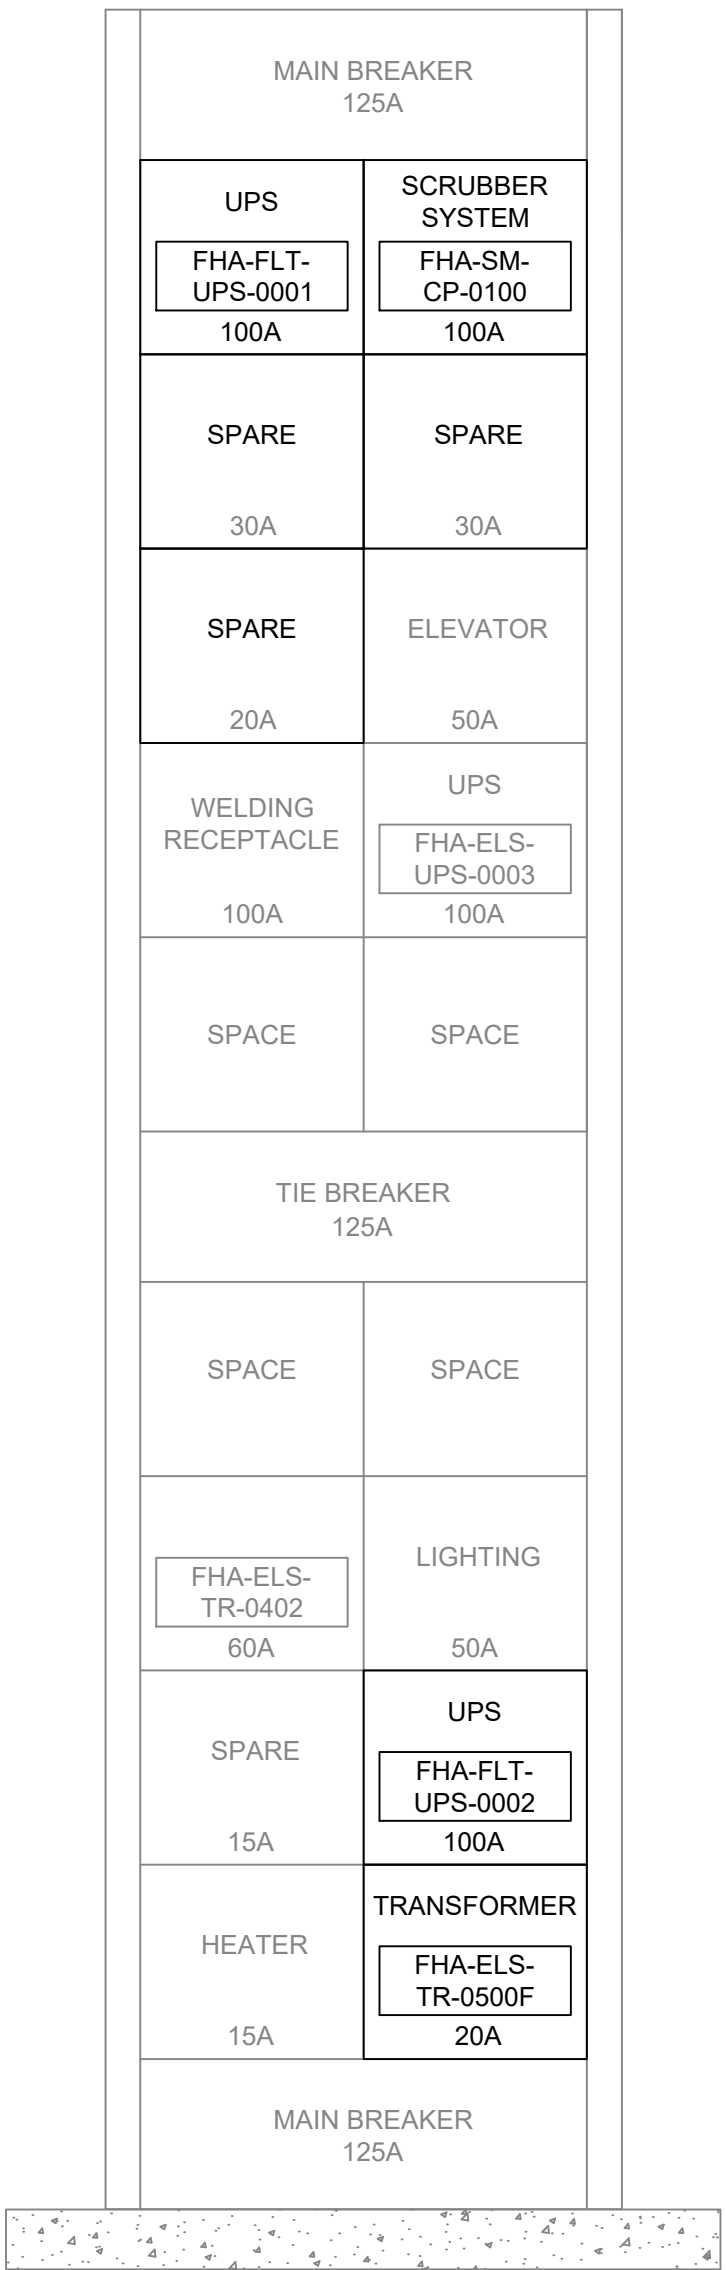

MODIFICATIONS

- NOTES:
1. ALL CONDUCTORS, EQUIPMENT, AND FIELD CONNECTIONS SHALL BE TAGGED AND IDENTIFIED AS PER CITY REQUIREMENTS.
 2. THIS DRAWING IS INTENDED TO PROVIDE THE GENERAL SCHEMATIC, SIZE, AND LAYOUT OF PANELS. ACTUAL SIZE AND LAYOUT MAY VARY PER EQUIPMENT. CONTRACTOR SHALL SUBMIT ALL LAYOUTS FOR REVIEW.
 3. DIMENSIONS ARE SHOWN IN MILLIMETERS UNLESS OTHERWISE NOTED.
 4. DIMENSIONS SHOWN ARE APPROXIMATE AND NOT TO BE EXCEEDED.
 5. REFER TO DWG E202 FOR LOCATION DETAILS.
 6. NEW ATS UNIT TO BE SEPARATE FROM NEW STANDBY PDP.

FHA-ELS-PDP-0401A/B ELEVATION LAYOUT


N.T.S.

EXISTING

NEW

										TORONTO WATER ENGINEERING AND CONSTRUCTION SERVICES				R.C. HARRIS WATER TREATMENT PLANT INSTALLATION OF A STANDBY GENERATOR FOR CRITICAL LOADS FHA-ELS-PDP-0401A/B ELEVATION LAYOUT			
 100-175 GALAXY BOULEVARD TORONTO, ONTARIO, M9W 0C9 TEL 416 679 1930 FAX 416 675 4620 www.arcadis.com		COPYRIGHT: This drawing has been prepared solely for the intended use. Thus, any reproduction or distribution for any purpose other than authorized by ARCADIS is forbidden. Written dimensions shall have precedence over scaled dimensions. Contractors shall verify and be responsible for all dimensions and conditions on the job, and ARCADIS shall be informed of any variations from the dimensions and conditions shown on the drawing. Shop drawings shall be submitted to IRI Group for general conformance before proceeding with fabrication.								WILLIAM FERNANDES, P. ENG DIRECTOR WATER TREATMENT AND SUPPLY		SIMON HOPTON, P. ENG. DIRECTOR DESIGN & CONSTRUCTION MAJOR INFRASTRUCTURE					
		ELECTRICAL				DESIGN: SC				DRAFTING: SC		CHECK: TS		CONTRACT No. 25ECS-MI-03HA			
		SCALE:		N.T.S.		DRAWING NUMBER:				2F-2017-08-47		E107					
DATE:		2024-09-30															
		A 2025-03-18		ISSUED FOR TENDER		T.S.											
NO.		DATE		REVISIONS		INITIAL		SIGNED									

FEEDER AND CONDUIT SCHEDULE		
NUMBER	SIZE	RATING (A)
1	1-4C #3 AWG TECK90	100

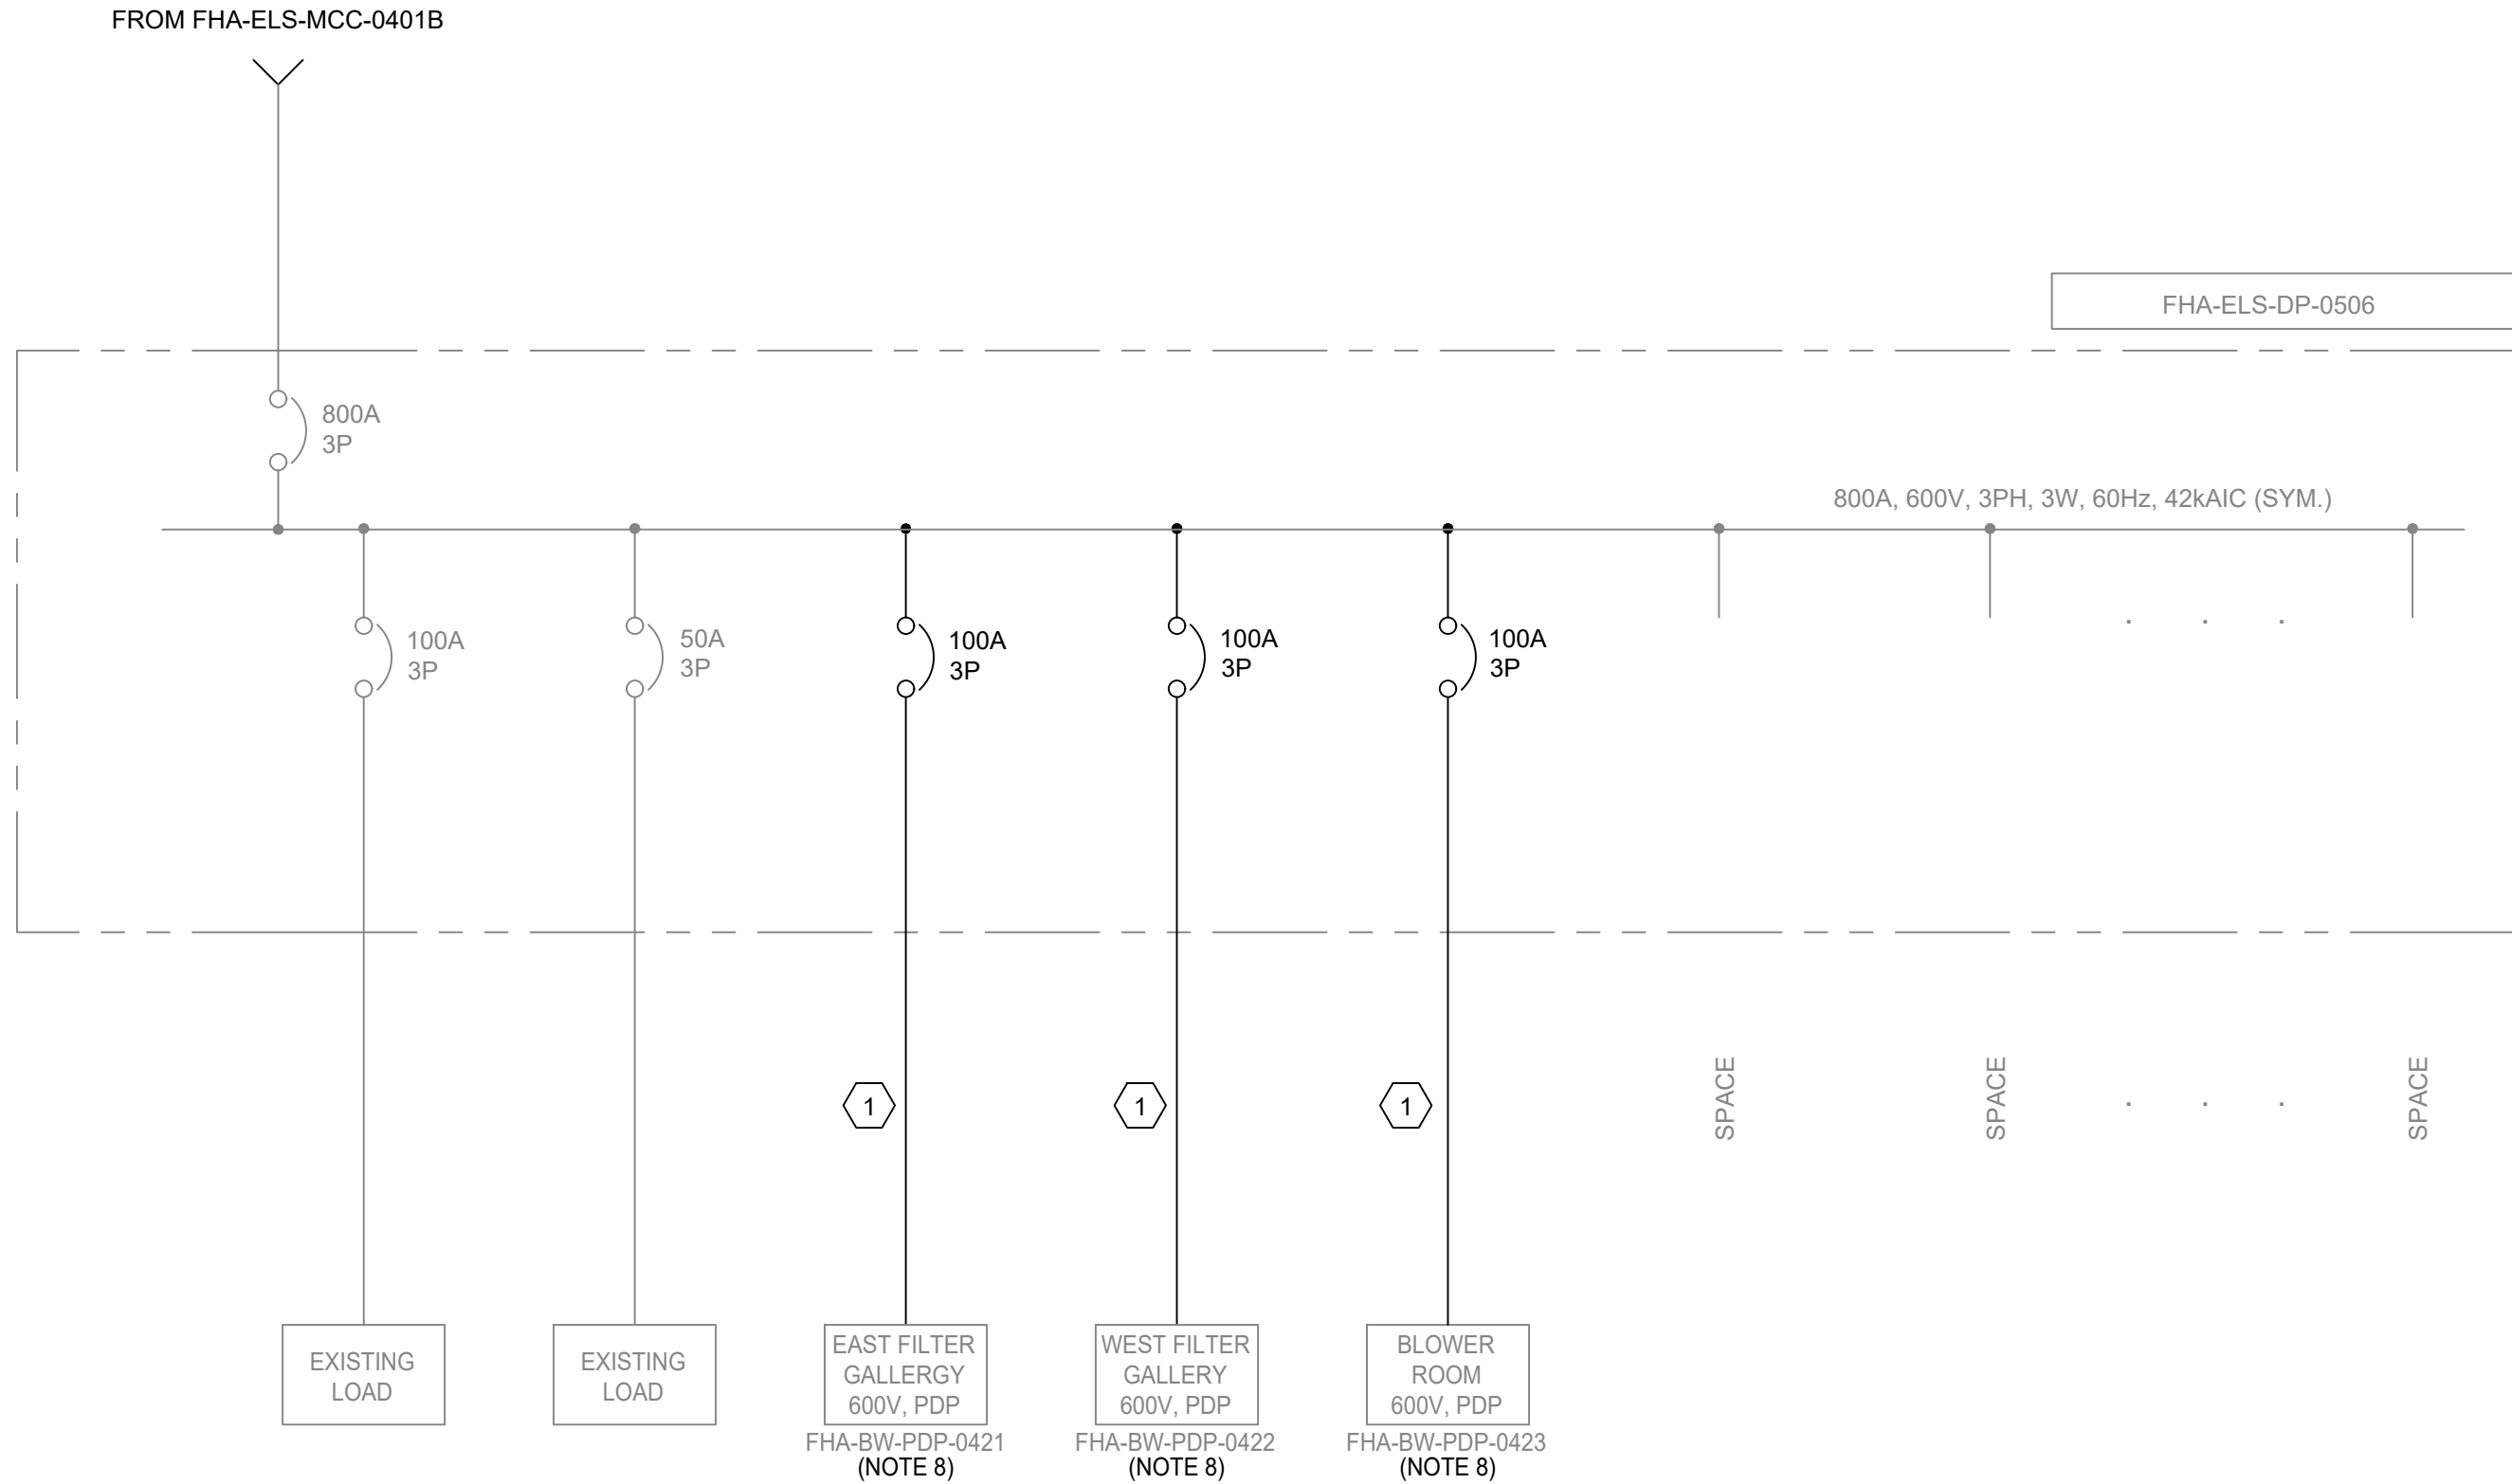


FHA-ELS-PDP-0506 SINGLE LINE DIAGRAM - MODIFICATIONS
N.T.S

NOTES:

- ALL TAG NAMES SHOWN ON THE DRAWINGS HAVE A PREFIX OF "FHA". ALL CONDUCTORS, EQUIPMENT, AND FIELD CONNECTIONS SHALL BE TAGGED AND IDENTIFIED AS PER CITY REQUIREMENTS.
- REFER TO DWG E015 FOR CONTROL WIRING.
- ALL CONDUCTORS, EQUIPMENT, AND FIELD CONNECTIONS SHALL BE TAGGED AND IDENTIFIED AS PER CITY REQUIREMENTS.
- UNLESS OTHERWISE INDICATED, ALL CONDUCTORS ARE TO BE COPPER AND ALL POWER CABLES ARE TO BE TECK90.
- REFER TO DWGs E207 AND E208 FOR LOCATION DETAILS.
- REFER TO DWG E144 FOR NEW STANDBY PDP ELEVATION LAYOUT.
- AT EACH DISTRIBUTION POINT, CIRCUIT BREAKERS, FUSES AND SWITCHES SHALL BE MARKED, ADJACENT THERETO, IN A CONSPICUOUS AND LEGIBLE MANNER TO INDICATE CLEARLY WHICH INSTALLATION OR PORTION OF INSTALLATION THEY PROTECT OR CONTROL AND THE MAXIMUM RATING OF OVERCURRENT DEVICE THAT IS PERMITTED.
- EXISTING EQUIPMENT FEED RELOCATED FROM PDP-0400A/B.

---	EXISTING
---	NEW
---	REMOVAL

												TORONTO WATER		R.C. HARRIS WATER TREATMENT PLANT INSTALLATION OF A STANDBY GENERATOR FOR CRITICAL LOADS FHA-ELS-PDP-0506 SINGLE LINE DIAGRAM - MODIFICATIONS			
												ENGINEERING AND CONSTRUCTION SERVICES					
 100-175 GALAXY BOULEVARD TORONTO, ONTARIO, M9W 0C9 TEL 416 679 1930 FAX 416 675 4620 www.arcadis.com		COPYRIGHT: This drawing has been prepared solely for the intended use, thus any reproduction or distribution for any purpose other than authorized by ARCADIS is forbidden. Written dimensions shall have precedence over scaled dimensions. Contractors shall verify and be responsible for all dimensions and conditions on the job, and ARCADIS shall be informed of any variations from the dimensions and conditions shown on the drawing. Shop drawings shall be submitted to IRI Group for general conformance before proceeding with fabrication.												WILLIAM FERNANDES, P. ENG. DIRECTOR WATER TREATMENT AND SUPPLY		SIMON HOPTON, P. ENG. DIRECTOR DESIGN & CONSTRUCTION MAJOR INFRASTRUCTURE	
		A		2025-03-18		ISSUED FOR TENDER		T.S.									
		NO.		DATE		REVISIONS		INITIAL		SIGNED							

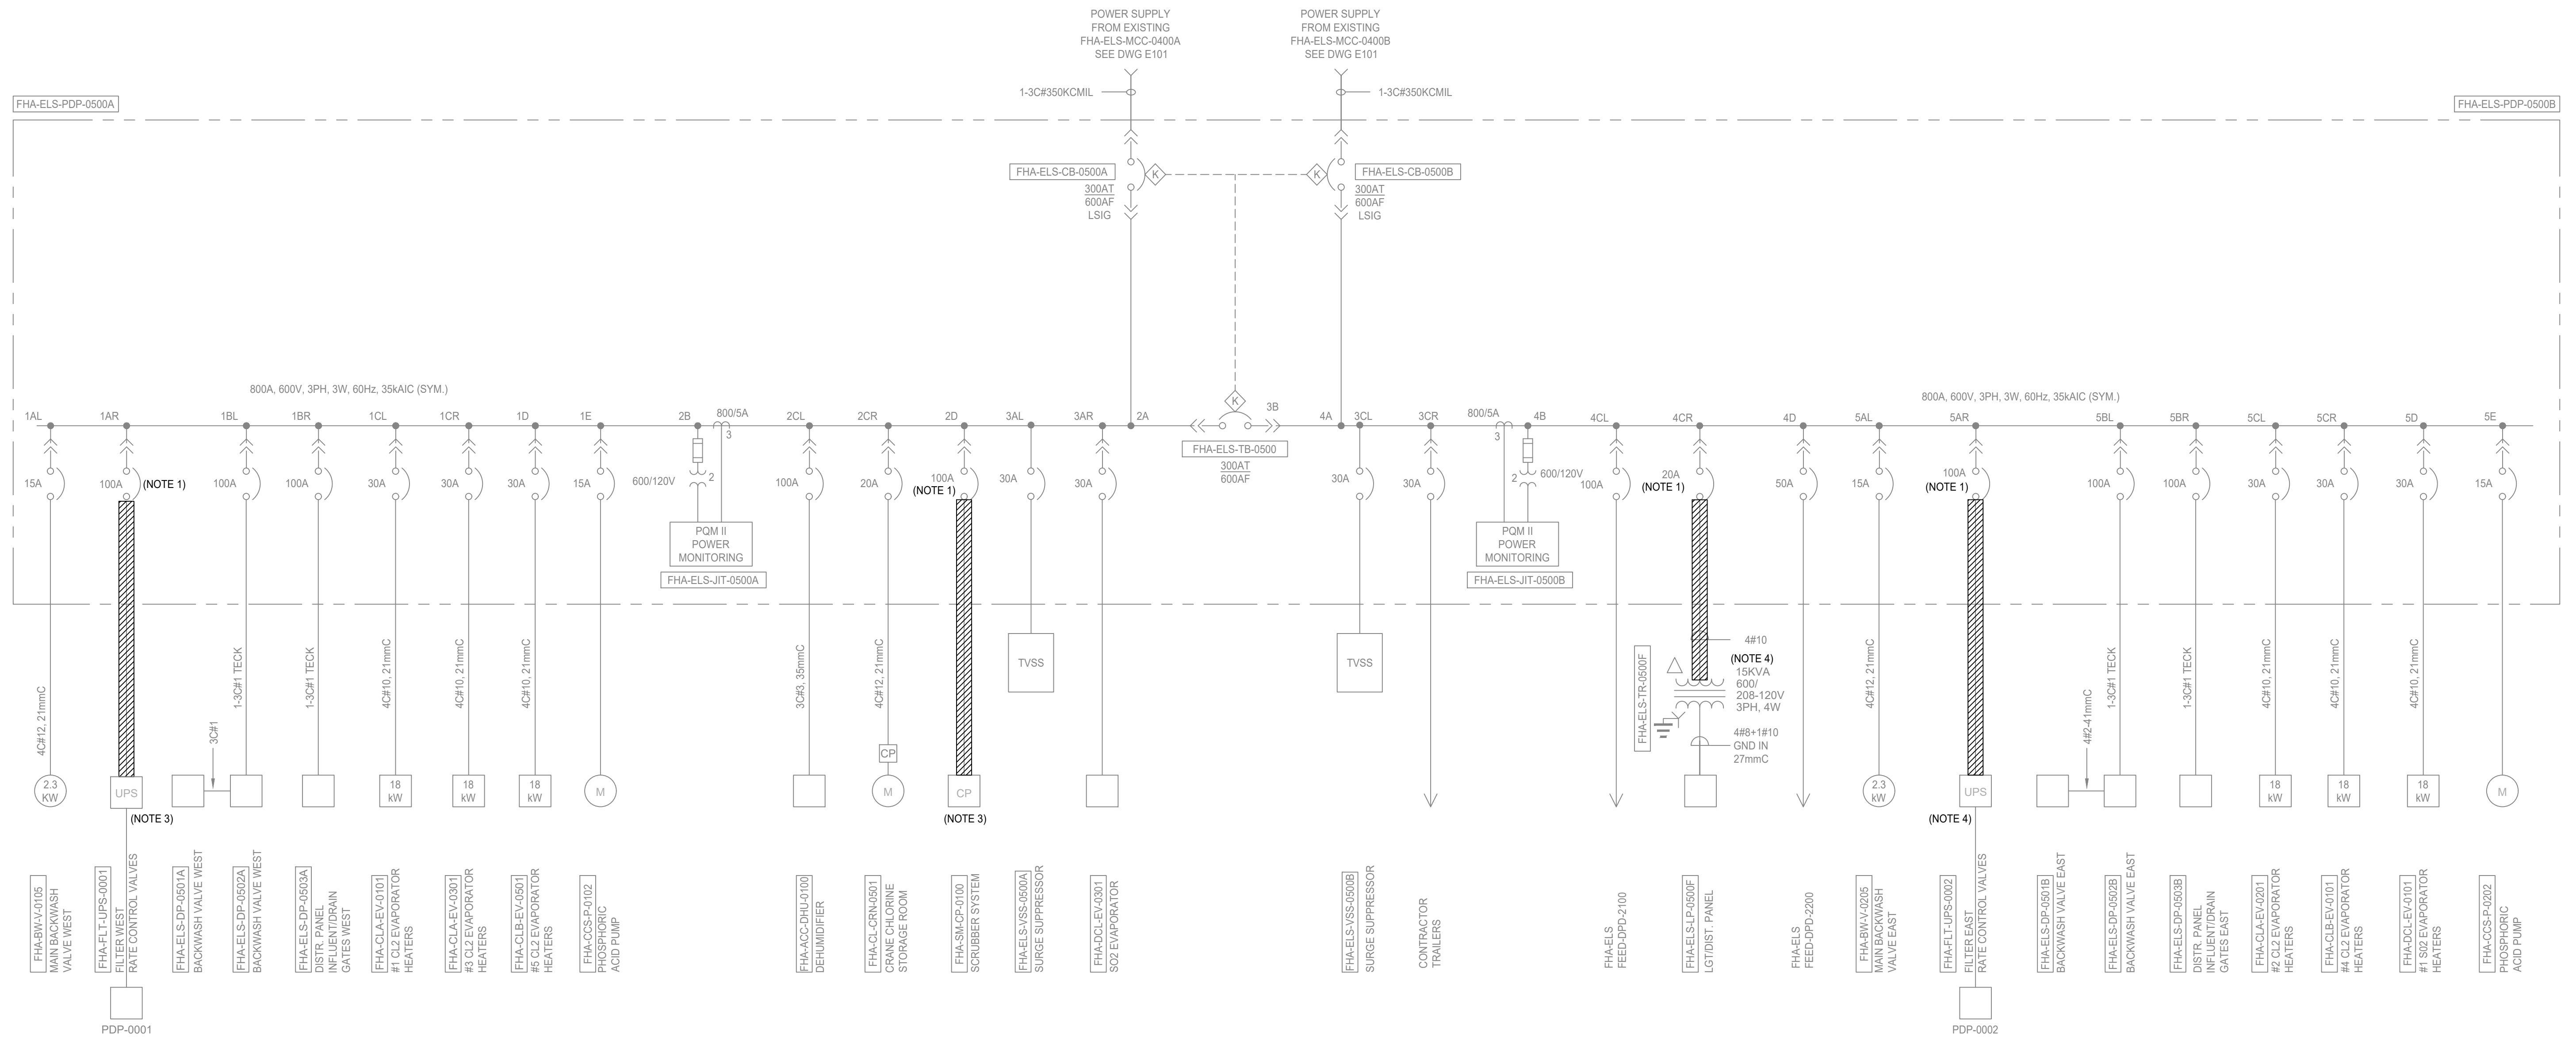

NOTES:


1. MCC CUBICLES TO BE SPARE.
2. WHEN RELOCATING OR REMOVING EQUIPMENT, SHOULD ANY CIRCUITS BE ABANDONED, THE CONDUCTORS TO THESE CIRCUITS MUST BE REMOVED OR PROPERLY TERMINATED AS DETAILED IN RULE 2-130, RULE 12-114, RULE 12-3000 AND BULLETIN 12-25*.
3. REFEED FROM FHA-ELS-PDP-0401A. SEE DRAWING E105.
4. REFEED FROM FHA-ELS-PDP-0401B. SEE DRAWING E105.

FHA-ELS-PDP-0500A/B SINGLE LINE DIAGRAM - MODIFICATIONS


N.T.S.

																																																																																																																																																																																																																																																																																																																																																																																																																																																																																																																																																																																																																																																																																																																																																																																																																																																																																																																																																																																																																																																																																																																																																																																																																																																																																																																																																																																																														</
---	--	--	----

Drawing: J:\M16-0273 TOR_HARRIS\WP-STANDBYGENERATOR\500_CAD\401-CAD\1-SS OR BU\SHEET\6 ELEC\2F-2017-08-50-E112.DWG
Layout: 03/19/2025 12:35:32 PM
Date: 03/19/2025 Time: 12:35:32 PM

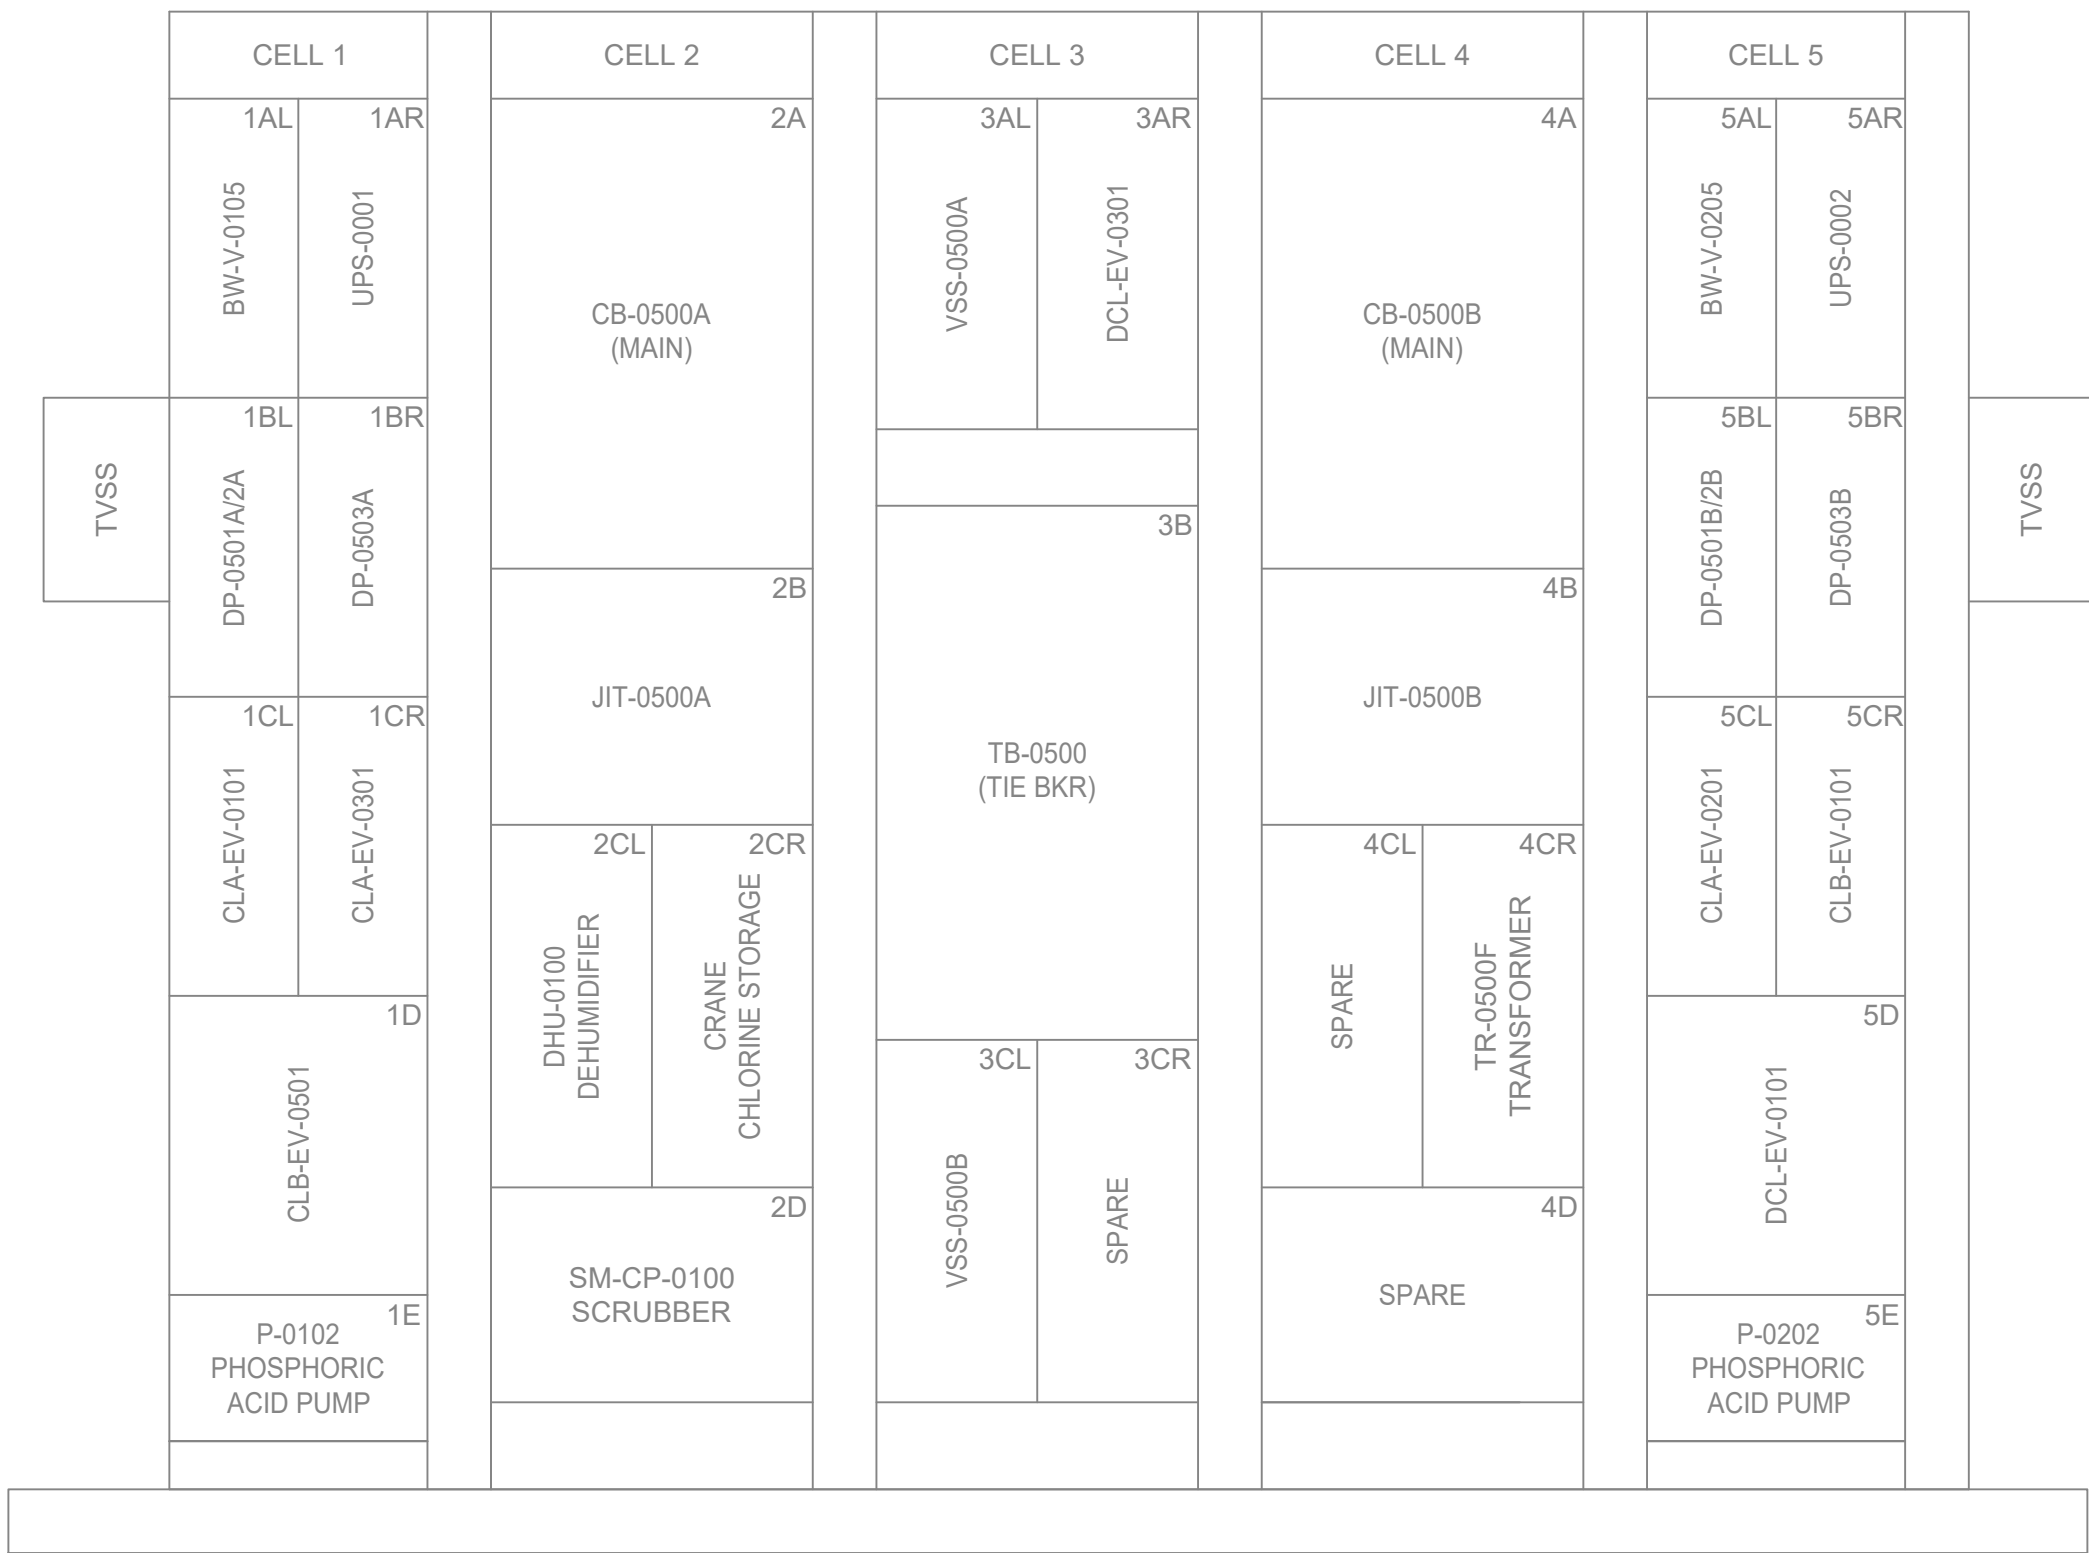

EXISTING

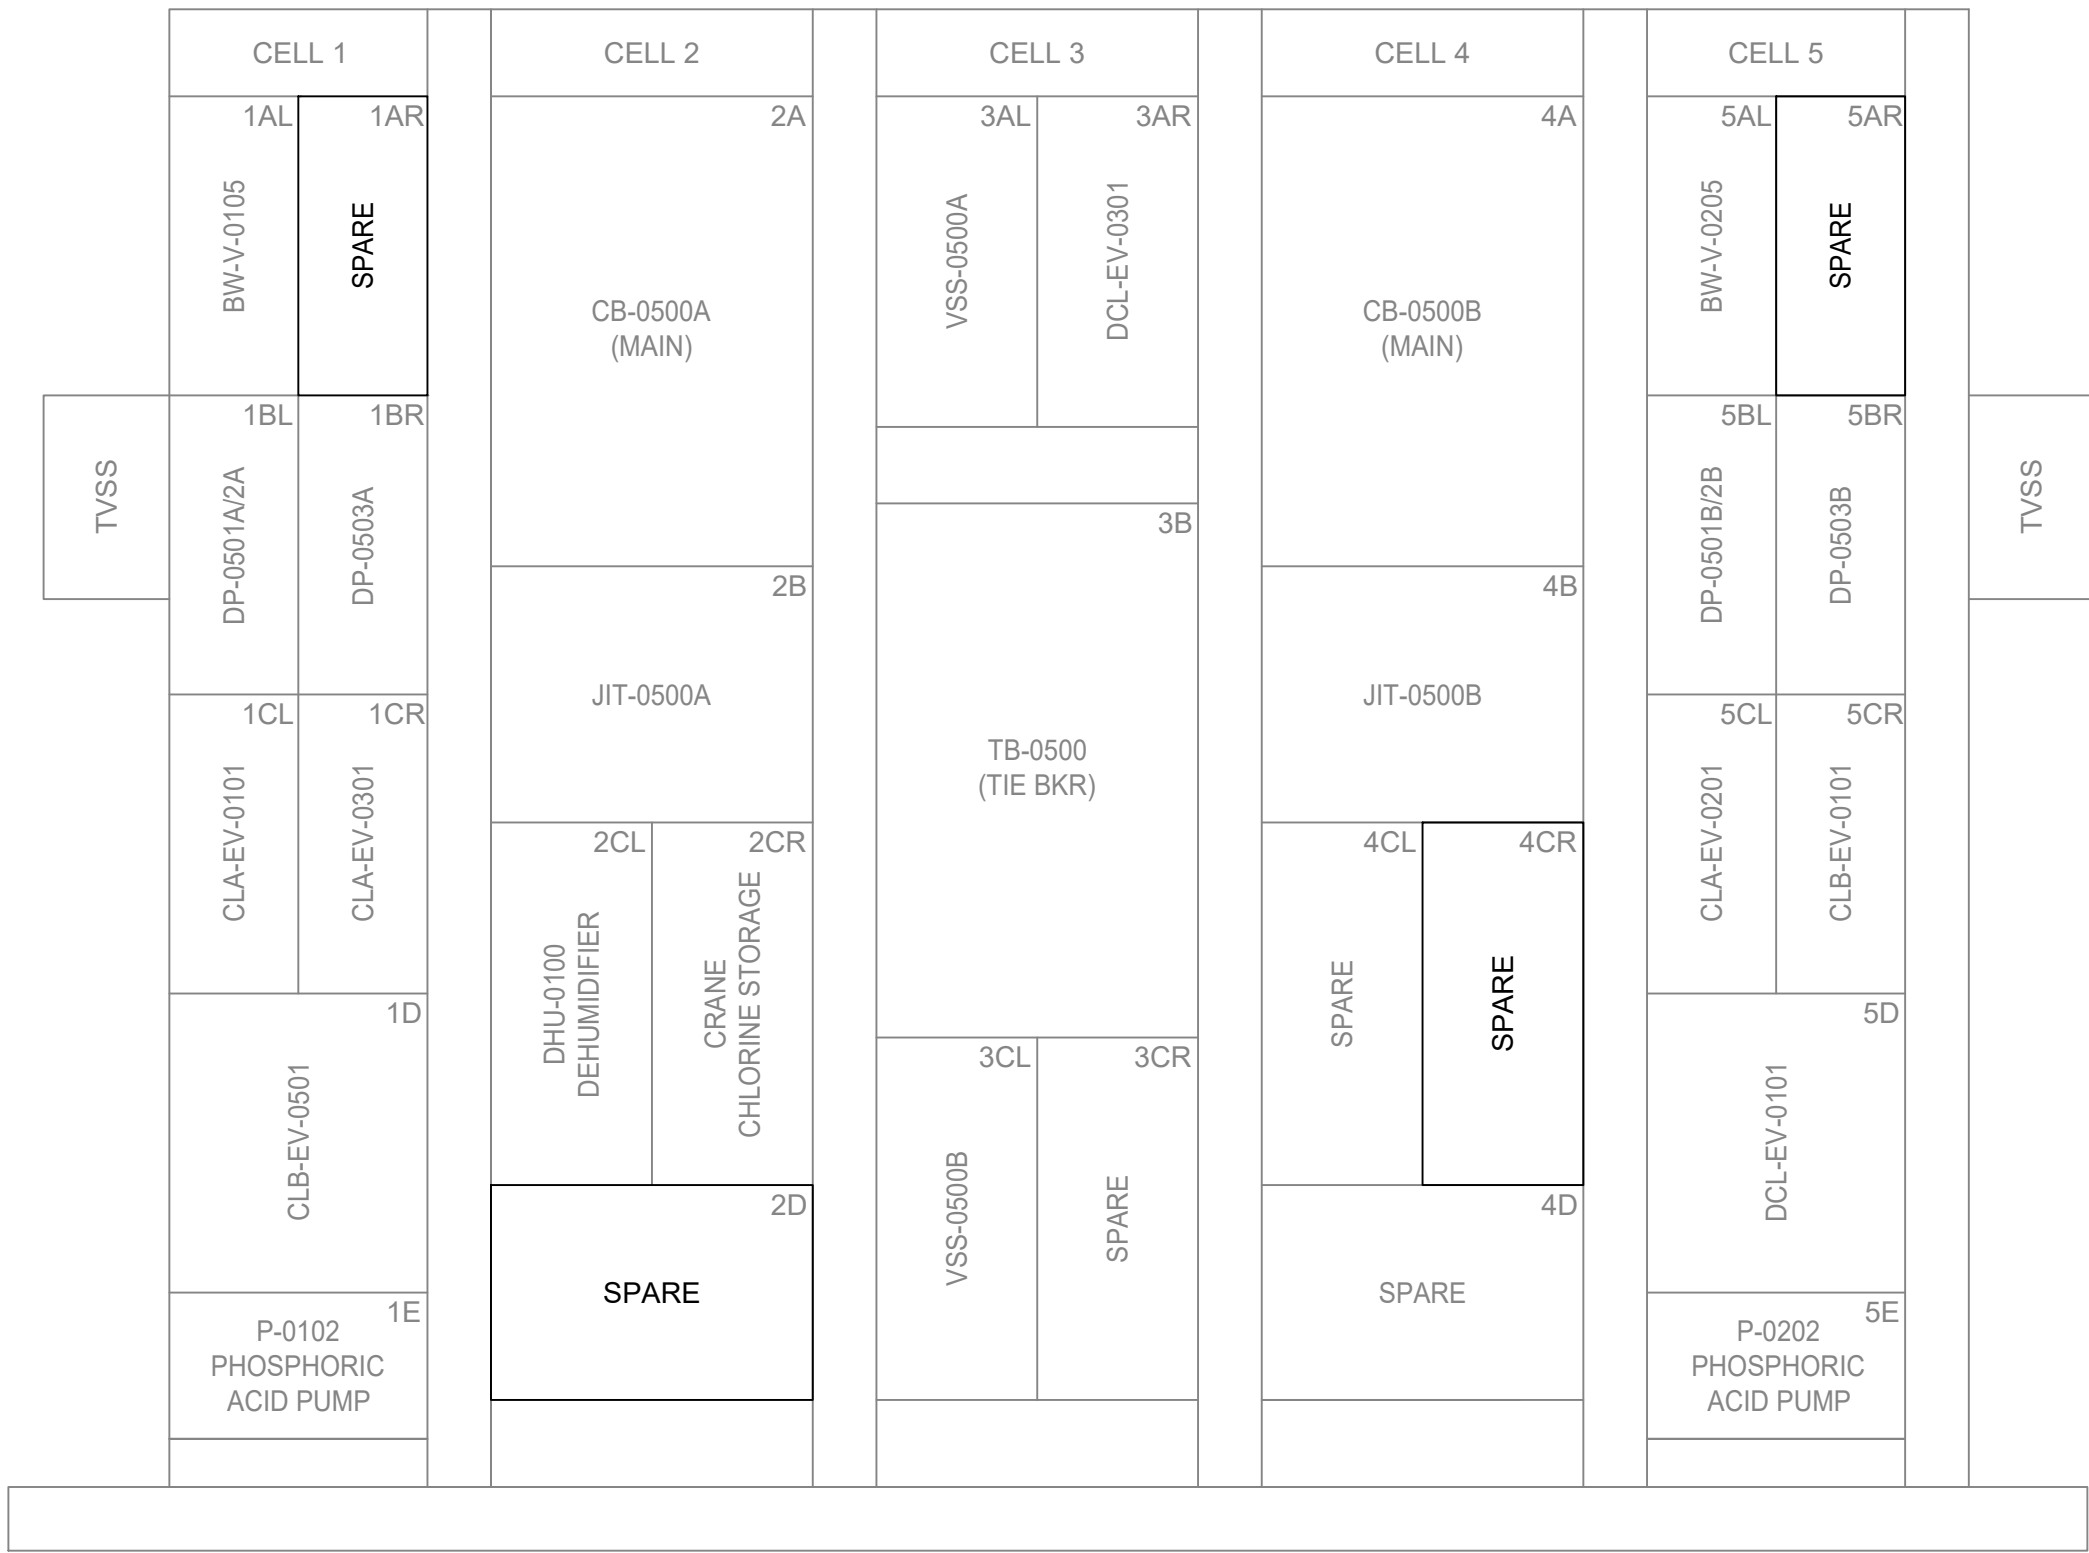

MODIFICATIONS


ELECTRICAL CHARACTERISTICS:

600 VOLTS	HORIZONTAL BUS: 800A
3 PH	VERTICAL BUS: 800A
3 WIRE	SCCR: 35kAIC (SYM RMS.)
60 Hz	BUS BRACING: 42kAIC (SYM RMS.)
	ENCLOSURE TYPE: EEMAC 1A (GASKETED)

- NOTES:**
- REFER TO DWG E203 FOR LOCATION DETAILS.
 - ALL CONDUCTORS, EQUIPMENT, AND FIELD CONNECTIONS SHALL BE TAGGED AND IDENTIFIED AS PER CITY REQUIREMENTS.



FHA-ELS-PDP-0500A/B ELEVATION LAYOUT- EXISTING AND MODIFICATIONS

N.T.S.

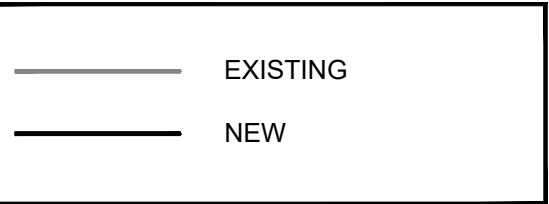

								TORONTO WATER		R.C. HARRIS WATER TREATMENT PLANT INSTALLATION OF A STANDBY GENERATOR FOR CRITICAL LOADS FHA-ELS-PDP-0500A/B ELEVATION LAYOUT- EXISTING AND MODIFICATIONS			
						ENGINEERING AND CONSTRUCTION SERVICES							
 100-175 GALAXY BOULEVARD TORONTO, ONTARIO, M9W 0C9 TEL 416 679 1930 FAX 416 675 4620 www.arcadis.com		COPYRIGHT: This drawing has been prepared solely for the intended use. Thus, any reproduction or distribution for any purpose other than authorized by ARCADIS is forbidden. Written dimensions shall have precedence over scaled dimensions. Contractors shall verify and be responsible for all dimensions and conditions on the job, and ARCADIS shall be informed of any variations from the dimensions and conditions shown on the drawing. Shop drawings shall be submitted to IRI Group for general conformance before proceeding with fabrication.		A 2025-03-18 ISSUED FOR TENDER T.S.				WILLIAM FERNANDES, P. ENG. DIRECTOR WATER TREATMENT AND SUPPLY		SIMON HOPTON, P. ENG. DIRECTOR DESIGN & CONSTRUCTION MAJOR INFRASTRUCTURE			
												ELECTRICAL	
												DESIGN:	SC
								DRAWING NUMBER:		2F-2017-08-50	E112		
								DATE:		2024-09-30			

Drawing: J:\M16-0273 TOR_HARRIS\WP-STANDBYGENERATOR\500_CAD\401-CAD\1-SS OR BU\SHEET\6 ELEC\2F-2017-08-51-E121.DWG
Layout: 03/19/2025 12:35:44 PM
Date: 03/19/2025

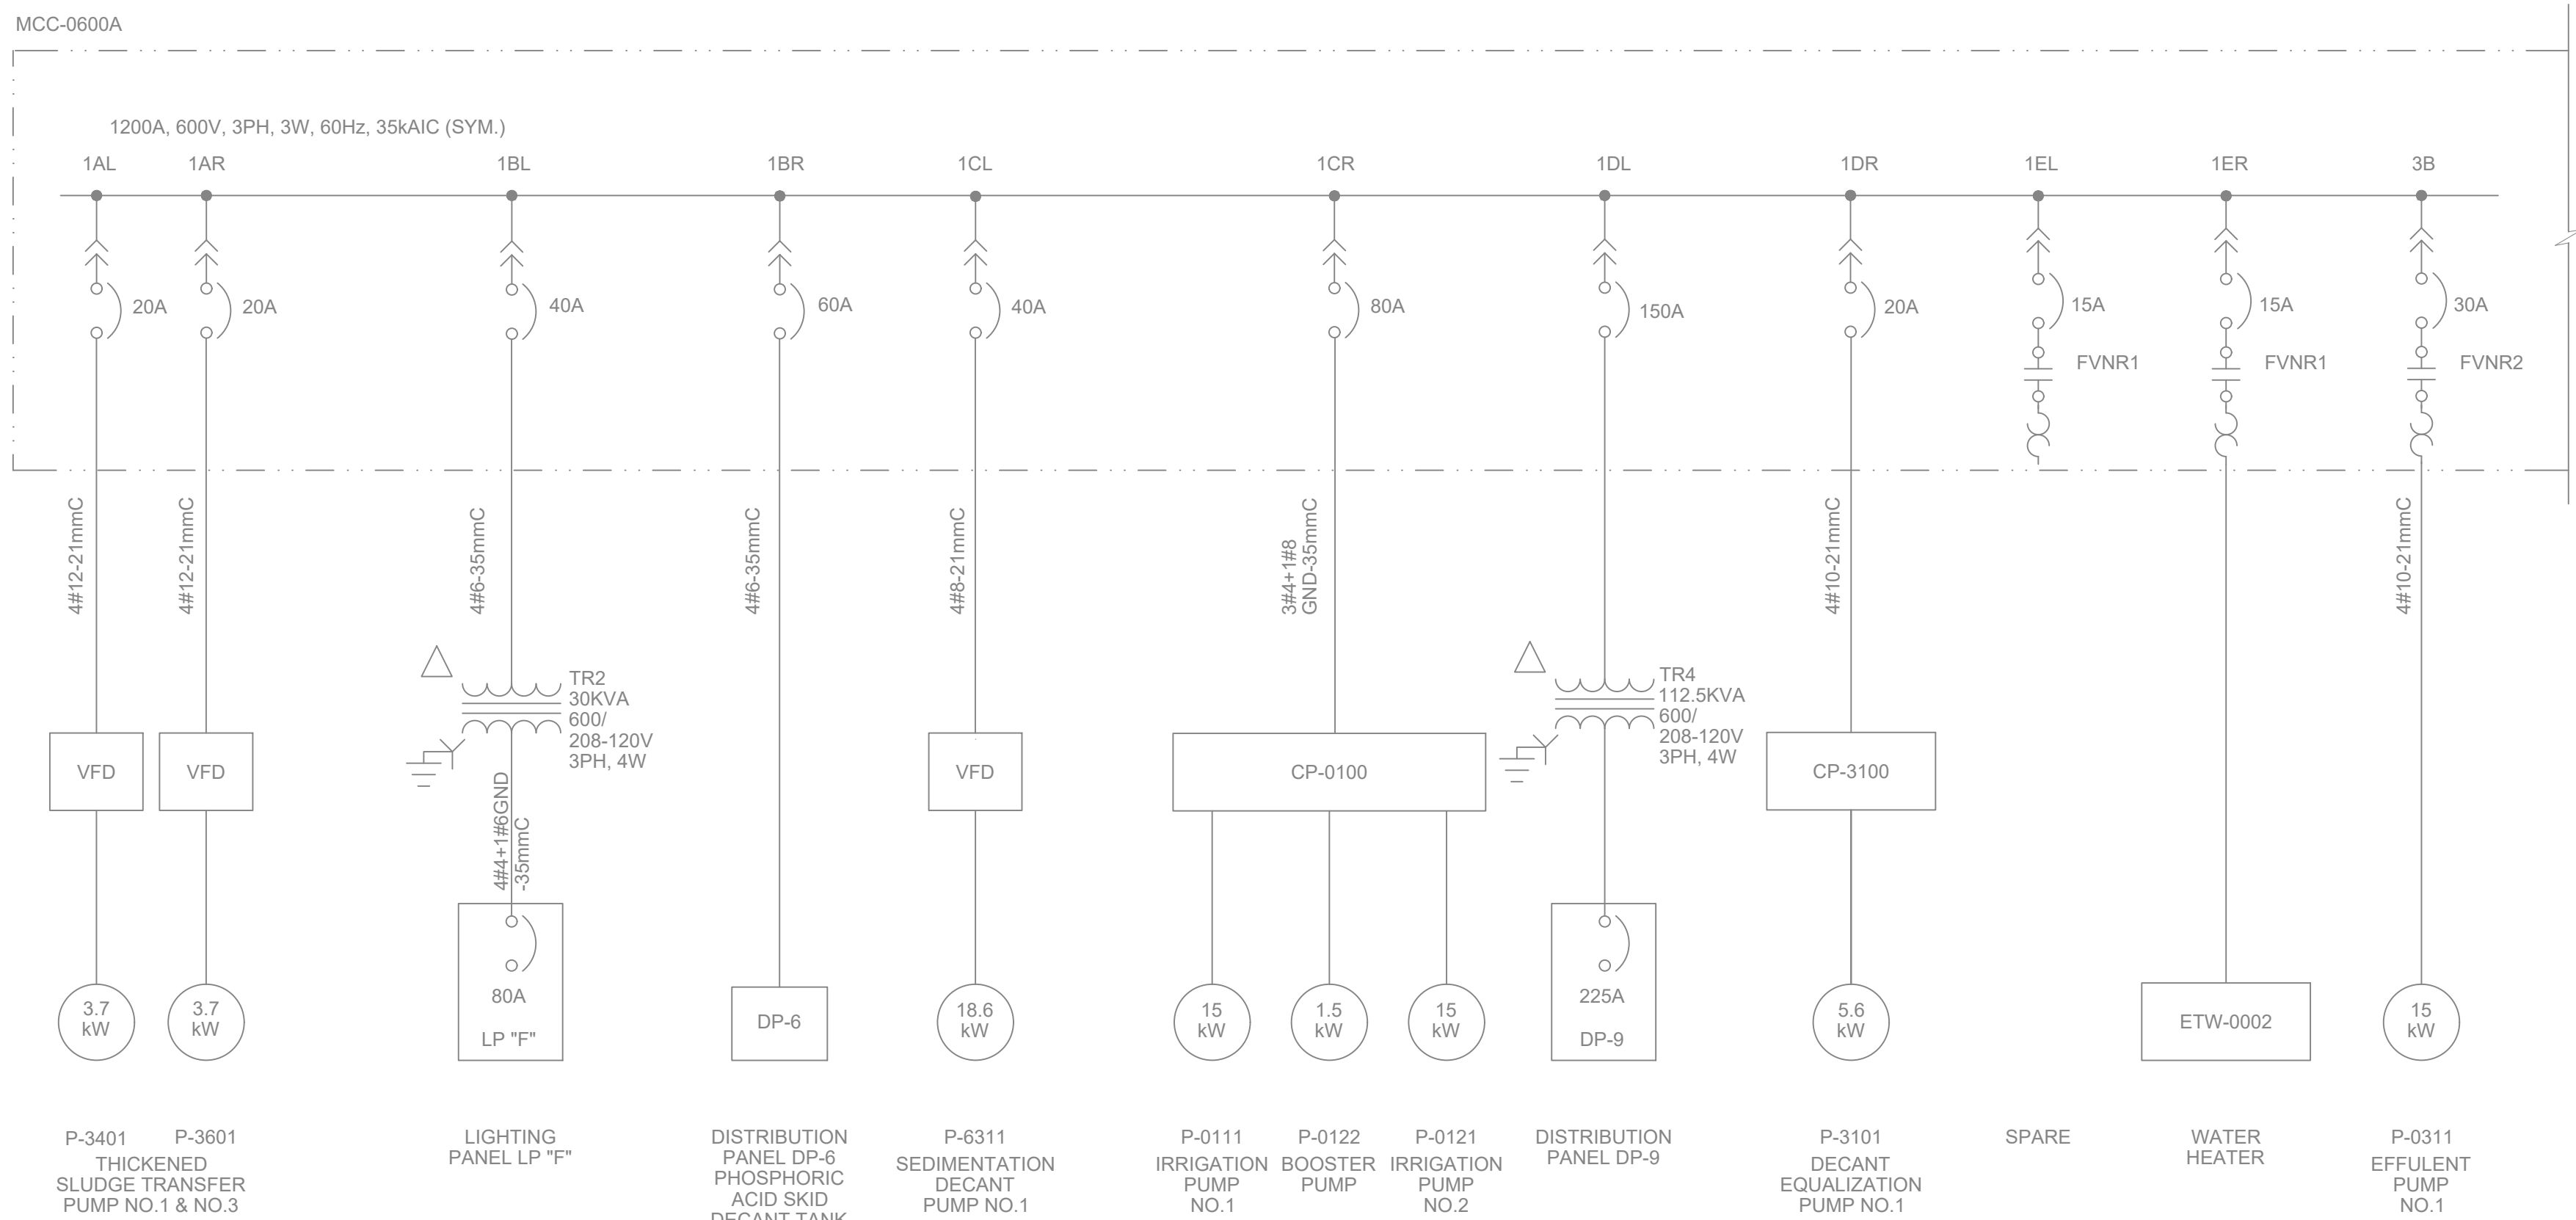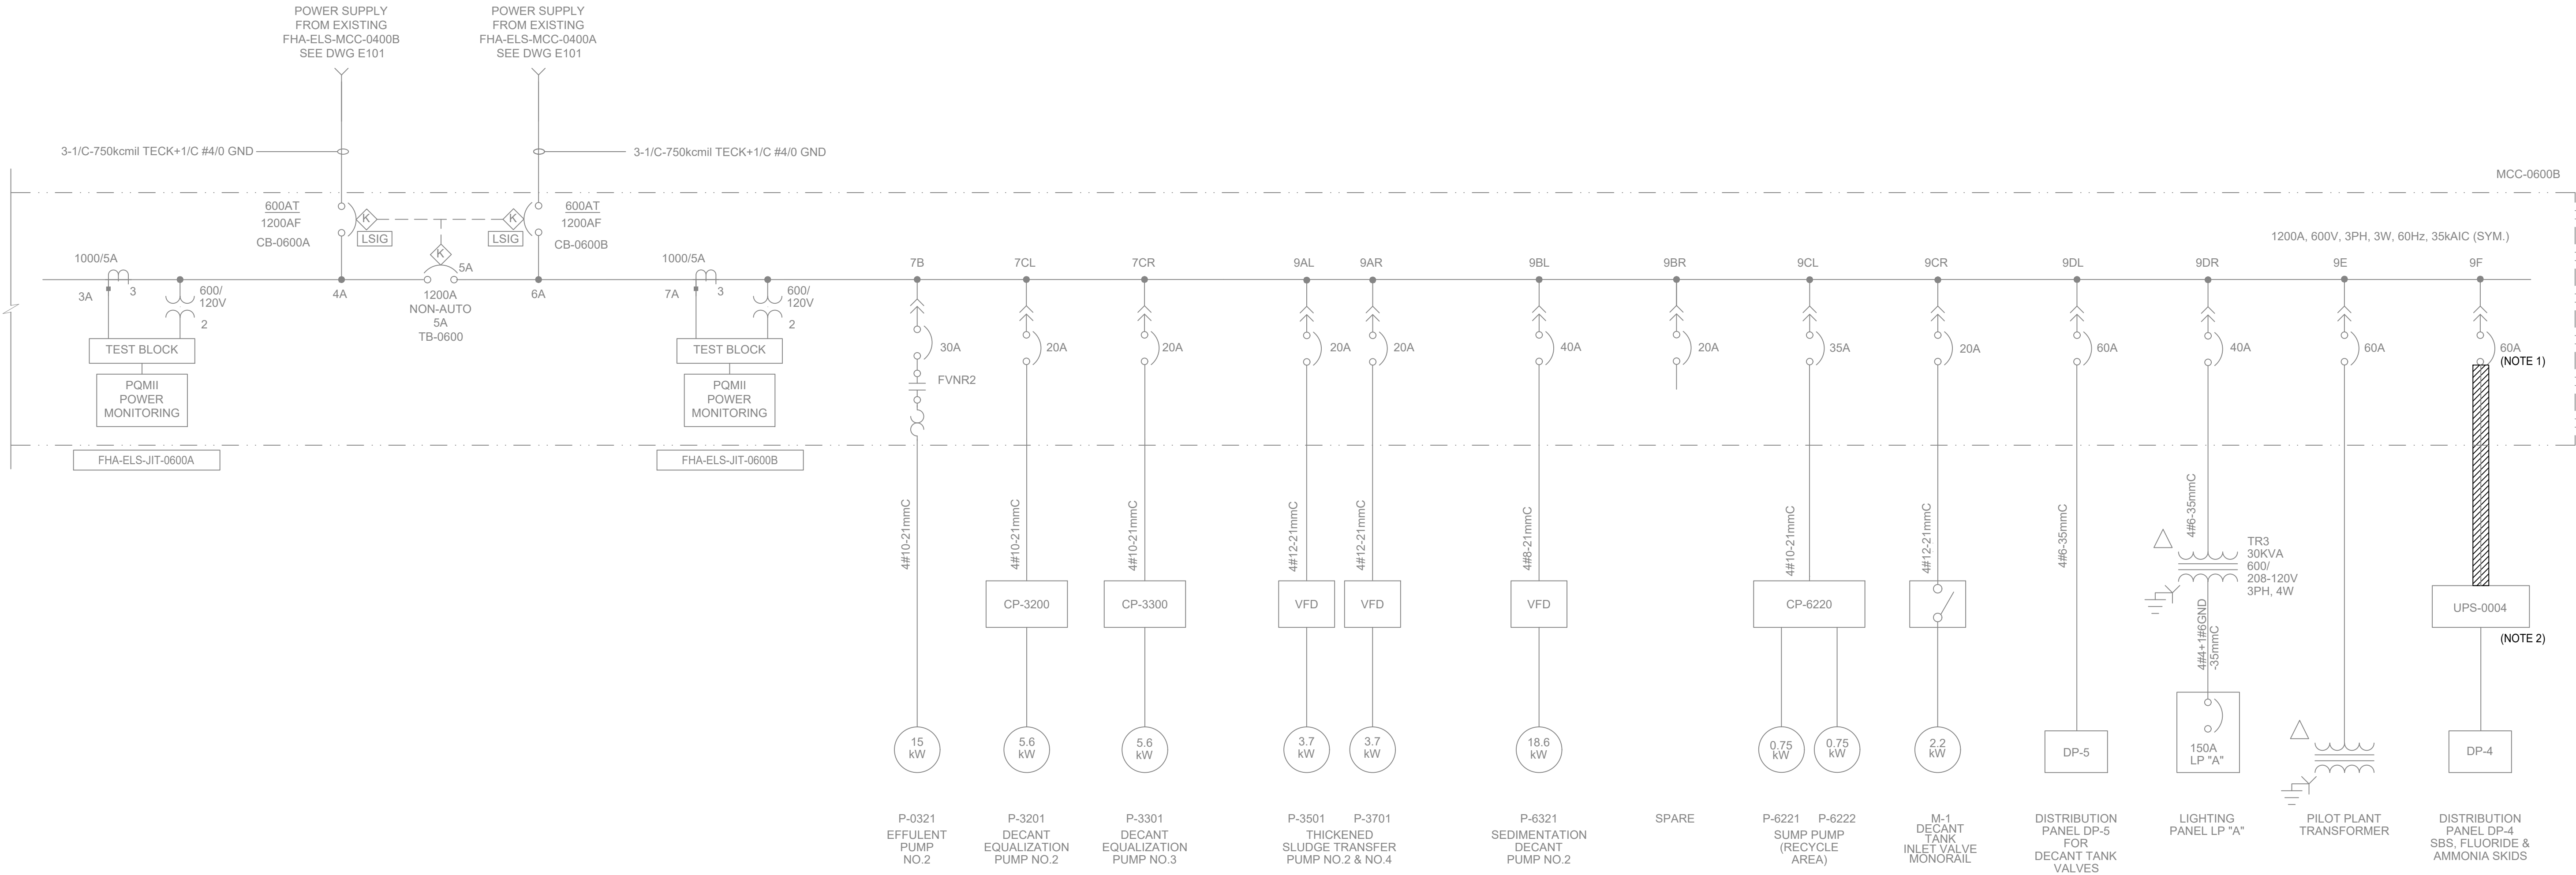

NOTES:

- MCC CUBICLE TO BE SPARE.
- REFEED FROM FHA-ELS-PDP-0400E. SEE DWG E103.
- WHEN RELOCATING OR REMOVING EQUIPMENT, SHOULD ANY CIRCUITS BE ABANDONED, THE CONDUCTORS TO THESE CIRCUITS MUST BE REMOVED OR PROPERLY TERMINATED AS DETAILED IN RULE 2-130, RULE 12-114, RULE 12-3000 AND BULLETIN 12-25-.

FHA-ELS-MCC-0600A/B SINGLE LINE DIAGRAM - MODIFICATIONS
N.T.S

EXISTING
NEW
REMOVAL, TO BE REPLACED WITH NEW CABLES & INSTALLED COMPLETE

												TORONTO WATER		R.C. HARRIS WATER TREATMENT PLANT INSTALLATION OF A STANDBY GENERATOR FOR CRITICAL LOADS FHA-ELS-MCC-0600A/B SINGLE LINE DIAGRAM - MODIFICATIONS								
												ENGINEERING AND CONSTRUCTION SERVICES										
 100-175 GALAXY BOULEVARD TORONTO, ONTARIO, M9W 0C9 TEL 416 679 1930 FAX 416 675 4620 www.arcadis.com		COPYRIGHT: This drawing has been prepared solely for the intended use, thus any reproduction or distribution for any purpose other than that authorized by ARCADIS is forbidden. Written dimensions shall have precedence over scaled dimensions. Contractors shall verify and be responsible for all dimensions and conditions on the job, and ARCADIS shall be informed of any variations from the dimensions and conditions shown on the drawing. Shop drawings shall be submitted to IRI Group for general conformance before proceeding with fabrication.												WILLIAM FERNANDES, P. ENG. DIRECTOR WATER TREATMENT AND SUPPLY		SIMON HOPTON, P. ENG. DIRECTOR DESIGN & CONSTRUCTION MAJOR INFRASTRUCTURE						
		A 2025-03-18 ISSUED FOR TENDER		T.S.																		
		NO.		DATE		REVISIONS		INITIAL		SIGNED												
														ELECTRICAL								
														DESIGN:		SC	DRAFTING:	SC	CHECK:	TS	CONTRACT No. 25ECS-MI-03HA	
														SCALE:		N.T.S.						
														DATE:		2024-09-30		DRAWING NUMBER:		2F-2017-08-51		E121

EXISTING


MODIFICATIONS

600 VOLTS	VERTICAL BUS: CELL 4-6: 1200A
3 PH	CELL 1-3: 600A
3 WIRE	CELL 7-9: 600A
60 Hz	SCCR: 35kAIC (SYM RMS.)
HORIZONTAL BUS: 1200A	BUS BRACING: 42kAIC (SYM RMS.)
	ENCLOSURE TYPE: EEMAC 1A (GASKETED)

1. REFER TO DWG E202 FOR LOCATION DETAILS.
2. ALL CONDUCTORS, EQUIPMENT, AND FIELD CONNECTIONS SHALL BE TAGGED AND IDENTIFIED AS PER CITY REQUIREMENTS.

N.T.S.

— EXISTING
— NEW

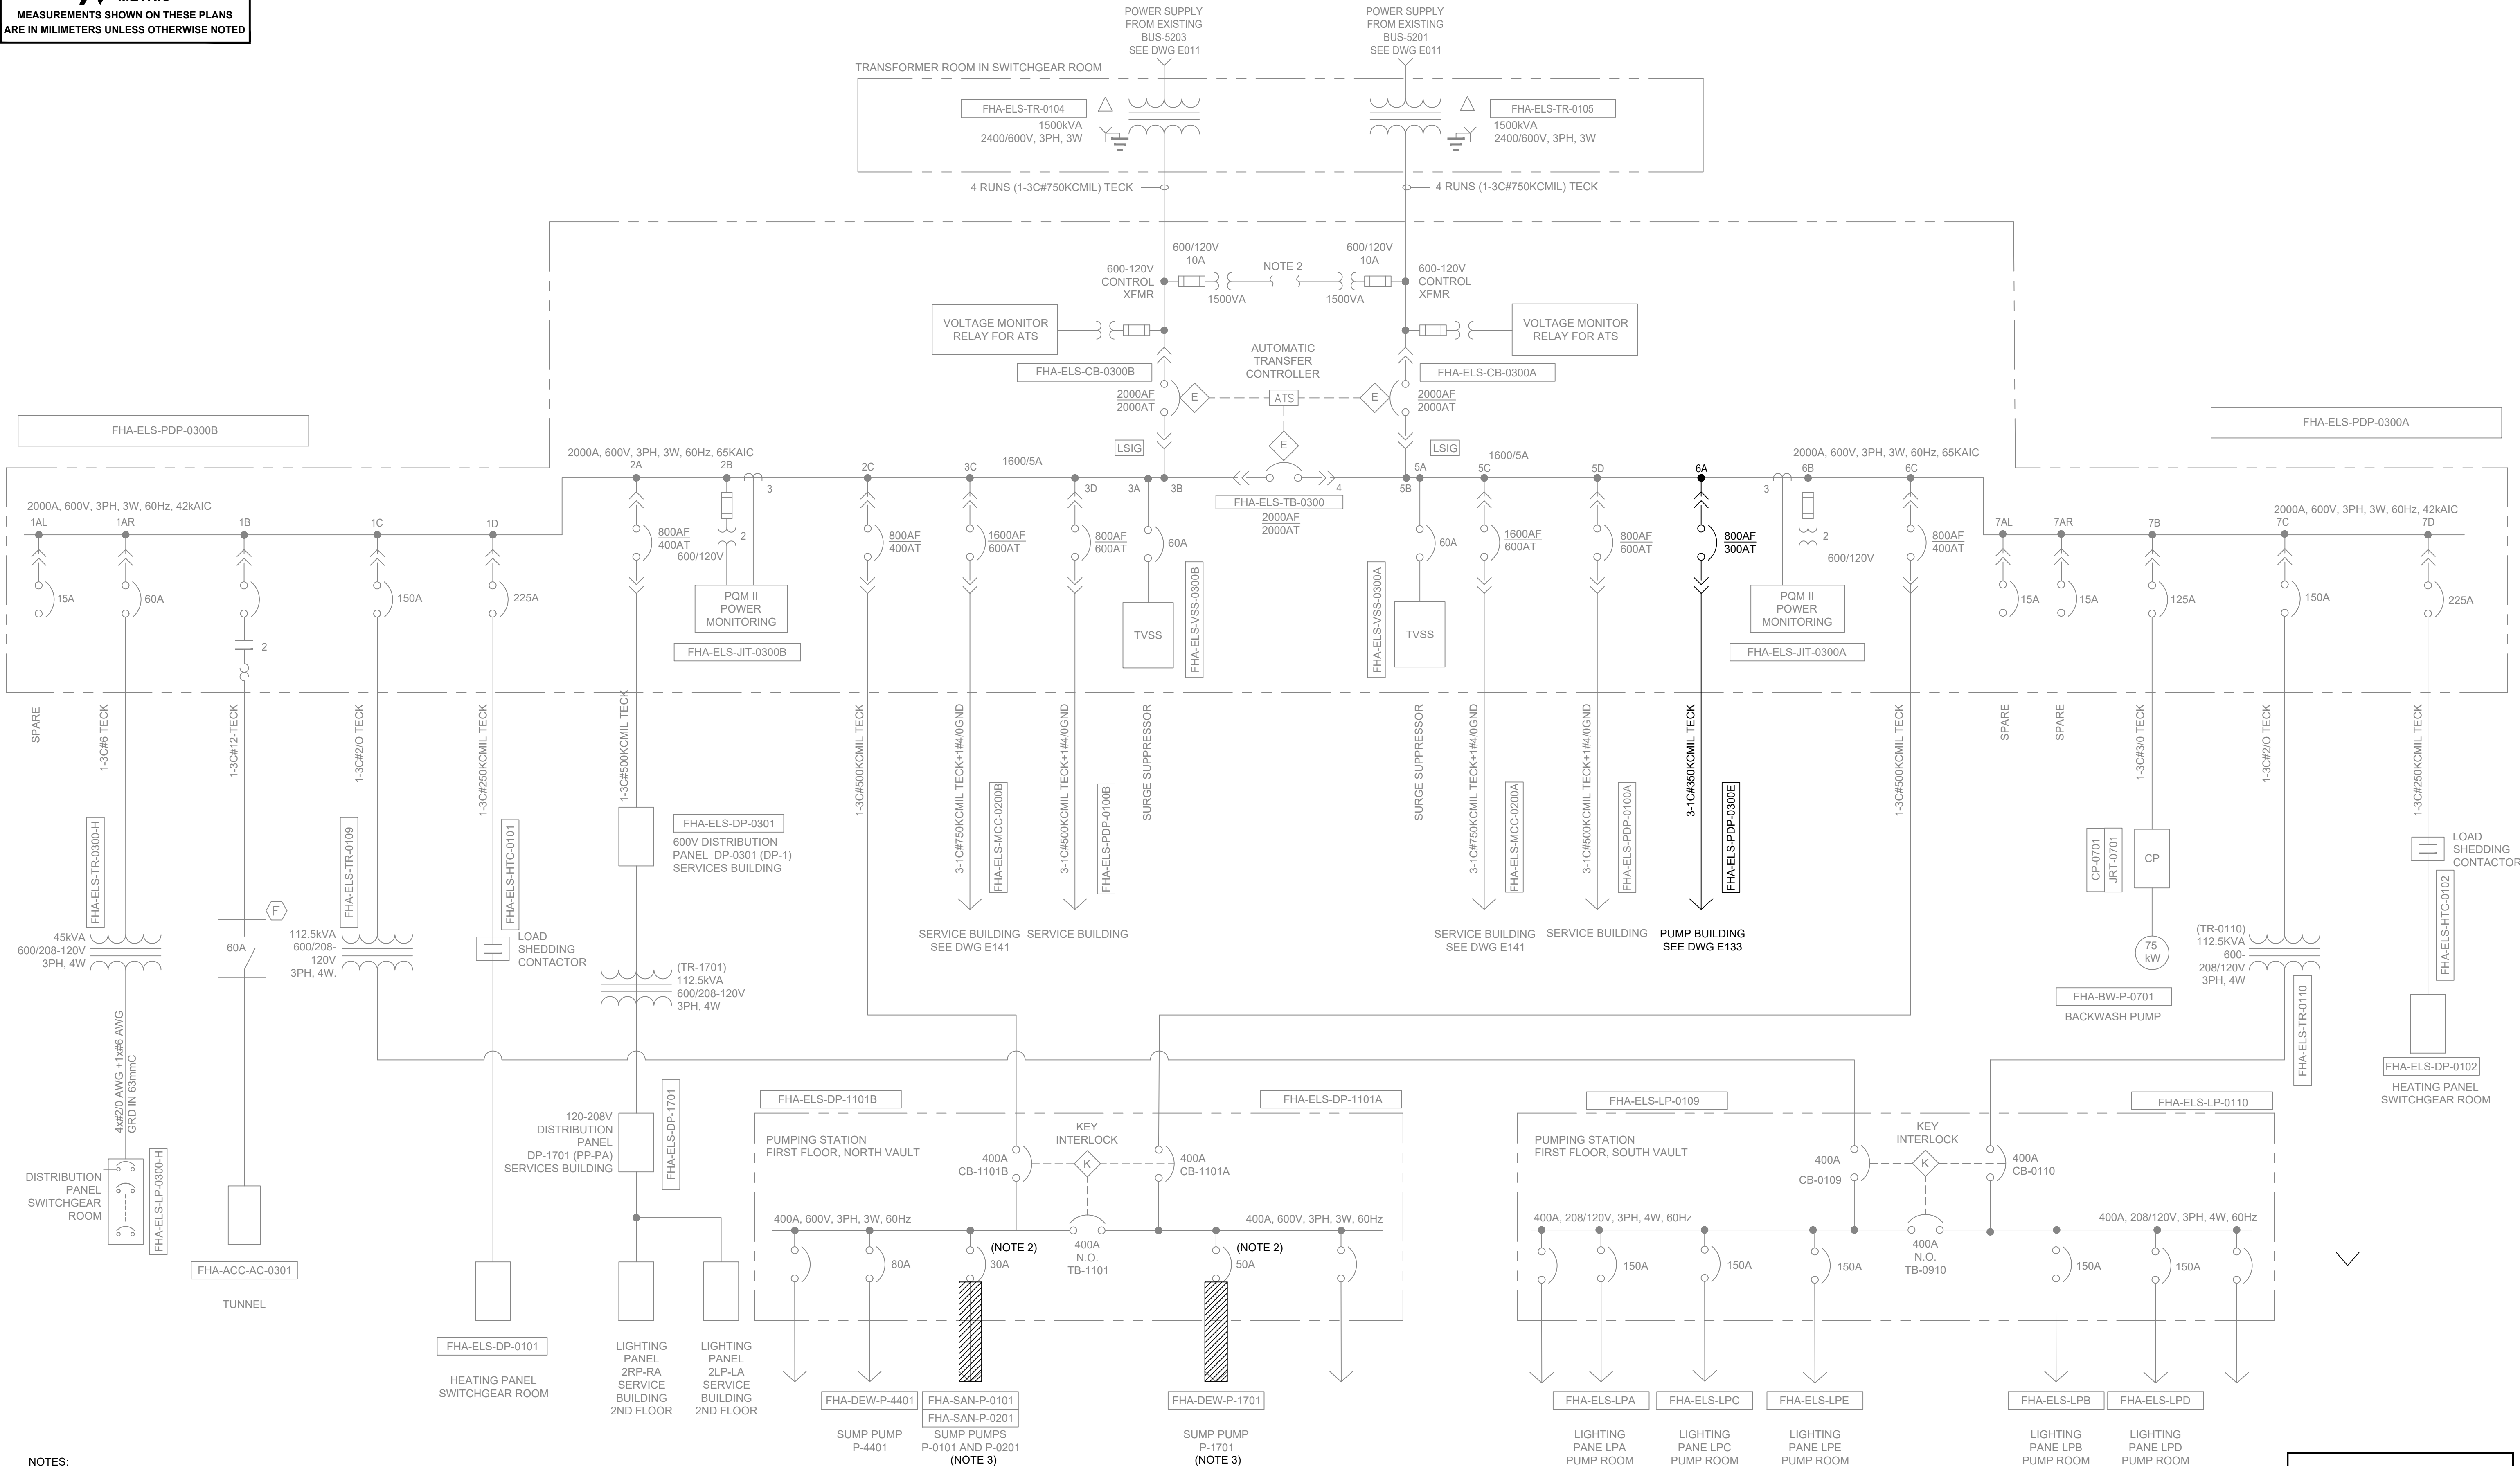

- NOTES:**
- EXISTING CIRCUIT BREAKER TO BE REPLACED WITH A NEW 200A CIRCUIT BREAKER.
 - MCC CUBICLES TO BE SPARE
 - REFEED FROM FHS-ELS-0300E. SEE DRAWING E133.
 - WHEN RELOCATING OR REMOVING EQUIPMENT, SHOULD ANY CIRCUITS BE ABANDONED, THE CONDUCTORS TO THESE CIRCUITS MUST BE REMOVED OR PROPERLY TERMINATED.

FHA-ELS-PDP-0300 SINGLE LINE DIAGRAM - MODIFICATIONS
N.T.S.


Drawing: J:\M16-0273 TOR_HARRIS\WP-STANDBYGENERATOR\500_CAD\401-CAD\1-SS OR BUS\SHEET\6 ELEC\2F-2017-08-53-E131.DWG
Layout: 03/19/2025
Date: 03/19/2025
Time: 12:36:07 PM

										TORONTO WATER ENGINEERING AND CONSTRUCTION SERVICES				R.C. HARRIS WATER TREATMENT PLANT INSTALLATION OF A STANDBY GENERATOR FOR CRITICAL LOADS FHA-ELS-PDP-0300 SINGLE LINE DIAGRAM - MODIFICATIONS			
 100-175 GALAXY BOULEVARD TORONTO, ONTARIO, M9W 0C9 TEL 416 679 1930 FAX 416 675 4620 www.arcadis.com		COPYRIGHT: This drawing has been prepared solely for the intended use, thus any reproduction or distribution for any purpose other than authorized by ARCADIS is forbidden. Written dimensions shall have precedence over scaled dimensions. Contractors shall verify and be responsible for all dimensions and conditions on the job, and ARCADIS shall be informed of any variations from the dimensions and conditions shown on the drawing. Shop drawings shall be submitted to Bli Group for general conformance before proceeding with fabrication.							WILLIAM FERNANDES, P.ENG DIRECTOR WATER TREATMENT AND SUPPLY	SIMON HOPTON, P.ENG. DIRECTOR DESIGN & CONSTRUCTION MAJOR INFRASTRUCTURE							
		A 2025-03-18 ISSUED FOR TENDER T.S.															
		NO. DATE REVISIONS		INITIAL SIGNED													

ELECTRICAL							
DESIGN:	SC	DRAFTING:	SC	CHECK:	TS	CONTRACT No. 25ECS-MI-03HA	
SCALE:	N.T.S.			DRAWING NUMBER:	2F-2017-08-53		E131
DATE:	2024-09-30						



EXISTING

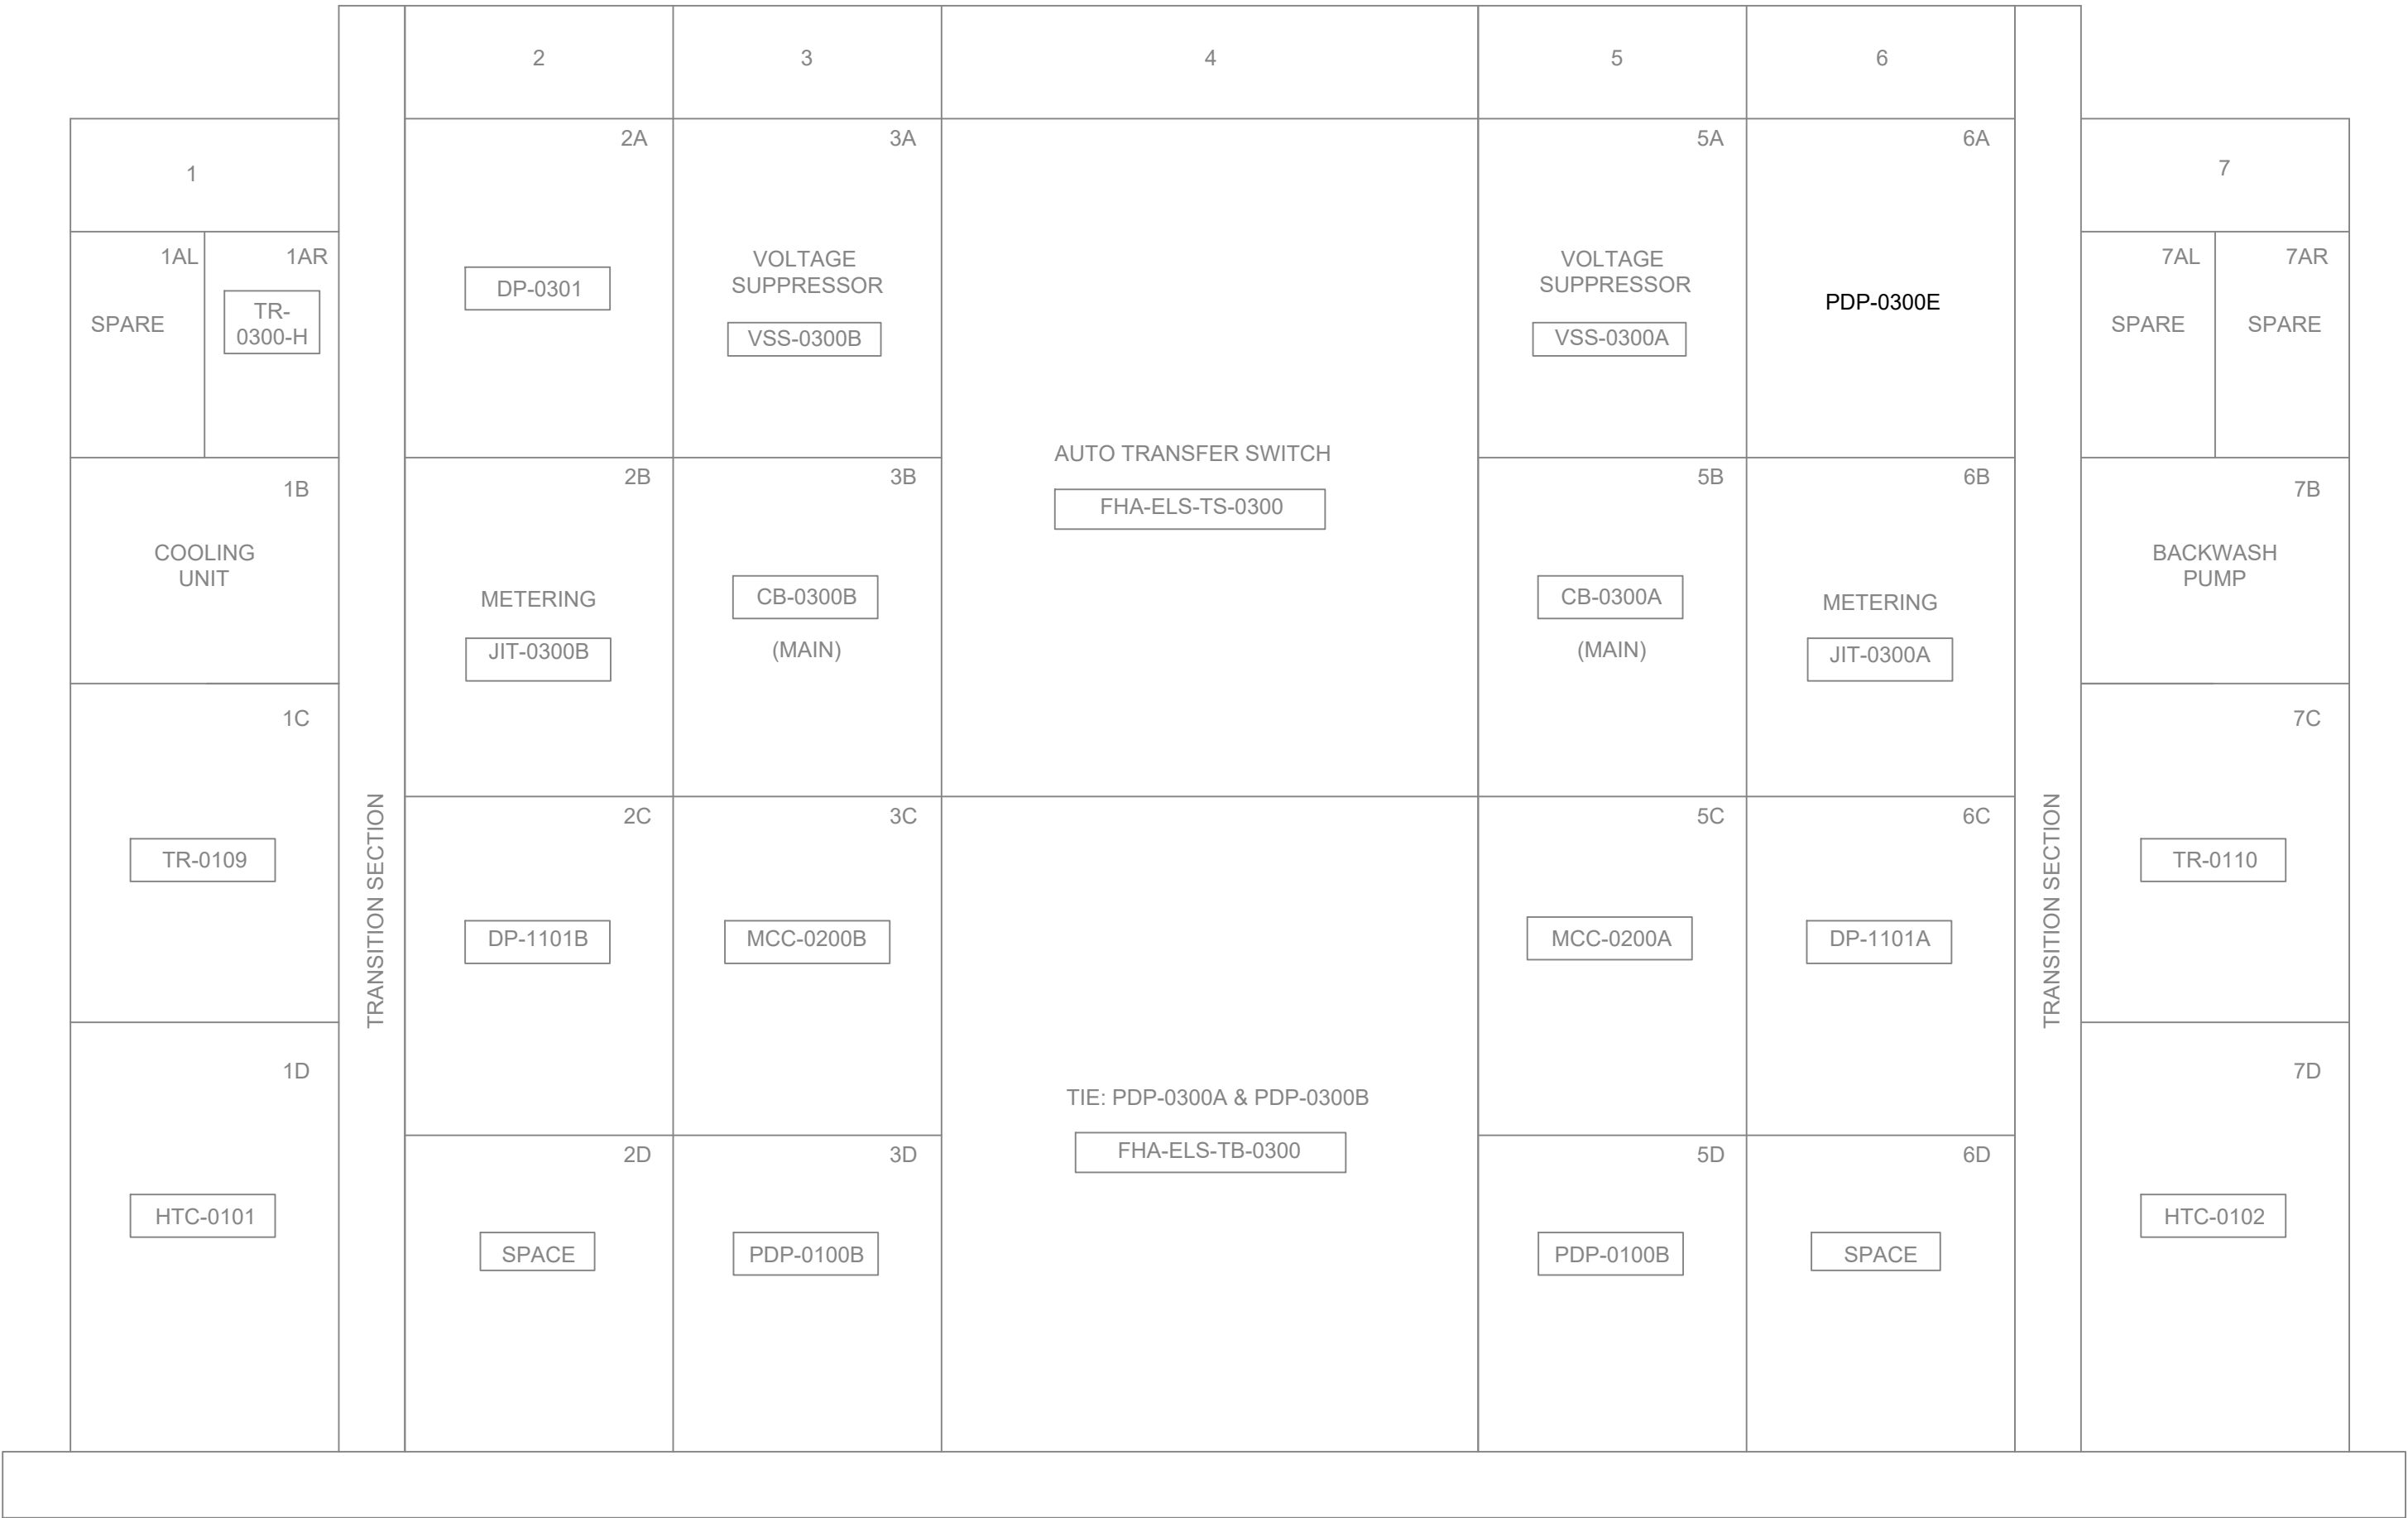


MODIFICATIONS

ELECTRICAL CHARACTERISTICS:

600 V MAIN BUS: 2000A
3 PH SCCR: 42KAIC (SYM RMS.)
3 WIRE BUS BRACING: 42KAIC (SYM RMS.)
60 Hz ENCLOSURE TYPE: EEMAC 1A (GASKETED)

NOTES:

- REFER TO DWG E205 FOR LOCATION DETAILS.
- ALL TAG NAMES SHOWN ON THE DRAWINGS HAVE A PREFIX OF "FHA". ALL CONDUCTORS, EQUIPMENT, AND FIELD CONNECTIONS SHALL BE TAGGED AND IDENTIFIED AS PER CITY REQUIREMENTS.
- DIMENSIONS ARE SHOWN IN MILLIMETERS UNLESS OTHERWISE NOTED.

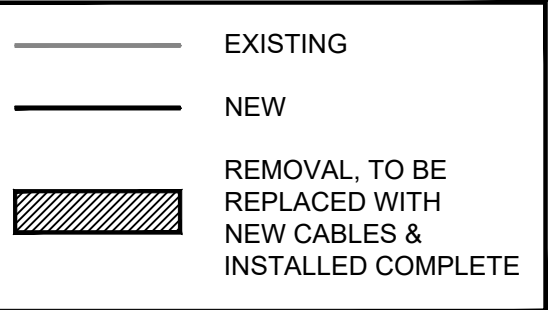

FHA-ELS-PDP-0300 ELEVATION LAYOUT - EXISTING AND MODIFICATIONS
SCALE: 1:10

								TORONTO WATER ENGINEERING AND CONSTRUCTION SERVICES		R.C. HARRIS WATER TREATMENT PLANT INSTALLATION OF A STANDBY GENERATOR FOR CRITICAL LOADS FHA-ELS-PDP-0300 ELEVATION LAYOUT - EXISTING AND MODIFICATIONS									
		COPYRIGHT: This drawing has been prepared solely for the intended use. Thus, any reproduction or distribution for any purpose other than authorized by ARCADIS is forbidden. Written dimensions shall have precedence over scaled dimensions. Contractors shall verify and be responsible for all dimensions and conditions on the job, and ARCADIS shall be informed of any variations from the dimensions and conditions shown on the drawing. Shop drawings shall be submitted to IRI Group for general conformance before proceeding with fabrication.										WILLIAM FERNANDES, P. ENG. DIRECTOR WATER TREATMENT AND SUPPLY		SIMON HOPTON, P. ENG. DIRECTOR DESIGN & CONSTRUCTION MAJOR INFRASTRUCTURE		ELECTRICAL			
100-175 GALAXY BOULEVARD TORONTO, ONTARIO, M9W 0C9 TEL 416 679 1930 FAX 416 675 4620 www.arcadis.com		A 2025-03-18 ISSUED FOR TENDER				T.S.						DESIGN: SC DRAFTING: SC CHECK: TS CONTRACT No. 25ECS-MI-03HA							
		NO. DATE REVISIONS				INITIAL SIGNED						SCALE: 1:10 DRAWING NUMBER: 2F-2017-08-54		E132					
												DATE: 2024-09-30							


Drawing: J:\M16-0273 TOR_HARRIS\WP-STANDBYGENERATOR\500_CAD\401-CAD\1-SS OR BU\SHEET\6 ELEC\2F-2017-08-55-E133.DWG
Layout: 03/19/2025 12:36:33 PM
Date: 03/19/2025

★ ★ CIRCUIT BREAKER'S HANDLE OPERATING MECHANISM TO BE PADLOCKABLE IN THE 'OFF' POSITION.

NOTES:

- 'S' DENOTES SHUNT TRIP.
- ALL TAG NAMES SHOWN ON THE DRAWING HAVE A PREFIX OF "FHA-ELS" UNLESS OTHERWISE NOTED.
- REFER TO DWG E015 FOR CONTROL WIRING.
- ALL CONDUCTORS, EQUIPMENT, AND FIELD CONNECTIONS SHALL BE TAGGED AND IDENTIFIED AS PER CITY REQUIREMENTS.
- UNLESS OTHERWISE INDICATED, ALL CONDUCTORS ARE TO BE COPPER AND ALL POWER CABLES ARE TO BE TECK90.
- REFER TO DWG E134 FOR NEW PDP ELEVATION LAYOUT.
- AT EACH DISTRIBUTION POINT, CIRCUIT BREAKERS, FUSES AND SWITCHES SHALL BE MARKED, ADJACENT THERETO, IN A CONSPICUOUS AND LEGIBLE MANNER TO INDICATE CLEARLY WHICH INSTALLATION OR PORTION OF INSTALLATION THEY PROTECT OR CONTROL AND THE MAXIMUM RATING OF OVERCURRENT DEVICE THAT IS PERMITTED.
- ADD NEW TAGS TO EXISTING PANELS.
- PROVIDE 15A, 120V RECEPTACLE FOR PLUG-IN SUMP PUMP.

FEEDER AND CONDUIT SCHEDULE		
NUMBER	SIZE	RATING (A)
1	1-3C #12 AWG TECK90	20
2	1-3C #10 AWG TECK90	30
3	1-3C #8 AWG TECK90	50
4	1-4C #6 AWG + #8GND - 27C	65
5	1-4C #3 AWG + #8 GND - 35C	100
6	1-4C #2 AWG + #6 GND - 35C	115
7	1-3C #3/0 AWG TECK90	200
8	1-3C 350 MCM TECK90	310
9	1-3C 500 MCM TECK90	500

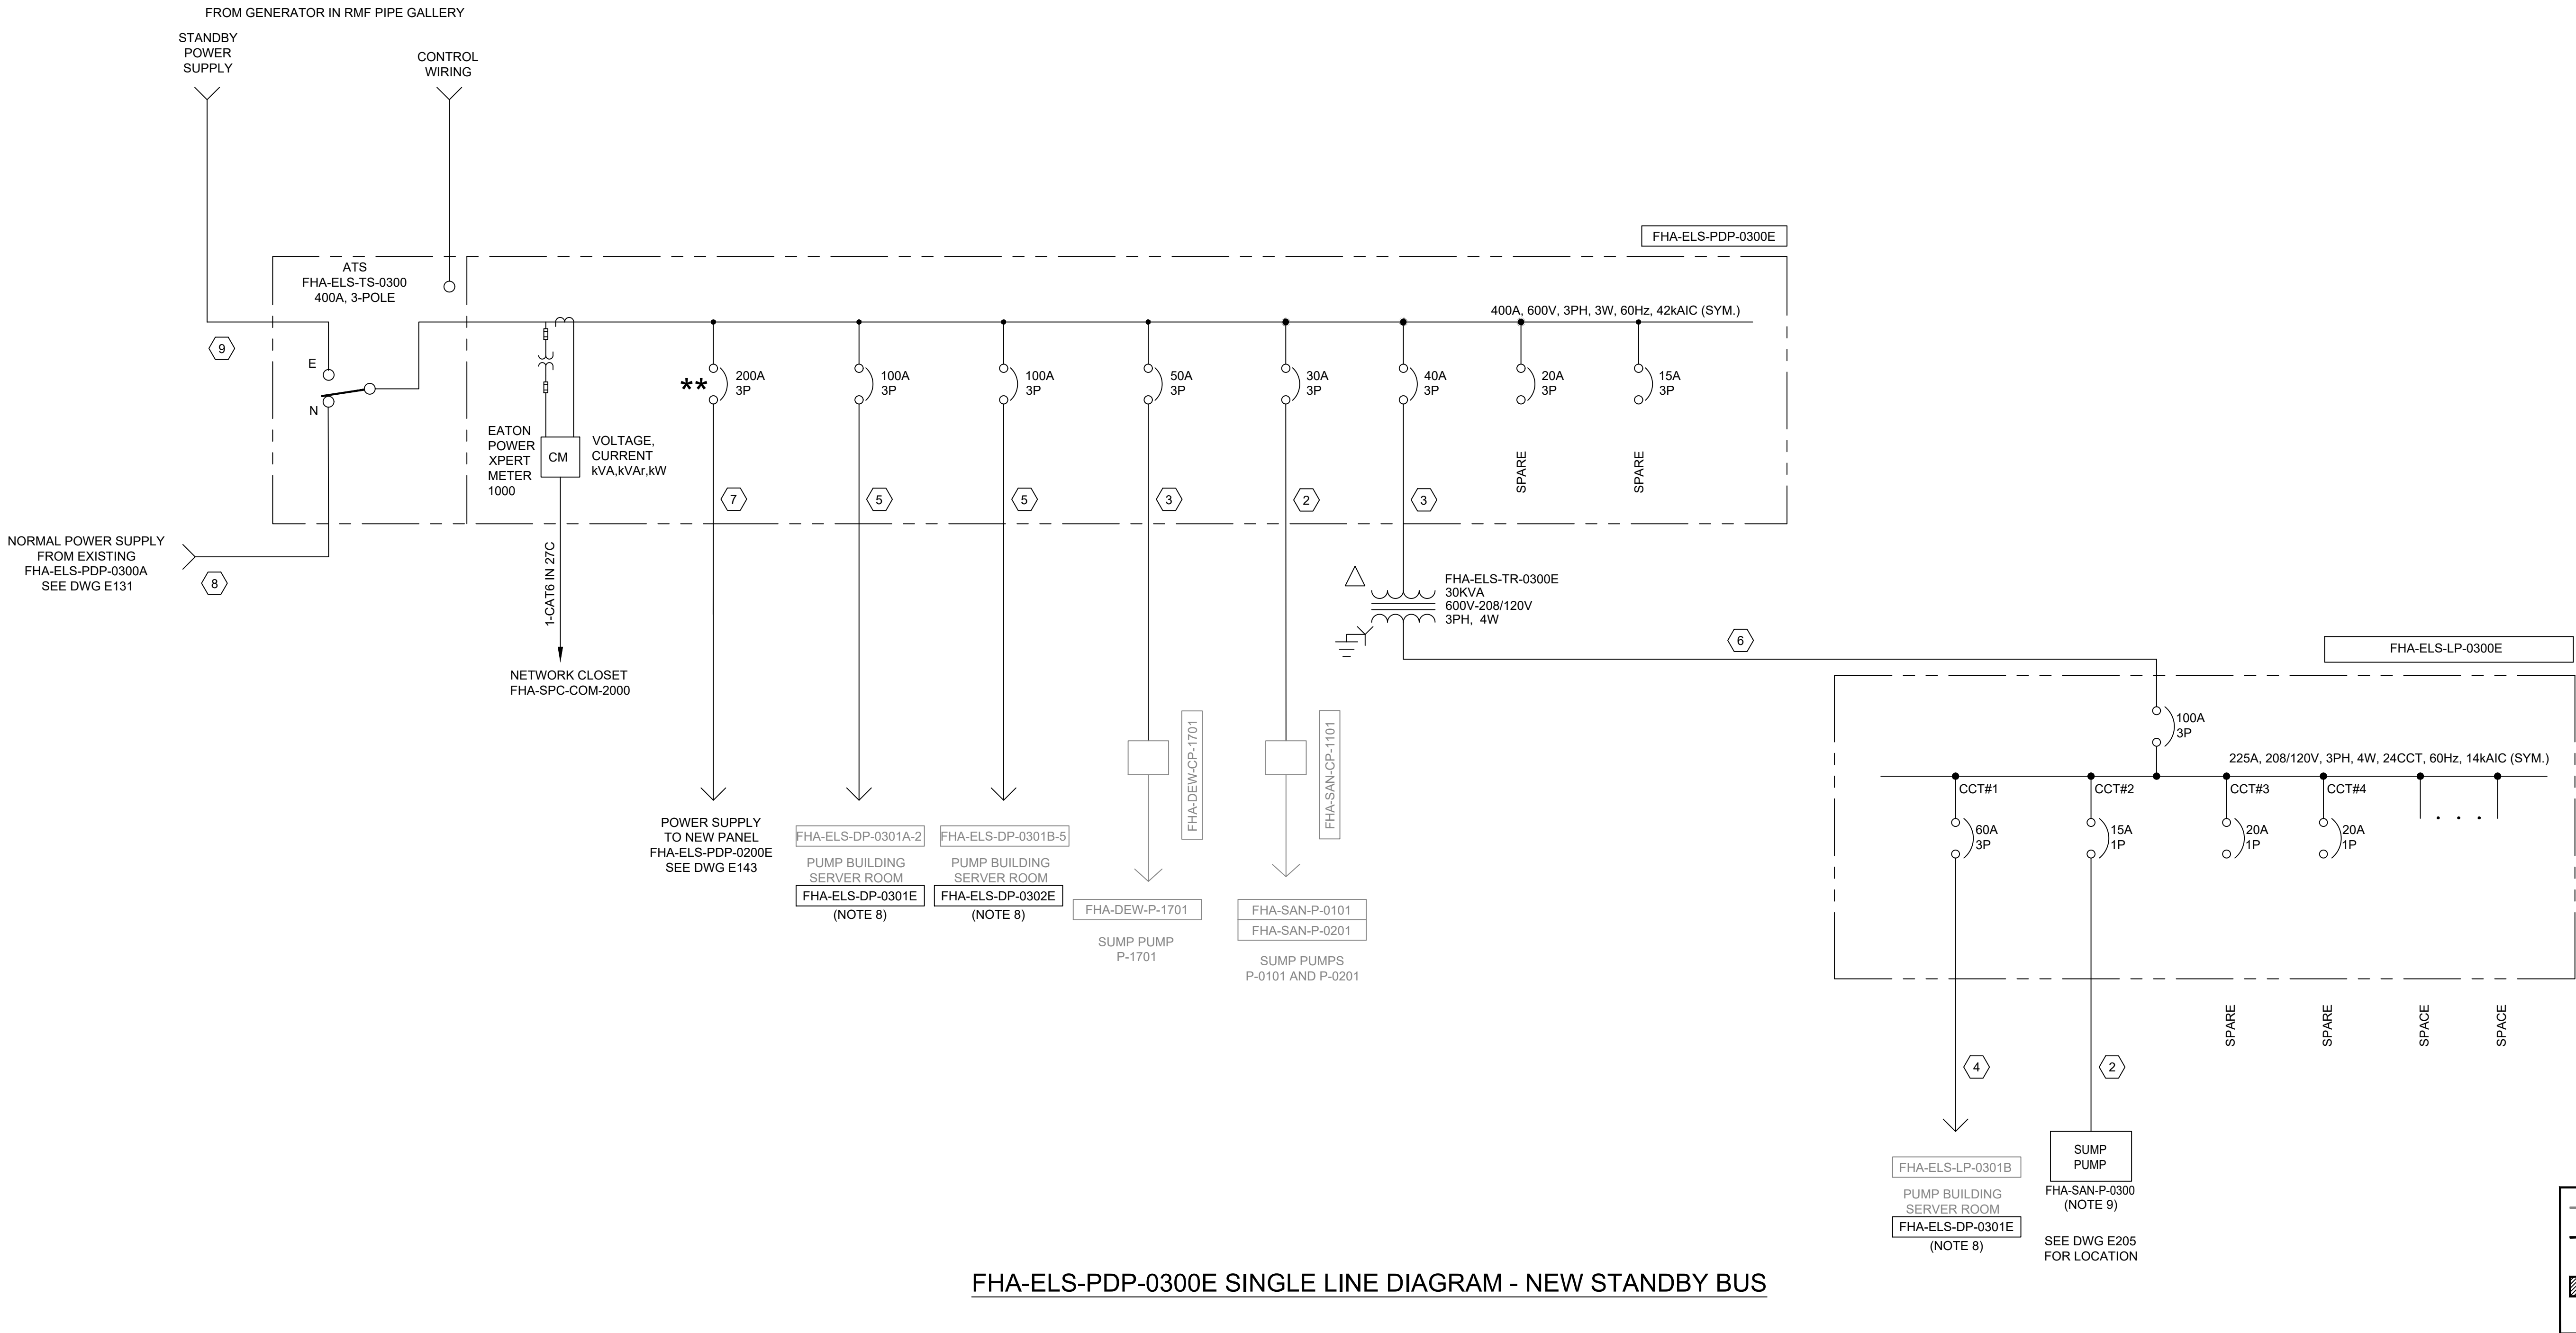


FHA-ELS-PDP-0300E SINGLE LINE DIAGRAM - NEW STANDBY BUS

—	EXISTING
—	NEW
■	REMOVAL, TO BE REPLACED WITH NEW CABLES & INSTALLED COMPLETE

								TORONTO WATER		ENGINEERING AND CONSTRUCTION SERVICES		R.C. HARRIS WATER TREATMENT PLANT INSTALLATION OF A STANDBY GENERATOR FOR CRITICAL LOADS FHA-ELS-PDP-0300E SINGLE LINE DIAGRAM - NEW STANDBY BUS			
								WILLIAM FERNANDES, P. ENG. DIRECTOR WATER TREATMENT AND SUPPLY		SIMON HOPTON, P. ENG. DIRECTOR DESIGN & CONSTRUCTION MAJOR INFRASTRUCTURE					
100-175 GALAXY BOULEVARD TORONTO, ONTARIO, M9W 0C9 TEL 416 679 1930 FAX 416 675 4620 www.arcadis.com		COPYRIGHT: This drawing has been prepared solely for the intended use. Any reproduction or distribution for any purpose other than authorized by ARCADIS is forbidden. Written dimensions shall have precedence over scaled dimensions. Contractors shall verify and be responsible for all dimensions and conditions on the job, and ARCADIS shall be informed of any variations from the dimensions and conditions shown on the drawing. Shop drawings shall be submitted to the Group for general conformance before proceeding with fabrication.		A		2025-03-18		ISSUED FOR TENDER		T.S.		ELECTRICAL			
ARCADIS Professional Services (Canada) Inc.		NO.		DATE		REVISIONS		INITIAL		SIGNED		DESIGN:		SC	
												DRAFTING:		SC	
												CHECK:		TS	
												CONTRACT No.		25ECS-MI-03HA	
												SCALE:		N.T.S.	
												DRAWING NUMBER:		2F-2017-08-55	
												DATE:		2024-09-30	
														E133	

Drawing: J:\M16-0273 TOR_HARRIS\WP-STANDBYGENERATOR\500_CAD\401-CAD\1-SS OR BU\SHEET\6 ELEC\2F-2017-08-57-E135.DWG
Layout: 03/19/2025 12:35 PM
Date: 03/19/2025 Time: 12:36:56 PM

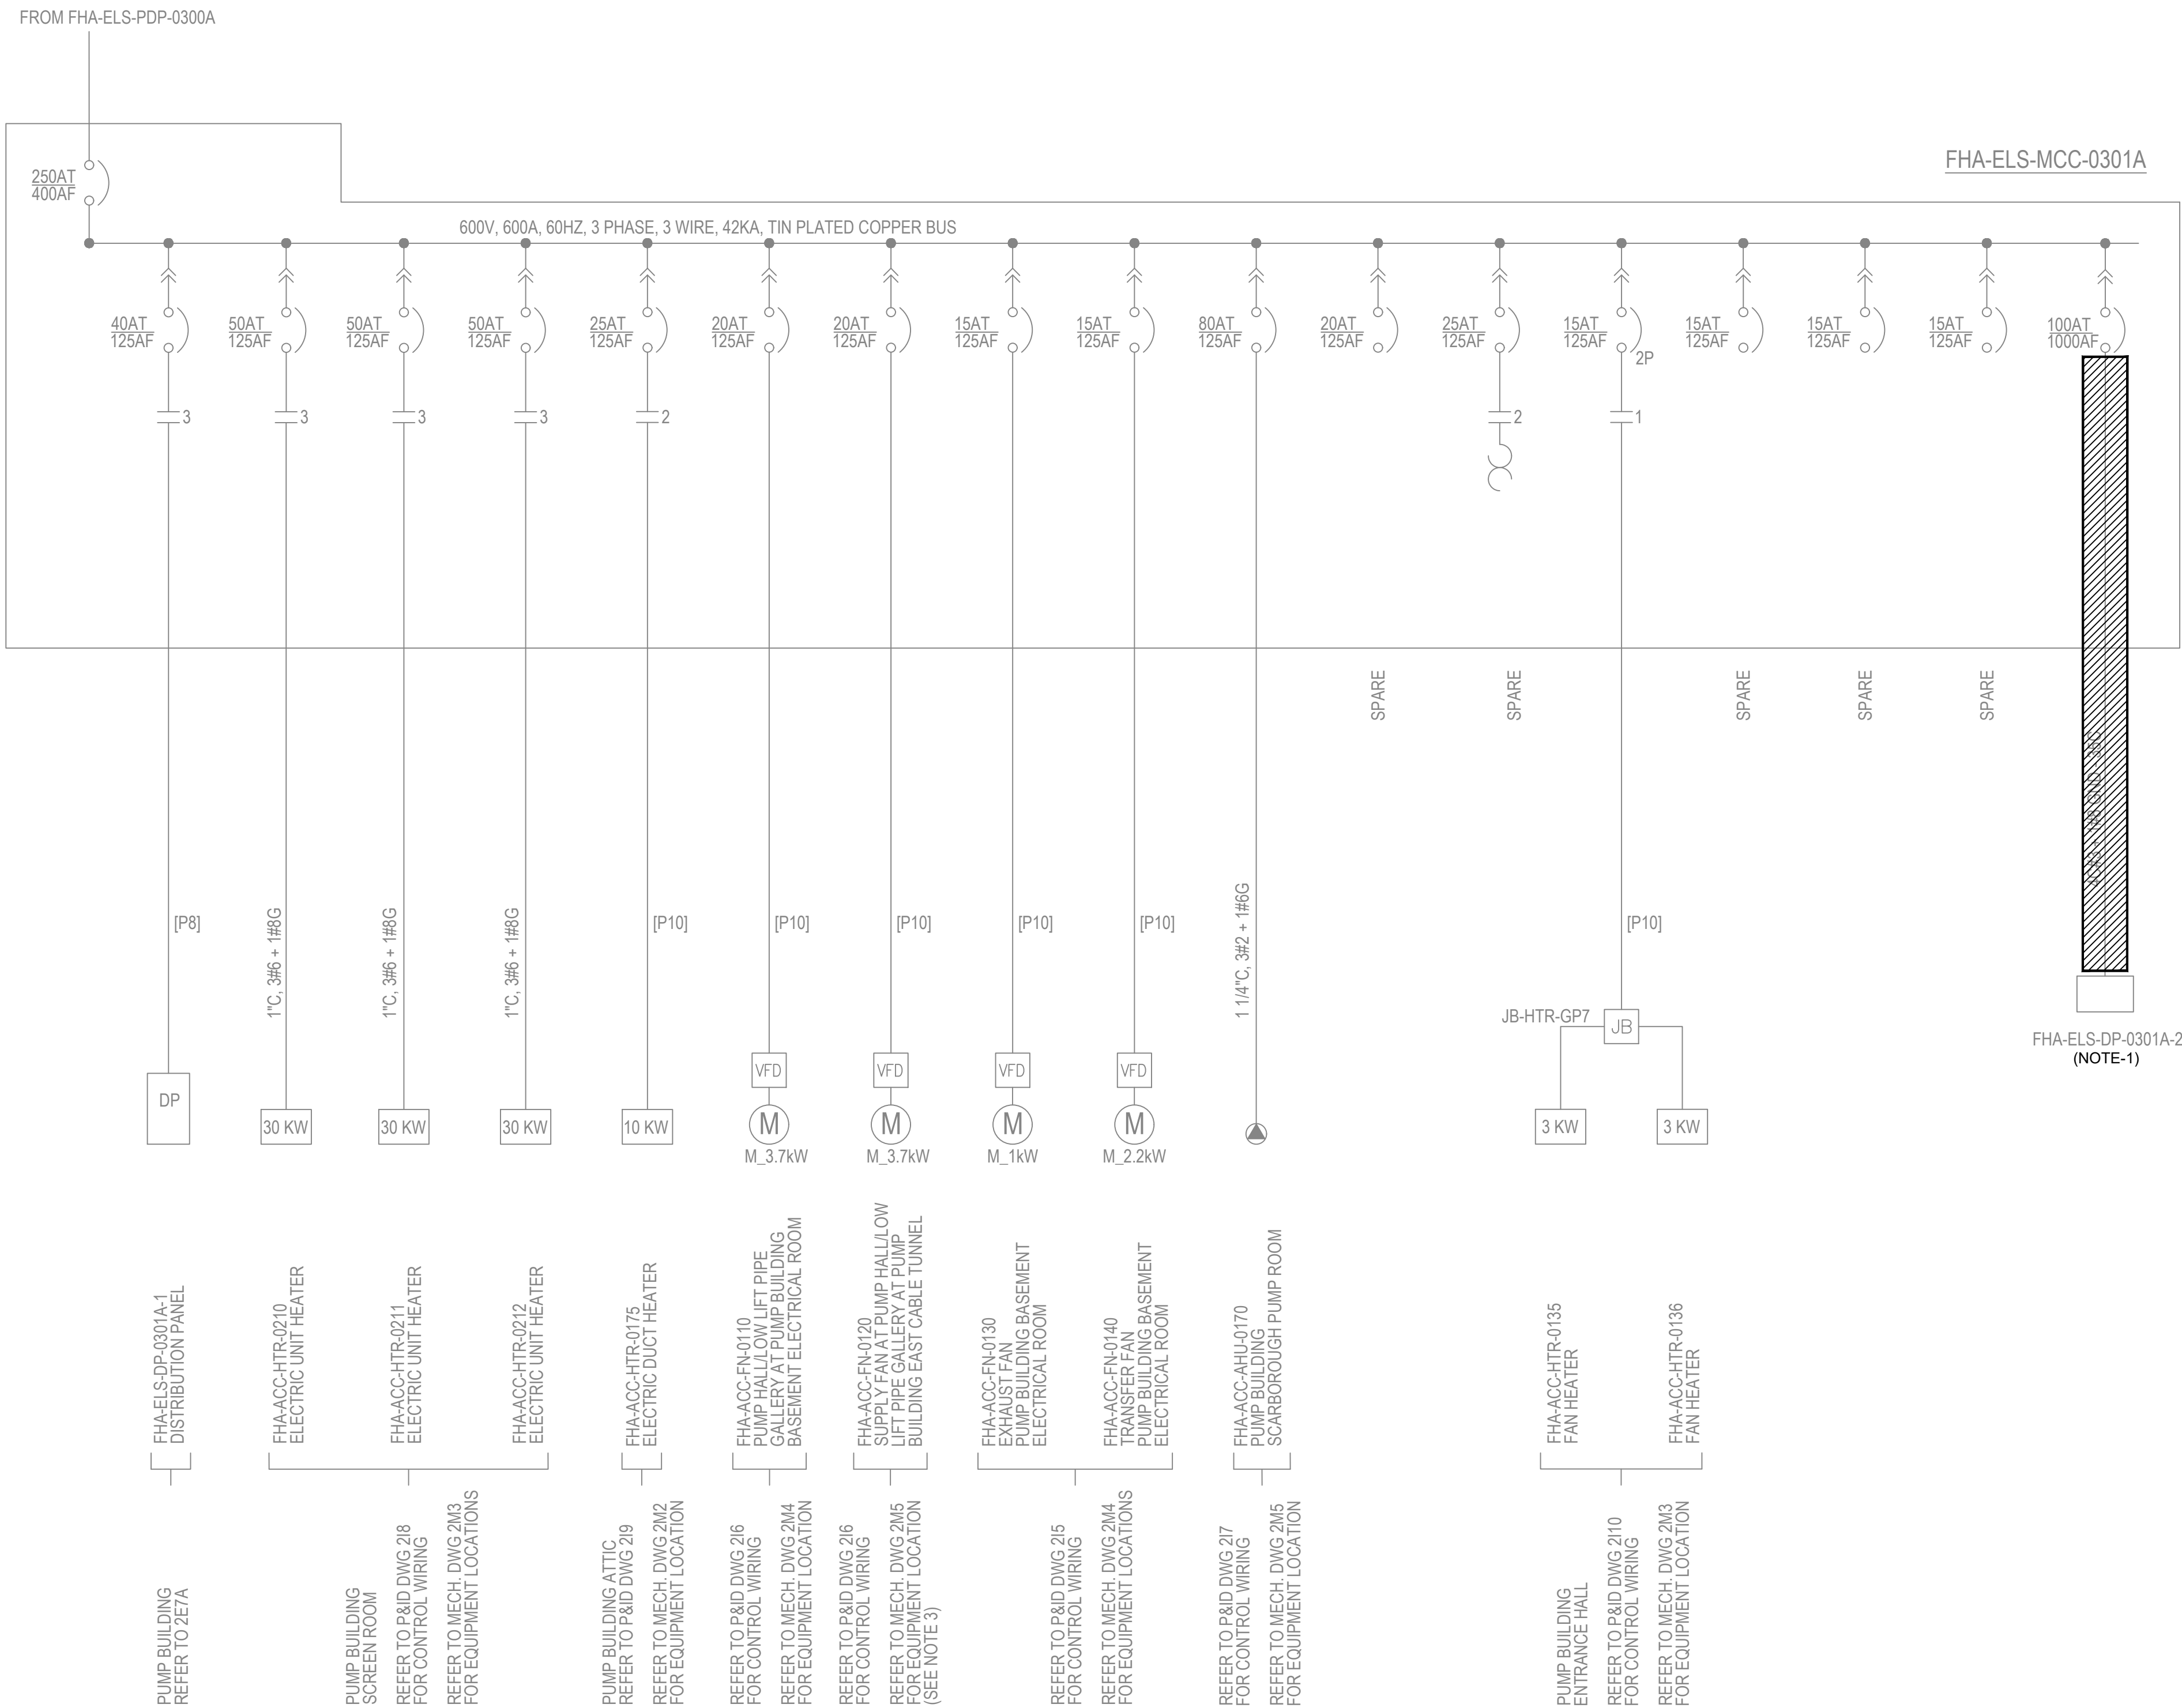

- NOTES:
1. REFEEED FROM FHA-ELS-PDP-03000E. SEE DRAWING E133.

FHA-ELS-MCC-0301A SINGLE LINE DIAGRAM

	EXISTING
	NEW
	REMOVAL, TO BE REPLACED WITH NEW CABLES & INSTALLED COMPLETE

--	--	


EXISTING

 NEW

 REMOVAL, TO BE REPLACED WITH NEW CABLES & INSTALLED COMPLETE

FHA-ELS-MCC-0301B SINGLE LINE DIAGRAM - EXISTING




COPYRIGHT:

This drawing has been prepared solely for the intended use, thus any reproduction or distribution for any purpose other than authorized by ARCADIS is forbidden. Written dimensions shall have precedence over scaled dimensions. Contractors shall verify and be responsible for all dimensions and conditions on the job, and ARCADIS shall be informed of any variations from the dimensions and conditions shown on the drawing. Shop drawings shall be submitted to IBI Group for general conformance before proceeding with fabrication.

ARCADIS Professional Services (Canada) Inc.

A	2025-03-18	ISSUED FOR TENDER	T.S.
NO.	DATE	REVISIONS	INITIAL SIGNED

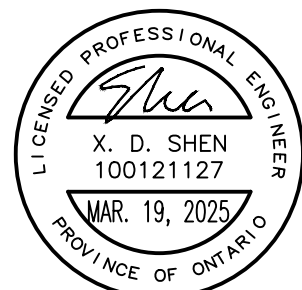

TORONTO WATER
ENGINEERING AND CONSTRUCTION SERVICES


WILLIAM FERNANDES, P.ENG
DIRECTOR
WATER TREATMENT AND SUPPLY

SIMON HOPTON, P. ENG.
DIRECTOR
DESIGN & CONSTRUCTION
MAJOR INFRASTRUCTURE


R.C. HARRIS WATER TREATMENT PLANT
INSTALLATION OF A STANDBY GENERATOR FOR CRITICAL LOADS
FHA-ELS-MCC-0301B SINGLE LINE DIAGRAM - EXISTING


ELECTRICAL

DESIGN:	SC	DRAFTING:	SC	CHECK:	TS	CONTRACT No.	25ECS-MI-03HA
SCALE:	N.T.S.			DRAWING NUMBER:	2F-2017-08-58		E136
DATE:	2024-09-30						

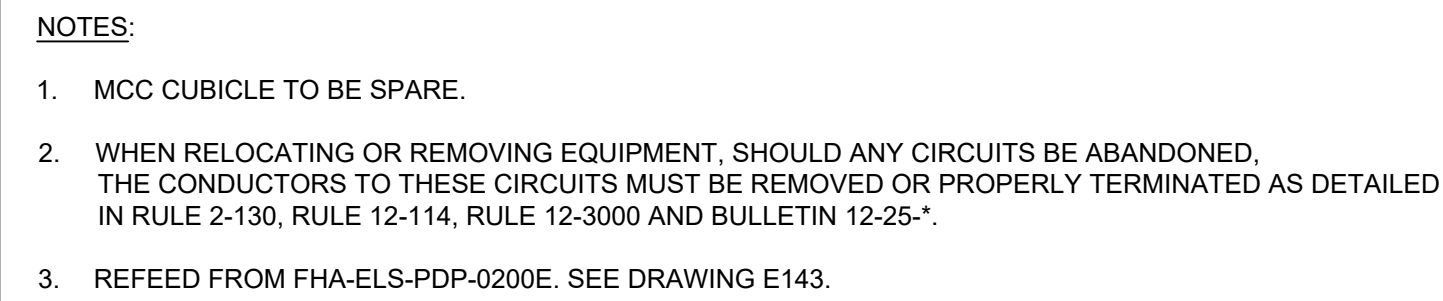


**** CIRCUIT BREAKER's HANDLE OPERATING MECHANISM TO BE PADLOCKABLE IN THE 'OFF' POSITION.**

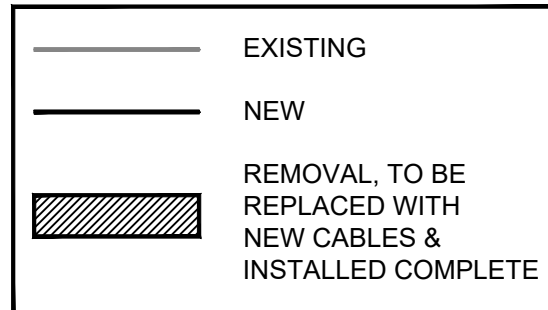

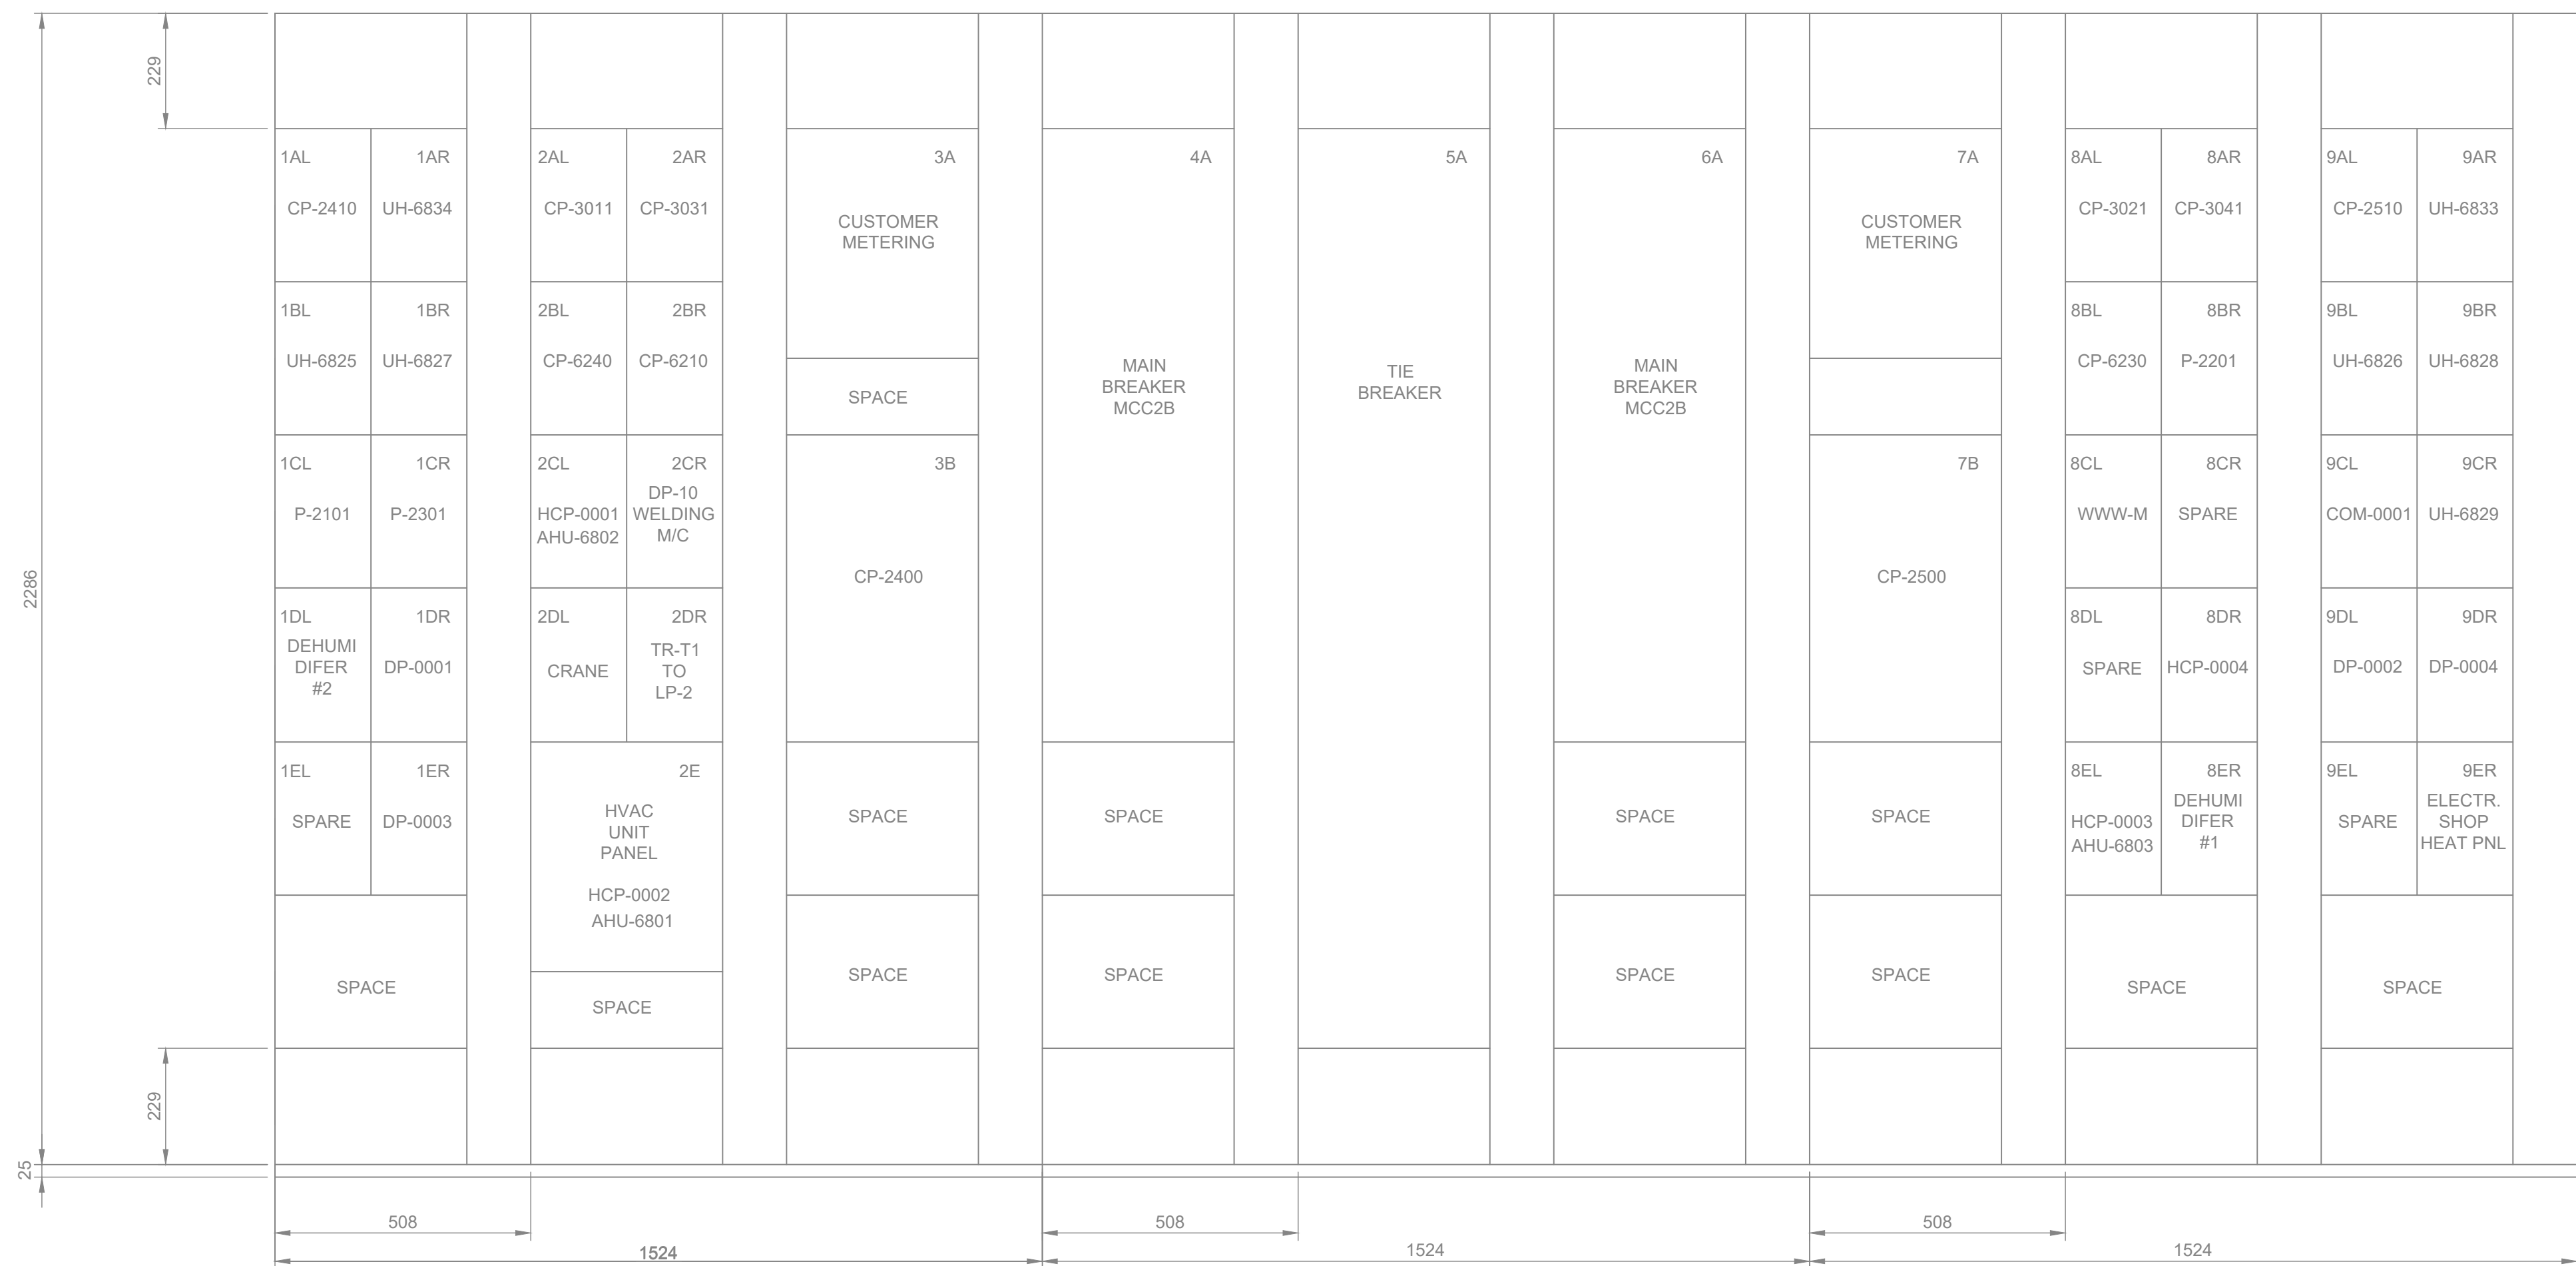

EXISTING

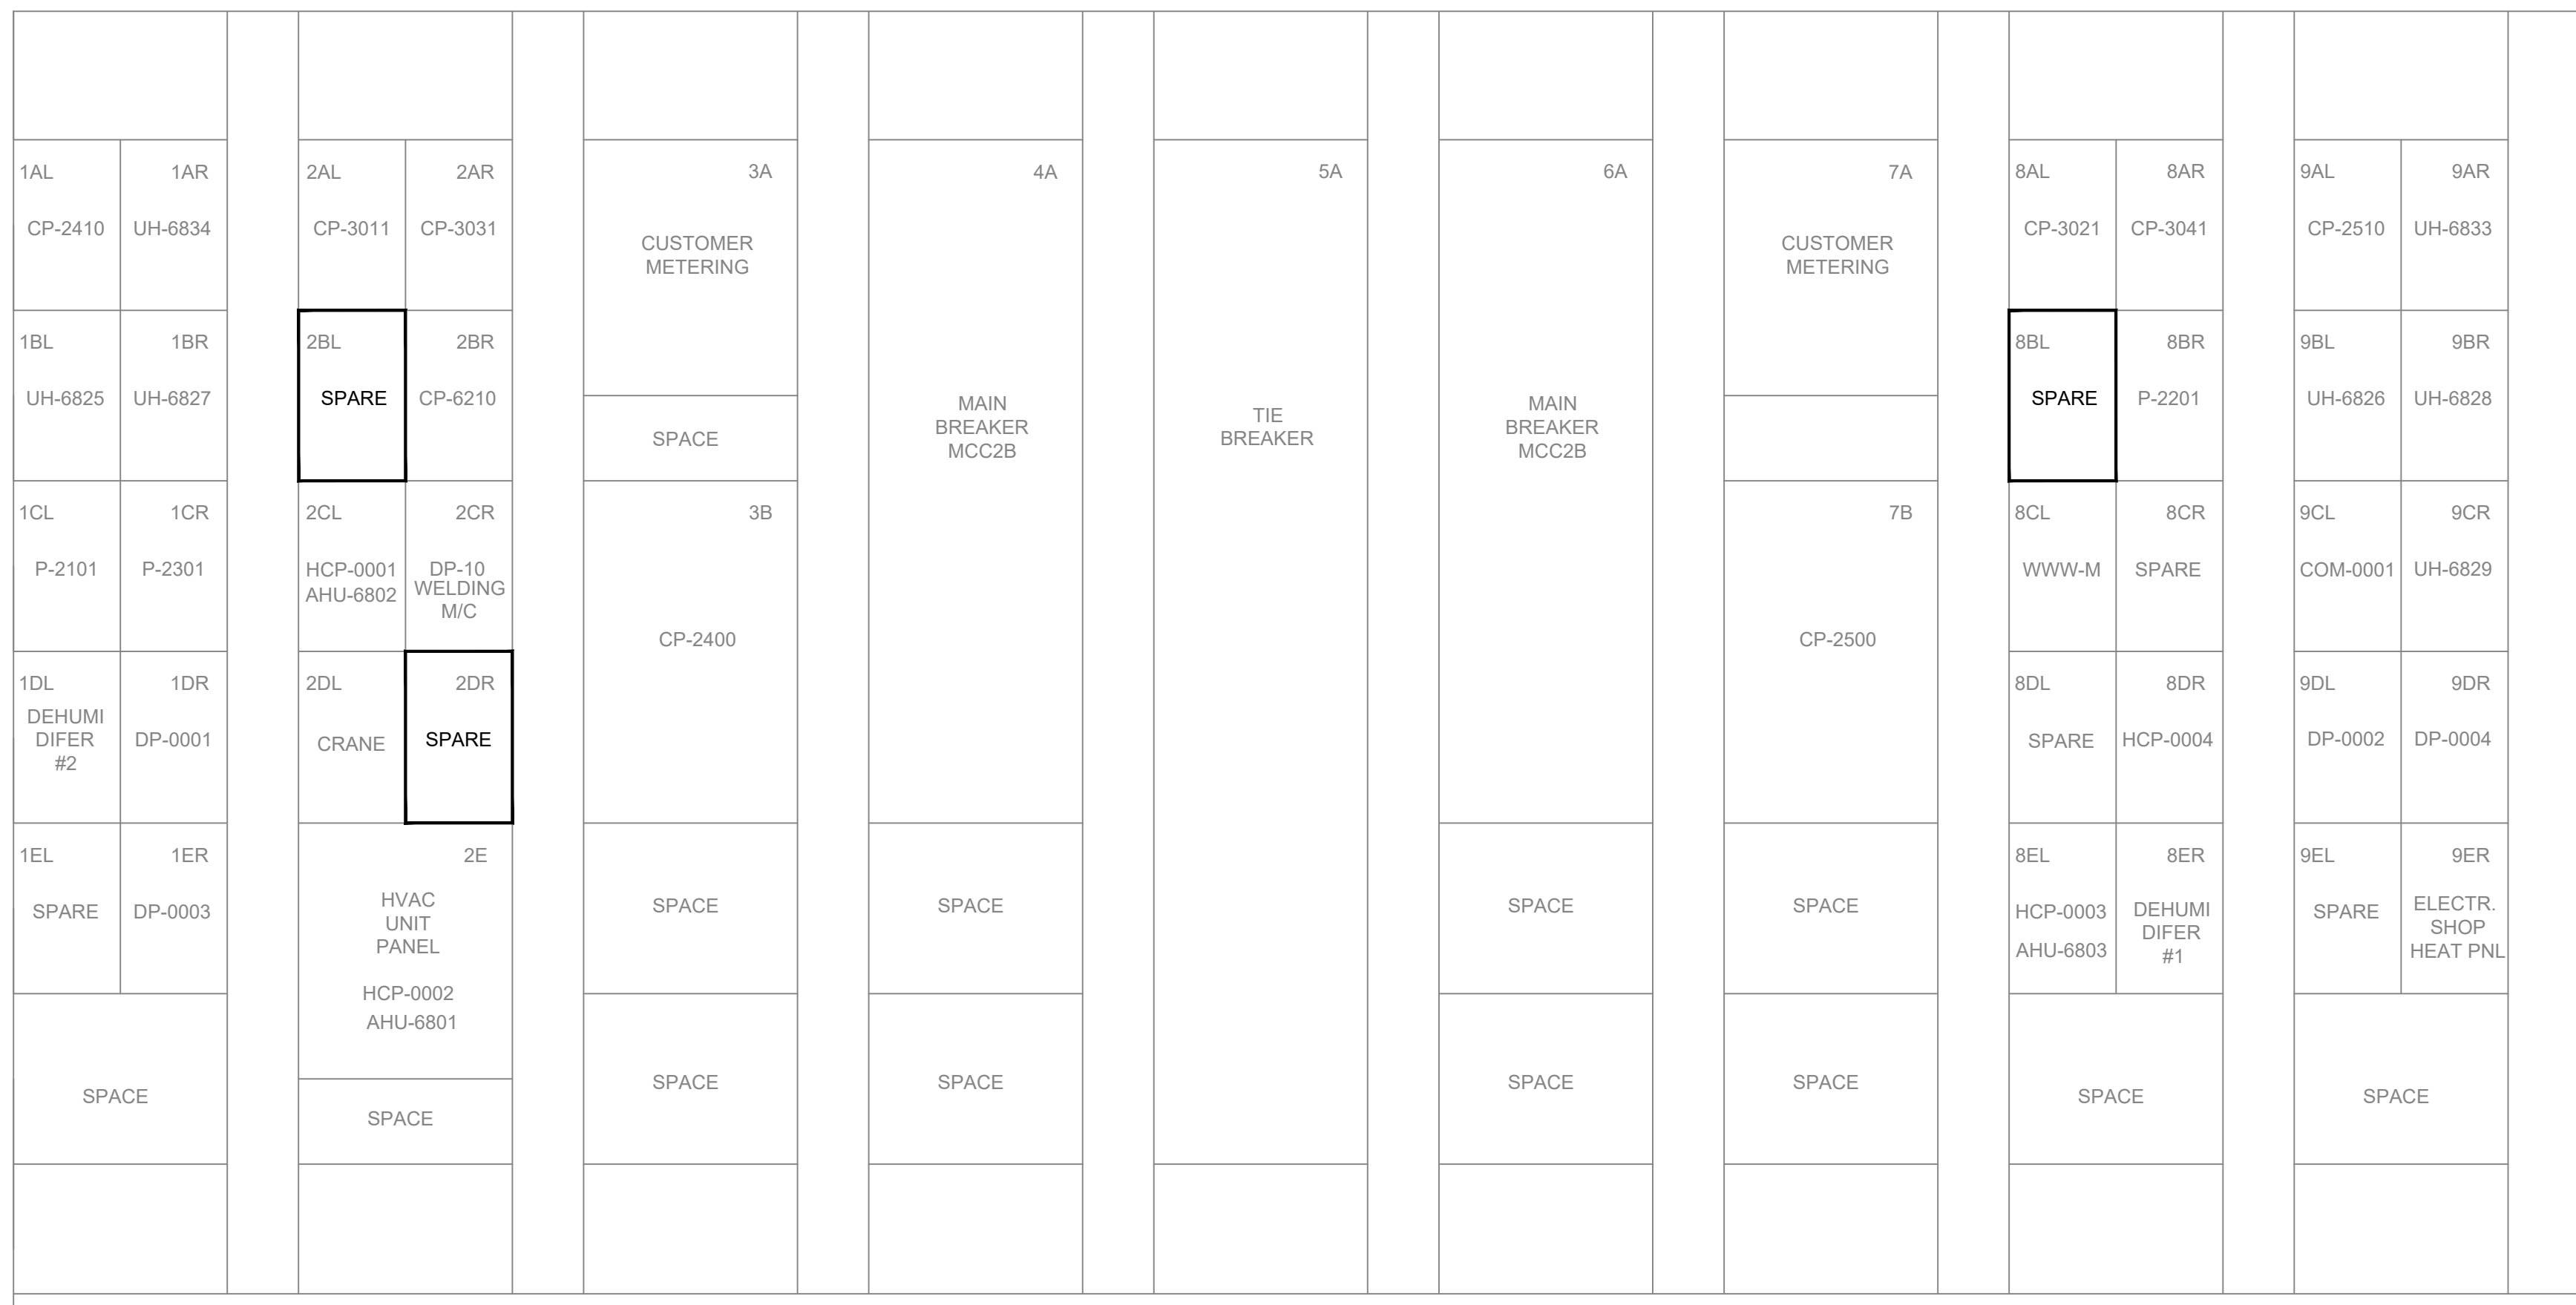

MODIFICATIONS

ELECTRICAL CHARACTERISTICS:


600 V	MAIN BUS: 1200A
3 PH	SCCR: 35kAIC (SYM RMS.)
3 WIRE	BUS BRACING: 42kAIC (SYM RMS.)
60 Hz	ENCLOSURE TYPE: EEMAC 1A

NOTES:

1. REFER TO DWG E207 FOR LOCATION DETAILS.
2. EXISTING CIRCUIT BREAKER TO BE SET TO 100A TRIP.
3. ALL TAG NAMES SHOWN ON THE DRAWINGS HAVE A PREFIX OF "FHA-WWWW-". ALL CONDUCTORS, EQUIPMENT, AND FIELD CONNECTIONS SHALL BE TAGGED AND IDENTIFIED AS PER CITY REQUIREMENTS.
4. DIMENSIONS ARE SHOWN IN MILLIMETERS UNLESS OTHERWISE NOTED.


FHA-ELS-MCC-0200A/B ELEVATION LAYOUT - EXISTING AND MODIFICATIONS

SCALE: 1:10

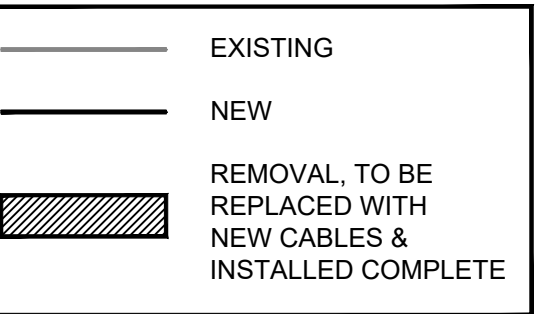

							TORONTO WATER ENGINEERING AND CONSTRUCTION SERVICES WILLIAM FERNANDES, P. ENG. DIRECTOR WATER TREATMENT AND SUPPLY SIMON HOPTON, P. ENG. DIRECTOR DESIGN & CONSTRUCTION MAJOR INFRASTRUCTURE								R.C. HARRIS WATER TREATMENT PLANT INSTALLATION OF A STANDBY GENERATOR FOR CRITICAL LOADS FHA-ELS-MCC-0200A/B ELEVATION LAYOUT - EXISTING AND MODIFICATIONS									
 100-175 GALAXY BOULEVARD TORONTO, ONTARIO, M9W 0C9 TEL 416 679 1930 FAX 416 675 4620 www.arcadis.com COPYRIGHT: This drawing has been prepared solely for the intended use, thus any reproduction or adaptation for any purpose other than authorized by ARCADIS is forbidden. Written dimensions shall have precedence over scaled dimensions. Contractors shall verify and be responsible for all dimensions and conditions on the job, and ARCADIS shall be informed of any variations from the dimensions and conditions shown on the drawing. Shop drawings shall be submitted to BCI Group for general conformance before proceeding with fabrication. ISSUED FOR TENDER REVISIONS INITIAL SIGNED							ELECTRICAL																	
							DESIGN:		SC		DRAFTING:		SC		CHECK:		TS		CONTRACT NO. 25ECS-MI-03HA					
							SCALE:		1:10										DRAWING NUMBER:		2F-2017-08-60		E142	
							DATE:		2024-09-30															

FEEDER AND CONDUIT SCHEDULE		
NUMBER	SIZE	RATING (A)
1	1-3C #10 AWG TECK90	35
2	1-3C #6 AWG TECK90	65

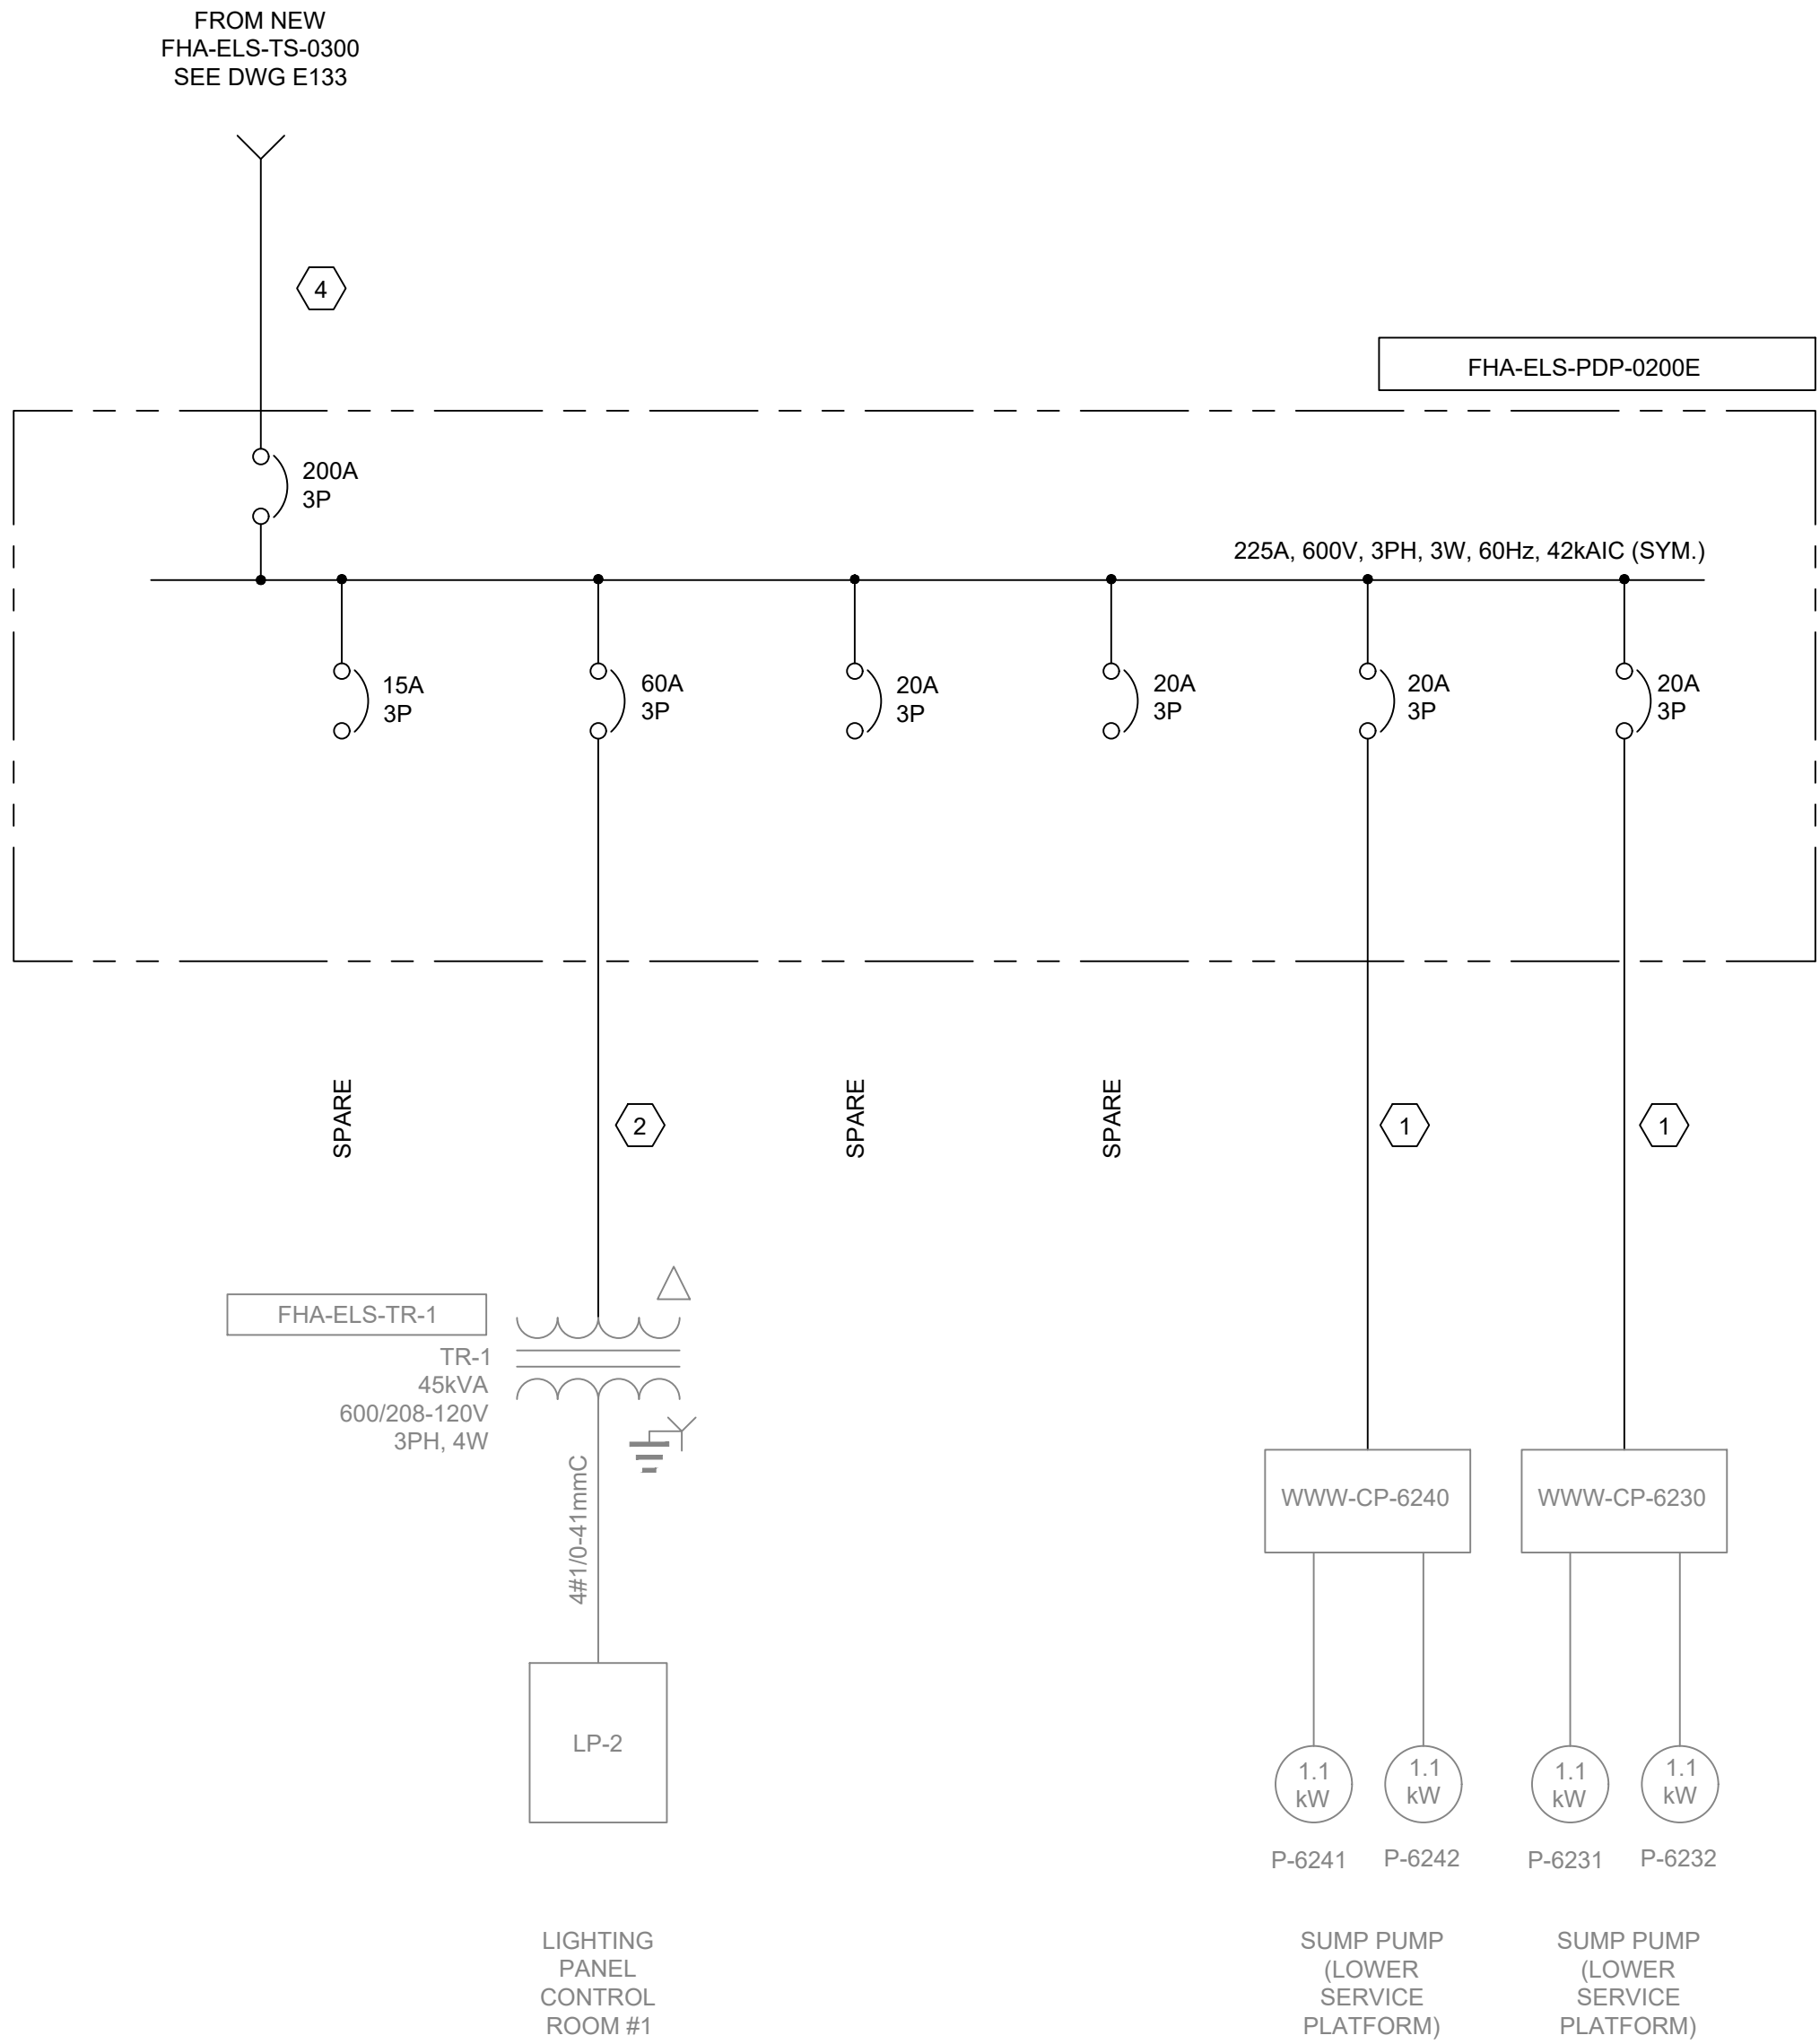


NOTES:

- ALL TAG NAMES SHOWN ON THE DRAWINGS HAVE A PREFIX OF "FHA". ALL CONDUCTORS, EQUIPMENT, AND FIELD CONNECTIONS SHALL BE TAGGED AND IDENTIFIED AS PER CITY REQUIREMENTS.
- REFER TO DWG E015 FOR CONTROL WIRING.
- ALL CONDUCTORS, EQUIPMENT, AND FIELD CONNECTIONS SHALL BE TAGGED AND IDENTIFIED AS PER CITY REQUIREMENTS.
- UNLESS OTHERWISE INDICATED, ALL CONDUCTORS ARE TO BE COPPER AND ALL POWER CABLES ARE TO BE TECK90.
- REFER TO DWGs E207 AND E208 FOR LOCATION DETAILS.
- REFER TO DWG E144 FOR NEW STANDBY PDP ELEVATION LAYOUT.
- AT EACH DISTRIBUTION POINT, CIRCUIT BREAKERS, FUSES AND SWITCHES SHALL BE MARKED, ADJACENT THERETO, IN A CONSPICUOUS AND LEGIBLE MANNER TO INDICATE CLEARLY WHICH INSTALLATION OR PORTION OF INSTALLATION THEY PROTECT OR CONTROL AND THE MAXIMUM RATING OF OVERCURRENT DEVICE THAT IS PERMITTED.

FHA-ELS-PDP-0200E SINGLE LINE DIAGRAM - NEW STANDBY BUS
N.T.S

—	EXISTING
—	NEW
	REMOVAL, TO BE REPLACED WITH NEW CABLES & INSTALLED COMPLETE


										TORONTO WATER		R.C. HARRIS WATER TREATMENT PLANT INSTALLATION OF A STANDBY GENERATOR FOR CRITICAL LOADS FHA-ELS-PDP-0200E SINGLE LINE DIAGRAM - NEW STANDBY BUS							
										ENGINEERING AND CONSTRUCTION SERVICES									
												WILLIAM FERNANDES, P. ENG. DIRECTOR WATER TREATMENT AND SUPPLY		SIMON HOPTON, P. ENG. DIRECTOR DESIGN & CONSTRUCTION MAJOR INFRASTRUCTURE					
 100-175 GALAXY BOULEVARD TORONTO, ONTARIO, M9W 0C9 TEL 416 679 1930 FAX 416 675 4620 www.arcadis.com		COPYRIGHT: This drawing has been prepared solely for the intended use, thus any reproduction or distribution for any purpose other than authorized by ARCADIS is forbidden. Written dimensions shall have precedence over scaled dimensions. Contractors shall verify and be responsible for all dimensions and conditions on the job, and ARCADIS shall be informed of any variations from the dimensions and conditions shown on the drawing. Shop drawings shall be submitted to full Group for general conformance before proceeding with fabrication.												ELECTRICAL					
		A 2025-03-18		ISSUED FOR TENDER		T.S.						DESIGN: SC		DRAFTING: SC		CHECK: TS		CONTRACT No. 25ECS-MI-03HA	
		NO.		DATE		REVISIONS		INITIAL		SIGNED		SCALE: N.T.S.		DRAWING NUMBER:		2F-2017-08-61		E143	
												DATE: 2024-09-30							

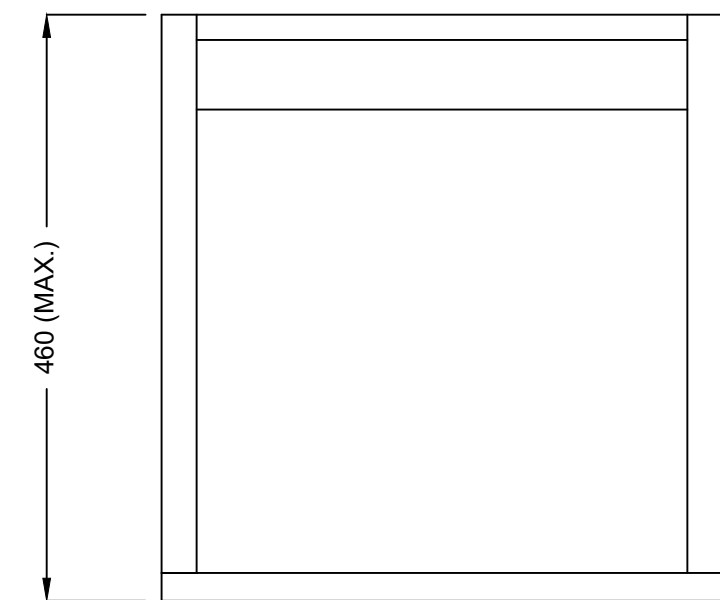

FLOOR VIEW OF PDP-0200E

N.T.S.

 -  EXISTING
 NEW
 REMOVAL, TO BE REPLACED WITH NEW CABLES & INSTALLED COMPLETE

				COPYRIGHT: This drawing has been prepared solely for the intended use, thus any reproduction or distribution for any purpose other than authorized by ARCADIS is forbidden. Written dimensions shall have precedence over scaled dimensions. Contractors shall verify and be responsible for all dimensions and conditions on the job, and ARCADIS shall be informed of any variations from the dimensions and conditions shown on the drawing. Shop drawings shall be submitted to IBI Group for general conformance before proceeding with fabrication.		A 2025-03-18 ISSUED FOR TENDER T.S.		NO. DATE REVISIONS INITIAL SIGNED		TORONTO WATER ENGINEERING AND CONSTRUCTION SERVICES				R.C. HARRIS WATER TREATMENT PLANT INSTALLATION OF A STANDBY GENERATOR FOR CRITICAL LOADS FHA-ELS-PDP-0200E ELEVATION LAYOUT - NEW			
														WILLIAM FERNANDES, P. ENG. DIRECTOR WATER TREATMENT AND SUPPLY		SIMON HOPTON, P. ENG. DIRECTOR DESIGN & CONSTRUCTION MAJOR INFRASTRUCTURE	

METRIC
MEASUREMENTS SHOWN ON THESE PLANS
ARE IN MILLIMETERS UNLESS OTHERWISE NOTED

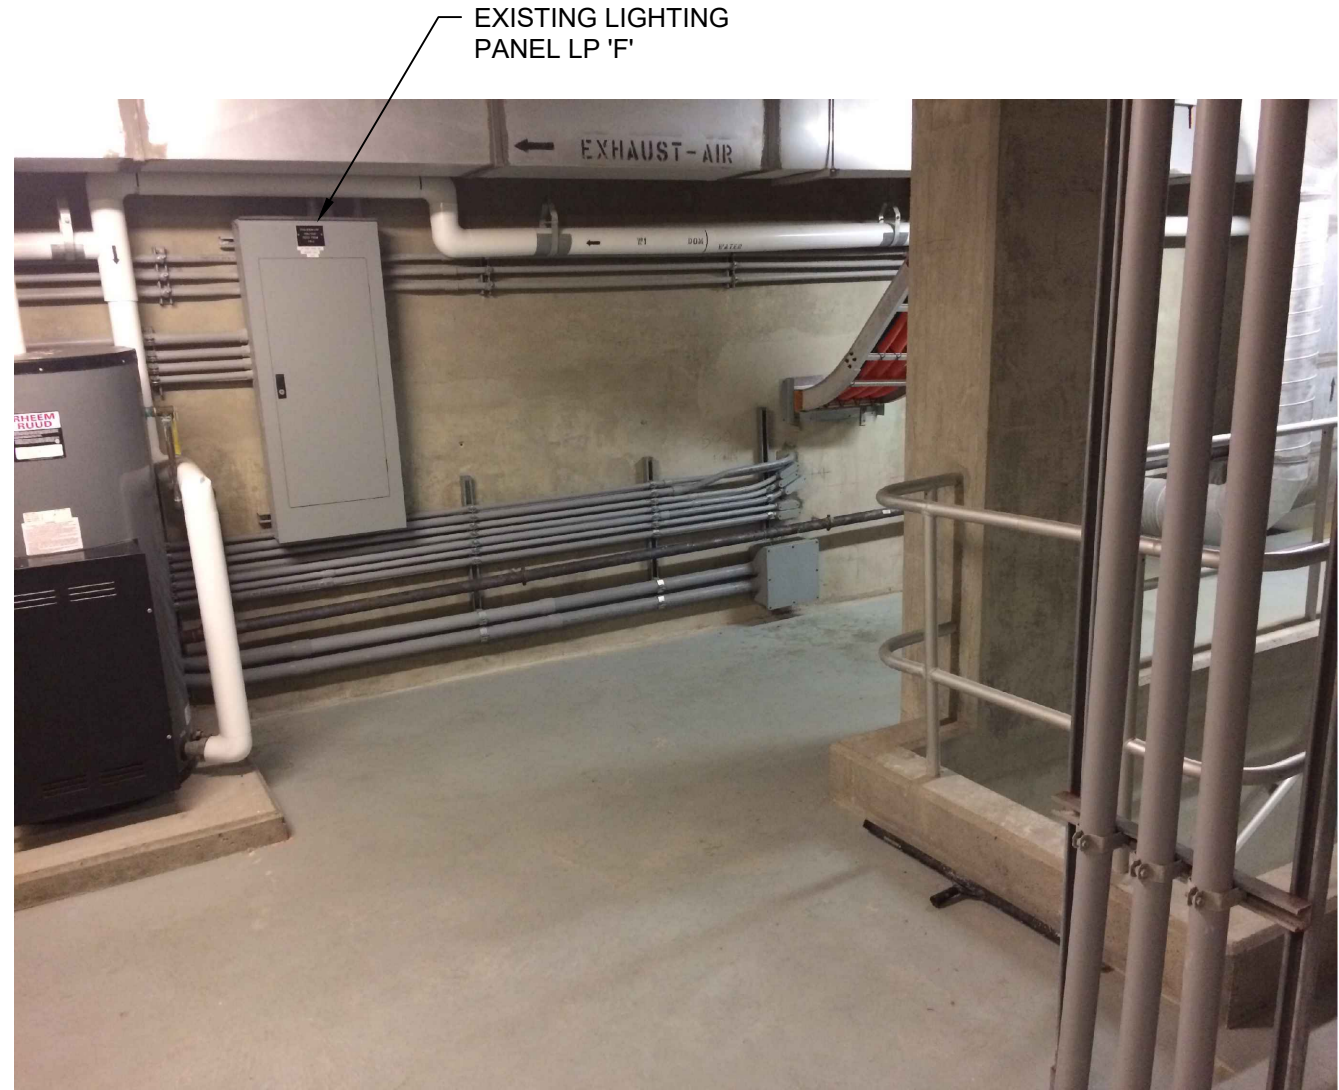


PHOTO 1



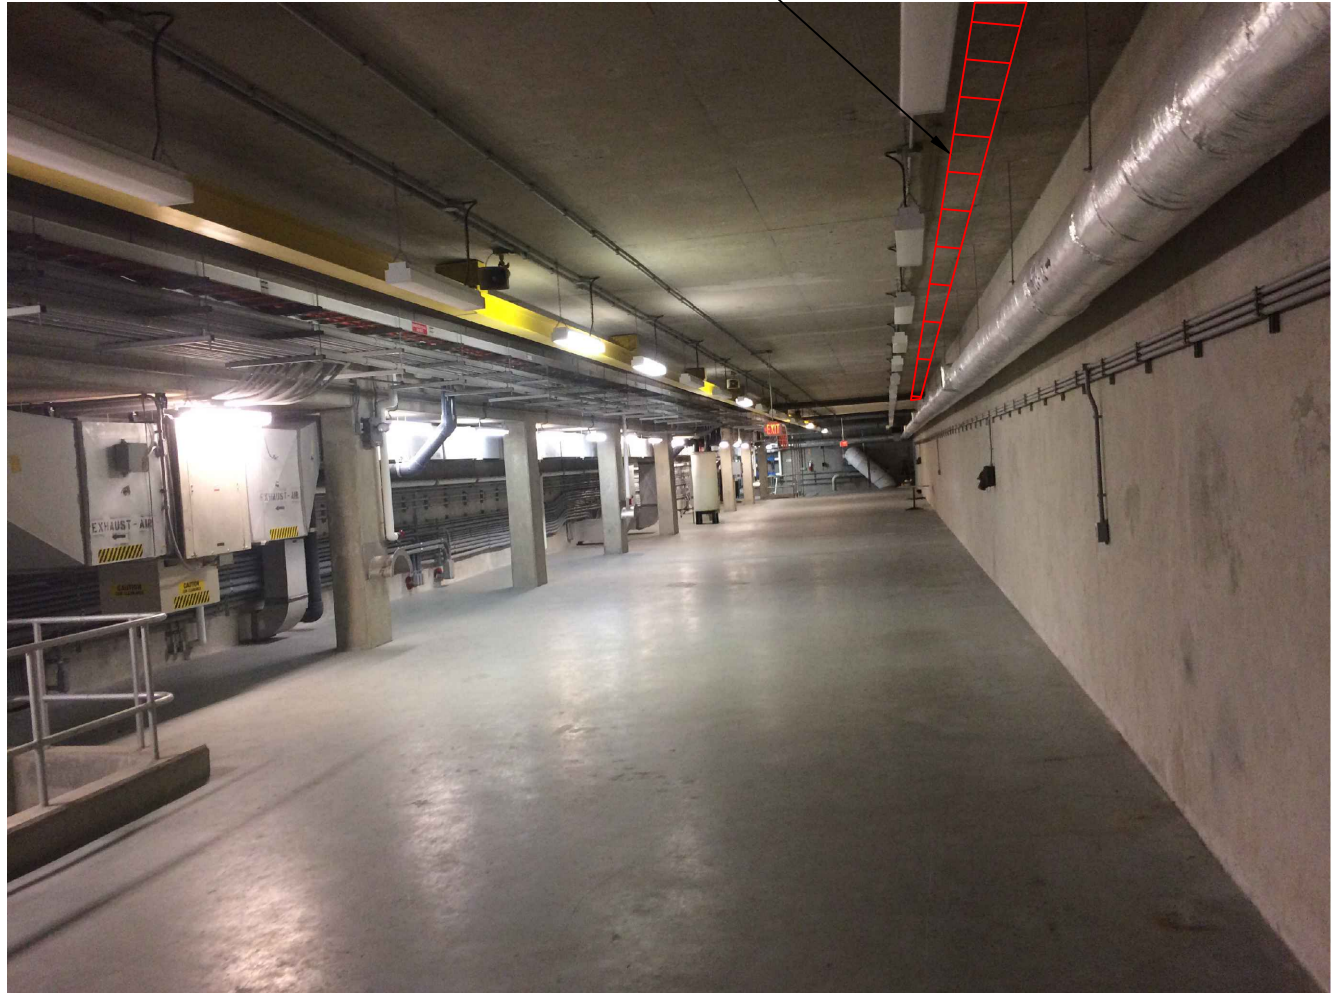


PHOTO 2

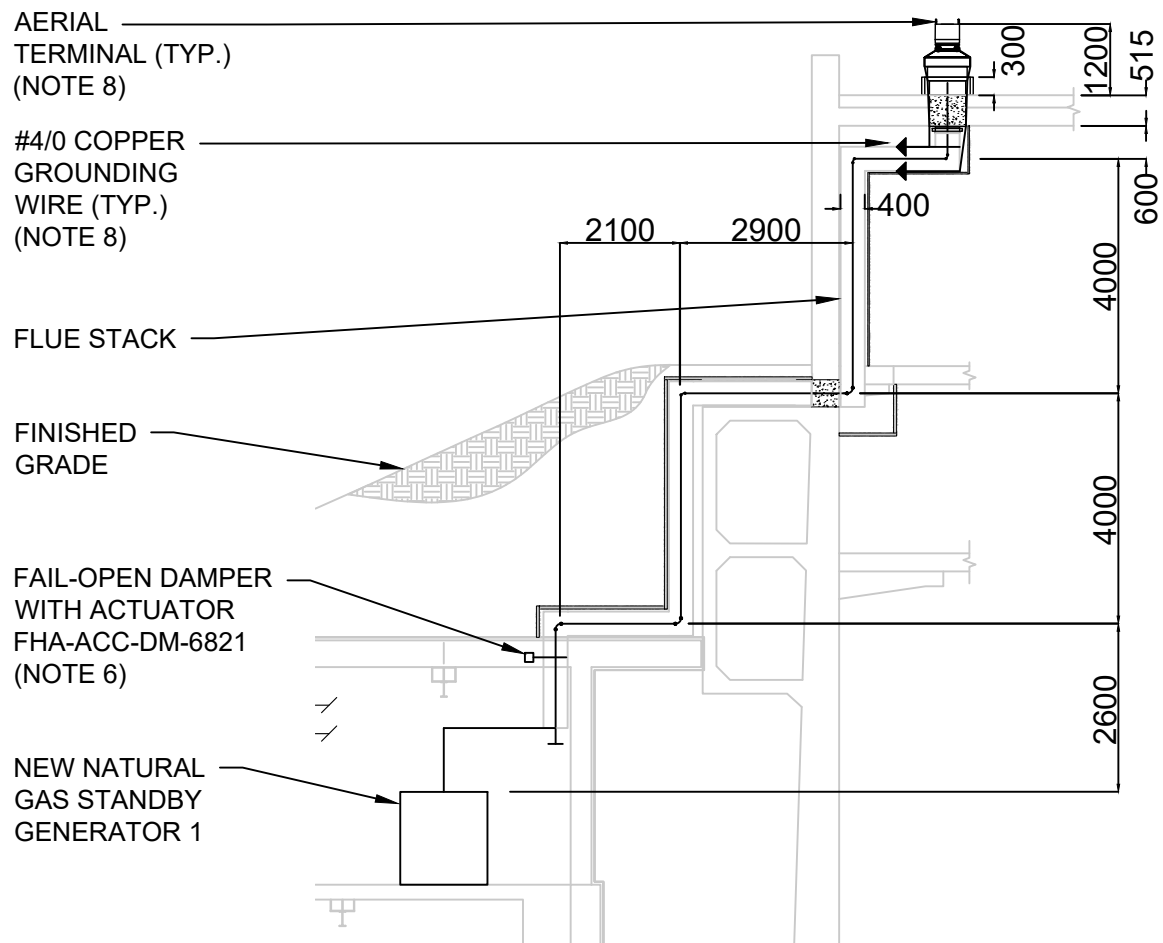

CABLE ROUTING TABLE				
#	FED FROM	TO	LOCATION	REFERENCE
G1	FHA-ELS-TS-0300	GENERATOR 1 FHA-ELS-GEN-0100	FROM PUMPING STATION TO RMF PIPE GALLERY	DWG E201, E205, E207, E209
G2	GENERATOR 1 FHA-ELS-GEN-0100	GENERATOR 1 LOAD CONNECTION BOX	FROM RMF PIPE GALLERY TO SODIUM BISULPHITE ROOM	DWG E201, E209

PIPE GALLERY & FILTER BUILDING ELEVATION -
CHIMNEY GROUNDING FOR NEW
NATURAL GAS STANDBY GENERATOR 1 -
FHA-ELS-GEN-0100

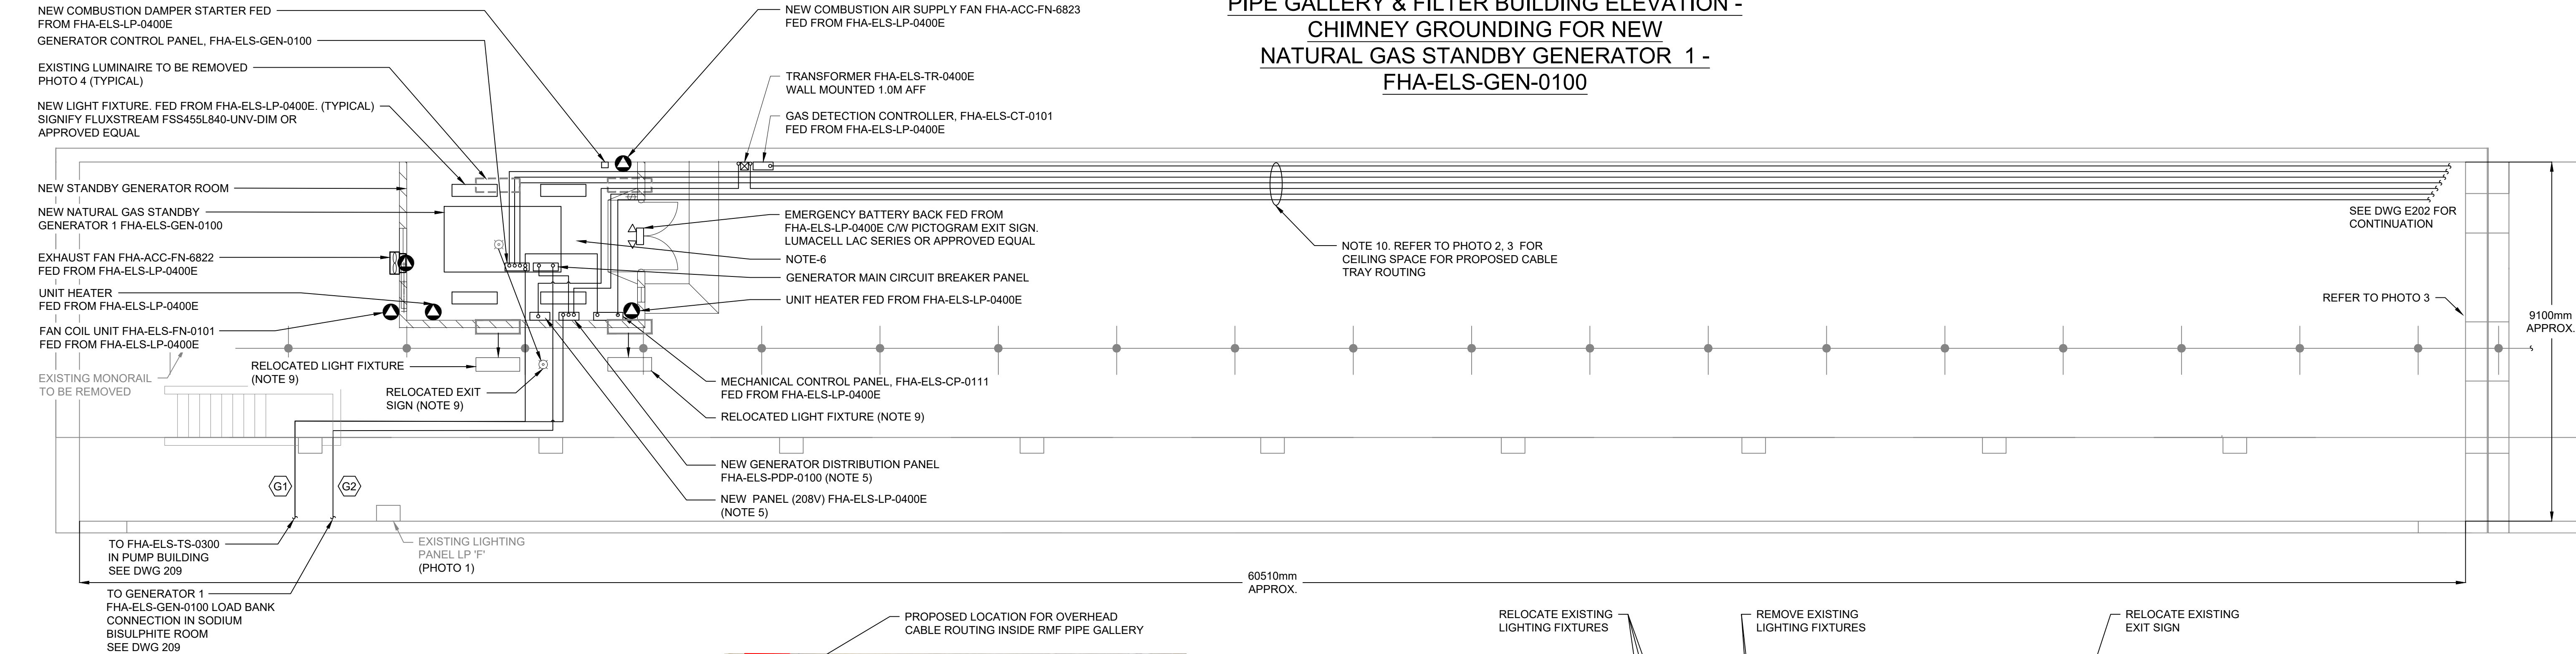

NOTES:

- THIS DRAWING SHOULD BE READ IN CONJUNCTION WITH THE STRUCTURAL AND MECHANICAL DRAWINGS.
- PROVIDE NEW AND COMPLETE OVERHEAD CABLE TRAY SYSTEM FOR ALL NEW POWER AND CONTROL CABLES/WIRING TO INTERCONNECT EQUIPMENT. USE OF EXISTING CABLE TRAYS WILL ONLY BE ACCEPTED IF SUFFICIENT SPACE IS AVAILABLE AND THE RESULTING FILL AREA DOES NOT EXCEED THE OESC CODE REQUIREMENTS.
- PROVIDE SEPARATE CABLE TRAYS OR ACCEPTABLE BARRIER FOR CONDUCTORS OF 600VAC POWER, ELECTRICAL LIGHTING, 120VAC CONTROL AND SIGNAL WIRING.
- UNLESS OTHERWISE INDICATED, ALL CONDUCTORS ARE TO BE COPPER AND ALL POWER CABLES ARE TO BE TECK90.
- NEW PANEL TO BE MOUNTED ON THE WALL INSIDE THE NEW ROOM FOR NEW STANDBY GENERATOR 1. SEE DRAWING E103 FOR CIRCUIT ASSIGNMENT.
- REFER TO MECHANICAL DRAWINGS FOR LOCATION OF ALL CONTROL AND MECHANICAL EQUIPMENT.
- REFER TO DWG E202 FOR LOCATION DETAILS OF EXISTING REMOTE PROCESSING UNIT FHA-SPC-RPU-2022.
- THE CHIMNEY SHALL BE ELECTRICALLY GROUNDED. CONTRACTOR TO PROVIDE TWO (2) AERIAL TERMINALS AT THE TOP OF THE CHIMNEY AND TWO (2) CONNECTING POINTS FOR #4/0 COPPER GROUNDING WIRES. GROUNDING WIRES (APPROX. 250m) TO BE EXTENDED TO THE GROUND BAR ON THE WALL LOCATED IN RMF MCC ROOM.
- RELOCATE EXISTING FIXTURE TO NEW LOCATION AS SHOWN. EXTEND CONDUIT AND WIRING AS REQUIRED.
- RUN TECK CABLES IN NEW CABLE TRAY. SUPPORT NEW CONTROL/SCADA CONDUITS BELOW THE CABLE TRAY. REFER TO DWG E015 FOR DETAILS.



PHOTO 3



PHOTO 4

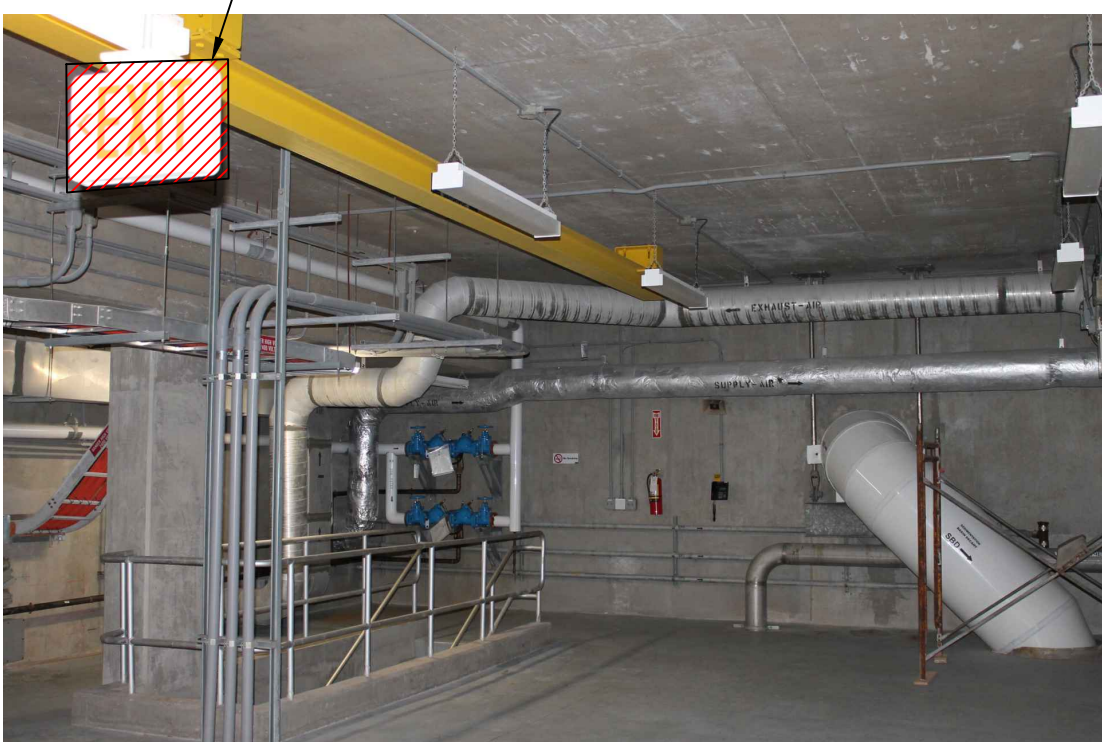


PHOTO 5

ELECTRICAL FLOOR PLAN - RMF PIPE GALLERY (EL. 88.00)
N.T.S.

				TORONTO WATER ENGINEERING AND CONSTRUCTION SERVICES		R.C. HARRIS WATER TREATMENT PLANT INSTALLATION OF A STANDBY GENERATOR FOR CRITICAL LOADS ELECTRICAL FLOOR PLAN - RMF PIPE GALLERY (EL. 88.00)								
				WILLIAM FERNANDES, P. ENG. DIRECTOR WATER TREATMENT AND SUPPLY	SIMON HOPTON, P. ENG. DIRECTOR DESIGN & CONSTRUCTION MAJOR INFRASTRUCTURE	ELECTRICAL								
COPYRIGHT: This drawing has been prepared solely for the intended use. No reproduction or distribution for any purpose other than authorized by ARCADIS is permitted. Written dimensions shall have precedence over scaled dimensions. Contractors shall verify and be responsible for all dimensions and conditions on the job, and ARCADIS shall be informed of any variations from the dimensions and conditions shown on the drawing. Shop drawings shall be submitted to the Group for general conformance before proceeding with fabrication.		A 2025-03-18		ISSUED FOR TENDER		DESIGN:	SC	DRAFTING:	SC	CHECK:	TS	CONTRACT No.	25ECS-MI-03HA	
ARCADIS Professional Services (Canada) Inc.		NO.		DATE		SCALE:	N.T.S.		DRAWING NUMBER:		2F-2017-08-63		E201	
						DATE:	2024-09-30							

METRIC
MEASUREMENTS SHOWN ON THESE PLANS
ARE IN MILLIMETERS UNLESS OTHERWISE NOTED

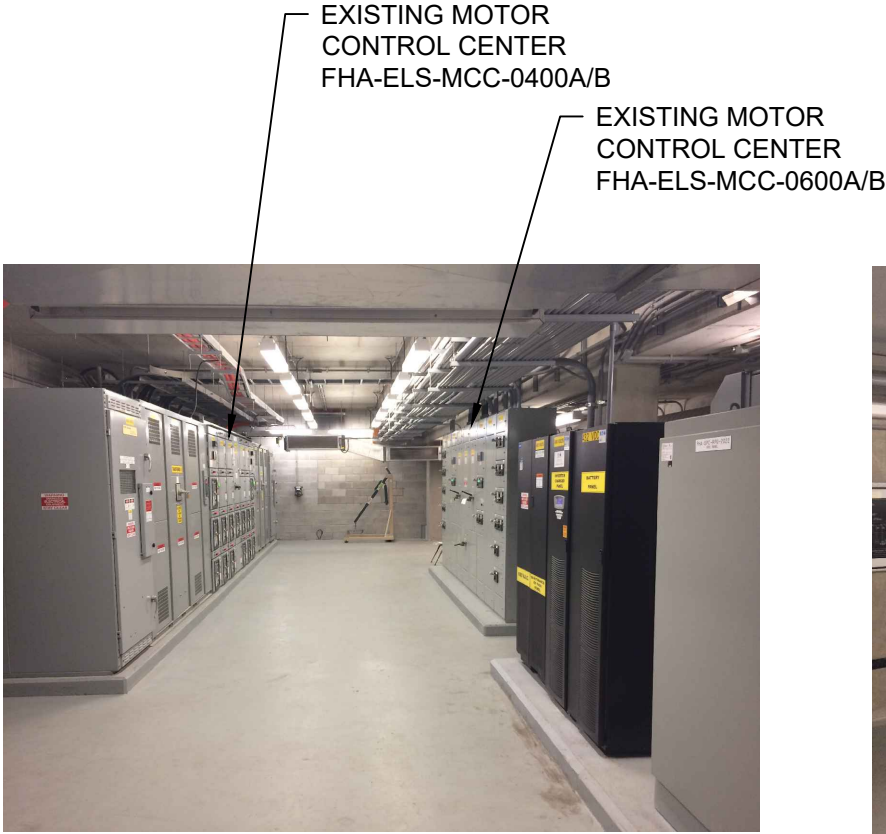


PHOTO 1
SCALE: N.T.S.




LOCATION FOR
NEW STANDBY
FHA-ELS-TS-0400
FHA-ELS-PDP-0400E

PHOTO 2
SCALE: N.T.S.

EXISTING 1500kVA
2400/600V
TRANSFORMER
FHA-ELS-TR-0106



PHOTO 3
SCALE: N.T.S.

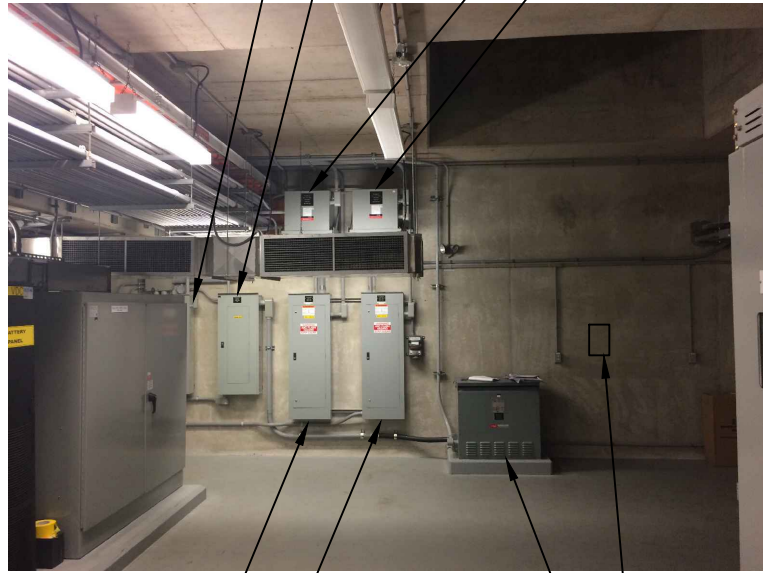

EXISTING LIGHTING
PANEL DP-5
EXISTING LIGHTING
PANEL DP-6

PHOTO 4
SCALE: N.T.S.

LOCATION FOR GENERATOR
REMOTE ANNUNCIATOR PANEL
FHA-ELS-GEN-0100
EXISTING
TRANSFORMER TR4



PHOTO 5
SCALE: N.T.S.


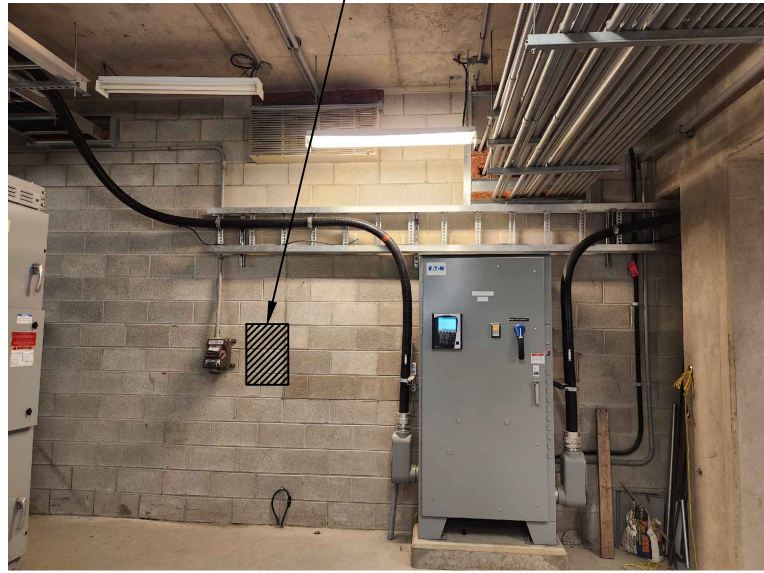


PHOTO 6
SCALE: N.T.S.



PHOTO 7
SCALE: N.T.S.

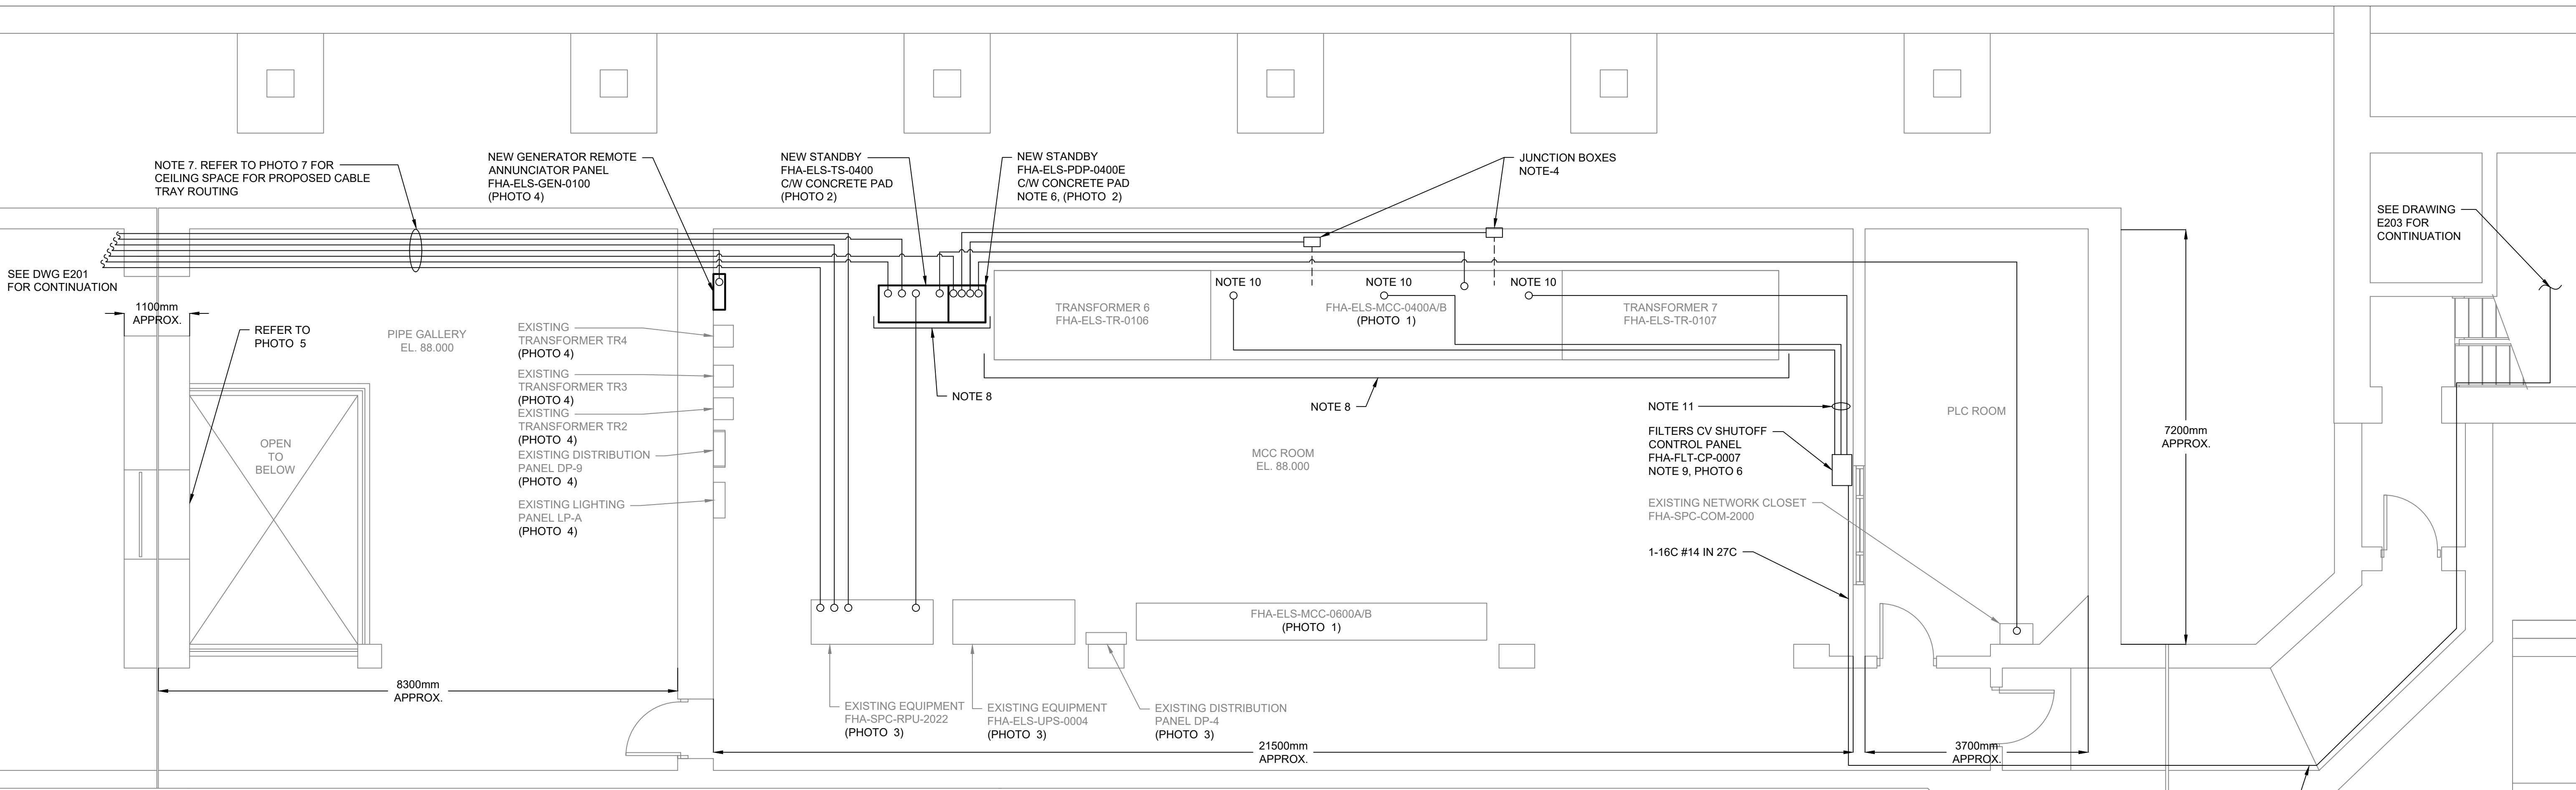

NOTES:

- PROVIDE NEW AND COMPLETE OVERHEAD CABLE TRAY SYSTEM FOR ALL NEW POWER AND CONTROL CABLES/WIRING TO INTERCONNECT EQUIPMENT WHERE INDICATED. USE OF EXISTING CABLE TRAYS WILL ONLY BE ACCEPTED IF SUFFICIENT SPACE IS AVAILABLE AND THE RESULTING FILL AREA DOES NOT EXCEED THE OESC CODE REQUIREMENTS.
- PROVIDE SEPARATE CABLE TRAYS OR ACCEPTABLE BARRIER FOR CONDUCTORS OF 600VAC POWER, ELECTRICAL LIGHTING, 120VAC CONTROL AND SIGNAL WIRING.
- UNLESS OTHERWISE INDICATED, ALL CONDUCTORS ARE TO BE COPPER AND ALL POWER CABLES ARE TO BE TECK90.
- DISCONNECT EXISTING FEEDERS FOR PDP-0401A/B FROM MCC-0400A/B AND EXTEND TO NEW PDP-0400E.
- CONTRACTOR TO COORDINATE WITH CITY OF TORONTO FOR THE EXACT INSTALLATION LOCATION OF THE EQUIPMENT.
- PROVIDE CONDUIT AND DATA WIRING BETWEEN POWER METER INSIDE FHA-ELS-PDP-0400E AND EXISTING NETWORK CLOSET FHA-SPC-COM-2000.
- RUN TECK CABLES IN CABLE TRAY, SUPPORT CONDUITS BELOW THE CABLE TRAY.

- PROVIDE 2" WIDE ELECTRICAL INSULATION MAT COVERING THE FULL LENGTH OF THE EQUIPMENT.
- REFER TO E016 FOR WIRING & CONNECTION DETAILS.
- INSTALL TECK CABLES TO THE UNDERSIDE OF THE EXISTING CABLE TRAY.
- PROVIDE SUPPORT FOR TECK CABLES ON WALL.

ELECTRICAL FLOOR PLAN - RMF MCC ROOM (EL. 88.00)
N.T.S.

				TORONTO WATER ENGINEERING AND CONSTRUCTION SERVICES		R.C. HARRIS WATER TREATMENT PLANT INSTALLATION OF A STANDBY GENERATOR FOR CRITICAL LOADS ELECTRICAL FLOOR PLAN - RMF MCC ROOM (EL. 88.00)					
				WILLIAM FERNANDES, P. ENG. DIRECTOR WATER TREATMENT AND SUPPLY		SIMON HOPTON, P. ENG. DIRECTOR DESIGN & CONSTRUCTION MAJOR INFRASTRUCTURE		ELECTRICAL			
COPYRIGHT: This drawing has been prepared solely for the intended use. Any reproduction or distribution for any purpose other than authorized by ARCADIS is forbidden. Written dimensions shall have precedence over scaled dimensions. Contractors shall verify and be responsible for all dimensions and conditions on the job, and ARCADIS shall be informed of any variations from the dimensions and conditions shown on the drawing. Shop drawings shall be submitted to the Client for general conformance before proceeding with fabrication.		A		2025-03-18		ISSUED FOR TENDER		T.S.		DESIGN: SC	
ARCADIS Professional Services (Canada) Inc.		NO.		DATE		REVISIONS		INITIAL		SIGNED	
100-175 GALAXY BOULEVARD TORONTO, ONTARIO, M9W 0C9 TEL 416 679 1930 FAX 416 675 4620 www.arcadis.com										CHECK: TS	
										CONTRACT No. 25ECS-MI-03HA	
										SCALE: N.T.S.	
										DRAWING NUMBER: 2F-2017-08-64	
										E202	



PHOTO 1
SCALE: N.T.S.

EXISTING SCRUBBER PANEL



PHOTO 2
SCALE: N.T.S.



PHOTO 3
SCALE: N.T.S.

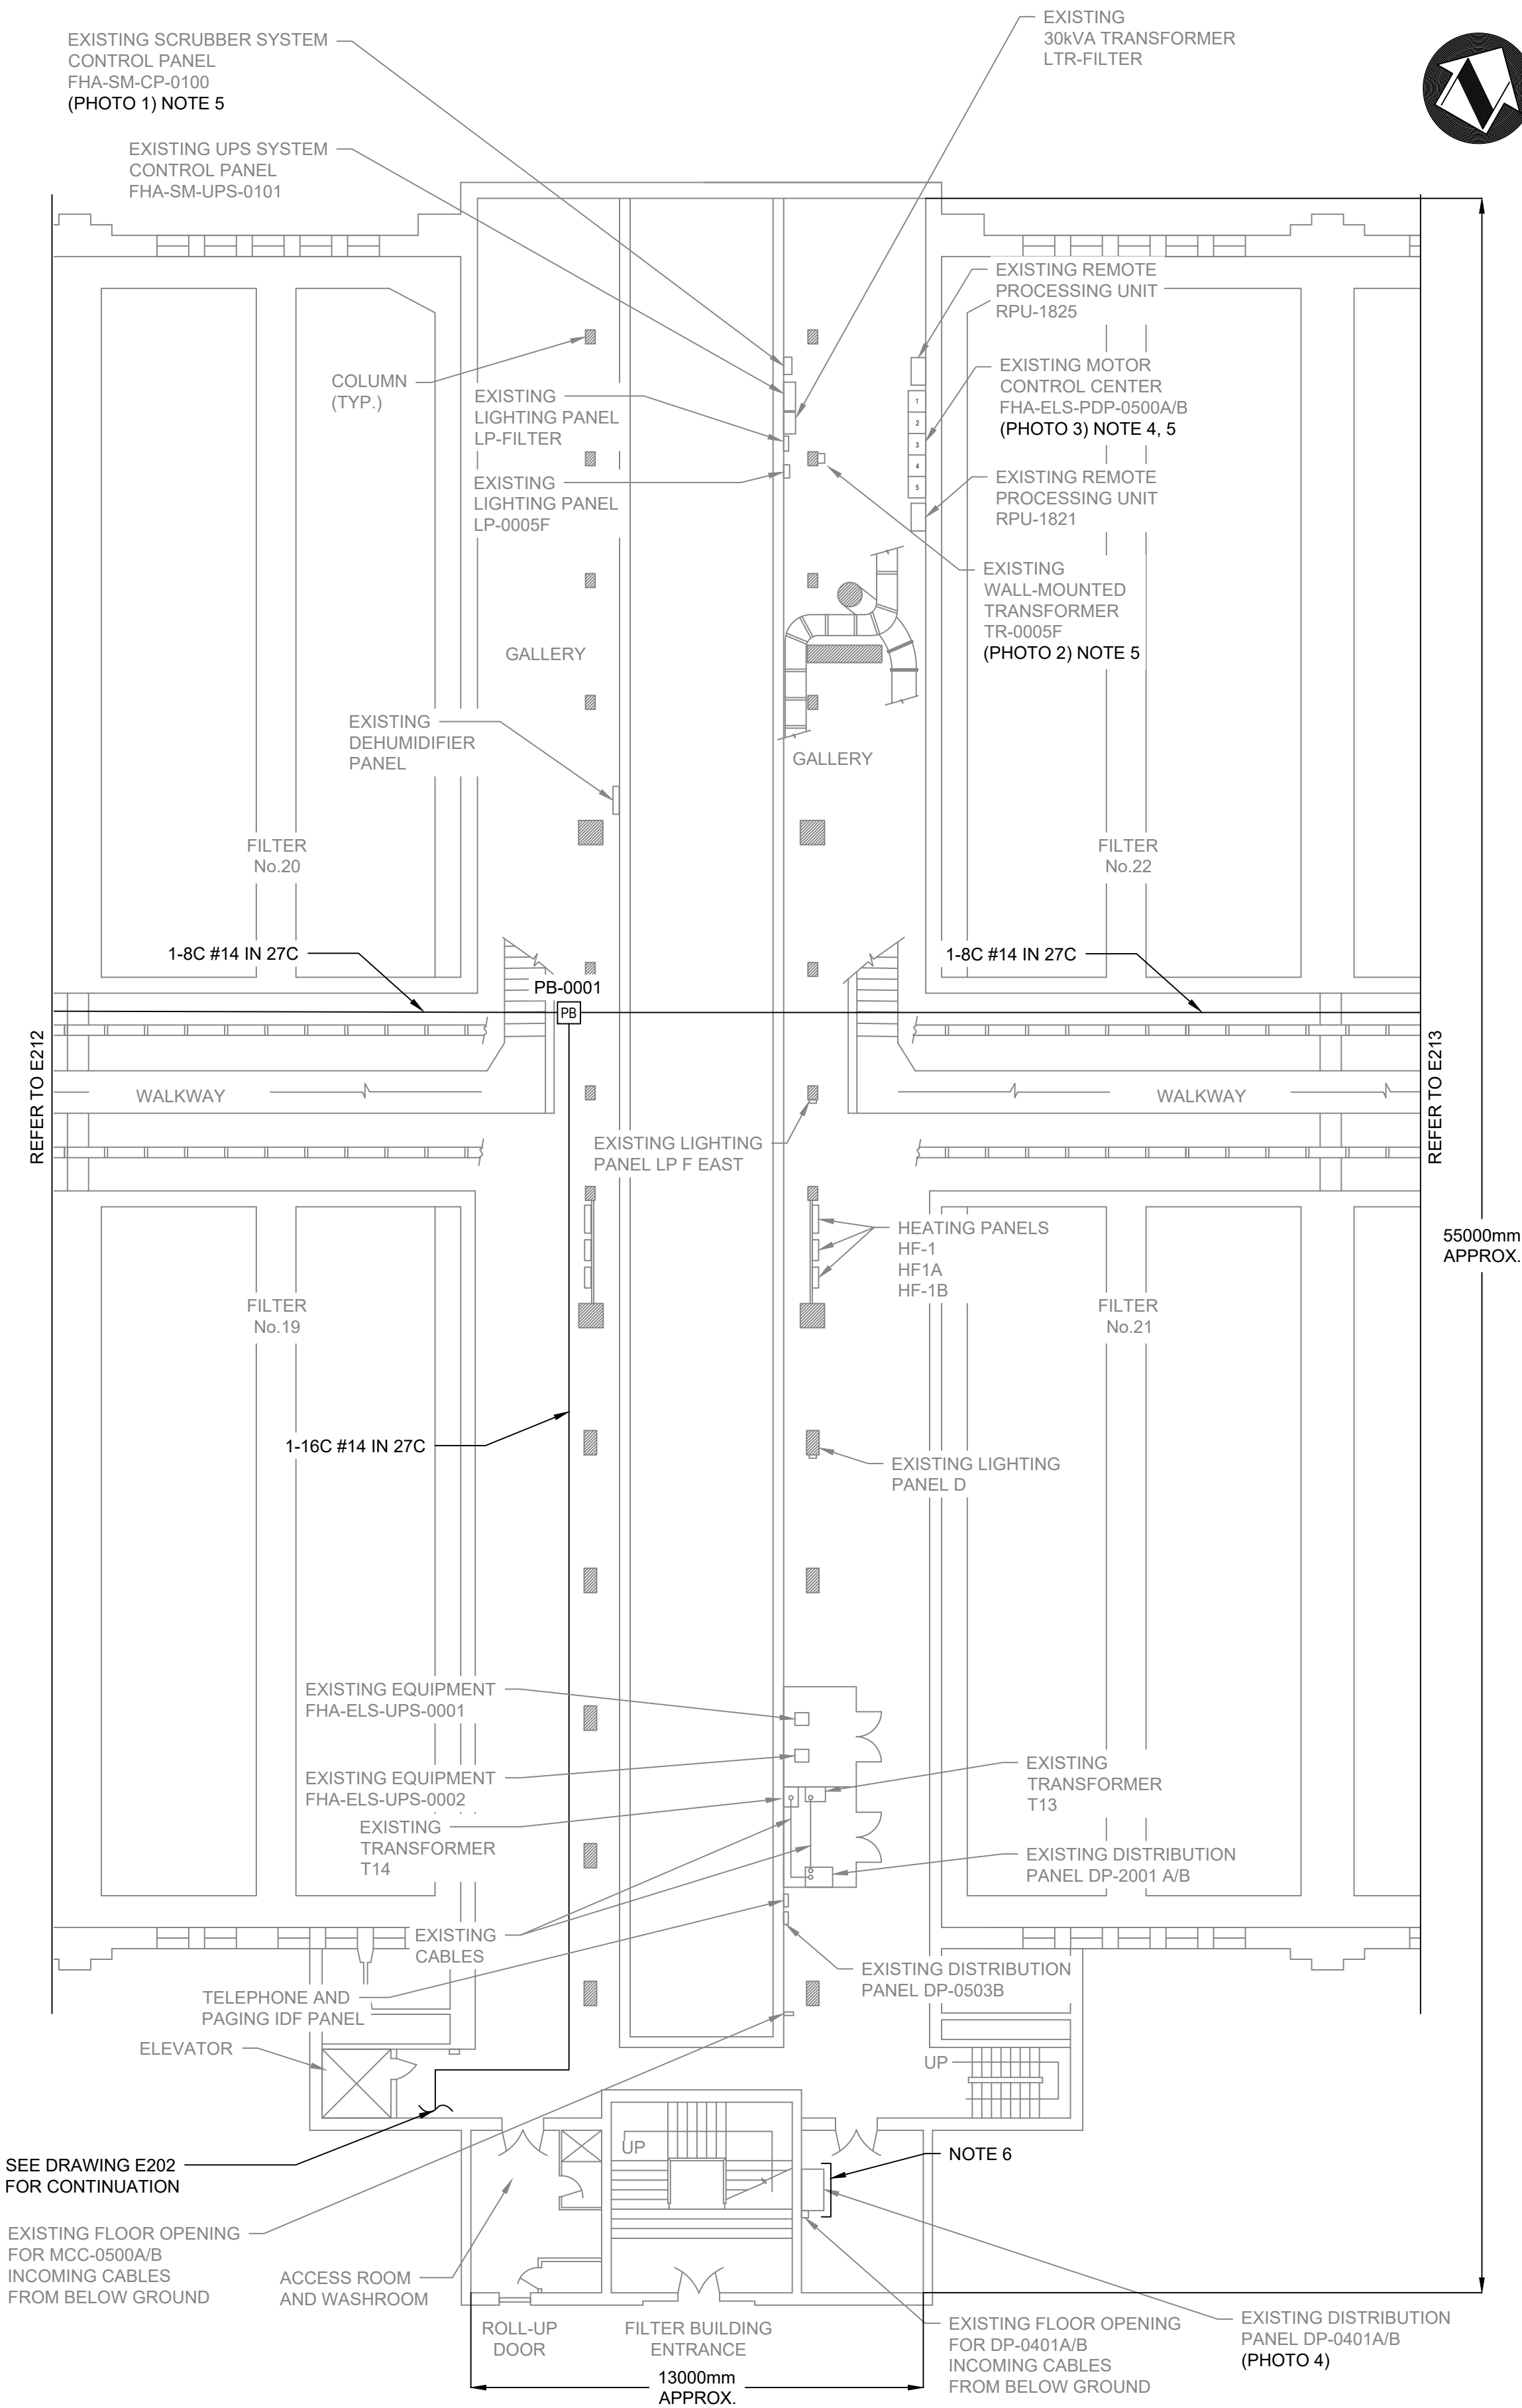


PHOTO 4
SCALE: N.T.S.

EXISTING DISTRIBUTION
PANEL DP-0401A/B

NOTES:

1. PROVIDE NEW AND COMPLETE OVERHEAD CABLE TRAY SYSTEM FOR ALL NEW POWER AND CONTROL CABLES/WIRING TO INTERCONNECT EQUIPMENT WHERE INDICATED. USE OF EXISTING CABLE TRAYS WILL ONLY BE ACCEPTED IF SUFFICIENT SPACE IS AVAILABLE AND THE RESULTING FILL AREA DOES NOT EXCEED THE OESC CODE REQUIREMENTS.
2. PROVIDE SEPARATE CABLE TRAYS OR ACCEPTABLE BARRIER FOR CONDUCTORS OF 600VAC POWER, ELECTRICAL LIGHTING, 120VAC CONTROL WIRING AND SIGNAL WIRING.
3. UNLESS OTHERWISE INDICATED ALL CONDUCTORS ARE TO BE COPPER AND ALL POWER CABLES ARE TO BE TECK90.
4. DISCONNECT EXISTING FEEDERS FOR FHA-FLT-UPS-0001 AND 0002. RELOCATE FEEDERS TO PDP-0401A/B.
5. DISCONNECT EXISTING FEEDERS FOR EXISTING SCRUBBER CONTROL PANEL FHA-SM-CP-0100 AND EXISTING TRANSFORMER FHA-ELS-TR-0500F. EXTEND FEEDERS TO PDP-0401A/B.
6. PROVIDE 2' WIDE ELECTRICAL INSULATION MAT COVERING THE FULL LENGTH OF THE EQUIPMENT.



ELECTRICAL FLOOR PLAN - LOWER FILTER PIPE GALLERY (EL. 94.06)
N.T.S.

—	EXISTING
—	NEW



TORONTO WATER

ENGINEERING AND CONSTRUCTION SERVICES

WILLIAM FERNANDES, P. ENG.
DIRECTOR
WATER TREATMENT AND SUPPLY

SIMON HOPTON, P. ENG.
DIRECTOR
DESIGN & CONSTRUCTION
MAJOR INFRASTRUCTURE

R.C. HARRIS WATER TREATMENT PLANT
INSTALLATION OF A STANDBY GENERATOR FOR CRITICAL LOADS
ELECTRICAL FLOOR PLAN - LOWER FILTER PIPE GALLERY (EL. 94.06)


ELECTRICAL

DESIGN:	SC	DRAFTING:	SC	CHECK:	TS	CONTRACT No.	25ECS-MI-03HA
SCALE:	N.T.S.				DRAWING NUMBER:	2F-2017-08-65	E203
DATE:	2024-09-30						


ARCADIS
100-175 GALAXY BOULEVARD
TORONTO, ONTARIO, M9W 0C9
TEL 416 679 1930 FAX 416 675 4620
www.arcadis.com

COPYRIGHT:
This drawing has been prepared solely for the intended use. Thus, any reproduction or distribution for any purpose other than authorized by ARCADIS is forbidden. Written dimensions shall have precedence over scaled dimensions. Contractors shall verify and be responsible for all dimensions and conditions on the job, and ARCADIS shall be informed of any variations from the dimensions and conditions shown on the drawing. Shop drawings shall be submitted to the Client for general conformance before proceeding with fabrication.
ARCADIS Professional Services (Canada) Inc.

NO.	DATE	REVISIONS	INITIAL	SIGNED
A	2025-03-18	ISSUED FOR TENDER	T.S.	

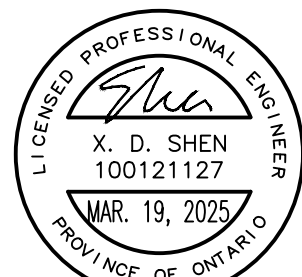

#	FED FROM	TO	LOCATION	REFERENCE
E1	FHA-ELS-PDP-0300E	FHA-ELS-PDP-0200E	FROM PUMPING STATION TO RMF BUILDING	DWG E205, E207, E208
G1	GENERATOR 1 FHA-ELS-GEN-0100	FHA-ELS-TS-0300	FROM RMF PIPE GALLERY TO SWITCHGEAR ROOM PUMP BUILDING	DWG E201, E205, E207, E209
H4	FHA-ELS-PDP-0300E	SUMP PUMP FHA-SAN-P-0300E	SWITCHGEAR ROOM PUMPING STATION TO TUNNEL UNDER SUBSTATION IN RMF BLDG	DWG E205

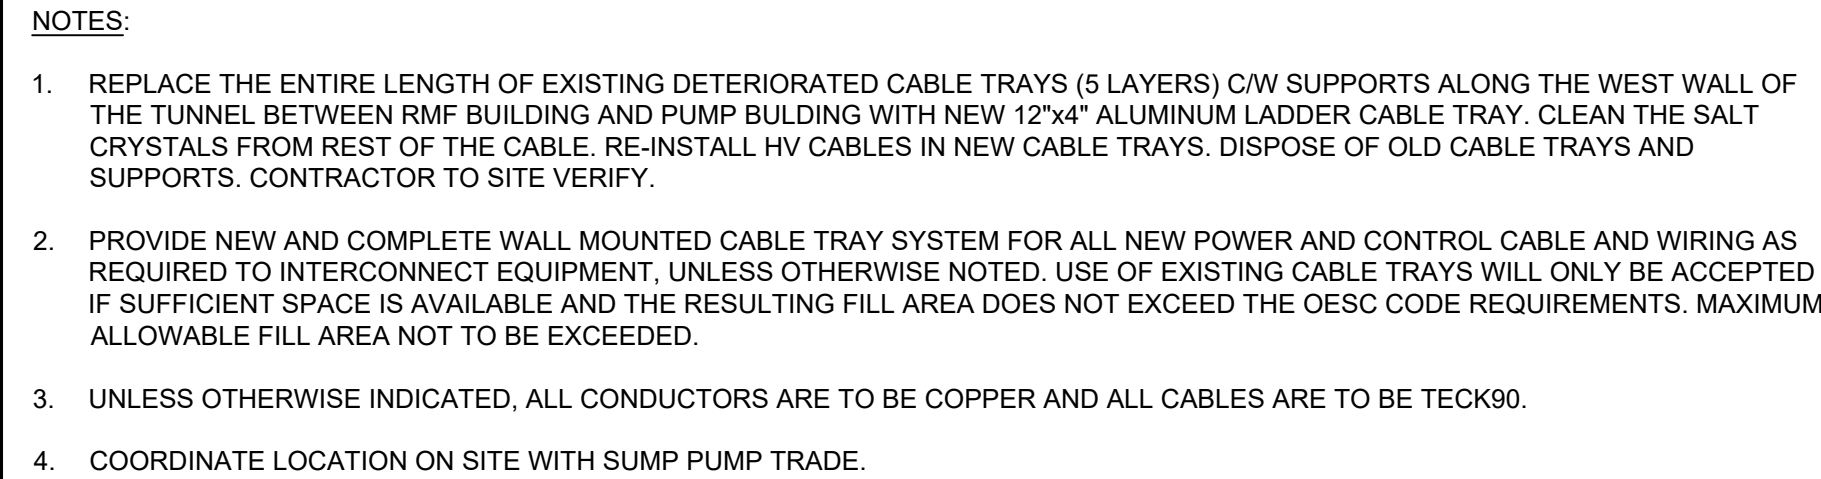

SCALE: 1:150

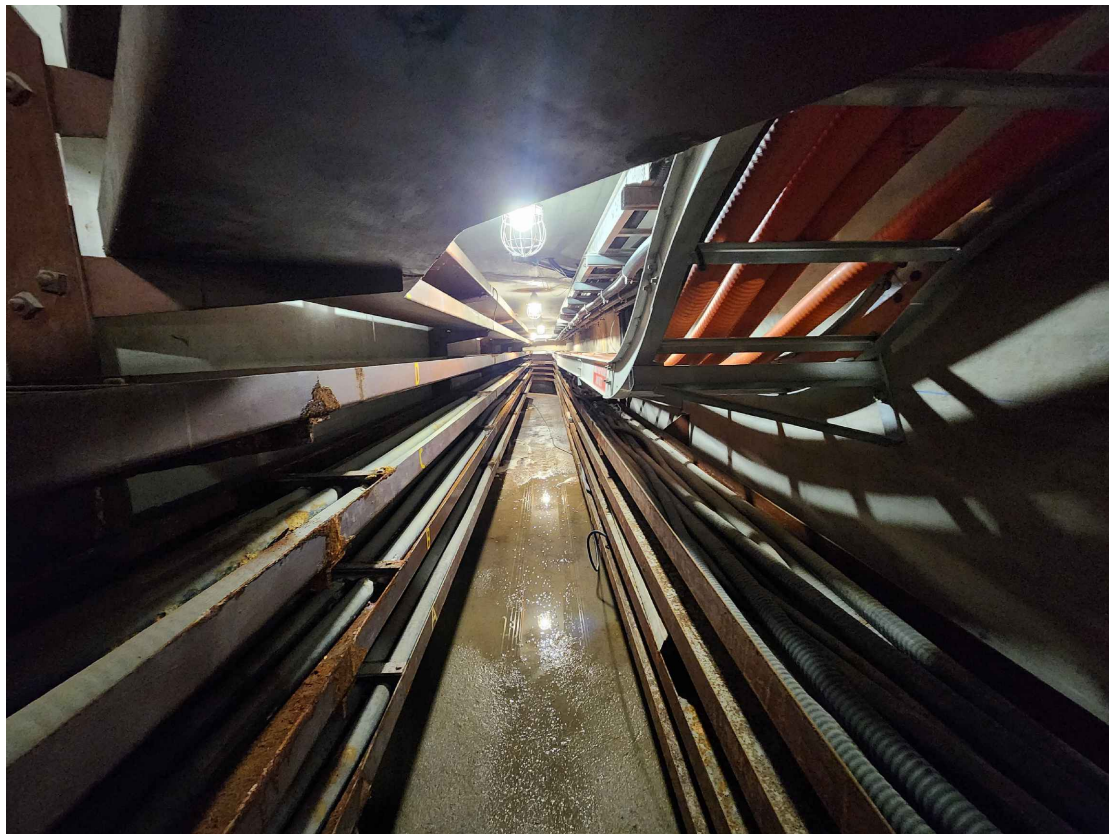


PHOTO 1

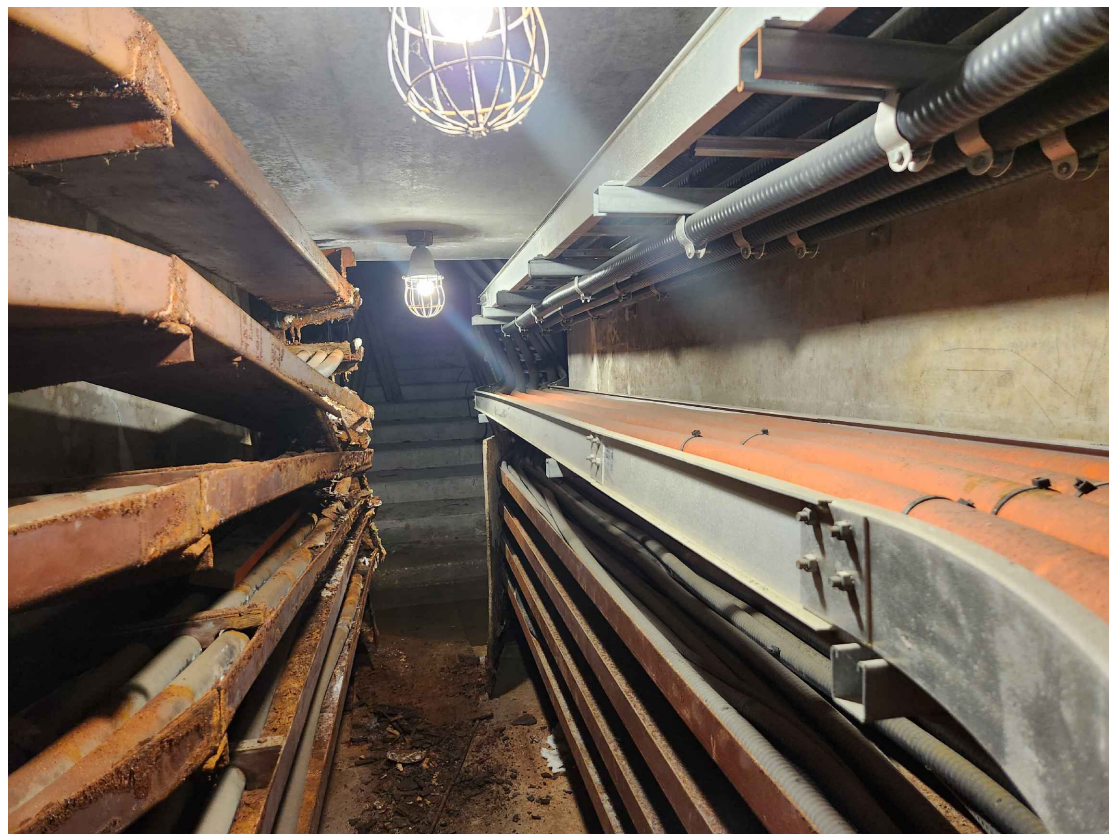


PHOTO 2



PHOTO 3

Drawing: J:\M16-0273 TOR_HARRISWTP-STANDBYGENERATOR\500_CAD\401-CAD\1-SS OR BU\SHEET\6 ELEC\2F-2017-08-67-E205.DWG
Layout: 03/19/2025
Date: 03/19/2025
Time: 12:39:50 PM

METRIC
MEASUREMENTS SHOWN ON THESE PLANS
ARE IN MILLIMETERS UNLESS OTHERWISE NOTED

EXISTING SUMP PUMP
CONTROL PANEL
FHA-SAN-CP-1101
(NOTE 6)

SUMP PUMP
FHA-SAN-P-0201

SUMP PUMP
FHA-SAN-P-0101

EXISTING
FHA-ELS-LP-0300H

EXISTING
TRANSFORMER
FHA-ELS-TR-0300H

NEW ATS
FHA-ELS-TS-0300
PHOTO 2

NEW PANEL
FHA-ELS-PDP-0300E
(NOTE 10)

TWO (2) EXISTING HOLES
TO ROUTE NEW CABLES
FROM THE SWITCHGEAR
ROOM TO GROUND FLOOR

NEW JUNCTION/PULL BOX FOR
CP-1101 FEEDER EXTENSION
TO FHA-ELSPDP-0300E

EXISTING NETWORK CLOSET
FHA-SPC-COM-1200

EXISTING
RPU-1221/1225

EXISTING
RPU-1223

EXISTING
RPU-1224/1226

NEW PANEL FHA-ELS-LP-0300E,
NEW TRANSFORMER (30kVA)
FHA-ELS-TR-0300E
(MOUNTED ABOVE PANEL)
(NOTE 9)

EXISTING PANEL
FHA-ELS-MCC-0301A
EXISTING PANEL
FHA-ELS-MCC-0301B

NOTE 11

NOTE 11

NOTE 11

CABLE DOWN TO TUNNEL VIA STAIRS
OPENING SUPPORTED BY NEW CABLE TRAY
REFER TO E204

EXISTING
FHA-ELS-PDP-0300
* PHOTO 1

OUTLINE OF SERVER ROOM AREA
ON GROUND FLOOR

EXISTING
CEILING
PENETRATION

EXISTING PANEL
FHA-ELS-DP-0301A-2
(NOTE 7)

EXISTING PANEL
FHA-ELS-DP-0301B-5
(NOTE 7)

NOTES:

1. PROVIDE NEW AND COMPLETE OVERHEAD CABLE TRAY SYSTEM FOR ALL NEW POWER AND CONTROL CABLE AND WIRING AS REQUIRED TO INTERCONNECT EQUIPMENT. USE OF EXISTING CABLE TRAYS WILL ONLY BE ACCEPTED IF SUFFICIENT SPACE IS AVAILABLE AND THE RESULTING FILL AREA DOES NOT EXCEED THE OESC CODE REQUIREMENTS. MAXIMUM ALLOWABLE FILL AREA NOT TO BE EXCEEDED.
2. PROVIDE SEPARATE CABLE TRAYS OR ACCEPTABLE BARRIER FOR CONDUCTORS OF 600VAC POWER, ELECTRICAL LIGHTING, 120VAC CONTROL AND SIGNAL WIRING.
3. UNLESS OTHERWISE INDICATED, ALL CONDUCTORS ARE TO BE COPPER AND ALL POWER CABLES ARE TO BE TECK90.
4. REFER TO DWG E133 FOR NEW STANDBY FHA-ELS-PDP-0300E SINGLE LINE DIAGRAM AND CABLE SCHEDULE.
5. REFER TO DWG E134 FOR NEW STANDBY PDP ELEVATION LAYOUT.
6. DISCONNECT EXISTING SUMP PUMP CONTROL PANEL CP-1101 FROM DP-1101B (LOCATED ON GROUND FLOOR). EXTEND EXISTING FEEDER TO FHA-ELS-PDP-0300E. CONTRACTOR TO FIELD VERIFY EXISTING SUMP PUMP CONTROL PANEL LOCATIONS.
7. DISCONNECT EXISTING FEEDER FOR FHA-ELS DP-0301A-2 FROM MCC-FLS-MCC-0301A AND RECONNECT TO FHA-ELS-PDP-0300E. COORDINATE SWITCH WITH THE FACILITY OR CONSULTANT.
8. DISCONNECT EXISTING FEEDER FOR FHA-ELS DP-0301B-5 FROM MCC-FLS-MCC-0301B AND RECONNECT TO FHA-ELS-PDP-0300E. COORDINATE SWITCH WITH THE FACILITY OR CONSULTANT.
9. DISCONNECT EXISTING FEEDER FOR FHA-ELS-LP-0301B FROM FHA-ELS-LP-0301A AND RECONNECT TO FHA-ELS-LP-0300E-A. COORDINATE SWITCH WITH THE FACILITY OR CONSULTANT.
10. PROVIDE CONDUIT AND DATA WIRING BETWEEN POWER METER INSIDE FHA-ELS-PDP-0300E AND EXISTING NETWORK CLOSET FHA-SPC-COM-1200.
8. PROVIDE 2" WIDE ELECTRICAL INSULATION MAT COVERING THE FULL LENGTH OF THE EQUIPMENT.

—	EXISTING
—	NEW
	REMOVAL, TO BE REPLACED WITH NEW CABLES & INSTALLED COMPLETE

PROPOSED LOCATION OF
FHA-ELS-TS-0300 &
FHA-ELS-PDP-0300E

EXISTING PDP
FHA-ELS-PDP-0300A/B

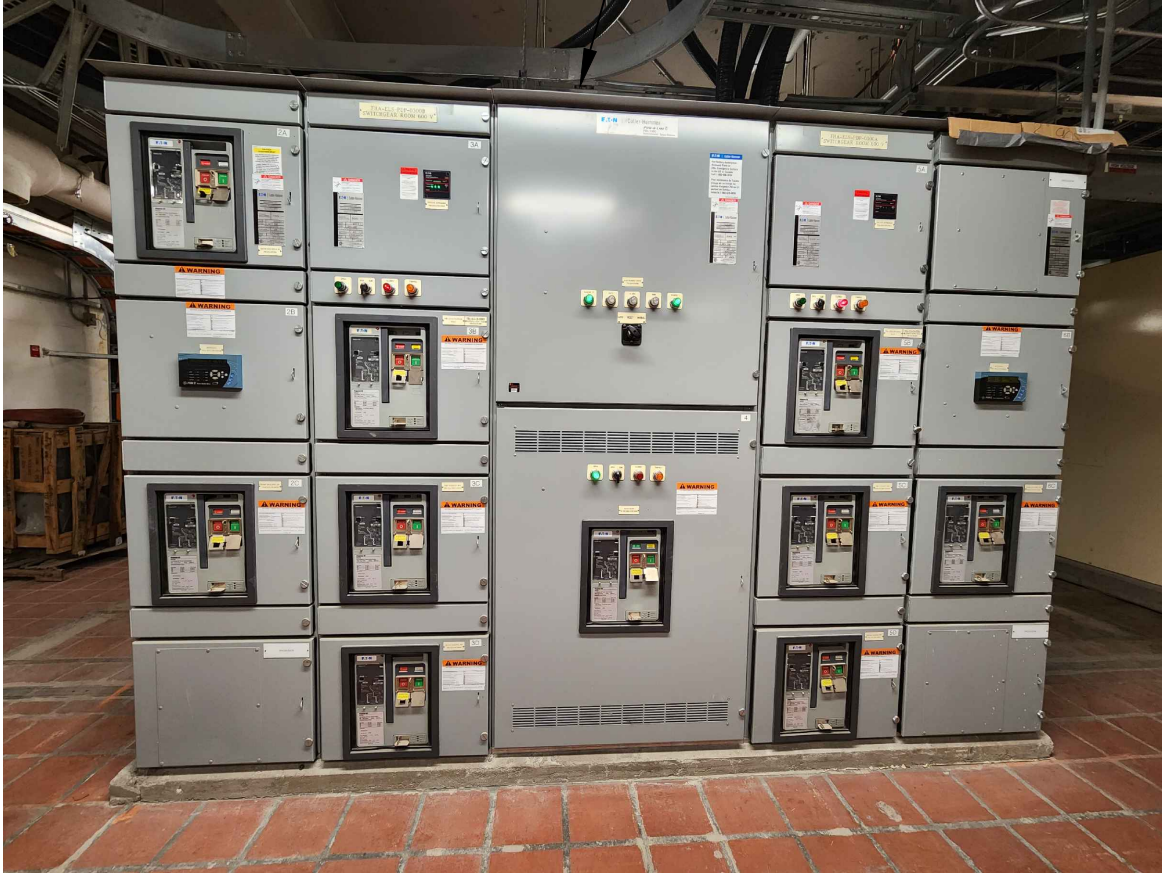


PHOTO 1



PHOTO 2

CABLE ROUTING TABLE

#	FED FROM	TO	LOCATION	REFERENCE
C1	FHA-ELS-PDP-0300B	FHA-ELS-TS-0300	SWITCHGEAR ROOM PUMPING STATION	DWG E205
E1	FHA-ELS-PDP-0300E	FHA-ELS-PDP-0200E	FROM PUMPING STATION TO RMF BUILDING	DWG E205, E207, E208
E2	FHA-ELS-PDP-0300E	FHA-ELS-PDP-0301A-2	SWITCHGEAR ROOM PUMPING STATION	DWG E205
E3	FHA-ELS-PDP-0300E	FHA-ELS-PDP-0301B-5	SWITCHGEAR ROOM PUMPING STATION	DWG E205
E4	FHA-ELS-PDP-0300E	FHA-ELS-LP-0301B	FROM SWITCHGEAR ROOM PUMPING STATION TO SERVER ROOM	DWG E205, E206
G1	GENERATOR 1 FHA-ELS-GEN-0100	FHA-ELS-TS-0300	FROM RMF PIPE GALLERY TO SWITHGEAR ROOM PUMP BUILDING	DWG E201, E205, E207, E209
H1	FHA-ELS-PDP-0300E	SUMP PUMP CONTROL PANEL FHA-DEW-CP-1701	SWITCHGEAR ROOM PUMPING STATION	DWG E205, E206
H2	FHA-ELS-PDP-0300E	SUMP PUMP CONTROL PANEL FHA-SAN-CP-1101	SWITCHGEAR ROOM PUMPING STATION	DWG E205
H3	FHA-ELS-PDP-0300E	TRANSFORMER FHA-ELS-TR-0300E	SWITCHGEAR ROOM PUMPING STATION	DWG E204, E205
H4	FHA-ELS-LP-0300E	SUMP PUMP FHA-SAN-P-0300E	SWITCHGEAR ROOM PUMPING STATION TO TUNNEL UNDER SUBSTATION IN RMF BLDG	DWG E205
H5	FHA-ELS-PDP-0300E	NETWORK CLOSET FHA-SPC-COM-1200	SWITCHGEAR ROOM PUMPING STATION	DWG E205
H6	FHA-ELS-TS-0300E	RPU PANEL RPU-1223	SWITCHGEAR ROOM PUMPING STATION	DWG E205

ELECTRICAL FLOOR PLAN - SWITCHGEAR ROOM PUMPING STATION BASEMENT

1:50



100-175 GALAXY BOULEVARD
TORONTO, ONTARIO, M9W 0C9
TEL 416 679 1930 FAX 416 675 4620
www.arcadis.com

COPYRIGHT:

This drawing has been prepared solely for the intended use. Thus, any reproduction or distribution for any purpose other than authorized by ARCADIS is forbidden. Written dimensions shall have precedence over scaled dimensions. Contractors shall verify and be responsible for all dimensions and conditions on the job, and ARCADIS shall be informed of any variations from the dimensions and conditions shown on the drawing. Shop drawings shall be submitted to IRI Group for general conformance before proceeding with fabrication.

ARCADIS Professional Services (Canada) Inc.

NO.	DATE	REVISIONS	INITIAL	SIGNED
A	2025-03-18	ISSUED FOR TENDER	T.S.	



TORONTO WATER	
ENGINEERING AND CONSTRUCTION SERVICES	
WILLIAM FERNANDES, P. ENG. DIRECTOR WATER TREATMENT AND SUPPLY	SIMON HOPTON, P. ENG. DIRECTOR DESIGN & CONSTRUCTION MAJOR INFRASTRUCTURE

R.C. HARRIS WATER TREATMENT PLANT					
INSTALLATION OF A STANDBY GENERATOR FOR CRITICAL LOADS					
ELECTRICAL FLOOR PLAN - PUMPING STATION BASEMENT LEVEL SWITCHGEAR ROOM					
ELECTRICAL					
DESIGN:	SC	DRAFTING:	SC	CHECK:	TS
SCALE:	1:50		DRAWING NUMBER:	2F-2017-08-67	
DATE:	2024-09-30			CONTRACT No. 25ECS-MI-03HA	
					E205

SUMP PUMP CONTROL
PANEL FHA-DEW-CP-4401





SUMP PUMP CONTROL
PANEL FHA-DEW-CP-1701

EXISTING SUMP PUMP
CONTROL PANEL
FHA-DEW-CP-1701
(NOTE 6)
*PHOTO 1

EXISTING SUMP PUMP
CONTROL PANEL
FHA-DEW-CP-4401
(NOTE 6)
*PHOTO 1

CROSS SECTION DETAIL
N.T.S.

A

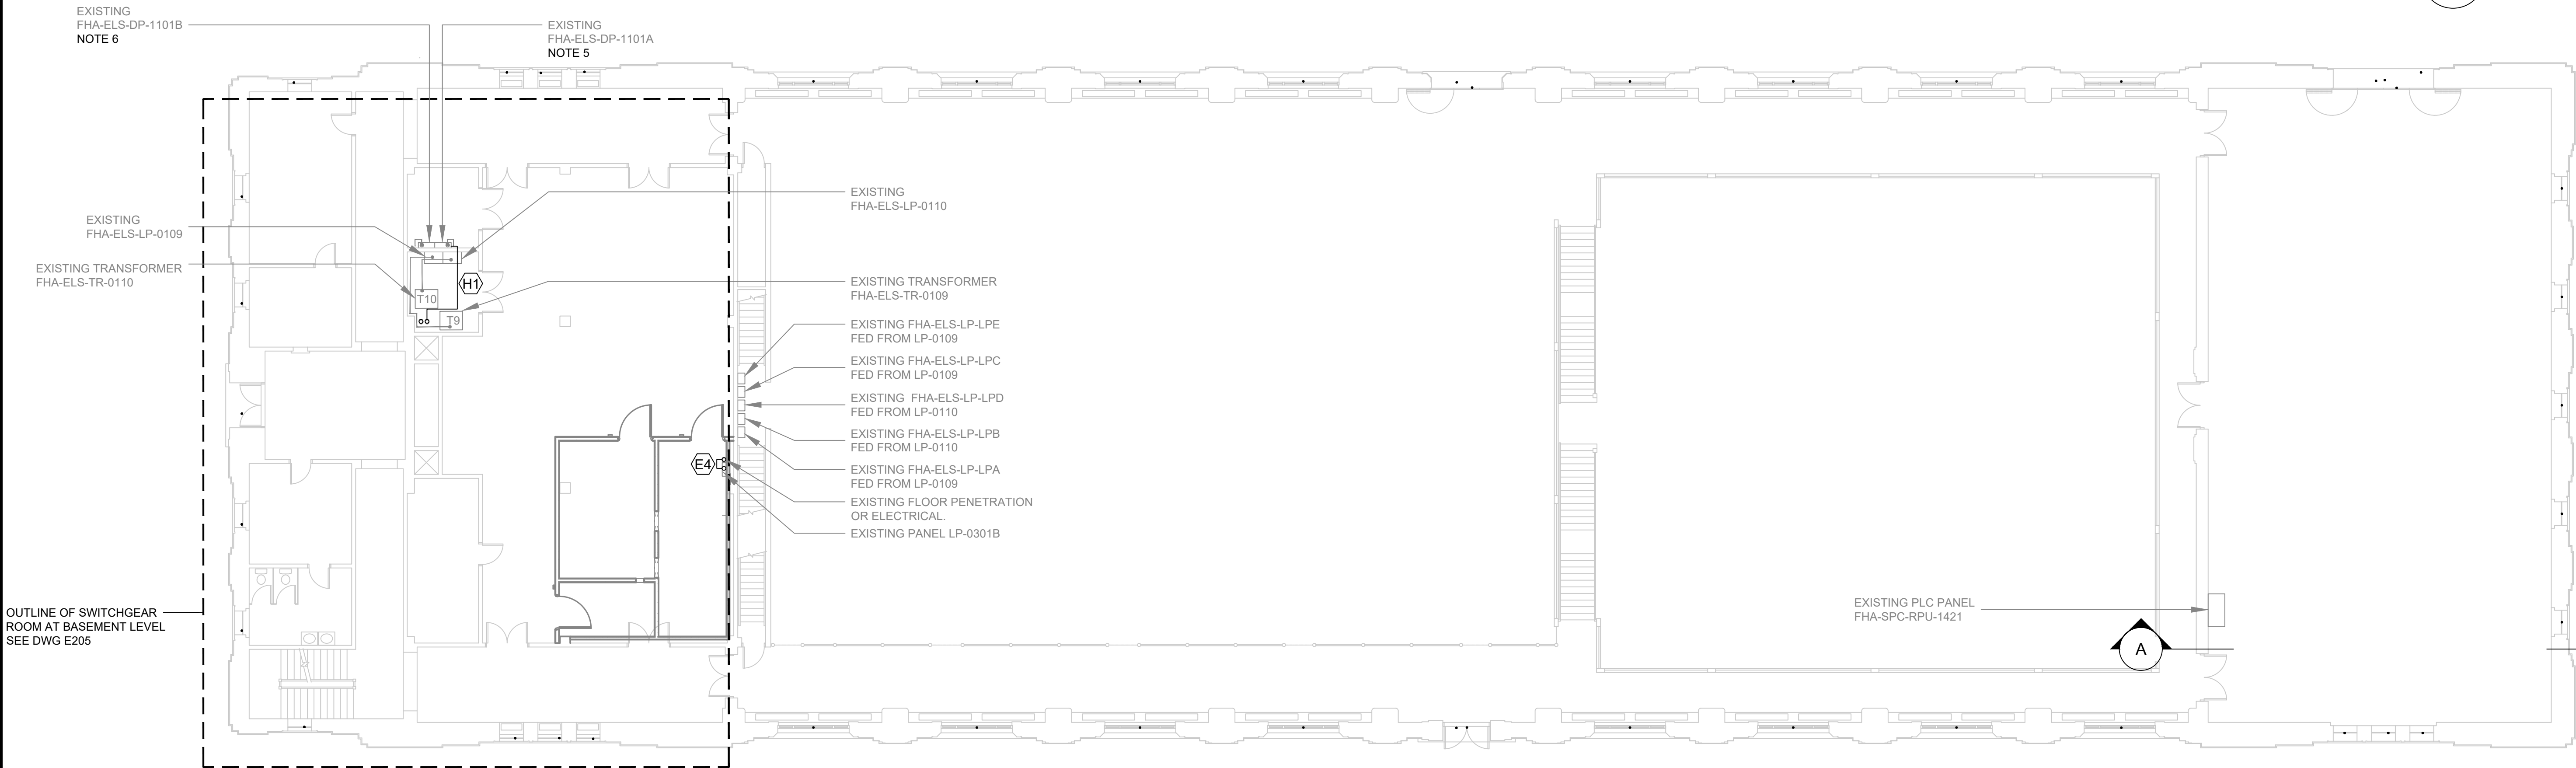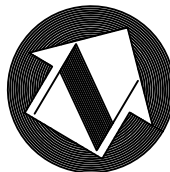

NOTES:

- THIS DRAWING SHOULD BE READ IN CONJUNCTION WITH THE STRUCTURAL AND MECHANICAL DRAWINGS.
- PROVIDE NEW AND COMPLETE OVERHEAD CABLE TRAY SYSTEM FOR ALL NEW POWER AND CONTROL CABLE AND WIRING AS REQUIRED TO INTERCONNECT EQUIPMENT WHERE INDICATED. USE OF EXISTING CABLE TRAYS WILL ONLY BE ACCEPTED IF SUFFICIENT SPACE IS AVAILABLE AND THE RESULTING FILL AREA DOES NOT EXCEED THE OESC CODE REQUIREMENTS. MAXIMUM ALLOWABLE FILL AREA NOT TO BE EXCEEDED.
- PROVIDE SEPARATE CABLE TRAYS OR ACCEPTABLE BARRIER FOR CONDUCTORS OF 600VAC POWER, ELECTRICAL LIGHTING, 120VAC CONTROL AND SIGNAL WIRING.
- UNLESS OTHERWISE INDICATED, ALL CONDUCTORS ARE TO BE COPPER AND ALL POWER CABLES ARE TO BE TECK90.
- DISCONNECT EXISTING FEEDER FOR CP-1701 AND EXTEND FEEDER TO PDP-0300E (LOCATED IN THE BASEMENT SWITCHGEAR ROOM) VIA NEAREST EXISTING FLOOR PENETRATION.
- DISCONNECT EXISTING SUMP PUMP CONTROL PANEL CP-1101 (LOCATED IN BASEMENT LEVEL) FROM FHA-ELS-DP-1101B . EXTEND EXISTING FEEDER TO FHA-ELS-PDP-0300E.

CABLE ROUTING TABLE

#	FED FROM	TO	LOCATION	REFERENCE
E4	FHA-ELS-PDP-0300E	FHA-ELS-LP-0301B	FROM SWITCHGEAR ROOM PUMPING STATION TO SERVER ROOM	DWG E205, E206
H1	FHA-ELS-PDP-0300E	SUMP PUMP CONTROL PANEL FHA-DEW-CP-1701	SWITCHGEAR ROOM PUMPING STATION	DWG E205, E206

ELECTRICAL FLOOR PLAN - PUMPING STATION GROUND LEVEL (EL. 78.64)

1:125

—	EXISTING
—	NEW
▨	REMOVAL, TO BE REPLACED WITH NEW CABLES & INSTALLED COMPLETE



TORONTO WATER

ENGINEERING AND CONSTRUCTION SERVICES

WILLIAM FERNANDES, P.ENG
DIRECTOR
WATER TREATMENT AND SUPPLY

SIMON HOPTON, P. ENG.
DIRECTOR
DESIGN & CONSTRUCTION
MAJOR INFRASTRUCTURE

R.C. HARRIS WATER TREATMENT PLANT

INSTALLATION OF A STANDBY GENERATOR FOR CRITICAL LOADS
ELECTRICAL FLOOR PLAN - PUMPING STATION GROUND LEVEL (EL. 78.64)

ELECTRICAL

DESIGN:	SC	DRAFTING:	SC	CHECK:	TS	CONTRACT No.	25ECS-MI-03HA	
SCALE:	1:125			DRAWING NUMBER:	2F-2017-08-68			E206
DATE:	2024-09-30							



100-175 GALAXY BOULEVARD
TORONTO, ONTARIO, M9W 0C9
TEL 416 679 1930 FAX 416 675 4620
www.arcadis.com

COPYRIGHT:

This drawing has been prepared solely for the intended use. Thus, any reproduction or distribution for any purpose other than authorized by ARCADIS is forbidden. Written dimensions shall have precedence over scaled dimensions. Contractors shall verify and be responsible for all dimensions and conditions on the job, and ARCADIS shall be informed of any variations from the dimensions and conditions shown on the drawing. Shop drawings shall be submitted to the Client for general conformance before proceeding with fabrication.

ARCADIS Professional Services (Canada) Inc.

NO.	DATE	REVISIONS	INITIAL	SIGNED
A	2025-03-18	ISSUED FOR TENDER	T.S.	



CONTRACTOR TO REMOVE AND RELOCATE ALL THE ITEMS ON THE WALL TO ANOTHER WALL SPACE AVAILABLE IN THE SAME ROOM

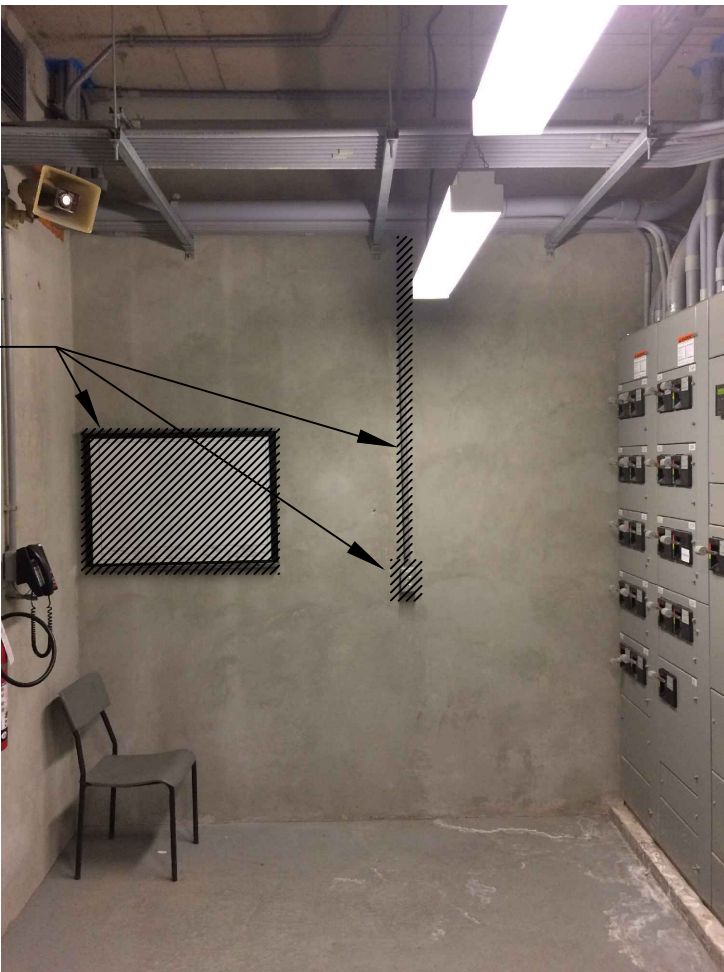


PHOTO 2



EXISTING CABLE TRAY

LOCATION FOR NEW STANDBY
FHA-ELS-PDP-0200E



PHOTO 3

EXISTING SUMP PUMP
CONTROL PANEL
FHA-WWW-CP-6210

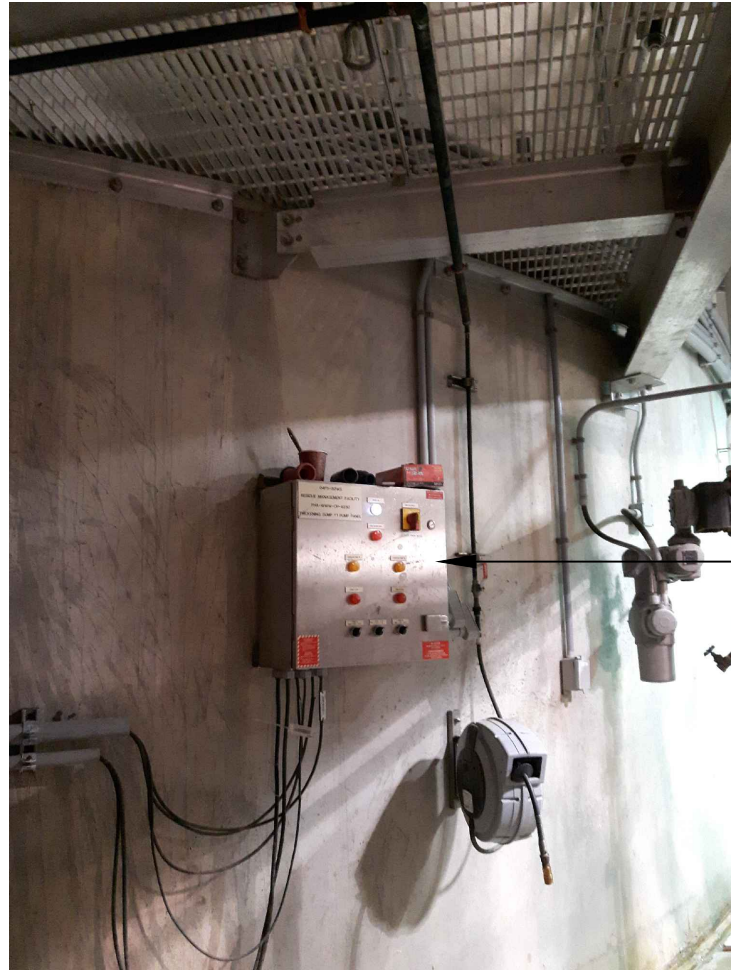


PHOTO 4

EXISTING SUMP PUMP
CONTROL PANEL
FHA-WWW-CP-6230
(NOTE 6)
* PHOTO 4



PHOTO 5

EXISTING SUMP PUMP
CONTROL PANEL
FHA-WWW-CP-6240



PHOTO 6

EXISTING
FHA-WWW-LP-B
FED FROM LP-2.
IT IS LOCATED
ONE (1) LEVEL
ABOVE THE ROOM
WHERE THE
EXISTING
MCC-0200 IS
LOCATED

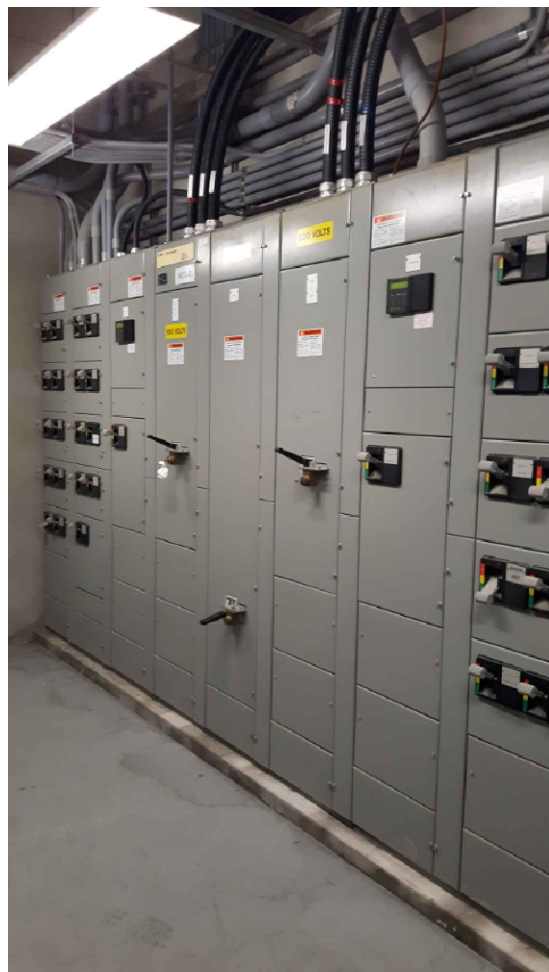


PHOTO 1

NEW STANDBY
FHA-ELS-0200E
* PHOTO 2

ELECTRICAL ROOM
SEE DETAIL 'A' ON DWG E208

EXISTING
FHA-ELS-MCC-0200
* PHOTO 1


EXISTING SUMP PUMP
CONTROL PANEL
FHA-WWW-CP-6210
(NOTE 6)
* PHOTO 3

PHOTO 6
FOR AREA ABOVE

TO FHA-ELS-GEN-0100 IN
RMF PIPE GALLERY. SEE
DWG E209

EXISTING SUMP PUMP
CONTROL PANEL
FHA-WWW-CP-6230
(APPROX. EL. 77)
(NOTE 6)
* PHOTO 4

EXISTING SUMP PUMP
CONTROL PANEL
FHA-WWW-CP-6240
(APPROX. EL. 77)
(NOTE 6)
* PHOTO 5

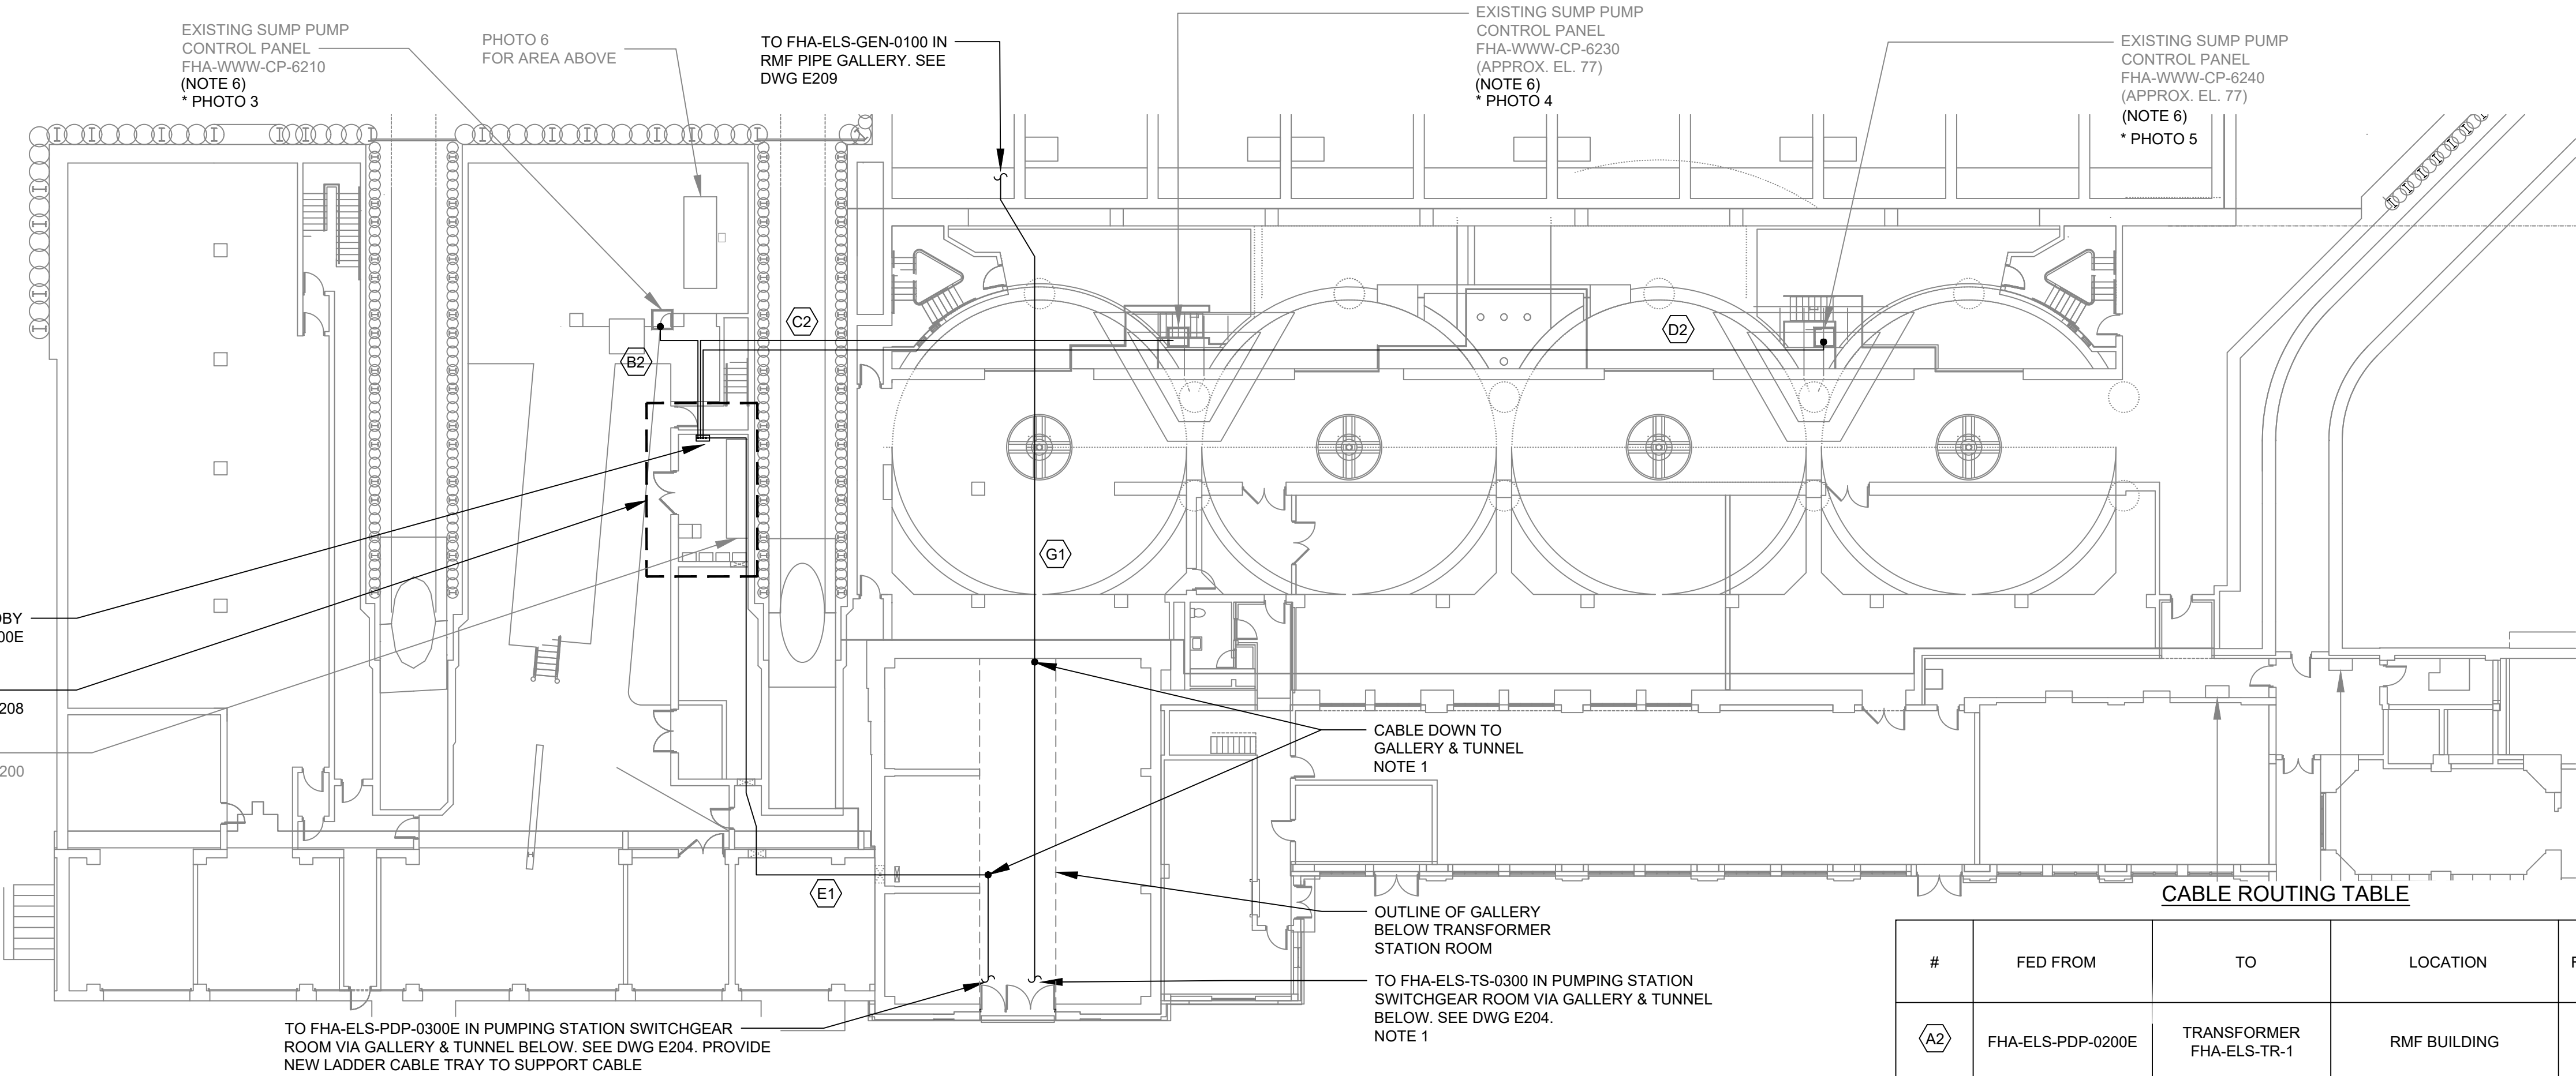

CABLE ROUTING TABLE

#	FED FROM	TO	LOCATION	REFERENCE
A2	FHA-ELS-PDP-0200E	TRANSFORMER FHA-ELS-TR-1	RMF BUILDING	DWG E208
B2	FHA-ELS-PDP-0200E	SUMP PUMP CONTROL PANEL FHA-WWW-CP-6210	RMF BUILDING (NOTE 6)	DWG E208
C2	FHA-ELS-PDP-0200E	SUMP PUMP CONTROL PANEL FHA-WWW-CP-6230	RMF & SERVICE BUILDING (NOTE 6)	DWG E207
D2	FHA-ELS-PDP-0200E	SUMP PUMP CONTROL PANEL FHA-WWW-CP-6240	RMF & SERVICE BUILDING (NOTE 6)	DWG E207
E1	FHA-ELS-PDP-0300E	FHA-ELS-PDP-0200E	FROM PUMPING STATION TO RMF BUILDING	DWG E205, E207, E208
G1	GENERATOR 1 FHA-ELS-GEN-0100	FHA-ELS-TS-0300	FROM RMF PIPE GALLERY TO SWITCHGEAR ROOM PUMP BUILDING	DWG E201, E205, E207, E209

NOTES:

1. PROVIDE NEW AND COMPLETE OVERHEAD CABLE TRAY SYSTEM FOR ALL NEW POWER AND CONTROL CABLE AND WIRING AS REQUIRED TO INTERCONNECT EQUIPMENT. USE OF EXISTING CABLE TRAYS WILL ONLY BE ACCEPTED IF SUFFICIENT SPACE IS AVAILABLE AND THE RESULTING FILL AREA DOES NOT EXCEED THE OESC CODE REQUIREMENTS. MAXIMUM ALLOWABLE FILL AREA NOT TO BE EXCEEDED.
2. PROVIDE SEPARATE CABLE TRAYS OR ACCEPTABLE BARRIER FOR CONDUCTORS OF 600VAC POWER, ELECTRICAL LIGHTING, 120VAC CONTROL AND SIGNAL WIRING.
3. UNLESS OTHERWISE INDICATED, ALL CONDUCTORS ARE TO BE COPPER AND ALL POWER CABLES ARE TO BE TECK90.
4. REFER TO DWG E143 FOR NEW STANDBY FHA-ELS-PDP-0200E SINGLE LINE DIAGRAM AND CABLE SCHEDULE.
5. REFER TO DWG E144 FOR NEW STANDBY PDP ELEVATION LAYOUT.
6. CONTRACTOR TO FIELD VERIFY EXISTING SUMP PUMP CONTROL PANEL LOCATIONS.
7. FLOOR/WALL TO BE CORE-DRILLED TO MAKE NEW HOLES TO RUN NEW CABLES. VNEW CABLES TO BE SUPPORTED AND PROTECTED PROPERLY.
8. SUITABLE CORING LOCATION TO BE IDENTIFIED PRIOR TO DRILLING TO PREVENT ANY INTERFERENCE WITH EXISTING EQUIPMENT, PIPES AND CONDUITS IN THE SWITCHGEAR ROOM.
9. ALL HOLES TO BE PATCHED AND FILLED. THEY SHALL BE RESTORED TO THE SAME FLOOR CONDITION AS PRIOR TO DRILLING.

ELECTRICAL FLOOR PLAN - RMF & SERVICE BUILDING (EL. 83.00)

1:200

EXISTING
NEW
REMOVAL, TO BE
REPLACED WITH
NEW CABLES &
INSTALLED COMPLETE

Toronto Water

Toronto

TORONTO WATER

ENGINEERING AND CONSTRUCTION SERVICES

WILLIAM FERNANDES, P.ENG
DIRECTOR
WATER TREATMENT AND SUPPLY

SIMON HOPTON, P. ENG.
DIRECTOR
DESIGN & CONSTRUCTION
MAJOR INFRASTRUCTURE

R.C. HARRIS WATER TREATMENT PLANT
INSTALLATION OF A STANDBY GENERATOR FOR CRITICAL LOADS
ELECTRICAL FLOOR PLAN - RMF & SERVICE BUILDING


ELECTRICAL


DESIGN:	SC	DRAFTING:	SC	CHECK:	TS	CONTRACT No.	25ECS-MI-03HA
SCALE:	1:200			DRAWING	NUMBER:		
DATE:	2024-09-30			2F-2017-08-69			E207

ARCADIS
100-175 GALAXY BOULEVARD
TORONTO, ONTARIO, M9W 0C9
TEL 416 679 1930 FAX 416 675 4620
www.arcadis.com

COPYRIGHT:
This drawing has been prepared solely for the intended use, and any reproduction or distribution for any purpose other than authorized by ARCADIS is forbidden. Written dimensions shall have precedence over scaled dimensions. Contractors shall verify and be responsible for all dimensions and conditions on the job, and ARCADIS shall be informed of any variations from the dimensions and conditions shown on the drawing. Shop drawings shall be submitted to BII Group for general conformance before proceeding with fabrication.
ARCADIS Professional Services (Canada) Inc.


A	2025-03-18	ISSUED FOR TENDER		T.S.	
NO.	DATE	REVISIONS		INITIAL	SIGNED

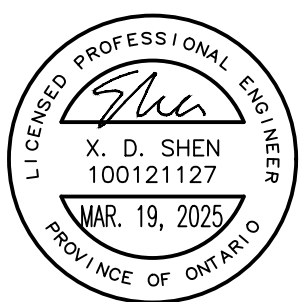

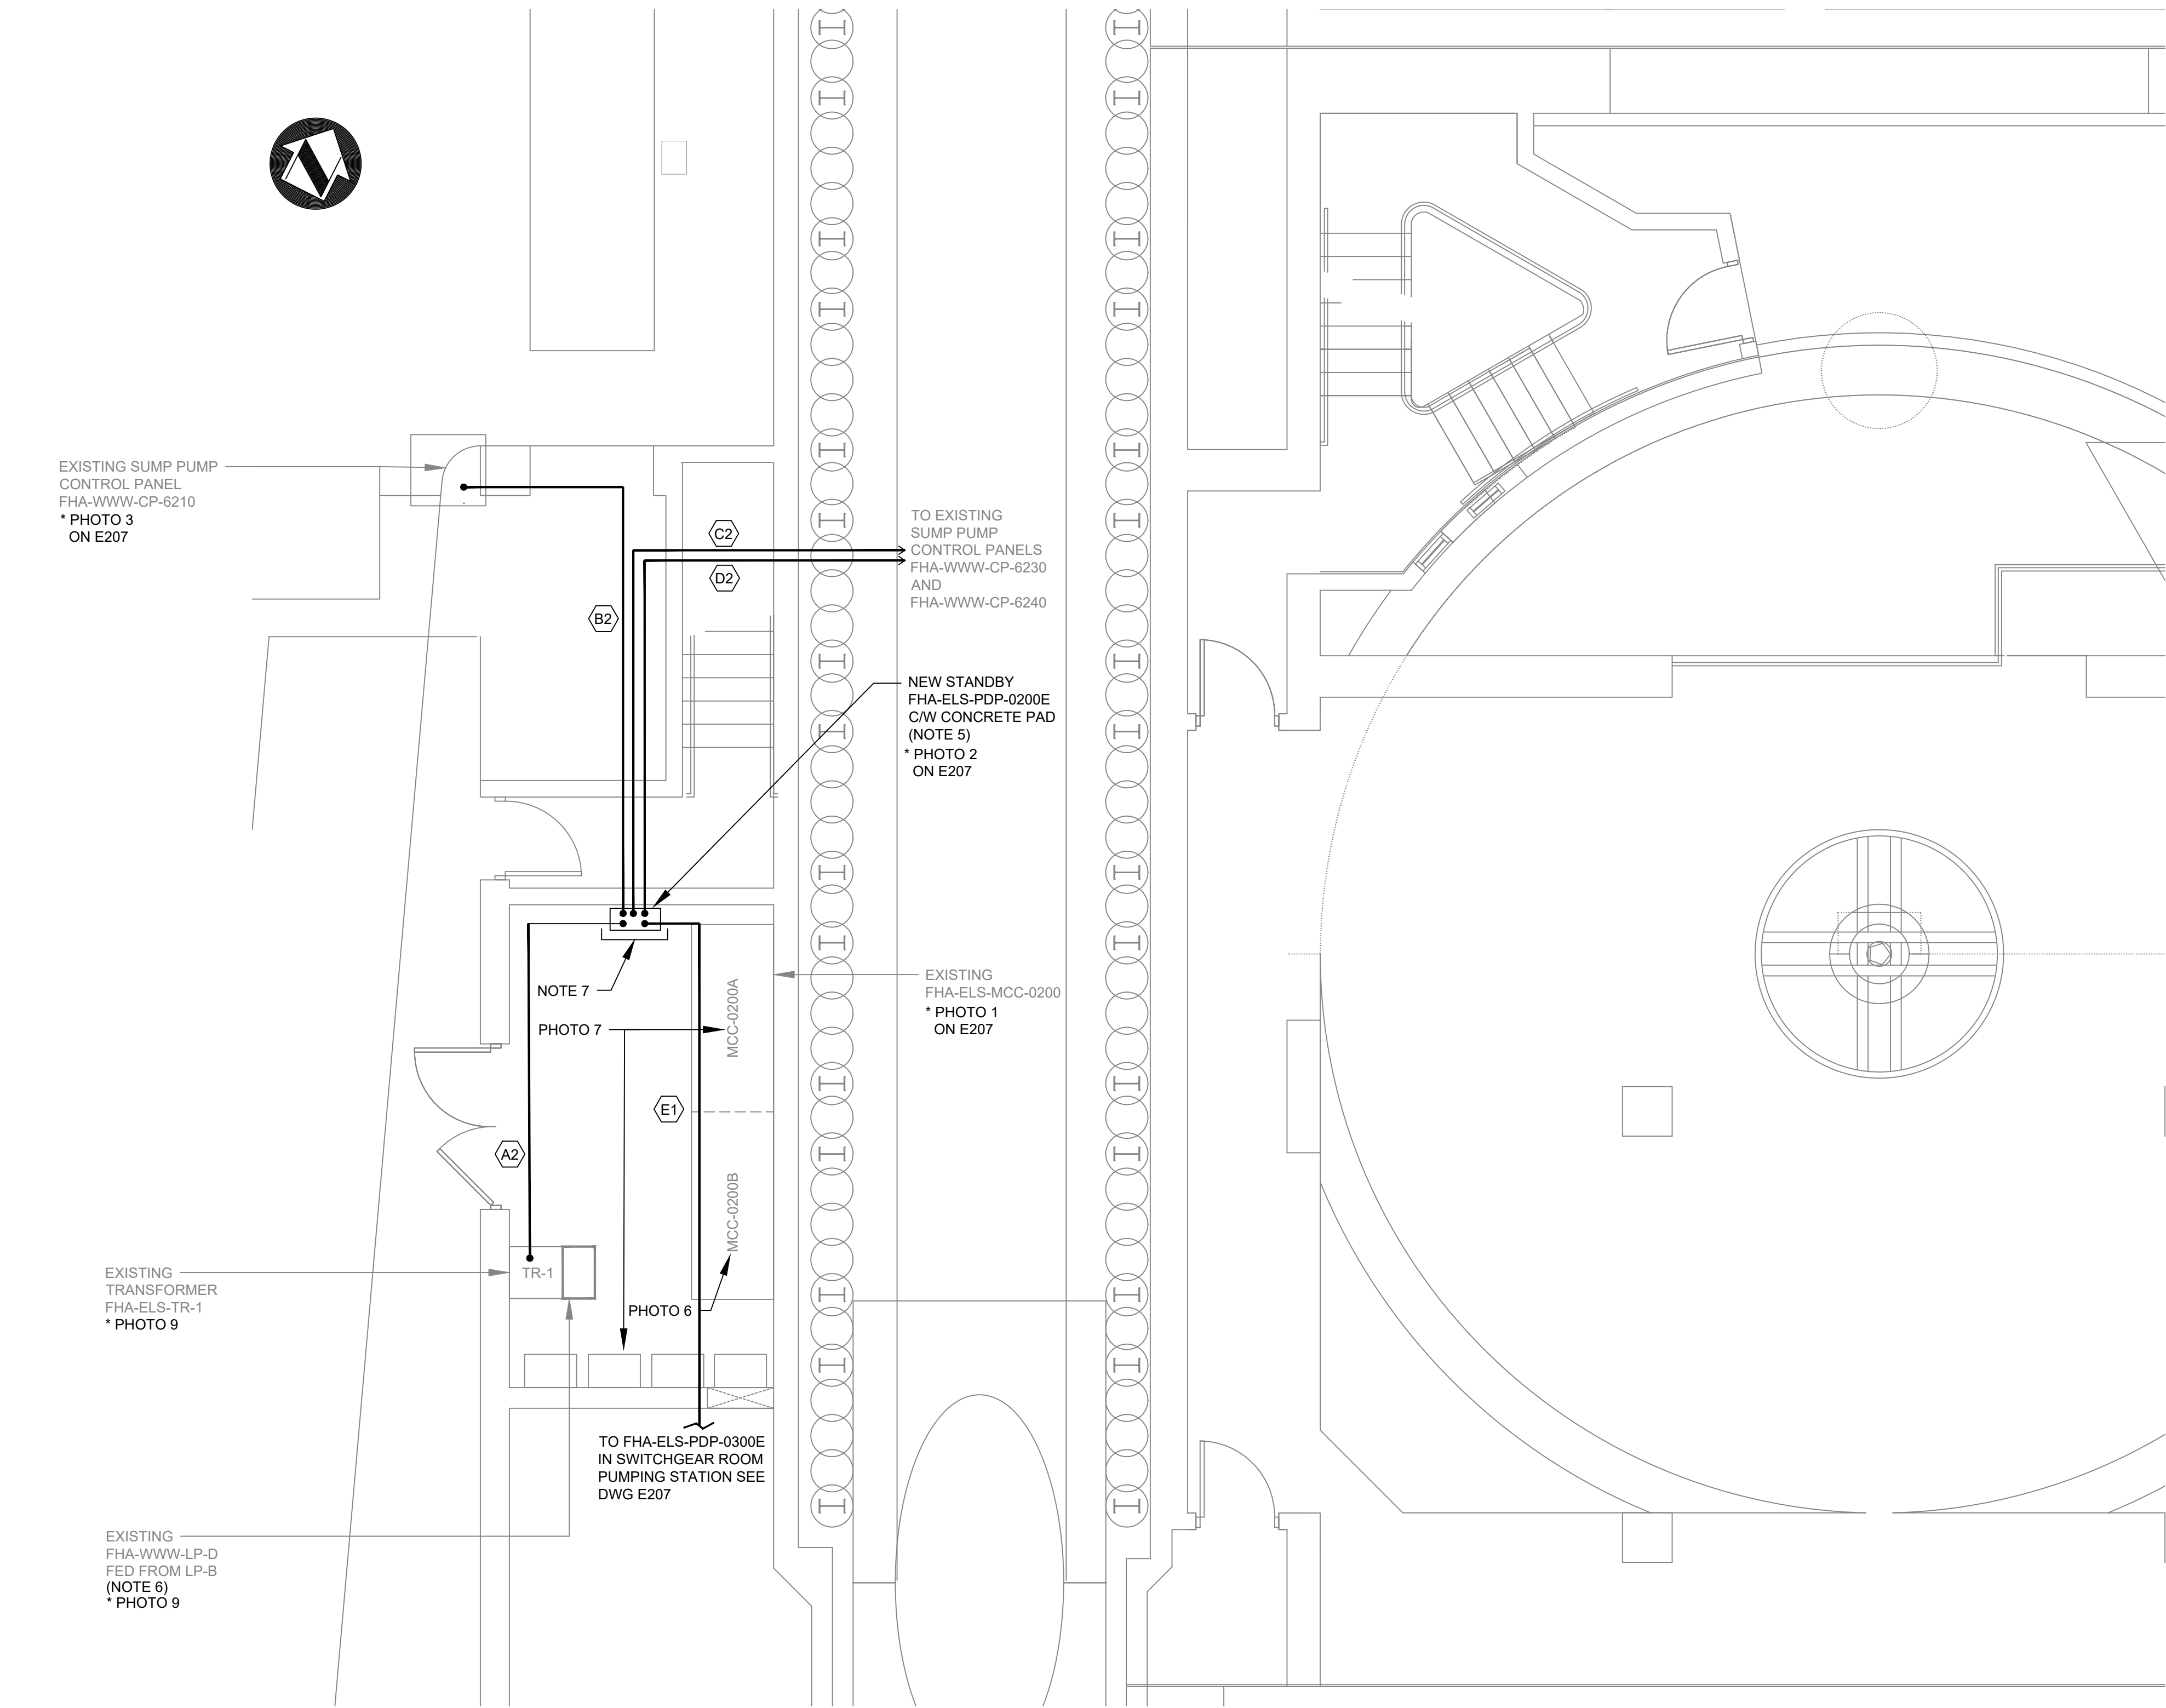

ELECTRICAL FLOOR PLAN - DETAIL 'A' - RMF & SERVICE BUILDING (EL. 83.00)

1:50

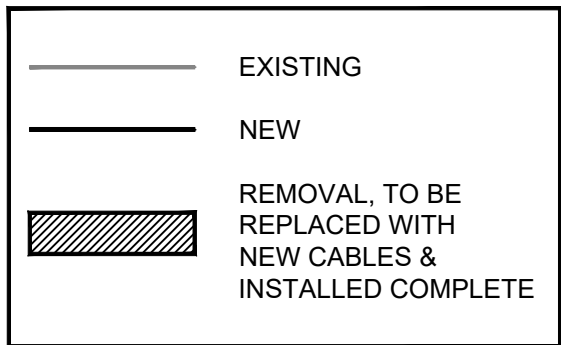

NOTES:

- PROVIDE NEW AND COMPLETE OVERHEAD CABLE TRAY SYSTEM FOR ALL NEW POWER AND CONTROL CABLE AND WIRING AS REQUIRED TO INTERCONNECT EQUIPMENT. USE OF EXISTING CABLE TRAYS WILL ONLY BE ACCEPTED IF SUFFICIENT SPACE IS AVAILABLE AND THE RESULTING FILL AREA DOES NOT EXCEED THE OESC CODE REQUIREMENTS. MAXIMUM ALLOWABLE FILL AREA NOT TO BE EXCEEDED.
- PROVIDE SEPARATE CABLE TRAYS OR ACCEPTABLE BARRIER FOR CONDUCTORS OF 600VAC POWER, ELECTRICAL LIGHTING, 120VAC CONTROL AND SIGNAL WIRING.
- UNLESS OTHERWISE INDICATED, ALL CONDUCTORS ARE TO BE COPPER AND ALL POWER CABLES ARE TO BE TECK90.
- REFER TO DWG E143 FOR NEW STANDBY FHA-ELS-PDP-0200E SINGLE LINE DIAGRAM AND CABLE SCHEDULE.
- REFER TO DWG E144 FOR NEW STANDBY PDP ELEVATION LAYOUT.
- REFER TO PHOTO 6 ON DWG E207.
- PROVIDE 2' WIDE ELECTRICAL INSULATION MAT COVERING THE FULL LENGTH OF THE EQUIPMENT.



PHOTO 7



PHOTO 8


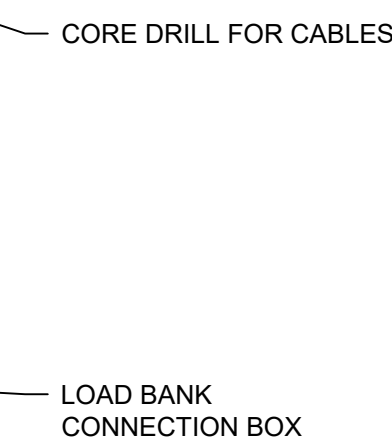


PHOTO 9

CABLE ROUTING TABLE

#	FED FROM	TO	LOCATION	REFERENCE
A2	FHA-ELS-PDP-0200E	TRANSFORMER FHA-ELS-TR-1	RMF BUILDING	DWG E208
B2	FHA-ELS-PDP-0200E	SUMP PUMP CONTROL PANEL FHA-WWW-CP-6210	RMF BUILDING (NOTE 6)	DWG E208
C2	FHA-ELS-PDP-0200E	SUMP PUMP CONTROL PANEL FHA-WWW-CP-6230	RMF & SERVICE BUILDING (NOTE 6)	DWG E207
D2	FHA-ELS-PDP-0200E	SUMP PUMP CONTROL PANEL FHA-WWW-CP-6240	RMF & SERVICE BUILDING (NOTE 6)	DWG E207
E1	FHA-ELS-PDP-0300E	FHA-ELS-PDP-0200E	FROM PUMPING STATION TO RMF BUILDING	DWG E205, E207, E208

								TORONTO WATER ENGINEERING AND CONSTRUCTION SERVICES		R.C. HARRIS WATER TREATMENT PLANT INSTALLATION OF A STANDBY GENERATOR FOR CRITICAL LOADS ELECTRICAL FLOOR PLAN - DETAIL 'A' - RMF & SERVICE BUILDING	
								WILLIAM FERNANDES, P. ENG. DIRECTOR WATER TREATMENT AND SUPPLY			
COPYRIGHT: This drawing has been prepared solely for the intended use. Thus, any reproduction or distribution for any purpose other than authorized by ARCADIS is forbidden. Written dimensions shall have precedence over scaled dimensions. Contractors shall verify and be responsible for all dimensions and conditions on the job, and ARCADIS shall be informed of any variations from the dimensions and conditions shown on the drawing. Shop drawings shall be submitted to IRI Group for general conformance before proceeding with fabrication.		A		2025-03-18		ISSUED FOR TENDER		T.S.		ELECTRICAL	
100-175 GALAXY BOULEVARD TORONTO, ONTARIO, M9W 0C9 TEL 416 679 1930 FAX 416 675 4620 www.arcadis.com		NO.		DATE		REVISIONS		INITIAL		SIGNED	
ARCADIS Professional Services (Canada) Inc.										DESIGN: SC DRAFTING: SC CHECK: TS CONTRACT No. 25ECS-MI-03HA	
										SCALE: 1:50 DRAWING NUMBER: 2F-2017-08-70 DATE: 2024-09-30	
										E208	

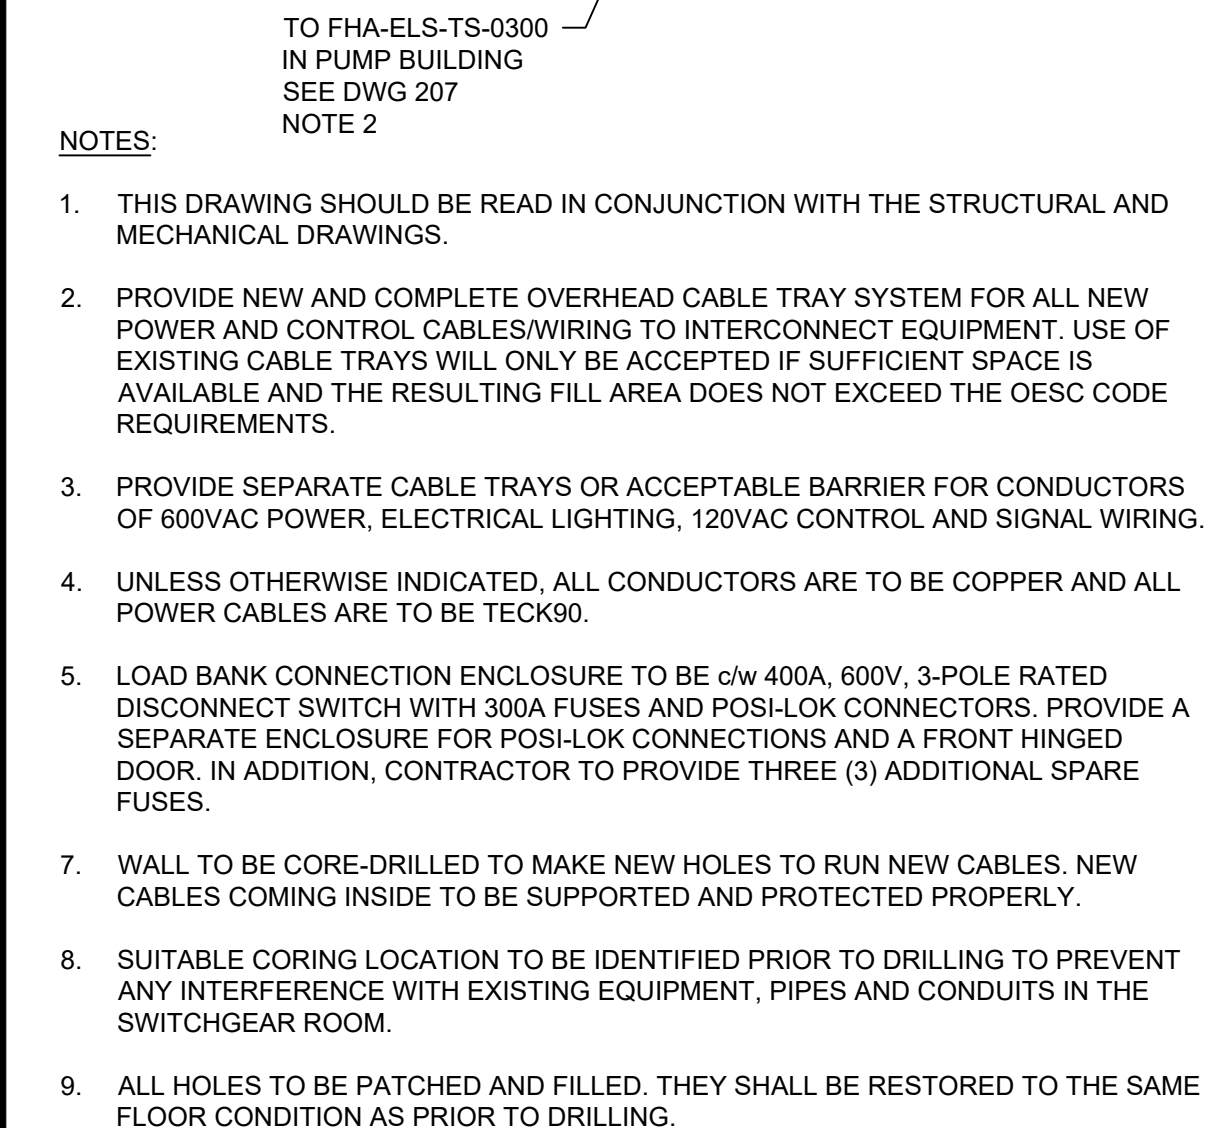

ELECTRICAL FLOOR PLAN - CHEMICALS ROOM. PIPE GALLERY
N.T.S.

— EXISTING
— NEW

[illegible]



PHOTO 1

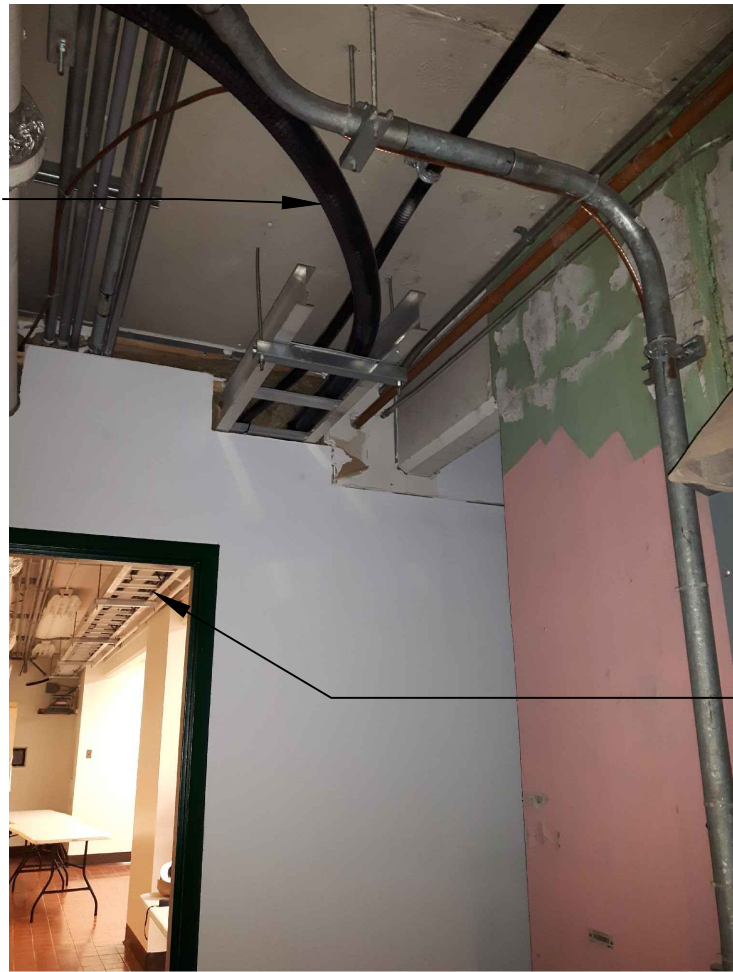


PHOTO 2



PHOTO 3

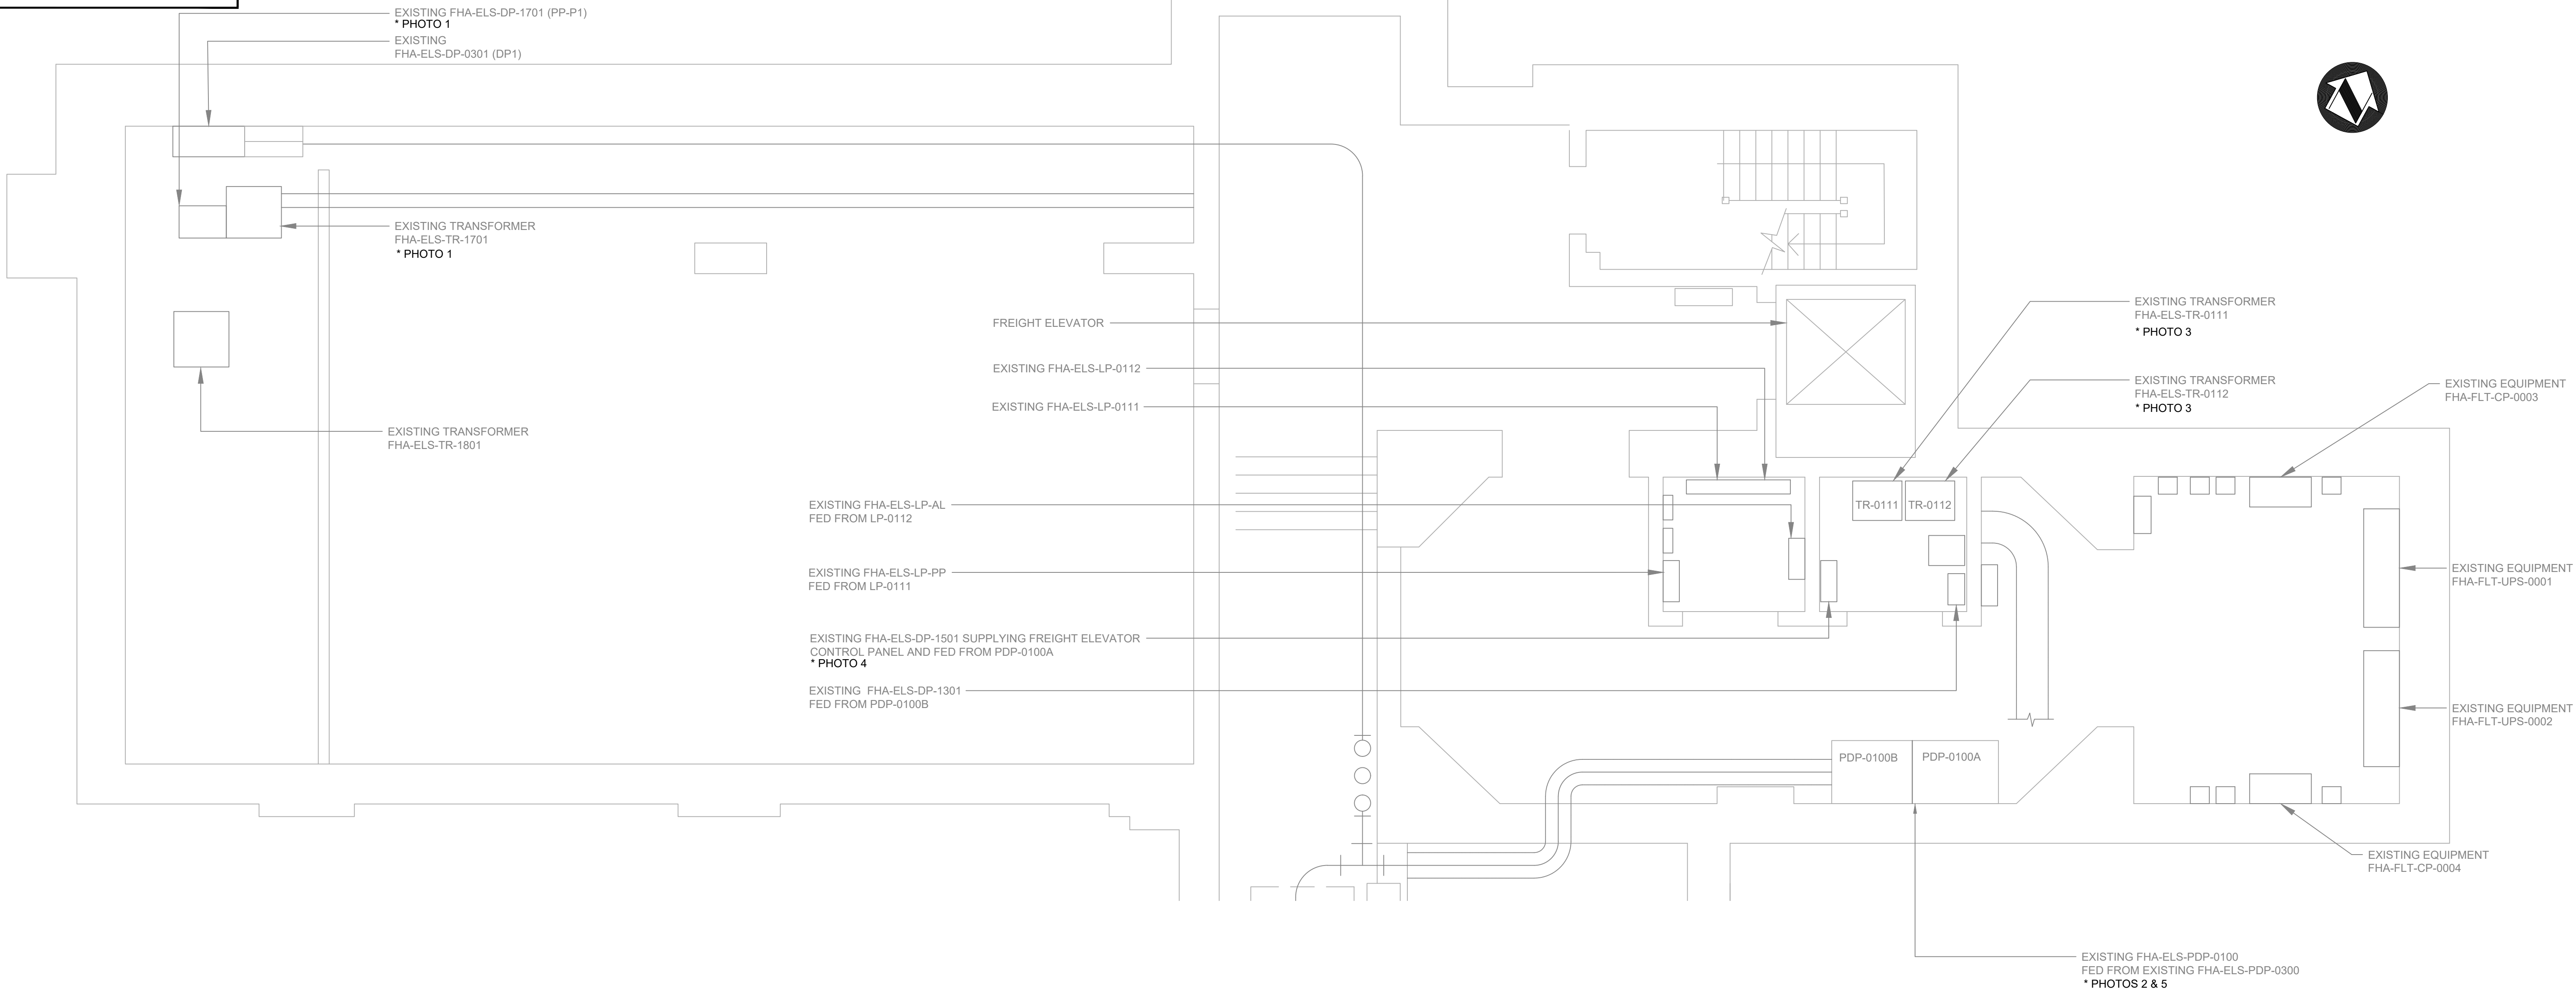


PHOTO 4



PHOTO 5

METRIC
MEASUREMENTS SHOWN ON THESE PLANS
ARE IN MILLIMETERS UNLESS OTHERWISE NOTED



ELECTRICAL FLOOR PLAN - SERVICE BUILDING BASEMENT (EL.75.59)
SCALE: 1:50

—	EXISTING
—	NEW
	REMOVAL, TO BE REPLACED WITH NEW CABLES & INSTALLED COMPLETE

								TORONTO WATER ENGINEERING AND CONSTRUCTION SERVICES		R.C. HARRIS WATER TREATMENT PLANT INSTALLATION OF A STANDBY GENERATOR FOR CRITICAL LOADS ELECTRICAL FLOOR PLAN - SERVICE BUILDING BASEMENT									
								WILLIAM FERNANDES, P. ENG. DIRECTOR WATER TREATMENT AND SUPPLY						SIMON HOPTON, P. ENG. DIRECTOR DESIGN & CONSTRUCTION MAJOR INFRASTRUCTURE					
COPYRIGHT: This drawing has been prepared solely for the intended use. Thus, any reproduction or distribution for any purpose other than authorized by ARCADIS is forbidden. Written dimensions shall have precedence over scaled dimensions. Contractors shall verify and be responsible for all dimensions and conditions on the job, and ARCADIS shall be informed of any variations from the dimensions and conditions shown on the drawing. Shop drawings shall be submitted to the Client for general conformance before proceeding with fabrication.												ELECTRICAL							
100-175 GALAXY BOULEVARD TORONTO, ONTARIO, M9W 0C9 TEL 416 679 1930 FAX 416 675 4620 www.arcadis.com		A		2025-03-18		ISSUED FOR TENDER		T.S.				DESIGN: SC		DRAFTING: SC		CHECK: TS		CONTRACT No. 25ECS-MI-03HA	
		NO.		DATE		REVISIONS		INITIAL		SIGNED				SCALE: 1:50		DRAWING NUMBER: 2F-2017-08-72		E211	
														DATE: 2024-09-30					

Drawing: J:\M16-0273 TOR_HARRISWTP-STANDBYGENERATOR\500_CAD\401-CAD\1-SS OR BU\SHEET\6 ELEC\2F-2017-08-72-E211.DWG
Layout: 03/19/2025
Date: 03/19/2025
Time: 12:41:35 PM


PHOTO 2
SCALE: N.T.S.

EXISTING CONTROL PANEL FHA-FLT-CP-0005.
RENAME PANEL TO FHA-FLT-JB-0005. PROVIDE
TERMINALS AND EXTEND WIRING C/W CONDUITS TO
NEW FHA-FLT-CP-0006 LOCATION.

NEW CONTROL PANEL
FHA-FLT-CP-0005. REFER
TO I&C DRAWING I106 FOR
DETAILS

NOTE:

 
1. PROVIDE 1-2C #14 FROM NEW FHA-FLT-CP-0005 TO EXISTING FHA-FLT-UPS-0001 VIA EXISTING JUNCTION BOX FHA-FLT-JB-0005. REUSE EXISTING CONDUITS BETWEEN EXISTING UPS-0001 AND JB-0005.



ELECTRICAL FLOOR PLAN - WEST LOWER FILTER PIPE GALLERY (EL. 94.06)
N.T.S.

— EXISTING
— NEW

NO.	DATE	REVISIONS	INITIAL	SIGNED

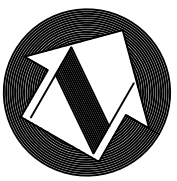

EXISTING CONTROL PANEL
FHA-FLT-CP-0006



PHOTO 1
SCALE: N.T.S.




PHOTO 2
SCALE: N.T.S.

EXISTING CONTROL PANEL
FHA-FLT-CP-0006. RENAME PANEL
TO FHA-FLT-JB-0006. PROVIDE
TERMINALS AND EXTEND WIRING
C/W CONDUITS TO NEW
FHA-FLT-CP-0006 LOCATION.

NEW CONTROL PANEL
FHA-FLT-CP-0006. REFER TO I&C
DRAWING I107 FOR DETAILS

NOTE:

1. PROVIDE 1-2C #14 FROM NEW FHA-FLT-CP-0006 TO EXISTING FHA-FLT-UPS-0002 VIA EXISTING JUNCTION BOX FHA-FLT-JB-0006. REUSE EXISTING CONDUITS BETWEEN EXISTING UPS-0002 AND JB-0006.

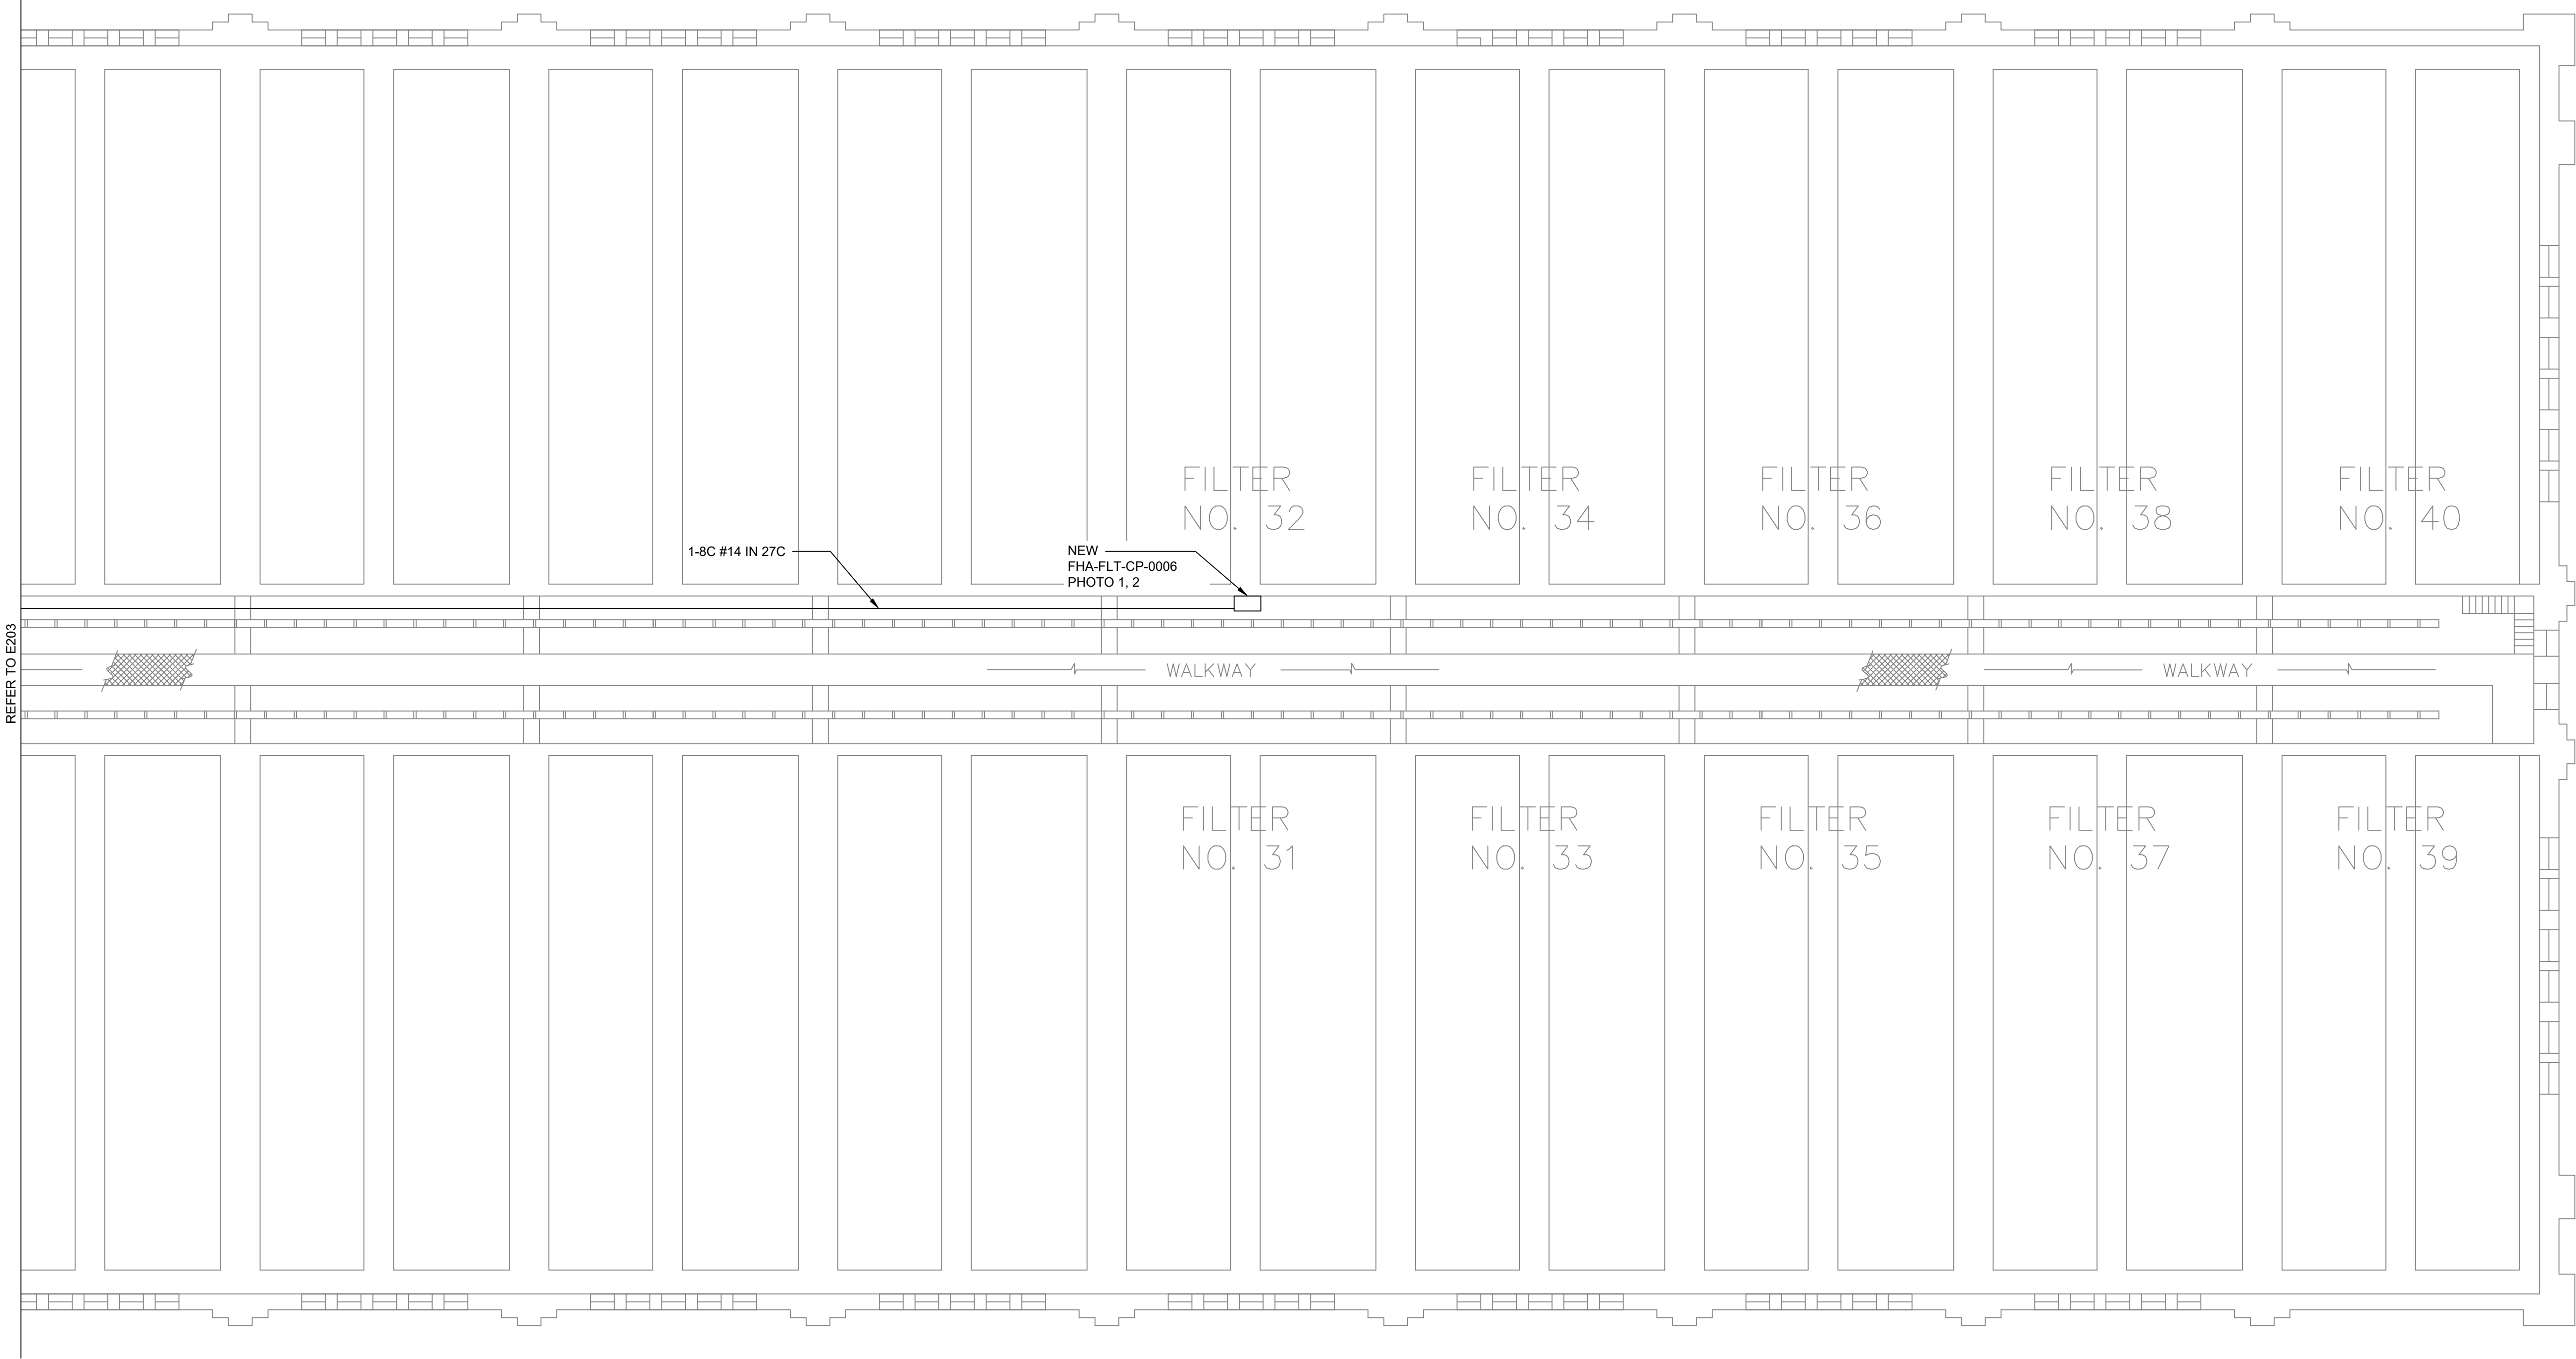

ELECTRICAL FLOOR PLAN - EAST LOWER FILTER PIPE GALLERY (EL. 94.06)
N.T.S.

---	EXISTING
---	NEW

Drawing: J:\M16-0273 TOR_HARRISWTP-STANDBYGENERATOR\500_CAD\401-CAD\1-SS OR BU\SHEET\6 ELEC\2F-2017-08-74-E213.DWG
Layout: 03/19/2025
Date: 03/19/2025
Time: 12:42:00 PM

								TORONTO WATER ENGINEERING AND CONSTRUCTION SERVICES		R.C. HARRIS WATER TREATMENT PLANT INSTALLATION OF A STANDBY GENERATOR FOR CRITICAL LOADS ELECTRICAL FLOOR PLAN - LOWER FILTER PIPE GALLERY - EAST (EL. 94.06)							
								WILLIAM FERNANDES, P. ENG. DIRECTOR WATER TREATMENT AND SUPPLY						SIMON HOPTON, P. ENG. DIRECTOR DESIGN & CONSTRUCTION MAJOR INFRASTRUCTURE			
COPYRIGHT: This drawing has been prepared solely for the intended use. Thus, any reproduction or distribution for any purpose other than authorized by ARCADIS is forbidden. Written dimensions shall have precedence over scaled dimensions. Contractors shall verify and be responsible for all dimensions and conditions on the job, and ARCADIS shall be informed of any variations from the dimensions and conditions shown on the drawing. Shop drawings shall be submitted to the Client for general conformance before proceeding with fabrication.										ELECTRICAL							
ARCADIS Professional Services (Canada) Inc.										DESIGN: SC		DRAFTING: SC		CHECK: TS		CONTRACT No. 25ECS-MI-03HA	
										SCALE: N.T.S.		DRAWING NUMBER: 2F-2017-08-74		E213			
										DATE: 2024-09-30							

INSTRUMENT IDENTIFICATION TABLE

ISA-S5.1-1984

LETTER	FIRST LETTER	MODIFIER	SUCCESSING LETTERS	MODIFIER
A	ANALYSIS (2)		ALARM	
B	BURNER, COMBUSTION		CLOSE, STOP, DECREASE (1)	
C			CONTROL	
D	DENSITY	DIFFERENTIAL	OPEN, START, INCREASE (1)	
E	VOLTAGE		SENSOR (PRIMARY ELEMENT)	
F	FLOW RATE	RATIO (FRACTION)		FAIL (1)
G			GLASS VIEWING DEVICE	
H	HAND			HIGH (OPENED)
I	CURRENT (ELECTRICAL)		INDICATE	
J	POWER	SCAN		
K	TIME, TIME SCHEDULE	TIME RATE OF CHANGE		
L	LEVEL		LIGHT	LOW (CLOSED)
M	MOTOR, MOTION (1)	MOMENTARY		MIDDLE OR INTERMEDIATE
N				ON OR OPERATE (1)
O			ORIFICE, RESTRICTION	OVERLOAD (1)
P	PRESSURE, VACUUM		POINT (TEST) CONNECTION	
Q	QUANTITY (2)	INTEGRATE, TOTALIZE		
R	RADIATION		RECORD	
S	SPEED, FREQUENCY	SAFETY		SWITCH
T	TEMPERATURE		TRANSMIT	
U	MULTI-VARIABLE (2)		MULTI-FUNCTION (2)	MULTI-FUNCTION (2)
V	VIBRATION, MECHANICAL ANALYSIS		VALVE, DAMPER, LOUVER	
W	WEIGHT, FORCE		WELL	
X	UNCLASSIFIED (2)		UNCLASSIFIED (2)	UNCLASSIFIED (2)
Y	EVENT, STATE, PRESENCE		RELAY, COMPUTE, CONVERT	
Z	POSITION, DIMENSION		DRIVER, ACTUATOR, UNCLASSIFIED FINAL CONTROL ELEMENT	


(1) USER'S CHOICE
(2) WHEN USED, SYMBOL OR SIGNAL LINE IS ANNOTATED.

FLOW STREAM IDENTIFICATION

— AM — AQUA AMMONIA	— FOAR — FOUL AIR RETURN	— SCA — SHAFT COOLING AIR
— AHP — AIR, HIGH PRESSURE PROCESS	— FOR — FUEL OIL RETURN	— SCNAR — SHAFT COOLING AIR NOT RETURN
— AIS — AIR, INSTRUMENT SUPPLY	— FOS — FUEL OIL SUPPLY	— SCAR — SHAFT COOLING AIR RETURN
— ALM — ALUM	— FRF — FILTER RPPENING/RECYCLE	— SCR — SCREEN
— ALP — AIR, LOW PRESSURE PROCESS	— FSC — FERROUS CHLORIDE	— SCM — SCUM
— ASH — ASH	— FWD — FILTER TO WASTE	— SDG — SULFUR DIOXIDE GAS
— ATM — ATMOSPHERE		— SDL — SULFUR DIOXIDE LIQUID
— BCA — BURNER COMBUSTION AIR	— GR — GRIT	— SDR — SANITARY DRAIN
— BFE — BIO-FILTER EFFLUENT	— GRS — GREASE	— SDS — SULFUR DIOXIDE SOLUTION
— BFR — BIO-FILTER RECYCLE	— HC — HYPOCHLORITE	— SE — SECONDARY EFFLUENT
— BLS — BLENDED SLUDGE	— HG — HYDROGEN GAS	— SES — SETTLED SOLIDS
— BR — BRINE	— HL — LIQUID HYDROGEN	— SEW — SETTLED WATER
— BRB — BRINE SLUDGE	— HPC — HIGH PRESSURE CONDENSATE	— SHS — SETTLED HEATED SLUDGE
— BRSP — BRINE, SPENT	— HPS — HIGH PRESSURE STEAM	— SL — SLURRY
— BVP — BYPASS	— HTS — HEAT TREATED SLUDGE	— SMP — SAMPLE
— CAU — CAUSTIC	— HWR — HEATING WATER RETURN	— SPD — SUMP PUMP DISCHARGE
— CC — CENTRIFUGE CAKE	— HWS — HEATING WATER SUPPLY	— SSL — SECONDARY SLUDGE
— CDG — CARBON DIOXIDE GAS		— STM — STEAM
— CDL — CARBON DIOXIDE LIQUID	— INF — INFILTRANT	— STR — STRAINER
— CEN — CENTRATE	— IW — IRRIGATION WATER	— STW — STORM WATER
— CGA — CARBON GRANULATED ACTIVATED	— LM — LIME, DRY	— SUB — SUB NANTANT
— CH — CHEMICAL	— LMS — LIME SLURRY	— SUP — SUPERNATANT
— CKE — CAKE	— LMSD — LIME SLUDGE	— SW — SEAL WATER
— CLG — CHLORINE GAS	— LO — LUBRICATION OIL	— SWW — SCREEN WASTEWATER SLUDGE
— CLL — CHLORINE LIQUID	— LPC — LOW PRESSURE CONDENSATE	— TAS — THICKENED ACTIVATED SLUDGE
— CLS — CHLORINE SOLUTION	— LPS — LOW PRESSURE STEAM	— TBS — THICKENER BOTTOM SLUDGE
— CON — CONDENSATE	— MG — METHANE GAS	— TO — THICKENER OVERFLOW
— CPA — CARBON POWDERED ACTIVATED	— ML — MIXED LIQUOR	— TPS — THICKENED PRIMARY SLUDGE
— CS — CLARIFIED SLUDGE	— MXS — MIXED SLUDGE	— TR — THICKENER RECYCLE
— CSL — CARBON SLURRY	— NAH — SODIUM HYDROXIDE	— TRS — THICKENED SLUDGE
— CWR — COOLING WATER RETURN	— NG — NATURAL GAS	— TRS — TRAVELLING SCREEN RESIDUE
— CWS — COOLING WATER SUPPLY	— NG — NITROGEN GAS	— TSUP — THICKENER SUPERNATANT
		— TUF — THICKENED UNDER FLOW
— DCL — DECANT LIQUOR	— OF — OVERFLOW	— UD — UNDER DRAIN
— DCT — DECANT	— OG — OXYGEN GAS	— UNW — UN-WATERING LINE
— DG — DIGESTER GAS	— OL — LIQUID OXYGEN	— VAC — VACUUM
— DR — DECANT RESIDUE	— OZN — OZONE	— VT — VENT
— DRAIN — DRAIN		
— DS — DIGESTED SLUDGE	— PD — PROCESS DRAIN	— WAW — WASH WATER
— DTR — DECANT TANK RESIDUE	— PG — PROPANE GAS	— WAS — WASTE ACTIVATED SLUDGE
— DTS — DECANT TANK SUPERNATANT	— PHA — PHOSPHORIC ACID	— WSW — WATER, BACK WASH
— DWS — DEWATERED SLUDGE	— PRE — PRIMARY EFFLUENT	— WCL — WATER, CHLORINATED PLANT EFFLUENT
	— PRI — PRIMARY INFILTRANT	— WD — WATER, DISTILLED
— EFF — EFFLUENT	— PRS — PRIMARY SLUDGE	— WDO — WATER, DEOZONATED
— EMA — EMISSION AIR	— PYD — POLYMER DRY	— WHF — HOT WATER FLUSHING
— ENG — EXHAUST GAS	— PYS — POLYMER SOLUTION	— WML — WASTE MIXED LIQUOR
— FA — FRESH AIR		— WO — WATER, OZONATED
— FC — FERRIC CHLORIDE	— RAS — RETURN ACTIVATED SLUDGE	— WP — WATER, POTABLE
— FCP — PICKLE LIQUOR	— RAW — RAW WATER	— WPS — WATER, PLANT SERVICES
— FES — FERROUS SULFATE	— RCY — RECYCLE	— WN — WATER, NON-POTABLE
— FG — FLUE GAS	— RI — RESIDUE INFILTRANT	— WSE — WATER, SCREENED EFFLUENT
— FHS — FLUORIDE	— RSE — RAW SEWAGE	— WW — WELL WATER
— FIW — FINISHED WATER		— WWW — WATER, WASTE WATER
— FLE — FILTER EFFLUENT (FILTERED WATER)	— SLG — SLUDGE	
— FLT — FLUORIDE	— SA — SODA ASH	
— FLR — FLUORIDE	— SAS — SODA ASH SOLUTION	
— FLW — FILTER WASH WATER	— SBS — SODIUM BISULPHITE	
— FOA — FOUL AIR	— SBD — SEDIMENTATION BASIN DECANT	

* IDENTIFICATION MAY BE FOLLOWED BY A NUMBER TO DIFFERENTIATE AMONG SIMILAR FLOW STREAMS. FOR EXAMPLE, CH1 & CH2 WOULD REPRESENT TWO DIFFERENT CHEMICAL FLOW STREAMS.


INSTRUMENT & FUNCTION TAGGING

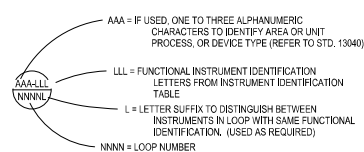

EQUIPMENT TAGGING



FLOW STREAM & INSTRUMENT LINE SYMBOLS

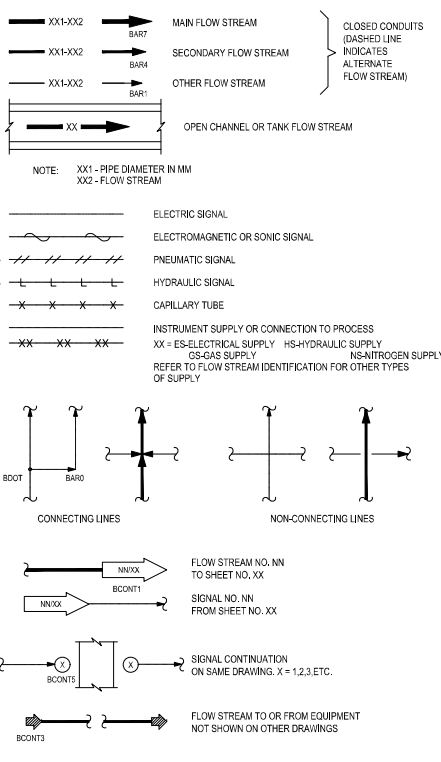

EXPLANATORY NOTATIONS

SIGNAL CONVERTERS

1Y	NOTE 1:	PROCESS OR INITIATING VARIABLE
2/3	NOTE 2/3:	A = ANALOG B = BINARY D = DIGITAL E = VOLTAGE F = FREQUENCY H = HYDRAULIC I = CURRENT
		M = MOTOR O = ELECTROMAGNETIC, SONIC P = PNEUMATIC PF = PULSE FREQUENCY PD = PULSE DURATION R = RESISTANCE

SMALL CIRCLE SIGNIFIES LOGICAL INVERSION OF SIGNAL.

HAND SWITCHES

NOTE XX:	AM = AUTOMANUAL CM = COMPUTER/MANUAL CAM = COMPUTER/AUTOMANUAL CL = COMPUTER/LOCAL F/R = FORWARD/REVERSE F/O/R = FORWARD/OFF/REVERSE F/S = FAST/SLOW F/O/S = FAST/OFF/SLOW H/O/A = HAND/OFF/AUTO L/R = LOCAL/REMOTE LOS = LOCKOUT STOP MFS = MODULATE FASTER/LOWER M/O/C = MODULATE OPEN/CLOSE O/C = OPEN/CLOSE O/O = ON/OFF O/S/C = OPEN/STOP/CLOSE S/S = START/STOP O/A/O = ON/AUTO/OFF N/M = NORMAL/MANUAL E/S = EMERGENCY/STOP N = NORMAL O = OPEN S = STOP C = CLOSE L = LOCAL
----------	---

ANALYSIS INSTRUMENTS

NOTE XX:	ALR = ALUMINUM RESIDUAL COL = COLOR ODG = CARBON DIOXIDE GAS CG = COMBUSTIBLE GAS CH4 = METHANE CLG = CHLORINE GAS CLR = CHLORINE RESIDUAL COG = CARBON MONOXIDE GAS DO = DISSOLVED OXYGEN FA = FREE AMMONIA FHS = FLUORIDE HC = HYDROCARBONS HUM = HUMIDITY H2S = HYDROGEN SULFIDE MHO = CONDUCTIVITY NOG = NITRIC OXIDE GAS NH4 = AMMONIA N2G = NITROGEN GAS OG = OXYGEN GAS ORP = OXIDATION REDUCTION POT. OUR = OXYGEN UPTAKE RATE OZG = OZONE GAS PC = PARTICLE COUNTER PH = pH SD = SOLIDS DENSITY SO2 = SULPHUR DIOXIDE GAS SS = SUSPENDED SOLIDS TMP = TEMPERATURE TOC = TOTAL ORGANIC CARBON TRB = TURBIDITY WT = WEIGHT
----------	---

MISCELLANEOUS

BRT = BEARING TEMPERATURE

NO.	DATE	REVISIONS	INITIAL	ISSUED FOR TENDER	C.H.	ISSUED
A	2024-03-18					

TORONTO WATER	
ENGINEERING AND CONSTRUCTION SERVICES	
WILLIAM FERNANDES, P. ENG. DIRECTOR WATER TREATMENT AND SUPPLY	SIMON HOPKIN, P. ENG. DIRECTOR DESIGN & CONSTRUCTION MAJOR INFRASTRUCTURE

R.C. HARRIS WATER TREATMENT PLANT INSTALLATION OF A STANDBY GENERATOR FOR CRITICAL LOADS LEGEND SHEET - 1

INSTRUMENTATION					
DESIGN:	M.D.	DRAFTING:	M.D.	CHECK:	J.G.C.
SCALE:	N.T.S.		DRAWING NUMBER:	2F-2017-08-75	
DATE:	2024-09-30		CONTRACT No.	25ECS-MI-03HA	
					1001

FLOW		LEVEL	
	ELECTROMAGNETIC		BUBBLE TUBE
	ULTRASONIC IN-LINE		ULTRASONIC
	ULTRASONIC CLAMP-ON OR DOPPLER		CAPACITANCE
	VENTURI		ELECTRODES (WITH HOLDER)
	ORIFICE PLATE		FLOAT
	PROPELLER OR TURBINE		OPTICAL
	VORTEX		
	TARGET		
	PITOT TUBE		
	ROTAMETER		
	AVERAGING PITOT TUBE		
	FLUME		
	WEIR		
	FLOW NOZZLE		
	ELECTROMAGNETIC CORIOLIS TYPE		
		TEMPERATURE	
			TEMPERATURE WITH WELL
			TEMPERATURE SURFACE MOUNT

	DIAPHRAGM SEAL		SELF-CONTAINED AIR SUPPLY
	ANNULAR DIAPHRAGM		PURGE SET NOTE X: W=WATER A=AIR
	RUPTURE DISK (PRESSURE RELIEF)		FLOW STRAIGHTENER
	RUPTURE DISK (VACUUM RELIEF)		TRAP
	VENT TO ATMOSPHERE		EQUIPMENT CONNECTION WITH ELECTRICAL INTERLOCK
	AIR GAP		SIGHT GLASS NOTE X: F=FLOW L=LEVEL
	DEVICE INTERFACE		PRESSURE GAUGE
	SIPHON BREAKER		Y TYPE STRAINER
	BLIND FLANGE		PULSATING DAMPER
	EXPANSION COUPLING		SCRUBBER
	CONCENTRIC REDUCER		
	ECCENTRIC REDUCER		
	UNION		
	VITALIC AIR COUPLING		
		NOTE X:	F=FLUSHING WATER L=LUBE OIL S=SEAL WATER

	BUTTERFLY VALVE		CONE VALVE
	CHECK VALVE		BALL VALVE
	GATE OR GENERAL IN-LINE VALVE		PLUG VALVE
	GLOBE VALVE		KNIFE GATE
	ROTARY VALVE		NEEDLE VALVE
	THREE WAY VALVE (ARROW IF SHOWN INDICATES FAIL OPEN PATH)		MUD VALVE
	TELESCOPING VALVE		BACK FLOW PREVENTER
	DAMPER OR LOUVER		PINCH VALVE
	SLUICE GATE		ANGLE VALVE
	PREFABRICATED SLIDE GATE		FOUR WAY VALVE
	FLAP VALVE		DIAPHRAGM VALVE
			BALANCING VALVE

	PRESSURE REDUCING REGULATOR WITH HAND WHEEL
	PRESSURE REDUCING REGULATOR WITH EXTERNAL PRESSURE TAP
	PRESSURE REDUCING VALVE WITH SOLENOID SHUTOFF
	DIFFERENTIAL PRESSURE REDUCING REGULATOR WITH INTERNAL AND EXTERNAL PRESSURE TAPS
	BACK PRESSURE REGULATOR SELF-CONTAINED
	BACK PRESSURE REGULATOR WITH EXTERNAL PRESSURE TAP
	PRESSURE REDUCING REGULATOR SELF-CONTAINED
	PRESSURE RELIEF OR SAFETY VALVE
	PRESSURE RELIEF OR SAFETY VALVE
	VACUUM RELIEF VALVE
	PRESSURE AND VACUUM RELIEF VALVE
	TEMPERATURE REGULATOR SELF-OPERATED
	AIR VENT

	FIELD MOUNTED		INTERLOCK LOGIC
	PILOT LIGHT		RESET
	FACE OF PANEL MOUNTED		AND LOGIC
	INTERIOR OF PANEL MOUNTED		OR LOGIC
	PANEL PILOT LIGHT		FIELD SWITCH
	MOTOR CONTROL CENTER MOUNTED		PANEL MOUNTED SWITCH
	INTERIOR OF MCC MOUNTED		MCC MOUNTED SWITCH
	MCC PILOT LIGHT		EXAMPLE OF INSTRUMENTS SHARING COMMON HOUSING

ANALOG INPUT	ANALOG OUTPUT
PULSE INPUT	PULSE OUTPUT X: BLANK = TIME DURATION (PULSE WIDTH) F = PULSE TRAIN T = TRIAC
DIGITAL INPUT	DIGITAL OUTPUT X: BLANK = MAINTAINED (ELECTRICALLY HELD) M = MOMENTARY L = LATCHED (MAGNETICALLY OR MECHANICALLY HELD)

NOTE:

YY: MEASURED VARIABLE OR OUTPUT FUNCTION
FROM INSTRUMENT IDENTIFICATION TABLE


YN: ON DIGITAL INPUT INDICATES COMPUTER-HAND
SWITCH STATUS

	CYLINDER		PRESSURE OR VACUUM RELIEF SPRING OR WEIGHT LOADED
	MOTOR		
	ELECTRO-PNEUMATIC		HYDRAMOTOR
	ELECTRO-HYDRAULIC		
	MANUAL (SHOWN ONLY FOR HAND OPERATED VALVES EQUIPPED WITH POSITION MONITORING INSTRUMENTS)		
	SOLENOID		
	DIAPHRAGM (SPRING OPPOSED)		
	DIAPHRAGM (PRESSURE BALANCED)		


XX: FO = FAIL OPEN
FC = FAIL CLOSED
FI = FAIL TO INTERMEDIATE POSITION
BLANK = FAIL TO LAST POSITION

Drawing: J:\MIG-0273 TOR-HARRISWP-STANDBYGENERATOR 600_CAD\01-CAD\1-SS OR BU\SHEET\7 I&C\2F-2017-08-77_003 LEGEND 3.DWG
Date: 03/21/2025
Time: 02:21:54 PM


EQUIPMENT SYMBOLS

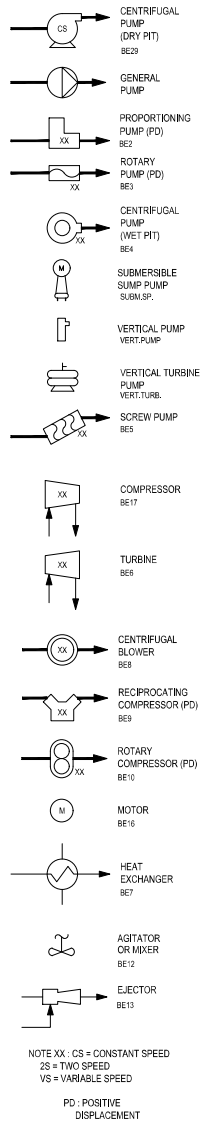

EQUIPMENT SYMBOLS

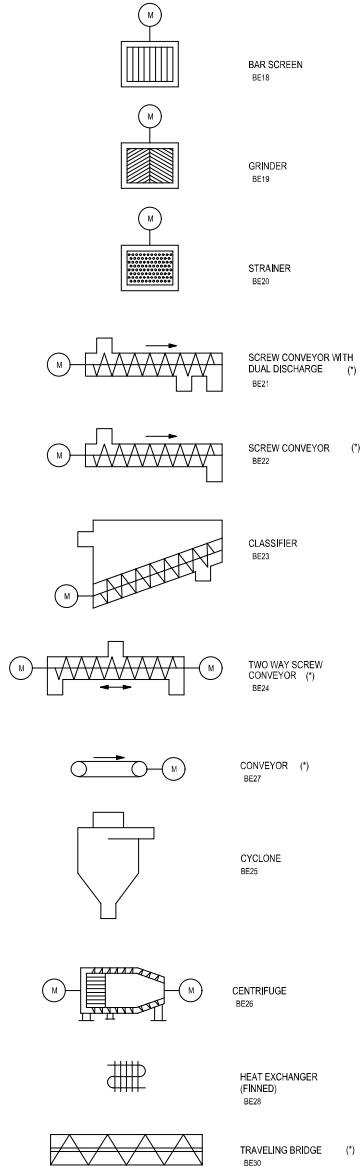


MISCELLANEOUS SYMBOLS

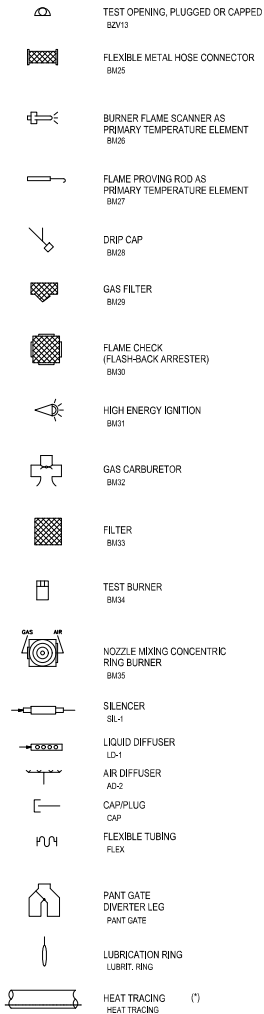

NOTE:
SYMBOLS SHOWN WITH A SINGLE ASTERISK (*) CAN BE EXTENDED HORIZONTALLY IF NEEDED.

PROCESS VENTILATION

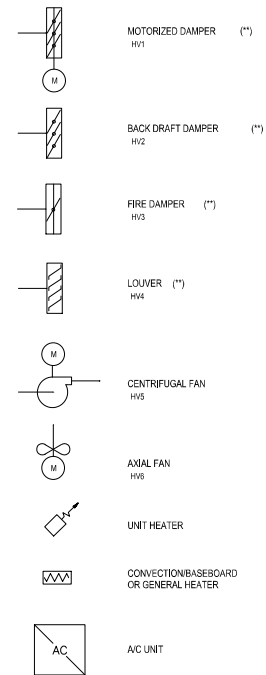

NOTE:
SYMBOLS SHOWN WITH A DOUBLE ASTERISK (**) CAN BE EXTENDED VERTICALLY IF NEEDED.

METRIC
MEASUREMENTS SHOWN ON THESE PLANS
ARE IN MILLIMETERS UNLESS OTHERWISE NOTED

GENERAL NOTES

- THIS IS A GENERAL P & ID SYMBOL SHEET. SOME SYMBOLS OR NOTATIONS MAY NOT BE USED ON THIS PROJECT.
- MOTOR CONTROL (MC) & VARIABLE SPEED DRIVE (VSD) PANELS ARE SHOWN WITH FACE OF PANEL MOUNTED INSTRUMENTS & EXTERNAL INTERFACE SIGNALS ONLY.
- A CONTROL PANEL (CP) PACKAGED WITH MECHANICAL EQUIPMENT OR A SYSTEM IS SHOWN WITH FACE OF PANEL MOUNTED INSTRUMENTS & EXTERNAL INTERFACE SIGNALS SIMILAR TO MC & VSD PANELS.
- CONTROL PANELS (CP) OTHER THAN THOSE PREVIOUSLY DESCRIBED ARE SHOWN WITH FACE & INTERIOR OF PANEL MOUNTED INSTRUMENTS.
- SEE ELECTRICAL DRAWINGS FOR MC & VSD LOCATIONS WITHIN THE MCC.
- EXISTING PIPING, EQUIPMENT & INSTRUMENTS ARE SHOWN LIGHT-LINED, SCREENED OR DOTTED.

(AB-1C) OLD TAG NUMBERS
ABC-1234 PCS INSTALLED TAG NUMBER
ABC-1234* PCS ASSIGNED TAG NUMBER
XXXXXX ITEMS TO BE REMOVED AND DISCONNECTED

Toronto Water

ARCADIS
100175 GALAXY BUILDING
TORONTO, ONTARIO, M9W 0G9
TEL 416 609 1000 FAX 416 675 4020
www.arcadis.com

COPYRIGHT:
This document has been prepared and/or for the client only. It is not to be used for any other purpose without the written permission of ARCADIS Professional Services (Canada) Inc. Any reproduction or distribution of this document without the written permission of ARCADIS Professional Services (Canada) Inc. is strictly prohibited. The design and construction of the project are the responsibility of the client. The design and construction of the project are the responsibility of the client. The design and construction of the project are the responsibility of the client.

NO.	DATE	REVISIONS	INITIAL	ISSUED
A	2025-03-18	ISSUED FOR TENDER	C.H.	

Toronto Water




WILLIAM FERNANDES, P. ENG.
DIRECTOR
WATER TREATMENT AND SUPPLY

TORONTO WATER
ENGINEERING AND CONSTRUCTION SERVICES

SMITH HOPTON, P. ENG.
DIRECTOR
DESIGN & CONSTRUCTION
MAJOR INFRASTRUCTURE

R.C. HARRIS WATER TREATMENT PLANT
INSTALLATION OF A STANDBY GENERATOR FOR CRITICAL LOADS
LEGEND SHEET - 3

DESIGN:	M.D.	DRAFTING:	M.D.	CHECK:	J.G.C.	CONTRACT No.	25ECS-MI-03HA
SCALE:		N.T.S.		DRAWING NUMBER:		2F-2017-08-77	1003
DATE:		2024-09-30					

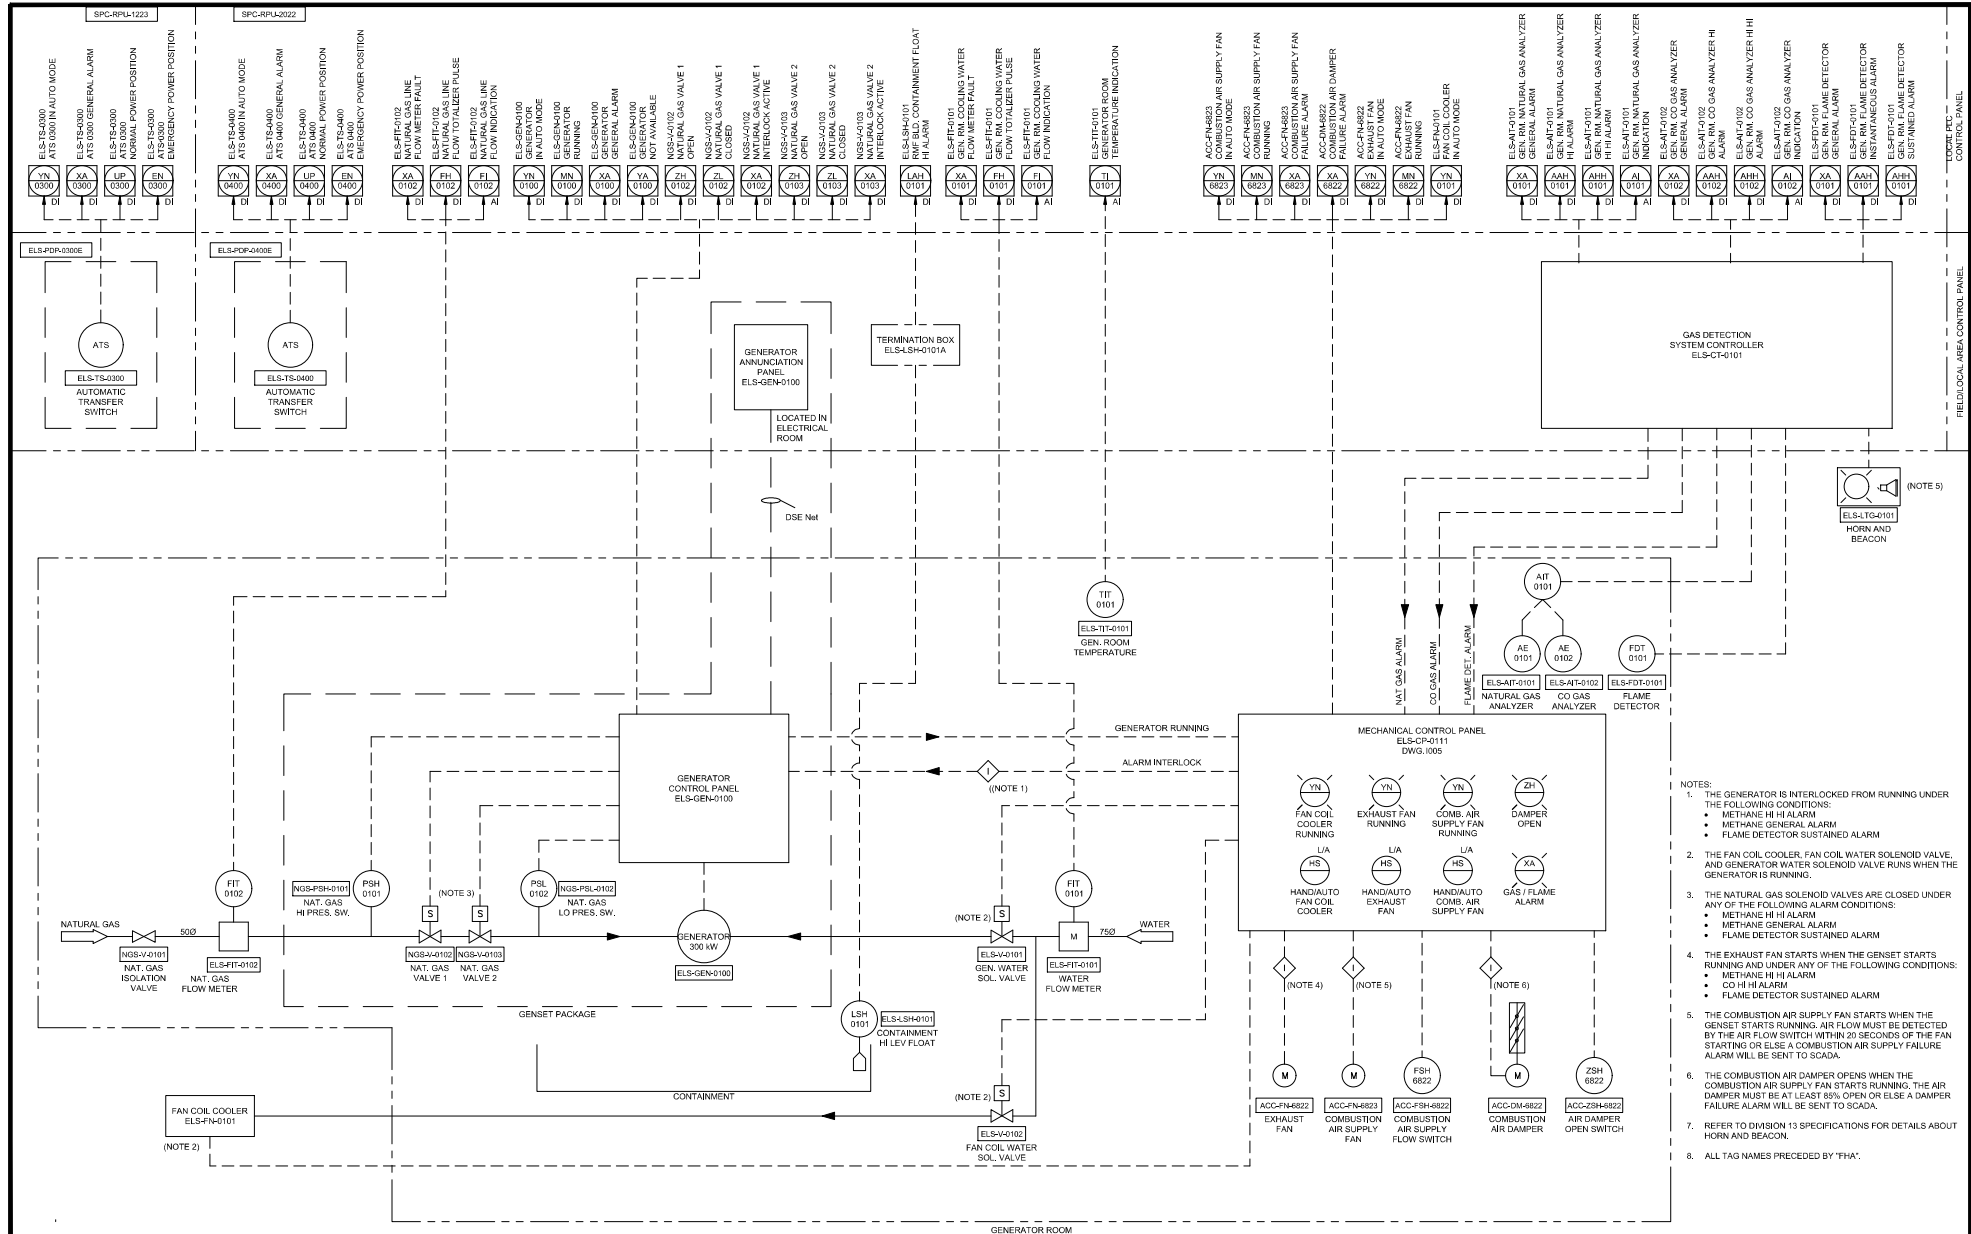

Toronto Water

ARCADIS
 10400 KENNEDY BOULEVARD
 TORONTO, ONTARIO, M3J 0C9
 TEL 416 679 1900 FAX 416 675 4820
 www.arcadis.com

COPYRIGHT:
 This drawing was prepared and/or for the construction. No part of this drawing may be reproduced or transmitted in any form or by any means electronic or mechanical, including photocopying, recording, or by any information storage and retrieval system, without permission in writing from ARCADIS Professional Services (Canada) Inc. All rights reserved.

NO.	DATE	REVISIONS	INITIAL	ISSUED
A	2023-03-18	ISSUED FOR TENDER	C.H.	

Toronto Water




TORONTO WATER
 ENGINEERING AND CONSTRUCTION SERVICES
 WILLIAM FERNANDES, P. ENG.
 DIRECTOR
 WATER TREATMENT AND SUPPLY
 SIMON HORTON, P. ENG.
 DIRECTOR
 DESIGN & CONSTRUCTION
 MAJOR INFRASTRUCTURE

R.C. HARRIS WATER TREATMENT PLANT
 INSTALLATION OF A STANDBY GENERATOR FOR CRITICAL LOADS
 PROCESS AND INSTRUMENTATION DIAGRAM

DESIGN:	M.D.	DRAFTING:	M.D.	CHECK:	J.G.C.	CONTRACT No.	25CS-MI-03HA
SCALE:	N.T.S.						
DATE:	2024-09-30						
DRAWING NUMBER:							

2F-2017-08-78
 1004

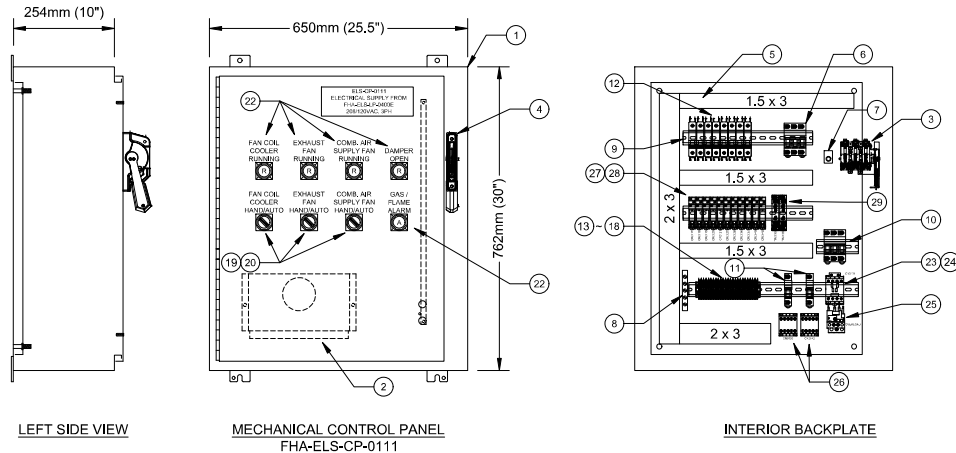

TYPICAL BILL OF MATERIALS

ITEM	PROCESS/TAG	EQUIPMENT	MANUFACTURER	PART #	DESCRIPTION	QTY
1	FHA-ELS-CP-0111	ENCLOSURE	RAISTON	N4-00727224	760x500x234 (30x25.5x10), WALL MOUNT ENCLOSURE, DISC SWITCH, NEMA 12	1
2		ENCLOSURE	HAMMOND	PKT12125	12" x 12" SHEET POCKET	1
3		DISCONNECT SWITCH	ALLEN BRADLEY	1494U-D3D	3 POLE, 30A	1
4		DISCONNECT SWITCH	ALLEN BRADLEY	1494U-30A-200A	DISCONNECT SWITCH HANDLE	1
5		ENCLOSURE SUNDRIES	ALLEN BRADLEY	1492-F8330	WIRE DUCT, 2"x3", 1.5' x 3', GRAY, AS SHOWN IN PANEL LAYOUT	AS REQ.
6		FUSE BLOCK	ALLEN BRADLEY	1492-F8330	3 POLE, CLASS J FUSE, 30A, LED INDICATOR	1
7		GROUND LUG	ILSCO	N-274	COPPER, 1 - 5/6 AWG	1
8		GROUND BAR	ILSCO	N-274	COPPER, CUT TO SIZE	1
9		DIN RAIL	PHOENIX CONTACT	801733	35mm	AS REQ.
10		FUSE BLOCK	ALLEN BRADLEY	P1492-F8C30-L	3 POLE, 30A, CLASS CC, LED INDICATOR	1
11		FUSE BLOCK	ALLEN BRADLEY	P1492-F8C30-L	1 POLE, 30A, CLASS CC, LED INDICATOR	2
12		CIRCUIT BREAKER	ALLEN BRADLEY	1489-MC1**D	1 POLE, ** (AMP RATINGS)	8
13		TERMINAL BLOCK	PHOENIX CONTACT	3044102	GREY TERMINAL M4/6	AS REQ.
14		TERMINAL BLOCK	PHOENIX CONTACT	3044128	GREEN GROUND TERMINALS	AS REQ.
15		TERMINAL BLOCK	PHOENIX CONTACT	3022276	END STOPS	AS REQ.
16		TERMINAL BLOCK	PHOENIX CONTACT	3047167	GREY SEPARATOR END SECTION	AS REQ.
17		TERMINAL BLOCK	PHOENIX CONTACT	3030271	10 POSITION PLUG IN BRIDGE	AS REQ.
18		TERMINAL BLOCK	PHOENIX CONTACT	1051003	TERMINAL MARKING STRIP	1
19		2 POSITION SELECTOR SWITCH	ALLEN BRADLEY	800T-A02A	30.5mm 1 POSITION MAINTAINED SELECTOR SWITCH, STANDARD KNOB, 1N.O. / 1N.C.	3
20		800T AUX CONTACT BLOCK	ALLEN BRADLEY	800T-XA1	AUXILIARY CONTACT BLOCK, 1N.O. / 1N.C.	3
21		PILOT LIGHT W. PUSH TO TEST	ALLEN BRADLEY	800T-GT2A	30.5mm, AMBER LED, 12-130V AC/DC, PUSH-TO-TEST	1
22		PILOT LIGHT W. PUSH TO TEST	ALLEN BRADLEY	800T-GT2R	30.5mm, RED LED, 12-130V AC/DC, PUSH-TO-TEST	4
23		CONTACTOR	ALLEN BRADLEY	100-C16010	120VAC, 3 POLE, 1N.O. AUX	1
24		120C AUX CONTACT BLOCK	ALLEN BRADLEY	100-F432	120VAC, 2 N.C.	1
25		OVERLOAD RELAY	ALLEN BRADLEY	1B3-T1AC12	MCS BIMETALLIC, 9.0A-12.5A	1
26		CONTACTOR	ALLEN BRADLEY	100-K12010	120VAC, 3 POLE, 1N.O. AUX	2
27		RELAY	OMRON	G2R-2-50A120VAC(S)	120VAC, DPDT, 10A, LED INDICATOR, REQUIRES CONNECTING SOCKET	11
28		RELAY BASE FOR OMRON G2R-2	OMRON	P28F-08-E	2-POLE RELAY SOCKET, SCREW TERMINAL, FOR G2R-2** DPDT	11
29		TIMER	PHOENIX CONTACT	2905813	120VAC, 50ms - 1hr	2

TYPICAL BILL OF MATERIALS

ITEM	PROCESS/TAG	EQUIPMENT	MANUFACTURER	PART #	DESCRIPTION	QTY
1	FHA-ELS-LSH-0101A	ENCLOSURE	RAISTON	IBCH-08DK06	203x152x152 (8x6x6), WALL MOUNT, NEMA 12	1
2		DIN RAIL	PHOENIX CONTACT	801733	35mm	1
3		TERMINAL BLOCK	PHOENIX CONTACT	3044102	GREY TERMINAL M4/6	AS REQ.
4		TERMINAL BLOCK	PHOENIX CONTACT	3044128	GREEN GROUND TERMINALS	AS REQ.
5		TERMINAL BLOCK	PHOENIX CONTACT	3022276	END STOPS	AS REQ.
6		TERMINAL BLOCK	PHOENIX CONTACT	3047167	GREY SEPARATOR END SECTION	AS REQ.

Toronto Water

ARCADIS
10407Y BAYVIEW BOULEVARD
TORONTO, ONTARIO, M3J 0G9
TEL: 416 670 1900 FAX: 416 670 4020
www.arcadis.com

COPYRIGHT:
This drawing was prepared by ARCADIS for the Corporation. No reproduction or transmission in any form or by any means is permitted without the written consent of ARCADIS Professional Services (Canada) Inc. All rights are reserved. No part of this drawing may be reproduced or transmitted in any form or by any means electronic or mechanical, including photocopying, recording, or by any information storage and retrieval system, without the prior written permission of ARCADIS Professional Services (Canada) Inc.

NO.	DATE	REVISIONS	INITIAL	ISSUED FOR TENDER	C.H.	ISSUED
A	2023-03-18					

Toronto Water




WILLIAM FERNANDEZ, P. ENG.
DIRECTOR
WATER TREATMENT AND SUPPLY

SIMON HOPTON, P. ENG.
DIRECTOR
DESIGN & CONSTRUCTION
MAJOR INFRASTRUCTURE

R.C. HARRIS WATER TREATMENT PLANT
INSTALLATION OF A STANDBY GENERATOR FOR CRITICAL LOADS
MECHANICAL CONTROL PANEL LAYOUT

DESIGN:	M.D.	DRAFTING:	M.D.	CHECK:	J.G.C.	CONTRACT No.	25ECS-MI-03HA
SCALE:	N.T.S.			DRAWING NUMBER:	2F-2017-08-79		
DATE:	2024-09-30				1005		

Drawing: J. MW-0273 TOR. HARRISWTP-STANDBYGENERATOR 500_CAD 401-CAD V-SS OR BU SHEET 7 I&C 2F-2017-08-81_007 RPU 2022 PLC RACK LAYOUTING
Date: 03/21/2025 Time: 02:22:23 PM

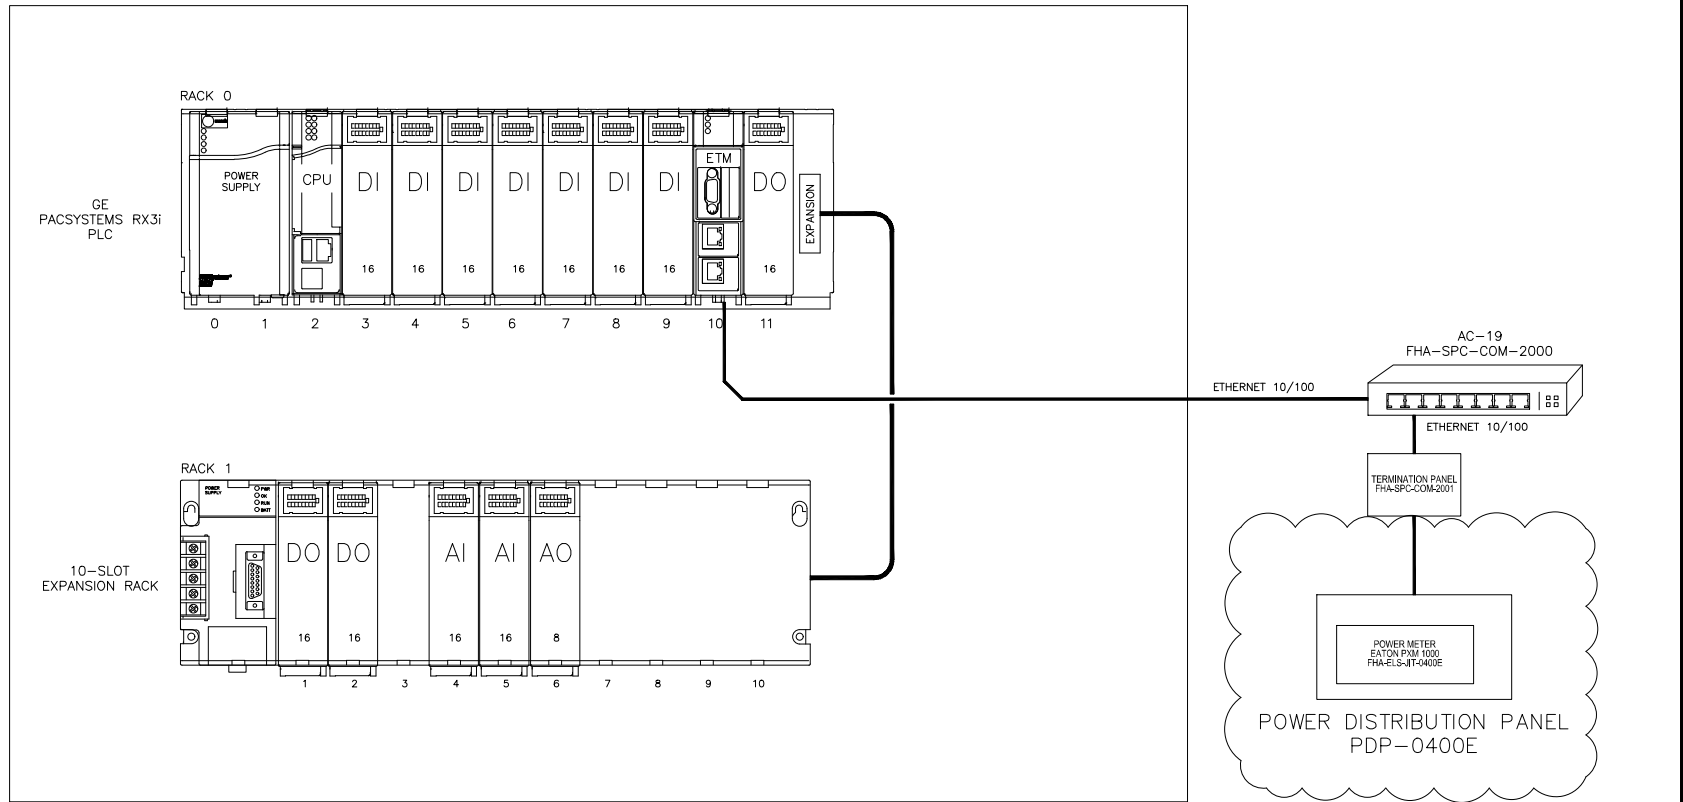

CORROSION CONTROL PANEL FHA-SPC-RPU-2022

NOTES:

1. THIS DRAWING IS BASED ON EXISTING RECORD DRAWINGS. DETAILS AS DEPICTED MAY NOT BE AN ACCURATE REPRESENTATION OF EXISTING CONDITIONS. CONTRACTOR TO FIELD VERIFY EXISTING CONDITIONS AND SUPPLY AND CONFIGURE ALL COMPONENTS TO PROVIDE A FUNCTIONAL SYSTEM THAT MEETS THE DESIGN INTENTION OF THIS DRAWING.
2. THE CONTRACTOR IS RESPONSIBLE FOR SUPPLYING AND INSTALLING ALL INTERCONNECTING CABLES, INCLUDING ETHERNET CABLES, PATCH CABLES, AS WELL AS THE NECESSARY CONNECTORS TO ENSURE A FULLY FUNCTIONAL COMMUNICATION LINK EXISTS BETWEEN THE NEW POWER MONITOR AND THE PHASPC-RPU-2022 SYSTEM.
3. CONTRACTOR TO FIELD VERIFY EXISTING TERMINATION PANEL AND NETWORK CLOSETS AND IDENTIFY SPARE PORT FOR CONNECTING THE POWER METER.
4. CONTRACTOR SHALL PERFORM NETWORK CABLEING TESTS AND SUBMIT RESULTS TO ENGINEER/CITY.

 
LEGEND:



ARCADIS
1001 DUNDAS STREET WEST
TORONTO, ONTARIO, M6H 0G9
TEL 416 679 1000 FAX 416 679 4020
www.arcadis.com

COPYRIGHT:
This drawing has been prepared and is the property of ARCADIS. It is not to be reproduced or used in any form without the written permission of ARCADIS. The user of this drawing is responsible for ensuring that it is used in accordance with the terms and conditions of the contract. ARCADIS Professional Services (Canada) Inc.

	</								



NOTES:
1. THIS DRAWING IS BASED ON EXISTING RECORD DRAWINGS. DETAILS AS DEPICTED MAY NOT BE AN ACCURATE REPRESENTATION OF EXISTING CONDITIONS. CONTRACTOR TO FIELD VERIFY EXISTING CONDITIONS AND SUPPLY AND CONFIGURE ALL COMPONENTS TO PROVIDE A FUNCTIONAL SYSTEM THAT MEETS THE DESIGN INTENTION OF THIS DRAWING.

COPYRIGHT:
This drawing has been prepared solely for the intended use, thus any reproduction or distribution for any purpose other than as authorized by ARCADIS is forbidden. Written dimensions shall have precedence over scaled dimensions. Constructors shall verify and be responsible for all dimensions and conditions on the job, and ARCADIS shall be informed of any variations from the dimensions and conditions shown on the drawing. Shop drawings shall be submitted to H&M Group for general concurrence before proceeding with fabrication.

ARCADIS Professional Services (Canada) Inc.


A	2025-03-18	ISSUED FOR TENDER		C.H.
NO.	DATE	REVISIONS		INITIAL
				SIGNED



TORONTO WATER	
ENGINEERING AND CONSTRUCTION SERVICES	
WILLIAM FERNANDES, P. ENG. DIRECTOR WATER TREATMENT AND SUPPLY	SIMON HOPTON, P. ENG. DIRECTOR DESIGN & CONSTRUCTION MAJOR INFRASTRUCTURE

R.C. HARRIS WATER TREATMENT PLANT
INSTALLATION OF A STANDBY GENERATOR FOR CRITICAL LOADS
SPC-RPU-2022 PLC PANEL LAYOUT

INSTRUMENTATION						
DESIGN:	M.D.	DRAFTING:	M.D.	CHECK:	J.G.C.	CONTRACT No. 25ECS-MI-03HA
SCALE:	N.T.S.			DRAWING NUMBER:	2F-2017-08-82	1008
DATE:	2024-09-30					

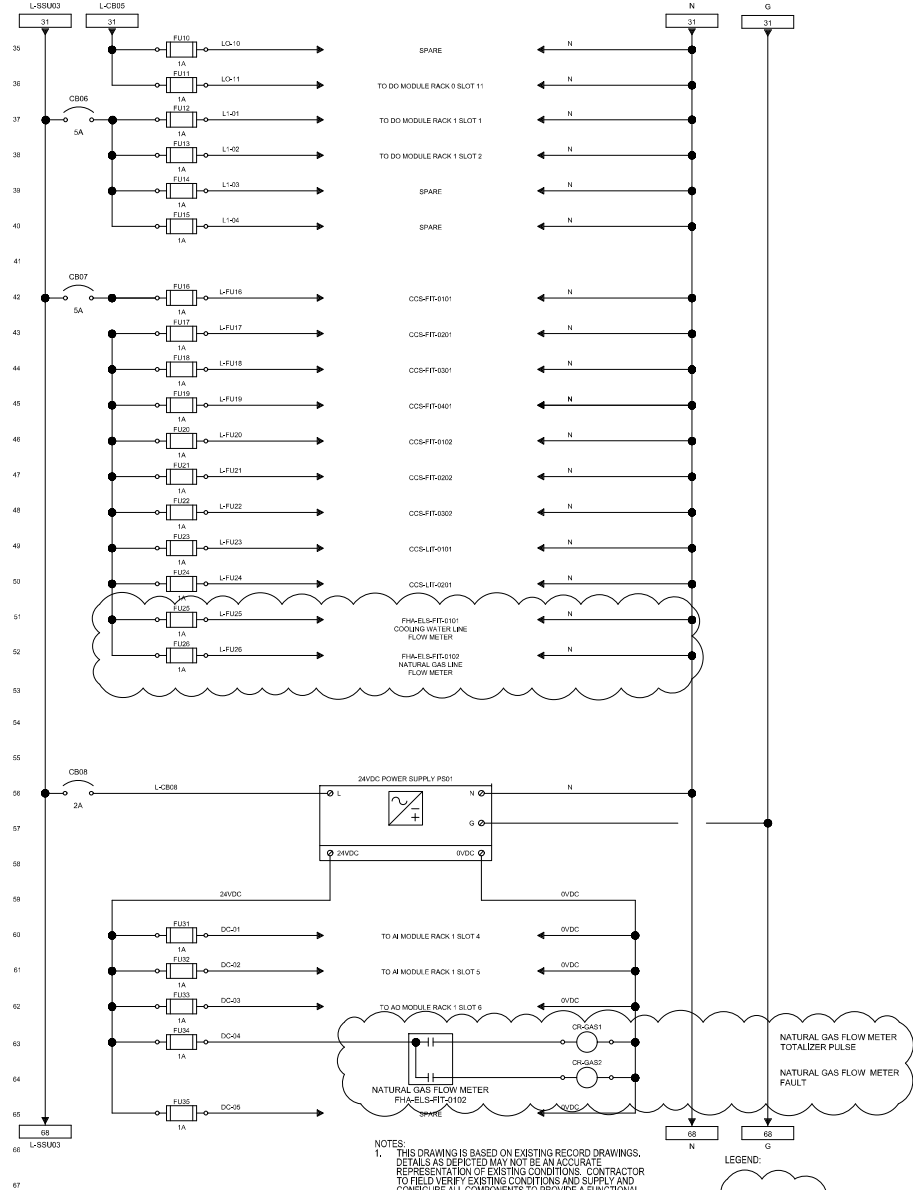


NOTES:
1. THIS DRAWING IS BASED ON EXISTING RECORD DRAWINGS, DETAILS AS DEPICTED MAY NOT BE AN ACCURATE REPRESENTATION OF EXISTING CONDITIONS. CONTRACTOR TO FIELD VERIFY EXISTING CONDITIONS AND SUPPLY AND CONFIGURE ALL COMPONENTS TO PROVIDE A FUNCTIONAL SYSTEM THAT MEETS THE DESIGN INTENTION OF THIS DRAWING AND SUPPLY AND CONFIGURE ALL COMPONENTS TO PROVIDE A FUNCTIONAL SYSTEM THAT MEETS THE DESIGN INTENTION OF THIS DRAWING.

LEGEND:

 NEW

Drawing: J:\M16-0273 TOR_HARRISWP-STANDBYGENERATOR\500_CAD\401-CAD\1-SS OR BU\SHEET\7 I&C\2F-2017-08-84_010 RPU 2022 R05.DWG
Date: 03/21/2025 Time: 02:25:50 PM

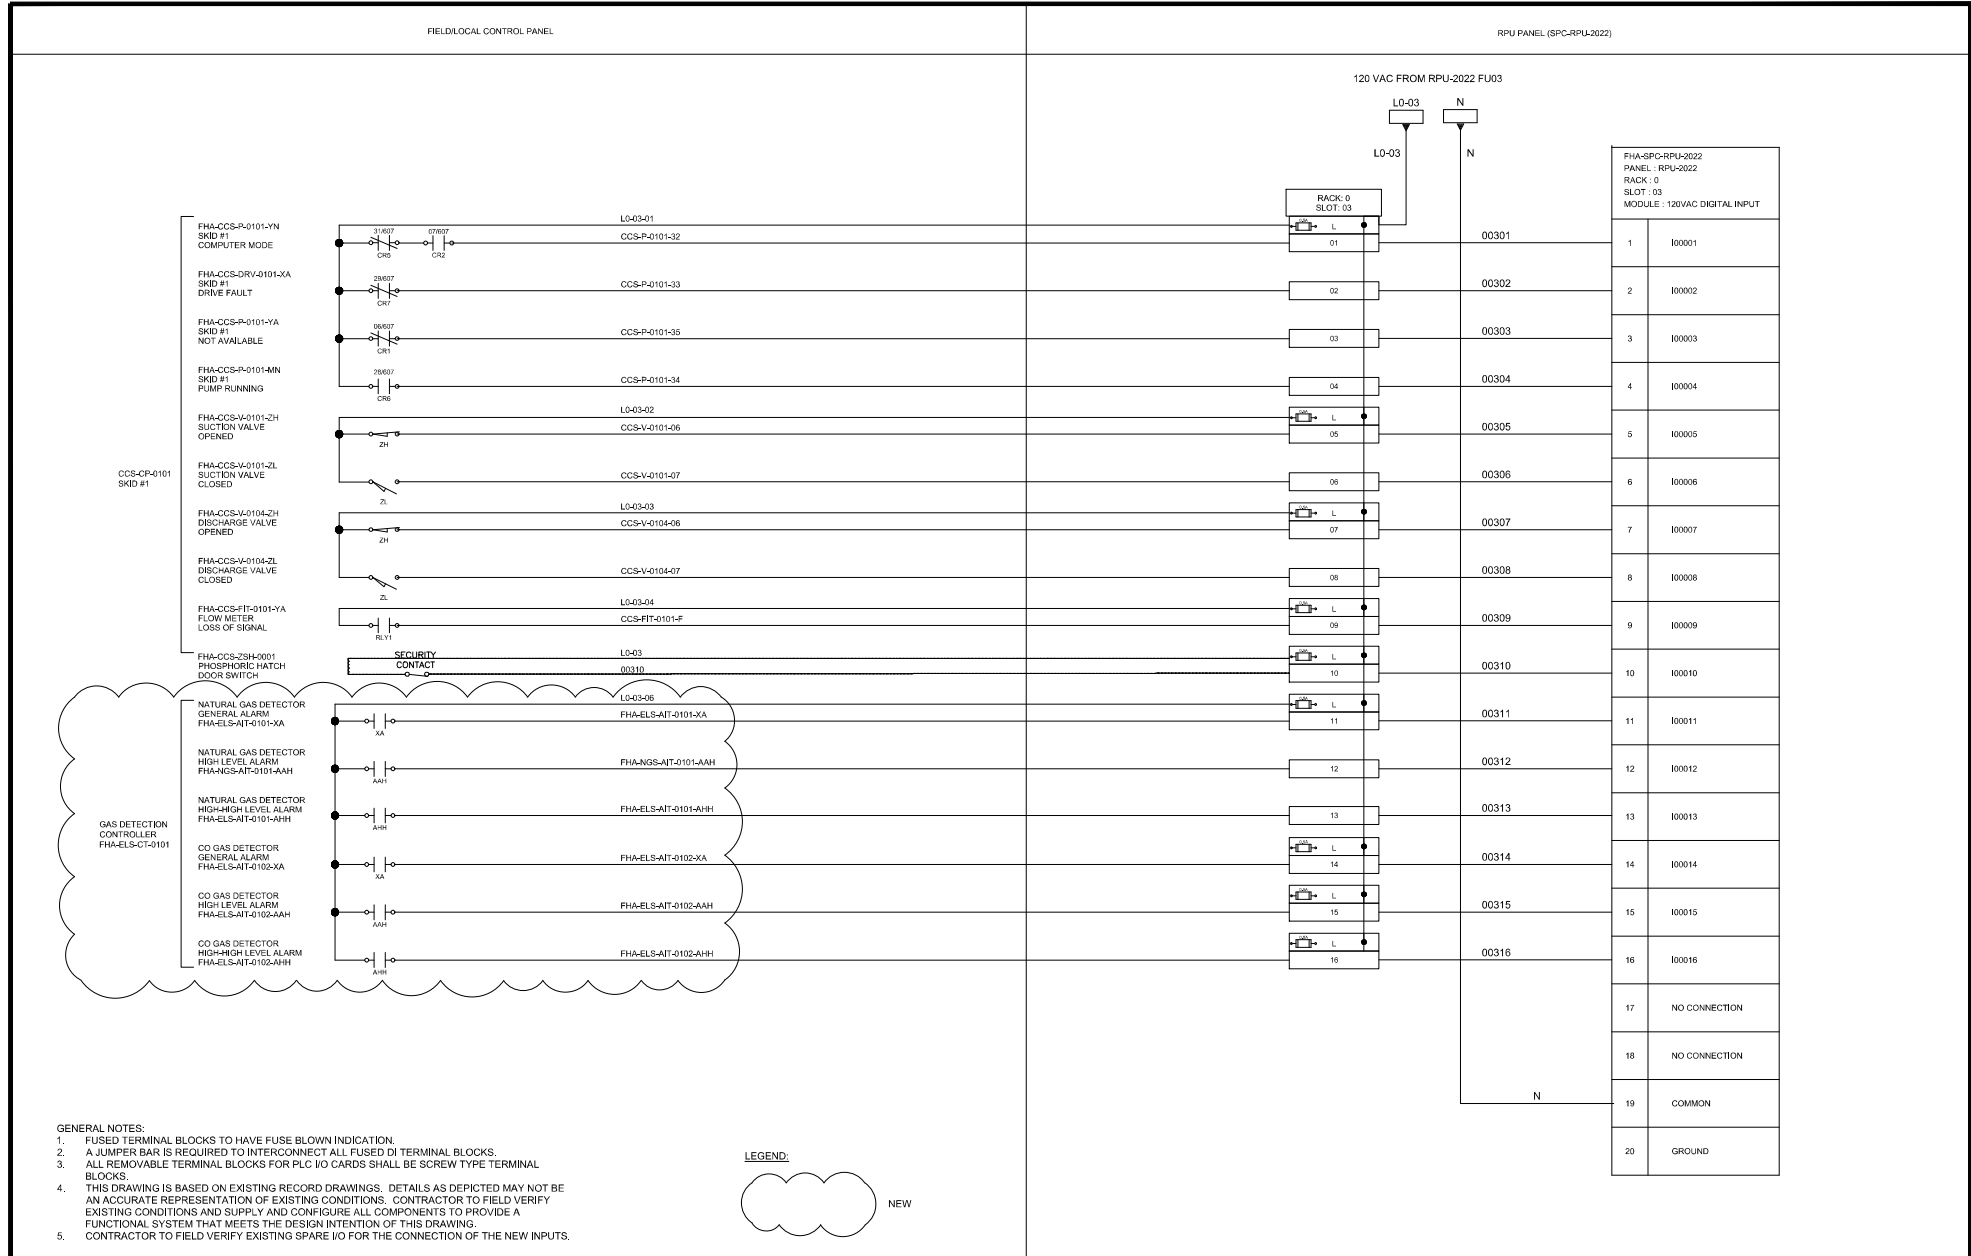

Toronto Water

Toronto

ARCADIS

COPYRIGHT:
This drawing is the property of ARCADIS Professional Services (Canada) Inc. It is to be used only for the project and location specified. No part of this drawing may be reproduced or transmitted in any form or by any means electronic or mechanical, including photocopying, recording, or by any information storage and retrieval system, without the prior written permission of ARCADIS Professional Services (Canada) Inc. The user of this drawing shall be responsible for obtaining all necessary permits and approvals from the appropriate authorities. The user shall also be responsible for ensuring that the drawing is used in accordance with the applicable laws and regulations. ARCADIS Professional Services (Canada) Inc. is not responsible for any errors or omissions in this drawing.

NO.	DATE	REVISIONS	INITIAL	ISSUED
A	2025-03-18	ISSUED FOR TENDER	C.H.	



WILLIAM FERNANDES, P. ENG.
DIRECTOR
WATER TREATMENT AND SUPPLY

TORONTO WATER
ENGINEERING AND CONSTRUCTION SERVICES
SIMON HOPTON, P. ENG.
DIRECTOR
DESIGN & CONSTRUCTION
MAJOR INFRASTRUCTURE


R.C. HARRIS WATER TREATMENT PLANT
INSTALLATION OF A STANDBY GENERATOR FOR CRITICAL LOADS
SPC-RPU-2022 RACK 0 SLOT 03 WIRING DIAGRAM

DESIGN:	M.D.	DRAFTING:	M.D.	CHECK:	J.G.C.	CONTRACT No.	25ECS-MI-03HA
SCALE:		N.T.S.				DRAWING NUMBER:	2F-2017-08-84
DATE:		2024-09-30					I010

Drawing: J:\M16-0273 TOR-HARRISWP-STANDBYGENERATOR\500_CAD\1-55 OR BU\SHEET\7 I&C\2F-2017-08-85-011 RPU 2022 R054.DWG
Date: 03/21/2025 Time: 02:18:41 PM

FIELD/LOCAL CONTROL PANEL

RPU PANEL (SPC-RPU-2022)

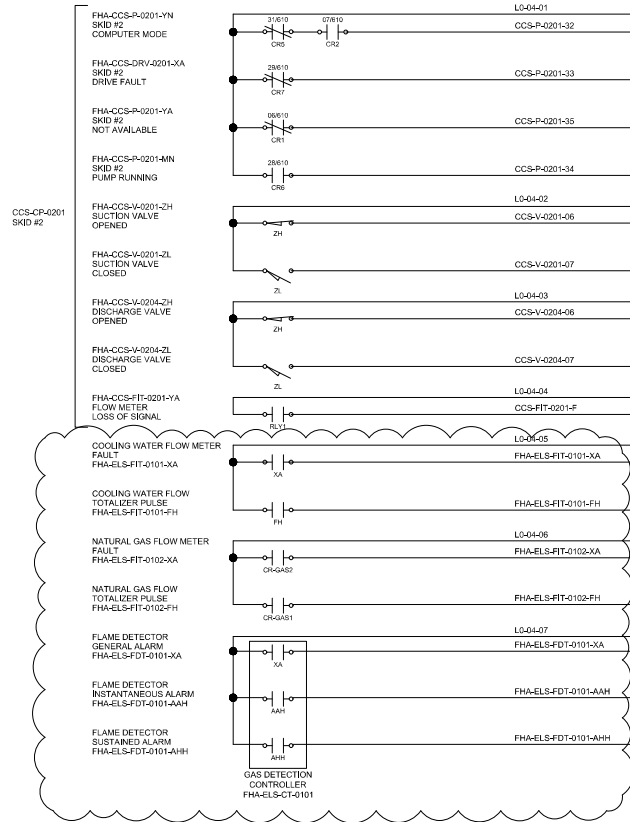

120 VAC FROM RPU-2022 FU04

L0-04
N

RACK 0
SLOT 04

L
D1

00401

02

00402

03

00403

04

00404

L
D5

00405

06

00406

L
D7

00407

08

00408

L
D9

00409

L
D10

00410

L
D11

00411

L
D12

00412

L
D13

00413

L
D14

00414

L
D15

00415

L
D16

00416

N

- GENERAL NOTES:
1. FUSED TERMINAL BLOCKS TO HAVE FUSE BLOWN INDICATION.
 2. A JUMPER BAR IS REQUIRED TO INTERCONNECT ALL FUSED DI TERMINAL BLOCKS.
 3. ALL REMOVABLE TERMINAL BLOCKS FOR PLC I/O CARDS SHALL BE SCREW TYPE TERMINAL BLOCKS.
 4. THIS DRAWING IS BASED ON EXISTING RECORD DRAWINGS. DETAILS AS DEPICTED MAY NOT BE AN ACCURATE REPRESENTATION OF EXISTING CONDITIONS. CONTRACTOR TO FIELD VERIFY EXISTING CONDITIONS AND SUPPLY AND CONFIGURE ALL COMPONENTS TO PROVIDE A FUNCTIONAL SYSTEM THAT MEETS THE DESIGN INTENTION OF THIS DRAWING. CONTRACTOR TO FIELD VERIFY EXISTING SPARE I/O FOR THE CONNECTION OF THE NEW INPUTS.

LEGEND:



Toronto Water

Toronto Water

ARCADIS
1001 DUNDAS STREET WEST
TORONTO, ONTARIO M5G 1C9
TEL 416 593 1000 FAX 416 575 4823
www.arcadis.com

COPYRIGHT:
This drawing is the property of ARCADIS Professional Services (Canada) Inc. It is to be used only for the project and location specified. No part of this drawing may be reproduced or transmitted in any form or by any means electronic or mechanical, including photocopying, recording, or by any information storage and retrieval system, without prior written permission from ARCADIS Professional Services (Canada) Inc.

NO.	DATE	REVISIONS	INITIAL	ISSUED
A	2025-03-18	ISSUED FOR TENDER	C.H.	



TORONTO WATER
ENGINEERING AND CONSTRUCTION SERVICES
WILLIAM FERNANDES, P. ENG.
DIRECTOR
WATER TREATMENT AND SUPPLY
SIMON HOPTON, P. ENG.
DIRECTOR
DESIGN & CONSTRUCTION
WATER INFRASTRUCTURE

R.C. HARRIS WATER TREATMENT PLANT
INSTALLATION OF A STANDBY GENERATOR FOR CRITICAL LOADS
SPC-RPU-2022 RACK 0 SLOT 04 WIRING DIAGRAM

DESIGN:	M.D.	DRAFTING:	M.D.	CHECK:	J.G.C.	CONTRACT No.	25ECS-MI-03HA
SCALE:	N.T.S.					DRAWING NUMBER:	2F-2017-08-85
DATE:	2024-09-30						011







NEW

Drawing: J:\M16-0273 TOR-HARRISWP-STANDBYGENERATOR\500_CAD\401-CAD\1-SS OR BU\SHEET\7 I&C\2F-2017-08-89_015 RPU 2022 R154.DWG
Date: 03/21/2025 Time: 02:18:45 PM

FIELD/LOCAL CONTROL PANEL

RPU PANEL (SPC-RPU-2022)

FHA-CCS-FIT-0101-FI
PUMP P-0101
FLOW INDICATION

FHA-CCS-FIT-0201-FI
PUMP P-0201
FLOW INDICATION

FHA-CCS-PIT-0101-PI
PUMP P-0101
PRESSURE INDICATION

FHA-CCS-PIT-0201-PI
PUMP P-0201
PRESSURE INDICATION

FHA-CCS-P-0101-SI
PUMP P-0101
SPEED INDICATION

FHA-CCS-P-0201-SI
PUMP P-0201
SPEED INDICATION

GENERATOR ROOM
TEMPERATURE INDICATION
FHA-ELS-TIT-0101-TIT

COOLING WATER LINE
FLOW INDICATION
FHA-ELS-FIT-0101-FI

NATURAL GAS LINE
FLOW INDICATION
FHA-ELS-FIT-0102-FI

NATURAL GAS DETECTOR
INDICATION
FHA-ELS-AIT-0101-AI

CO GAS DETECTOR
INDICATION
FHA-ELS-AIT-0102-AI

SPARE

SPARE

SPARE

SPARE

TO/FROM
FHA-ELS-TIT-0101-TIT
AND II (SEE NOTE 3)

TO/FROM
FHA-ELS-FIT-0101-FI
AND II (SEE NOTE 3)

TO/FROM
FHA-ELS-FIT-0102-FI
AND II (SEE NOTE 3)

TO/FROM
FHA-ELS-AIT-0101-AI
AND II (SEE NOTE 3)

TO/FROM
FHA-ELS-AIT-0102-AI
AND II (SEE NOTE 3)

GAS DETECTION
CONTROLLER
FHA-ELS-CT-0101

TO/FROM
CCS-FIT-0101-A
CCS-FIT-0101-C
AND II (SEE NOTE 3)

TO/FROM
CCS-FIT-0201-A
CCS-FIT-0201-C
AND II (SEE NOTE 3)

TO/FROM
CCS-PIT-0101-A
AND II (SEE NOTE 3)

TO/FROM
CCS-PIT-0201-A
AND II (SEE NOTE 3)

TO/FROM
CCS-DRV-0101-24
AND II (SEE NOTE 3)

TO/FROM
CCS-DRV-0201-24
AND II (SEE NOTE 3)

TO/FROM
FHA-ELS-TIT-0101-TIT
AND II (SEE NOTE 3)

TO/FROM
FHA-ELS-FIT-0101-FI
AND II (SEE NOTE 3)

TO/FROM
FHA-ELS-FIT-0102-FI
AND II (SEE NOTE 3)

TO/FROM
FHA-ELS-AIT-0101-AI
AND II (SEE NOTE 3)

TO/FROM
FHA-ELS-AIT-0102-AI
AND II (SEE NOTE 3)

LEGEND

NEW

120 VAC FROM RPU-2022 FU31

DC-01 0VDC

DC-01 0VDC

FHA-SPC-RPU-2022
PANEL : RPU-2022
RACK 1
SLOT NO. : 04
MODULE : 24V ANALOG INPUT

1 24V IN

2 24V OUT

3 AI001

4 AI002

5 AI003

6 AI004

7 AI005

8 AI006

9 AI007

10 AI008

11 AI009

12 AI010

13 AI011

14 AI012

15 AI013

16 AI014

17 AI015

18 AI016

19 COMMON

20 GROUND

- GENERAL NOTES:
1. FUSED TERMINAL BLOCKS TO HAVE FUSE BLOWN INDICATION.
 2. A JUMPER BAR IS REQUIRED TO INTERCONNECT ALL FUSED DI TERMINAL BLOCKS.
 3. ALL REMOVABLE TERMINAL BLOCKS FOR PLC I/O CARDS SHALL BE SCREW TYPE TERMINAL BLOCKS.
 4. THIS DRAWING IS BASED ON EXISTING RECORD DRAWINGS. DETAILS AS DEPICTED MAY NOT BE AN ACCURATE REPRESENTATION OF EXISTING CONDITIONS. CONTRACTOR TO FIELD VERIFY EXISTING CONDITIONS AND SUPPLY AND CONFIGURE ALL COMPONENTS TO PROVIDE A FUNCTIONAL SYSTEM THAT MEETS THE DESIGN INTENTION OF THIS DRAWING.
 5. CONTRACTOR TO FIELD VERIFY EXISTING SPARE I/O FOR THE CONNECTION OF THE NEW INPUTS.

Toronto Water

ARCADIS
10011 DAVENPORT BUILDING
TORONTO, ONTARIO, M5W 0G9
TEL 416 693 1000 FAX 416 675 4823
www.arcadis.com

COPYRIGHT:
This drawing is the property of the client. It is not to be reproduced or used in any way without the written permission of ARCADIS Professional Services (Canada) Inc. (ARCADIS).
ARCADIS Professional Services (Canada) Inc.

NO.	DATE	REVISIONS	INITIAL	ISSUED
A	2025-03-18	ISSUED FOR TENDER	C.H.	

Toronto Water




WILLIAM FERNANDES, P. ENG.
DIRECTOR
WATER TREATMENT AND SUPPLY

TORONTO WATER
ENGINEERING AND CONSTRUCTION SERVICES

SIMON HOPTON, P. ENG.
DIRECTOR
DESIGN & CONSTRUCTION
MAJOR INFRASTRUCTURE

R.C. HARRIS WATER TREATMENT PLANT
INSTALLATION OF A STANDBY GENERATOR FOR CRITICAL LOADS
SPC-RPU-2022 RACK 1 SLOT 04 WIRING DIAGRAM

DESIGN:	M.D.	DRAFTING:	M.D.	CHECK:	J.G.C.	CONTRACT No.	25ECS-MI-03HA
SCALE:	N.T.S.					DRAWING NUMBER:	2F-2017-08-89
DATE:	2024-09-30						015

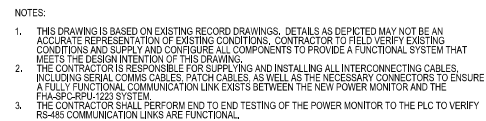

NEW



PLC CONTROL PANEL
FHA-SPC-RPU-1223

FRONT VIEW



- GENERAL NOTES:
1. THIS DRAWING IS BASED ON EXISTING RECORD DRAWINGS. DETAILS AS DEPICTED MAY NOT BE AN ACCURATE REPRESENTATION OF EXISTING CONDITIONS. CONTRACTOR TO FIELD VERIFY EXISTING CONDITIONS AND SUPPLY AND CONFIGURE ALL COMPONENTS TO PROVIDE A FUNCTIONAL SYSTEM THAT MEETS THE DESIGN INTENTION OF THIS DRAWING.
 2. CONTRACTOR TO FIELD VERIFY EXISTING SPARE I/O FOR THE CONNECTION OF THE NEW INPUTS.

 NEW

COPYRIGHT:
This drawing has been prepared **entirely** for the intended use, thus any reproduction, distribution for any purpose other than that authorized by ARCADIS is forbidden. The client shall have precedence over third parties. Contractors shall be responsible for all drawings and conditions on the job, and ARCADIS shall be liable for any variations from the drawings and conditions shown on the drawing. They shall also be submitted to **all** Group for general confirmation before proceeding with fabrication.

ARCADIS Professional Services (Canada) Inc.

A	2025-03-18	ISSUED FOR TENDER						C.H.	
NO.	DATE	REVISIONS						INITIAL	SIGNED





WILLIAM FERNANDES, P. ENG.
DIRECTOR,
WATER TREATMENT AND SUPPLY

SIMON HOPTON, P. ENG.
DIRECTOR
DESIGN & CONSTRUCTION
MAJOR INFRASTRUCTURE

R.C. HARRIS WATER TREATMENT PLANT
INSTALLATION OF A STANDBY GENERATOR FOR CRITICAL LOADS
SPC-RPU-1223 PLC PANEL LAYOUT

INSTRUMENTATION						
DESIGN:	M.D.	DRAFTING:	M.D.	CHECK:	J.G.C.	CONTRACT No. 25ECS-MI-03HA
SCALE:	N.T.S.			DRAWING NUMBER:	2F-2017-08-91	I017
DATE:	2024-09-30					



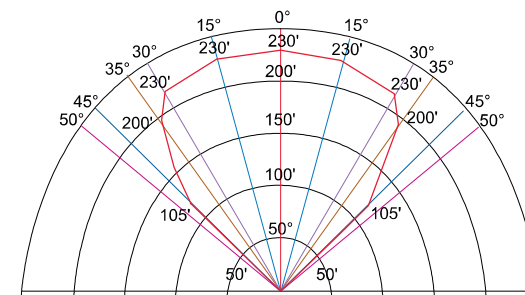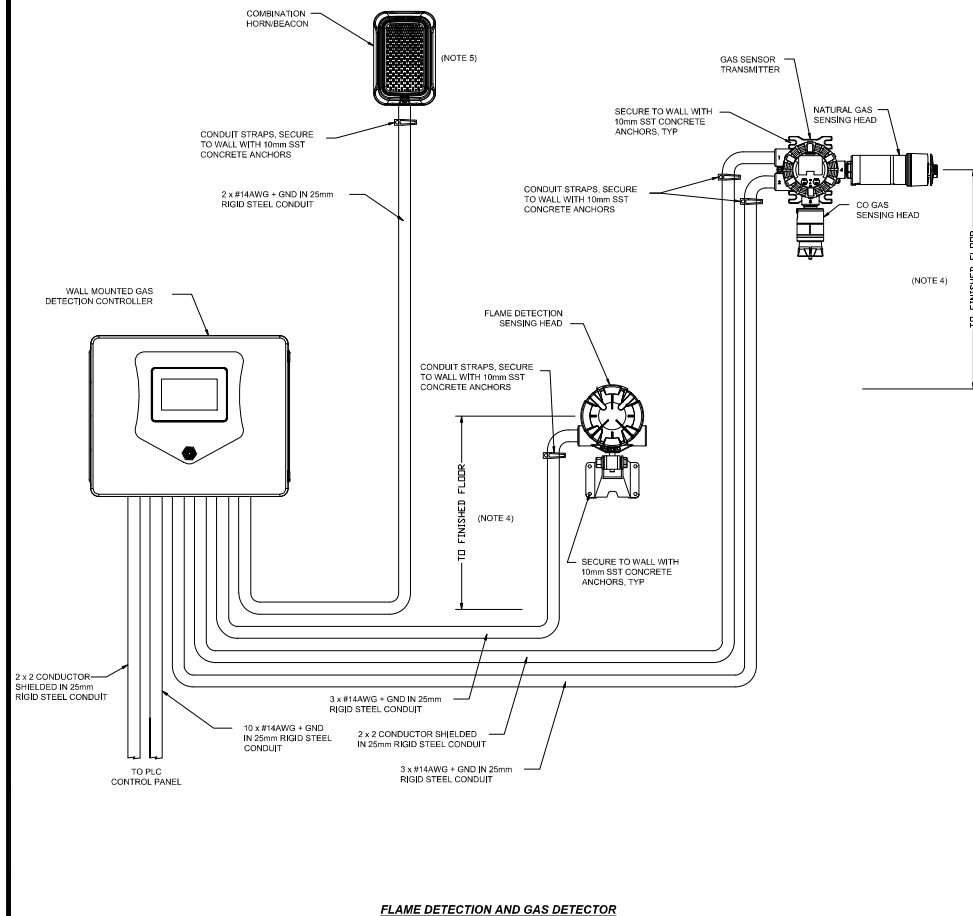

NOTES:

1. 1 SQ. FT. N-HEPTANE FIRE USING HIGH SENSITIVITY. THIS IS A NOMINAL VALUE AND DIFFERENT RESULTS MAY ARISE DEPENDING ON THE SOURCE OF EACH FIRE.
2. MAXIMUM FIELD OF VIEW IS THE ANGLE AT WHICH THE DETECTOR CAN DETECT FLAME AT 50% OF MAXIMUM SPECIFIED RANGE.

FLAME DETECTOR MAXIMUM FIELD OF VIEW

NOTES:

1. INSTALL SENSOR/TRANSMITTER AND DETECTOR IN ACCORDANCE WITH MANUFACTURER INSTRUCTIONS.
2. SENSOR/TRANSMITTER LOCATED IN AREA TO BE MONITORED, GAS DETECTION CONTROLLER TO BE INSTALLED REMOTELY.
3. THE MANUFACTURER MOUNTING BRACKET IS TO BE USED FOR INSTALLATION.
4. REFER TO MANUFACTURER'S RECOMMENDATION FOR MOUNTING DISTANCE.
5. INSTALL HORNEBAKE ABOVE THE DOOR ON THE OUTSIDE OF THE GENERATOR ROOM.
6. PIPE nipples shall be SCH 40S, 1/2", MAXIMUM 100mm FROM PROCESS OR PIPE LAGGING.
7. CONDUIT (AND CABLE) ENTRY CONNECTION TO THE INSTRUMENT SHALL BE 100mm (3") FLEXIBLE, THE BALANCE IN RIGID CONDUIT.



WILLIAM FERNANDES, P. ENG.
DIRECTOR,
WATER TREATMENT AND SUPPLY

ONTARIO WATER

ENGINEERING AND CONSTRUCTION SERVICES


WILLIAM FERNANDES, P. ENG.
DIRECTOR,
WATER TREATMENT AND SUPPLY

SIMON HOPTON, P. ENG.
DIRECTOR
DESIGN & CONSTRUCTION
MAJOR INFRASTRUCTURE

R.C. HARRIS WATER TREATMENT PLANT
INSTALLATION OF A STANDBY GENERATOR FOR CRITICAL LOADS
INSTALLATION DETAILS - 1

INSTRUMENTATION


DESIGN:	M.D.	DRAFTING:	M.D.	CHECK:	J.G.C.	CONTRACT No.	25ECS-MI-03HA
SCALE:	N.T.S.			DRAWING NUMBER:	2F-2017-08-94		I020
DATE:	2024-09-30						

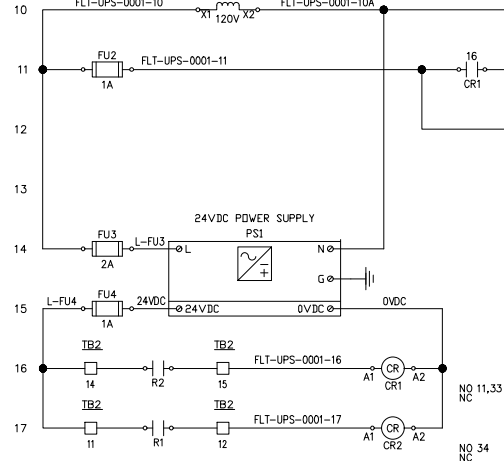

18

19

 20



- - DEVICE TERMINAL
- ☒ - TERMINAL BLOCK IN MCC/SWITCHGEAR
- - TERMINAL BLOCK IN LOCAL PANEL
- ▣ - TERMINAL BLOCK IN RPU
- ◇ - TERMINAL BLOCK IN CENTRAL BACKUP PANEL (CBP)
- ◊ - TERMINAL BLOCK IN AREA CONTROL PANEL (ACP)
- - TERMINAL BLOCK IN TERMINAL (JUNCTION) BOX



– REMOVALS

NOTES:
1. EXISTING ENCLOSURE TO BE REUSED AS A JUNCTION BOX. SUPPLY AND INSTALL NEW TERMINAL BLOCKS INSIDE THE ENCLOSURE AS REQUIRED.

COPYRIGHT:
This drawing has been prepared solely for the intended use, thus any reproduction or distribution for any purpose other than authorized by ARCADIS is forbidden. These dimensions shall have precedence over scaled dimensions. Contractors shall verify responsibility for all dimensions and conditions on the job, and ARCADIS shall be liable for any variations from the dimensions and conditions shown on the drawing. Shop drawings shall be submitted to the Group for general conformance before proceeding with fabrication.

ARCADIS Professional Services (Canada) Inc.

the Toronto




CONSTRUCTION SERVICES

SIMON HOPTON, P. ENG.
DIRECTOR
DESIGN & CONSTRUCTION
MAJOR INFRASTRUCTURE

R.C. HARRIS WATER TREATMENT PLANT
INSTALLATION OF A STANDBY GENERATOR FOR CRITICAL LOADS
FLT-UPS-0001 POWER FAILURE WIRING DIAGRAM

INSTRUMENTATION						
DESIGN:	M.D.	DRAFTING:	M.D.	CHECK:	J.G.C.	CONTRACT No. 25ECS-MI-03HA
SCALE:	N.T.S.			DRAWING NUMBER:	2F-2017-08-96	I101
DATE:	2024-09-30					

Drawing: J:\M16-0273 TOR_HARRISWP-STANDBYGENERATOR 600_CAD\401-CAD\1-SS OR BU\SHEET\7 I&C\FILTER CV SHUTDOWN_VF-2017-08-97_1102 UPS-0002.DWG
Date: 03/21/2020 Time: 02:34:52 PM

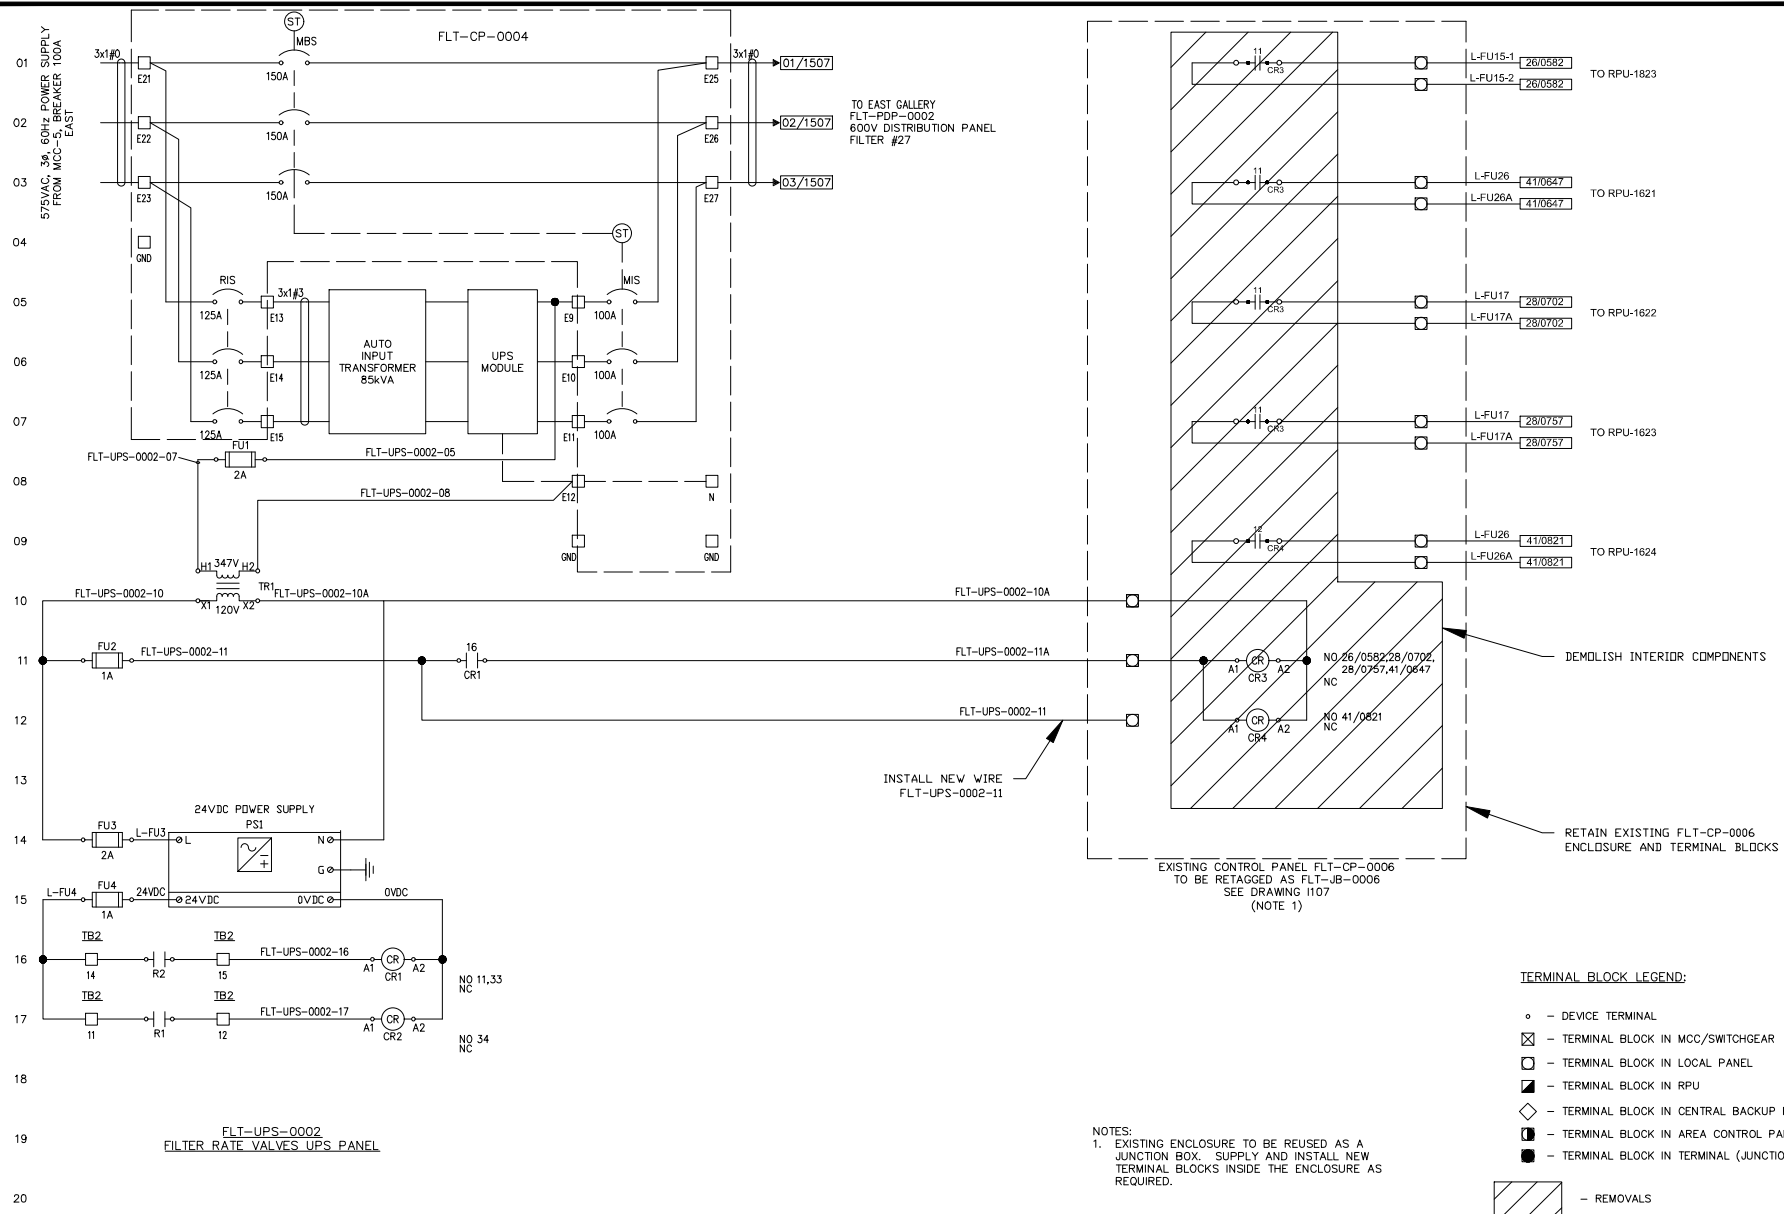

Toronto Water

ARCADIS

COPYRIGHT:
This drawing has been prepared and is the intellectual property of ARCADIS Professional Services (Canada) Inc. It is to be used for the project and location shown on the drawing. It is not to be used for any other purpose without the written consent of ARCADIS Professional Services (Canada) Inc.

NO.	DATE	REVISIONS	INITIAL	ISSUED FOR TENDER	C.H.	ISSUED
A	2024-03-18					


Toronto Water



TORONTO WATER	
ENGINEERING AND CONSTRUCTION SERVICES	
WILLIAM FERNANDES, P. ENG. DIRECTOR WATER TREATMENT AND SUPPLY	SIMON HOPKIN, P. ENG. DIRECTOR DESIGN & CONSTRUCTION MAJOR INFRASTRUCTURE

R.C. HARRIS WATER TREATMENT PLANT
INSTALLATION OF A STANDBY GENERATOR FOR CRITICAL LOADS
FLT-UPS-0002 POWER FAILURE WIRING DIAGRAM

INSTRUMENTATION					
DESIGN:	M.D.	DRAFTING:	M.D.	CHECK:	J.G.C.
SCALE:	N.T.S.			DRAWING NUMBER:	2F-2017-08-97
DATE:	2024-09-30				1102

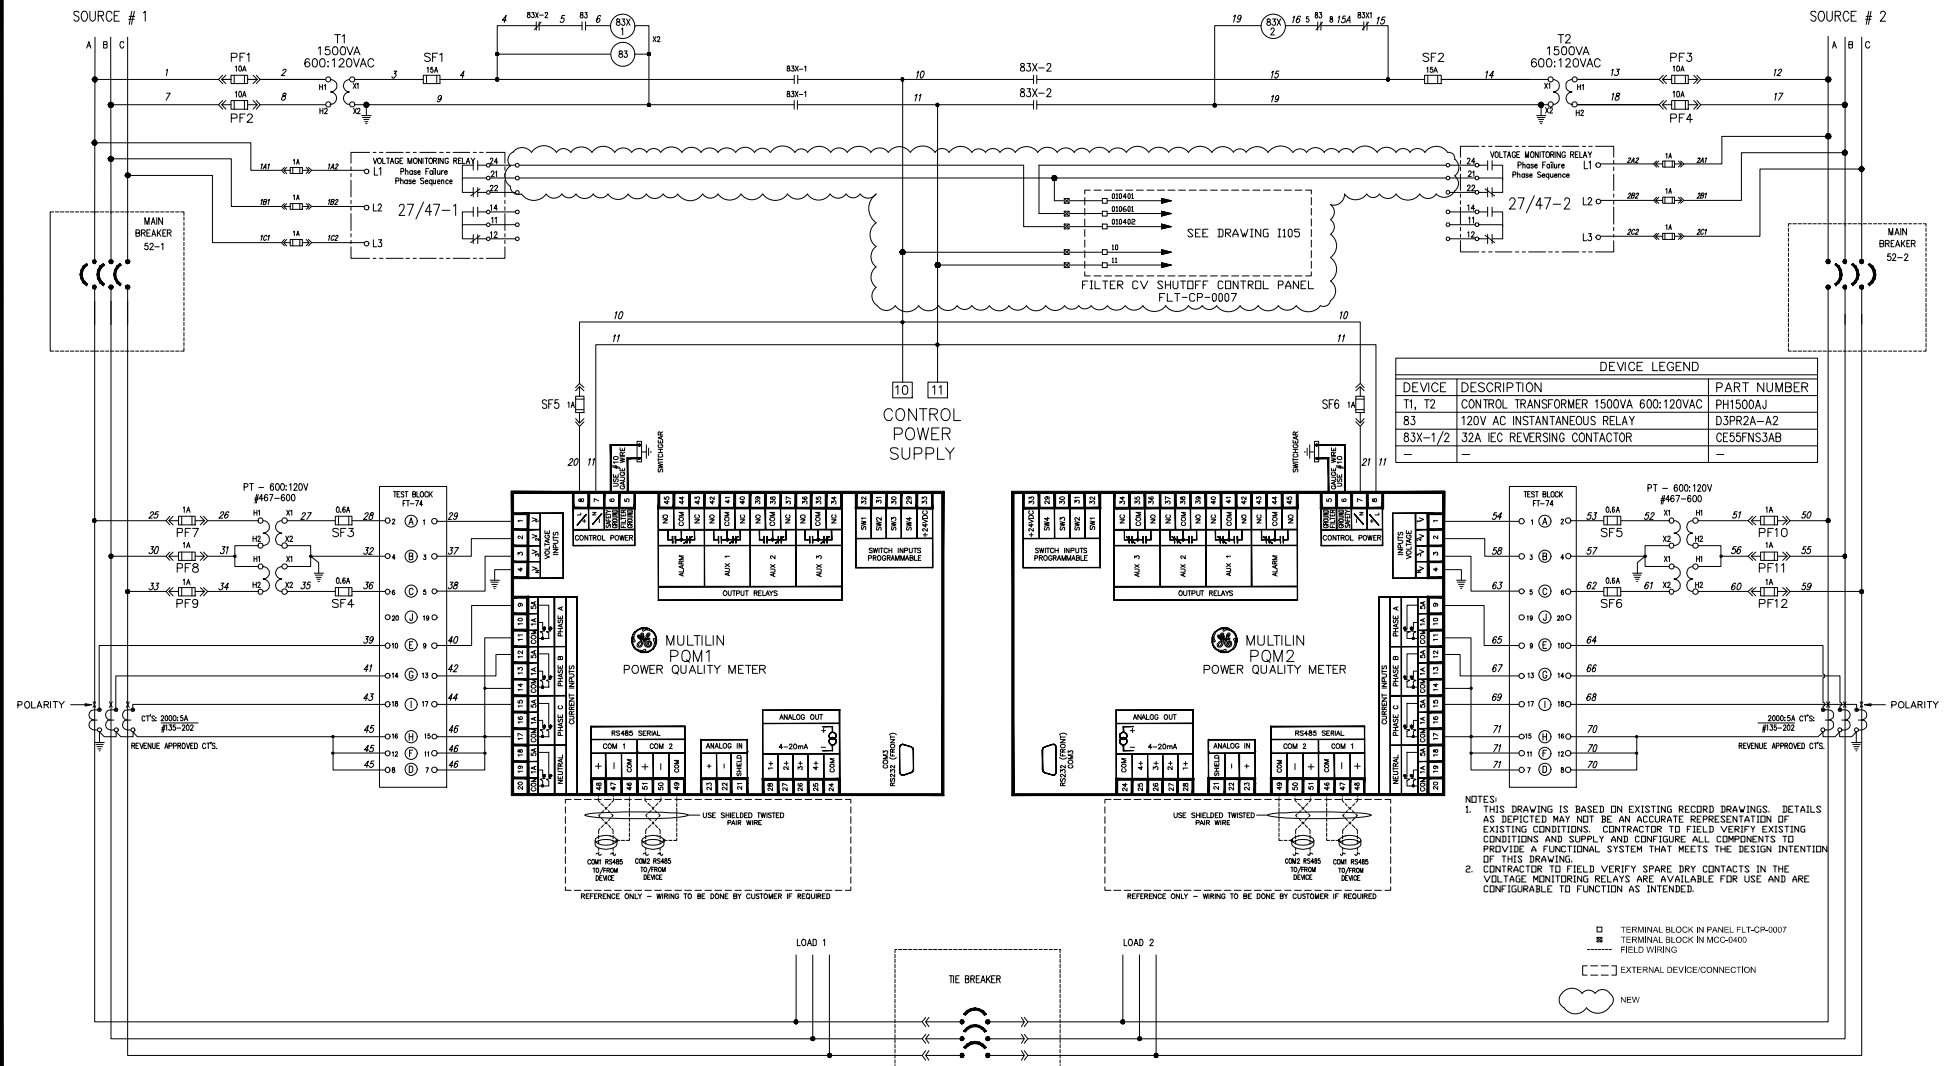

Toronto Water



COPYRIGHT:
 This drawing was prepared by ARCADIS Professional Services (Canada) Inc. for the use of the client. It is the property of ARCADIS Professional Services (Canada) Inc. and is not to be reproduced or used in any manner without the written consent of ARCADIS Professional Services (Canada) Inc. ARCADIS Professional Services (Canada) Inc. is a registered professional engineering firm in the Province of Ontario, Canada. ARCADIS Professional Services (Canada) Inc. is a member of the ARCADIS group of companies. ARCADIS Professional Services (Canada) Inc. is a member of the ARCADIS group of companies. ARCADIS Professional Services (Canada) Inc. is a member of the ARCADIS group of companies.

NO.	DATE	REVISIONS	INITIAL	ISSUED FOR TENDER	CH.	ISSUED
A	2024-03-18					



WILLIAM FERNANDES, P. ENG.
 DIRECTOR
 WATER TREATMENT AND SUPPLY

SIMON HOPKIN, P. ENG.
 DESIGNER
 DESIGN & CONSTRUCTION
 MAJOR INFRASTRUCTURE

R.C. HARRIS WATER TREATMENT PLANT INSTALLATION OF A STANDBY GENERATOR FOR CRITICAL LOADS MCC-0400 WIRING DETAIL

DESIGN:	M.D.	DRAFTING:	M.D.	CHECK:	J.G.C.	CONTRACT No.	25ECS-MI-03HA
SCALE:	N.T.S.						
DATE:	2024-09-30						
DRAWING NUMBER:	2F-2017-08-98						
							1103

NORMAL CONDITION

1. MAIN BREAKERS (52-1, 52-2) ARE CLOSED
2. TIE BREAKER (52-T) IS OPEN

INTERLOCKING

1. MAIN AND TIE BREAKERS ARE ELECTRICALLY INTERLOCKED TO PREVENT PARALLELING OF SOURCES AT ALL TIMES.
2. CLOSING OF MAIN AND TIE BREAKERS VIA SELECTOR SWITCH IS PERMITTED ONLY WHEN THE AUTO/OFF/MANUAL SELECTOR SWITCH (43-1) IS IN THE MANUAL OR OFF POSITION.
3. TRIPPING OF MAIN AND TIE BREAKERS VIA SELECTOR SWITCH IS PERMITTED UNDER ALL CIRCUMSTANCES.

LOCKOUT

1. OVERCURRENT TRIP SWITCHES (OTS) ON MAIN AND TIE BREAKERS ARE INCORPORATED IN THE CONTROL SCHEME TO PREVENT CLOSURE OF TIE & FAULTED MAIN BREAKER AFTER A FAULT. THE FAULT MUST BE CLEARED AND THE CORRESPONDING BREAKER MANUALLY RESET TO RETURN TO NORMAL OPERATION.

4. ONLY TWO BREAKERS CAN BE CLOSED AT ONE TIME WHEN SELECTOR SWITCH (43-1) IS EITHER IN AUTO, OFF OR MANUAL POSITION AND BKRS ARE IN FULLY CONNECTED POSITION. **INTERLOCKING IS DEPRATED WHEN BREAKERS ARE IN TRIP POSITION. SELECTOR SWITCH (43-1) MUST BE IN OFF POSITION WHEN TESTING THE BREAKERS.**

INITIAL START-UP

1. VERIFY SELECTOR SWITCH (43-1) IS IN "MANUAL" POSITION.
2. VERIFY ALL 3 BREAKERS ARE IN THE FULLY CONNECTED POSITION IN THEIR RESPECTIVE CELLS.
3. TURN SELECTOR SWITCH (43-1) TO CLOSE POSITION.
--MAIN BREAKERS CLOSES.
4. PLACE SELECTOR SWITCH (43-1) IN THE "AUTO" POSITION.

SEQUENCE OF AUTOMATIC OPERATION

- A. LOSS OF UTILITY POWER AT EITHER MAIN.
 1. DEVICE 47 DETECTS LOSS OF NORMAL VOLTAGE (BUILT IN TIME DELAY SET TO MINIMUM).
 2. DEVICE 62-1/2 TIMES OUT FOR 5s(ADJUSTABLE 0.0s - 10sec.)
 3. MAIN BREAKER OPENS
 4. DEVICE 62-3/4 TIMES OUT FOR 1s(ADJUSTABLE 0.5s - 10s)
 5. TIE BREAKER CLOSES
- B. POWER RESTORED AT EITHER MAIN.
 1. DEVICE 47 DETECTS NORMAL VOLTAGE (AUTOMATICALLY RESETS CONTACT)
 2. DEVICE 62-5/6 TIMES OUT FOR 5min. (ADJUSTABLE 0min - 10min)
 3. THE BREAKER OPENS
 4. DEVICE 62-3/4 TIMES OUT FOR 1s(ADJUSTABLE 0.5s - 10s)
 5. MAIN BREAKER CLOSES
- C. LOSS OF UTILITY POWER AT BOTH MAINS.
 1. NO ACTIVITY UNTIL AT LEAST ONE SOURCE IS AVAILABLE.

MANUAL MODE SEQUENCE

1. PLACE SELECTOR SWITCH (43-1) IN "MANUAL" POSITION.
2. USING SELECTOR SWITCH(43-1)M2/T) IN EACH MAIN BREAKERS WILL ALLOW MANUAL TRANSFER CONTROL OF THE ASSOCIATED BREAKER. OPERATION OF THE BREAKER SELECTOR SWITCH IN TRIP POSITION WILL TRIP THE ASSOCIATED BREAKER.
3. OPERATION OF MAIN BREAKERS SELECTOR SWITCH (43-1)M2) IN CLOSE POSITION WILL TRIP THE TIE BREAKER. TIE BREAKER CANNOT BE CLOSED UNLESS ONE OF THE MAIN BREAKERS IS OPEN. ONLY TWO BREAKERS CAN BE CLOSED AT ANY GIVEN TIME.
4. MAIN BREAKER WILL CLOSE ONLY IF SOURCE POWER IS AVAILABLE.
5. SELECTOR SWITCH (43-1) MAY BE RETURNED TO "AUTO" TO REACT TO NEXT POWER FAILURE.


NOTES:

1. THIS DRAWING IS BASED ON EXISTING RECORD DRAWINGS. DETAILS AS DEPICTED MAY NOT BE AN ACCURATE REPRESENTATION OF EXISTING CONDITIONS. CONTRACTOR TO FIELD VERIFY EXISTING CONDITIONS AND SUPPLY AND CONFIGURE ALL COMPONENTS TO PROVIDE A FUNCTIONAL SYSTEM THAT MEETS THE DESIGN INTENTION OF THIS DRAWING.
2. CONTRACTOR TO FIELD VERIFY EXISTING SPARE CONTACTS FOR TIE-SET RELAY ARE AVAILABLE FOR USE. SUPPLY AND INSTALL EXPANSION RELAY/AUX. CONTACTS AS REQUIRED.

- TERMINAL BLOCK IN PANEL FLT-CP-0007
- TERMINAL BLOCK IN MCC-0400
- FIELD WIRING
- [] EXTERNAL DEVICE/CONNECTION
- ☁ NEW


- LEGEND:
- OTC OVERCURRENT TRIP SWITCH (BELL ALARM)
 - TOC TRUCK OPERATED
 - CELL SWITCH
 - 120V AC COIL
 - 120V AC PILOT LIGHT
 - FUSE
 - MOT SPRING CHARGE OPERATOR
 - SR SPRING RELEASE (CLOSE)
 - 27/47 VOLTAGE MONITORING RELAY-DESMVLS600-B1
 - TRIP COIL
 - VENDOR WIRING
 - TERMINAL BLOCK

DEVICE LEGEND		
DEVICE	DESCRIPTION	PART NUMBER
43-1	AUTO/OFF/MANUAL SELECTOR SWITCH - 3 POS. SELECTOR SWITCH	LVDAJB404
43-M1/M2	CLOSE/OFF/OPEN SELECTOR SWITCH - 3 POS. MOMENTARY	1025013043
62-1,62-2	OMRON OFF-DELAY (3s-10min) 120V AC RELAY - 8 PIN (H3CR)	3A16862H01
62-1,62-2	RELAY SOCKET - 8 PIN	D3PA2-A2
62-3,62-4	OMRON ON-DELAY (0.5-60s) 120V AC RELAY - 8 PIN (H3CR)	LVDAJ7617
62-3,62-4	RELAY SOCKET - 11 PIN	D3PA3-A2
62-5,62-6	OMRON ON-DELAY (2min-120min) 120V AC RELAY - 8 PIN (H3CR)	LVDAJ7617
62-5,62-6	RELAY SOCKET - 11 PIN	D3PA3-A2
62-1,62-2	RELAY SOCKET - 8 PIN	D3PA2-A2
LIGHTS	120V AC PUSH-TO-TEST TRANSFORMER TYPE PILOT LIGHTS	102501221N
G	GREEN PILOT LIGHT LENS	102501C22
R	RED PILOT LIGHT LENS	102501C21
Q-UR-3, Q-7	CONTROL RELAY 120VAC / 8 PIN SOCKET	D3PR2A / D3PA2-A2
Q-UR-5, Q-6	CONTROL RELAY 120VAC / 11 PIN SOCKET	D3PR3A / D3PA3-A2

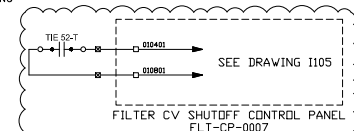


DEVICE 43-1


AUTO/MANUAL SELECTOR SWITCH			
CONTACT	AUTO	OFF	MAN
1-11-2	X		
3-11-2			X
5-11-6	X		
7-11-6			X
25-11-18	X		
27-11-18			X
17-11-20	X		
19-11-20			X
9-11-10	X		
11-11-10			X
23-11-24	X		
21-11-24			X
13-11-14	X		

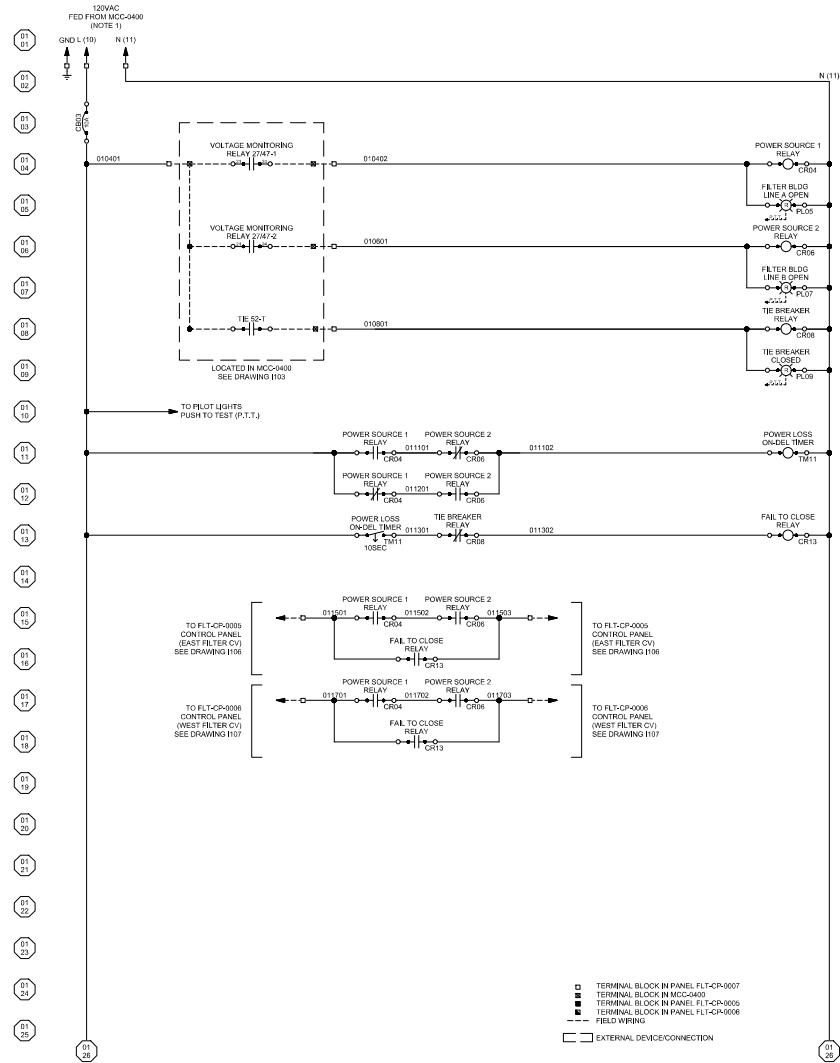

NOTE:
1. 120 VAC FED FROM CONTROL POWER SUPPLY IN MCC-0400, SEE DRAWING I103
2. REFER TO DRAWING I202 FOR DETAILS ON THE LOCATION OF THE FILTER CV SHUTOFF CONTROL PANEL FLT-CP-0007

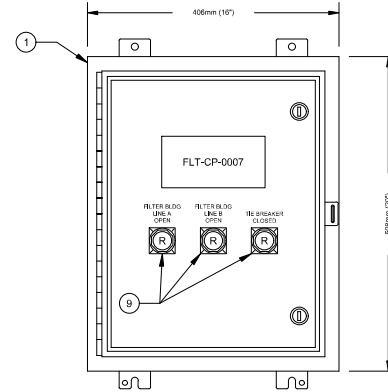

FLT-CP-0007 FILTER CV SHUTOFF CONTROL PANEL

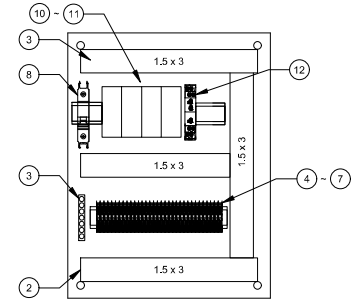

INTERIOR BACKPLATE

FILTER CV SHUTOFF CONTROL PANEL - BILL OF MATERIALS

ITEM	EQUIPMENT	MANUFACTURER	PART #	DESCRIPTION	QTY
1	ENCLOSURE	MALSTON	N12-201608	500x500x203 (20x16x8), WALL MOUNTED/SINGLE DOOR NEMA 12	1
2	ENCLOSURE SUNDRIES	PANZUIT OR EQUIVALENT		WIRE DUCT, 6"x4", 6"x4", 3"x4", 2"x4", 4"x3", 3"x3", 2"x3", 2"x3", GRAY, AS SHOWN IN PANEL LAYOUT	AR
3	GROUND BAR	ILSCO	N-174	COPPER, CUT TO SIZE	1
4	TERMINAL BLOCK	PHOENIX CONTACT	3044102	GREY TERMINAL MA6/6	AR
5	TERMINAL BLOCK	PHOENIX CONTACT	3022276	END STOPS	AR
6	TERMINAL BLOCK	PHOENIX CONTACT	3047167	GREY SEPARATOR END SECTION	AR
7	TERMINAL BLOCK	PHOENIX CONTACT	1051003	TERMINAL MARKING STRIP	AR
8	CIRCUIT BREAKER 1 POLE, 10A	SCHNEIDER ELECTRIC	M9F42110	MULTI 9 C60BP, 1P, 10A, C CURVE	1
9	CIRCUIT BREAKER 1 POLE, 10A	ALLEN BRADLEY	8001-421E2N	30.5mm, RELU L50, 1A-120V AC/DC, PUSH-10-1E1	3
10	RELAY	OMRON	MY4N-CR	120VAC, 4-POLE WITH INDICATOR	4
11	RELAY BASE FOR OMRON MY4N-CR	OMRON	PYZ14T	4-POLE RELAY SOCKET, SCREW TERMINAL, FOR MY4N-CR	4
12	TIMER RELAY	PHOENIX CONTACT	2905813	ETD-BL-1T-230, ADJUSTABLE TIME RANGE OF 50MS - 1H	1

Toronto Water

ARCADIS
1000 KENNEDY ROAD
TORONTO, ONTARIO, M9W 0C9
TEL 416 679 1000 FAX 416 675 4020
www.arcadis.com

COPYRIGHT:
This drawing was prepared and/or for the Corporation. No part of this drawing may be reproduced or transmitted in any form or by any means electronic or mechanical, including photocopying, recording, or by any information storage and retrieval system, without permission in writing from the Corporation and/or its subsidiaries. This drawing is the property of the Corporation and its subsidiaries. It is to be used only for the project and location shown on the drawing. This drawing is not to be used for any other project or location without the written permission of the Corporation and its subsidiaries.

NO.	DATE	REVISIONS	INITIAL	ISSUED FOR TENDER	C.H.	ISSUED
A	2024-03-18					

Toronto




WILLIAM FERNANDES, P. ENG.
DIRECTOR
WATER TREATMENT AND SUPPLY

SIMON HOPTON, P. ENG.
DIRECTOR
DESIGN & CONSTRUCTION
MAJOR INFRASTRUCTURE

R.C. HARRIS WATER TREATMENT PLANT
INSTALLATION OF A STANDBY GENERATOR FOR CRITICAL LOADS
FILTER CV SHUTOFF CONTROL PANEL LAYOUT AND WIRING



DESIGN:	M.D.	DRAFTING:	M.D.	CHECK:	T.S.	CONTRACT No.	25ECS-MI-03HA
SCALE:	N.T.S.					DRAWING NUMBER:	2F-2017-08-100
DATE:	2024-09-30						I105

 


FLT-CP-0005 - BILL OF MATERIALS

ITEM	EQUIPMENT	MANUFACTURER	PART #	DESCRIPTION	QTY
1	ENCLOSURE	BAISON	N12-201608	5084046201 (20x16x6), WALL MOUNTED/SINGLE DOOR NEMA 12	1
2	ENCLOSURE SUNDRIES	LEGIO OR EQUIVALENT		WIRE CUT, 6"x4", 4"x4", 3"x4", 2"x4", 4"x3", 3"x3", 2"x3", GRAY, AS SHOWN IN PANEL LAYOUT	AR
3	GROUND BARS	ISO	N-174	COPPER, CUT TO SIZE	AR
4	TERMINAL BLOCK	PHOENIX CONTACT	2045102	GRY TERMINAL, M4/M5	AR
5	TERMINAL BLOCK	PHOENIX CONTACT	3022276	END STOPS	AR
6	TERMINAL BLOCK	PHOENIX CONTACT	3047167	GRY SEPARATOR END SECTION	AR
7	TERMINAL BLOCK	PHOENIX CONTACT	1051003	TERMINAL MARKING STRIP	AR
8	PILOT LIGHT W/ PUSH TO TEST	ALLEN BRADLEY	800T-QT328	30.5mm, RED LED, 12-30V AC/DC, PUSH-TO TEST	1
9	2-POSITION SELECTOR SWITCH	ALLEN BRADLEY	800T-PS2A	40.27mm x 2-POSITION MAIN/PAINT SELECTOR SWITCH, STANDARD KNOB, 1/8" I.D.C.	1
10	RELAY	MYNAR	MYNAR-C	120VAC, 4-POLE WITH INDICATOR	1
11	RELAY BASE FOR OMRON MY4N-C	OMRON	PFY214T	4-POLE RELAY SOCKET, SCREW TERMINAL, FOR MY4N-C	3

NOTES:
1. REFER TO DRAWING E212 FOR DETAILS ON THE LOCATION
OF THE NEW FILTER CV PANEL FLT-CP-0005

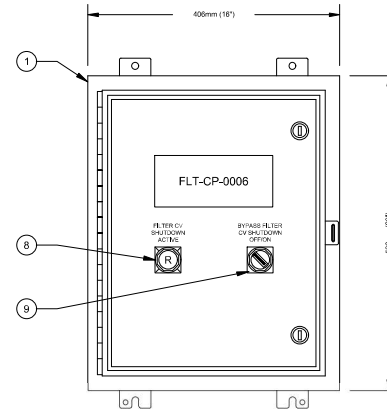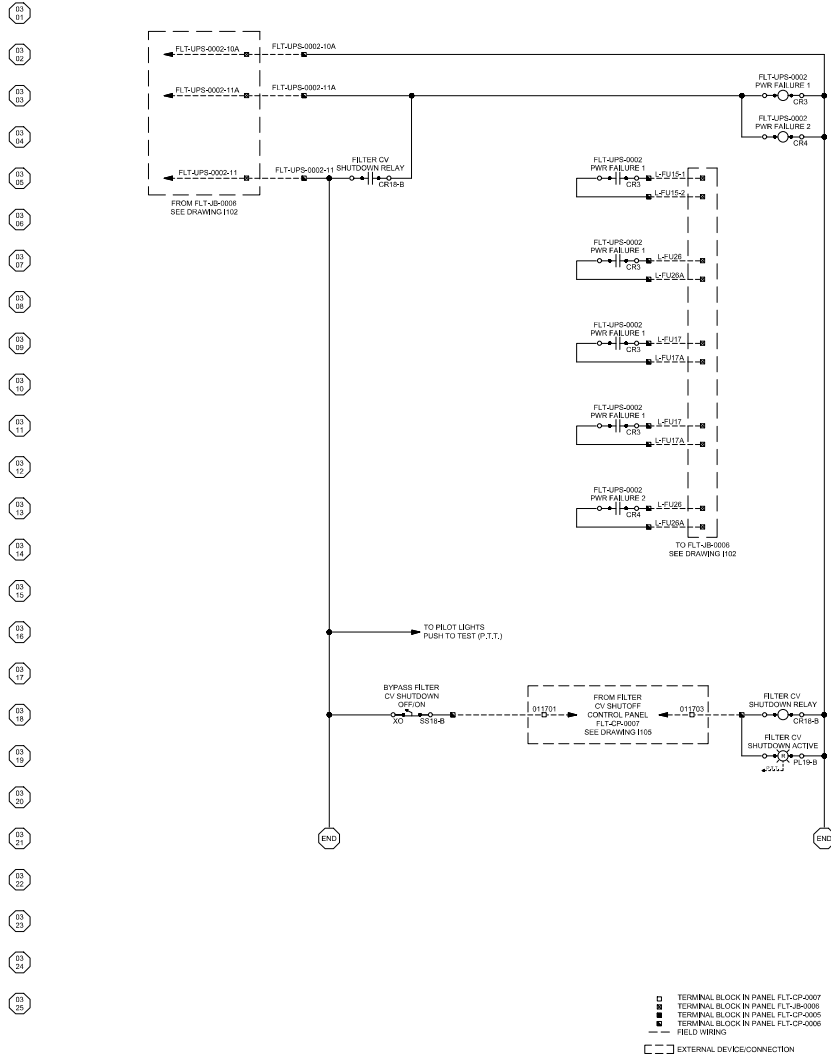

NEW FLT-CP-0006 PANEL

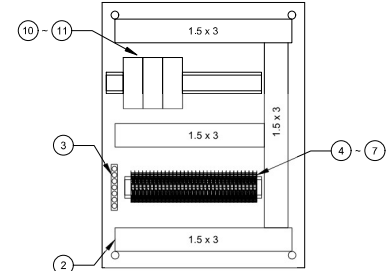

INTERIOR BACKPLATE

FLT-CP-0006 - BILL OF MATERIALS

ITEM	EQUIPMENT	MANUFACTURER	PART #	DESCRIPTION	QTY
1	ENCLOSURE	RAILSTON	N12-201608	508x406x203 (20x16x8), WALL MOUNTED/SINGLE DOOR NEMA 12	1
2	ENCLOSURE SUNDRIES	PANOUTIT OR EQUIVALENT		WIRE DUCT, 6"x4", 4"x4", 3"x4", 2"x4", 4"x3", 3"x3", 2"x3", 2"x3", GRAY, AS SHOWN IN PANEL LAYOUT	AR
3	GROUND BAR	USCO	N-174	COPPER, CUT TO SIZE	1
4	TERMINAL BLOCK	PHOENIX CONTACT	3044102	GREY TERMINAL MA/6	AR
5	TERMINAL BLOCK	PHOENIX CONTACT	3022276	END STOPS	AR
6	TERMINAL BLOCK	PHOENIX CONTACT	3047167	GREY SEPARATOR END SECTION	AR
7	TERMINAL BLOCK	PHOENIX CONTACT	1051003	TERMINAL MARKING STRIP	AR
8	PILOT LIGHT W. PUSH TO TEST	ALLEN BRADLEY	800T-QTE2R	30.5mm, RED LED, 12-130V AC/DC, PUSH-TO-TEST	1
9	2-POSITION SELECTOR SWITCH	ALLEN BRADLEY	800T-H2A	30.5mm 2-POSITION MAINTAINED SELECTOR SWITCH, STANDARD KNOB, 1N.O. / 1N.C.	1
10	RELAY	OMRON	MY4N-CR	120VAC, 4-POLE WITH INDICATOR	3
11	RELAY BASE FOR OMRON MY4N-CR	OMRON	PYF214T	4-POLE RELAY SOCKET, SCREW TERMINAL, FOR MY4N-CR	3
12					

NOTES:
1. REFER TO DRAWING 8213 FOR DETAILS ON THE LOCATION OF THE NEW FILTER CV PANEL FLT-CP-0006

Toronto Water

Toronto



WILLIAM FERNANDES, P. ENG.
DIRECTOR
WATER TREATMENT AND SUPPLY

SIMON HOPTON, P. ENG.
ENGINEER
DESIGN & CONSTRUCTION
MAJOR INFRASTRUCTURE

R.C. HARRIS WATER TREATMENT PLANT
INSTALLATION OF A STANDBY GENERATOR FOR CRITICAL LOADS
FLT-CP-0006 CONTROL PANEL

INSTRUMENTATION					
DESIGN:	M.D.	DRAFTING:	M.D.	CHECK:	J.G.C.
SCALE:	N.T.S.			DRAWING NUMBER:	2F-2017-08-102
DATE:	2024-09-30				1107

ARCADIS
100 AVENUE REXBURN
TORONTO, ONTARIO, M9W 0G9
TEL 416 679 1001 FAX 416 675 4820
www.arcadis.com

COPYRIGHT:
This drawing was prepared and is the intellectual property of ARCADIS Professional Services (Canada) Inc. All rights are reserved. No part of this drawing may be reproduced or transmitted in any form or by any means electronic or mechanical, including photocopying, recording, or by any information storage and retrieval system, without prior written permission from ARCADIS Professional Services (Canada) Inc. This drawing is provided as a service to the client and is not to be used for any other purpose without the prior written consent of ARCADIS Professional Services (Canada) Inc.

NO.	DATE	REVISIONS	INITIAL	ISSUED
A	2024-03-18	ISSUED FOR TENDER	C.H.	