

3. ALL DIMENSIONS ARE TO THE FINISHED SURFACES UNLESS NOTED OTHERWISE.
2. DO NOT SCALE DRAWINGS – USE DIMENSIONS.
3. ALL CONSTRUCTION IS NEW UNLESS OTHERWISE NOTED.
4. CONTRACTOR MUST VERIFY ALL DIMENSIONS AND BE RESPONSIBLE FOR SAME. REPORT ANY ERRORS OR OMISSIONS TO THE ARCHITECT IN WRITING PRIOR TO COMMENCING WORK. PRINTS ARE NOT TO BE SCALED.
5. ALL CONSTRUCTION SHALL BE IN COMPLIANCE WITH CURRENT BUILDING CODE AND WITH ALL OTHER CODES, ORDINANCES AND REQUIREMENTS HAVING JURISDICTION.
6. ALL WORK RELATING TO THIS CONSTRUCTION SHALL COMPLY WITH THE PROVINCIAL MINISTRY OF LABOUR, THE OCCUPATIONAL HEALTH AND SAFETY STANDARDS AND ALL RELATED LOCAL BUILDING CODES AND ORDINANCES.
7. DRAWINGS ARE TO BE READ IN CONJUNCTION WITH ALL OTHER ARCHITECTURAL, MECHANICAL & ELECTRICAL DRAWINGS FOR A COMPLETE SCOPE OF WORK.
8. INFORMATION SHOWN HEREIN ARE BASED ON PREVIOUS RECORDS & DRAWINGS. THE ACCURACY OF THIS DATA HAS BEEN MODERATELY VERIFIED WITH FRAGMENTARY DIMENSIONS WHERE POSSIBLE.
9. PATTERNS OF HATCHING ARE GRAPHIC REPRESENTATIONS ONLY. THEY DO NOT REPRESENT THE PLACEMENT OR COURSING.
10. IT IS THE GENERAL CONTRACTORS RESPONSIBILITY TO REMOVE, STORE & RELOCATE / RENT/STAL ALL FIXED IN PLACE MILLWORK, EQUIPMENT ETC. IN AREAS OF WORK. THE GENERAL CONTRACTOR WILL PATCH, REPAIR OR REPLACE ANY DAMAGED ITEMS, UNDER HIS RESPONSIBILITY AS A CONSEQUENCE OF IMPROPER STORAGE OR HANDLING, AT HIS OWN EXPENSE. THE GENERAL CONTRACTOR SHALL CO-ORDINATE WITH THE SCHOOL BOARD WHEN THE ITEMS, UNDER HIS RESPONSIBILITY, SHALL BE RENT/STALLED (WHEN THAT AN INSPECTION FOR DAMAGE SHALL BE CONDUCTED BY THE SCHOOL BOARD).
11. CRACKING IN CONCRETE SLAB NOT RELATED TO TRANSITIONS OR SAWCUTTING ARE TO BE CLEANED OUT, INFILLED & LEVELLED SMOOTH. GRIND SMOOTH, INFILL AND PATCH LOCATIONS OF SAWCUTS OR TRANSITION JOINTS & COLUMNS ISOLATION JOINTS TO MAKE TRANSITION IMPERCEPTIBLE IN PREPARATION OF INSTALLATION OF ALL NEW FLOORING. GENERAL CONTRACTOR TO SITE CONFIRM LOCATIONS.
12. LEVEL SLAB AREAS AFTER ANY REMOVALS WHICH MAY HAVE DIFFERENT ELEVATIONS.
13. WHERE FLOORING IS BEING REMOVED, GRIND SMOOTH EXISTING CONCRETE FLOOR SLAB TO REMOVE ANY REMNANT ADHESIVE, MORTAR ETC. & MAKE READY TO RECEIVE NEW FLOOR FINISHES.
14. ADJUST AS REQUIRED ALL DRAINS AND CLEAN-OUTS TO SUIT NEW FLOORING ELEVATION; NEATLY CUT FLOORINGS AROUND CLEAN-OUTS.
15. "MAKE GOOD" SHALL BE DEFINED AS: WHEN THE WORK IS COMPLETED ALL FINISHES, MATERIALS & SURFACES ARE TO RESEMBLE A NEW INSTALLATION, THIS WILL INCLUDE INFILLING, PATCHING & SANDING. THIS WILL BE APPLIED TO ALL AREAS WHERE REMOVAL OR REMOVAL OCCURS & TO ANY SURFACES DAMAGED THROUGHOUT THE COURSE OF CONSTRUCTION. PATCHING IS THE REPAIRING OF ALL MATERIALS, SURFACES & FINISHES WHICH SHALL BE THE ADJACENT FINISHES & COLOURS UNLESS OTHERWISE NOTED. WHERE RE-PANTING IS REQUIRED, THE EXISTING SURFACE PLAN SHALL ALSO BE PAINTED.
16. ALL MECHANICAL & ELECTRICAL SERVICES RELATED TO EQUIPMENT, MILLWORK, REMOVALS, RELOCATIONS & DEMOLITIONS SHALL BE DISCONNECTED & CAPPED BENEATH THE FINISHED FLOOR LEVEL. MAKE GOOD ALL SLAB OPENINGS AS REQUIRED & MAKE READY TO ACCEPT NEW FINISHES. REFER TO MECHANICAL AND ELECTRICAL DRAWINGS FOR A COMPLETE SCOPE OF WORK.

1. SELECTIVE DEMOLITION OF WALLS AND CEILINGS AS REQUIRED TO ACCOMMODATE INSTALLATION OF STRUCTURAL, MECHANICAL AND ELECTRICAL ROUGH-INS AND EQUIPMENT.

The figure contains three technical drawings labeled W1, W2, and W3.

- W1:** A cross-section of a masonry partition. It shows a central block with a diamond pattern, flanked by two vertical lines representing reinforcement or joints. The total height is 190mm.
- W2:** A cross-section of an interior partition. It shows a central block with a diamond pattern, flanked by two vertical lines representing reinforcement or joints. The total height is 190mm, with a 12mm gap at the top and bottom.
- W3:** A cross-section of an interior partition. It shows a central block with a diamond pattern, flanked by two vertical lines representing reinforcement or joints. The total height is 190mm, with a 12mm gap at the top and bottom.

MASONRY PARTITION:
190mm CONCRETE MASONRY STANDARD BLOCK UNIT, PAINTED

INTERIOR PARTITION:
12mm GYPSUM BOARD, PAINTED
90° METAL STUDS @ 400mm O.C.

Technical drawings of fire-rated screen details A, B, and C, showing dimensions and components.

Detail A: Shows a screen with a height of 2195 and a width of 1465. The screen is divided into two sections, each with a height of 1095 and a width of 732.5. The screen is mounted on a base with a height of 305 and a width of 50. The screen is labeled "REFER TO SCHEDULE" and "1G".

Detail B: Shows a screen with a height of 2150 and a width of 1155. The screen is divided into two sections, each with a height of 1075 and a width of 577.5. The screen is mounted on a base with a height of 845 and a width of 50. The screen is labeled "VISION PANEL" and "1G".

Detail C: Shows a screen with a height of 1865 and a width of 2350. The screen is divided into two sections, each with a height of 932.5 and a width of 1175. The screen is mounted on a base with a height of 790 and a width of 50. The screen is labeled "FIRE RATED SCREEN".

[illegible]

GREY TONE REPRESENTS EXISTING

EXISTING VESTIBULE ← ROOM NAME 101 ← NUMBER	EXISTING ROOM NAME & NUMBER	NEW VESTIBULE ← ROOM NAME 101 ← NUMBER	NEW ROOM NAME & NUMBER
--	--	---	-----------------------------------

DETAIL NUMBER A-300 SHEET NUMBER	SECTION REFERENCE	DOOR & FRAME DOOR NUMBER	MODIFIED DOOR & NUMBER REFERENCE
DETAIL NUMBER A-210 SHEET NUMBER	BUILDING CROSS SECTION REFERENCE	FIRE HOSE CABINET	
1000		ELECTRICAL PANEL	
30°		FLOOR DRAIN AND SLOPES	
DETAIL NUMBER DWG NUMBER ELEVATION DIRECTION	ELEVATION REFERENCE	1000	RADIUS DIMENSION
DETAIL NUMBER A-410 SHEET NUMBER	DETAIL REFERENCE BUBBLE	30°	ANGLE DIMENSION
000 FINISH FLOOR	ELEVATION INDICATOR	01	SPECIFIC DRAWING NOTE
XXX	CEILING ELEVATION INDICATOR	1200 01 INDICATES STRUCTURAL WALL ONLY WALL TYPE WALL HEIGHT (ONLY USED IF NOT FULL HEIGHT ON INTERIOR)	WALL SCHEDULE REFERENCE TAG
GL	GRID LINE BUBBLE	VESTIBULE ← ROOM NAME 101 ← NUMBER	ROOM NAME & NUMBER
500	GRID LINE DIMENSION	MAIN ENTRANCE	
500	DIMENSION LINE	BUILDING EXIT / ENTRANCE	
01	DRAWING REVISION	01	ELEVATION NOTE TAG
01 DOOR & FRAME DOOR NUMBER	DOOR & NUMBER REFERENCE	01	SPOT ELEVATION
EXISTING DOOR		01	PLUMBING STACK
EXISTING DOOR TO BE REMOVED		52 SCREEN NUMBER GLAZING/SCREENS	SCREEN w/ NUMBER REFERENCE TAG
		W2	WINDOW NUMBER – REFER TO WINDOW SCHEDULE
		OVERHEAD ELEMENT	
		AIR BARRIER	
		VAPOUR BARRIER	
		ROOF MEMBRANE	

**Waterloo Region
District School Board**

CLIENT

WATERLOO REGION DISTRICT SCHOOL BOARD
KITCHENER

CONTACT: ROBERT PERKO
51 ARDELT AVE
KITCHENER, ON N2C 2R5
PHONE: 519-465-0362

ARCHITECTURAL

BJC architects + associates inc.

CONTACT: MR. BARRY R. JOHNSON
R.R.#2 8016 HIGHWAY #7,
GUELPH, ON N1H 6H8
PHONE: 519-822-7390
FAX: 519-822-5881

MECHANICAL & ELECTRICAL

DEI CONSULTING ENGINEERS

CONTACT: STEVE OATLEY
DUSTIN MCCONKEY
55 NORTHLAND ROAD,
WATERLOO, ON N2V 1Y8
PHONE: 519-725-3555


ACJ TILE. –	ACOUSTIC TILE	GALV. –	GALVANIZED	PTD. –	PAINTED
ADJ. –	ADJUSTABLE	G.C. –	GENERAL CONTRACTOR	PART. –	PARTIAL
A.H.J. –	AUTHORITY HAVING JURISDICTION	GLAZ. –	GLAZING	P. LAM. –	PLASTIC LAMINATE
B.F. –	BARRIER FREE	GWB. –	GYPSSUM WALL BOARD	PLYWD. –	PLYWOOD
B.K. –	BLOCK	GA. –	GAGE	PREF'N. –	PRE-FINISHED
BD. –	BOARD	H.M. –	HOLLOW METAL	RD. –	ROOF
BLDG. –	BUILDING	HD/SLR. –	HARDENER & SEALER	REQ'D. –	REQUIRED
CLG. –	CEILING	HORIZ. –	HORIZONTAL, HORIZONTALLY	REINF. –	REINFORCED
CT. –	CERAMIC TILE	HT. –	HEIGHT	SIM. –	SIMILAR
c/w –	COMPLETE WITH	INCL. –	INCLUDING	SS. –	STAINLESS STEEL
COORD. –	COORDINATE	JT. –	JOINT	STL. –	STEEL
DEMO. –	DEMOLISH, DEMOLITION	MAX. –	MAXIMUM	STRUCT'L. –	STRUCTURAL
DN. –	DOWN	MECH. –	MECHANICAL	SUSP. –	SUSPENDED
DWG. –	DRAWING	MIN. –	MINIMUM	T.O.S. –	TOP OF SLAB
EA –	EACH	MTD. –	MOUNTED	TPR. –	TYPICAL
ELECT. –	ELECTRICAL	MTL. –	MOUNTING	u/s –	UNDERSIDE
EQ. –	EQUIVALENT, OR EQUAL	MTL. –	METAL	U.N.O. –	UNLESS NOTED OTHERWISE
EQPM'T. –	EQUIPMENT	MEZZ. –	MEZZANINE	V.B. –	VAPOUR BARRIER
EXIST. –	EXISTING	N/A. –	NOT APPLICABLE	V.C.T. –	VINYL COMPOSITION TILE
E.X. –	EXPANSION JOINT	N.I.C. –	NOT IN CONTRACT	VERT. –	VERTICAL, VERTICALLY
F.D. –	FLOOR DRAIN	N.R. –	NOT REQUIRED	W.W.F. –	WELDED WIRE FABRIC
F.F. –	FINISHED FLOOR ELEVATION	O.C. –	ON CENTRE	w/ –	WITH
FIN. –	FINISHED	O.D. –	OUTSIDE DIAMETER	WD. –	WOOD
FLR. –	FLOOR				

SUBJECT BUILDING

River Arena

Idlewood Greenway

Eby Park

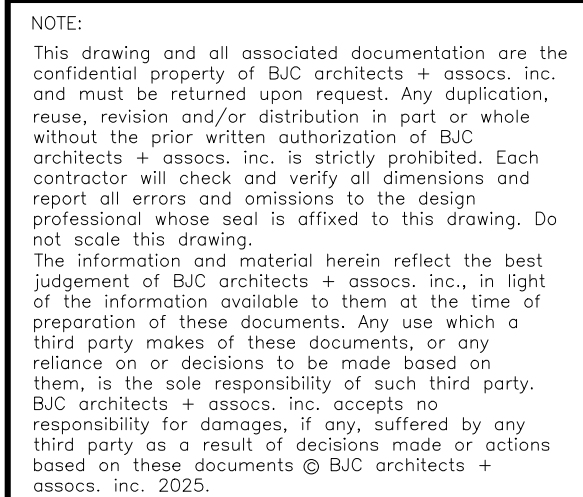

01	ISSUED FOR TENDER	2026, 04.08	
No.	REVISIONS		date



PROJECT NORTH



TRUE NORTH

scale

AS NOTED

	drawn		
	MV		
	last worked on	by	
	2026.03.18	MV	
	checked		
	B.R.J.		
	print date		
	2026.04.08		



client	
WATERLOO REGION DISTRICT SCHOOL BOARD	
51 ARDELT AVE KITCHENER	ONTARIO
project	
GRAND RIVER COLLEGIATE INSTITUTE RENOVATION	
175 INDIAN RD KITCHENER	ONTARIO

drawing title GENERAL NOTES & INDEX	
reference	
project no. 25-092	client reference number
sheet no.	


A

-

001

0

1

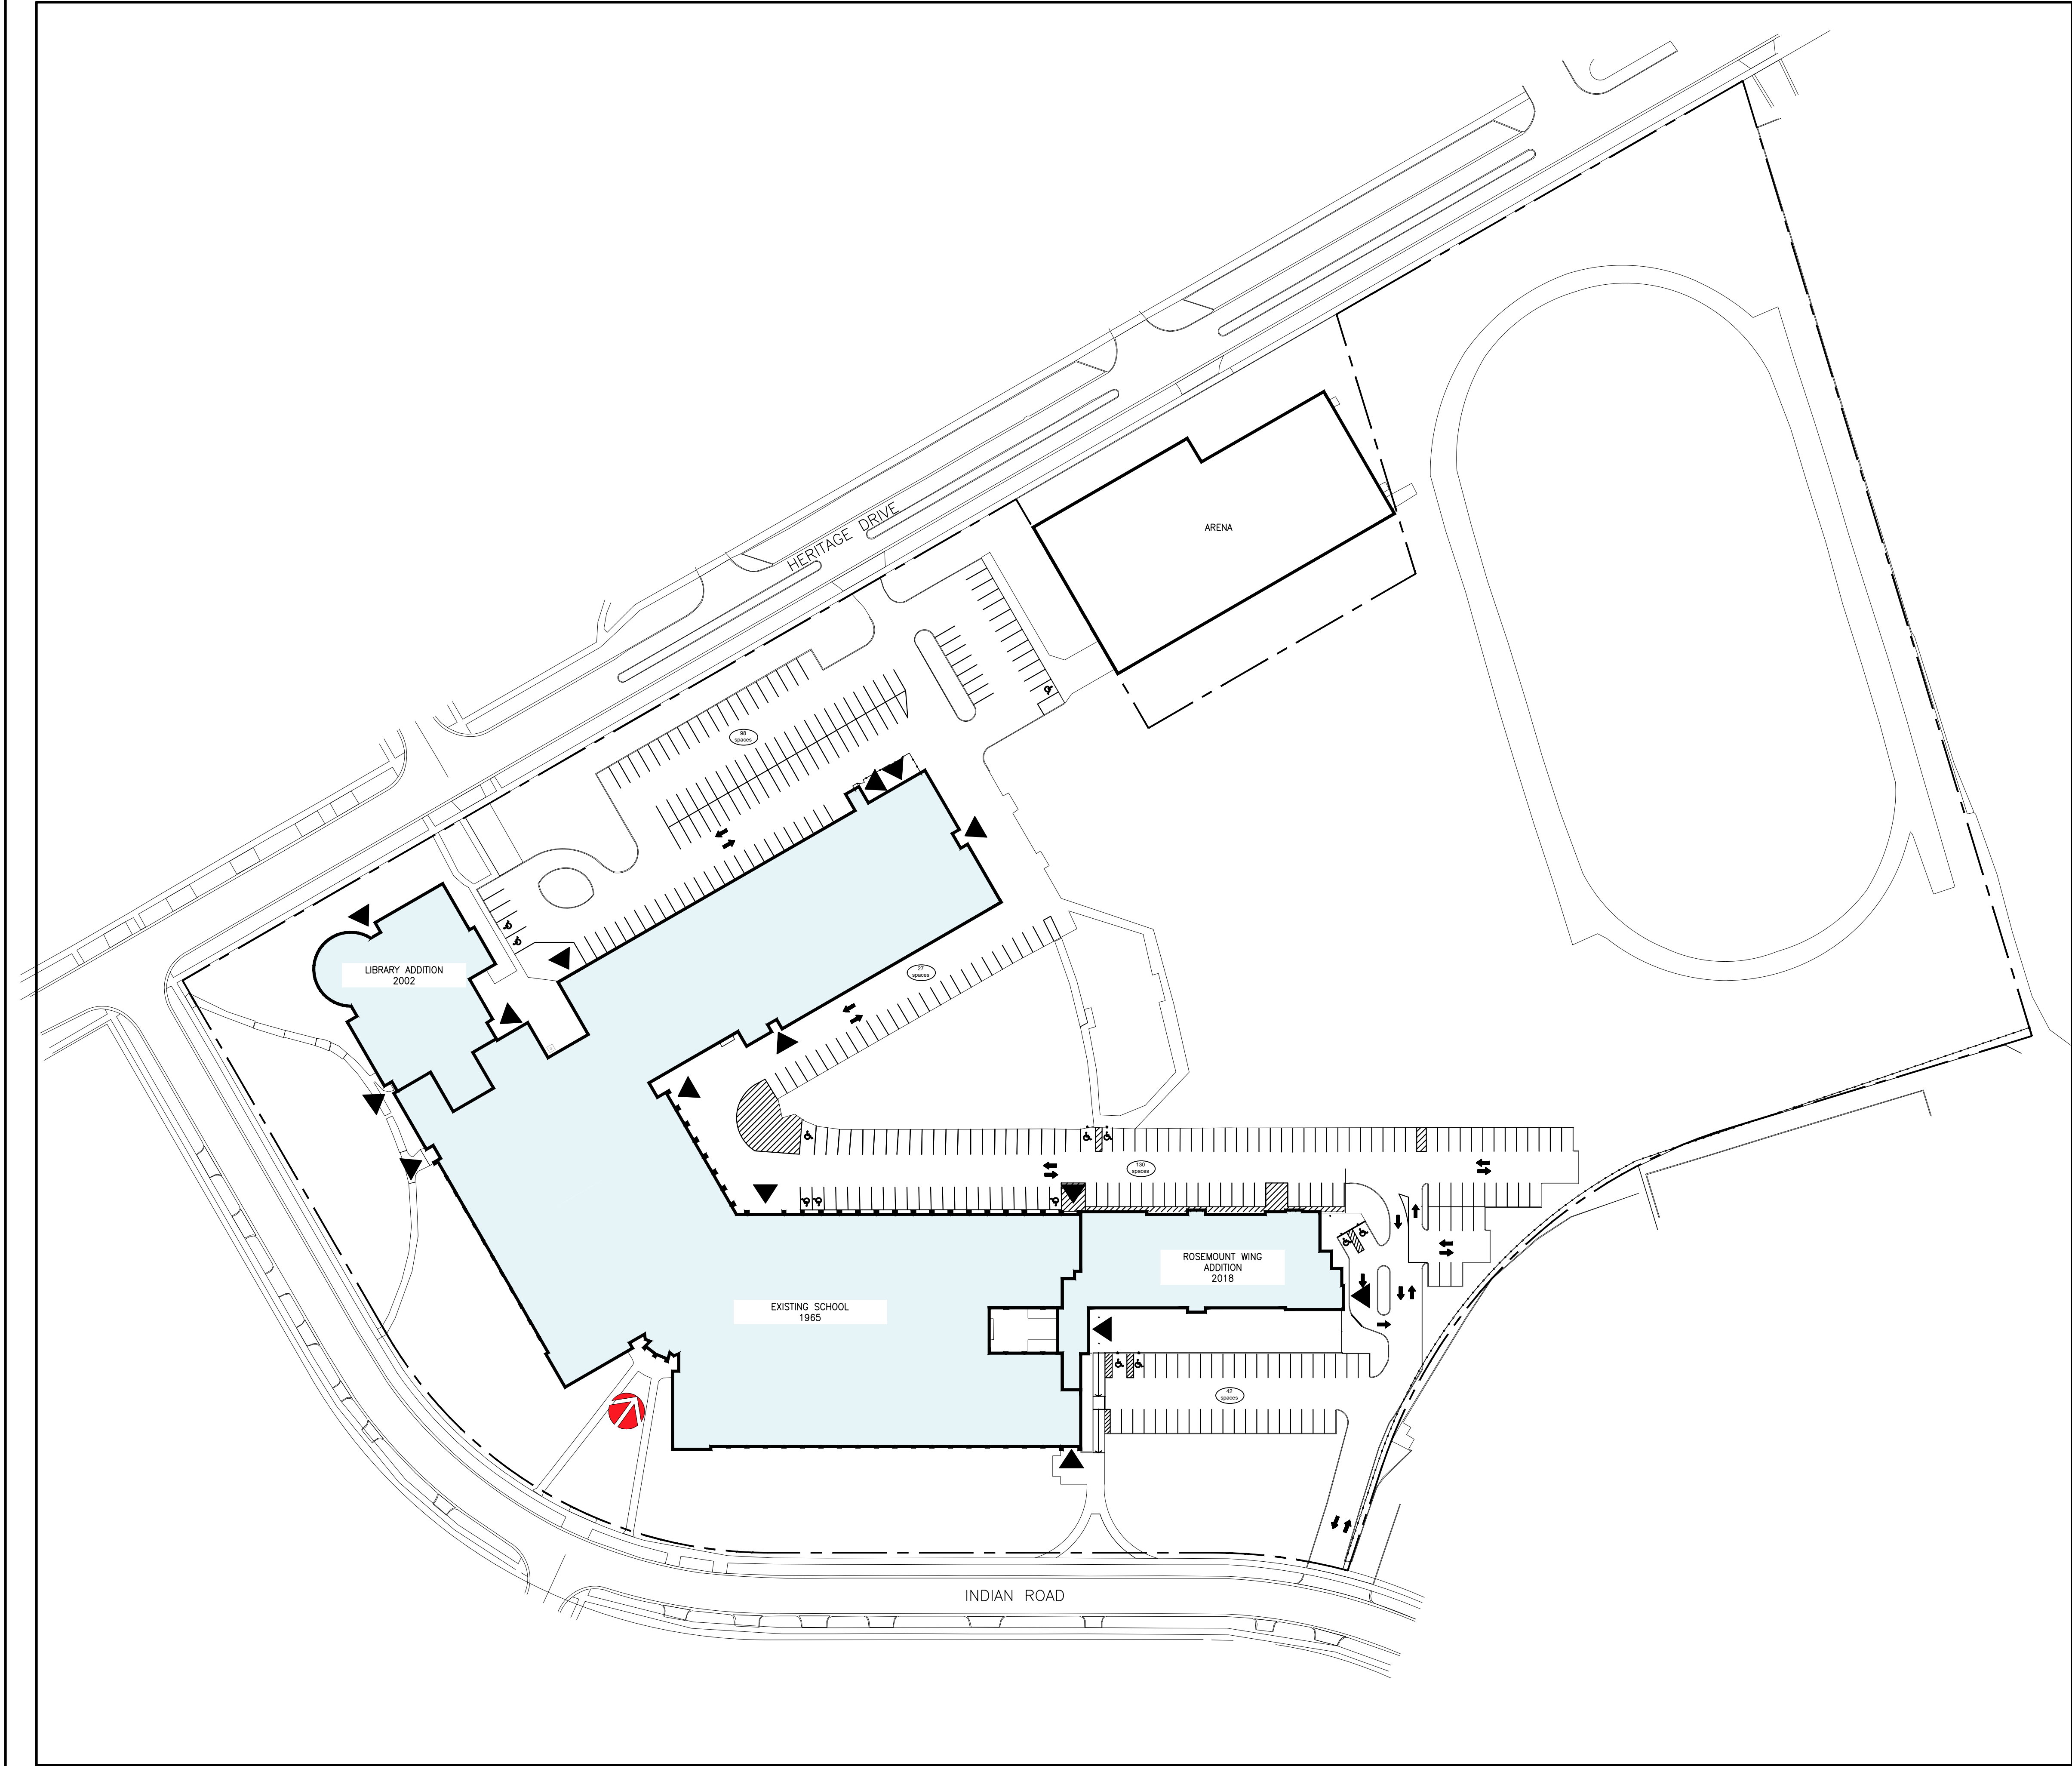

1 SITE PLAN
scale: 1 : 750

KEY MAP



LEGEND

-  SUBJECT BUILDING
-  BUILDING MAIN ENTRANCE
-  SECONDARY ENTRANCE/EXIT


SITE LEGAL DESCRIPTION

THE LEGAL DESCRIPTION & PROPERTY INFORMATION USED FOR THIS DRAWING HAS BEEN TRANSFERRED FROM THE SITE PLAN PROVIDED BY WATERLOO REGION DISTRICT SCHOOL BOARD FEB 2025.



NOTE:
This drawing and all associated documentation are the confidential property of BJC architects + assoc. inc. and must be returned upon request. Any duplication, reuse, revision and/or distribution in part or whole without the prior written authorization of BJC architects + assoc. inc. is strictly prohibited. Each contractor will check and verify all dimensions and report all errors and omissions to the design professional whose seal is affixed to this drawing. Do not scale this drawing.
The information and material herein reflect the best judgement of BJC architects + assoc. inc. in light of the information available to them at the time of preparation of these documents. Any use which a third party makes of these documents, or any reliance on or decisions to be made based on them, is the sole responsibility of such third party. BJC architects + assoc. inc. accepts no responsibility for damages, if any, suffered by any third party as a result of decisions made or actions based on these documents © BJC architects + assoc. inc. 2025.

01	ISSUED FOR TENDER	2026.04.08
No.	REVISIONS	date

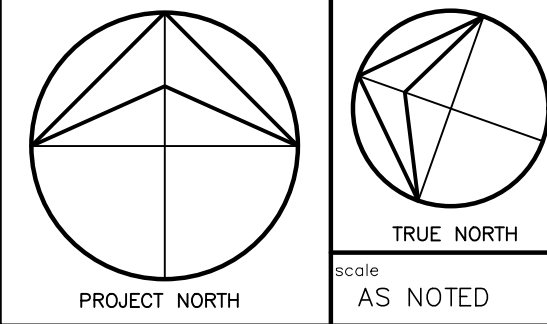



drawn	MV
last worked on by	2026.03.30 MV
checked	B.R.J.
print date	2026.04.08



client	WATERLOO REGION DISTRICT SCHOOL BOARD
51 ARDELT AVE KITCHENER	ONTARIO
project	GRAND RIVER COLLEGIATE INSTITUTE RENOVATION
175 INDIAN RD KITCHENER	ONTARIO

drawing title	SITE PLAN
reference	
project no.	25-092
client reference number	
sheet no.	A - 100 01

NOTE:
This drawing and all associated documentation are the confidential property of BJC architects + assoc.s, inc. and must be returned upon request. Any duplication, reuse, revision and/or distribution in part or whole without the prior written authorization of BJC architects + assoc.s, inc. is strictly prohibited. Each contractor will check and verify all dimensions and report all errors and omissions to the design professional whose seal is affixed to this drawing. Do not scale this drawing.
The information and material herein reflect the best judgement of BJC architects + assoc.s, inc. in light of the information available to them at the time of preparation of these documents. Any use which a third party makes of these documents, or any reliance on or decisions to be made based on them, is the sole responsibility of such third party. BJC architects + assoc.s, inc. accepts no responsibility for damages, if any, suffered by any third party as a result of decisions made or actions based on these documents © BJC architects + assoc.s, inc., 2025.

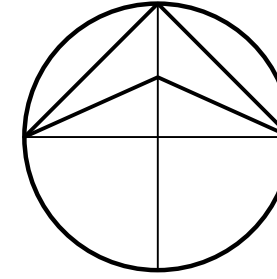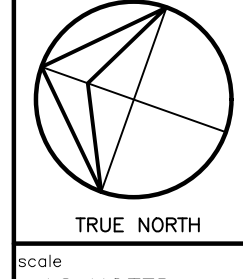01	ISSUED FOR TENDER	2026.04.02
No.	REVISIONS	date
		
PROJECT NORTH		TRUE NORTH
scale		AS NOTED

drawn	VA
last worked on by	2026.03.25 MV
checked	B.R.J.
print date	2026.04.02



client	WATERLOO REGION DISTRICT SCHOOL BOARD
51 ARDELT AVE KITCHENER	ONTARIO
project	GRAND RIVER COLLEGIATE INSTITUTE RENOVATION
175 INDIAN RD KITCHENER	ONTARIO

drawing title
OVERALL FIRST FLOOR & TRAVEL DISTANCE PLANS

reference	
project no.	25-092
client reference number	
sheet no.	

A - 105 00

ONTARIO BUILDING CODE SUMMARY

NAME OF PRACTICE: BJC architects + assoc.s, inc.		NAME OF PROJECT: GRAND RIVER COLLEGIATE INSTITUTE - KITCHENER, RENOVATIONS	LOCATION: 175 INDIAN RD, KITCHENER, ONTARIO
ITEM	2024 ONTARIO BUILDING CODE		O.B.C. REFERENCE
1.0	PROJECT DESCRIPTION:	☐ NEW ☐ ADDITION ☒ ALTERATION ☐ CHANGE OF USE	☐ PART 3 ☐ PART 9 ☒ PART 11 11.3.3.1. 11.3.3.2.
PART 11 - A2 OCCUPANCY			
11.2	EXISTING BUILDING CLASSIFICATION:	DESCRIBE EXISTING USE: CONSTRUCTION INDEX: HAZARD INDEX:	A2 SCHOOL N/A - NO CHANGE IN MAJOR N/A - NO CHANGE IN MAJOR 11.2.1. 11.2.1.1.
11.3	ALTERATIONS TO EXISTING BUILDING IS:	BASIC RENOVATION EXTENSIVE RENOVATION	☒ ☐ 11.3.3.1. 11.3.3.2.
11.4	REDUCTION IN PERFORMANCE LEVEL:	STRUCTURAL: INCREASE IN OCCUPANT LOAD: CHANGE OF MAJOR OCCUPANCY: PLUMBING: SEWAGE SYSTEMS: NOTE: NO INCREASE IN OCCUPANT LOAD, THUS NO INCREASE IN DAILY SANITARY SEWAGE FLOW.	☐ NO ☐ YES ☐ NO ☐ YES ☐ NO ☐ YES ☐ NO ☐ YES ☐ NO ☐ YES 11.4.2.1. 11.4.2.2. 11.4.2.3. 11.4.2.4. 11.4.2.5.
11.5	COMPENSATING CONSTRUCTION:	STRUCTURAL: INCREASE IN OCCUPANT LOAD: CHANGE OF MAJOR OCCUPANCY: PLUMBING: SEWAGE SYSTEM:	☒ NO ☐ YES ☐ NO ☐ YES ☐ NO ☐ YES ☐ NO ☐ YES 11.4.3. 11.4.3.2. 11.4.3.3. 11.4.3.4. 11.4.3.5. 11.4.3.6.
11.6	COMPLIANCE ALTERNATIVES PROPOSED:	NO YES	☒ ☐ 11.5.1.

NOTE 1:

THESE DRAWINGS ARE PREPARED WITH THE USE OF LINE TYPES, HATCH PATTERNS, COLOURS, AND NUMERICALLY DESIGNATED NOTES. COLLECTIVELY THESE REPRESENT THE FULL SCOPE OF WORK, WITH THE INTENT TO PROVIDE CLARITY. NOT ALL ITEMS MAY BE INDIVIDUALLY NOTED. IF ANYTHING IS AMBIGUOUS THE GENERAL CONTRACTOR IS TO ASK FOR CLARIFICATION AT THE TIME OF TENDER. FAILURE TO DO SO WILL LEAVE THE INTERPRETATION OF THE DRAWINGS TO THE ARCHITECT. THIS NOTE APPLIES TO ALL DRAWINGS.



NOTE 2:


THIS DRAWING CONTAINS THE USE OF COLOUR TO BETTER ILLUSTRATE AND DESCRIBE THE INTENT OF THE DRAWING BY HIGHLIGHTING LINE TYPES, HATCH PATTERNS, TEXT, DIMENSIONS, OR TONES. IT IS MANDATORY THAT THIS DRAWING BE PRINTED IN COLOUR FOR ITS USE. FAILURE TO DO SO WILL NOT RESULT IN ANY COMPENSATION FOR COSTS OR TIME LOST BY THE GC OR HIS/HER SUBTRADE DUE TO OMISSIONS, ERRORS, OR MISUNDERSTANDING OF THE FULL SCOPE OF THE WORK.

FIRE SAFETY LEGEND

	TD = 45.00m	END OF TRAVEL
	2 HR	DENOTES 2 HOUR FIRE SEPARATION
	1 HR	DENOTES 1 HOUR FIRE SEPARATION
		DENOTES FIRE SEPARATION (NO RATING)

  LEGEND


	APPROXIMATE AREA NOT IN CONTRACT SCOPE.		MAIN ENTRANCE.
	EXISTING WALL.		SECONDARY ENTRANCE/EXIT.
	NEW INTERIOR WALL.		
	NEW DOOR.		
	EXISTING DOOR.		

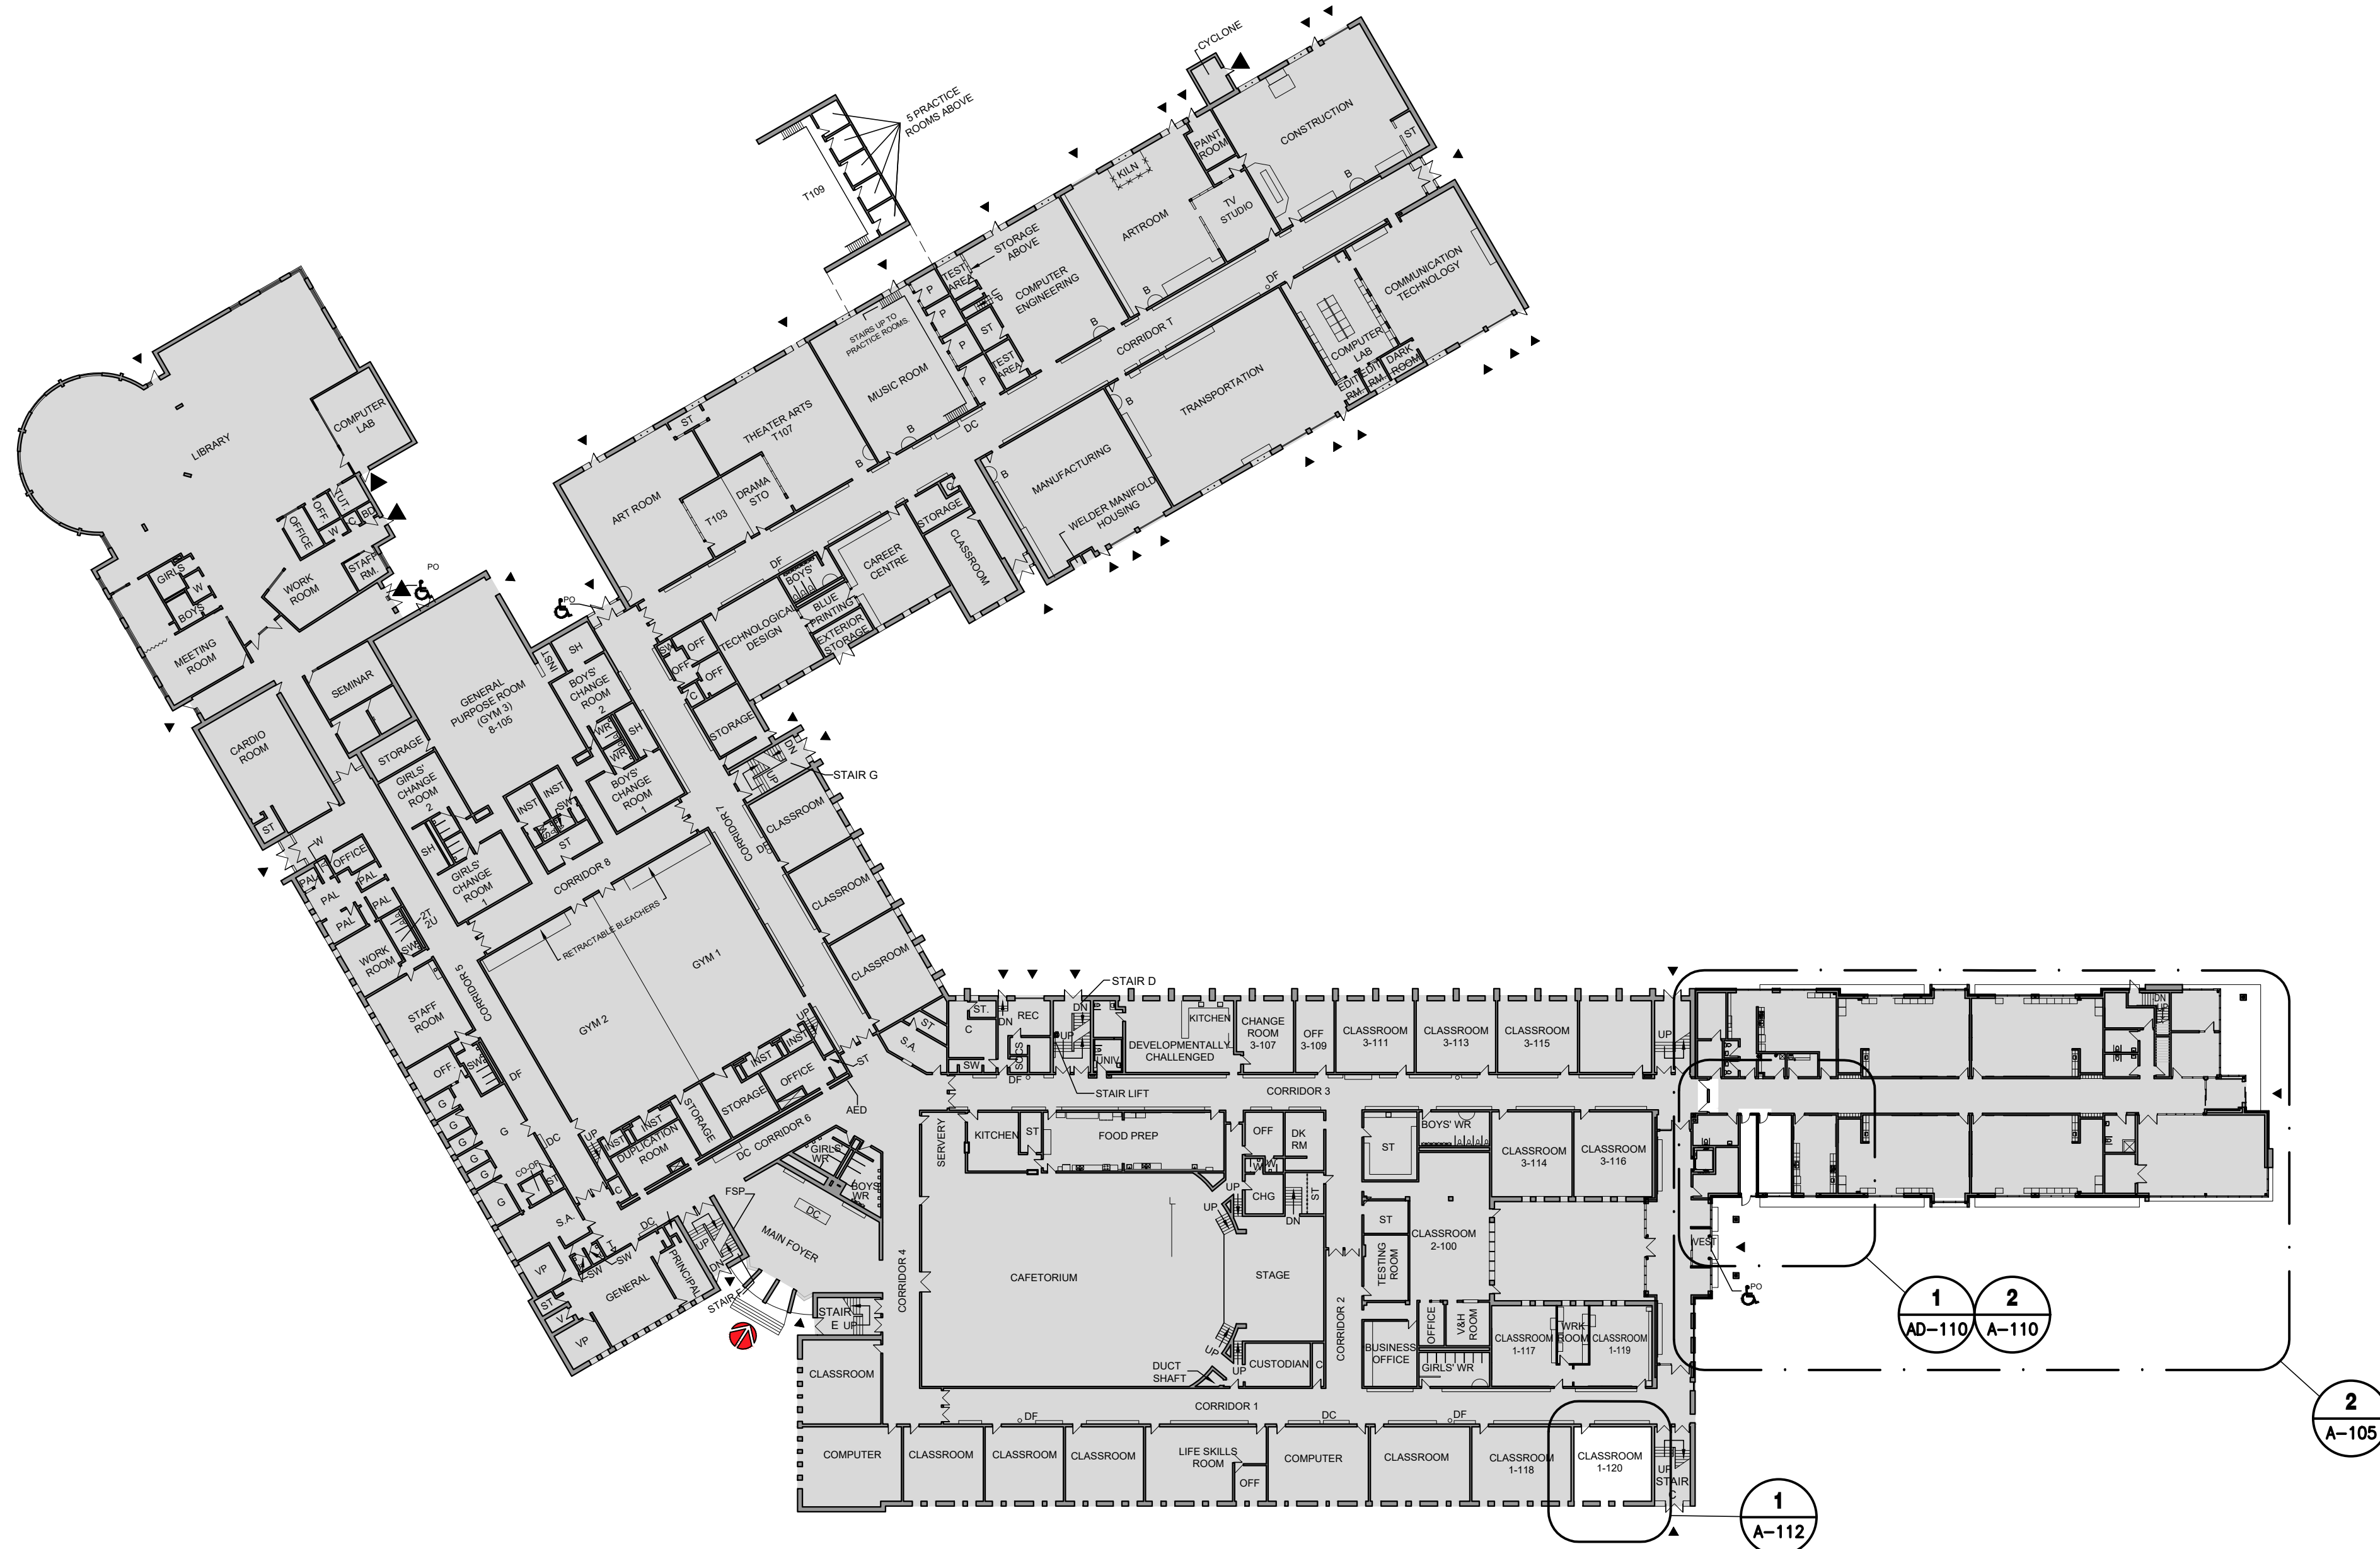

1

OVERALL FIRST FLOOR PLAN


scale: 1 : 500

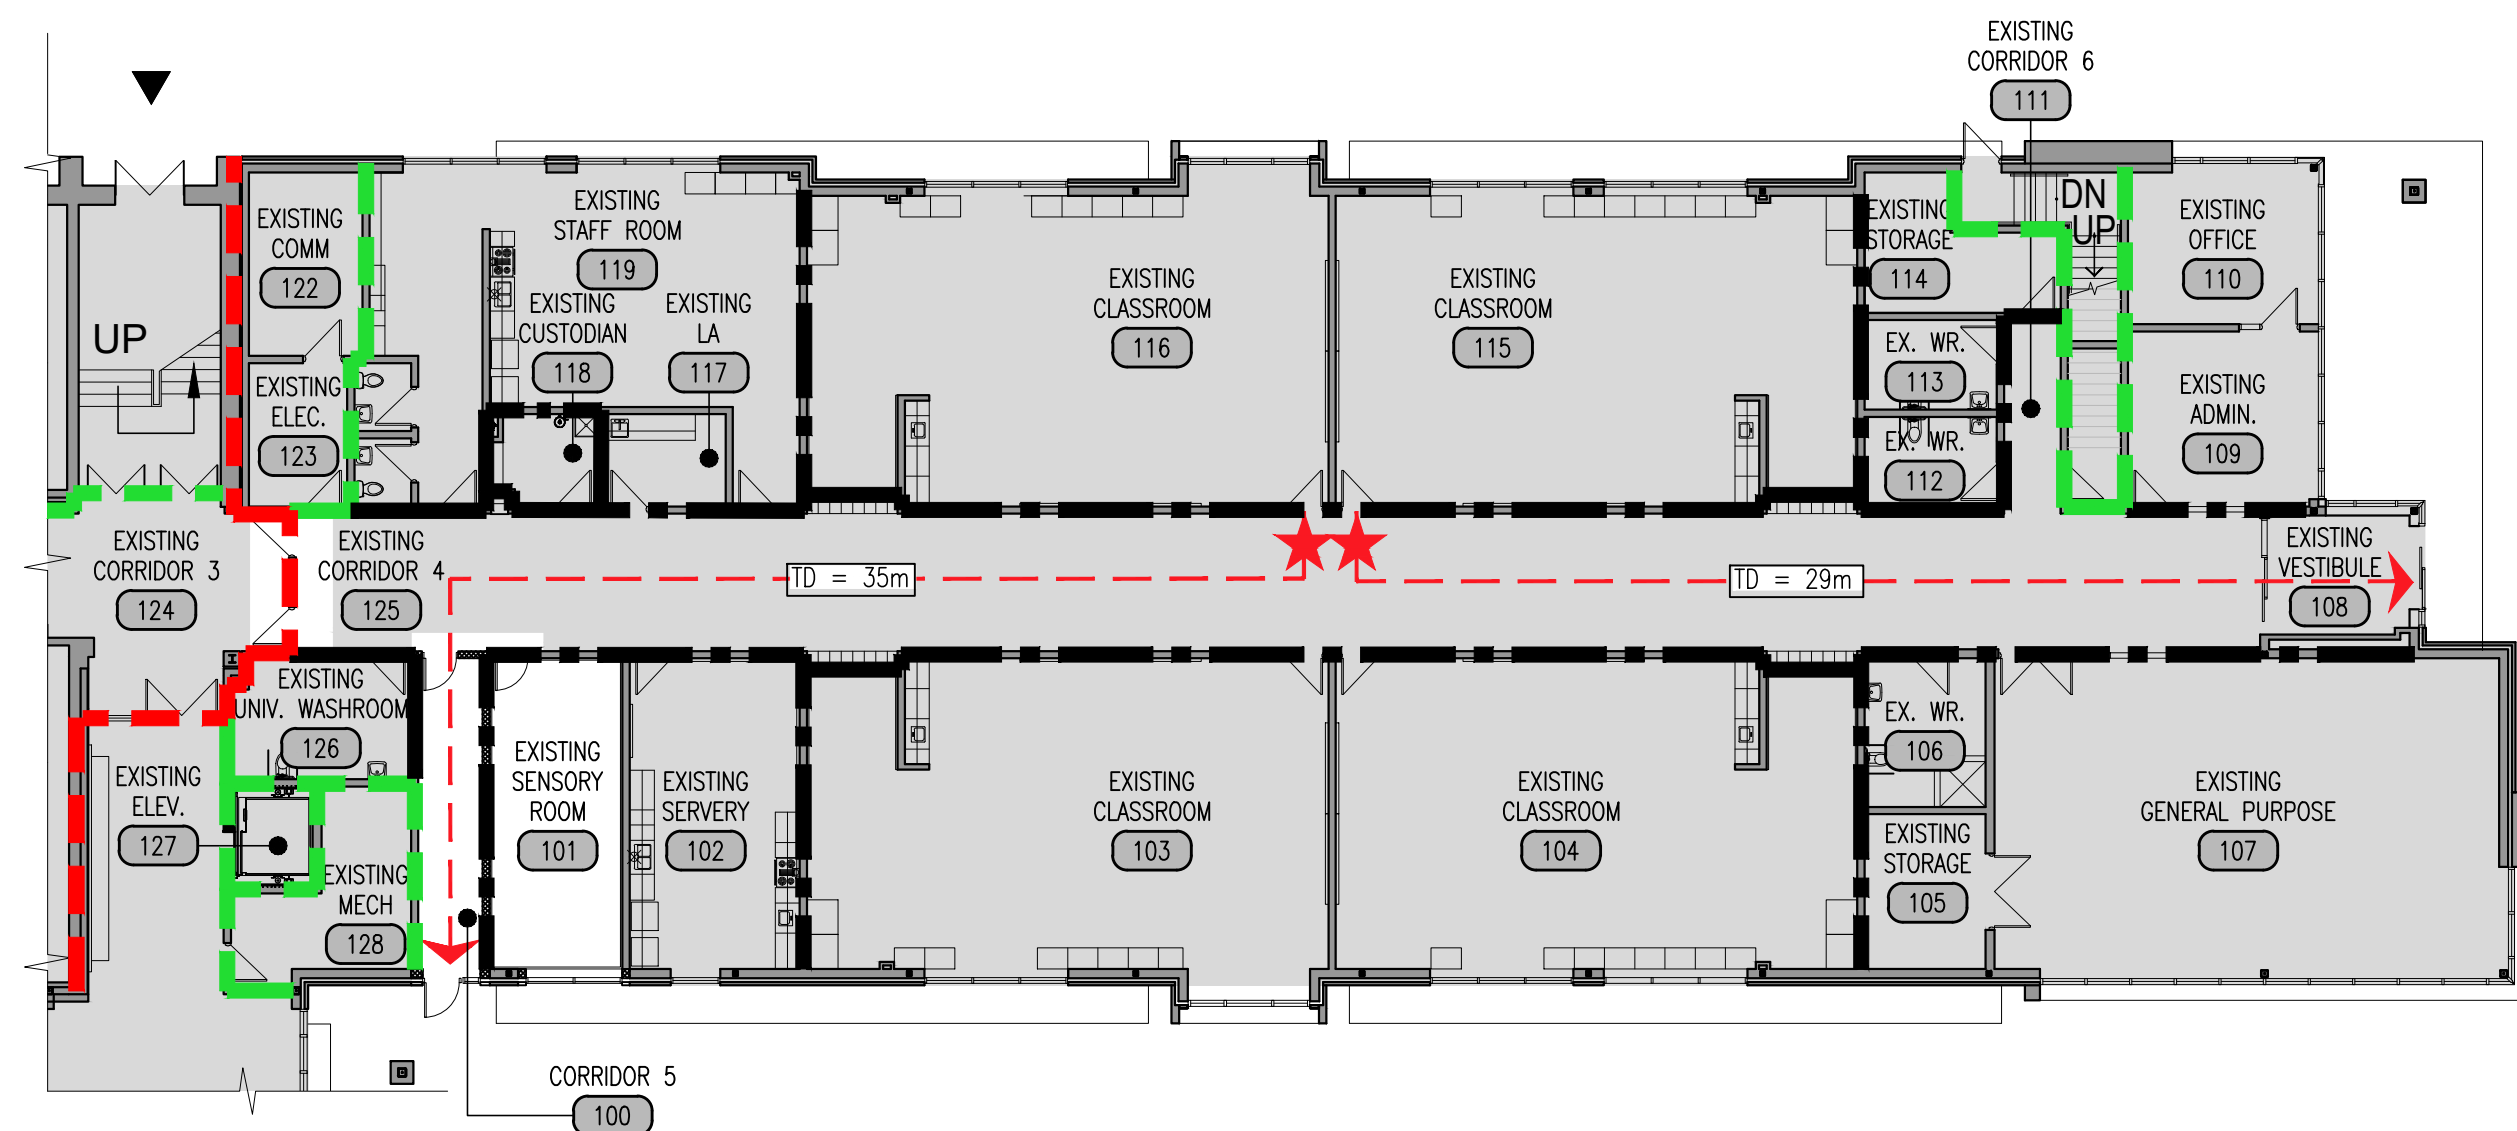

2

PARTIAL FIRST FLOOR TRAVEL DISTANCE PLAN

scale: 1 : 200

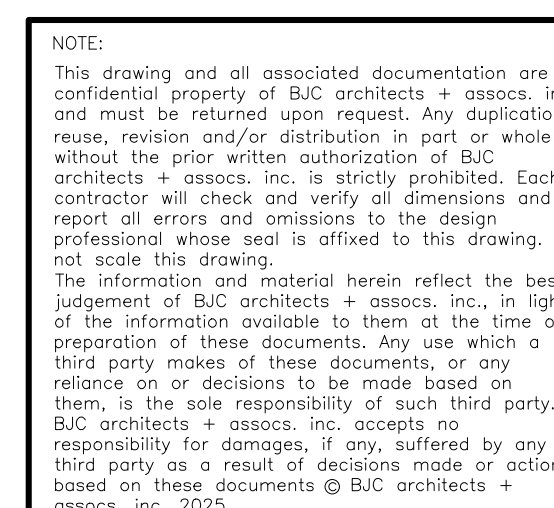

PROJECT NORTH



TRUE NORTH

scale

AS NOTED

BJC
architects + assoc. inc.

drawing title	
OVERALL SECOND FLOOR & TRAVEL DISTANCE PLANS	
reference	
project no. 25--092	client reference number
sheet no.	
A - 1 0 6 0 1	

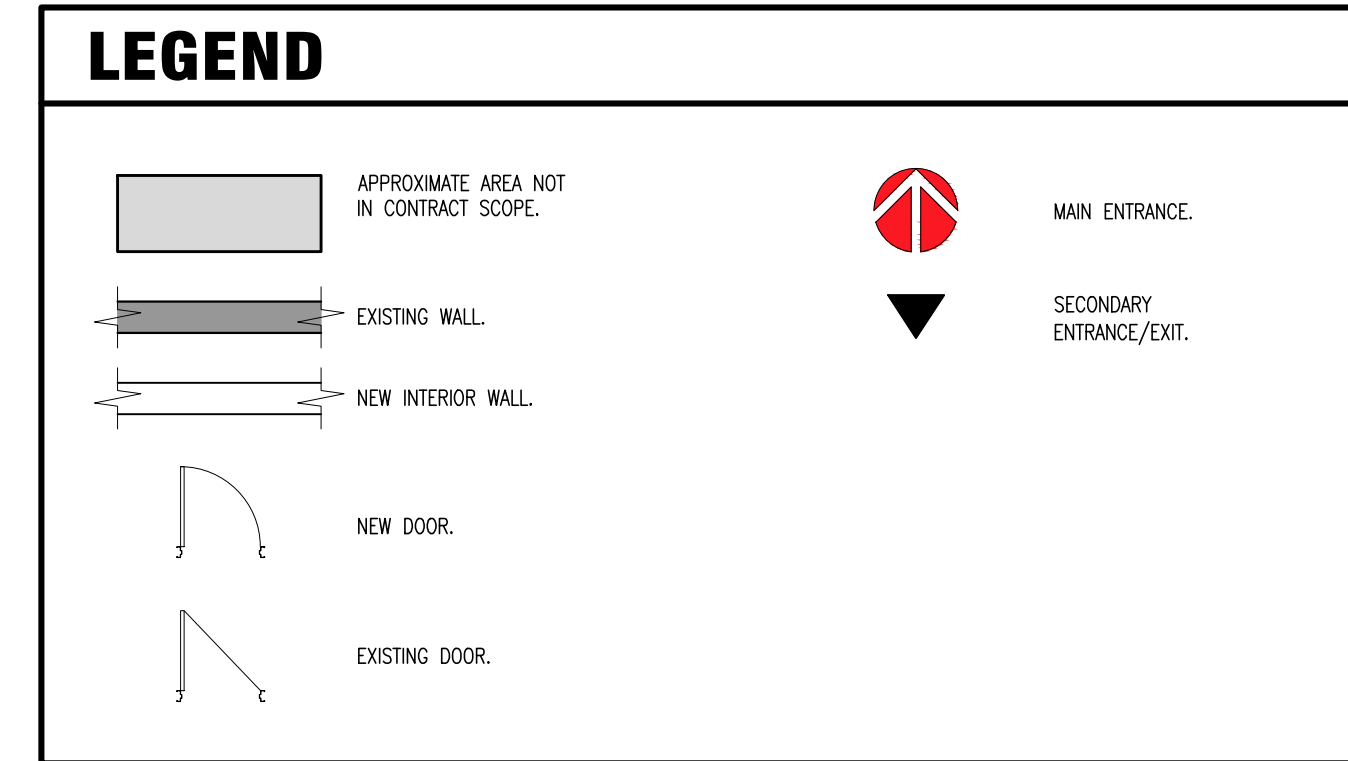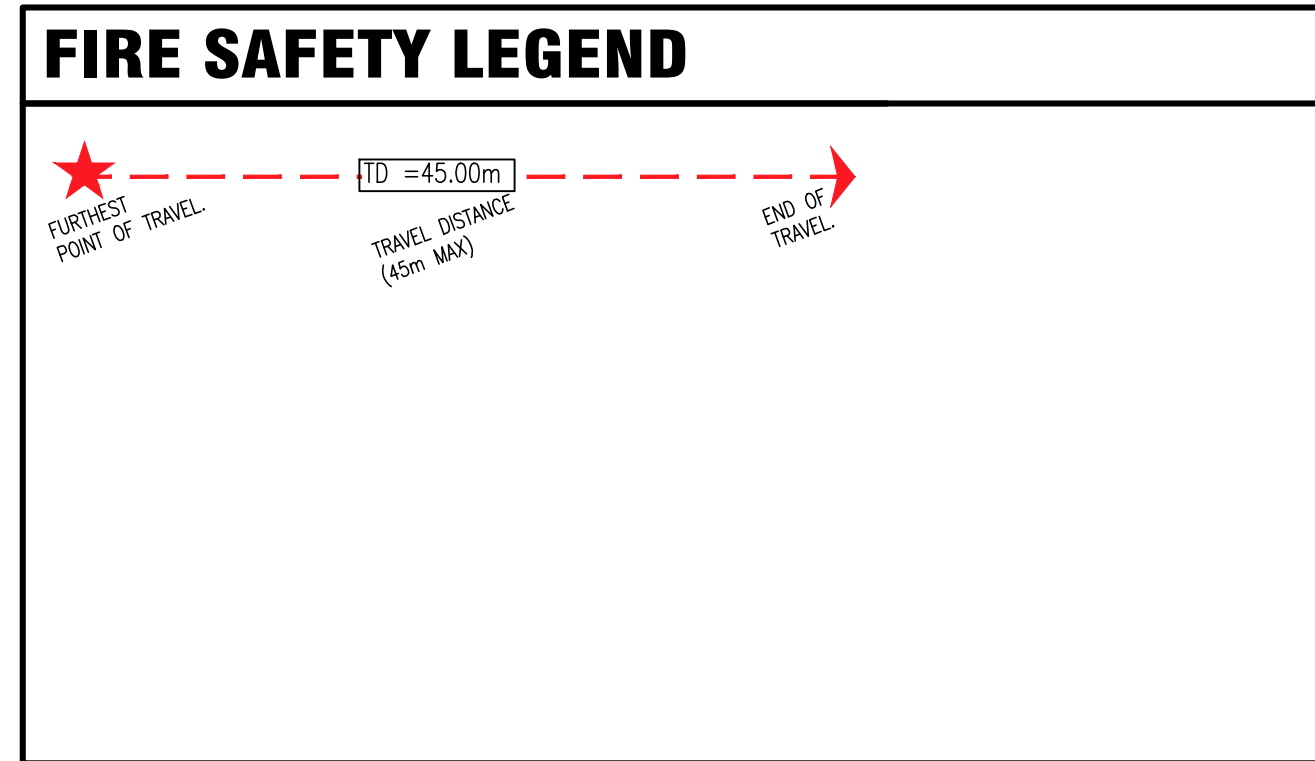

NOTE:
This drawing and all associated documentation are the confidential property of BJC architects + assoc. inc. and must be returned upon request. Any duplication, reuse, revision and/or distribution in part or whole without the prior written authorization of BJC architects + assoc. inc. is strictly prohibited. Each contractor will check and verify all dimensions and report all errors and omissions to the design professional whose seal is affixed to this drawing. Do not scale this drawing.
The information and material herein reflect the best judgement of BJC architects + assoc. inc. in light of the information available to them at the time of preparation of these documents. Any use which a third party makes of these documents, or any reliance on or decisions to be made based on them, is the sole responsibility of such third party. BJC architects + assoc. inc. accepts no responsibility for damages, if any, suffered by any third party as a result of decisions made or actions based on these documents © BJC architects + assoc. inc., 2025.

01	ISSUED FOR TENDER	2026.04.08
No.	REVISIONS	date
PROJECT NORTH		TRUE NORTH
scale		AS NOTED

drawn	MV
last worked on by	2026.03.18 MV
checked	B.R.J.
print date	2026.04.08


BJC
architects + assoc. inc.

client
**WATERLOO REGION
DISTRICT SCHOOL
BOARD**
51 ARDELT AVE
KITCHENER ONTARIO
project
**GRAND RIVER COLLEGIATE
INSTITUTE RENOVATION**
175 INDIAN RD
KITCHENER ONTARIO

drawing title
**PARTIAL FIRST
FLOOR DEMOLITION
PLAN & RCP**

reference	
project no.	25-092
client reference number	
sheet no.	

AD11001

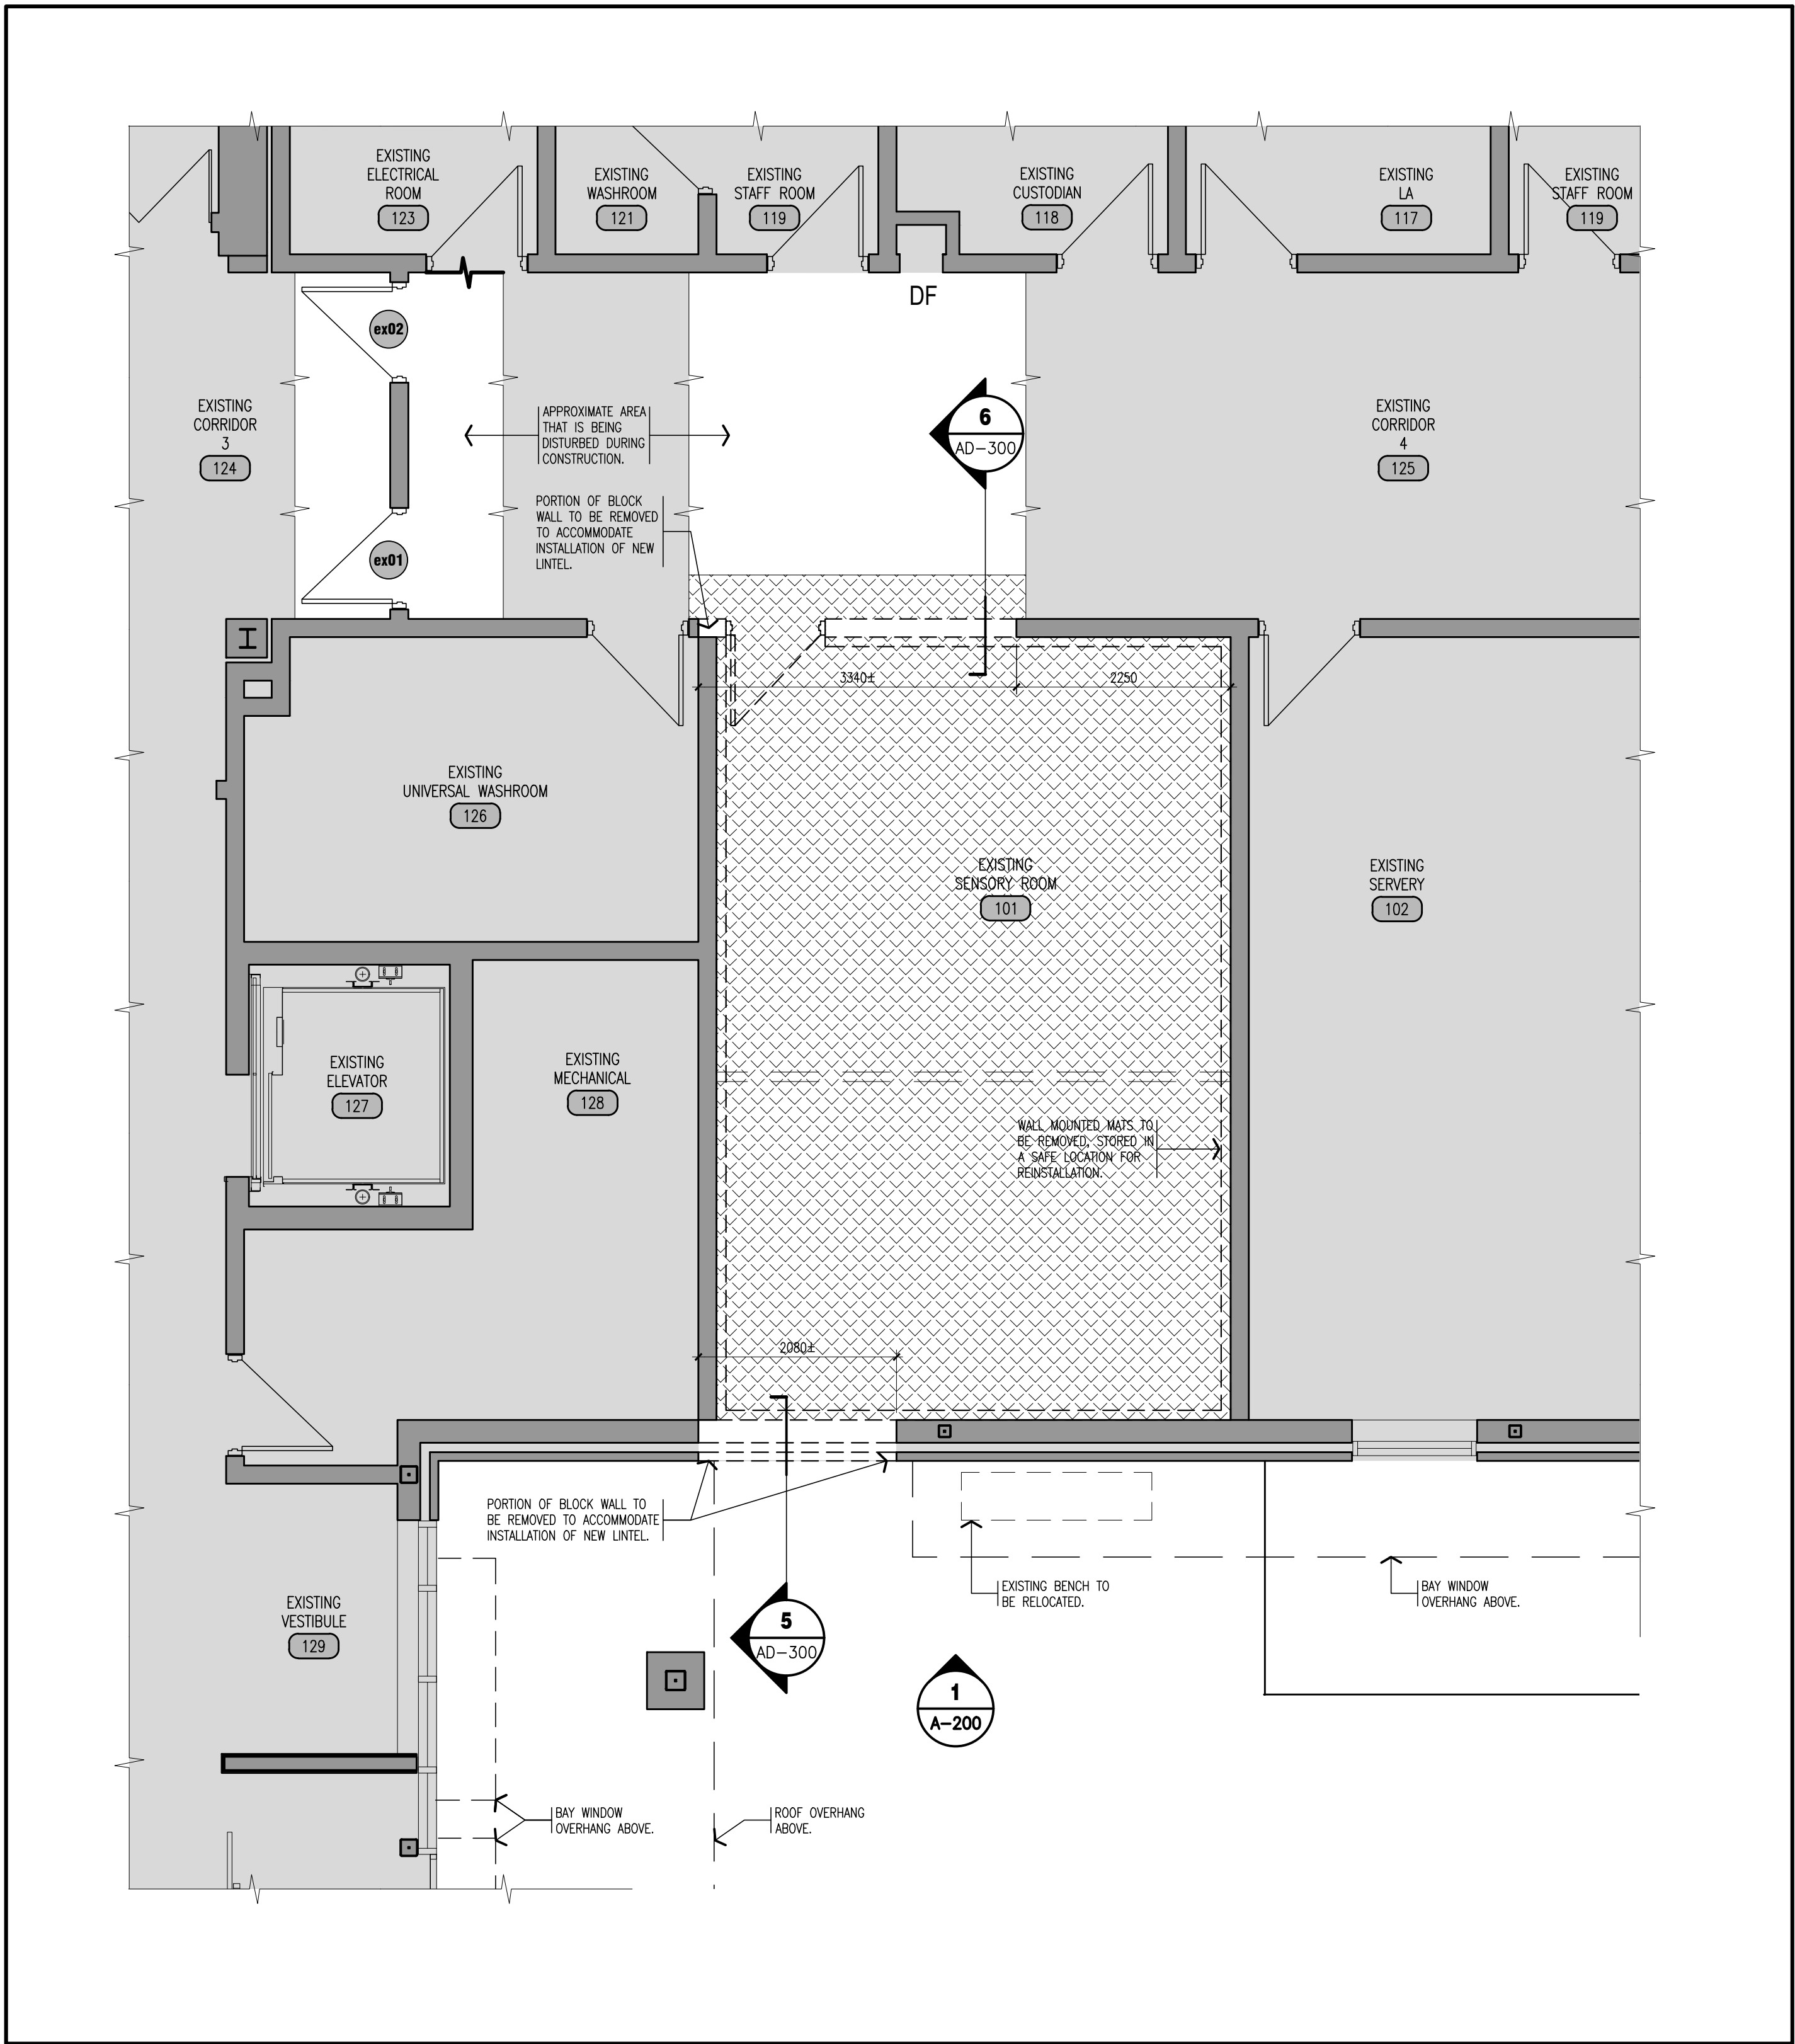

1 PARTIAL FIRST FLOOR DEMOLITION PLAN
ROSEMOUNT WING
scale: 1 : 50

GENERAL NOTES

- CONTRACTOR MUST VERIFY ALL DIMENSIONS AND BE RESPONSIBLE FOR THE SAME. REPORT ANY ERRORS OR OMISSIONS TO THE ARCHITECT IN WRITING PRIOR TO COMMENCING WITH THE WORK. PRINTS ARE NOT TO BE SCALED.
- THIS DRAWING IS TO BE READ IN CONJUNCTION WITH ALL OTHER ARCHITECTURAL, MECHANICAL & ELECTRICAL DRAWINGS FOR A COMPLETE SCOPE OF WORK. IT IS THE GENERAL CONTRACTOR'S RESPONSIBILITY TO ENSURE ALL DEMOLITION REQUIRED BY OTHER TRADES IS PRICED & COORDINATED ACCORDINGLY.
- ALL CONSTRUCTION MATERIALS TO BE REMOVED WILL BE THE RESPONSIBILITY OF THE GENERAL CONTRACTOR TO DISPOSE OF AT AN APPROVED DISPOSAL FACILITY, UNLESS OTHERWISE NOTED.
- ANY ACOUSTIC CEILING TILES REMOVED DURING THE COURSE OF CONSTRUCTION TO ACCOMMODATE THE INSTALLATION OF NEW SERVICES OR DEMOLITION WORK SHALL BE SALVAGED, STORED, & REINSTALLED. IT IS THE GENERAL CONTRACTOR'S RESPONSIBILITY TO REPLACE ALL DAMAGED CEILING TILES WITH NEW, UNLESS OTHERWISE NOTED.
- ALL MECHANICAL & ELECTRICAL SERVICES RELATED TO EQUIPMENT, MILLWORK, REMOVALS, RELOCATIONS & DEMOLITIONS SHALL BE DISCONNECTED & CAPPED BENEATH THE FINISHED FLOOR LEVEL. REFER TO MECHANICAL AND ELECTRICAL DRAWINGS FOR A COMPLETE SCOPE OF WORK.
- IT IS THE GENERAL CONTRACTOR'S RESPONSIBILITY TO REMOVE, STORE & RELOCATE / REINSTALL ALL FIXED IN PLACE MILLWORK, EQUIPMENT ETC. IN AREAS OF WORK. THE GENERAL CONTRACTOR SHALL CO-ORDINATE WITH THE OWNER WHEN THE ITEMS UNDER HIS RESPONSIBILITY, SHALL BE REINSTALLED AT WHICH TIME AN INSPECTION FOR DAMAGE SHALL BE CONDUCTED BY THE SCHOOL BOARD.
- SELECTIVE DEMOLITION OF WALLS AND CEILINGS AS REQUIRED TO ACCOMMODATE INSTALLATION OF MECHANICAL AND ELECTRICAL ROUGH-INS AND EQUIPMENT.

NOTE 1:


THESE DRAWINGS ARE PREPARED WITH THE USE OF LINE TYPES, HATCH PATTERNS, COLOURS, AND NUMERICALLY DESIGNATED NOTES. COLLECTIVELY THESE REPRESENT THE FULL SCOPE OF WORK, WITH THE INTENT TO PROVIDE CLARITY. NOT ALL ITEMS MAY BE INDIVIDUALLY NOTED. IF ANYTHING IS AMBIGUOUS THE GENERAL CONTRACTOR IS TO ASK FOR CLARIFICATION AT THE TIME OF TENDER. FAILURE TO DO SO WILL LEAVE THE INTERPRETATION OF THE DRAWINGS TO THE ARCHITECT. THIS NOTE APPLIES TO ALL DRAWINGS.

NOTE 2:

THIS DRAWING CONTAINS THE USE OF COLOUR TO BETTER ILLUSTRATE AND DESCRIBE THE INTENT OF THE DRAWING BY HIGHLIGHTING LINE TYPES, HATCH PATTERNS, TEXT, DIMENSIONS, OR TONES. IT IS MANDATORY THAT THIS DRAWING BE PRINTED IN COLOUR FOR ITS USE. FAILURE TO DO SO WILL NOT RESULT IN ANY COMPENSATION FOR COSTS OR TIME LOST BY THE GC OR HIS/HER SUBTRADE DUE TO OMISSIONS, ERRORS, OR MISUNDERSTANDING OF THE FULL SCOPE OF THE WORK.

LEGEND

	APPROXIMATE AREA NOT IN CONTRACT SCOPE.	ROOM NAME 101	ROOM NAME & NUMBER.		LIGHT FIXTURES. (REFER TO ELECTRICAL DRAWINGS).
	EXISTING WALL.	ROOM NAME 101	EXISTING ROOM NAME & NUMBER.		MECHANICAL GRILLES & DIFFUSERS. (REFER TO MECHANICAL DRAWINGS).
	EXISTING TO BE REMOVED.		MAIN ENTRANCE.		
	EXISTING DOOR & FRAME TO REMAIN.		SECONDARY ENTRANCE/EXT.		
	EXISTING DOOR & FRAME TO BE REMOVED.		APPROXIMATE AREA OF EXISTING FLOORING, WALL BASE AND ADHESIVES TO BE REMOVED.		
			EXISTING ACOUSTIC TILE CEILING AND T-BAR SUSPENSION SYSTEM TO BE REMOVED.		

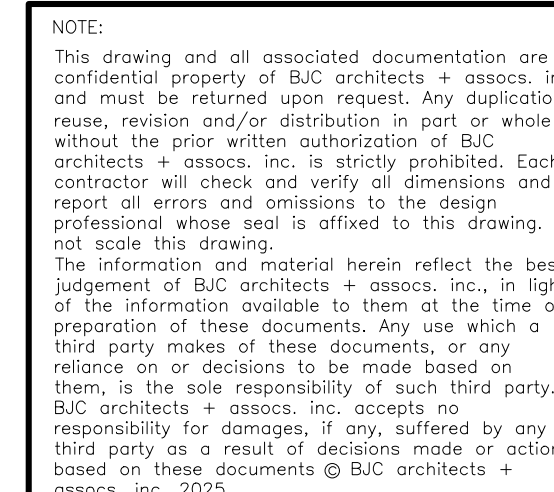

	drawn	
	MV	
	last worked on	by
	2026.02.11	M
	checked	
	B.R.J.	
	print date	
	2026.04.08	

drawing title
PARTIAL DEMOLITION
SECOND FLOOR PLAN
FAMILY STUDIES 1-23

reference	
project no. 25-092	client reference number
sheet no.	


A	D	1	1	1	0	1
---	---	---	---	---	---	---

1. CONTRACTOR MUST VERIFY ALL DIMENSIONS AND BE RESPONSIBLE FOR THE SAME. REPORT ANY ERRORS OR OMISSIONS TO THE ARCHITECT IN WRITING PRIOR TO COMMENCING WITH THE WORK. PRINTS ARE NOT TO BE SCALED.
2. THIS DRAWING IS TO BE READ IN CONJUNCTION WITH ALL OTHER ARCHITECTURAL, MECHANICAL & ELECTRICAL DRAWINGS FOR A COMPLETE SCOPE OF WORK. IT IS THE GENERAL CONTRACTOR'S RESPONSIBILITY TO ENSURE ALL DEMOLITION REQUIRED BY OTHER TRADES IS PRICED & COORDINATED ACCORDINGLY.
3. ALL CONSTRUCTION MATERIALS TO BE REMOVED WILL BE THE RESPONSIBILITY OF THE GENERAL CONTRACTOR TO DISPOSE OF AT AN APPROVED DISPOSAL FACILITY, UNLESS OTHERWISE NOTED.
4. ALL MECHANICAL & ELECTRICAL SERVICES RELATED TO EQUIPMENT, MILLWORK, REMOVALS, RELOCATIONS & DEMOLITIONS SHALL BE DISCONNECTED & CAPPED BEHIND THE FINISHED FLOOR LEVEL. REFER TO MECHANICAL AND ELECTRICAL DRAWINGS FOR A COMPLETE SCOPE OF WORK.
5. IT IS THE GENERAL CONTRACTOR'S RESPONSIBILITY TO REMOVE, STORE & RELOCATE / REINSTALL ALL FIXED IN PLACE MILLWORK, EQUIPMENT ETC. IN AREAS OF WORK. THE GENERAL CONTRACTOR SHALL CO-ORDINATE WITH THE OWNER WHEN THE ITEMS, UNDER HIS RESPONSIBILITY, SHALL BE REINSTALLED AT A LATER DATE. AN INSPECTION FOR DAMAGE SHALL BE CONDUCTED BY THE SCHOOL BOARD.
6. SELECTIVE DEMOLITION OF WALLS AND CEILINGS AS REQUIRED TO ACCOMMODATE INSTALLATION OF MECHANICAL AND ELECTRICAL ROUGH-INS AND EQUIPMENT.
7. CONTRACTOR TO REMOVE ALL EXISTING INTERIOR SCENE, EQUIPMENT, WHITEBOARDS & TABLETOPS DURING PAINTING OF WALLS AND REINSTALL UPON COMPLETION OF PAINTING. LOCATIONS TO BE REVEALED WITH OWNER PRIOR TO INSTALLATION.
8. REFER TO MECHANICAL DEMO DRAWINGS FOR SCOPE OF PIPES REMAINING AND BEING REMOVED.
9. EXISTING OVENS, FRIDGES, MICROWAVES, DISHWASHERS, WALL MOUNTED PAPER SHARPENER, WASHES AND DRYER ARE TO BE RETURNED TO THE OWNER.

THESE DRAWINGS ARE PREPARED WITH THE USE OF LINE TYPES, HATCH PATTERNS, COLOURS, AND NUMERICALLY DESIGNATED NOTES. COLLECTIVELY THESE REPRESENT THE FULL SCOPE OF WORK, WITH THE INTENT TO PROVIDE CLARITY. NOT ALL ITEMS MAY BE INDIVIDUALLY NOTED. IF ANYTHING IS AMBIGUOUS THE GENERAL CONTRACTOR IS TO ASK FOR CLARIFICATION AT THE TIME OF TENDER. FAILURE TO DO SO WILL LEAVE THE INTERPRETATION OF THE DRAWINGS TO THE ARCHITECT. THIS NOTE APPLIES TO ALL DRAWINGS.

THIS DRAWING CONTAINS THE USE OF COLOUR TO BETTER ILLUSTRATE AND DESCRIBE THE INTENT OF THE DRAWING BY HIGHLIGHTING LINE TYPES, HATCH PATTERNS, TEXT, DIMENSIONS, OR TONES. IT IS MANDATORY THAT THIS DRAWING BE PRINTED IN COLOUR FOR ITS USE. FAILURE TO DO SO WILL NOT RESULT IN ANY COMPENSATION FOR COSTS OR TIME LOST BY THE GC OR HIS/HER SUBTRADE DUE TO OMISSIONS, ERRORS, OR MISUNDERSTANDING OF THE FULL SCOPE OF THE WORK.

scale: 1 : 25

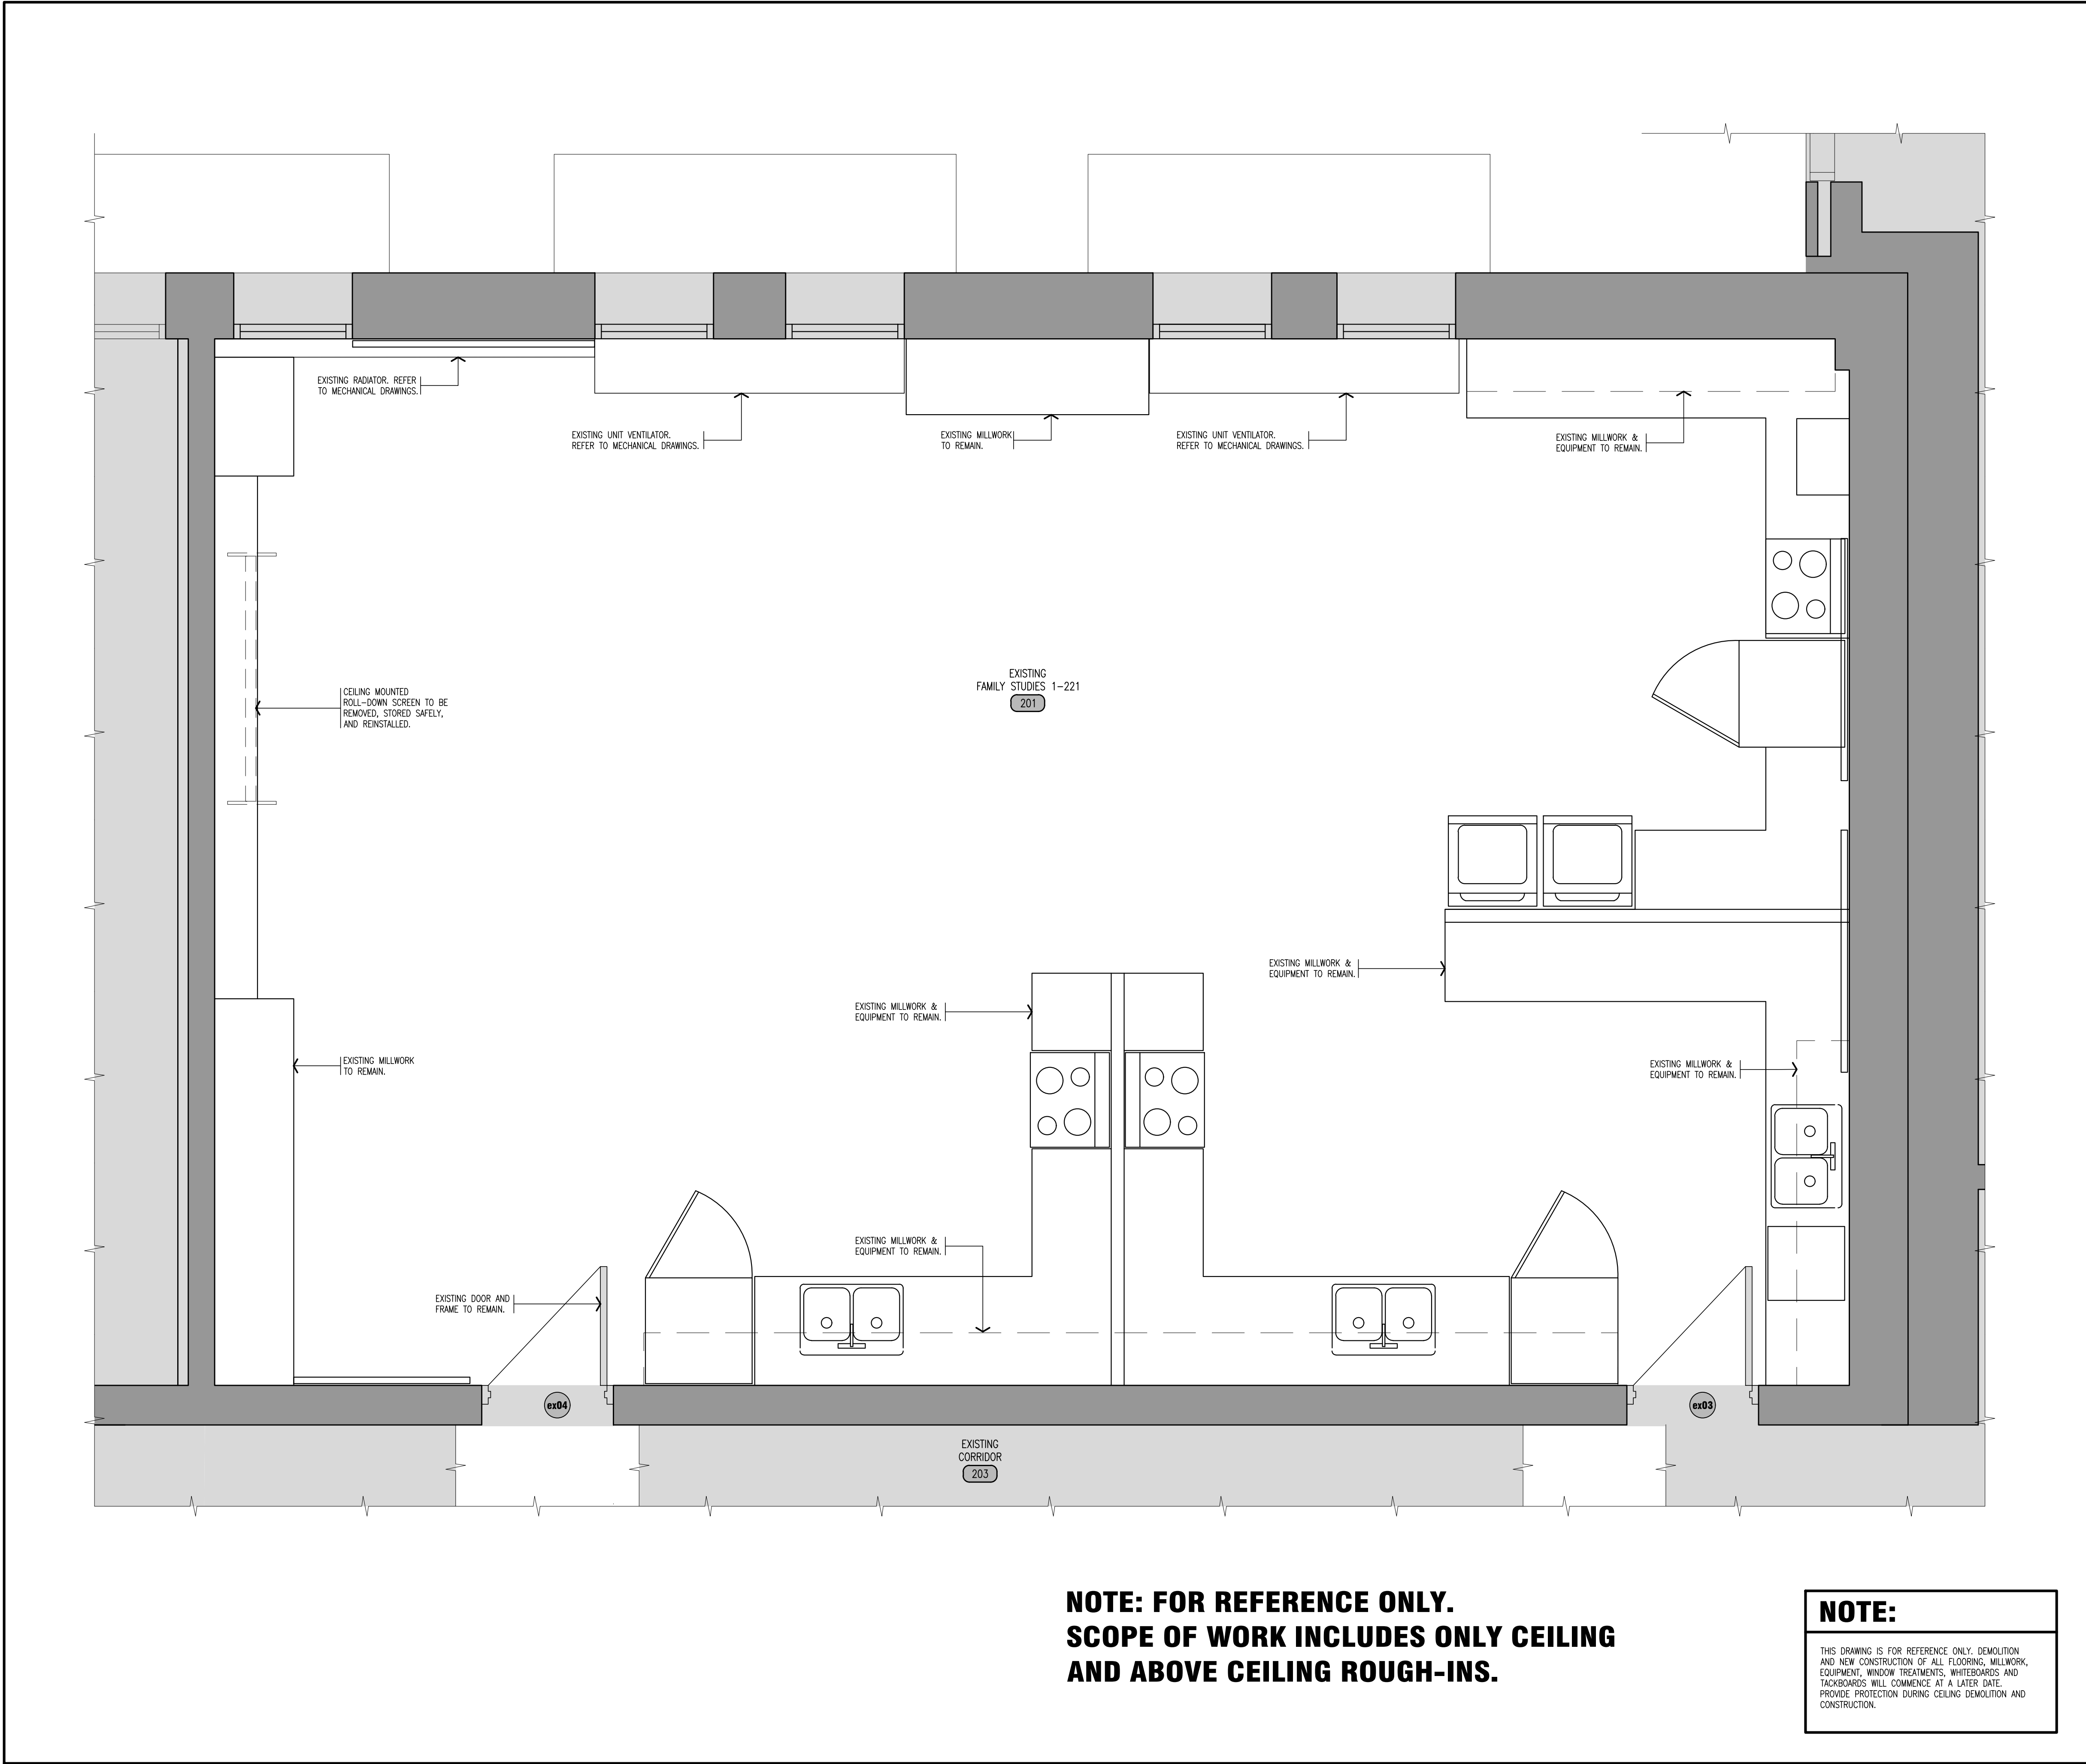

GENERAL NOTES

1. CONTRACTOR MUST VERIFY ALL DIMENSIONS AND BE RESPONSIBLE FOR THE SAME. REPORT ANY ERRORS OR OMISSIONS TO THE ARCHITECT IN WRITING PRIOR TO COMMENCING WITH THE WORK. PRINTS ARE NOT TO BE SCALED.
2. THIS DRAWING IS TO BE READ IN CONJUNCTION WITH ALL OTHER ARCHITECTURAL, MECHANICAL & ELECTRICAL DRAWINGS FOR A COMPLETE SCOPE OF WORK. IT IS THE GENERAL CONTRACTOR'S RESPONSIBILITY TO ENSURE ALL DEMOLITION REQUIRED BY OTHER TRADES IS PRICED & COORDINATED ACCORDINGLY.
3. ALL CONSTRUCTION MATERIALS TO BE REMOVED WILL BE THE RESPONSIBILITY OF THE GENERAL CONTRACTOR TO DISPOSE OF AT AN APPROVED DISPOSAL FACILITY, UNLESS OTHERWISE NOTED.
4. IT IS THE GENERAL CONTRACTOR'S RESPONSIBILITY TO REMOVE, STORE & RELOCATE / REINSTALL ALL FIXED IN PLACE MILLWORK, EQUIPMENT ETC. IN AREAS OF WORK. THE GENERAL CONTRACTOR SHALL CO-ORDINATE WITH THE OWNER WHEN THE ITEMS, UNDER HIS RESPONSIBILITY, SHALL BE REINSTALLED AT WHICH TIME AN INSPECTION FOR DAMAGE SHALL BE CONDUCTED BY THE SCHOOL BOARD.
5. SELECTIVE DEMOLITION OF WALLS AND CEILINGS AS REQUIRED TO ACCOMMODATE INSTALLATION OF MECHANICAL AND ELECTRICAL ROUGH-INS AND EQUIPMENT.

NOTE 1:

THESE DRAWINGS ARE PREPARED WITH THE USE OF LINE TYPES, HATCH PATTERNS, COLOURS, AND NUMERICALLY DESIGNATED NOTES. COLLECTIVELY THESE REPRESENT THE FULL SCOPE OF WORK, WITH THE INTENT TO PROVIDE CLARITY. NOT ALL ITEMS MAY BE INDIVIDUALLY NOTED. IF ANYTHING IS AMBIGUOUS THE GENERAL CONTRACTOR IS TO ASK FOR CLARIFICATION AT THE TIME OF TENDER. FAILURE TO DO SO WILL LEAVE THE INTERPRETATION OF THE DRAWINGS TO THE ARCHITECT. THIS NOTE APPLIES TO ALL DRAWINGS.

NOTE 2:


THIS DRAWING CONTAINS THE USE OF COLOUR TO BETTER ILLUSTRATE AND DESCRIBE THE INTENT OF THE DRAWING BY HIGHLIGHTING LINE TYPES, HATCH PATTERNS, TEXT, DIMENSIONS, OR TONES. IT IS MANDATORY THAT THIS DRAWING BE PRINTED IN COLOUR FOR ITS USE. FAILURE TO DO SO WILL NOT RESULT IN ANY COMPENSATION FOR COSTS OR TIME LOST BY THE GC OR HIS/HER SUBTRADE DUE TO OMISSIONS, ERRORS, OR MISUNDERSTANDING OF THE FULL SCOPE OF THE WORK.

LEGEND

- APPROXIMATE AREA NOT IN CONTRACT SCOPE.
 - EXISTING WALL.
 - EXISTING TO BE REMOVED.
 - EXISTING DOOR & FRAME TO REMAIN.
 - EXISTING DOOR & FRAME TO BE REMOVED.
 - ROOM NAME
101
 - ROOM NAME
101
- ROOM NAME & NUMBER.
- EXISTING ROOM NAME & NUMBER.

NOTE:

THIS DRAWING IS FOR REFERENCE ONLY. DEMOLITION AND NEW CONSTRUCTION OF ALL FLOORING, MILLWORK, EQUIPMENT, WINDOW TREATMENTS, WHITEBOARDS AND TACKBOARDS WILL COMMENCE AT A LATER DATE. PROVIDE PROTECTION DURING CEILING DEMOLITION AND CONSTRUCTION.

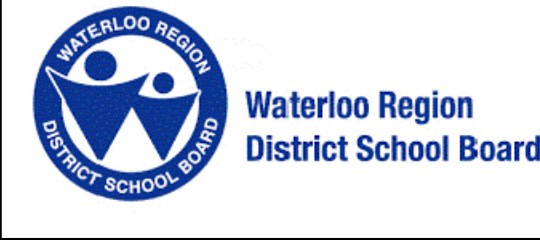

NOTE:
This drawing and all associated documentation are the confidential property of BJC architects + assoc. inc. and must be returned upon request. Any duplication, reuse, revision and/or distribution in part or whole without the prior written authorization of BJC architects + assoc. inc. is strictly prohibited. Each contractor will check and verify all dimensions and report all errors and omissions to the design professional whose seal is affixed to this drawing. Do not scale this drawing.
The information and material herein reflect the best judgement of BJC architects + assoc. inc. in light of the information available to them at the time of preparation of these documents. Any use which a third party makes of these documents, or any reliance on or decisions to be made based on them, is the sole responsibility of such third party. BJC architects + assoc. inc. accepts no responsibility for damages, if any, suffered by any third party as a result of decisions made or actions based on these documents © BJC architects + assoc. inc. 2025.

01	ISSUED FOR TENDER	2026.04.08
No.	REVISIONS	date
PROJECT NORTH	TRUE NORTH	
	scale	AS NOTED


drawn	VA
last worked on by	2026.04.08 MV
checked	B.R.J.
print date	2026.04.08



client	WATERLOO REGION DISTRICT SCHOOL BOARD
51 ARDELT AVE KITCHENER	ONTARIO
project	GRAND RIVER COLLEGIATE INSTITUTE RENOVATION
175 INDIAN RD KITCHENER	ONTARIO

drawing title	PARTIAL DEMOLITION SECOND FLOOR PLAN FAMILY STUDIES 1-221
---------------	---

reference	
project no.	25-092
client reference number	
sheet no.	AD11201

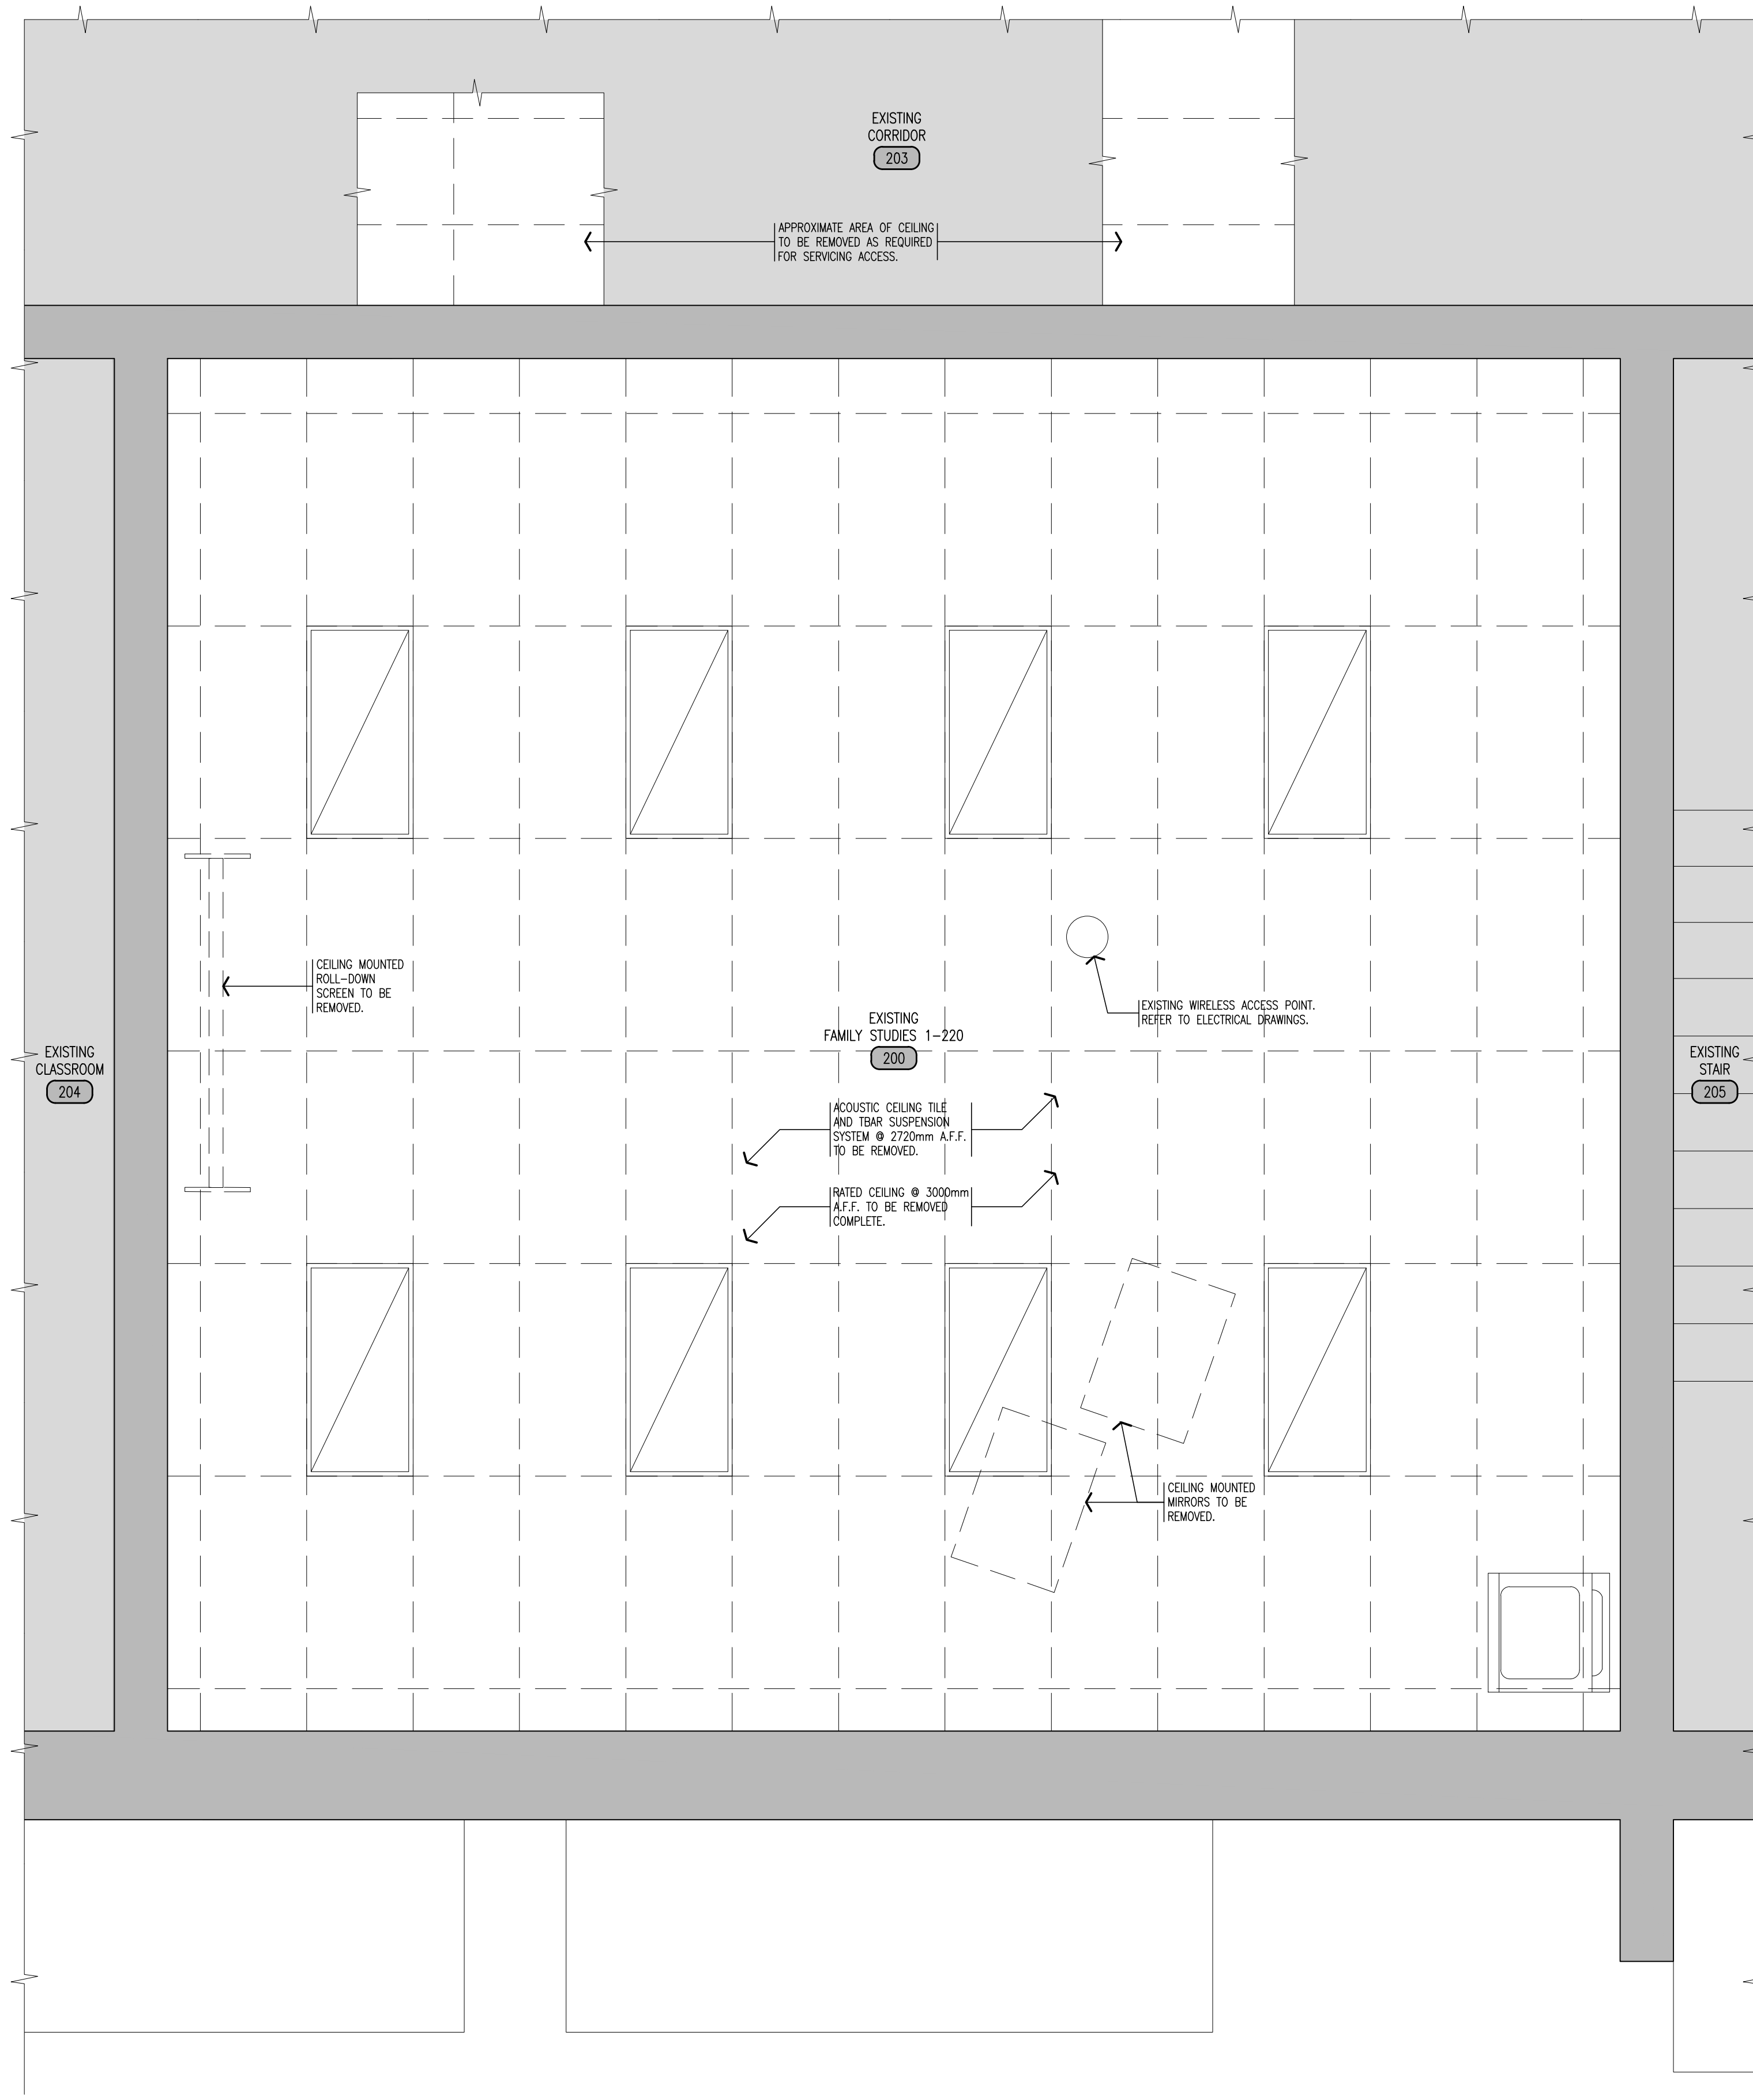

1 PARTIAL DEMOLITION SECOND FLOOR REFLECTED CEILING PLAN
FAMILY STUDIES 1-220

scale: 1 : 25

GENERAL NOTES

1. CONTRACTOR MUST VERIFY ALL DIMENSIONS AND BE RESPONSIBLE FOR THE SAME. REPORT ANY ERRORS OR OMISSIONS TO THE ARCHITECT IN WRITING PRIOR TO COMMENCING WITH THE WORK. PRINTS ARE NOT TO BE SCALED.
2. THIS DRAWING IS TO BE READ IN CONJUNCTION WITH ALL OTHER ARCHITECTURAL, MECHANICAL & ELECTRICAL DRAWINGS FOR A COMPLETE SCOPE OF WORK. IT IS THE GENERAL CONTRACTOR'S RESPONSIBILITY TO ENSURE ALL DEMOLITION REQUIRED BY OTHER TRADES IS PRICED & COORDINATED ACCORDINGLY.
3. ALL CONSTRUCTION MATERIALS TO BE REMOVED WILL BE THE RESPONSIBILITY OF THE GENERAL CONTRACTOR TO DISPOSE OF AT AN APPROVED DISPOSAL FACILITY, UNLESS OTHERWISE NOTED.
4. IT IS THE GENERAL CONTRACTOR'S RESPONSIBILITY TO REMOVE, STORE & RELOCATE / REINSTALL ALL FIXED IN PLACE MILLWORK, EQUIPMENT ETC. IN AREAS OF WORK. THE GENERAL CONTRACTOR SHALL CO-ORDINATE WITH THE OWNER WHEN THE ITEMS, UNDER HIS RESPONSIBILITY, SHALL BE REINSTALLED AT WHICH TIME AN INSPECTION FOR DAMAGE SHALL BE CONDUCTED BY THE SCHOOL BOARD.
5. SELECTIVE DEMOLITION OF WALLS AND CEILINGS AS REQUIRED TO ACCOMMODATE INSTALLATION OF MECHANICAL AND ELECTRICAL ROUGH-INS AND EQUIPMENT.
6. COORDINATE WITH MECHANICAL FOR THE PROTECTION OF EXISTING SPRINKLER SYSTEM DURING THE DEMOLITION AND REMOVAL OF CEILINGS. REFER TO MECHANICAL DRAWINGS.

NOTE 1:

THESE DRAWINGS ARE PREPARED WITH THE USE OF LINE TYPES, HATCH PATTERNS, COLOURS, AND NUMERICALLY DESIGNATED NOTES. COLLECTIVELY THESE REPRESENT THE FULL SCOPE OF WORK, WITH THE INTENT TO PROVIDE CLARITY. NOT ALL ITEMS MAY BE INDIVIDUALLY NOTED. IF ANYTHING IS AMBIGUOUS THE GENERAL CONTRACTOR IS TO ASK FOR CLARIFICATION AT THE TIME OF TENDER. FAILURE TO DO SO WILL LEAVE THE INTERPRETATION OF THE DRAWINGS TO THE ARCHITECT. THIS NOTE APPLIES TO ALL DRAWINGS.

NOTE 2:

THIS DRAWING CONTAINS THE USE OF COLOUR TO BETTER ILLUSTRATE AND DESCRIBE THE INTENT OF THE DRAWING BY HIGHLIGHTING LINE TYPES, HATCH PATTERNS, TEXT, DIMENSIONS, OR TONES. IT IS MANDATORY THAT THIS DRAWING BE PRINTED IN COLOUR FOR ITS USE. FAILURE TO DO SO WILL NOT RESULT IN ANY COMPENSATION FOR COSTS OR TIME LOST BY THE GC OR HIS/HER SUBTRADE DUE TO OMISSIONS, ERRORS, OR MISUNDERSTANDING OF THE FULL SCOPE OF THE WORK.

LEGEND

- APPROXIMATE AREA NOT IN CONTRACT SCOPE.
- EXISTING WALL.
- ROOM NAME 101 ROOM NAME & NUMBER.
- ROOM NAME 101 EXISTING ROOM NAME & NUMBER.
- EXISTING ACOUSTIC TILE CEILING AND T-BAR SUSPENSION SYSTEM TO BE REMOVED.
- LIGHT FIXTURES. (REFER TO ELECTRICAL DRAWINGS).



NOTE:
This drawing and all associated documentation are the confidential property of BJC architects + assocs. inc. and must be returned upon request. Any duplication, reuse, revision and/or distribution in part or whole without the prior written authorization of BJC architects + assocs. inc. is strictly prohibited. Each contractor will check and verify all dimensions and report all errors and omissions to the design professional whose seal is affixed to this drawing. Do not scale this drawing.
The information and material herein reflect the best judgement of BJC architects + assocs. inc. in light of the information available to them at the time of preparation of these documents. Any use which a third party makes of these documents, or any reliance on or decisions to be made based on them, is the sole responsibility of such third party. BJC architects + assocs. inc. accepts no responsibility for damages, if any, suffered by any third party as a result of decisions made or actions based on these documents © BJC architects + assocs. inc. 2025.


01	ISSUED FOR TENDER	2026.04.08
No.	REVISIONS	date
PROJECT NORTH		TRUE NORTH
scale		AS NOTED

drawn	MV
last worked on	by 2026.02.11 MV
checked	B.R.J.
print date	2026.04.08



client	WATERLOO REGION DISTRICT SCHOOL BOARD
51 ARDELT AVE KITCHENER	ONTARIO
project	GRAND RIVER COLLEGIATE INSTITUTE RENOVATION
175 INDIAN RD KITCHENER	ONTARIO

drawing title	PARTIAL DEMOLITION SECOND FLOOR RCP FAMILY STUDIES 1-220
reference	
project no.	25-092
client reference number	
sheet no.	AD160 01

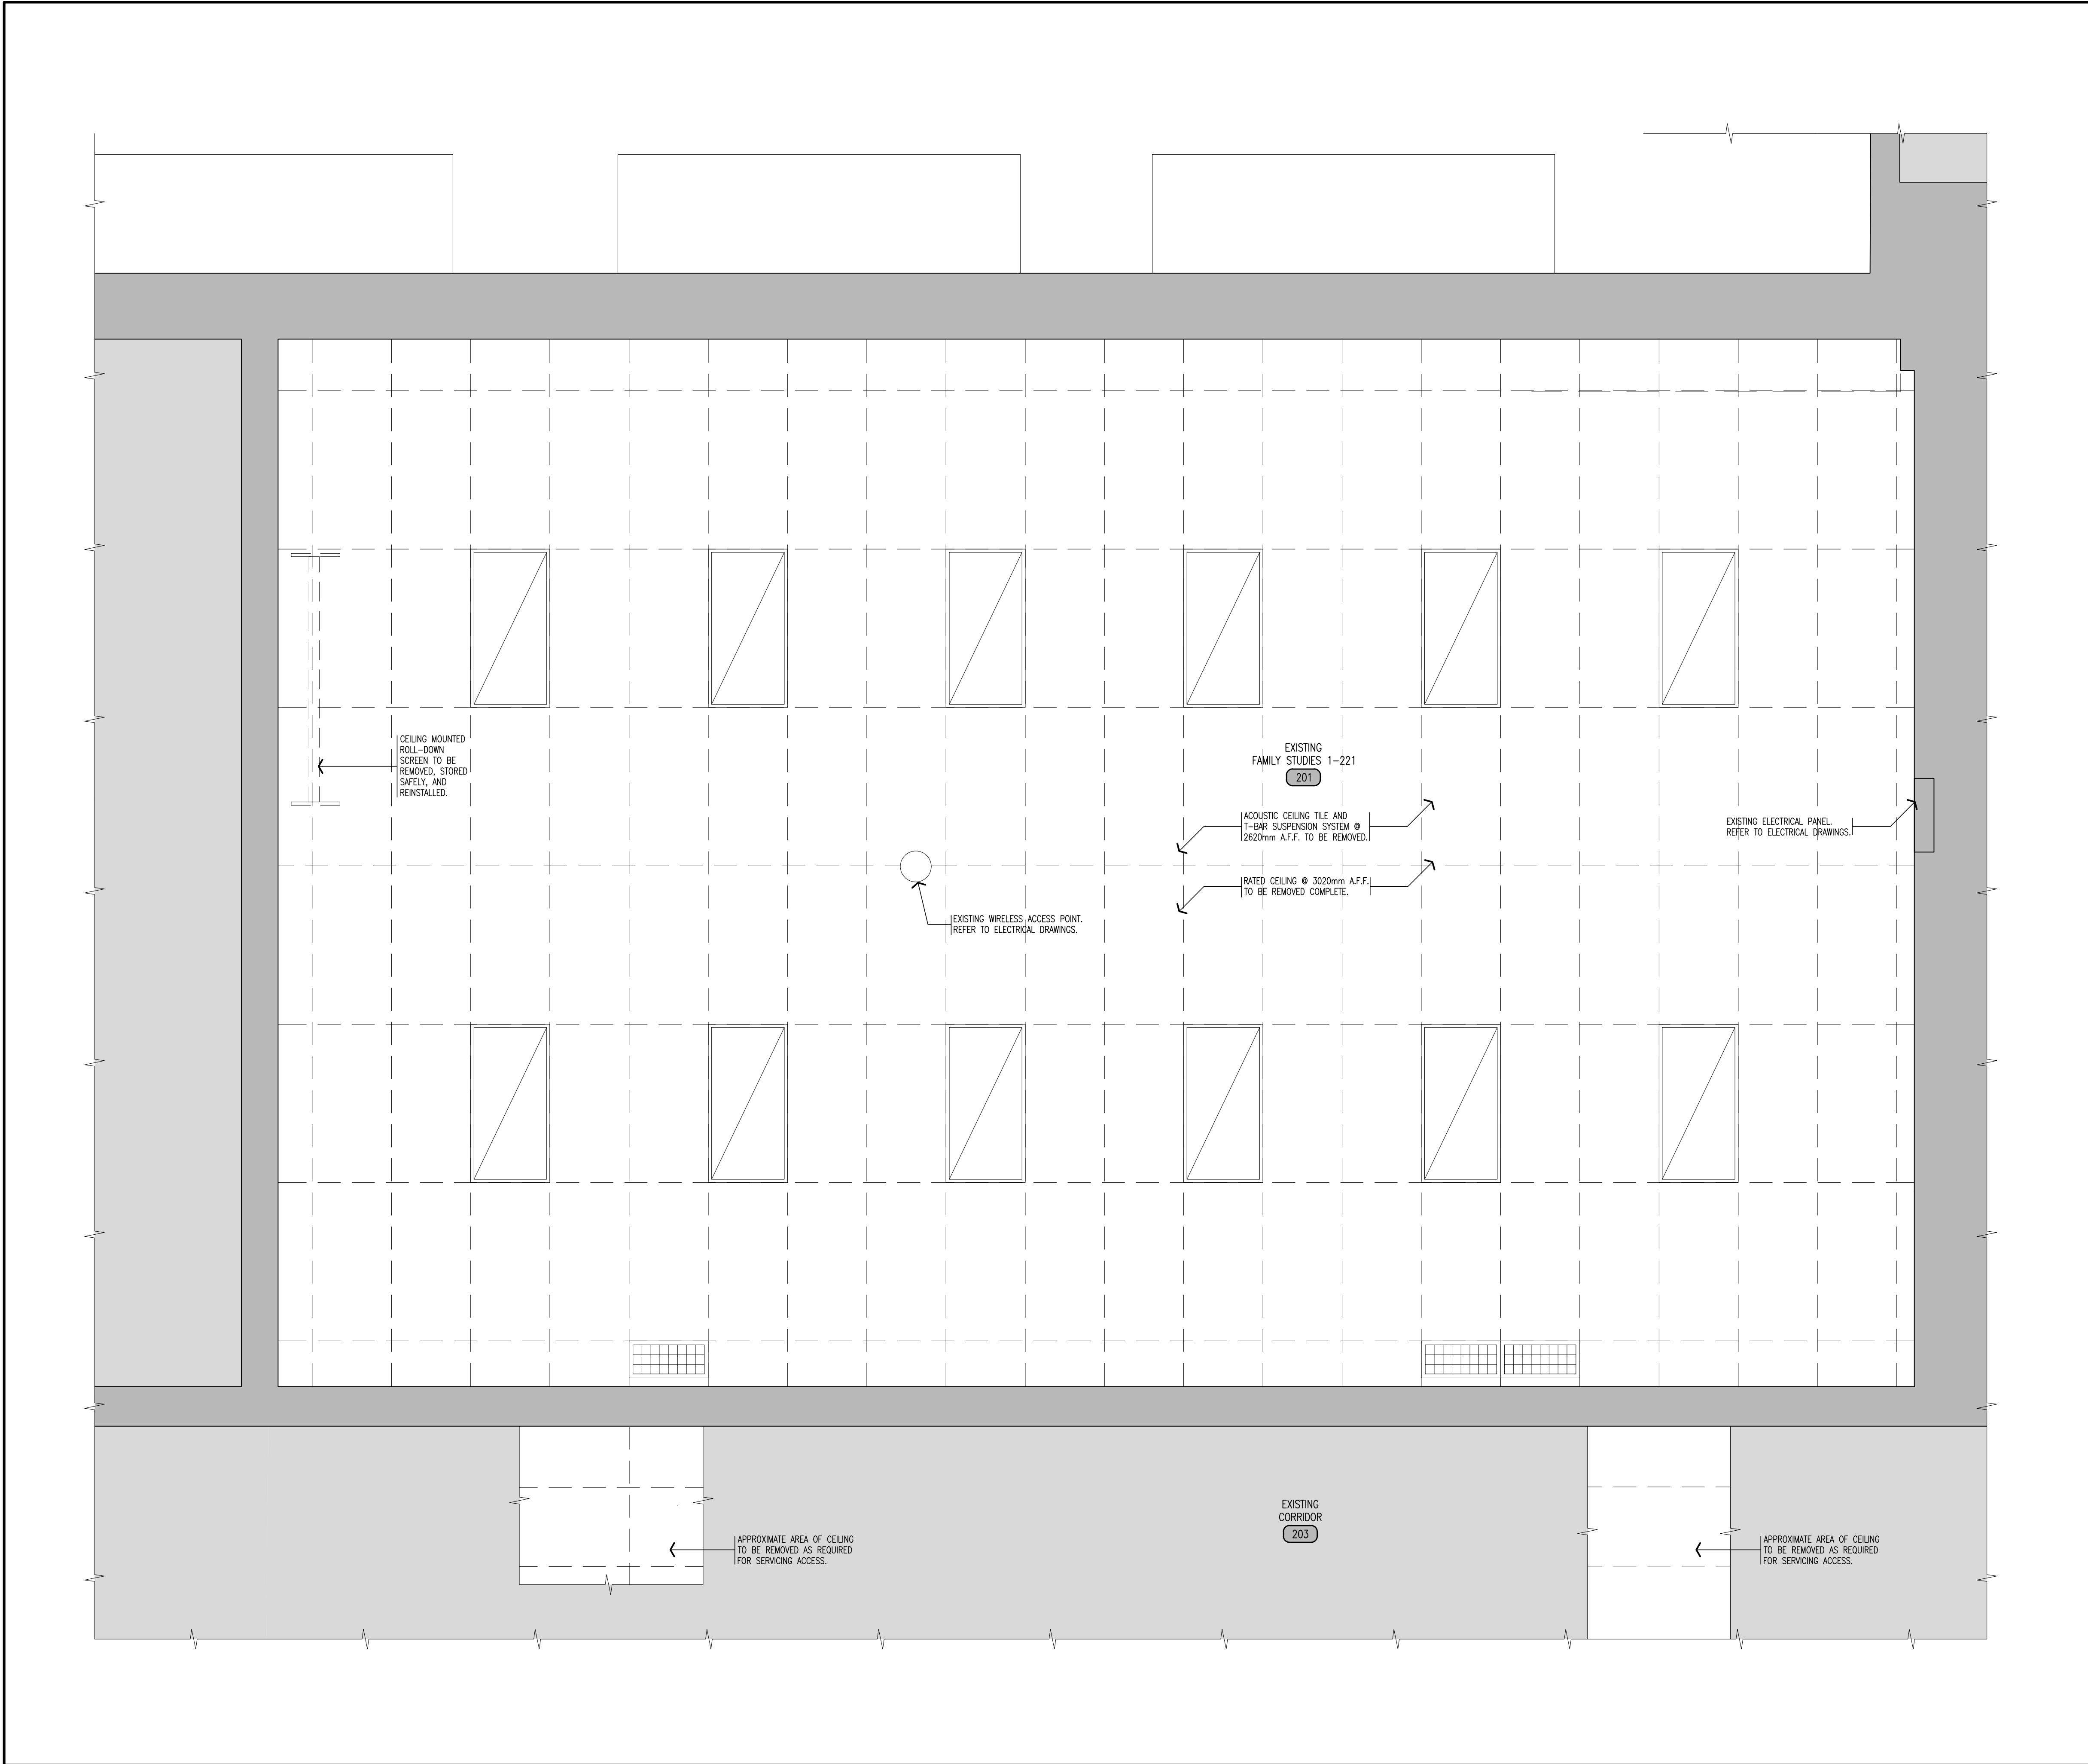

1

PARTIAL DEMOLITION SECOND FLOOR REFLECTED CEILING PLAN
FAMILY STUDIES 1-221

scale: 1 : 25

GENERAL NOTES

1. CONTRACTOR MUST VERIFY ALL DIMENSIONS AND BE RESPONSIBLE FOR THE SAME. REPORT ANY ERRORS OR OMISSIONS TO THE ARCHITECT IN WRITING PRIOR TO COMMENCING WITH THE WORK. PRINTS ARE NOT TO BE SCALED.
2. THIS DRAWING IS TO BE READ IN CONJUNCTION WITH ALL OTHER ARCHITECTURAL, MECHANICAL & ELECTRICAL DRAWINGS FOR A COMPLETE SCOPE OF WORK. IT IS THE GENERAL CONTRACTOR'S RESPONSIBILITY TO ENSURE ALL DEMOLITION REQUIRED BY OTHER TRADES IS PRICED & COORDINATED ACCORDINGLY.
3. ALL CONSTRUCTION MATERIALS TO BE REMOVED WILL BE THE RESPONSIBILITY OF THE GENERAL CONTRACTOR TO DISPOSE OF AT AN APPROVED DISPOSAL FACILITY, UNLESS OTHERWISE NOTED.
4. IT IS THE GENERAL CONTRACTOR'S RESPONSIBILITY TO REMOVE, STORE & RELOCATE / REINSTALL ALL FIXED IN PLACE MILLWORK, EQUIPMENT ETC. IN AREAS OF WORK. THE GENERAL CONTRACTOR SHALL CO-ORDINATE WITH THE OWNER WHEN THE ITEMS, UNDER HIS RESPONSIBILITY, SHALL BE REINSTALLED AT WHICH TIME AN INSPECTION FOR DAMAGE SHALL BE CONDUCTED BY THE SCHOOL BOARD.
5. SELECTIVE DEMOLITION OF WALLS AND CEILINGS AS REQUIRED TO ACCOMMODATE INSTALLATION OF MECHANICAL AND ELECTRICAL ROUGH-INS AND EQUIPMENT.
6. COORDINATE WITH MECHANICAL FOR THE PROTECTION OF EXISTING SPRINKLER SYSTEM DURING THE DEMOLITION AND REMOVAL OF CEILINGS. REFER TO MECHANICAL DRAWINGS.

NOTE 1:

THESE DRAWINGS ARE PREPARED WITH THE USE OF LINE TYPES, HATCH PATTERNS, COLOURS, AND NUMERICALLY DESIGNATED NOTES. COLLECTIVELY THESE REPRESENT THE FULL SCOPE OF WORK, WITH THE INTENT TO PROVIDE CLARITY. NOT ALL ITEMS MAY BE INDIVIDUALLY NOTED. IF ANYTHING IS AMBIGUOUS THE GENERAL CONTRACTOR IS TO ASK FOR CLARIFICATION AT THE TIME OF TENDER. FAILURE TO DO SO WILL LEAVE THE INTERPRETATION OF THE DRAWINGS TO THE ARCHITECT. THIS NOTE APPLIES TO ALL DRAWINGS.

NOTE 2:

THIS DRAWING CONTAINS THE USE OF COLOUR TO BETTER ILLUSTRATE AND DESCRIBE THE INTENT OF THE DRAWING BY HIGHLIGHTING LINE TYPES, HATCH PATTERNS, TEXT, DIMENSIONS, OR TONES. IT IS MANDATORY THAT THIS DRAWING BE PRINTED IN COLOUR FOR ITS USE. FAILURE TO DO SO WILL NOT RESULT IN ANY COMPENSATION FOR COSTS OR TIME LOST BY THE GC OR HIS/HER SUBTRADE DUE TO OMISSIONS, ERRORS, OR MISUNDERSTANDING OF THE FULL SCOPE OF THE WORK.

LEGEND

- APPROXIMATE AREA NOT IN CONTRACT SCOPE.
- EXISTING WALL.
- ROOM NAME
101

ROOM NAME & NUMBER.
- ROOM NAME
101

EXISTING ROOM NAME & NUMBER.
- EXISTING ACOUSTIC TILE CEILING AND T-BAR SUSPENSION SYSTEM TO BE REMOVED.
- LIGHT FIXTURES.
(REFER TO ELECTRICAL DRAWINGS).
- MECHANICAL GRILLES & DIFFUSERS.
(REFER TO MECHANICAL DRAWINGS).



NOTE:
This drawing and all associated documentation are the confidential property of BJC architects + assoc.s, inc. and must be returned upon request. Any duplication, reuse, revision and/or distribution in part or whole without the prior written authorization of BJC architects + assoc.s, inc. is strictly prohibited. Each contractor will check and verify all dimensions and report all errors and omissions to the design professional whose seal is affixed to this drawing. Do not scale this drawing.
The information and material herein reflect the best judgement of BJC architects + assoc.s, inc. in light of the information available to them at the time of preparation of these documents. Any use which a third party makes of these documents, or any reliance on or decisions to be made based on them, is the sole responsibility of such third party. BJC architects + assoc.s, inc. accepts no responsibility for damages, if any, suffered by any third party as a result of decisions made or actions based on these documents © BJC architects + assoc.s, inc., 2025.

01	ISSUED FOR TENDER	2026.04.08
No.	REVISIONS	date
PROJECT NORTH		TRUE NORTH
scale:		AS NOTED


drawn	VA
last worked on by	2026.02.11 MV
checked	B.R.J.
print date	2026.04.08



client	WATERLOO REGION DISTRICT SCHOOL BOARD
51 ARDELT AVE KITCHENER	ONTARIO
project	GRAND RIVER COLLEGIATE INSTITUTE RENOVATION
175 INDIAN RD KITCHENER	ONTARIO

drawing title	PARTIAL DEMOLITION SECOND FLOOR RCP FAMILY STUDIES 1-221
---------------	--

reference	
project no.	25-092
client reference number	
sheet no.	AD16101

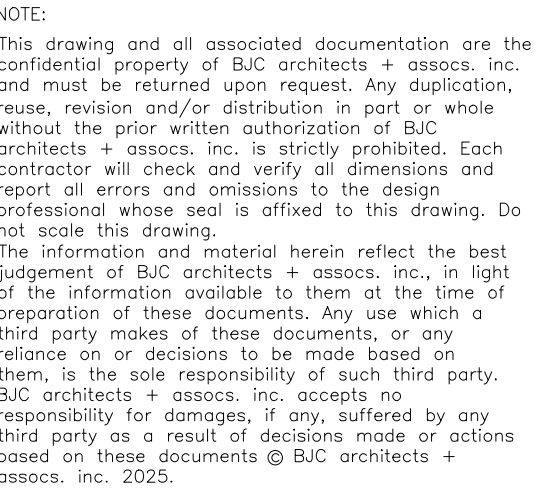

01	ISSUED FOR TENDER	2026. 04.08
No.	REVISIONS	date

scale
1:20

drawn
MV
last worked on by
2026.04.08 MV
checked
B.R.J.
print date
2026.04.08



client
WATERLOO REGION
DISTRICT SCHOOL
BOARD

51 ARDELT AVE
KITCHENER ONTARIO

project
GRAND RIVER COLLEGIATE
INSTITUTE RENOVATION

175 INDIAN RD
KITCHENER ONTARIO

drawing title

DEMOLITION
WALL SECTIONS

ference

project no. 25-092	client reference number
-----------------------	-------------------------

Sheet no. _____

A D 3 0 0 **0 1**

1) _____ RESERVED

2) _____ RESERVED

3) _____ RESERVED


4) RESERVED

5) DEMOLITION WALL SECTION THRU EXTERIOR WALL

scale: 1 : 20

6) DEMOLITION WALL SECTION THRU INTERIOR WALL
BETWEEN SENSORY ROOM & CORRIDOR 4 scale: 1 : 20

scale: 1 : 20

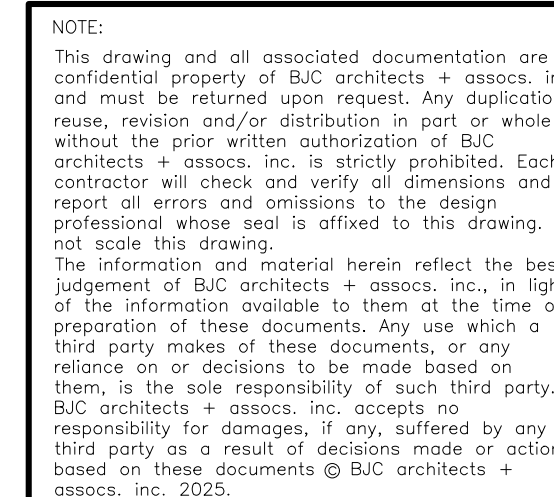

1. CONTRACTOR MUST VERIFY ALL DIMENSIONS AND BE RESPONSIBLE FOR THE SAME. REPORT ANY ERRORS OR OMISSIONS TO THE ARCHITECT IN WRITING PRIOR TO COMMENCING WITH THE WORK. PRINTS ARE NOT TO BE SCALED.
2. THIS DRAWING IS TO BE READ IN CONJUNCTION WITH ALL OTHER ARCHITECTURAL, MECHANICAL & ELECTRICAL DRAWINGS FOR A COMPLETE SCOPE OF WORK.
3. WHERE FLOORING IS BEING REMOVED, GRIND SMOOTH EXISTING CONCRETE FLOOR SLAB TO REMOVE ANY REMNANT ADHESIVE, MORTAR ETC. & MAKE READY TO RECEIVE NEW FLOOR FINISHES.
4. CRACKING IN CONCRETE SLAB NOT RELATED TO TRANSITIONS OR SAWCUTTING ARE TO BE CLEANED OUT, INFILLED & LEVELLED SMOOTH. GRIND SMOOTH, INFILL PATCH LOCATION SAWCUTS OR TRANSITION JOINTS & COLUMN ISOLATION JOINTS TO MAKE TRANSITION IMPERCEPTIBLE IN PREPARATION OF INSTALLATION OF ALL NEW FLOORING. GENERAL CONTRACTOR TO SITE CONFIRM LOCATIONS.
5. LEVEL SLAB AREAS AFTER ANY REMOVALS WHICH MAY HAVE DIFFERENT ELEVATIONS.
6. WHERE EXISTING SURFACES ARE DISTURBED DUE TO DEMOLITION OR ALTERATIONS WORK, SUCH SURFACES SHALL BE MADE GOOD TO MATCH EXISTING ADJACENT MATERIALS.
7. THE GENERAL CONTRACTOR WILL PATCH, REPAIR OR REPLACE ANY DAMAGED ITEMS, UNDER HIS RESPONSIBILITY AS A CONSEQUENCE OF IMPROPER STORAGE OR HANDLING, AT HIS OWN EXPENSE.
8. REFER TO ARCHITECTURAL DRAWING A-001 FOR WALL TYPE AND WINDOW TYPE LEGEND.
9. AT EXTERIOR & INTERIOR FIRE RATED WALL(S) & FIRE SEPARATIONS, ENSURE ALL PENETRATIONS & GAPS ARE FIRE STOPPED & SEALED, WITH AN APPROVED FIRE STOP MATERIAL TO MAINTAIN DESIGNATED RATING OF DESIGN AS REQUIRED.
10. ALL NEW WALLS ARE TO BE FULL FILL TO u/s OF EXISTING SLAB/DECK, UNLESS SPECIFICALLY IDENTIFIED.
11. PATTERNS OF HATCHING ARE GRAPHIC REPRESENTATIONS ONLY. THEY DO NOT REPRESENT THE PLACEMENT OR COURSING.
12. GENERAL CONTRACTOR IS RESPONSIBLE FOR PROVIDING FLOORING PROTECTION UNTIL DEMOLITION TO OWNERS. IF FLOORING DAMAGED AS A RESULT OF PROTECTION NOT BEING PROVIDED WILL BE THE RESPONSIBILITY OF THE GENERAL CONTRACTOR TO REPAIR AND OR REPLACE AT THE GENERAL CONTRACTOR'S EXPENSE.
13. ENSURE ALL SURFACES ARE CLEAN AND FREE OF DEBRIS PRIOR TO PAINTING
14. ALL WALLS ARE TO BE PAINTED. COLOUR: TBD.
15. ALL DOORS AND FRAMES ARE TO BE PAINTED. COLOUR: TBD.
16. GENERAL CONTRACTOR TO SALVAGE CONCRETE BLOCK FROM DEMOLITION TO INFILL WALL WHERE NEW DOOR OPENINGS ARE MADE.

THESE DRAWINGS ARE PREPARED WITH THE USE OF LINE TYPES, HATCH PATTERNS, COLOURS, AND NUMERICALLY DESIGNATED NOTES. COLLECTIVELY THESE REPRESENT THE FULL SCOPE OF WORK, WITH THE INTENT TO PROVIDE CLARITY. NOT ALL ITEMS MAY BE INDIVIDUALLY NOTED. IF ANYTHING IS AMBIGUOUS THE GENERAL CONTRACTOR IS TO ASK FOR CLARIFICATION AT THE TIME OF TENDER. FAILURE TO DO SO WILL LEAVE THE INTERPRETATION OF THE DRAWINGS TO THE ARCHITECT. THIS NOTE APPLIES TO ALL DRAWINGS.

THIS DRAWING CONTAINS THE USE OF COLOUR TO BETTER ILLUSTRATE AND DESCRIBE THE INTENT OF THE DRAWING BY HIGHLIGHTING LINE TYPES, HATCH PATTERNS, TEXT, DIMENSIONS, OR TONES. IT IS MANDATORY THAT THIS DRAWING BE PRINTED IN COLOUR FOR ITS USE. FAILURE TO DO SO WILL NOT RESULT IN ANY COMPENSATION FOR COSTS OR TIME LOST BY THE GC OR HIS/HER SUBTRADE DUE TO OMISSIONS, ERRORS, OR MISUNDERSTANDING OF THE FULL SCOPE OF THE WORK.

APPROXIMATE AREA NOT IN CONTRACT SCOPE.

EXISTING WALL.

NEW INTERIOR BLOCK WALL.

NEW DOOR & DOOR NUMBER.

EXISTING DOOR & FRAME & DOOR NUMBER.

ROOM NAME
101

ROOM NAME & NUMBER.

ROOM NAME
101

EXISTING ROOM NAME & NUMBER.

WT1

WALL TYPE.

SCREEN NUMBER.

S1

SECONDARY ENTRANCE/EXIT.

NEW MILLWORK.

OVERHEAD ELEMENT.

AREA OF NEW SPORTS FLOORING c/w RUBBER WALL BASE.
MANUFACTURER: TARKETT SPORTS OMNISPORTS GREENLAY
COLOUR: GUNSTOCK OAK

AREA OF NEW PORCELAIN TILE TO MATCH EXISTING FLOORING c/w CERAMIC TILE BASE.
MANUFACTURER: OLYMPIA TILE
COLOUR: MUST SERIES TAUPE MATTE

TS--XX

TRANSITION STRIP.

PT-1

PAINT FINISH
COLOUR: TBD.


APPROXIMATE AREA OF FLOOR TO BE SKIMMED A MINIMUM OF 1500mm TO PROVIDE A SMOOTH TRANSITION.



NT



scale: 1 : 50

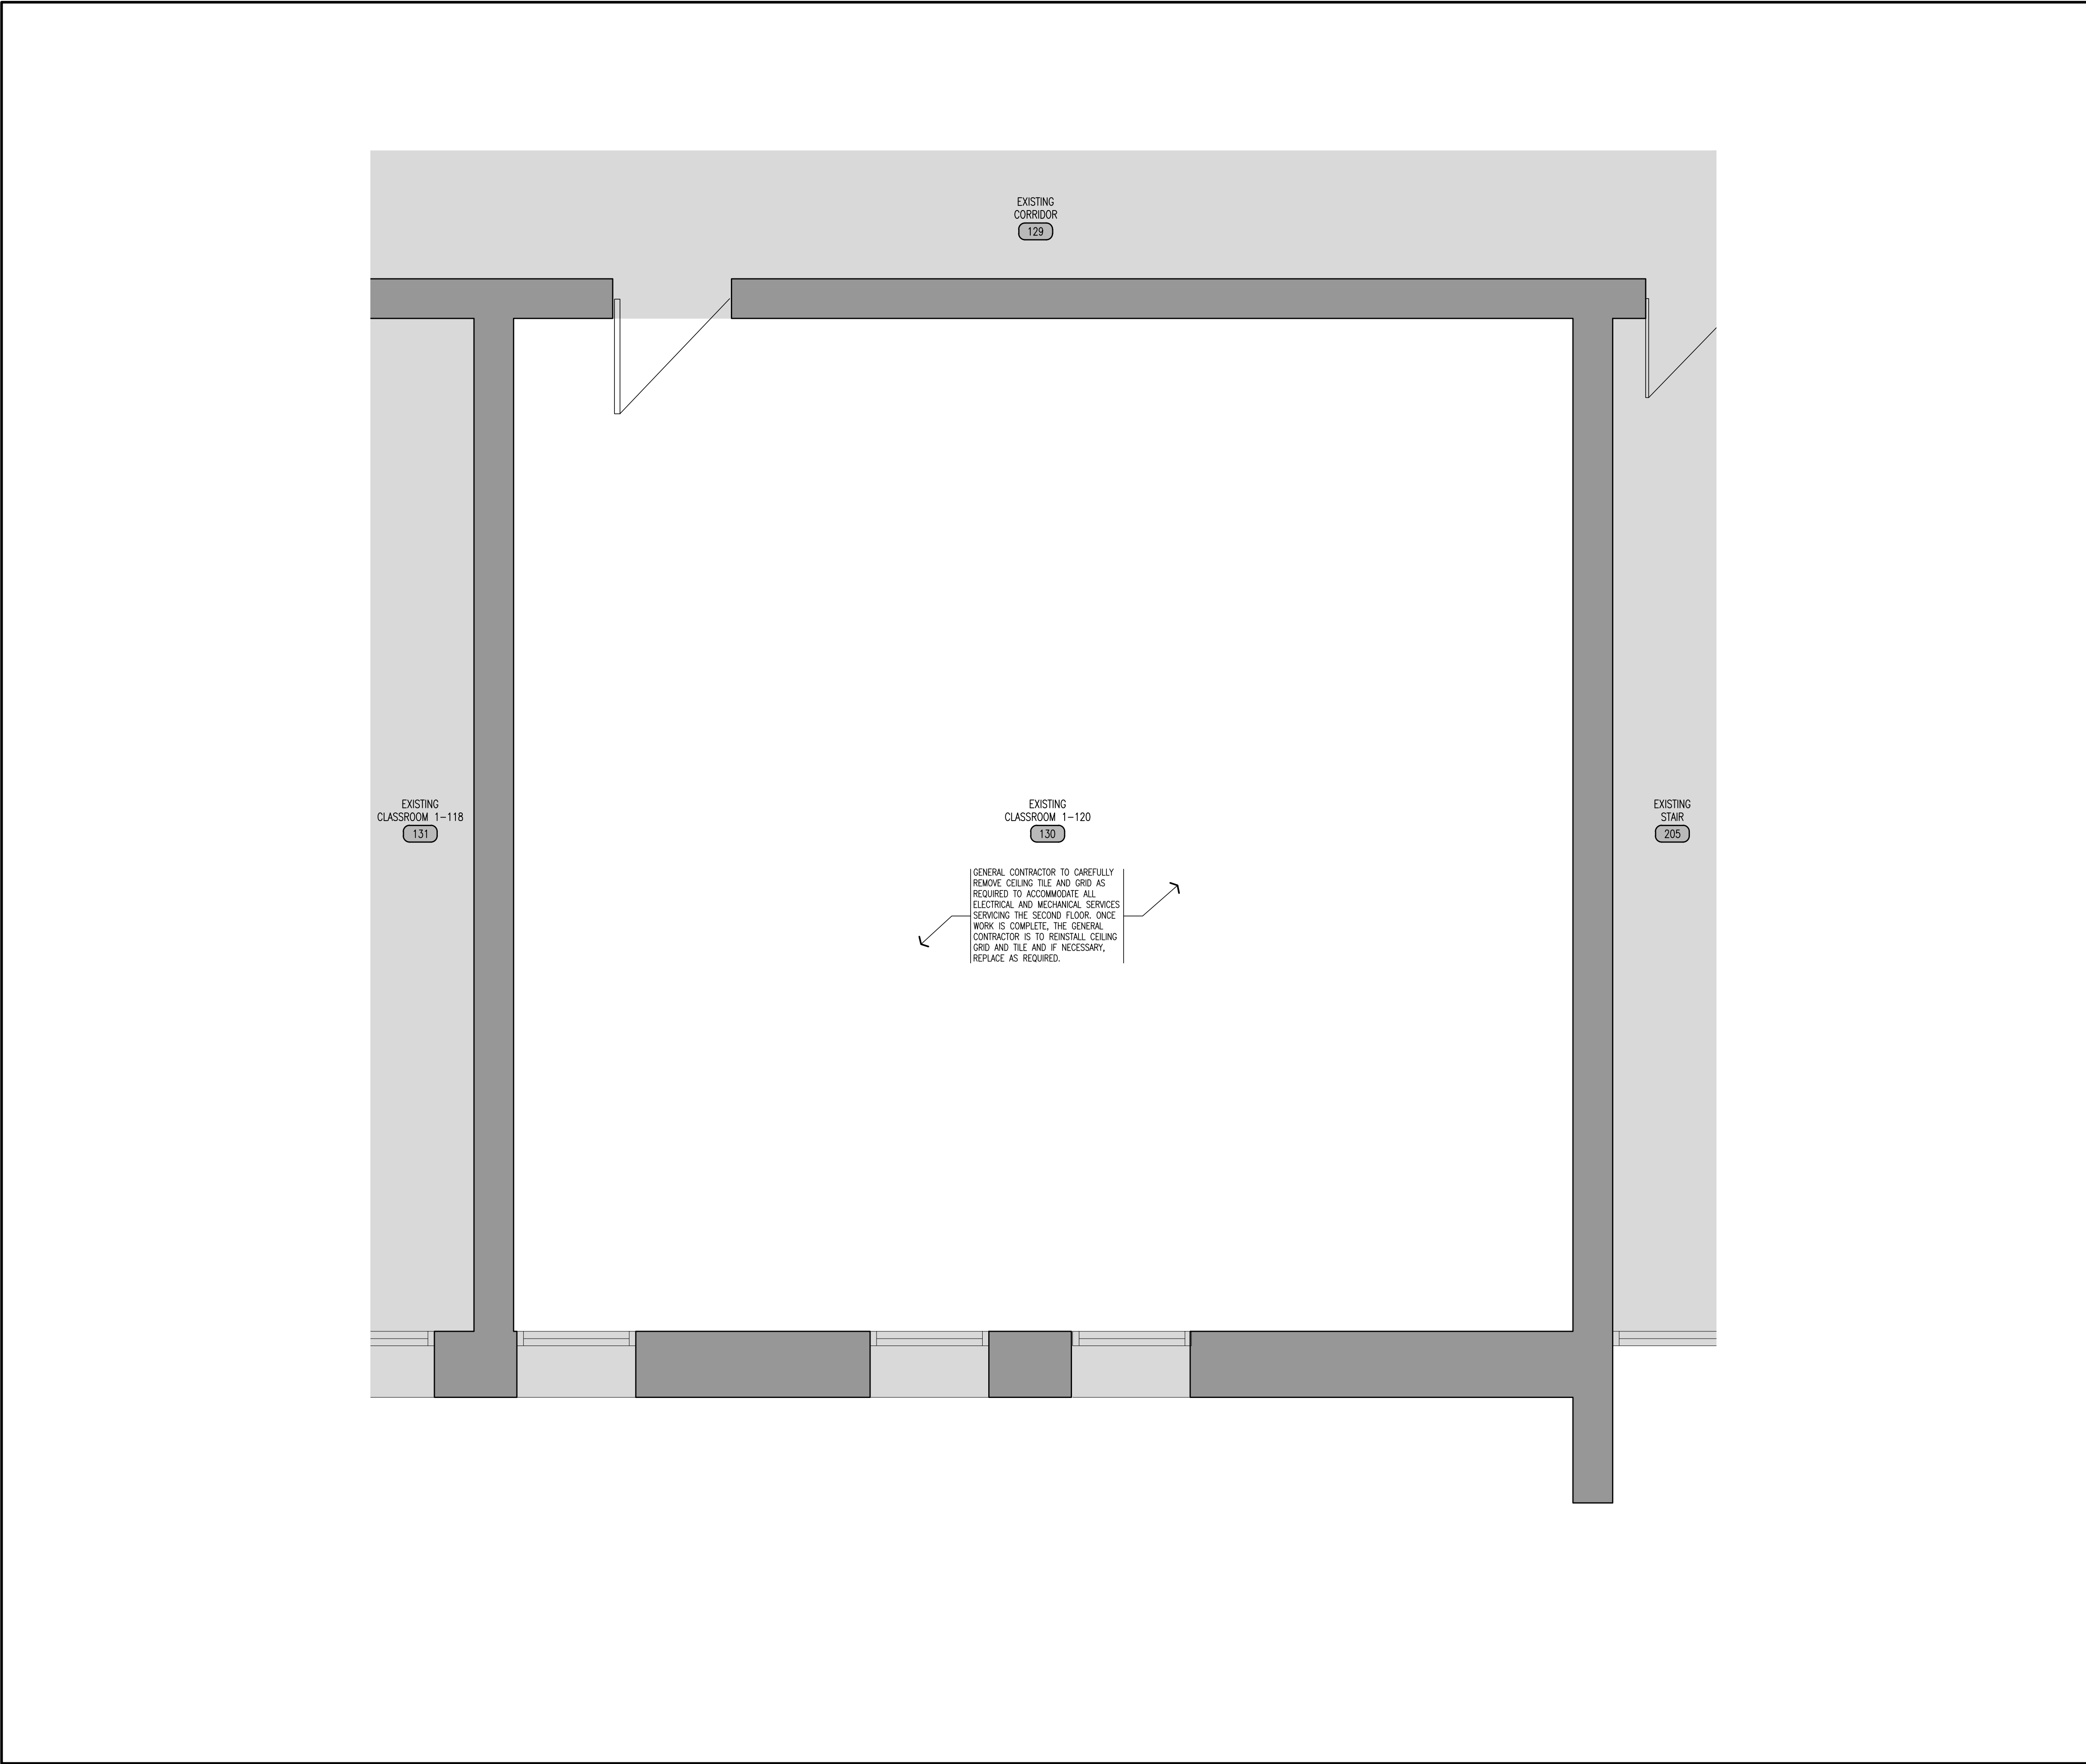

1 PARTIAL FIRST FLOOR PLAN
ROOM 1-120
scale: 1 : 50

GENERAL NOTES

1. CONTRACTOR MUST VERIFY ALL DIMENSIONS AND BE RESPONSIBLE FOR THE SAME. REPORT ANY ERRORS OR OMISSIONS TO THE ARCHITECT IN WRITING PRIOR TO COMMENCING WITH THE WORK. PRINTS ARE NOT TO BE SCALED.
2. THIS DRAWING IS TO BE READ IN CONJUNCTION WITH ALL OTHER ARCHITECTURAL, MECHANICAL & ELECTRICAL DRAWINGS FOR A COMPLETE SCOPE OF WORK.
3. WHERE FLOORING IS BEING REMOVED, GRIND SMOOTH EXISTING CONCRETE FLOOR SLAB TO REMOVE ANY REMNANT ADHESIVE, MORTAR ETC. & MAKE READY TO RECEIVE NEW FLOOR FINISHES.
4. CRACKING IN CONCRETE SLAB NOT RELATED TO TRANSITIONS OR SAWCUTTING ARE TO BE CLEANED OUT, INFILLED & LEVELLED SMOOTH. GRIND SMOOTH, INFILL AND PATCH LOCATIONS OF SAWCUTS OR TRANSITION JOINTS & COLUMNS ISOLATION JOINTS TO MAKE TRANSITION IMPERCEPTIBLE IN PREPARATION OF INSTALLATION OF ALL NEW FLOORING. GENERAL CONTRACTOR TO SITE CONFIRM LOCATIONS.
5. LEVEL SLAB AREAS AFTER ANY REMOVALS WHICH MAY HAVE DIFFERENT ELEVATIONS.
6. WHERE EXISTING SURFACES ARE DISTURBED DUE TO DEMOLITION OR ALTERATIONS WORK, SUCH SURFACES SHALL BE MADE GOOD TO MATCH EXISTING ADJACENT MATERIALS.
7. THE GENERAL CONTRACTOR WILL PATCH, REPAIR OR REPLACE ANY DAMAGED ITEMS, UNDER HIS RESPONSIBILITY AS A CONSEQUENCE OF IMPROPER STORAGE OR HANDLING, AT HIS OWN EXPENSE.
8. AT EXTERIOR & INTERIOR FIRE RATED WALL(S) & FIRE SEPARATIONS, ENSURE ALL PENETRATIONS & GAPS ARE FIRE STOPPED/ SEALED, WITH AN APPROVED FIRE STOP MATERIAL TO MAINTAIN DESIGNATED RATING OF DESIGN AS REQUIRED.
9. THE GENERAL CONTRACTOR IS TO PROTECT ALL FURNISHINGS AND FURNITURE WHILE WORK IS UNDERWAY. COORDINATE WITH SCHOOL BOARD REPRESENTATIVE.

NOTE 1:

THESE DRAWINGS ARE PREPARED WITH THE USE OF LINE TYPES, HATCH PATTERNS, COLOURS, AND NUMERICALLY DESIGNATED NOTES. COLLECTIVELY THESE REPRESENT THE FULL SCOPE OF WORK, WITH THE INTENT TO PROVIDE CLARITY. NOT ALL ITEMS MAY BE INDIVIDUALLY NOTED. IF ANYTHING IS AMBIGUOUS THE GENERAL CONTRACTOR IS TO ASK FOR CLARIFICATION AT THE TIME OF TENDER. FAILURE TO DO SO WILL LEAVE THE INTERPRETATION OF THE DRAWINGS TO THE ARCHITECT. THIS NOTE APPLIES TO ALL DRAWINGS.

NOTE 2:

THIS DRAWING CONTAINS THE USE OF COLOUR TO BETTER ILLUSTRATE AND DESCRIBE THE INTENT OF THE DRAWING BY HIGHLIGHTING LINE TYPES, HATCH PATTERNS, TEXT, DIMENSIONS, OR TONES. IT IS MANDATORY THAT THIS DRAWING BE PRINTED IN COLOUR FOR ITS USE. FAILURE TO DO SO WILL NOT RESULT IN ANY COMPENSATION FOR COSTS OR TIME LOST BY THE GC OR HIS/HER SUBTRADE DUE TO OMISSIONS, ERRORS, OR MISUNDERSTANDING OF THE FULL SCOPE OF THE WORK.


LEGEND

- APPROXIMATE AREA NOT IN CONTRACT SCOPE.
- EXISTING WALL.
- NEW INTERIOR BLOCK WALL.
- NEW DOOR & DOOR NUMBER.
- EXISTING DOOR & FRAME & DOOR NUMBER.
- ROOM NAME & NUMBER.
- EXISTING ROOM NAME & NUMBER.
- WALL TYPE.
- WINDOW NUMBER.
- MAIN ENTRANCE.
- SECONDARY ENTRANCE/EXIT.



NOTE:
This drawing and all associated documentation are the confidential property of BJC architects + assoc.s, inc. and must be returned upon request. Any duplication, reuse, revision and/or distribution in part or whole without the prior written authorization of BJC architects + assoc.s, inc. is strictly prohibited. Each contractor will check and verify all dimensions and report all errors and omissions to the design professional whose seal is affixed to this drawing. Do not scale this drawing.
The information and material herein reflect the best judgement of BJC architects + assoc.s, inc. in light of the information available to them at the time of preparation of these documents. Any use which a third party makes of these documents, or any reliance on or decisions to be made based on them, is the sole responsibility of such third party. BJC architects + assoc.s, inc. accepts no responsibility for damages, if any, suffered by any third party as a result of decisions made or actions based on these documents © BJC architects + assoc.s, inc. 2025.

01	ISSUED FOR TENDER	2026.04.08
No.	REVISIONS	date

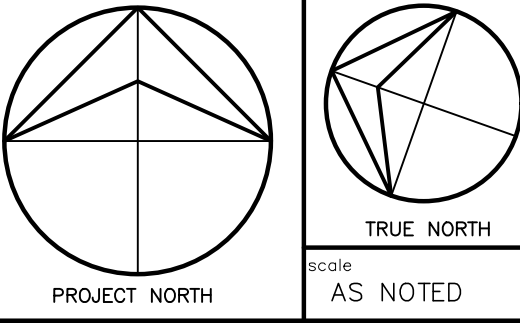


drawn	VA
last worked on by	2026.04.08 MV
checked	B.R.J.
print date	2026.04.08



client	WATERLOO REGION DISTRICT SCHOOL BOARD
51 ARDELT AVE KITCHENER	ONTARIO
project	GRAND RIVER COLLEGIATE INSTITUTE RENOVATION
175 INDIAN RD KITCHENER	ONTARIO

drawing title
PARTIAL FIRST FLOOR PLAN
ROOM 1-120

reference	
project no.	25-092
client reference number	
sheet no.	A - 112 01

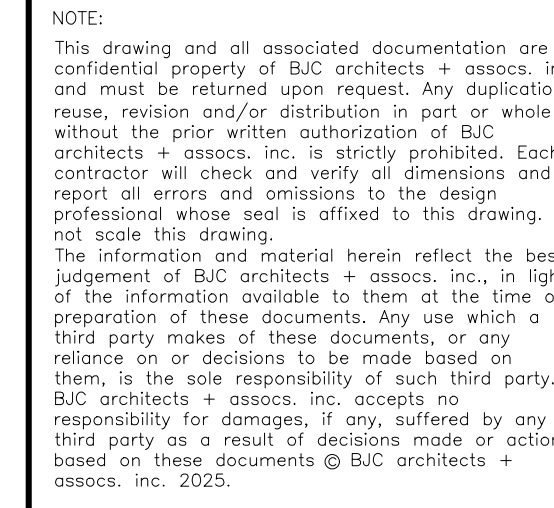

BJC
architects + assocs. inc.

drawing title

PARTIAL SECOND
FLOOR & WALL
FINISHES PLAN

reference	
project no. 25-092	client reference number
sheet no.	
A - 1 2 0 0 1	

1. CONTRACTOR MUST VERIFY ALL DIMENSIONS AND BE RESPONSIBLE FOR THE SAME. REPORT ANY ERRORS OR OMISSIONS TO THE ARCHITECT IN WRITING PRIOR TO COMMENCING WITH THE WORK. PRINTS ARE NOT TO BE SCALED.
2. THIS DRAWING IS TO BE READ IN CONJUNCTION WITH ALL OTHER ARCHITECTURAL, MECHANICAL & ELECTRICAL DRAWINGS FOR A COMPLETE SCOPE OF WORK.
3. PATTERNS OF HATCHING ARE GRAPHIC REPRESENTATIONS ONLY. THEY DO NOT REPRESENT FLOORING PLACEMENT OR COURSING.
4. GENERAL CONTRACTOR IS RESPONSIBLE FOR PROVIDING FLOORING PROTECTION UNTIL HANDED OVER TO OWNER. ALL FLOORING DAMAGED AS A RESULT OF PROTECTION NOT BEING PROVIDED WILL BE THE RESPONSIBILITY OF THE GENERAL CONTRACTOR TO REPAIR AND OR REPLACE AT THE GENERAL CONTRACTOR'S EXPENSE.
5. ENSURE ALL SURFACES ARE CLEAN AND FREE OF DEBRIS PRIOR TO PAINTING.
6. ALL WALLS AND GYPSUM BOARD ARE TO BE PAINTED. COLOUR: TBD.
7. ALL DOORS AND FRAMES ARE TO BE PAINTED. COLOUR: TBD.
8. PAINTED FINISHES SHALL EXTEND BEHIND ALL MILLWORK & WALL MOUNTED ACCESSORIES.
9. FLOORING IS TO EXTEND UNDER ALL NEW MILLWORK UNLESS OTHERWISE SPECIFIED.

THESE DRAWINGS ARE PREPARED WITH THE USE OF LINE TYPES, HATCH PATTERNS, COLOURS, AND NUMERICALLY DESIGNATED NOTES. COLLECTIVELY THESE REPRESENT THE FULL SCOPE OF WORK, WITH THE INTENT TO PROVIDE CLARITY. NOT ALL ITEMS MAY BE INDIVIDUALLY NOTED. IF ANYTHING IS AMBIGUOUS THE GENERAL CONTRACTOR IS TO ASK FOR CLARIFICATION AT THE TIME OF TENDER. FAILURE TO DO SO WILL LEAVE THE INTERPRETATION OF THE DRAWINGS TO THE ARCHITECT. THIS NOTE APPLIES TO ALL DRAWINGS.

THIS DRAWING CONTAINS THE USE OF COLOUR TO BETTER ILLUSTRATE AND DESCRIBE THE INTENT OF THE DRAWING BY HIGHLIGHTING LINE TYPES, HATCH PATTERNS, TEXT, DIMENSIONS, OR TONES. IT IS MANDATORY THAT THIS DRAWING BE PRINTED IN COLOUR FOR ITS USE. FAILURE TO DO SO WILL NOT RESULT IN ANY COMPENSATION FOR COSTS OR TIME LOST BY THE GC OR HIS/HER SUBTRADE DUE TO OMISSIONS, ERRORS, OR MISUNDERSTANDING OF THE FULL SCOPE OF THE WORK.

APPROXIMATE AREA NOT IN CONTRACT SCOPE.

EXISTING WALL.

NEW INTERIOR WALL.

NEW DOOR & DOOR NUMBER.

EXISTING DOOR & FRAME & DOOR NUMBER.

ROOM NAME ROOM NAME & NUMBER.

ROOM NAME ROOM NAME & NUMBER.

AREA OF NEW SAFETY VINYL SHEET FLOORING c/w 100mm RUBBER WALL BASE. MANUFACTURERS: POLYSAFE VERONA PUR COLOUR: TBD

TRANSITION STRIP.


PAINT FINISH COLOUR:

CERAMIC TILE COLOUR:

APPROXIMATE AREA OF FLOOR TO BE SKIMMED A MINIMUM OF 150mm TO PROVIDE A SMOOTH TRANSITION.



3 _____ RESERVED

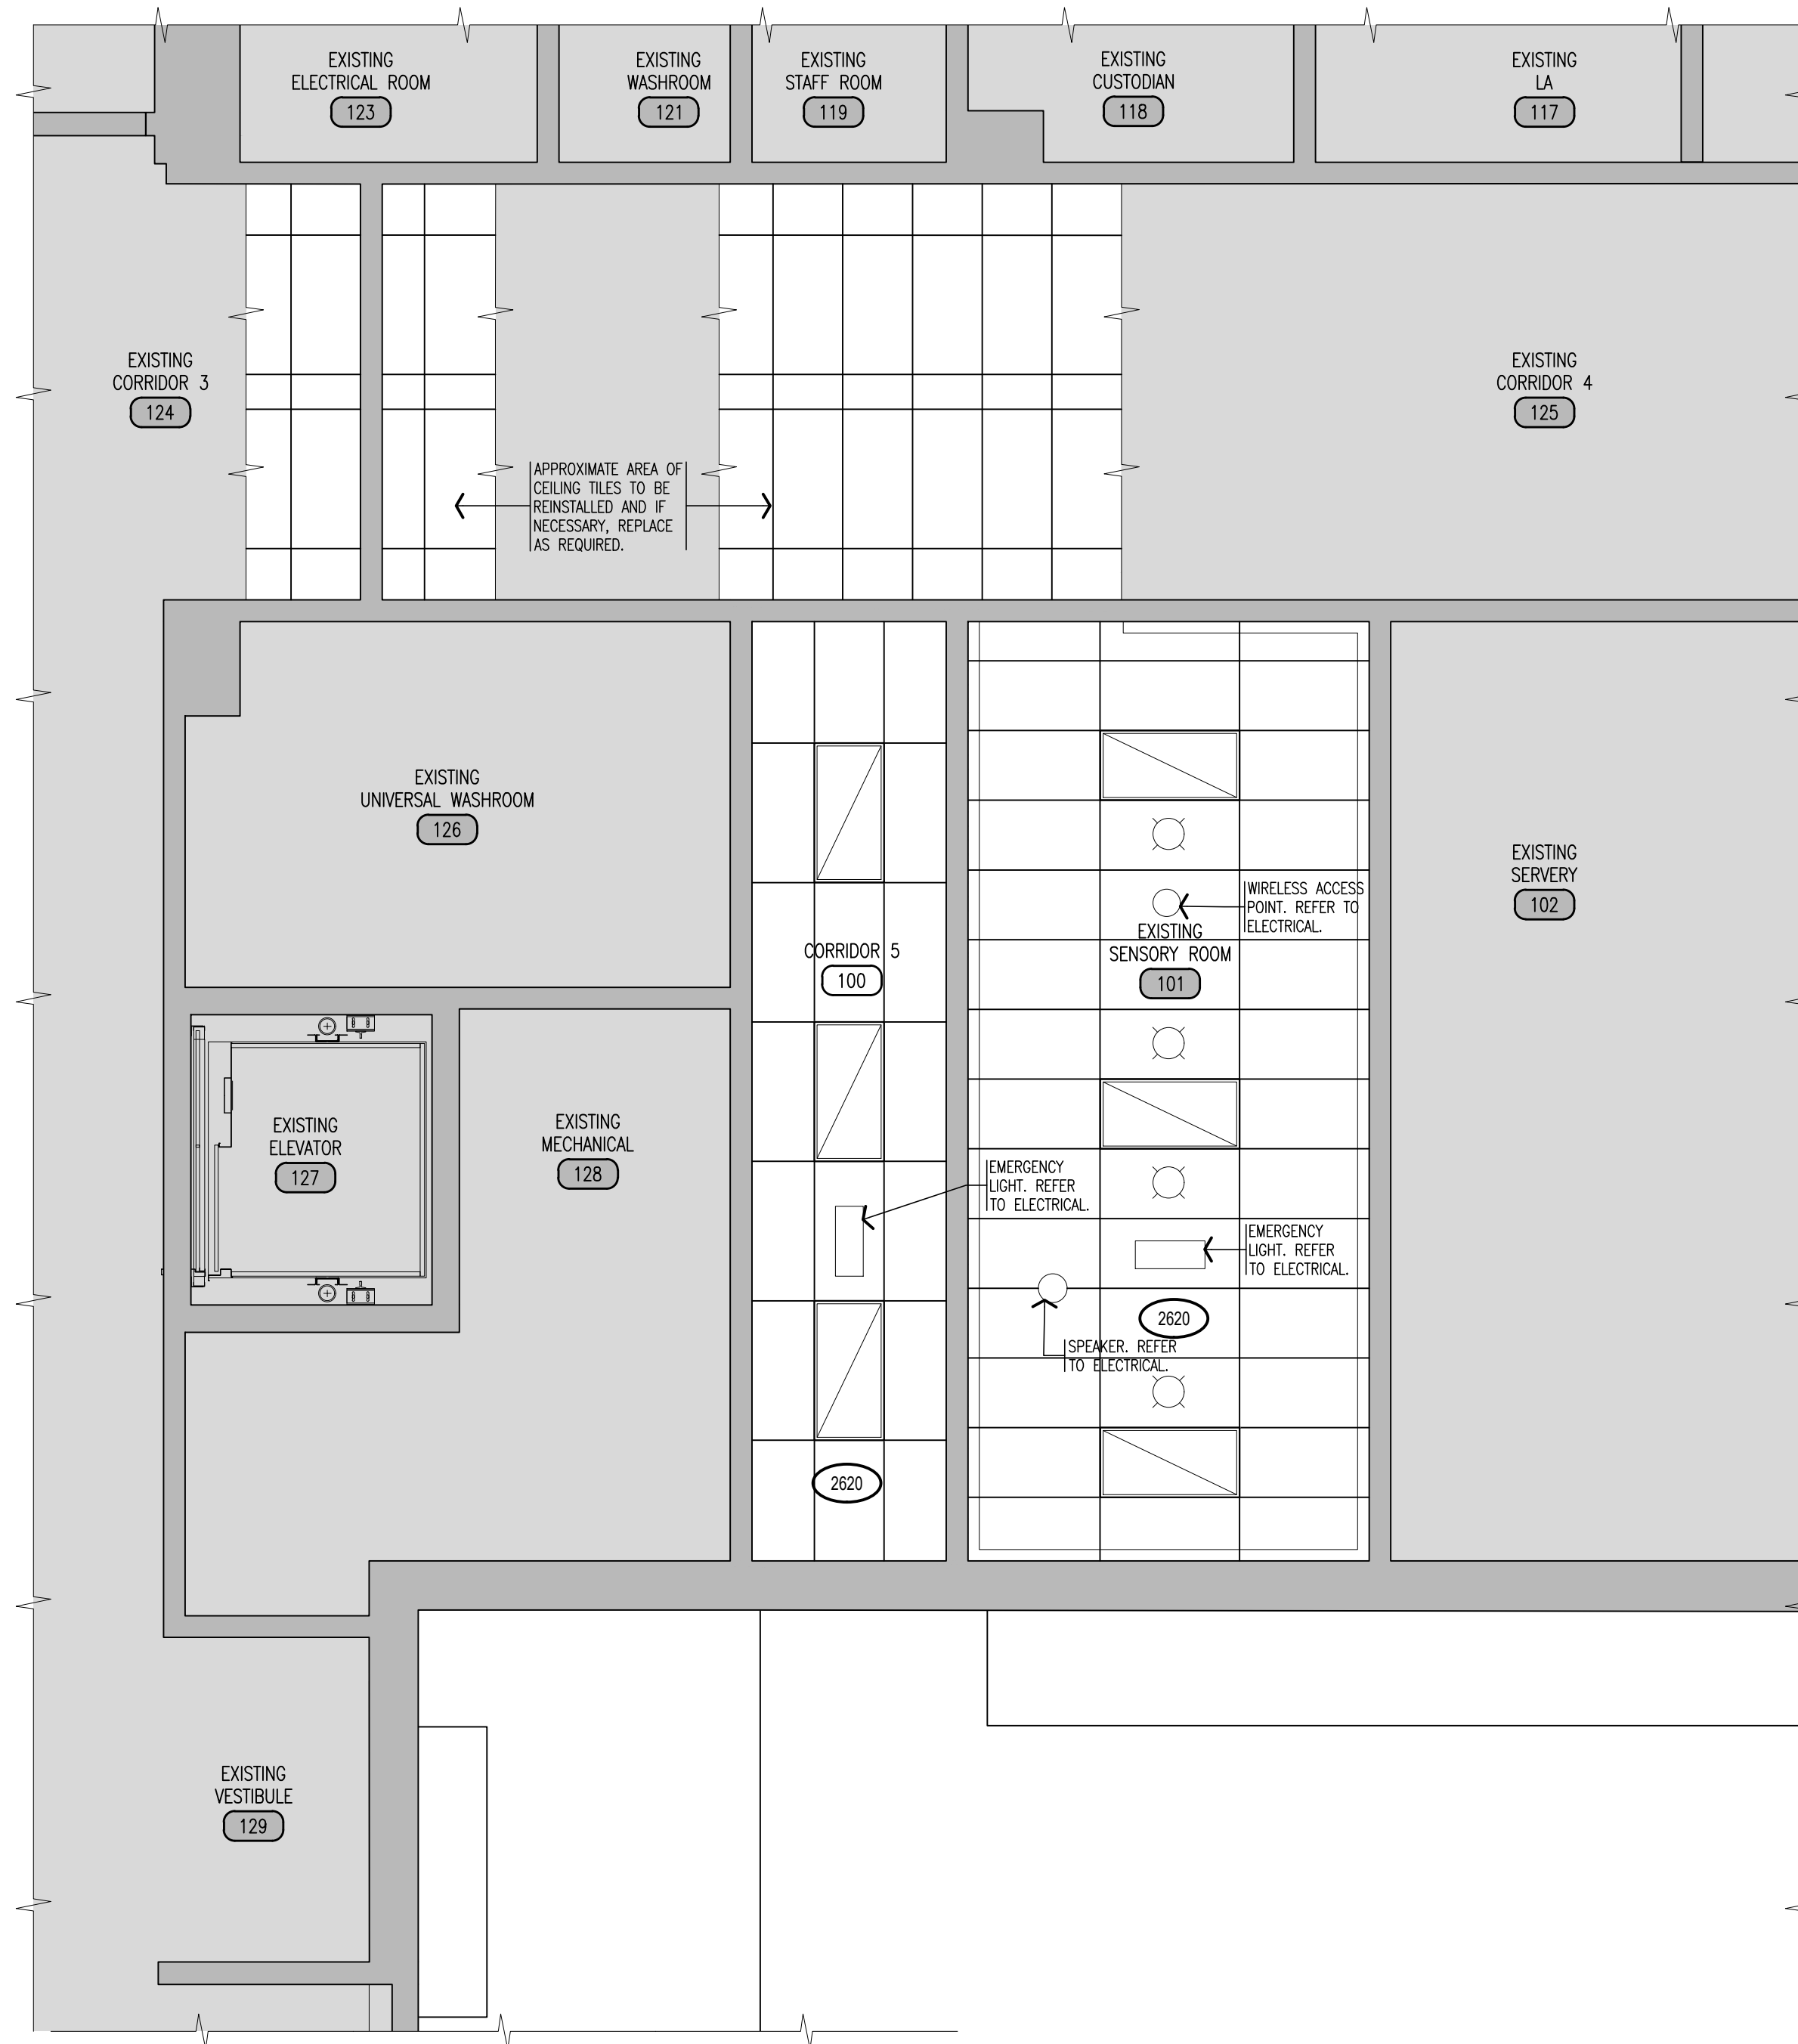

1 PARTIAL FIRST FLOOR REFLECTED CEILING PLAN
ROSEMOUNT WING

scale: 1 : 50

GENERAL NOTES

1. CONTRACTOR MUST VERIFY ALL DIMENSIONS AND BE RESPONSIBLE FOR THE SAME. REPORT ANY ERRORS OR OMISSIONS TO THE ARCHITECT IN WRITING PRIOR TO COMMENCING WITH THE WORK. PRINTS ARE NOT TO BE SCALED.
2. THIS DRAWING IS TO BE READ IN CONJUNCTION WITH ALL OTHER ARCHITECTURAL, MECHANICAL & ELECTRICAL DRAWINGS FOR A COMPLETE SCOPE OF WORK.
3. WHERE EXISTING SURFACES ARE DISTURBED DUE TO DEMOLITION OR ALTERATIONS WORK, SUCH SURFACES SHALL BE MADE GOOD TO MATCH EXISTING ADJACENT MATERIALS.
4. PATCH AND REPAIR AFFECTED WALLS WHERE T-BAR CEILING HAS BEEN REMOVED. MAKE GOOD TO MATCH EXISTING.

NOTE 1:

THESE DRAWINGS ARE PREPARED WITH THE USE OF LINE TYPES, HATCH PATTERNS, COLOURS, AND NUMERICALLY DESIGNATED NOTES. COLLECTIVELY THESE REPRESENT THE FULL SCOPE OF WORK, WITH THE INTENT TO PROVIDE CLARITY. NOT ALL ITEMS MAY BE INDIVIDUALLY NOTED. IF ANYTHING IS AMBIGUOUS THE GENERAL CONTRACTOR IS TO ASK FOR CLARIFICATION AT THE TIME OF TENDER. FAILURE TO DO SO WILL LEAVE THE INTERPRETATION OF THE DRAWINGS TO THE ARCHITECT. THIS NOTE APPLIES TO ALL DRAWINGS.

LEGEND

- APPROXIMATE AREA NOT IN CONTRACT SCOPE.
- EXISTING AND NEW WALLS.
- ROOM NAME & NUMBER.
 ROOM NAME & NUMBER.
- CEILING ELEVATION MARKER ABOVE FINISHED FLOOR LEVEL.
- NEW LAY-IN ACOUSTIC TILE CEILING & T-BAR SUSPENSION SYSTEM. MANUFACTURER: ARMSTRONG DUNE SQUARE LAY-IN 1851M COORDINATE WITH MECHANICAL AND ELECTRICAL.
- LIGHT FIXTURES. (REFER TO ELECTRICAL DRAWINGS).
- MECHANICAL GRILLES & DIFFUSERS. (REFER TO MECHANICAL DRAWINGS).



NOTE:
This drawing and all associated documentation are the confidential property of BJC architects + assocs. inc. and must be returned upon request. Any duplication, reuse, revision and/or distribution in part or whole without the prior written authorization of BJC architects + assocs. inc. is strictly prohibited. Each contractor will check and verify all dimensions and report all errors and omissions to the design professional whose seal is affixed to this drawing. Do not scale this drawing.
The information and material herein reflect the best judgement of BJC architects + assocs. inc. in light of the information available to them at the time of preparation of these documents. Any use which a third party makes of these documents, or any reliance on or decisions to be made based on them, is the sole responsibility of such third party. BJC architects + assocs. inc. accepts no responsibility for damages, if any, suffered by any third party as a result of decisions made or actions based on these documents © BJC architects + assocs. inc. 2025.

01	ISSUED FOR TENDER	2026.04.08
No.	REVISIONS	date
PROJECT NORTH		TRUE NORTH
		scale: AS NOTED

drawn	VA
last worked on	by 2026.03.18 MV
checked	
B.R.J.	
print date	2026.04.08



client	WATERLOO REGION DISTRICT SCHOOL BOARD
51 ARDELT AVE KITCHENER	ONTARIO
project	GRAND RIVER COLLEGIATE INSTITUTE RENOVATION
175 INDIAN RD KITCHENER	ONTARIO

drawing title	PARTIAL FIRST FLOOR RCP ROSEMOUNT WING
---------------	--


reference	
project no.	25-092
client reference number	
sheet no.	

A - 160 01




scale: 1 : 25

sheet no. **A - 161** **01**

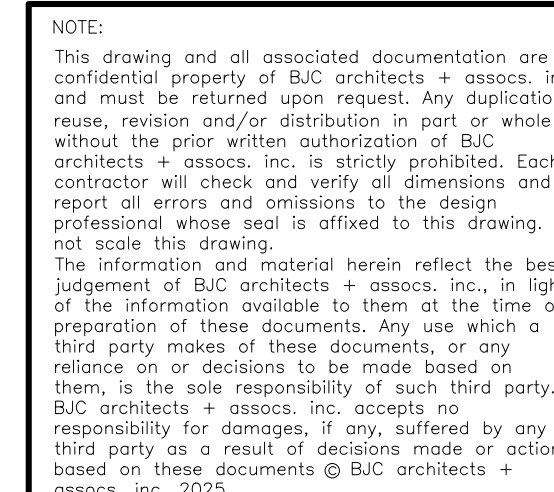

01	ISSUED FOR TENDER	2000
No.	REVISIONS	d

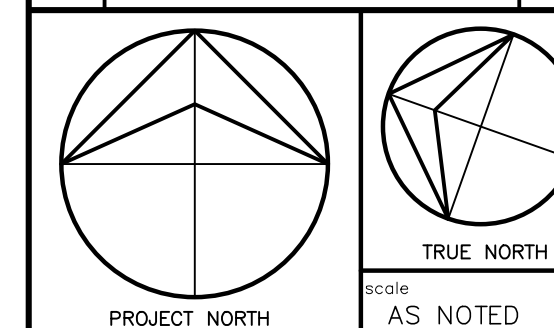

drawn VA		
last worked on 2026.03.18	by M	
checked B.R.J.		
print date 2026.04.08		



client	WATERLOO REGION DISTRICT SCHOOL BOARD
51 ARDELT AVE KITCHENER	ONTARIO
project	GRAND RIVER COLLEGIATE INSTITUTE RENOVATION
175 INDIAN RD KITCHENER	ONTARIO

drawing title

PARTIAL SECOND
FLOOR RCP FAMILY
STUDIES 1-221

reference	
project no. 25-092	client reference number
sheet no.	

A	-	1	6	2	0	1
---	---	---	---	---	---	---

1. CONTRACTOR MUST VERIFY ALL DIMENSIONS AND BE RESPONSIBLE FOR THE SAME. REPORT ANY ERRORS OR OMISSIONS TO THE ARCHITECT IN WRITING PRIOR TO COMMENCING WITH THE WORK. PRINTS ARE NOT TO BE SCALED.
2. THIS DRAWING IS TO BE READ IN CONJUNCTION WITH ALL OTHER ARCHITECTURAL, MECHANICAL & ELECTRICAL DRAWINGS FOR A COMPLETE SCOPE OF WORK.
3. WHERE EXISTING SURFACES ARE DISTURBED DUE TO DEMOLITION OR ALTERATIONS WORK, SUCH SURFACES SHALL BE MADE GOOD TO MATCH EXISTING ADJACENT MATERIALS.

THESE DRAWINGS ARE PREPARED WITH THE USE OF LINE TYPES, HATCH PATTERNS, COLOURS, AND NUMERICALLY DESIGNATED NOTES. COLLECTIVELY THESE REPRESENT THE FULL SCOPE OF WORK, WITH THE INTENT TO PROVIDE CLARITY. NOT ALL ITEMS MAY BE INDIVIDUALLY NOTED. IF ANYTHING IS AMBIGUOUS THE GENERAL CONTRACTOR IS TO ASK FOR CLARIFICATION AT THE TIME OF TENDER. FAILURE TO DO SO WILL LEAVE THE INTERPRETATION OF THE DRAWINGS TO THE ARCHITECT. THIS NOTE APPLIES TO ALL DRAWINGS.

THIS DRAWING CONTAINS THE USE OF COLOUR TO BETTER ILLUSTRATE AND DESCRIBE THE INTENT OF THE DRAWING BY HIGHLIGHTING LINE TYPES, HATCH PATTERNS, DIMENSIONS, OR TONES. IT IS MANDATORY THAT THIS DRAWING BE PRINTED IN COLOUR FOR ITS USE. FAILURE TO DO SO WILL NOT RESULT IN ANY COMPENSATION FOR COSTS OR TIME LOST BY THE GC OR HIS/HER SUBTRADE DUE TO OMISSIONS, ERRORS, OR MISUNDERSTANDING OF THE FULL SCOPE OF THE WORK.

APPROXIMATE AREA NOT
IN CONTRACT SCOPE.

EXISTING AND NEW WALLS.

ROOM NAME

101

ROOM NAME

101

CEILING ELEVATION
MARKER ABOVE FINISHED
FLOOR LEVEL

 
NEW LAY-IN ACUSTIC TILE CEILING & T-BAR
SUSPENSION SYSTEM
MANUFACTURER: ARMSTRONG DUNE SQUARE LAY-IN
COORDINATE WITH MECHANICAL AND ELECTRICAL.

NO LIGHT FIXTURES TO BE WITHIN AN
AREA OF 460mm AROUND HOOD.


LIGHT FIXTURES.
(REFER TO ELECTRICAL DRAWINGS).
NOTE: PROVIDE PERIMETER CLASSROOM LIGHTS
ON SEPARATE SWITCH.

MECHANICAL GRILLES & DIFFUSERS.
(REFER TO MECHANICAL DRAWINGS).

scale: 1 : 25




1 RESERVED

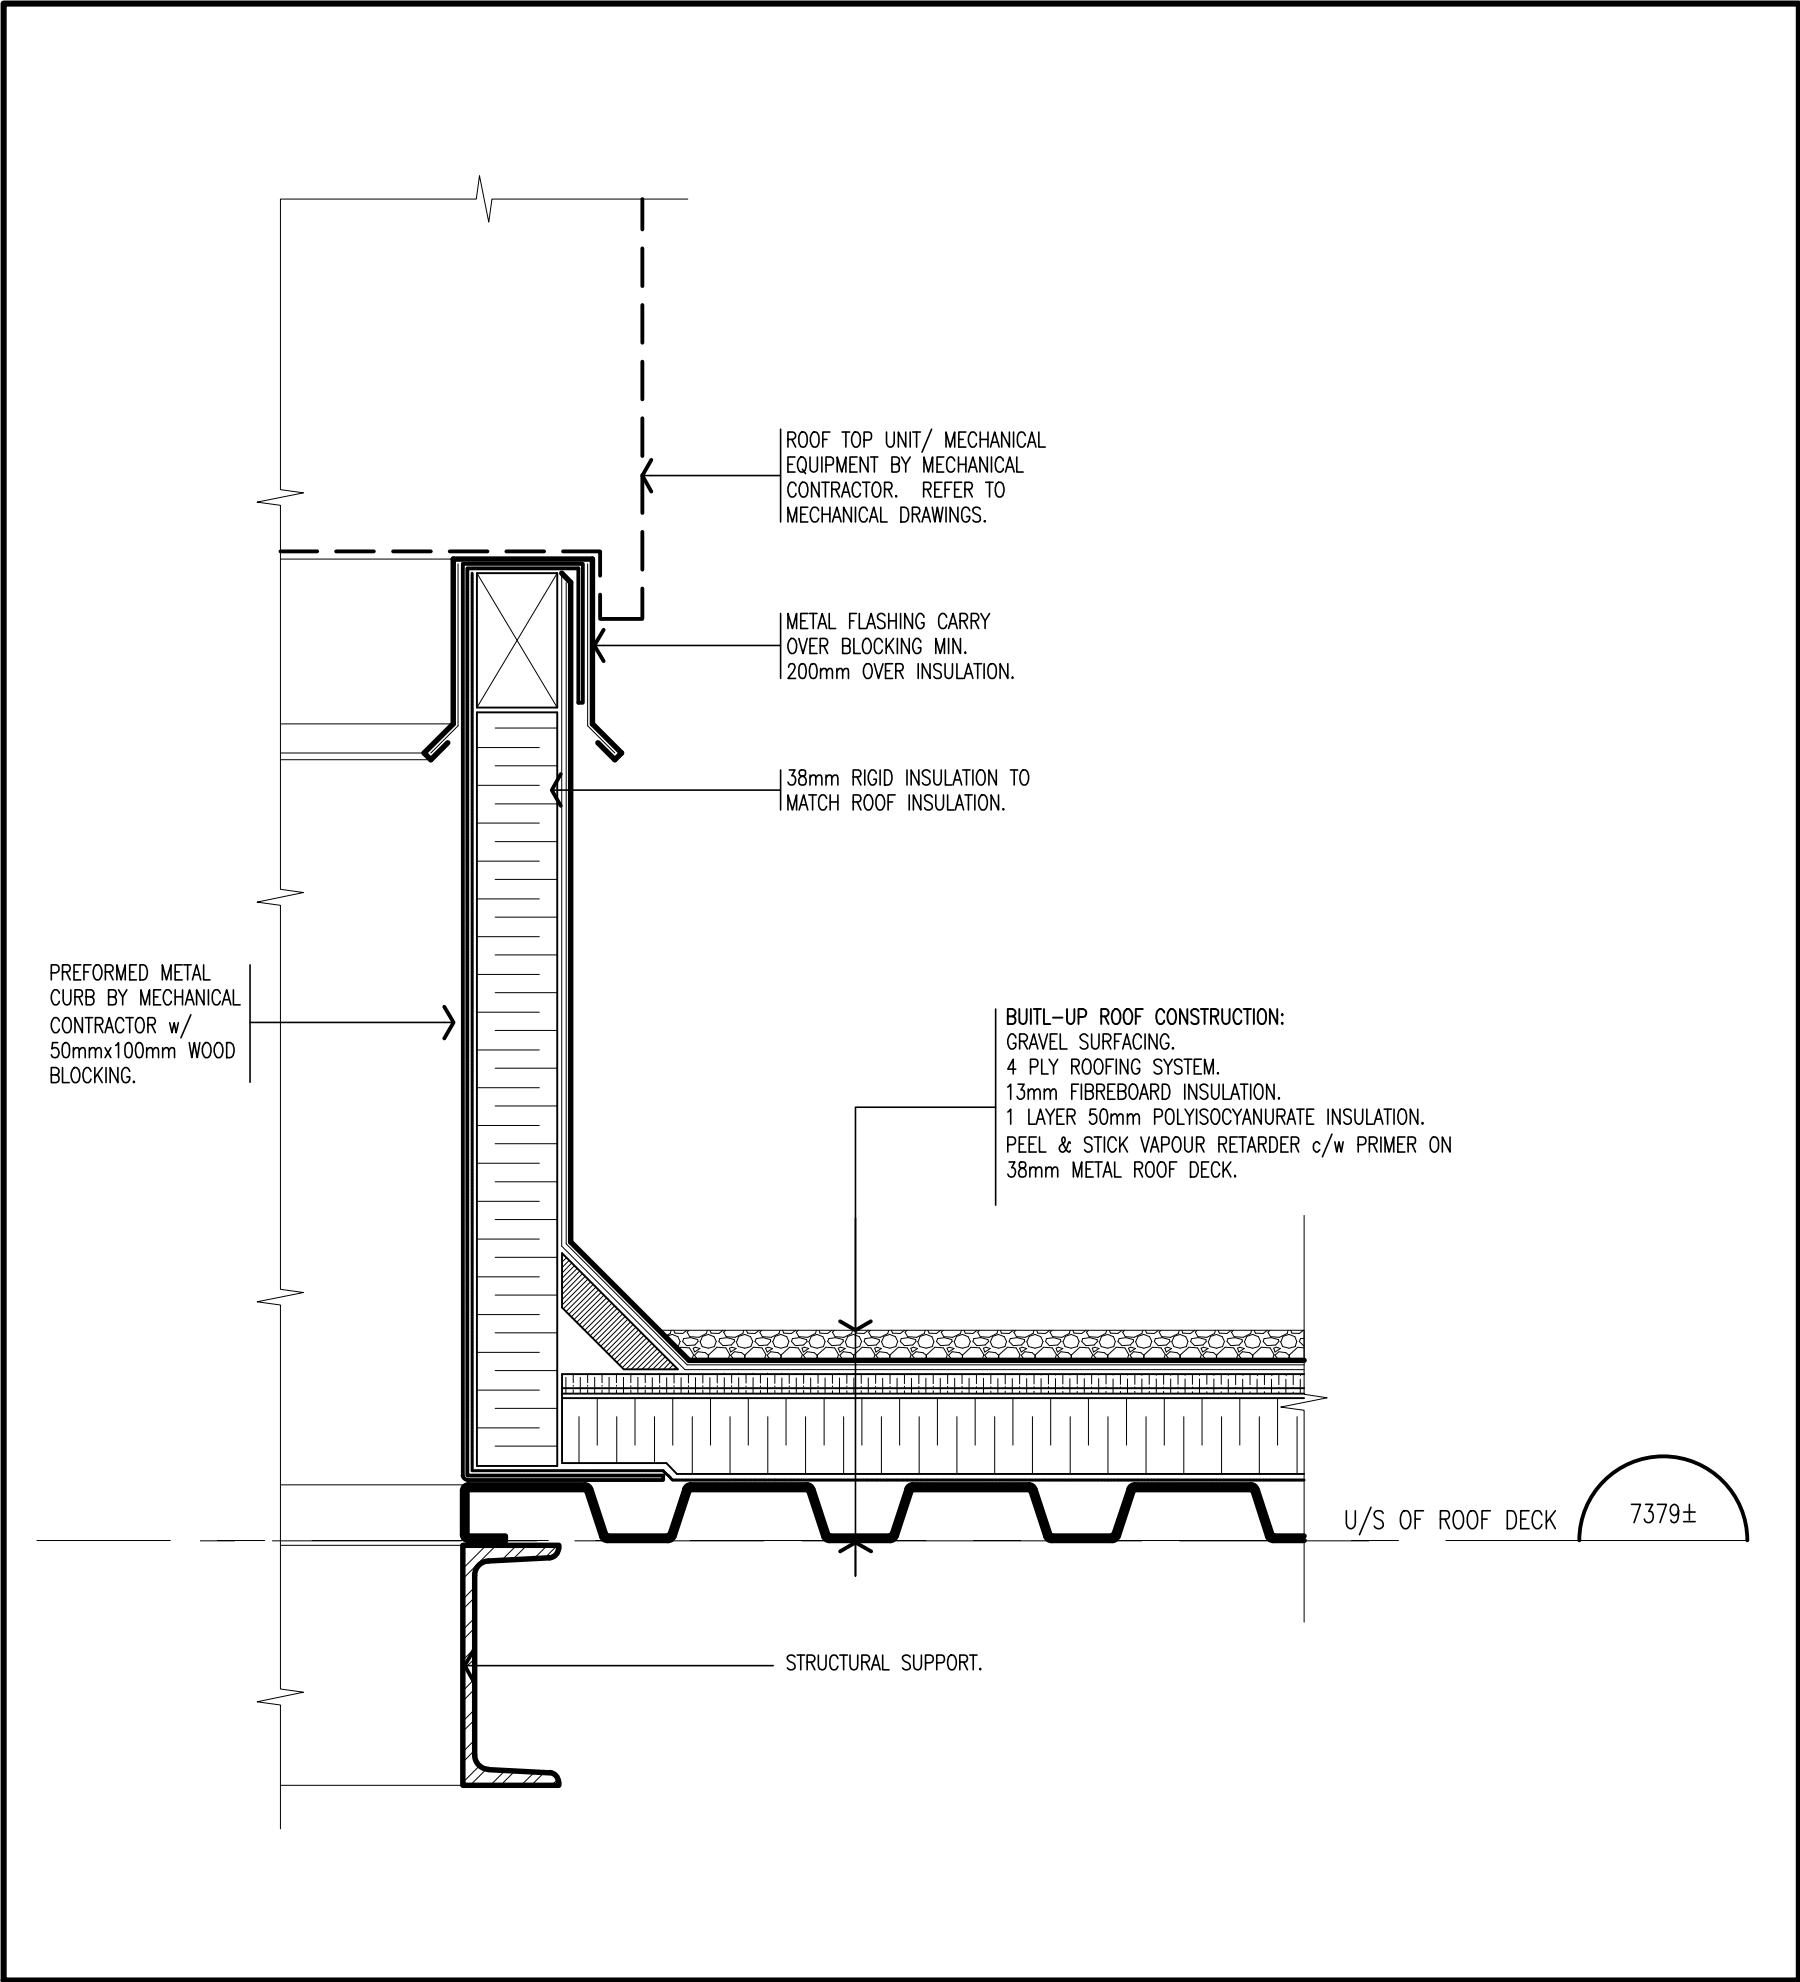

2 ROOF CURB DETAILS

scale: 1 : 5

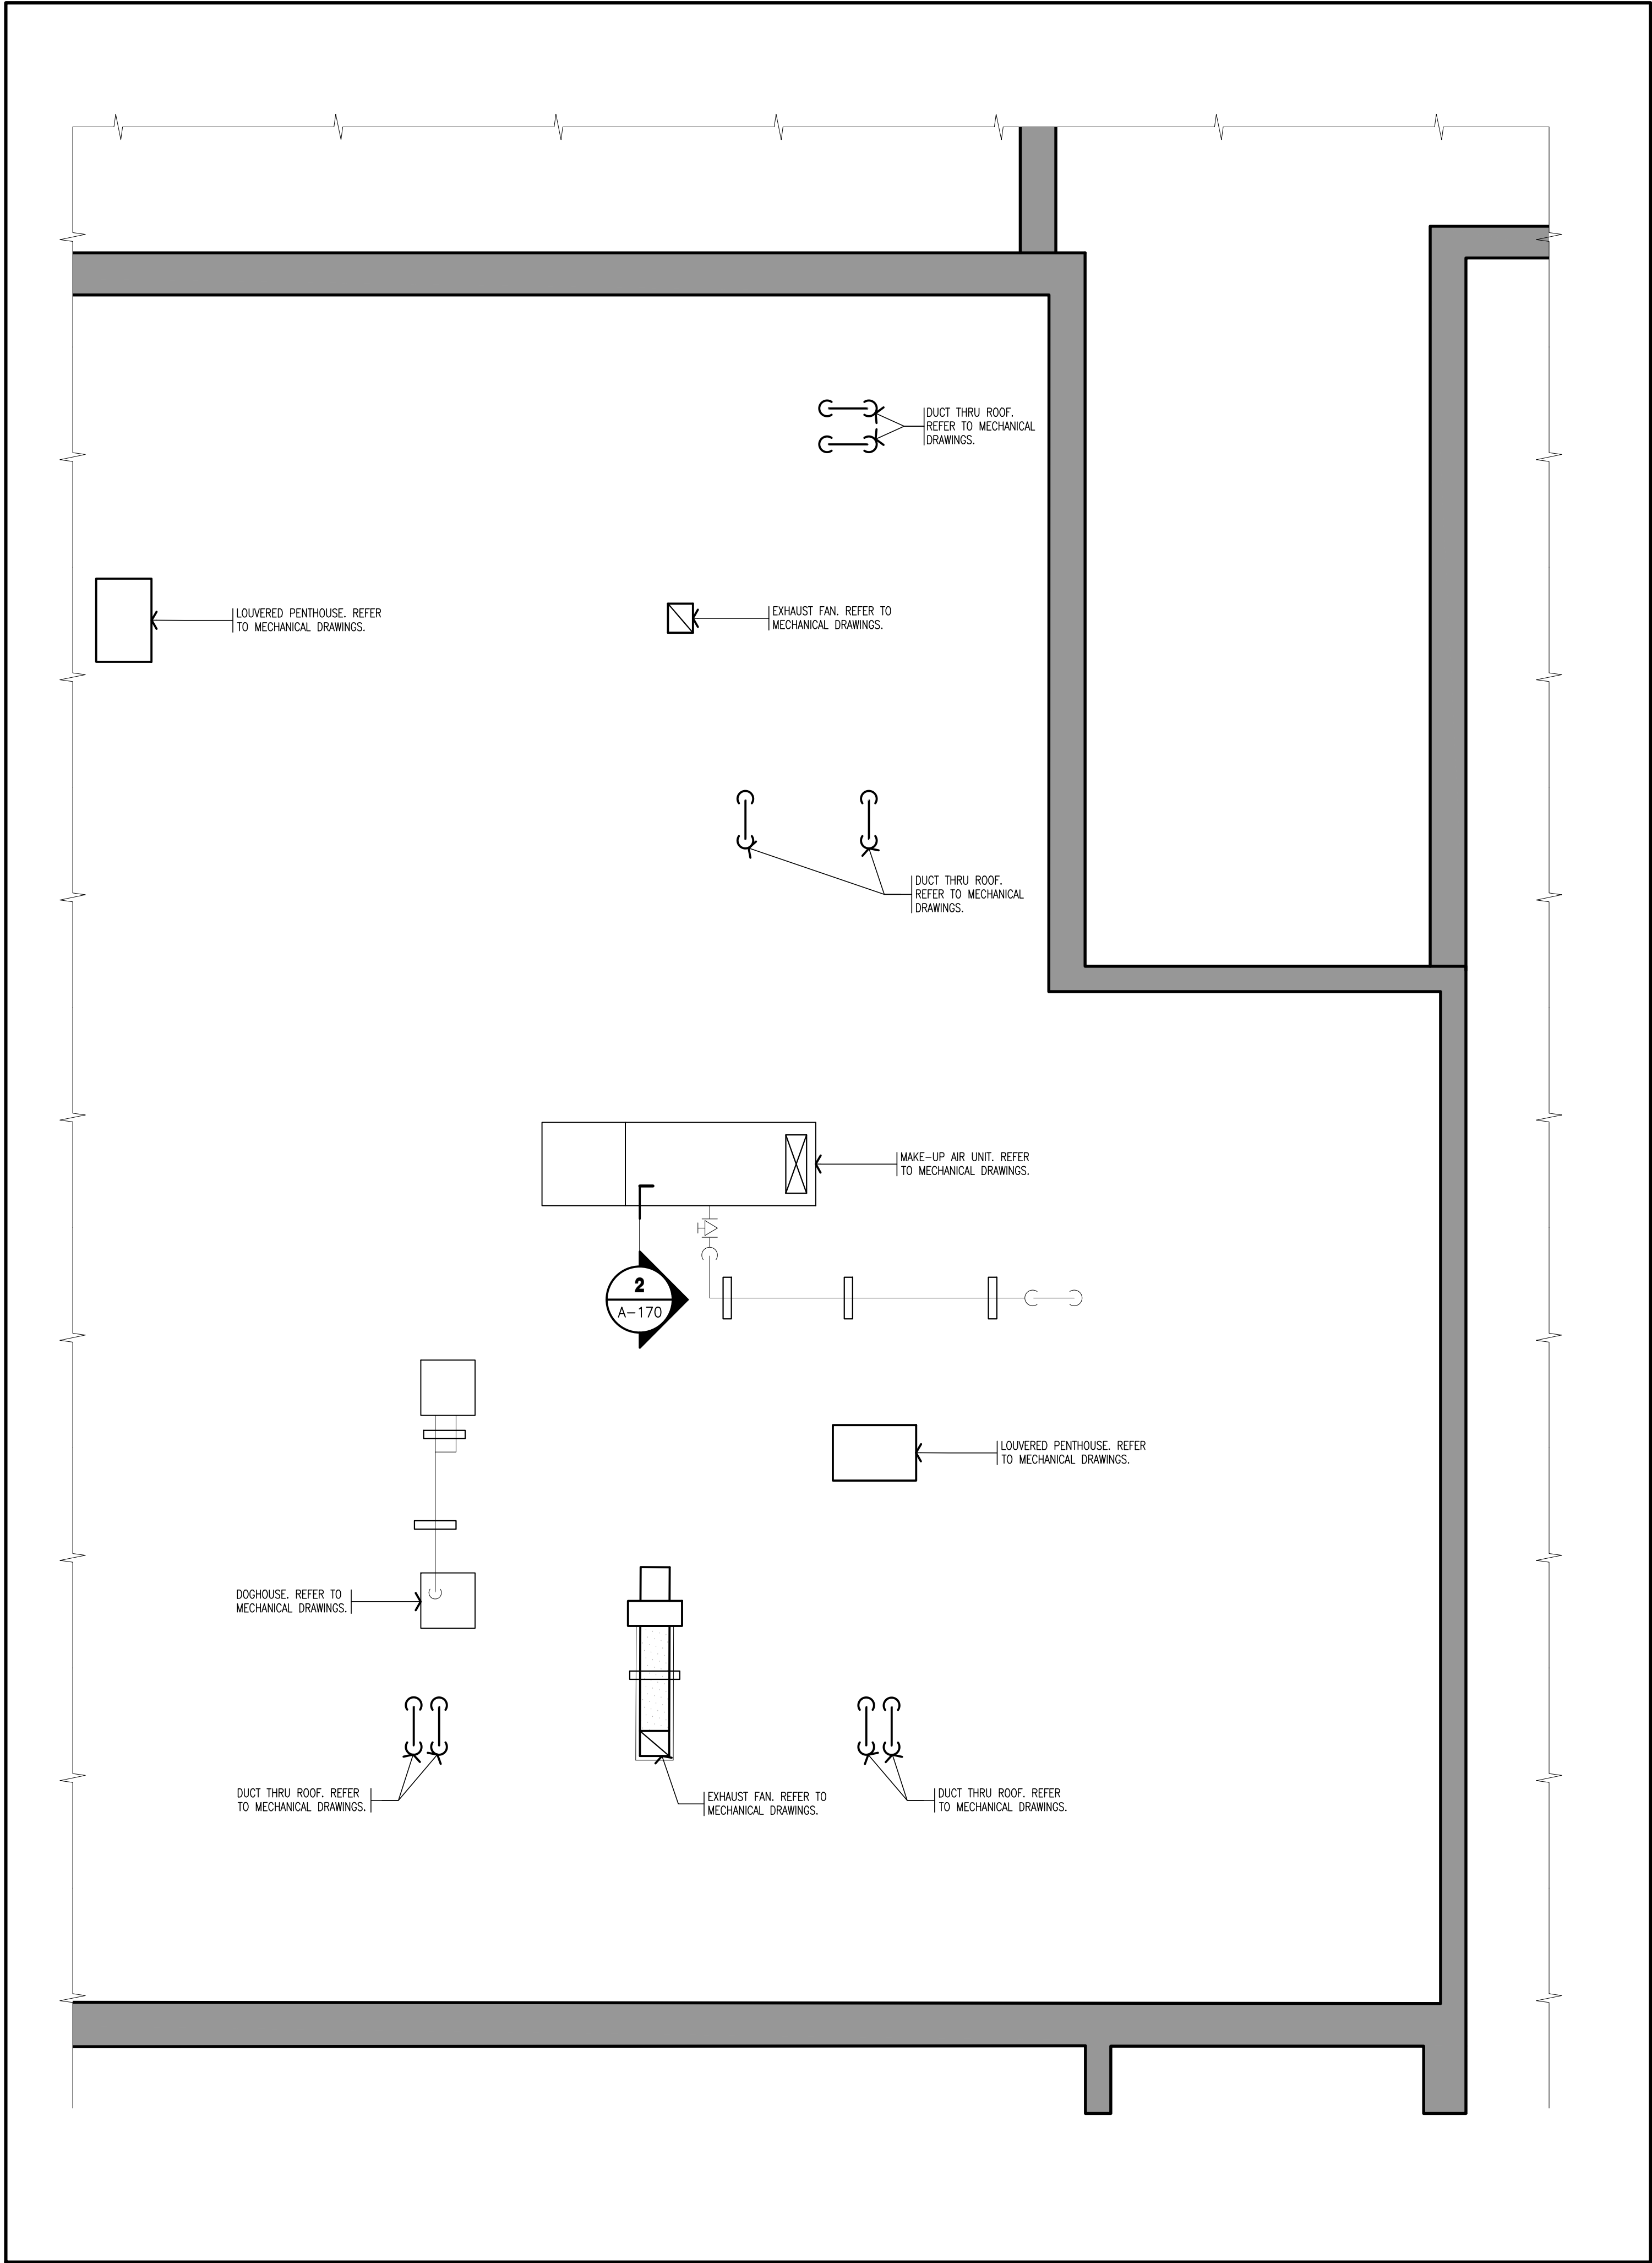

3 PARTIAL ROOF PLAN

scale: 1 : 25

GENERAL NOTES

1. CONTRACTOR MUST VERIFY ALL DIMENSIONS AND BE RESPONSIBLE FOR THE SAME. REPORT ANY ERRORS OR OMISSIONS TO THE ARCHITECT IN WRITING PRIOR TO COMMENCING WITH THE WORK. PRINTS ARE NOT TO BE SCALED.
2. THIS DRAWING IS TO BE READ IN CONJUNCTION WITH ALL OTHER ARCHITECTURAL, MECHANICAL & ELECTRICAL DRAWINGS FOR A COMPLETE SCOPE OF WORK.
3. REFER TO MECHANICAL AND ELECTRICAL DRAWINGS FOR ALL MECHANICAL ROOF TOP EQUIPMENT AND SERVICES.
4. COORDINATE ALL LOCATION OF OPENINGS FOR MECHANICAL UNITS AND ALL OTHER ROOF PENETRATIONS WITH STRUCTURAL DRAWINGS.

NOTE 1:

THESE DRAWINGS ARE PREPARED WITH THE USE OF LINE TYPES, HATCH PATTERNS, COLOURS, AND NUMERICALLY DESIGNATED NOTES. COLLECTIVELY THESE REPRESENT THE FULL SCOPE OF WORK, WITH THE INTENT TO PROVIDE CLARITY. NOT ALL ITEMS MAY BE INDIVIDUALLY NOTED. IF ANYTHING IS AMBIGUOUS THE GENERAL CONTRACTOR IS TO ASK FOR CLARIFICATION AT THE TIME OF TENDER. FAILURE TO DO SO WILL LEAVE THE INTERPRETATION OF THE DRAWINGS TO THE ARCHITECT. THIS NOTE APPLIES TO ALL DRAWINGS.

LEGEND

- APPROXIMATE AREA NOT IN CONTRACT SCOPE.
- EXISTING ROOF LINE.
- EXISTING EQUIPMENT TO REMAIN. REFER TO MECHANICAL & ELECTRICAL DWGS.
- NEW EQUIPMENT. REFER TO MECHANICAL & ELECTRICAL DWGS.
- APPROXIMATE EXTENT OF ROOF MEMBRANE TIE-IN AT NEW ROOF. PENETRATIONS AND PATCHES FOR REMOVED EQUIPMENT.
- NEW GAP PIPING/ CONDENSATE LINES. SEE MECHANICAL DWGS.



NOTE:
This drawing and all associated documentation are the confidential property of BJC architects + assoc. inc. and must be returned upon request. Any duplication, reuse, revision and/or distribution in part or whole without the prior written authorization of BJC architects + assoc. inc. is strictly prohibited. Each contractor will check and verify all dimensions and report all errors and omissions to the design professional whose seal is affixed to this drawing. Do not scale this drawing.
The information and material herein reflect the best judgement of BJC architects + assoc. inc. in light of the information available to them at the time of preparation of these documents. Any use which a third party makes of these documents, or any reliance on or decisions to be made based on them, is the sole responsibility of such third party. BJC architects + assoc. inc. accepts no responsibility for damages, if any, suffered by any third party as a result of decisions made or actions based on these documents © BJC architects + assoc. inc. 2025.



01	ISSUED FOR TENDER	2026.04.08
No.	REVISIONS	date
PROJECT NORTH		TRUE NORTH
scale:		AS NOTED

drawn	MV
last worked on	by 2026.03.18 MV
checked	B.R.J.
print date	2026.04.08



client	WATERLOO REGION DISTRICT SCHOOL BOARD
51 ARDELT AVE KITCHENER	ONTARIO
project	GRAND RIVER COLLEGIATE INSTITUTE RENOVATION
175 INDIAN RD KITCHENER	ONTARIO

drawing title	PARTIAL ROOF PLAN
reference	
project no.	25-092
client reference number	
sheet no.	A - 170 01

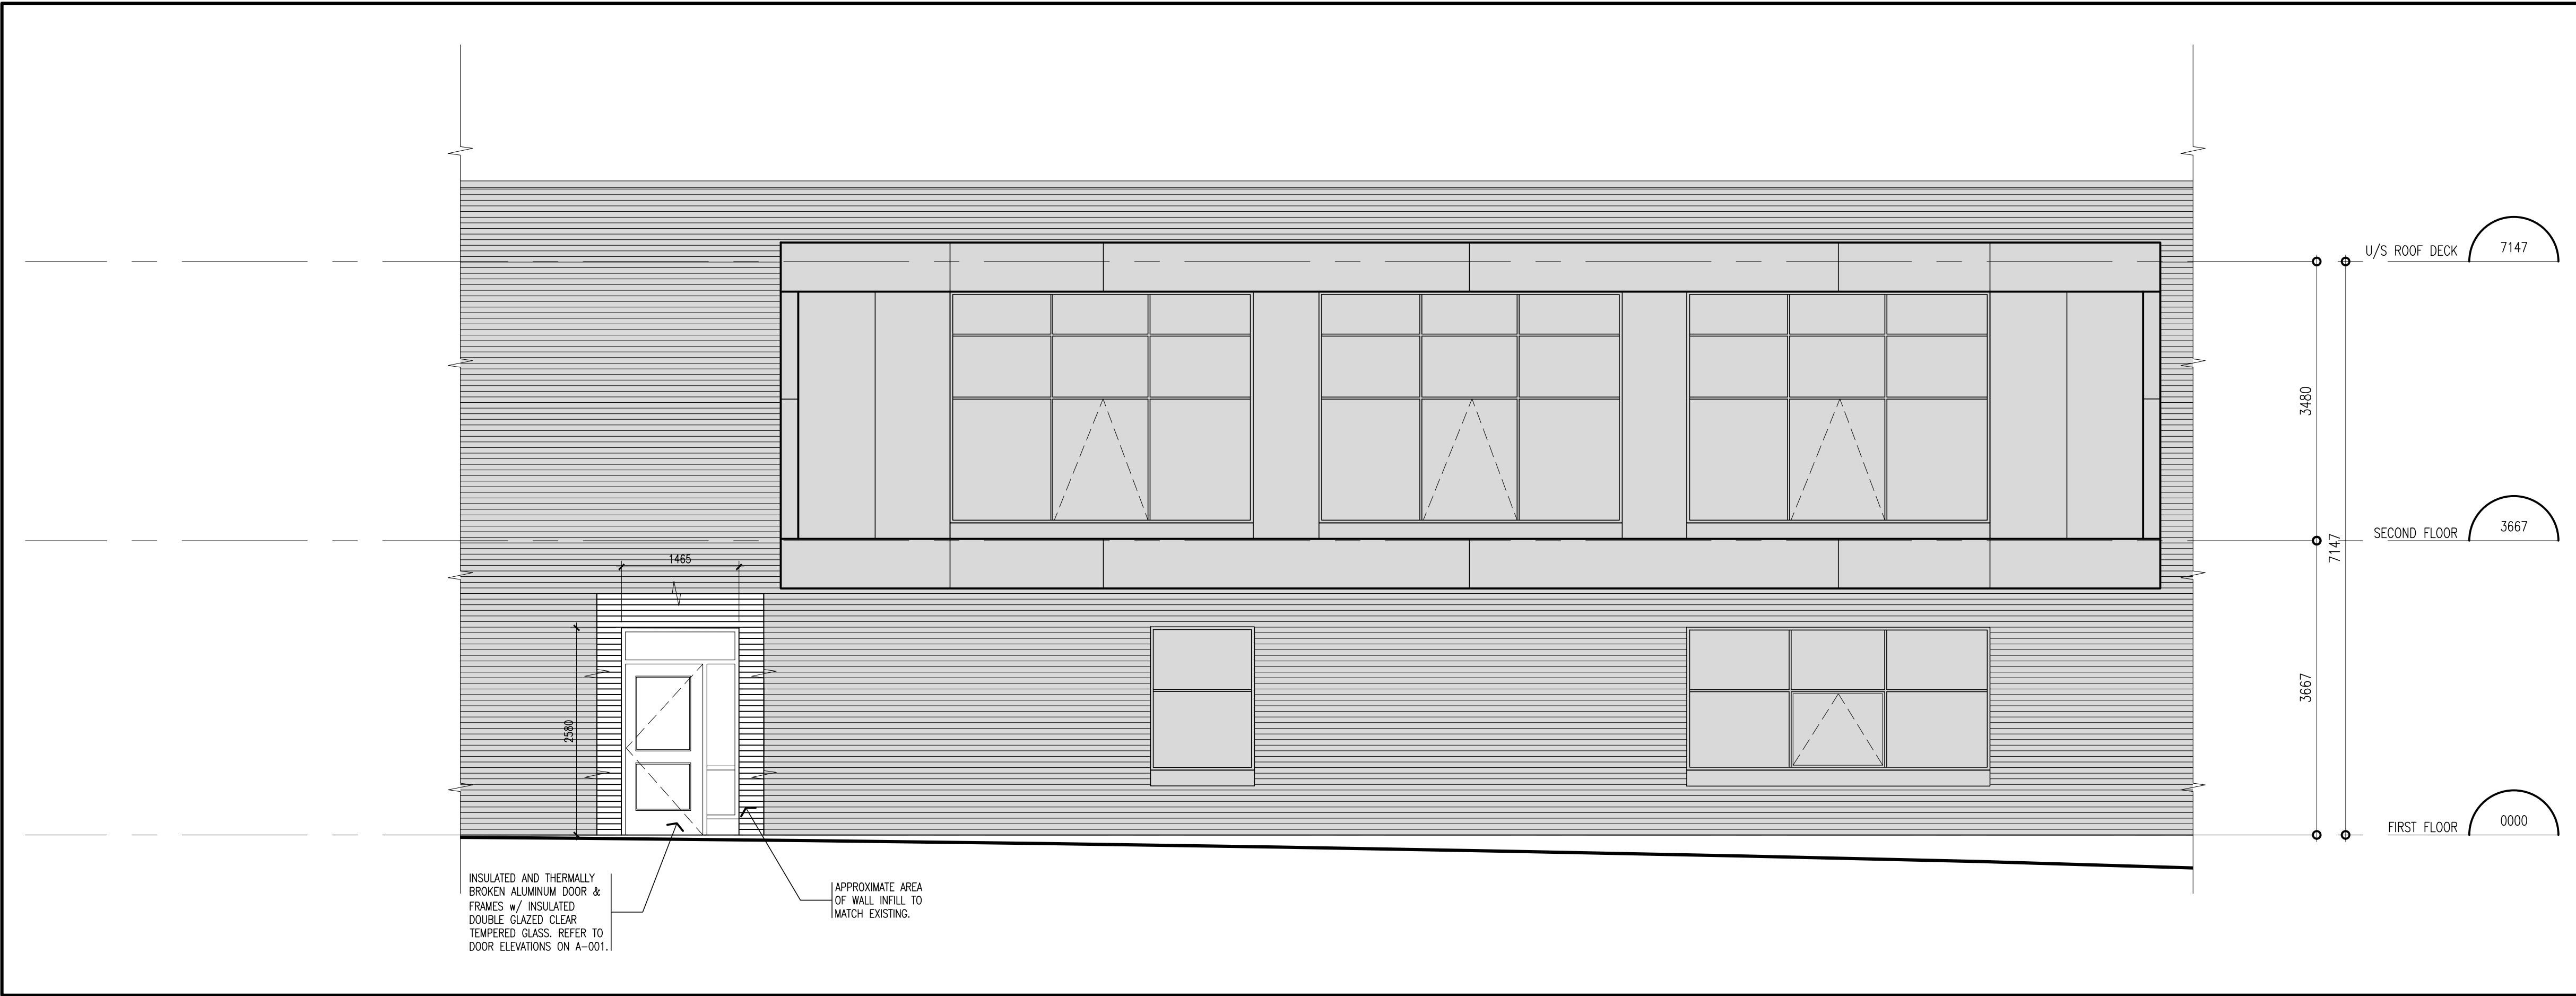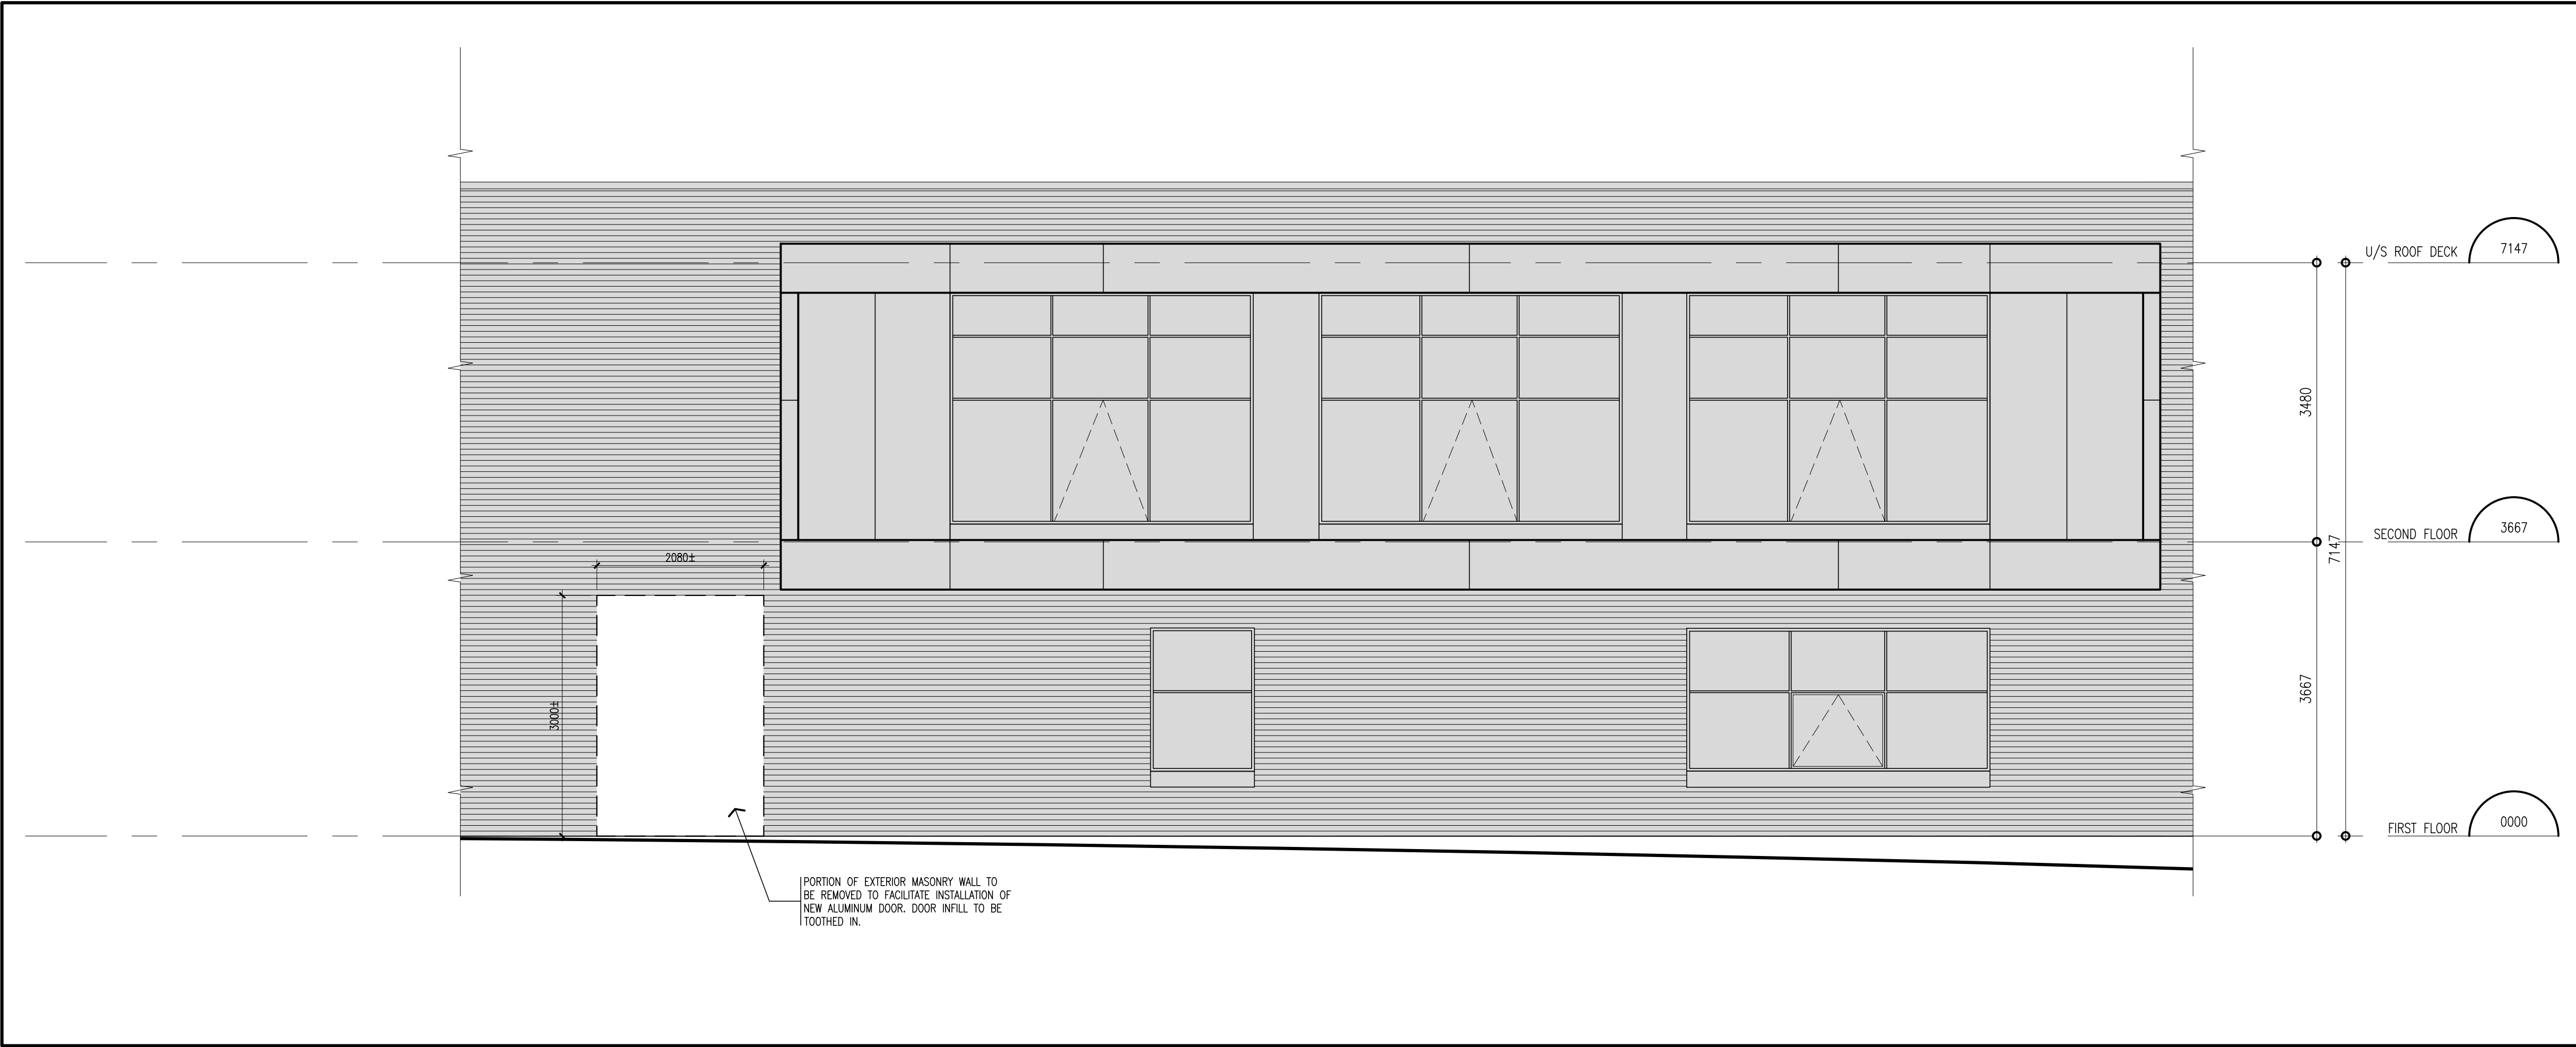

NOTE 1:

THESE DRAWINGS ARE PREPARED WITH THE USE OF LINE TYPES, HATCH PATTERNS, COLOURS, AND NUMERICALLY DESIGNATED NOTES. COLLECTIVELY THESE REPRESENT THE FULL SCOPE OF WORK, WITH THE INTENT TO PROVIDE CLARITY. NOT ALL ITEMS MAY BE INDIVIDUALLY NOTED. IF ANYTHING IS AMBIGUOUS THE GENERAL CONTRACTOR IS TO ASK FOR CLARIFICATION AT THE TIME OF TENDER. FAILURE TO DO SO WILL LEAVE THE INTERPRETATION OF THE DRAWINGS TO THE ARCHITECT. THIS NOTE APPLIES TO ALL DRAWINGS.

NOTE 2:

THIS DRAWING CONTAINS THE USE OF COLOUR TO BETTER ILLUSTRATE AND DESCRIBE THE INTENT OF THE DRAWING BY HIGHLIGHTING LINE TYPES, HATCH PATTERNS, TEXT, DIMENSIONS, OR TONES. IT IS MANDATORY THAT THIS DRAWING BE PRINTED IN COLOUR FOR ITS USE. FAILURE TO DO SO WILL NOT RESULT IN ANY COMPENSATION FOR COSTS OR TIME LOST BY THE GC OR HIS/HER SUBTRADE DUE TO OMISSIONS, ERRORS, OR MISUNDERSTANDING OF THE FULL SCOPE OF THE WORK.


LEGEND

- APPROXIMATE AREA NOT IN CONTRACT SCOPE.
- EXISTING BRICK.
- NEW BRICK INFILL TO MATCH EXISTING.



NOTE:
This drawing and all associated documentation are the confidential property of BJC architects + assocs. inc. and must be returned upon request. Any duplication, reuse, revision and/or distribution in part or whole without the prior written authorization of BJC architects + assocs. inc. is strictly prohibited. Each contractor will check and verify all dimensions and report all errors and omissions to the design professional whose seal is affixed to this drawing. Do not scale this drawing.
The information and material herein reflect the best judgement of BJC architects + assocs. inc. in light of the information available to them at the time of preparation of these documents. Any use which a third party makes of these documents, or any reliance on or decisions to be made based on them, is the sole responsibility of such third party. BJC architects + assocs. inc. accepts no responsibility for damages, if any, suffered by any third party as a result of decisions made or actions based on these documents © BJC architects + assocs. inc. 2025.

01	ISSUED FOR TENDER	2026.04.08
No.	REVISIONS	date

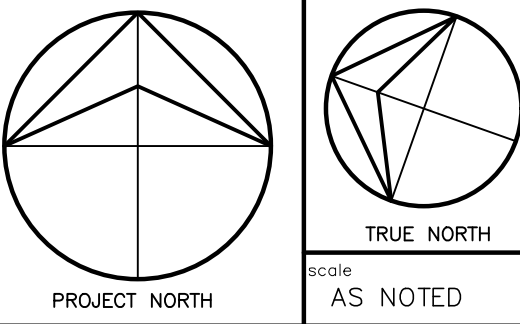

drawn	VA
last worked on by	by 2026.04.08 MV
checked	B.R.J.
print date	2026.04.08




client	WATERLOO REGION DISTRICT SCHOOL BOARD
51 ARDELT AVE KITCHENER	ONTARIO
project	GRAND RIVER COLLEGIATE INSTITUTE RENOVATION
175 INDIAN RD KITCHENER	ONTARIO

drawing title
EXTERIOR ELEVATIONS DEMOLITION & RENO

reference	
project no.	25-092
client reference number	
sheet no.	

A - 200 01

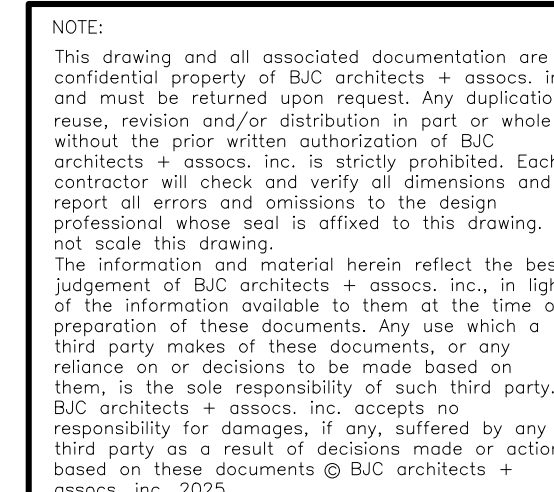

01	ISSUED FOR TENDER	2004
No.	EMBEDMENT REVISIONS	d


scale
1:20

	drawn	
	MV	
	last worked on	by
	2026.04.08	C
	checked	
	B.R.J.	
	print date	
	2026.04.02	




client	WATERLOO REGION DISTRICT SCHOOL BOARD	
51 ARDELT AVE KITCHENER		ONTARIO
project	GRAND RIVER COLLEGIATE INSTITUTE RENOVATION	
175 INDIAN RD KITCHENER		ONTARIO


drawing title	
WALL SECTIONS & SECTION DETAILS	
reference	
project no. 25-092	client reference number
sheet no.	
A - 3 0 0 0	

 


1 RESERVED

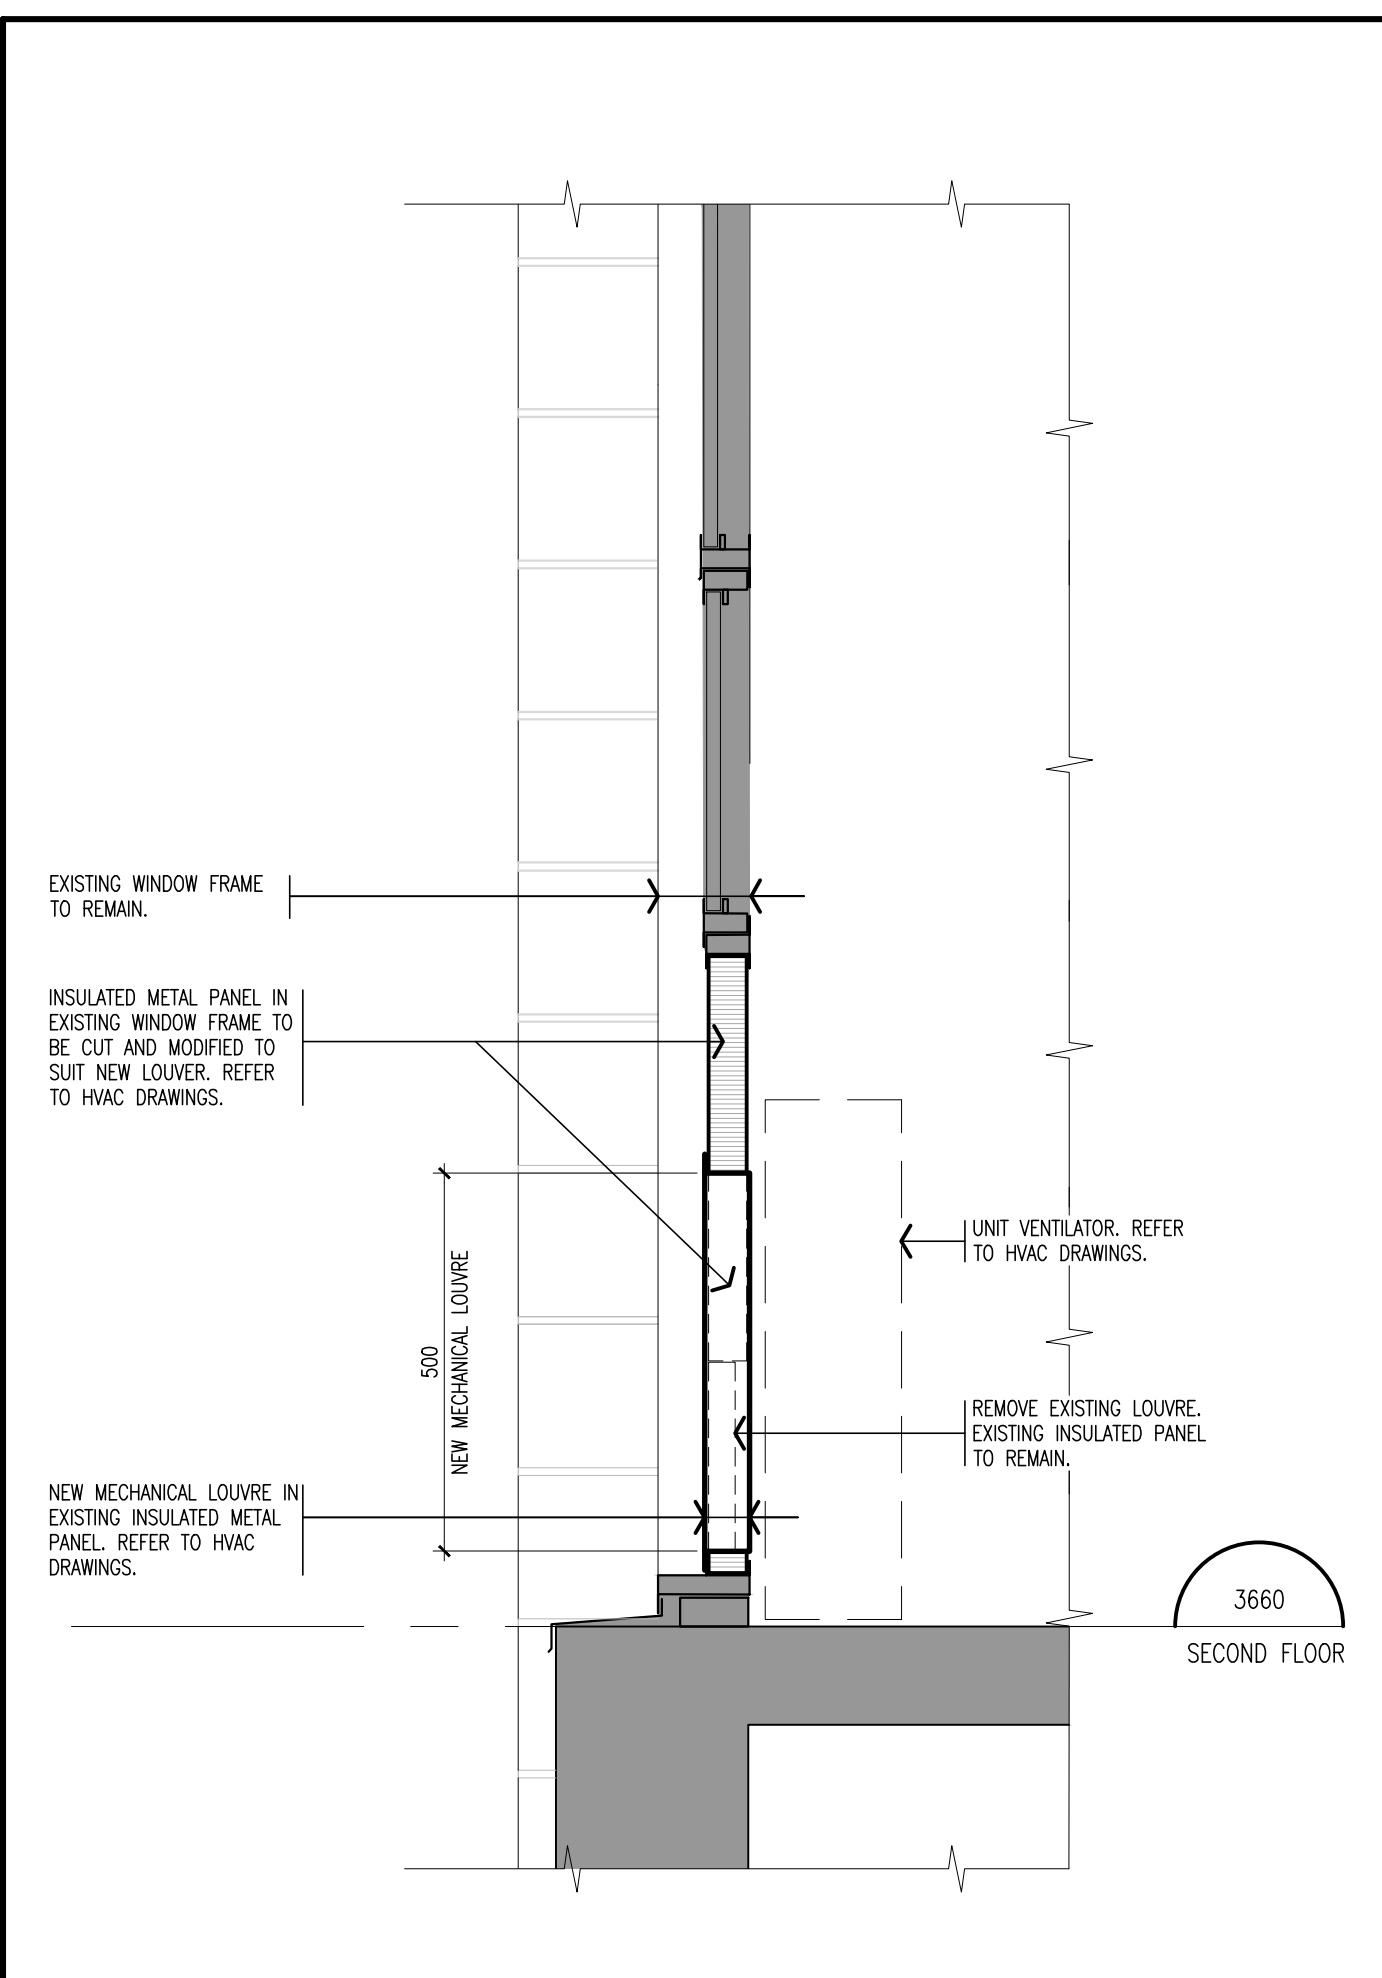


2 SECTION DETAIL AT NEW LOUVRE

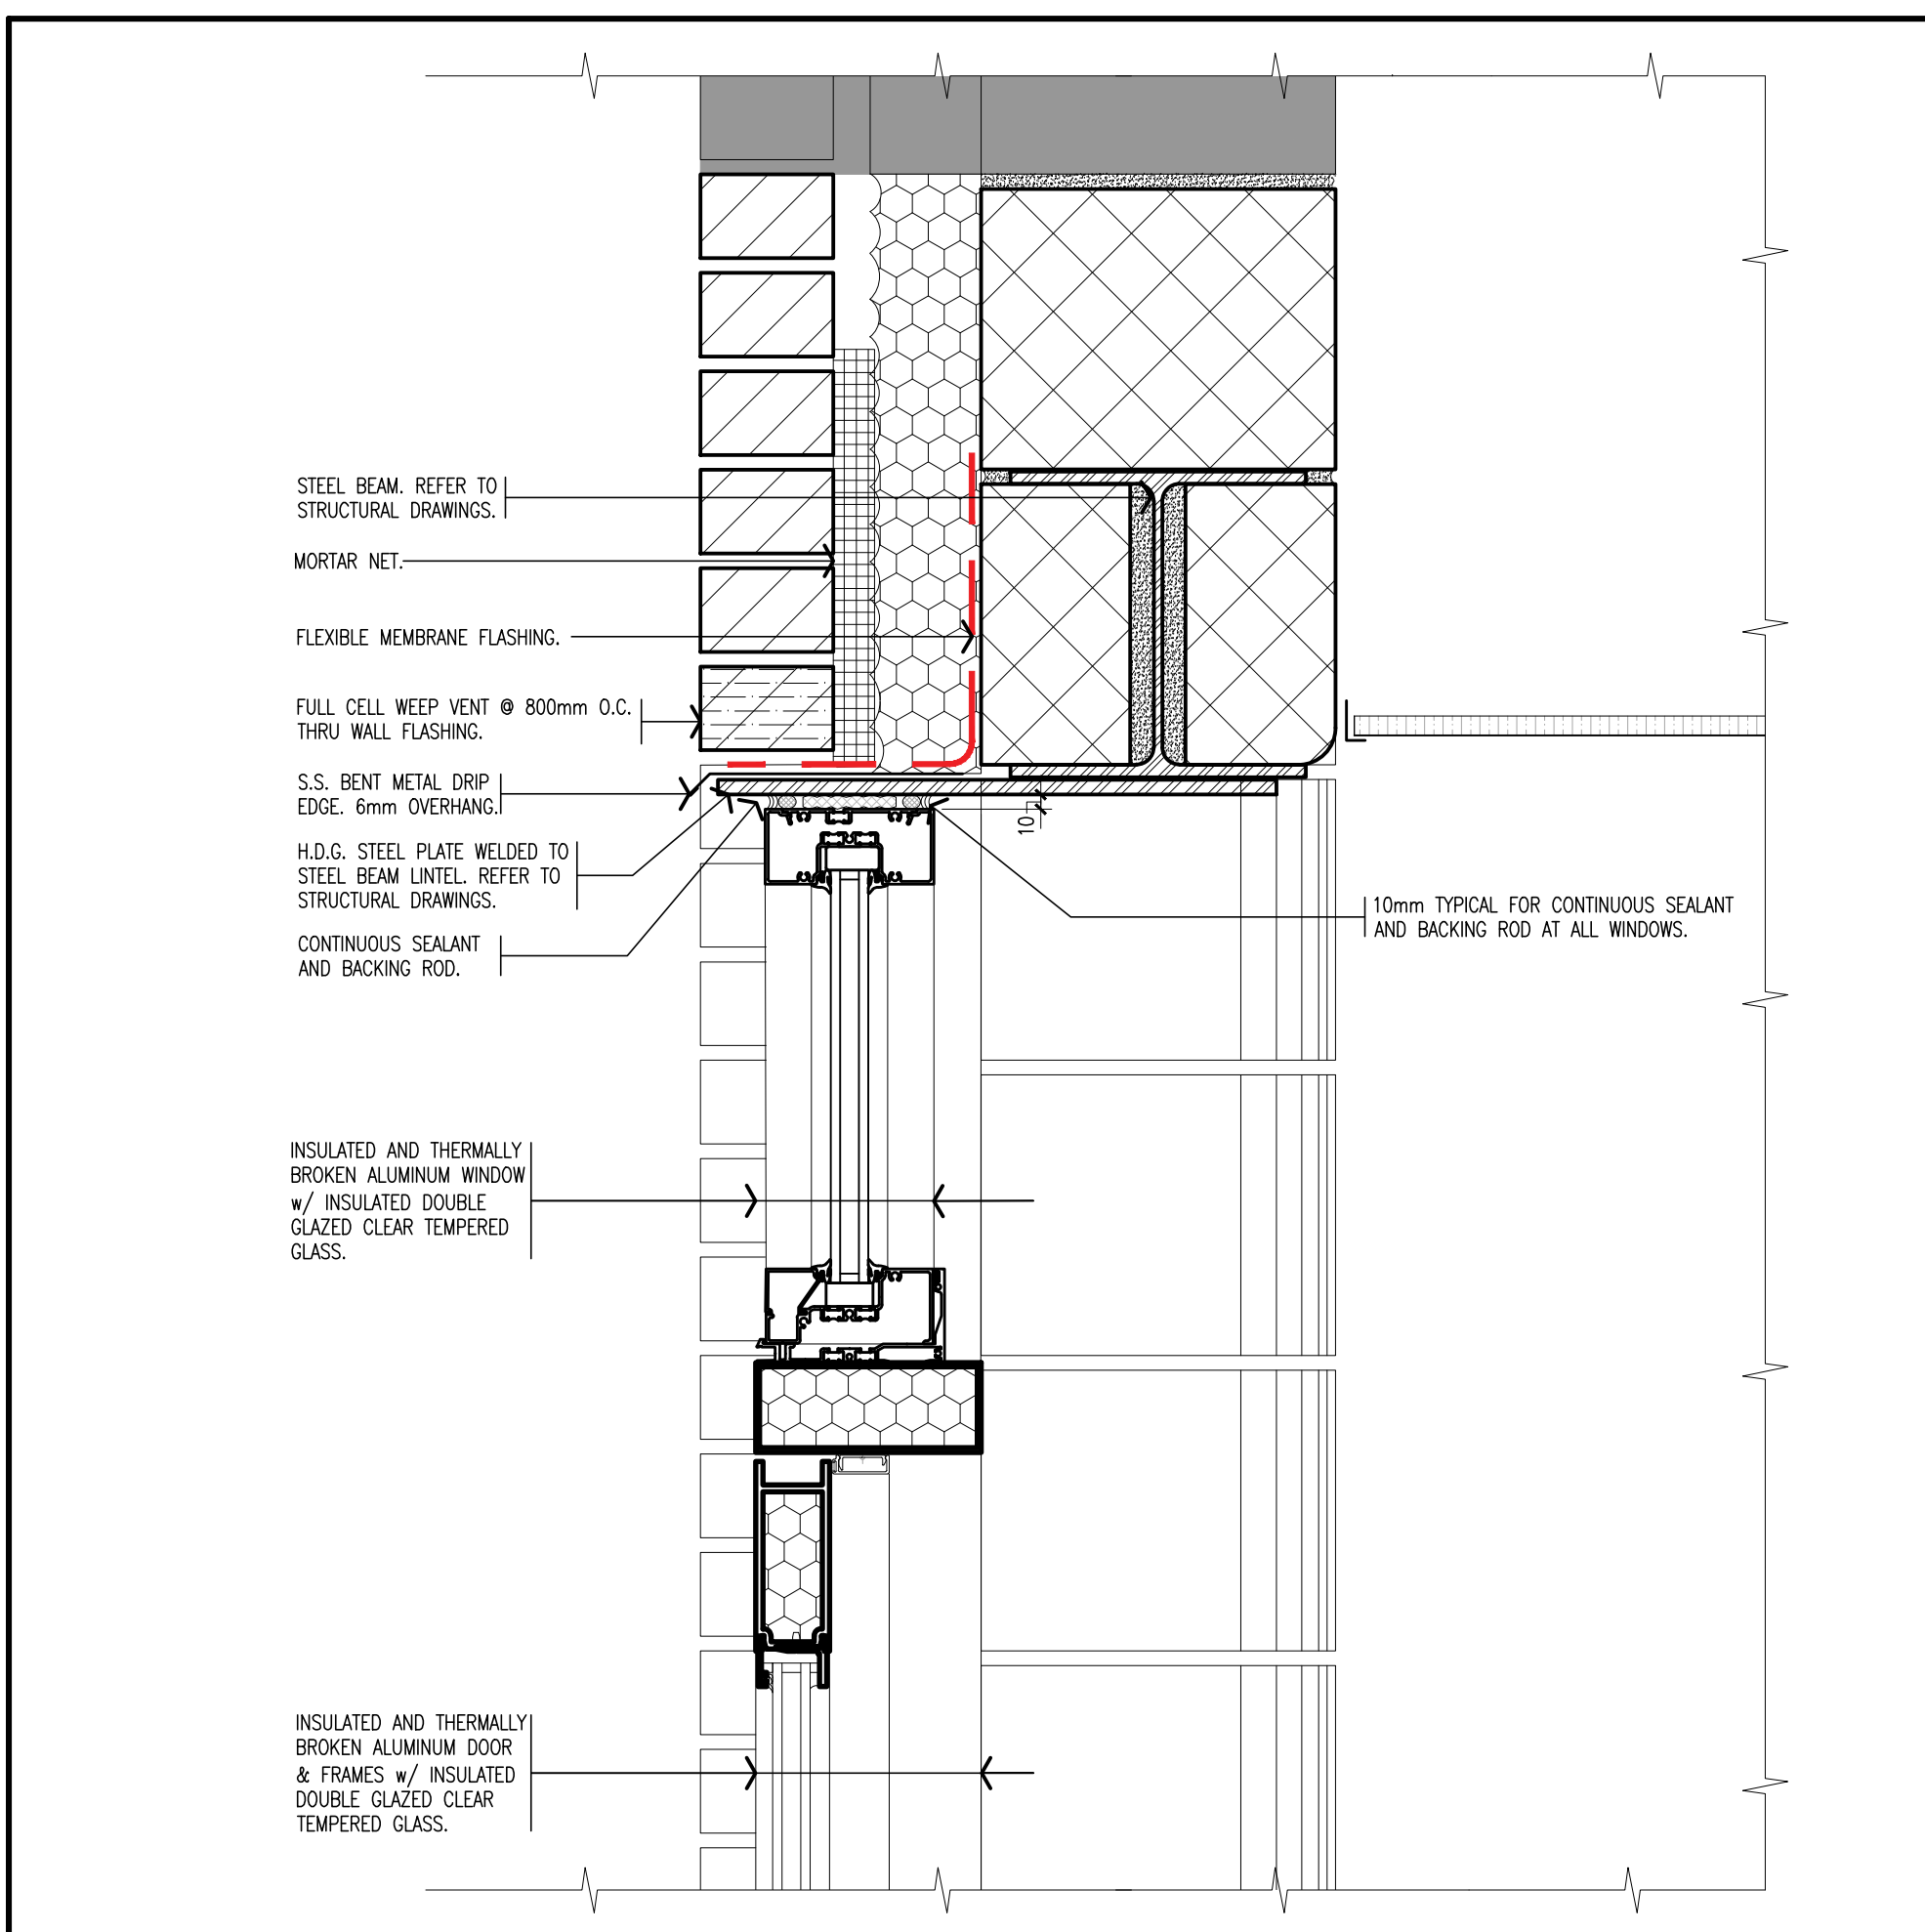


3 SECTION DETAIL AT
EXTERIOR DOOR scale: 1 : 5

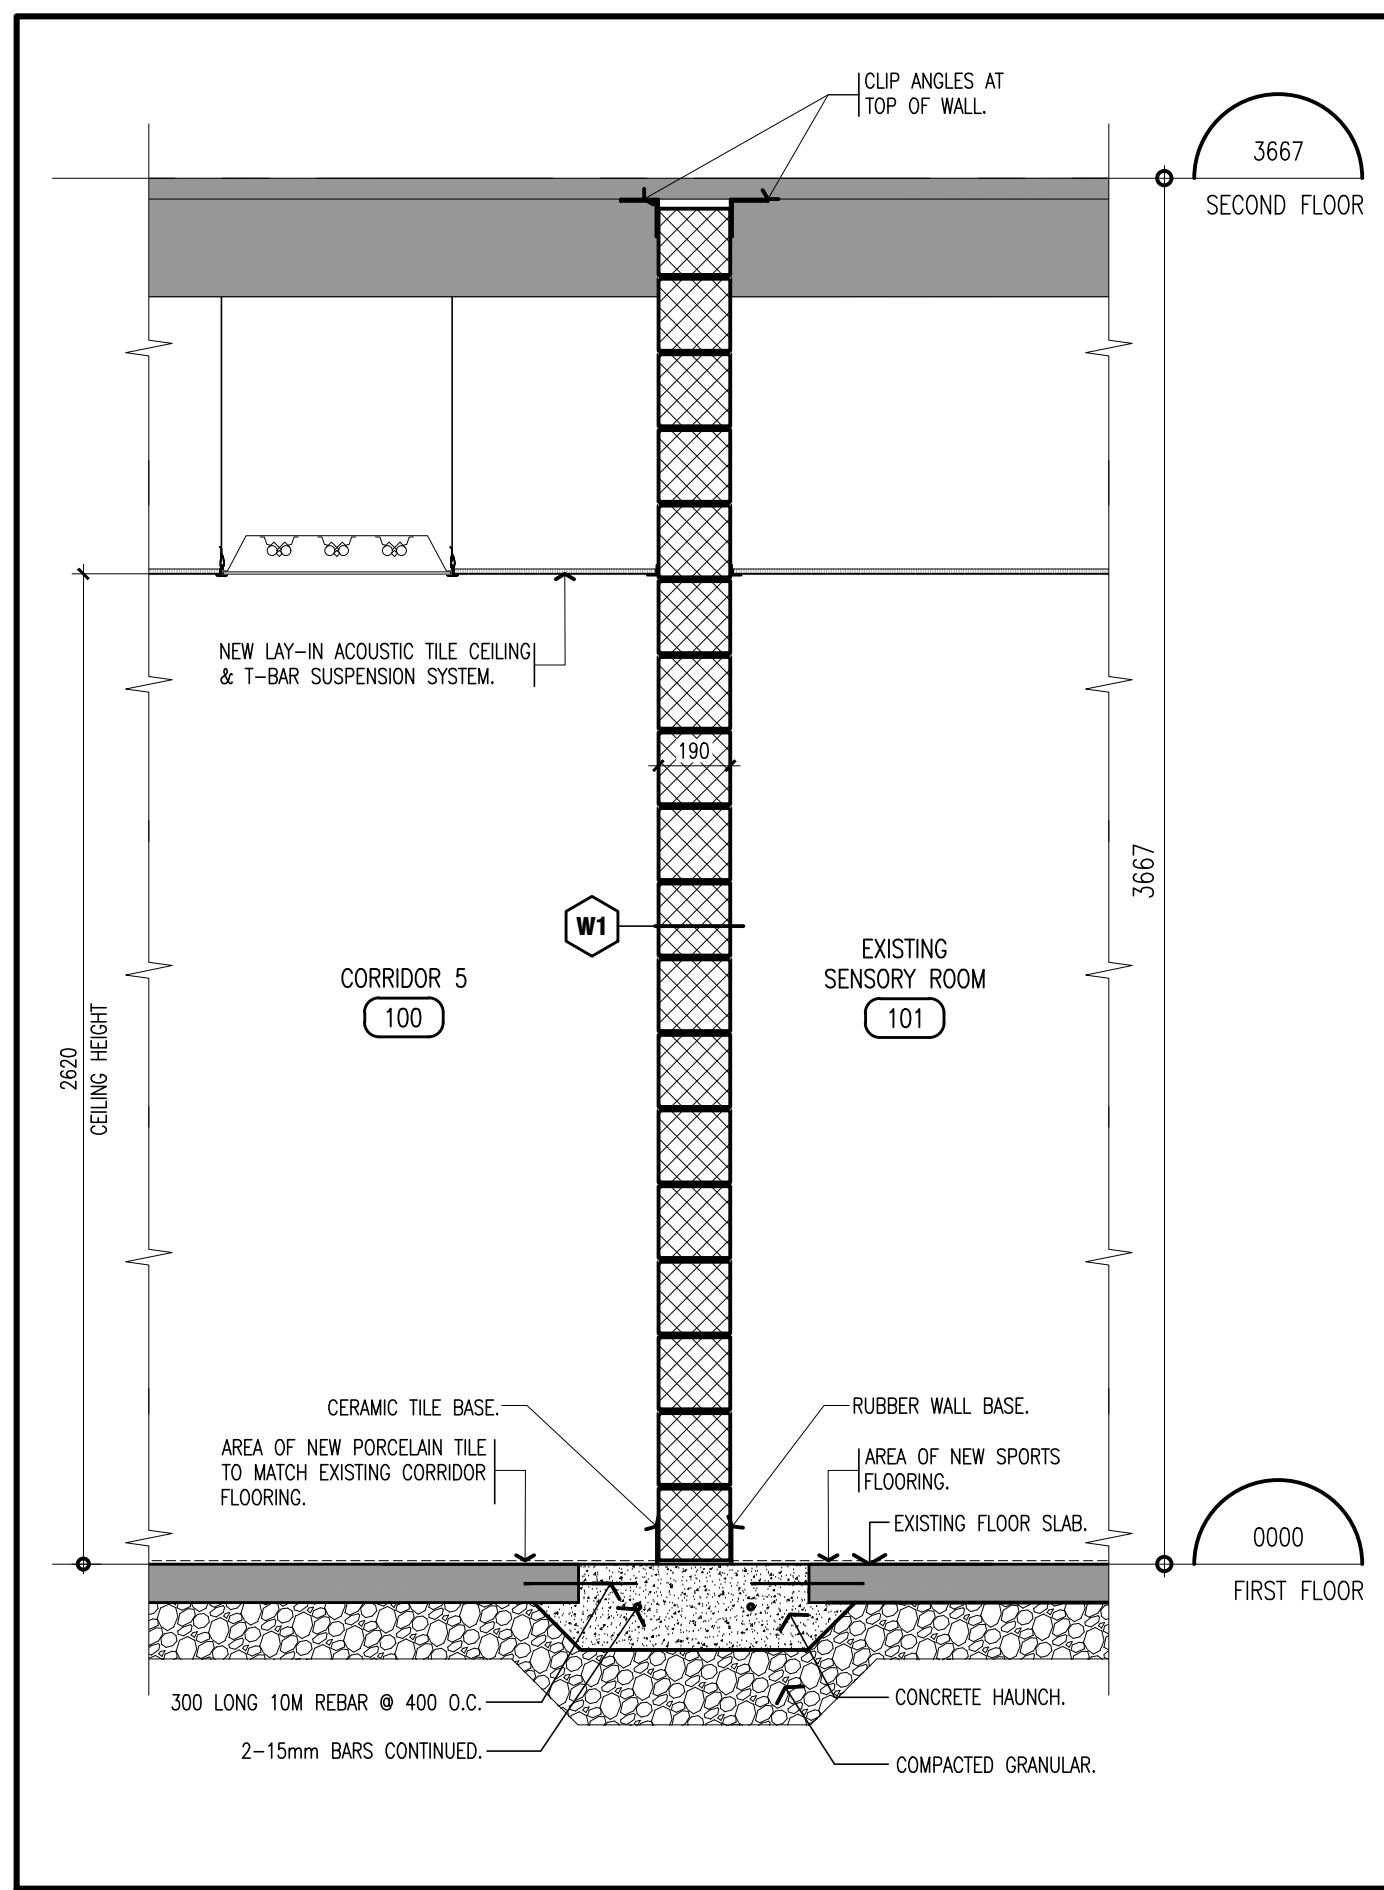


4 WALL SECTION THRU INTERIOR WALL
BETWEEN CORRIOR 5 & SENSORY ROOM scale: 1 : 20

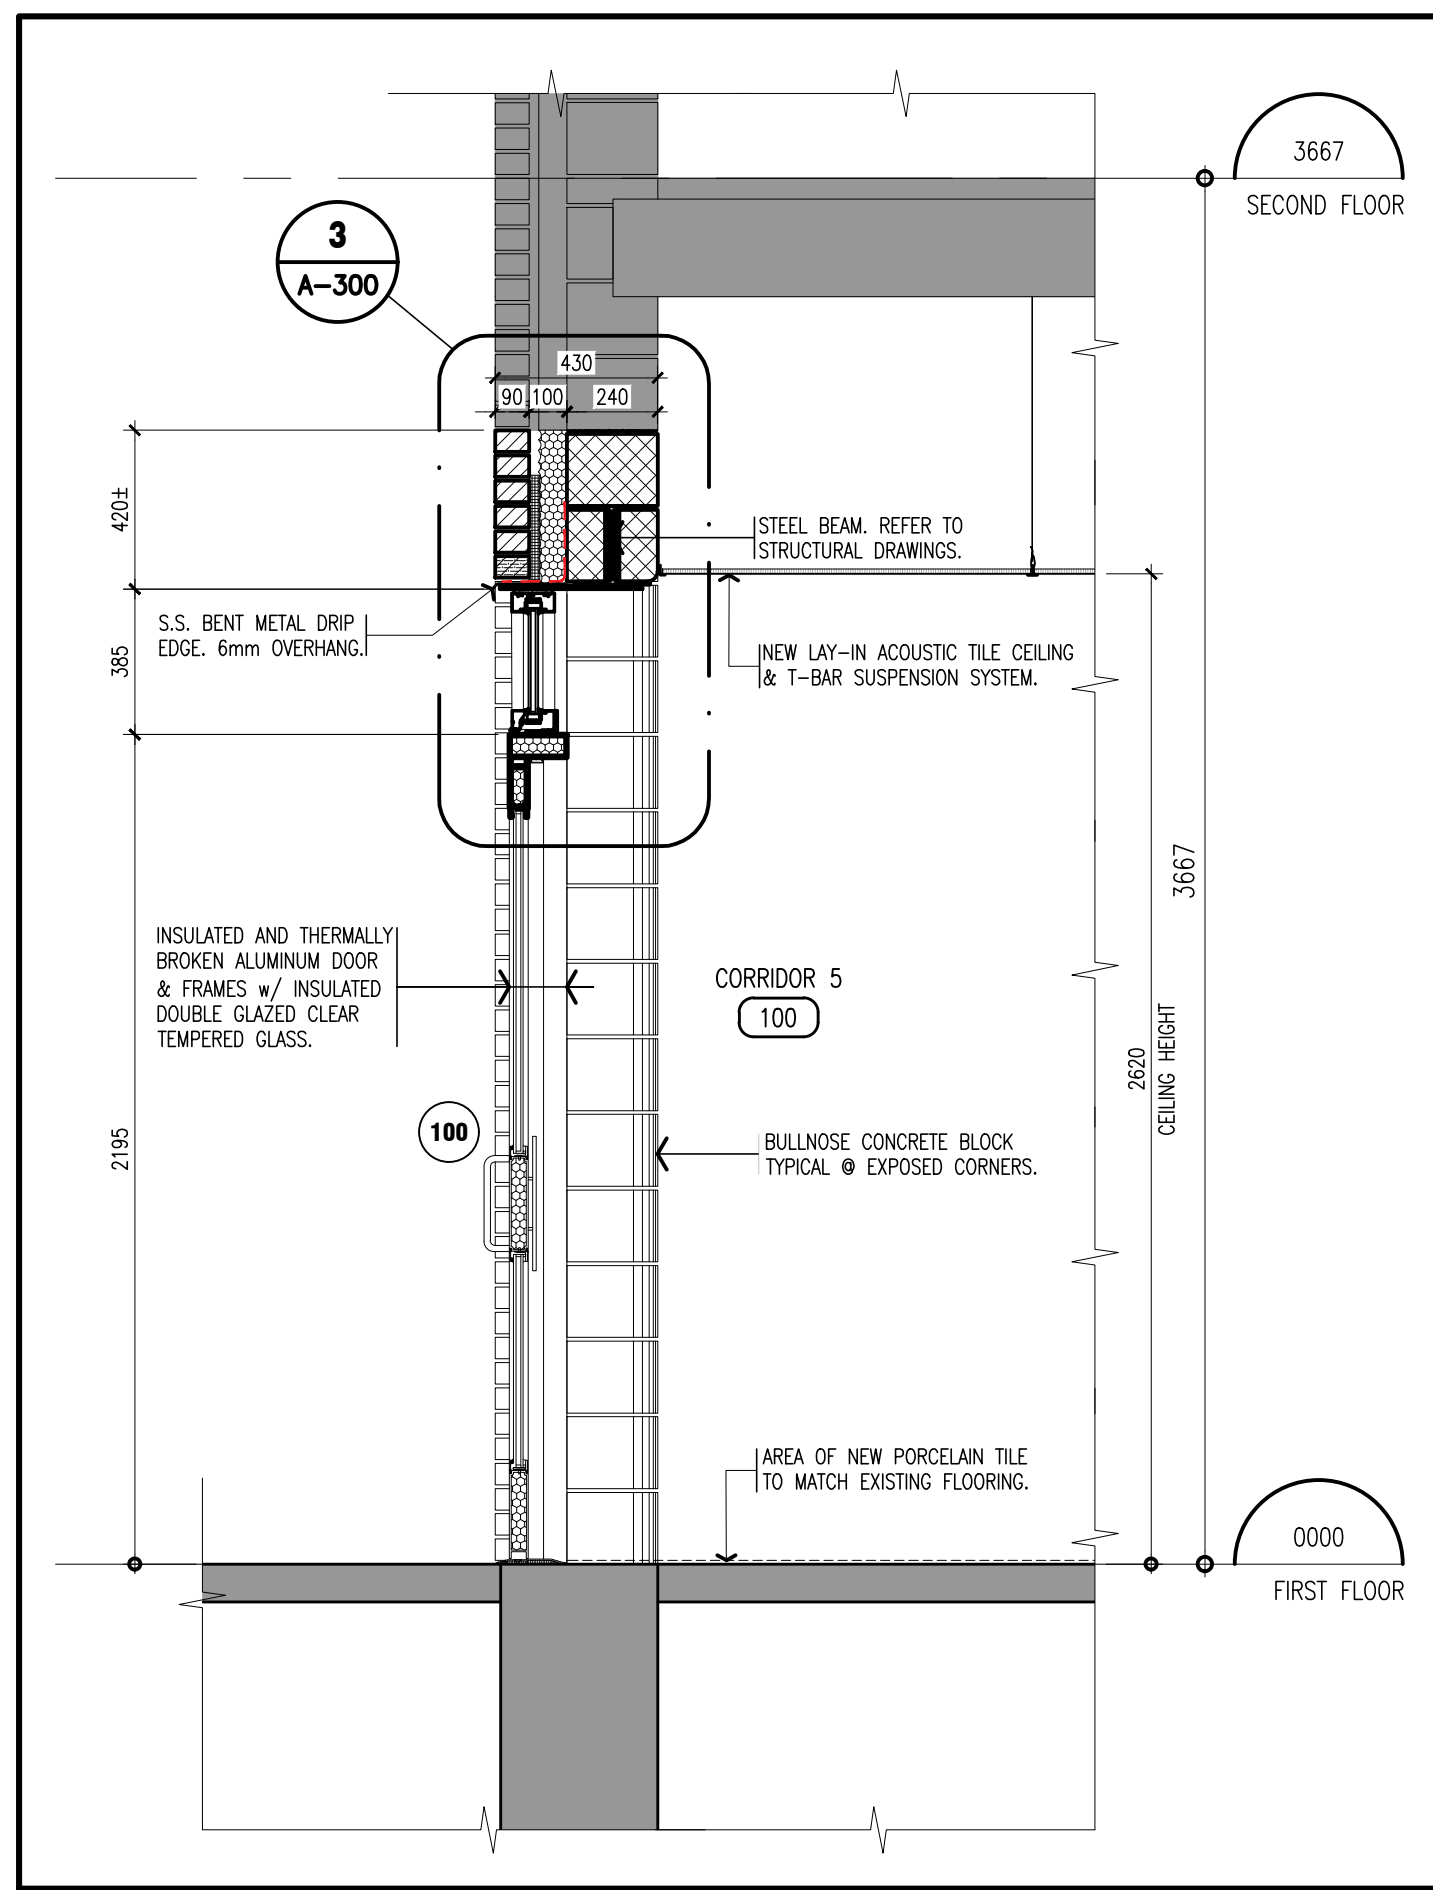

5 WALL SECTION THRU ALUMINUM DOOR

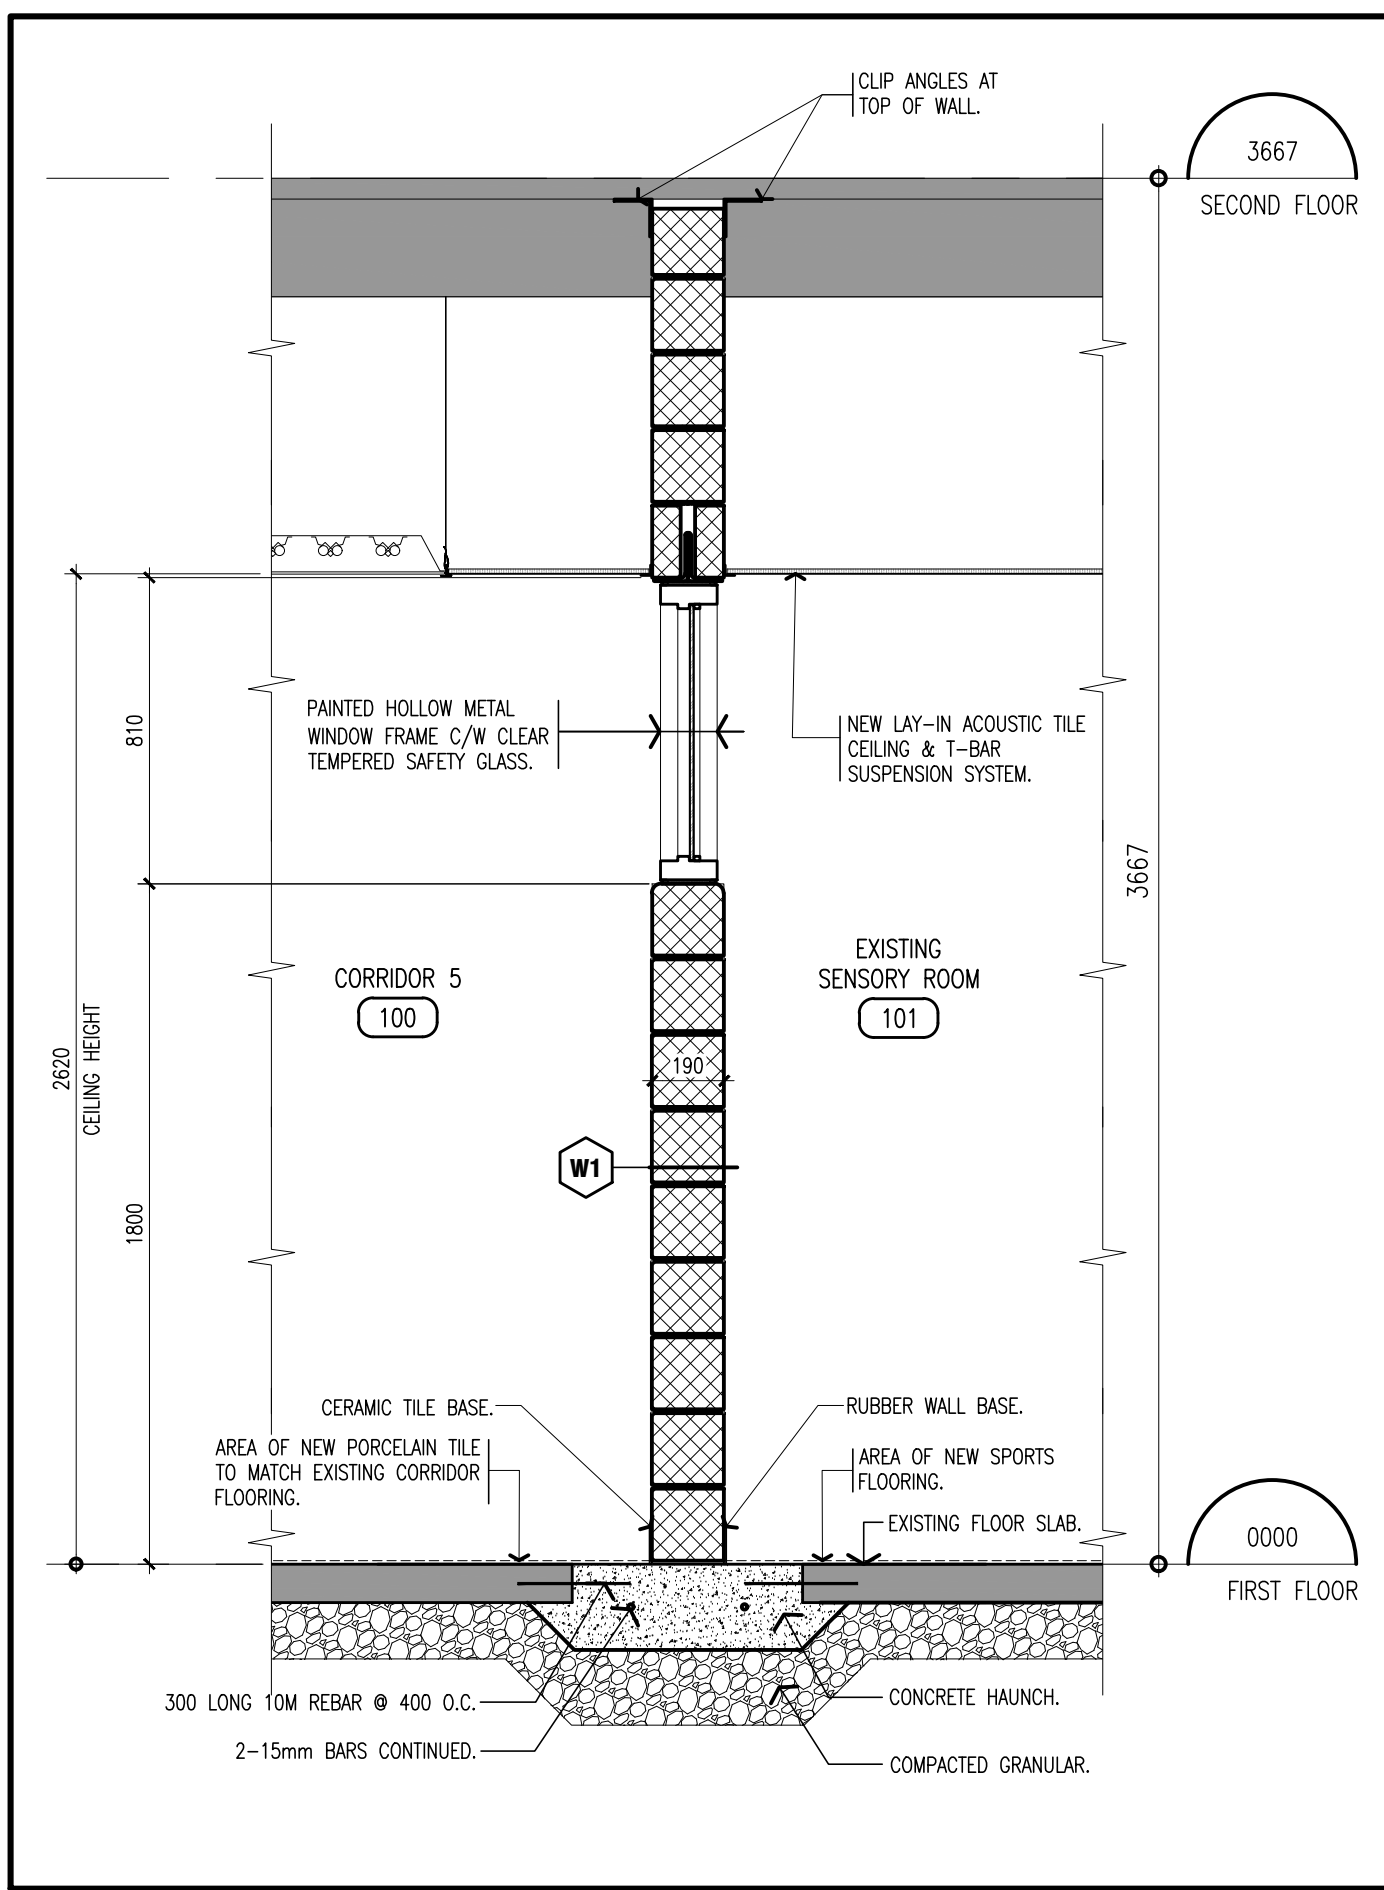


6 WALL SECTION THRU CLERESTORY GLAZING
BETWEEN CORRIOR 5 & SENSORY ROOM scale: 1 : 20

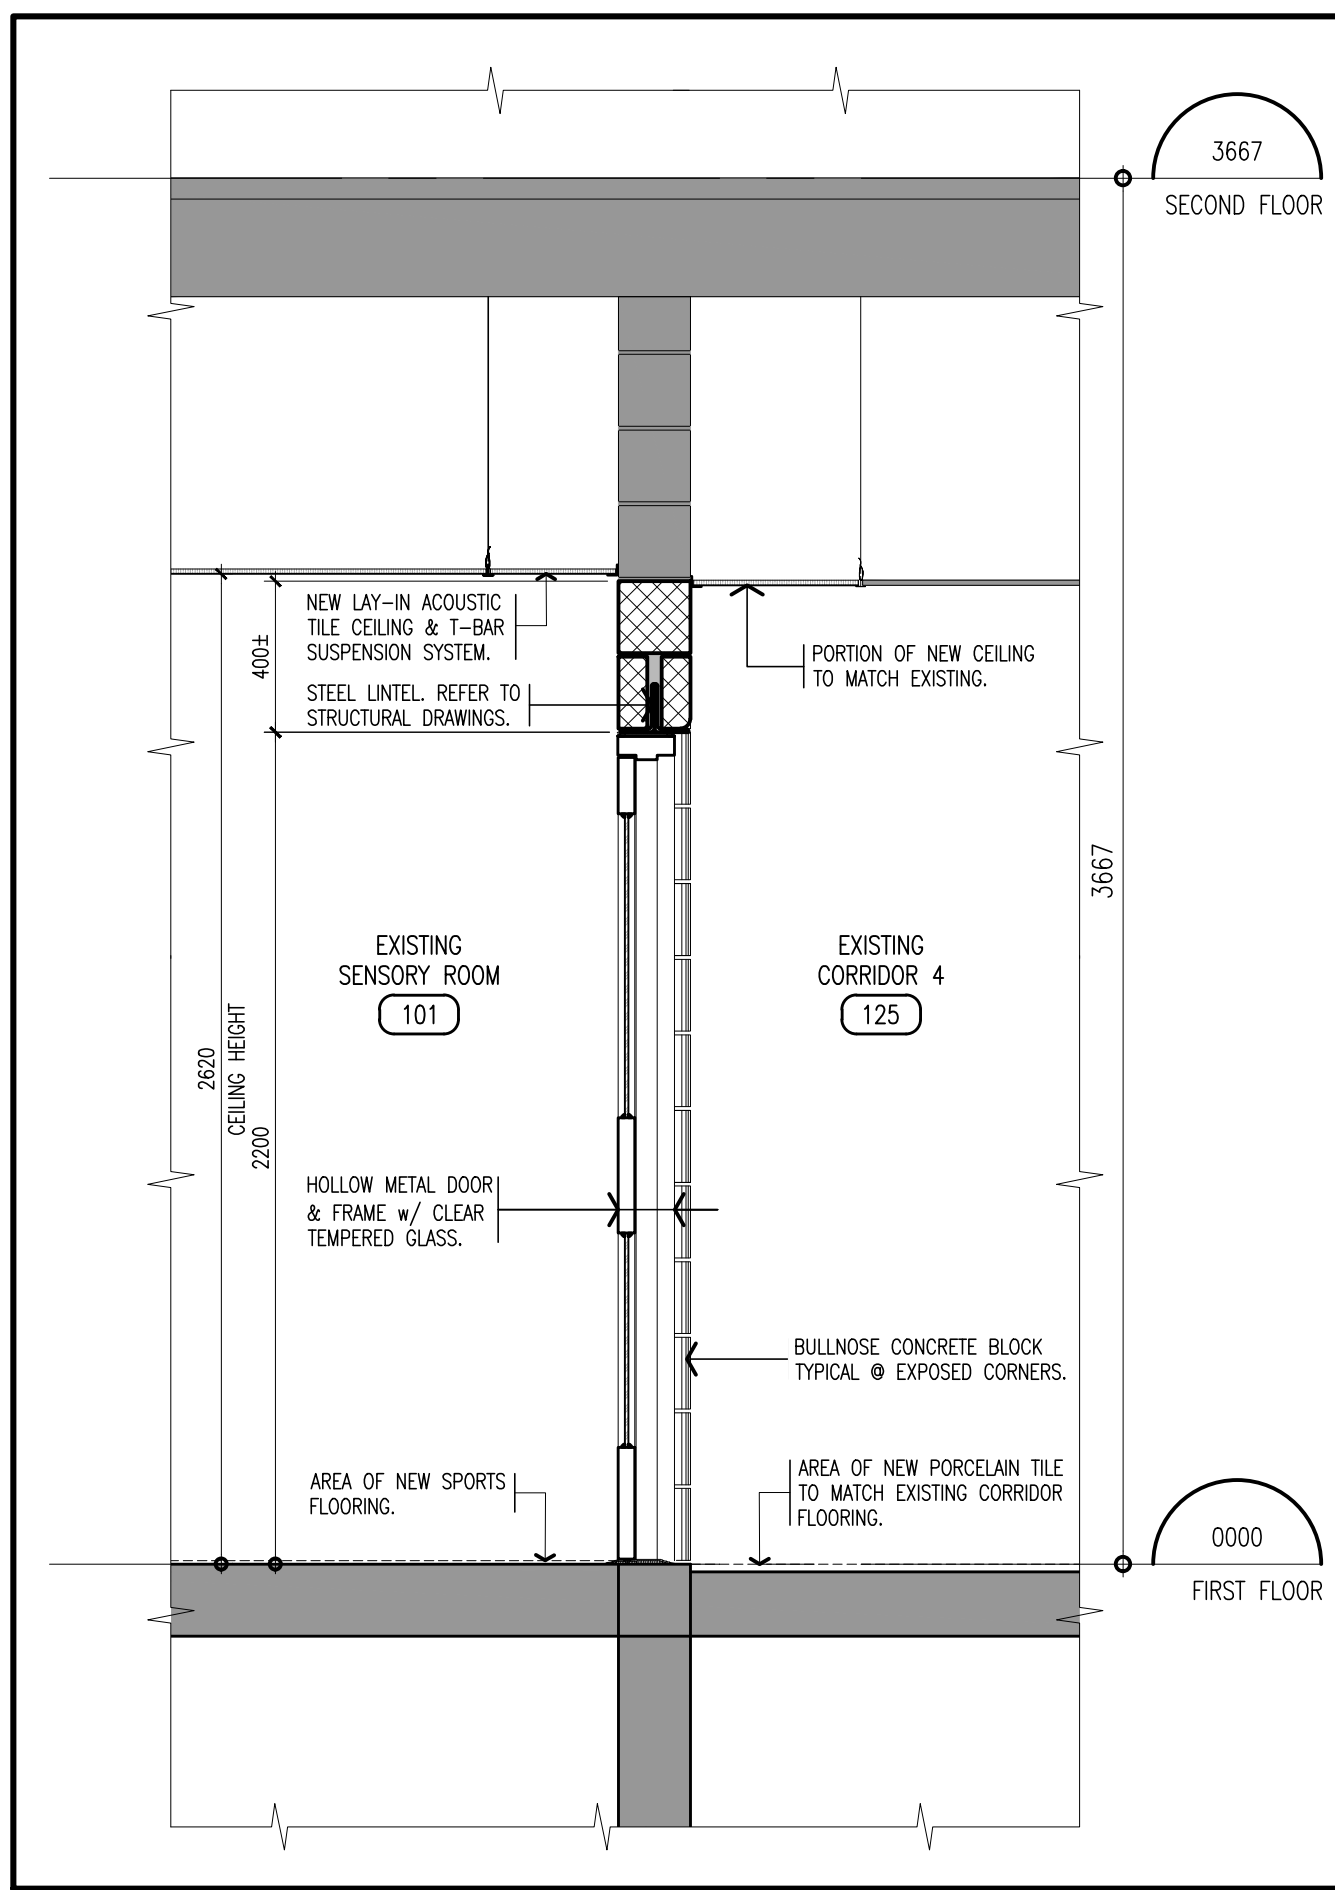

7 WALL SECTION THRU INTERIOR WALL
BETWEEN SENSORY ROOM & CORRIDOR 4 scale: 1 : 20

NOTE:
This drawing and all associated documentation are the confidential property of BJC architects + assocs. inc. and must be returned upon request. Any duplication, reuse, revision and/or distribution in part or whole without the prior written authorization of BJC architects + assocs. inc. is strictly prohibited. Each contractor will check and verify all dimensions and report all errors and omissions to the design professional whose seal is affixed to this drawing. Do not scale this drawing.
The information and material herein reflect the best judgement of BJC architects + assocs. inc. in light of the information available to them at the time of preparation of these documents. Any use which a third party makes of these documents, or any reliance on or decisions to be made based on them, is the sole responsibility of such third party. BJC architects + assocs. inc. accepts no responsibility for damages, if any, suffered by any third party as a result of decisions made or actions based on these documents © BJC architects + assocs. inc. 2025.

01	ISSUED FOR TENDER	2026.04.08
No.	REVISIONS	date

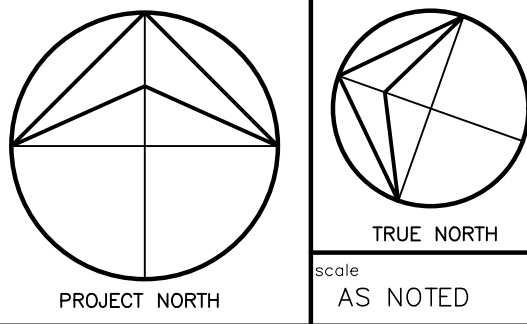

drawn MV	last worked on by 2026.04.08 MV
checked B.R.J.	print date 2026.04.08



client
WATERLOO REGION
DISTRICT SCHOOL
BOARD


51 ARDELT AVE
KITCHENER ONTARIO

project
GRAND RIVER COLLEGIATE
INSTITUTE RENOVATION


175 INDIAN RD
KITCHENER ONTARIO

drawing title
SECOND FLOOR
INTERIOR
ELEVATIONS


reference	project no. 25-092	client reference number
sheet no.	A - 500 01	

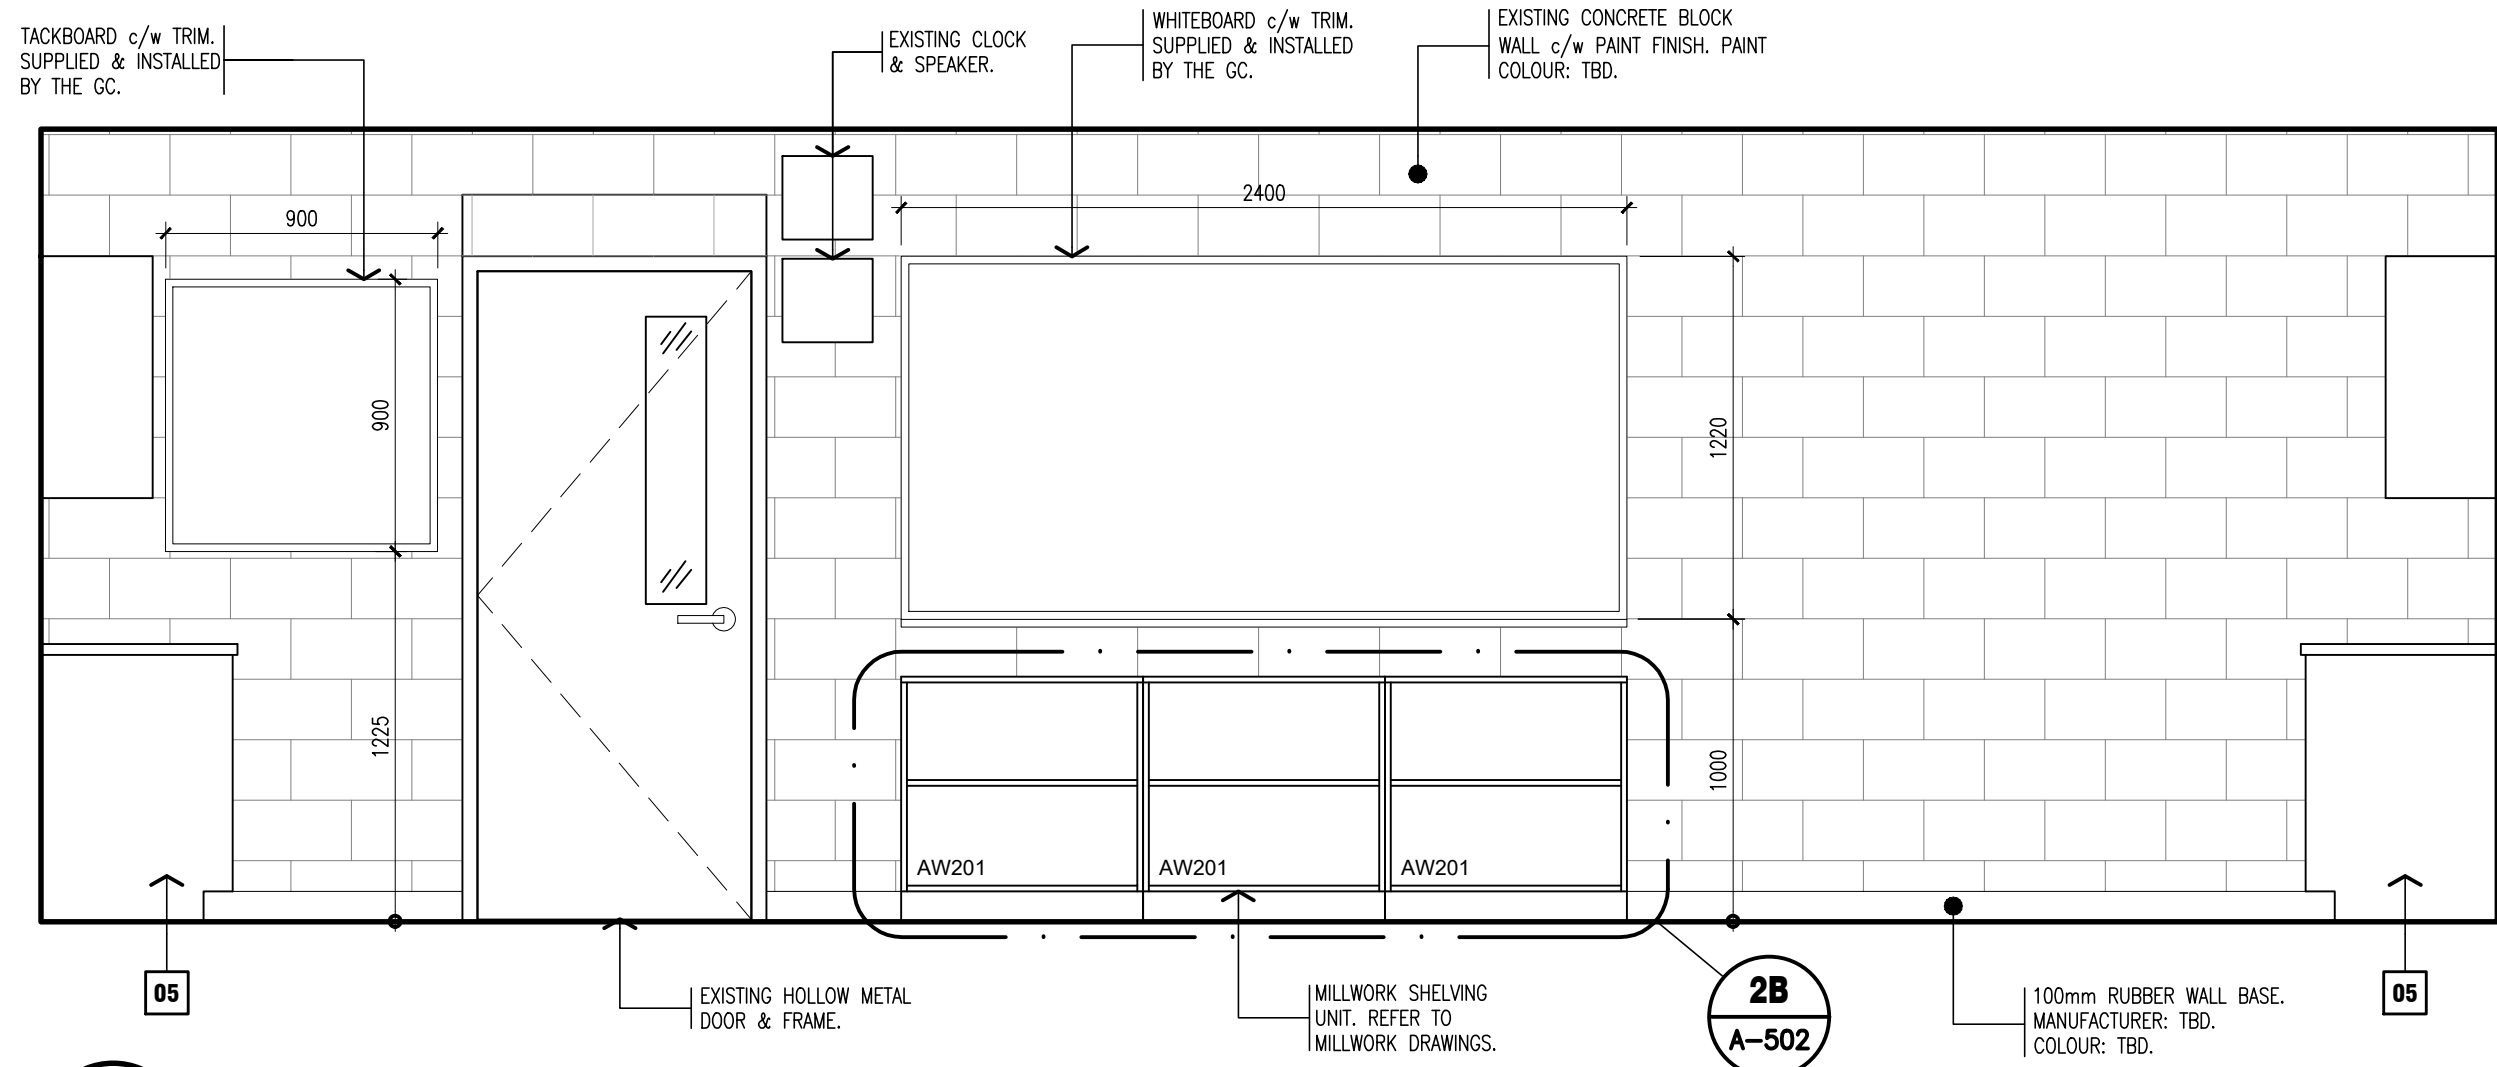


A NORTH ELEVATION

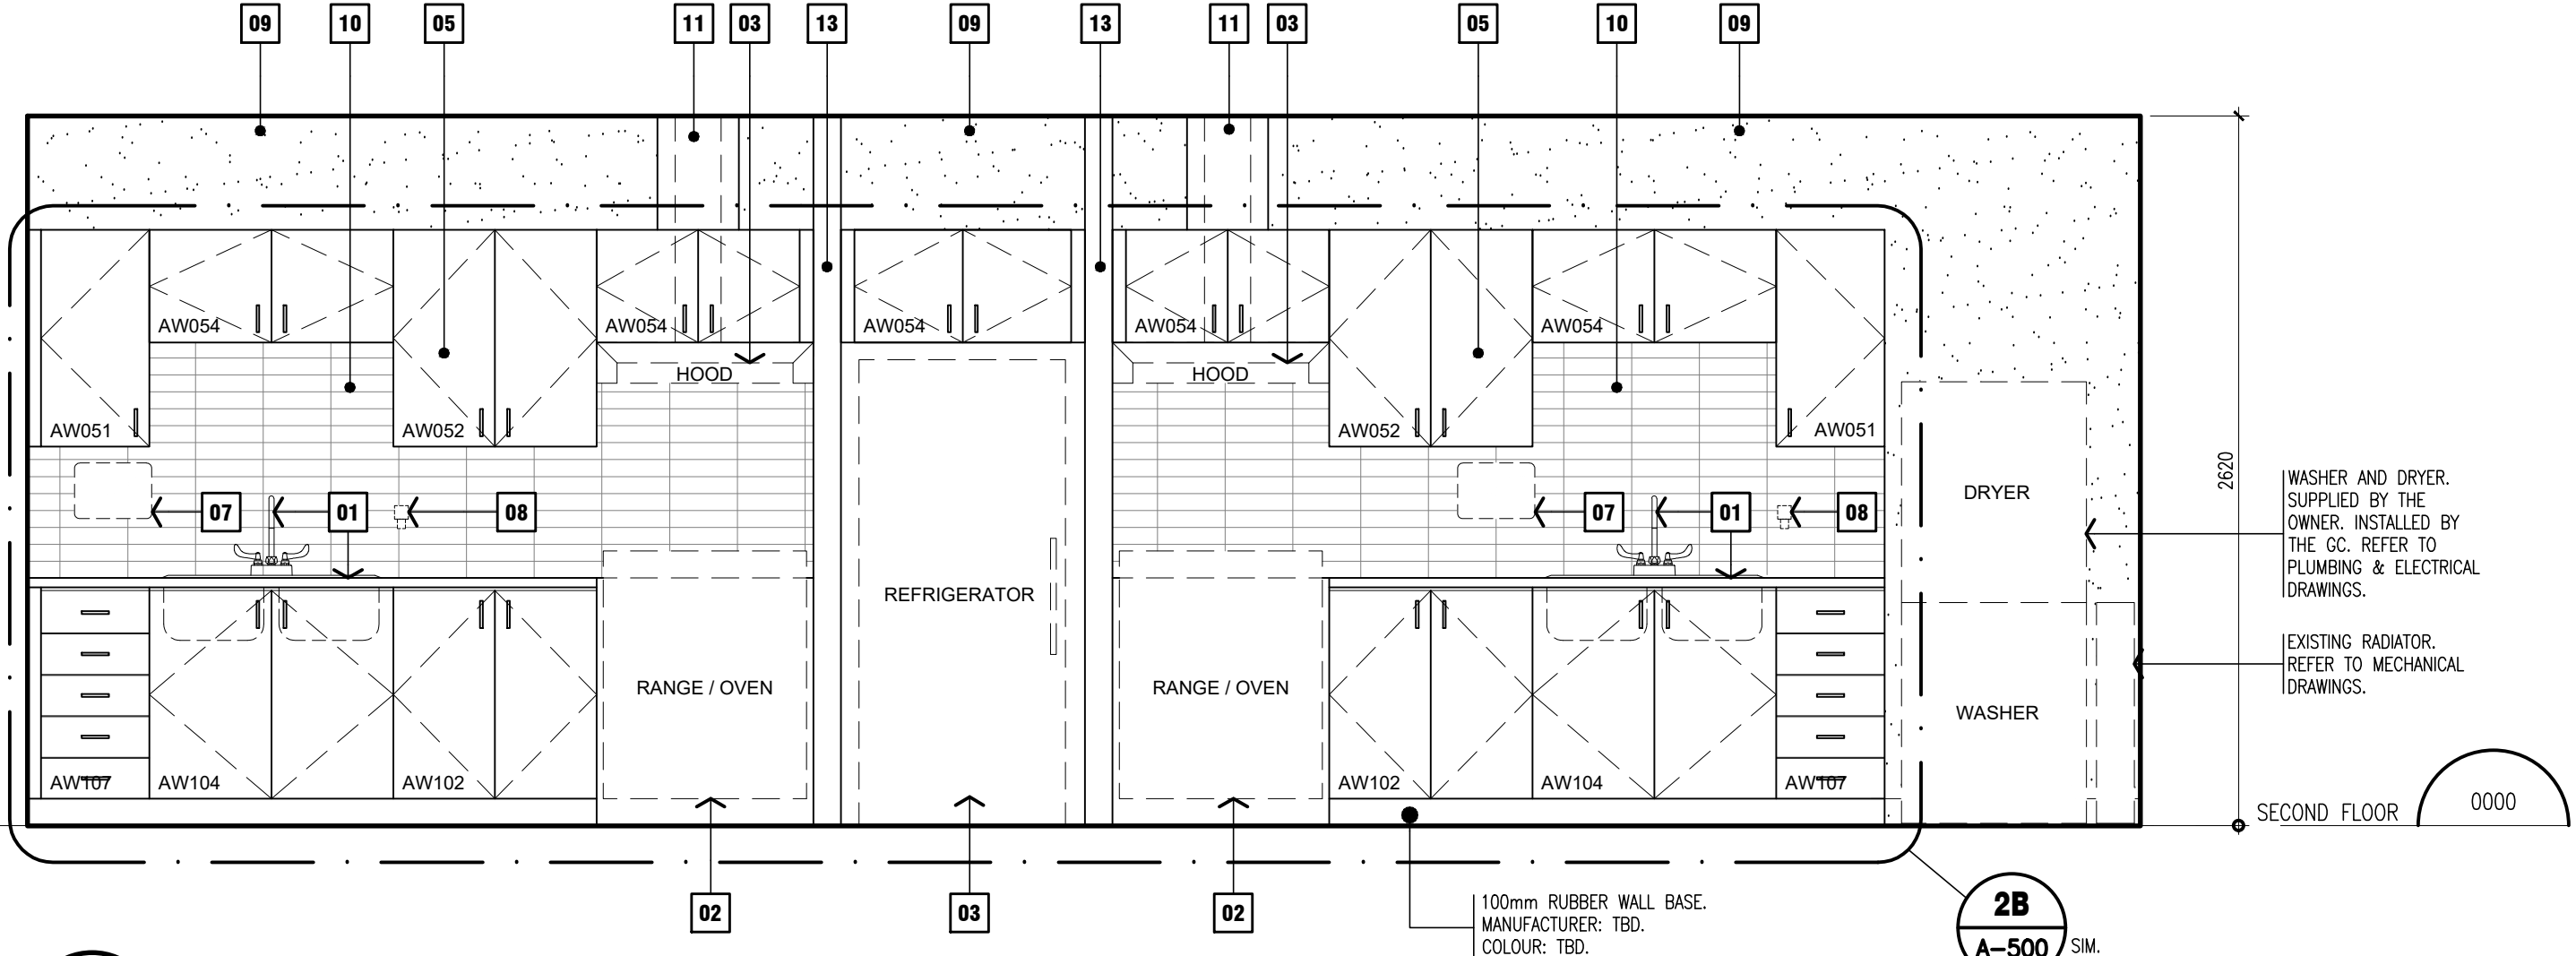

B EAST ELEVATION

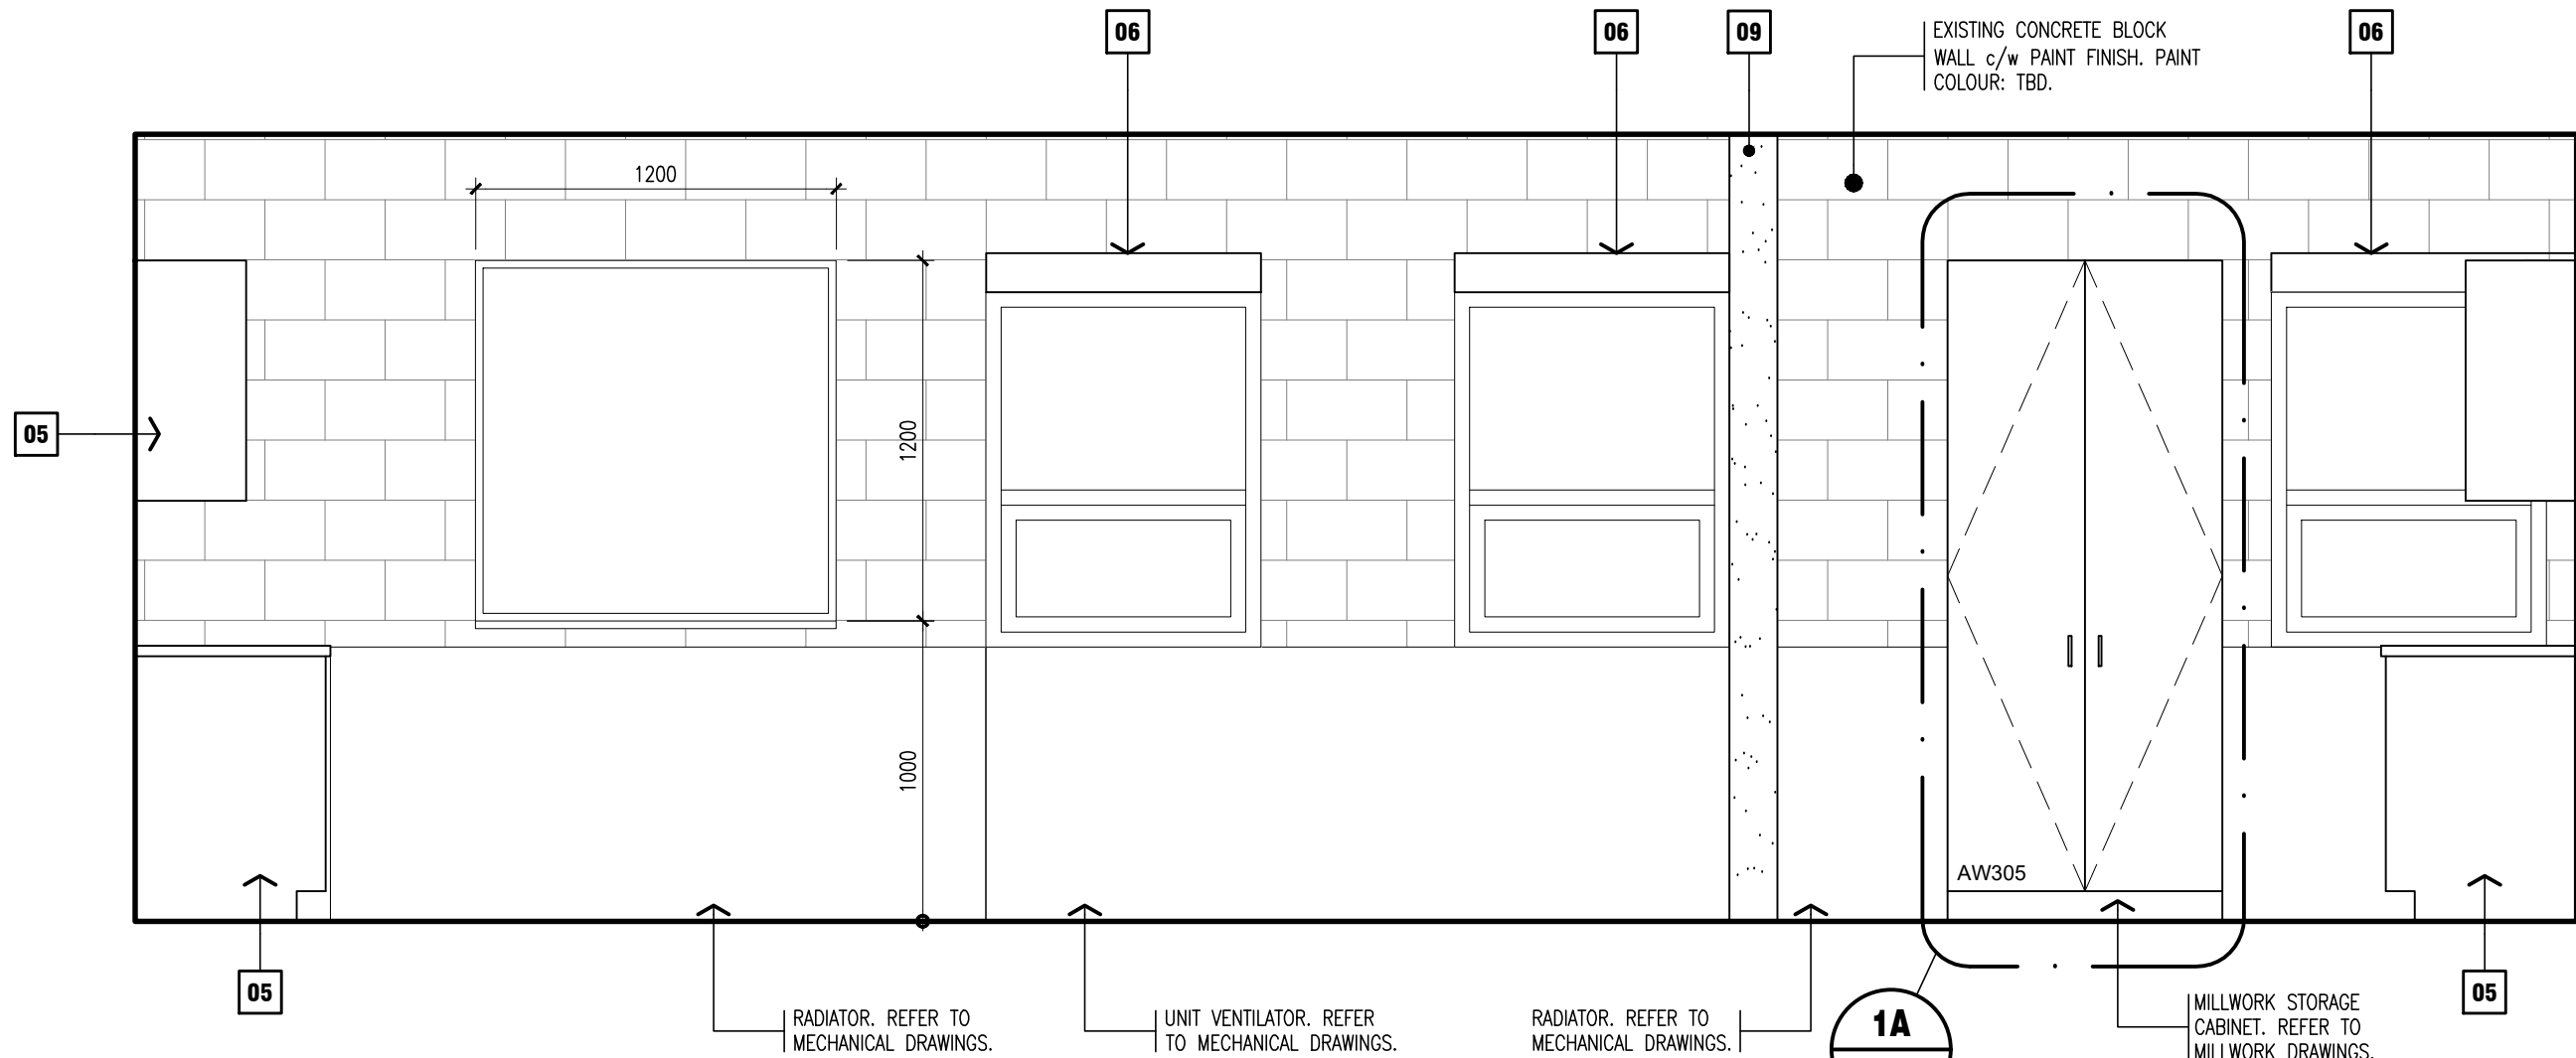

C SOUTH ELEVATION

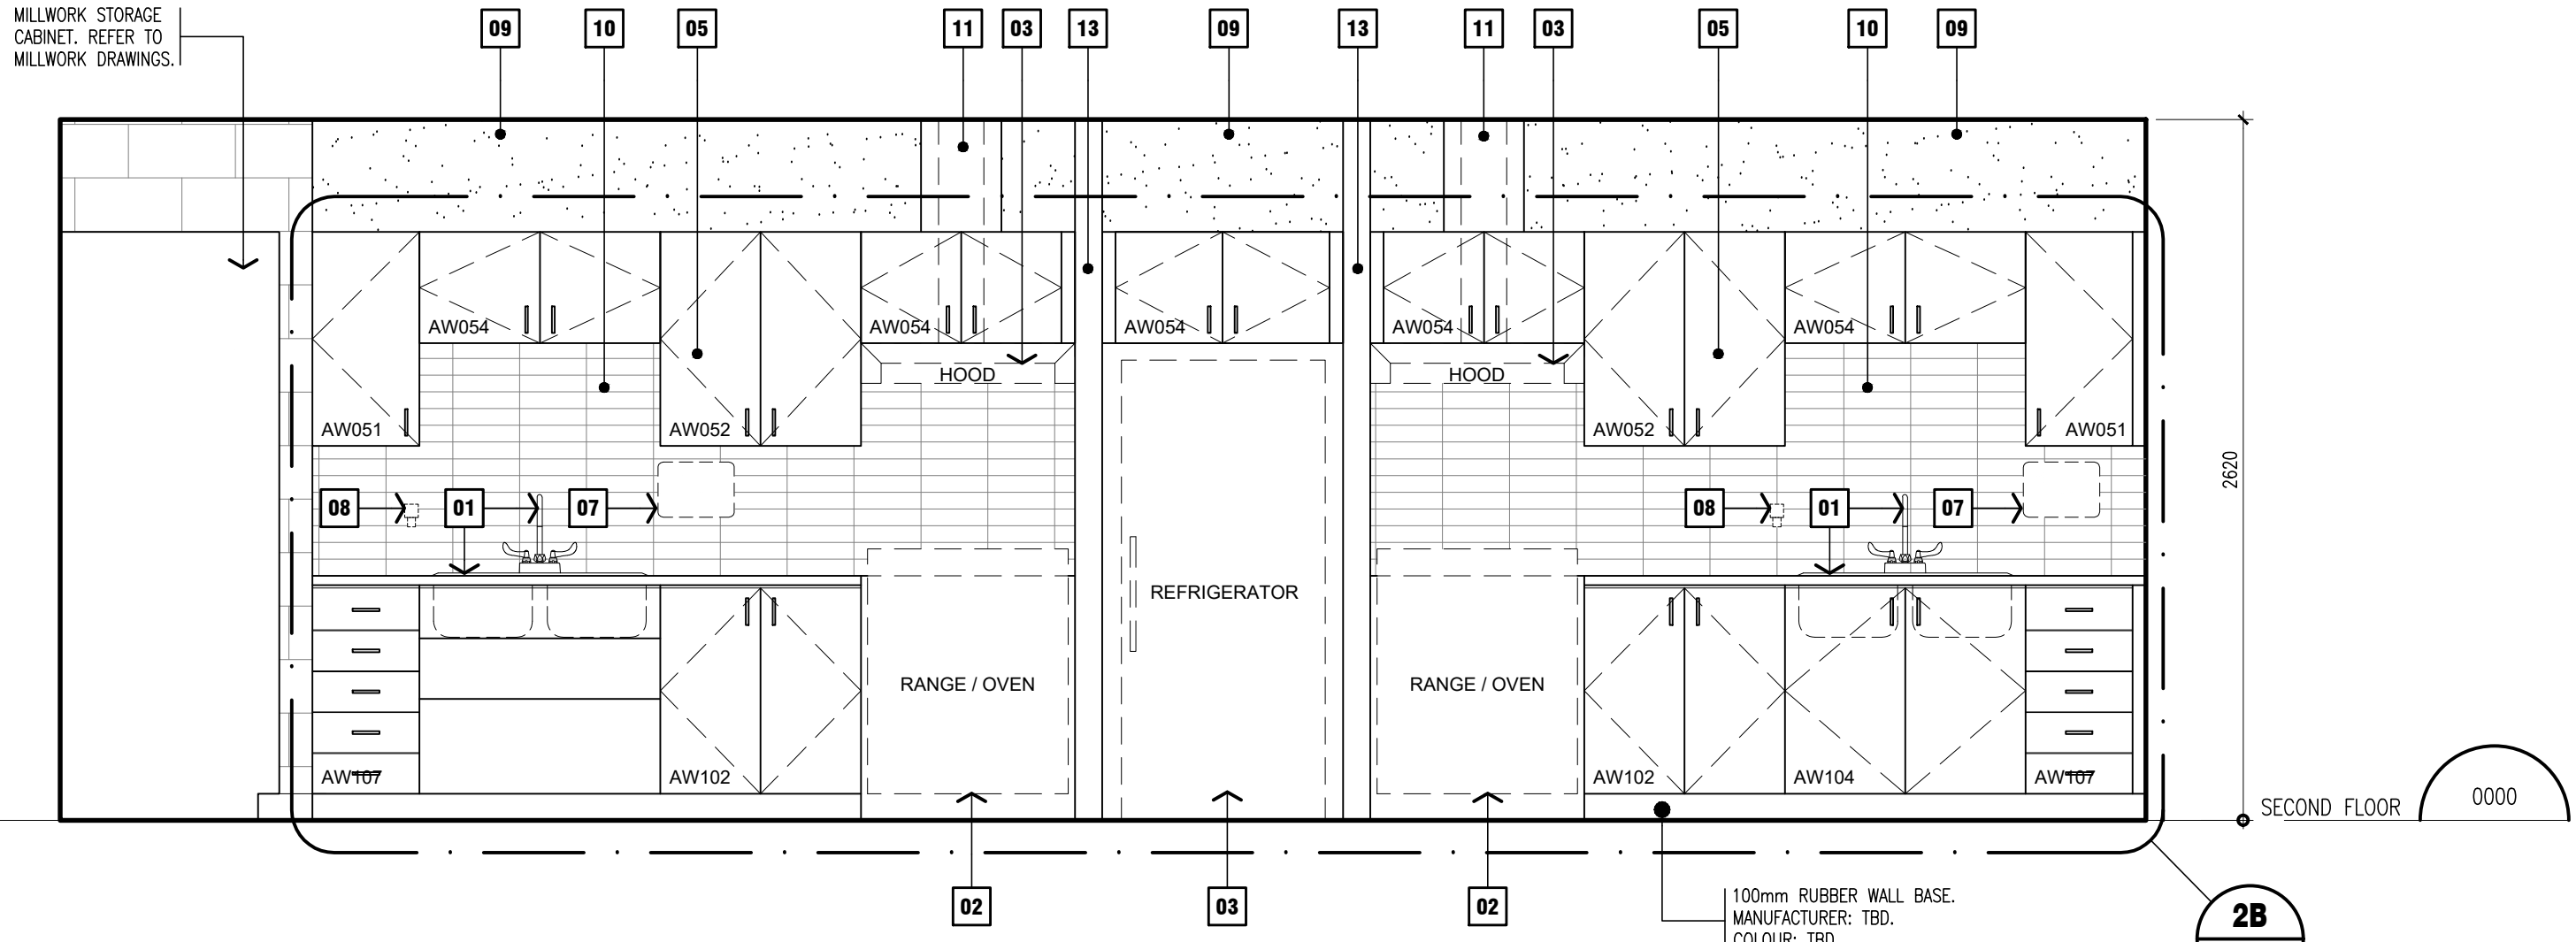

D WEST ELEVATION

1 INTERIOR ELEVATIONS – FAMILY STUDIES 1-220




scale: 1 : 50

DRAWING NOTES:

- | | |
|--|--|
| 01 SINK & FAUCET, SUPPLIED & INSTALLED BY GC. REFER TO PLUMBING DRAWINGS. | 09 GYPSUM BOARD c/w PAINT FINISH. PAINT COLOUR: TBD. |
| 02 RANGE-OVEN, SUPPLIED BY THE OWNER, INSTALLED BY GC. REFER TO MECHANICAL & ELECTRICAL DRAWINGS. | 10 CERAMIC TILE. REFER TO FLOOR FINISH PLAN. |
| 03 FAN HOOD, REFER TO MECHANICAL & ELECTRICAL DRAWINGS. | 11 DUCT ENCLOSURE. REFER TO MILLWORK DRAWINGS. |
| 04 FRIDGE, SUPPLIED BY THE OWNER, INSTALLED BY GC. REFER TO ELECTRICAL & PLUMBING DRAWINGS. | 12 MECHANICAL LOUVRE. REFER TO MECHANICAL DRAWINGS. |
| 05 MILLWORK COUNTER & UPpers c/w 1% UNDER-CABINET LIGHTING. REFER TO MILLWORK DRAWINGS. | 13 STAINLESS STEEL U GUARD. |
| 06 MANUAL ROLLING BLINDS c/w 1% OPEN WEAVE FLAME RETARDANT FABRIC AT EACH EXISTING WINDOW, SUPPLIED & INSTALLED BY THE GC. | |
| 07 PAPER TOWEL DISPENSER, SUPPLIED BY OWNER, INSTALLED BY GC. | |
| 08 SOAP DISPENSER, SUPPLIED BY OWNER, INSTALLED BY GC. | |

LEGEND

- | | |
|--|--|
| | NEW MILLWORK. |
| | EQUIPMENT, SUPPLIED BY THE OWNER, INSTALLED BY THE GENERAL CONTRACTOR. |

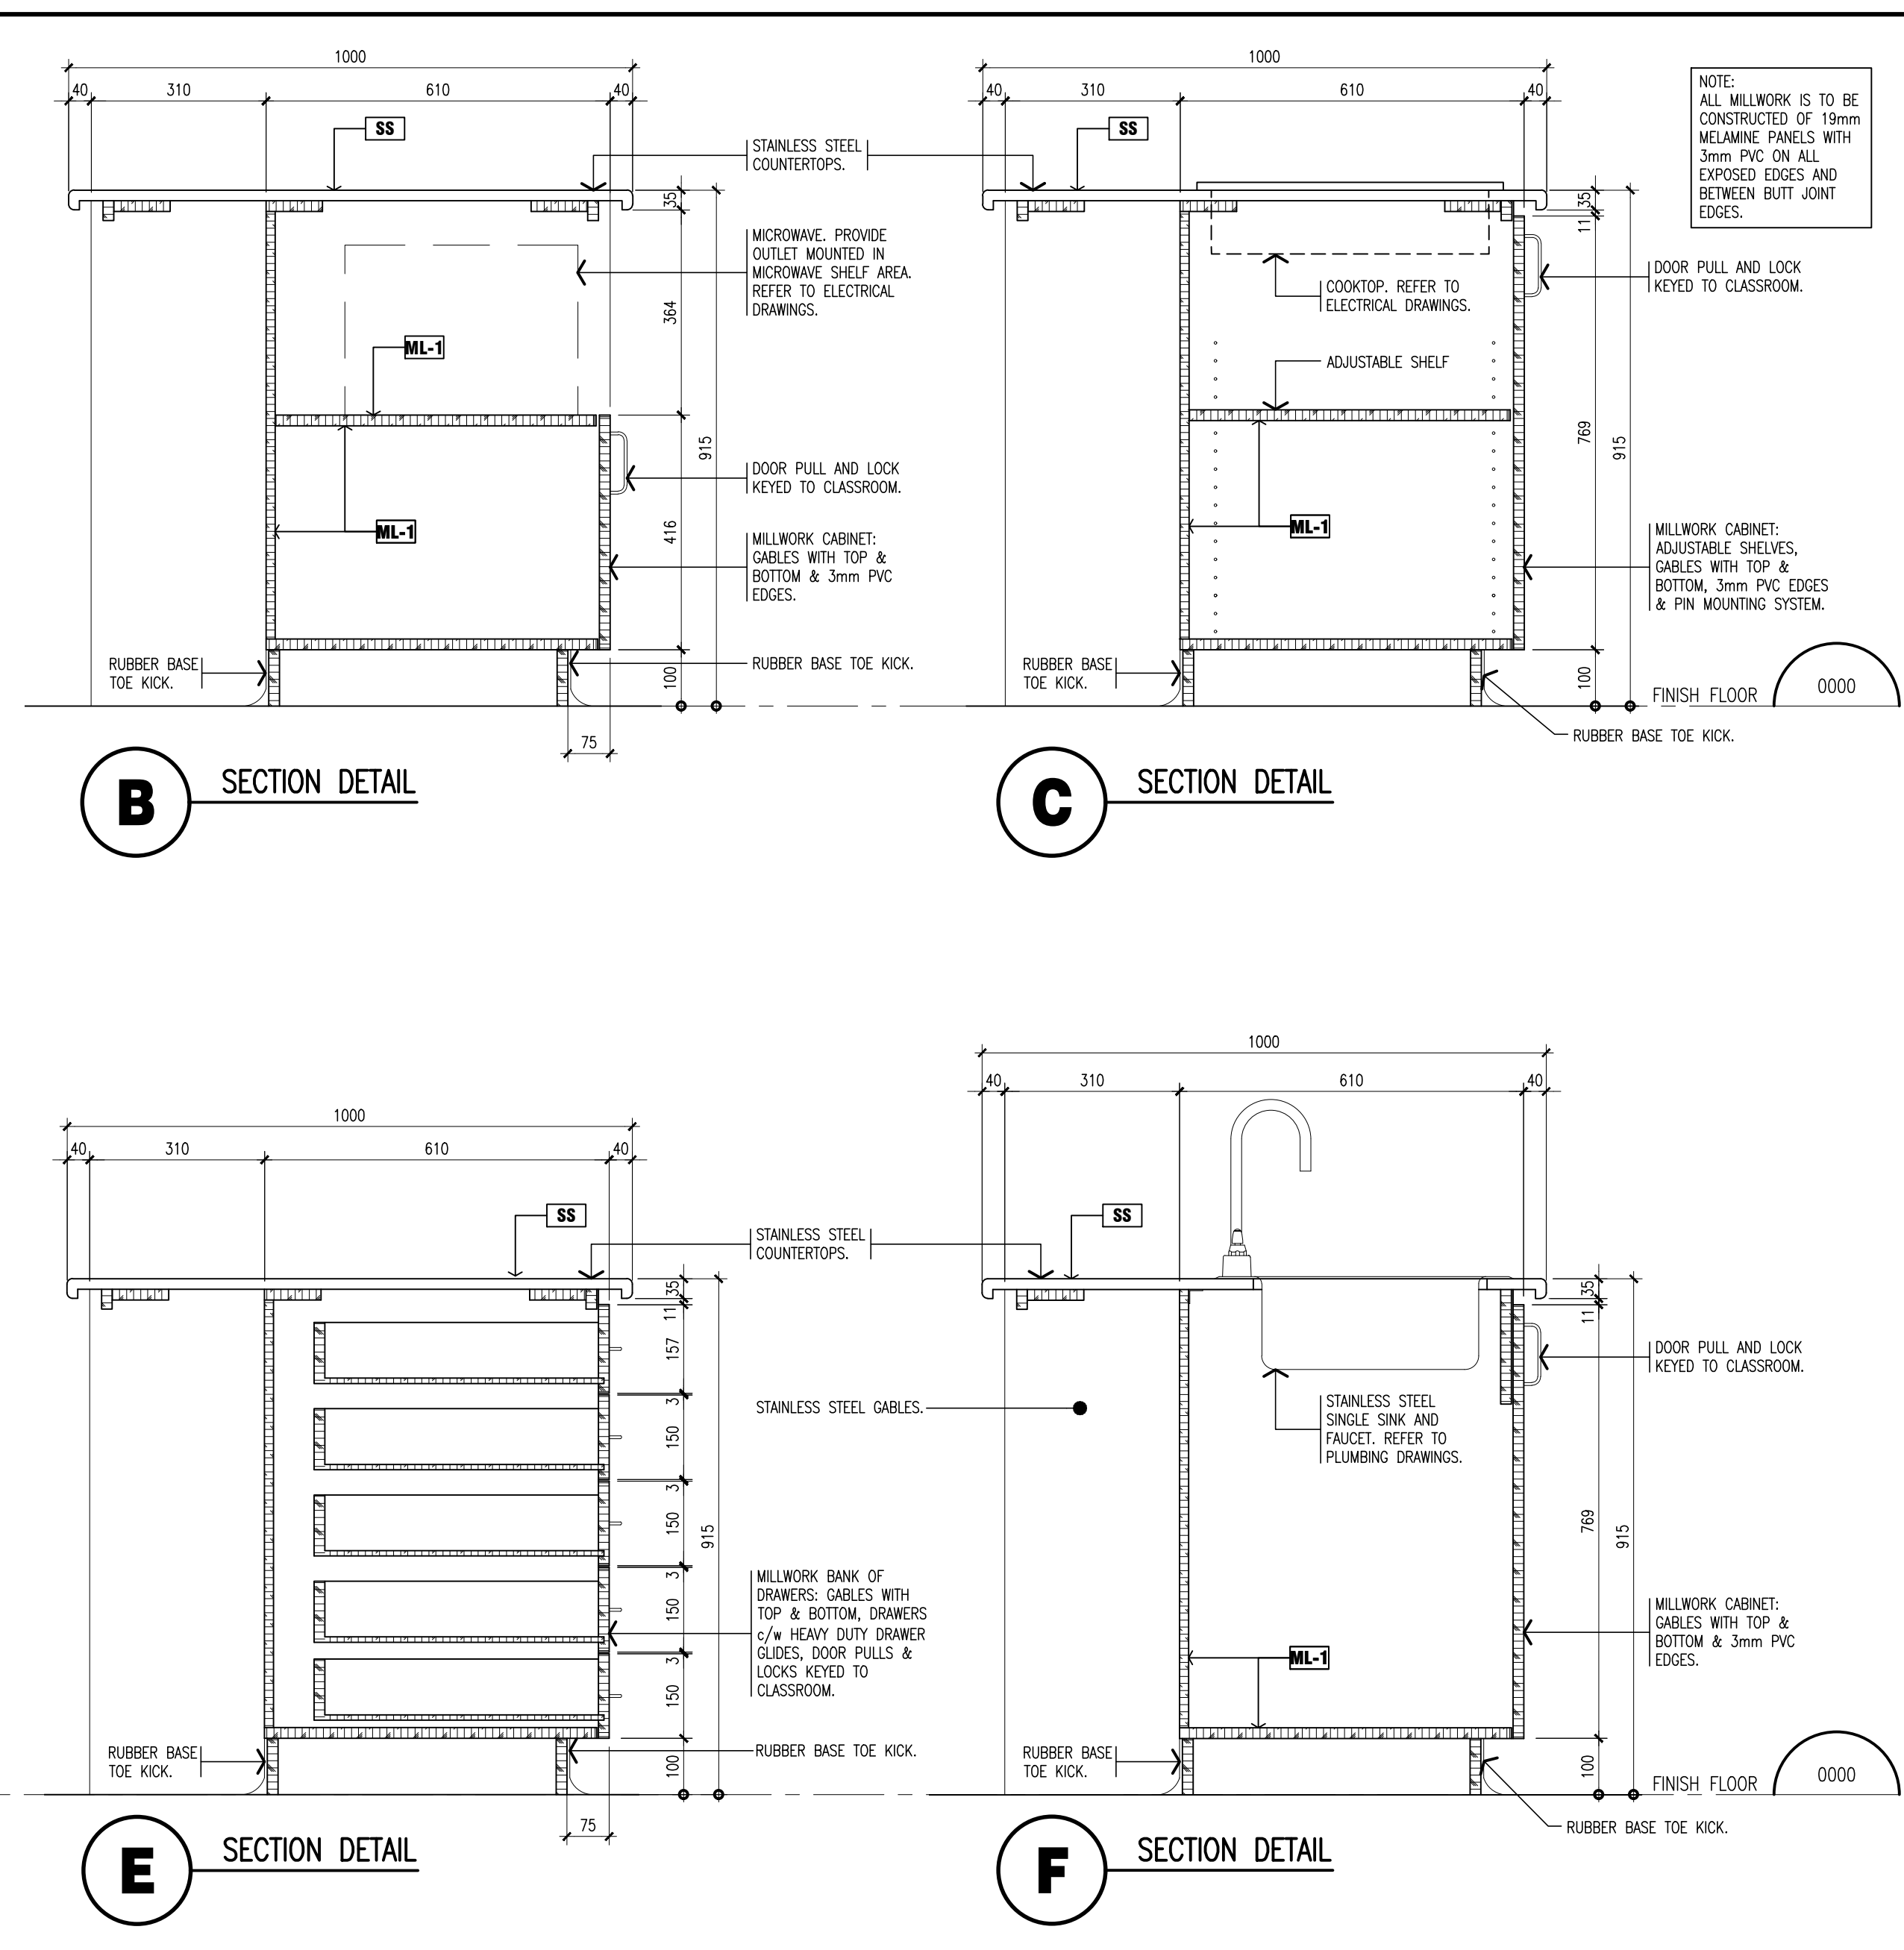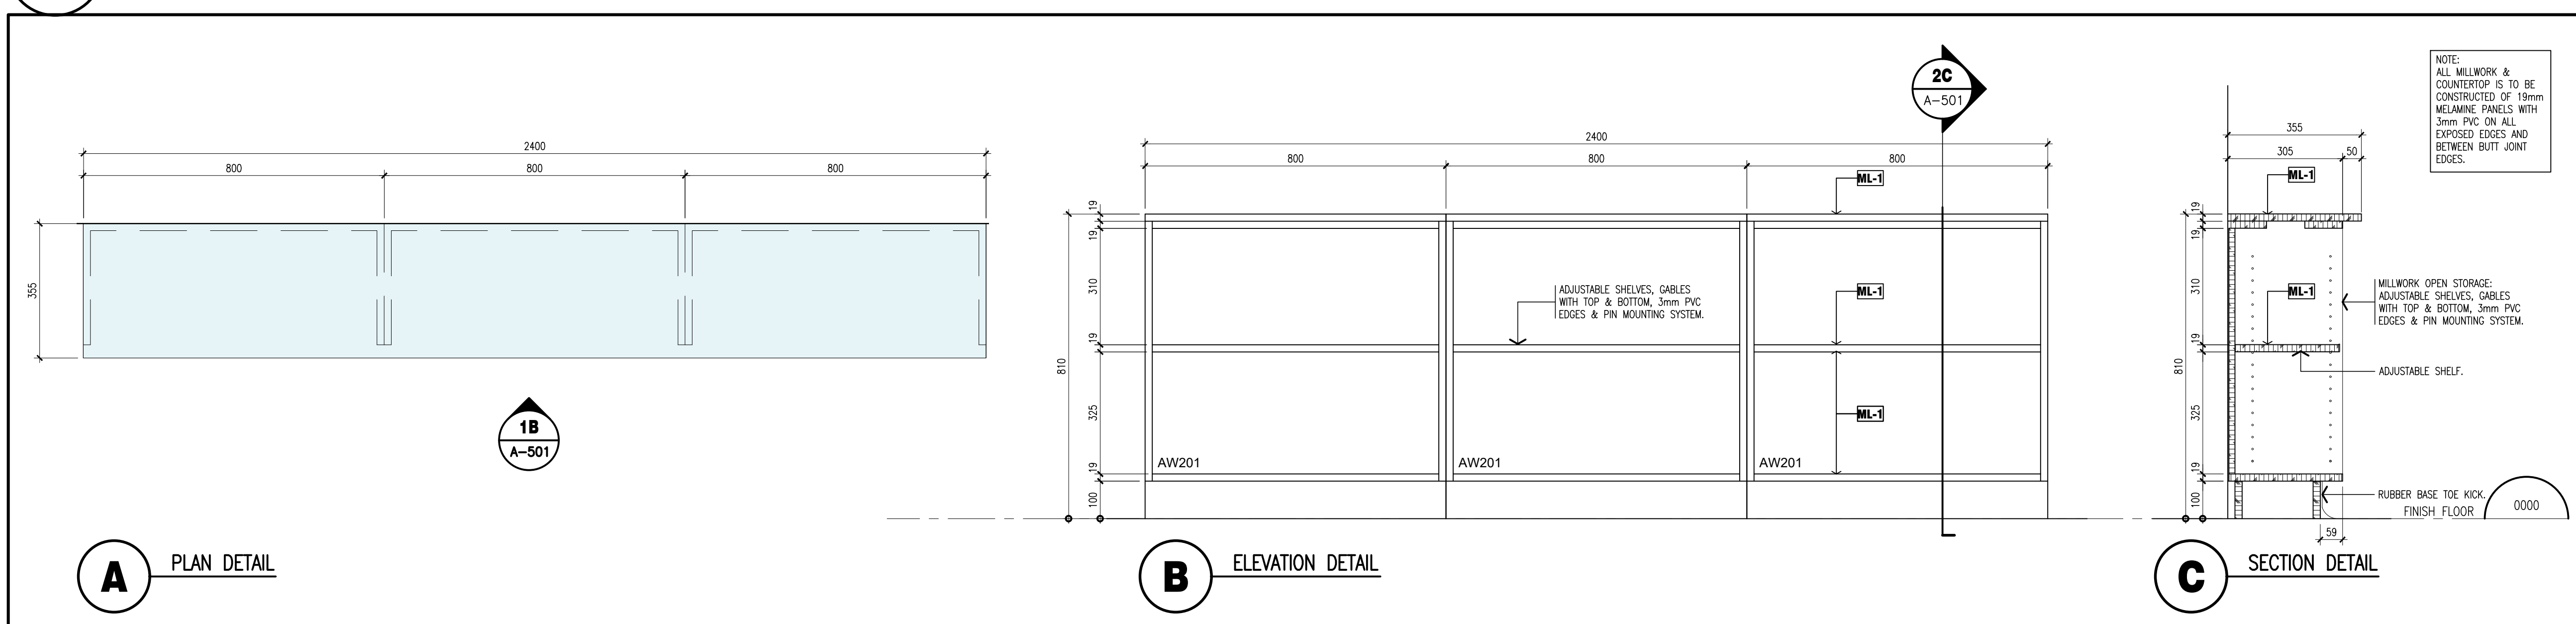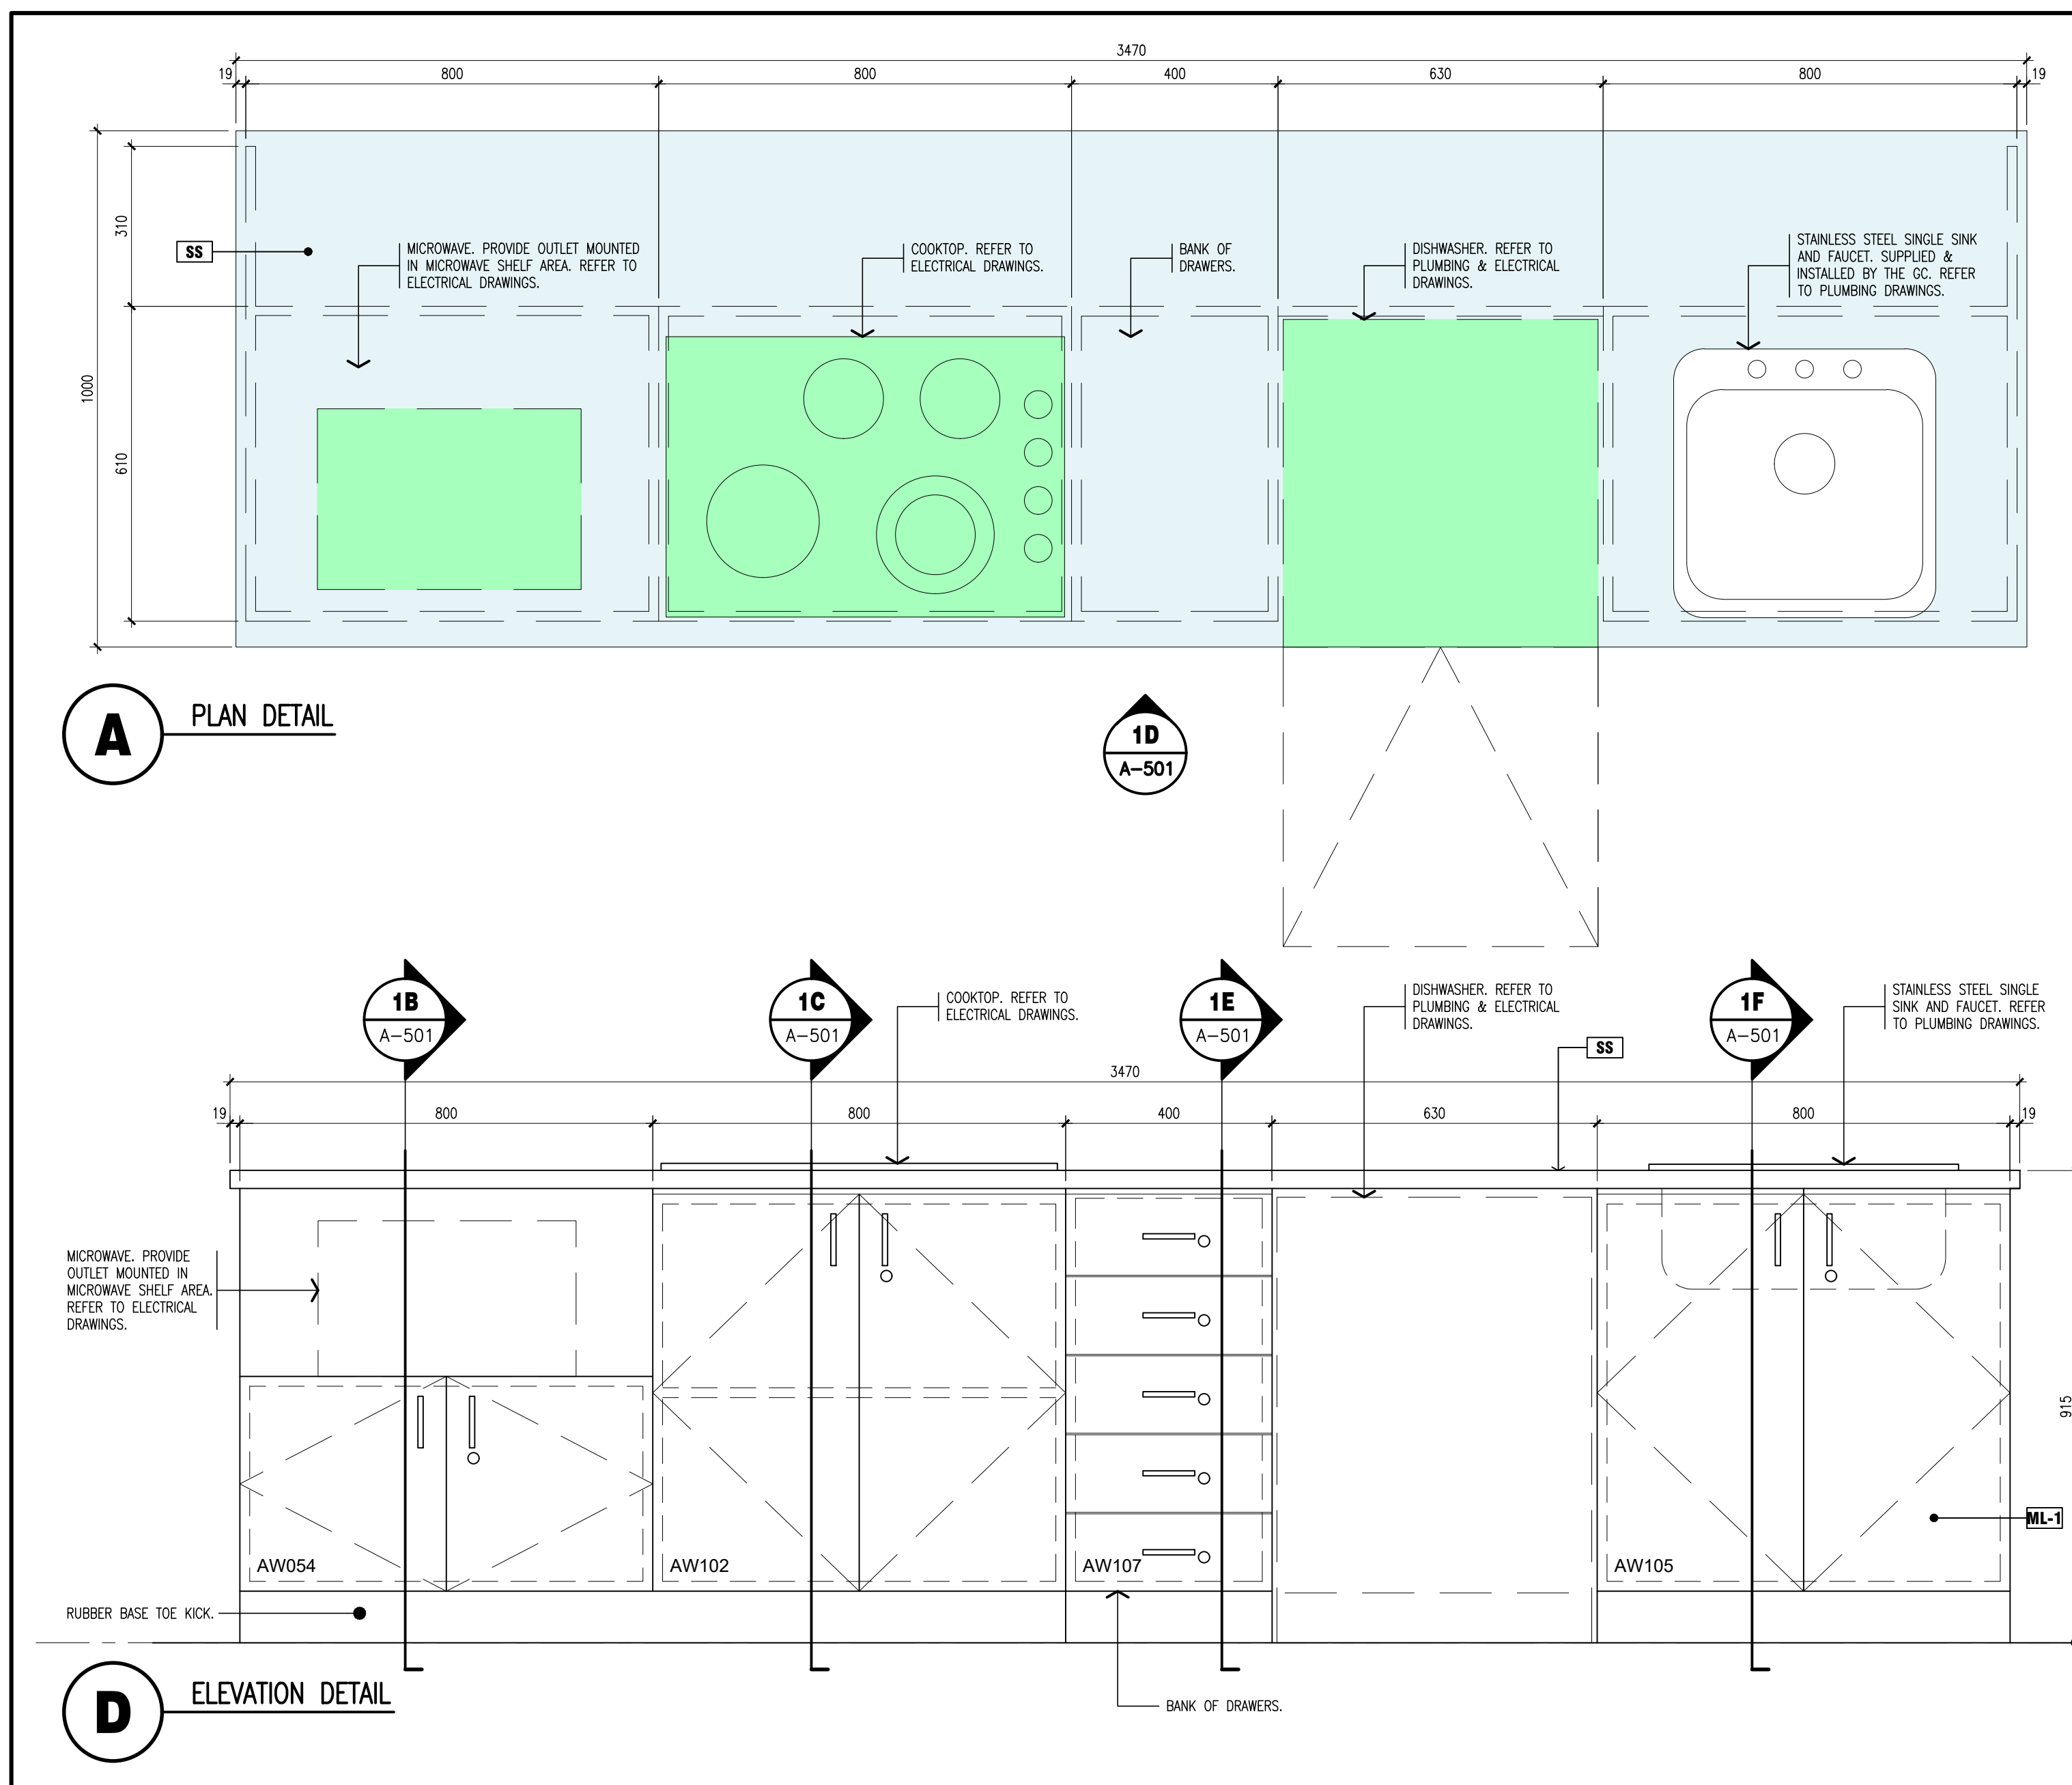


NOTE: This drawing and all associated documentation are the confidential property of BJC architects & assocs, inc. and shall be returned upon request. Any duplication, reuse, revision and/or distribution in part or whole without the prior written authorization of BJC architects & assocs, inc. is prohibited. Each contractor will check and verify all dimensions and report all errors and omissions to the design architect. The contractor is notified that this drawing does not scale this drawing.


The information and materials herein reflect the best and true work of BJC architects & assocs, inc. in light of the information available to them at the time of preparation of these documents. Any use which a contractor makes of any materials, information or data contained herein or on decisions to be made based on reliance on these documents is the sole responsibility of such third party. BJC architects & assocs, inc. shall not be held responsible for damages, if any, suffered by any contractor as a result of any actions taken based on these documents © BJC architects & assocs, inc. 2025.

01	ISSUED FOR TENDER	2026.	04.08
No.	REVISIONS		date

	drawn MV	
	last worked on 2026.03.17	by MV
	checked B.R.J.	
	print date 2026.04.08	

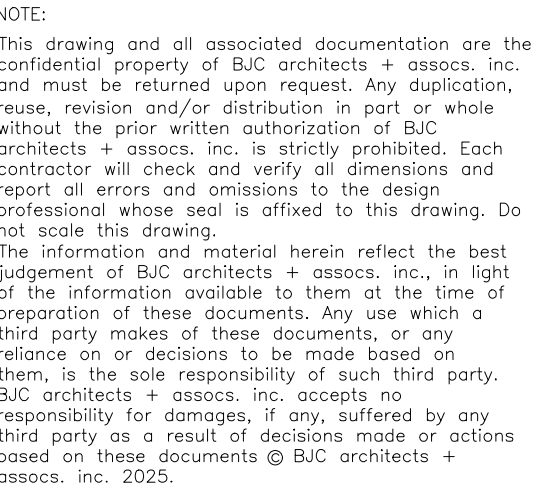

01	ISSUED FOR TENDER	2026. 04.08
No.	REVISIONS	date

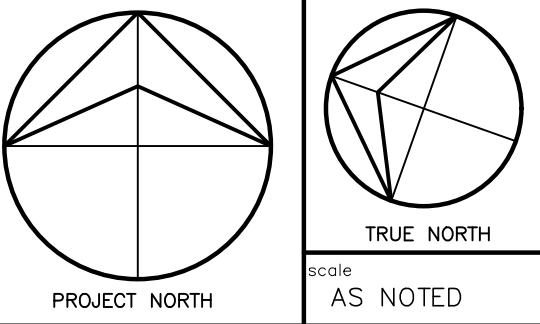

drawn	
MV	
last worked on	by
2026.04.02	MV
checked	
B.R.J.	
print date	
2026.04.08	



client
WATERLOO REGION
DISTRICT SCHOOL
BOARD

51 ARDELT AVE
KITCHENER ONTARIO

project
GRAND RIVER COLLEGIATE
INSTITUTE RENOVATION

175 INDIAN RD
KITCHENER ONTARIO

drawing title

INTERIOR
ELEVATIONS &
MILLWORK DETAILS


ference

project no. 25-092	client reference number
-----------------------	-------------------------


Sheet no. _____

A	-	5	0	2	0	1
----------	----------	----------	----------	----------	----------	----------

1) _____ RESERVED _____

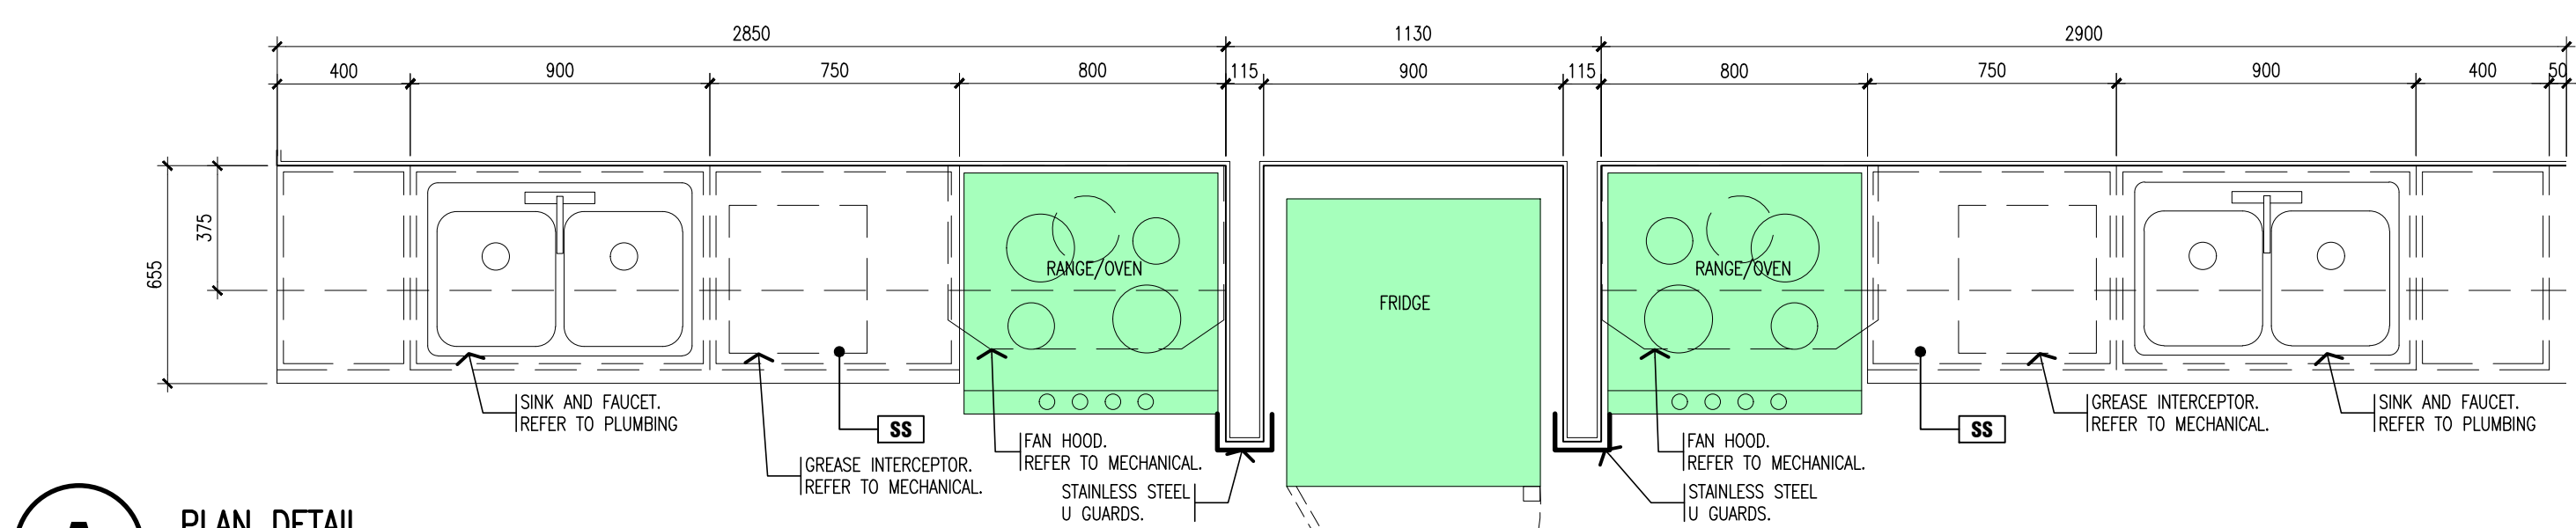

NOTE:
ALL MILLWORK IS TO BE
CONSTRUCTED OF 19mm
MELAMINE PANELS WITH
3mm PVC ON ALL
EXPOSED EDGES AND
BETWEEN BUTT JOINT
EDGES. COUNTERTOPS
ARE TO BE STAINLESS
STEEL.


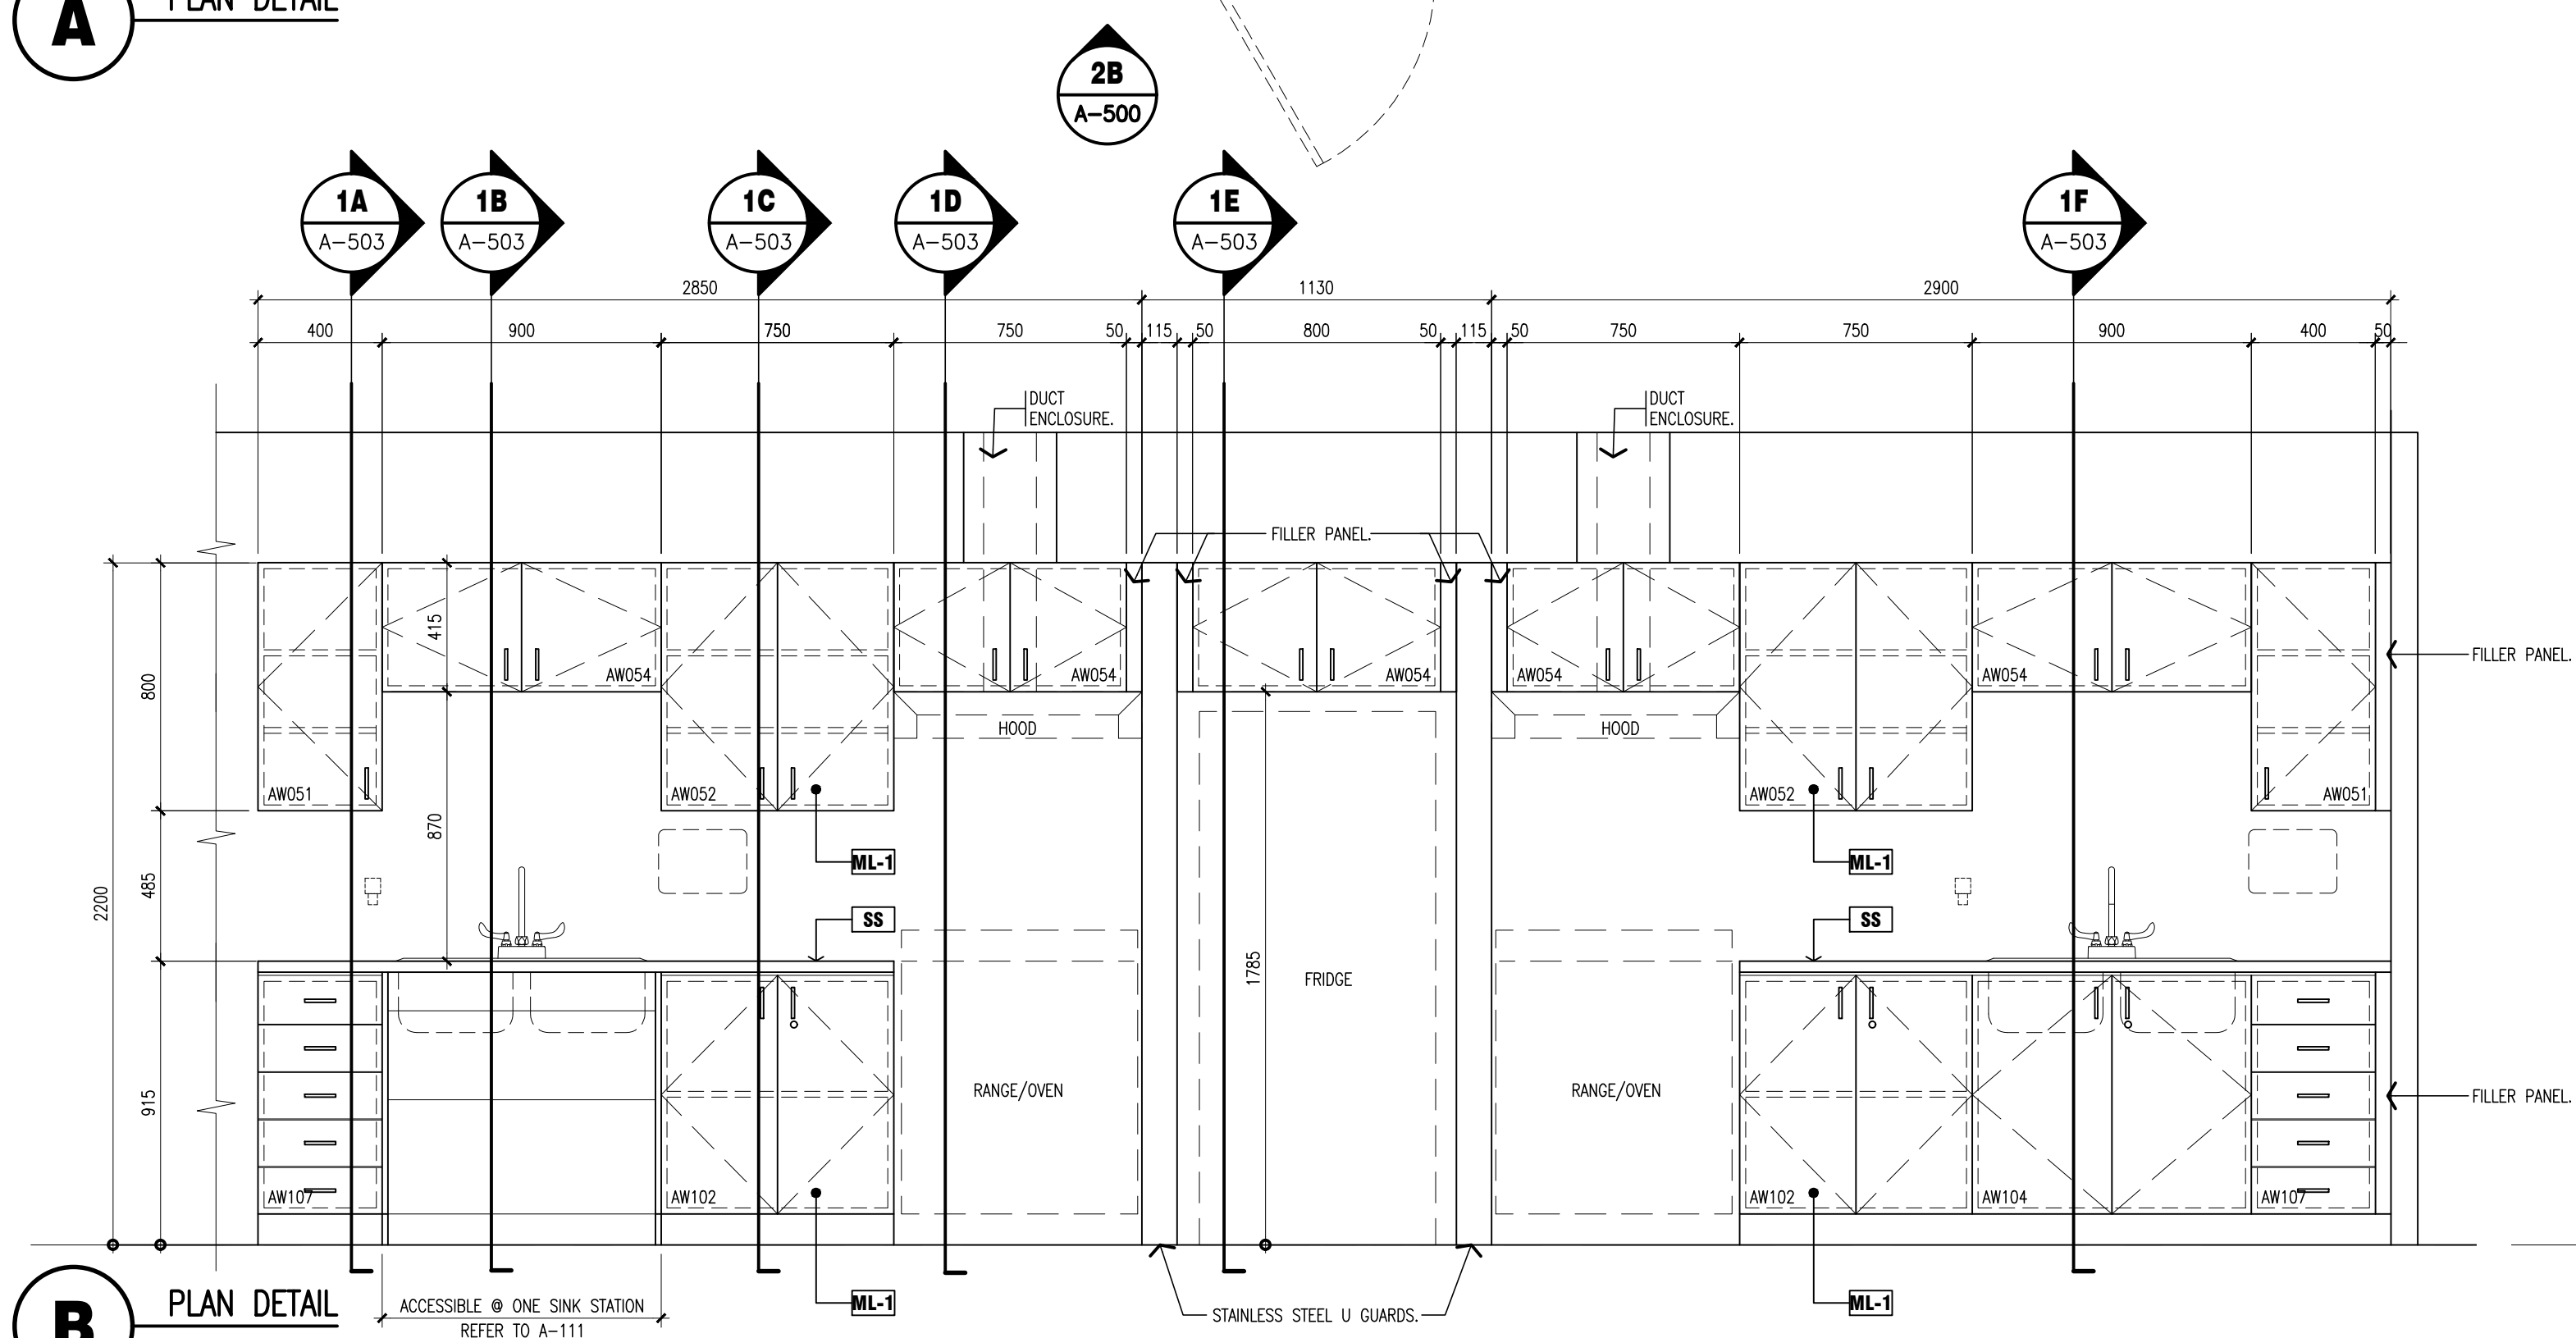


SECOND FLOOR (0000)

scale: 1 : 20

2) MILLWORK DETAILS – COUNTER & UPPERS

scale: 1 : 20

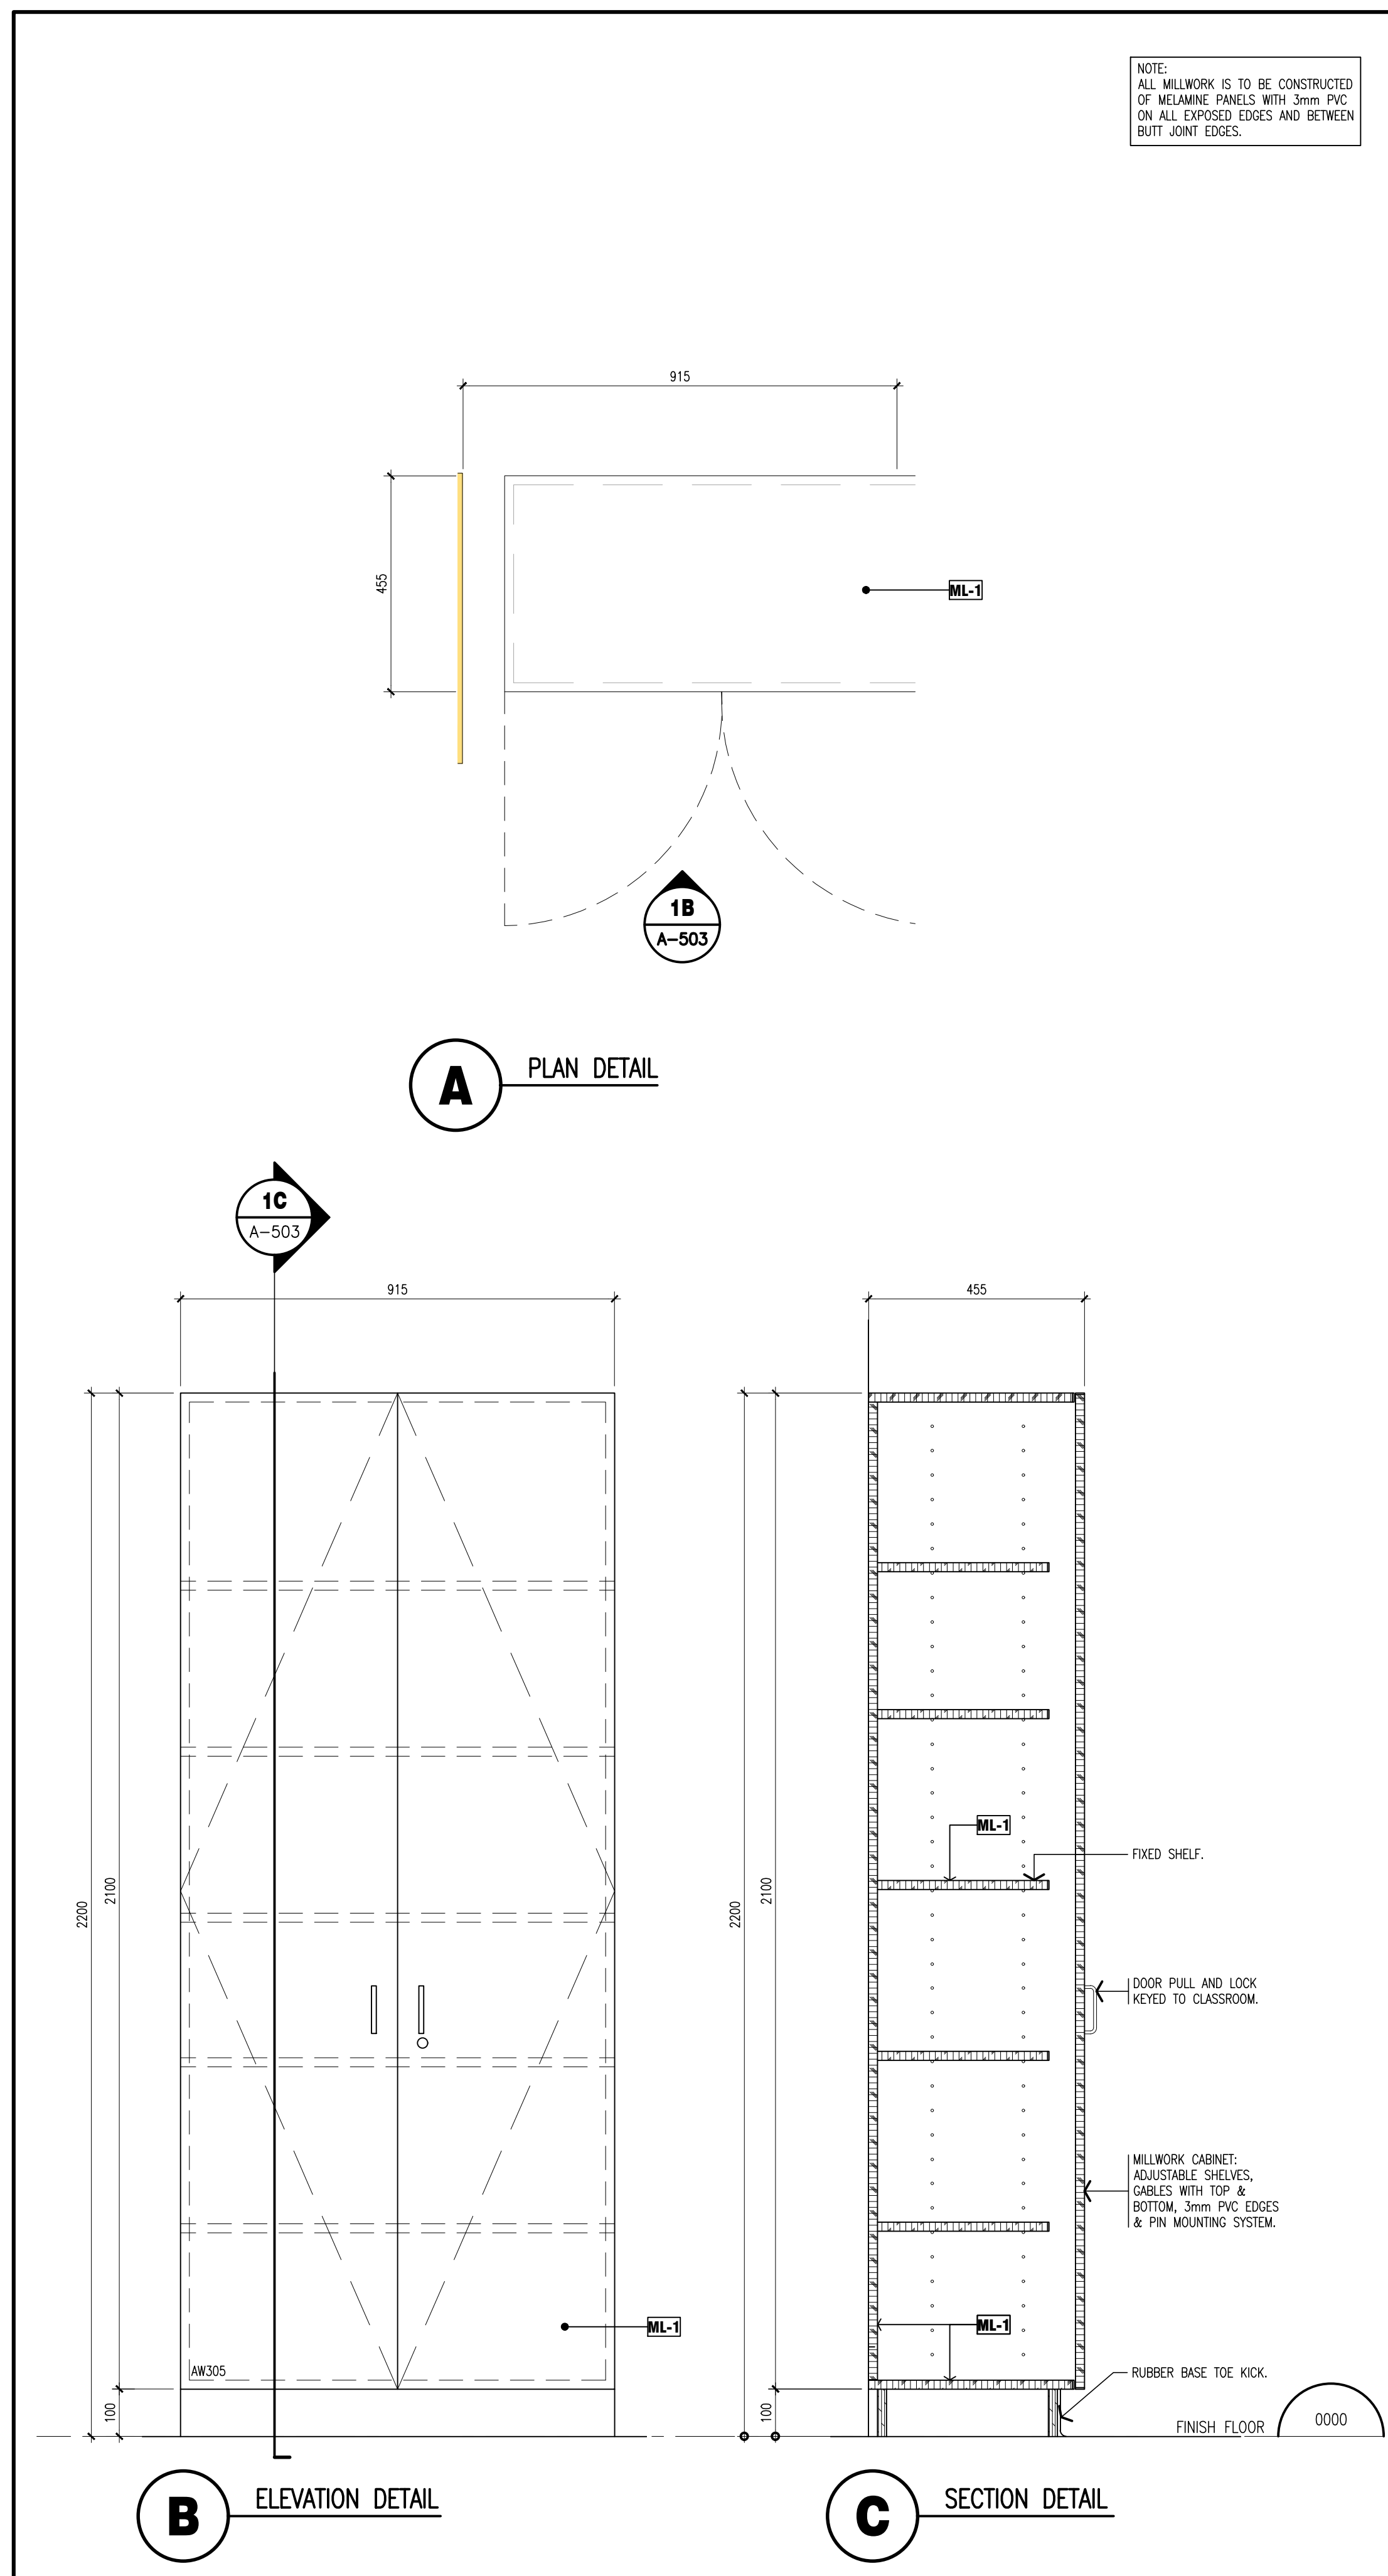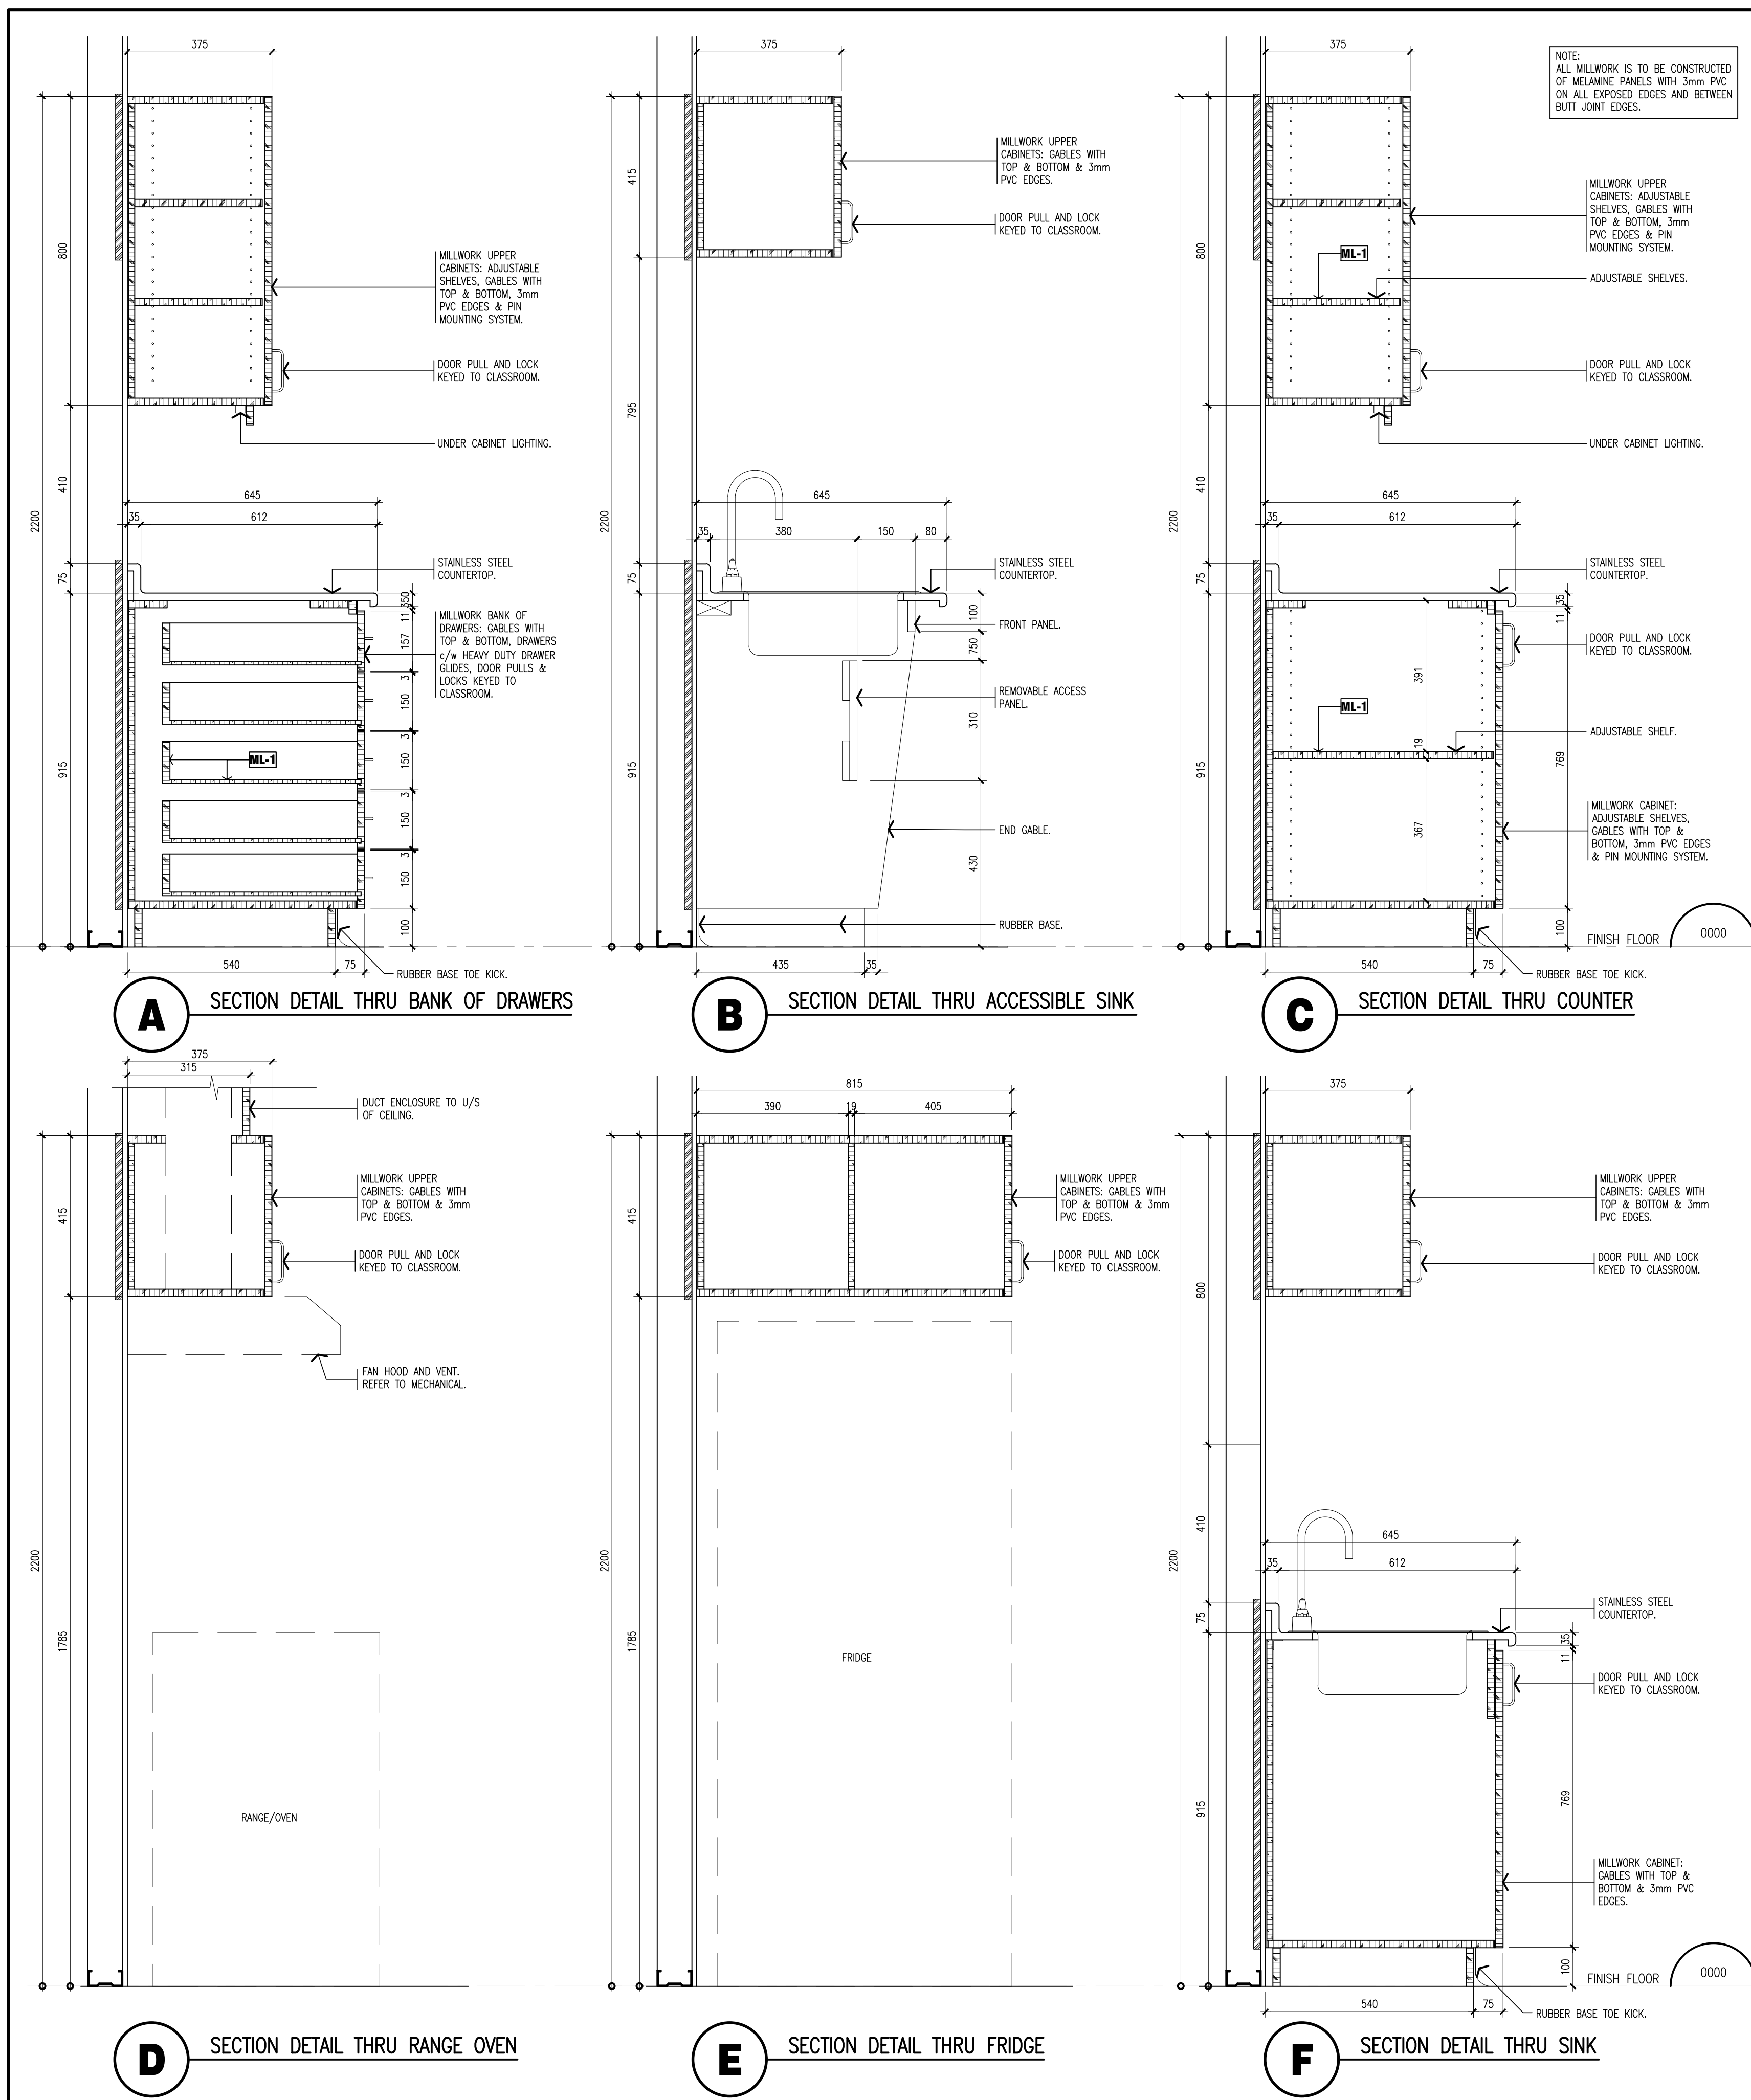


NOTE:

This drawing and all associated documentation are the confidential property of BJC architects + assocs, inc. and must be returned upon request. Any duplication, alteration, and/or use of this drawing, in whole or without the prior written authorization of BJC architects + assocs, inc. is strictly prohibited. Each user of this drawing shall verify all dimensions and report all errors and omissions to the design professional whose seal is affixed to this drawing. D.

The information and material herein reflect the best judgement of BJC architects + assocs, inc. in light of the information and data provided. The preparation of these documents, any use of them, or any decision based on them, is the sole responsibility of such third party. BJC architects + assocs, inc. accepts no liability for damages, losses, or expenses by any third party as a result of decisions made or actions based on these documents © BJC architects + assocs, inc. 1993

01	ISSUED FOR TENDER	2020 04.
No.	REVISIONS	dat

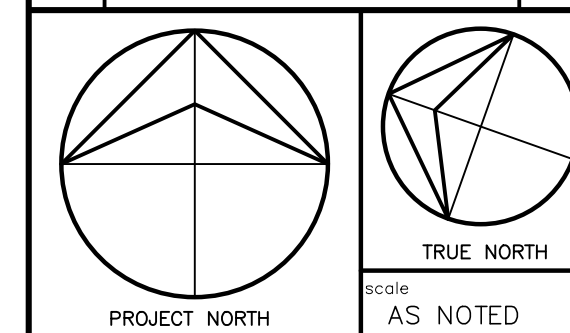

	drawn	
	VA	
	last worked on	by
	2026.04.02	MM
	checked	
	B.R.J.	
	print date	
	2026.04.08	



client
WATERLOO REGION
DISTRICT SCHOOL
BOARD

51 ARDELT AVE
KITCHENER ONTARIO


project
GRAND RIVER COLLEGIATE
INSTITUTE RENOVATION

175 INDIAN RD
KITCHENER ONTARIO


drawing title
MILLWORK DETAILS

reference	
project no. 25-092	client reference number
sheet no.	

A	-	5	0	3	0	1
---	---	---	---	---	---	---

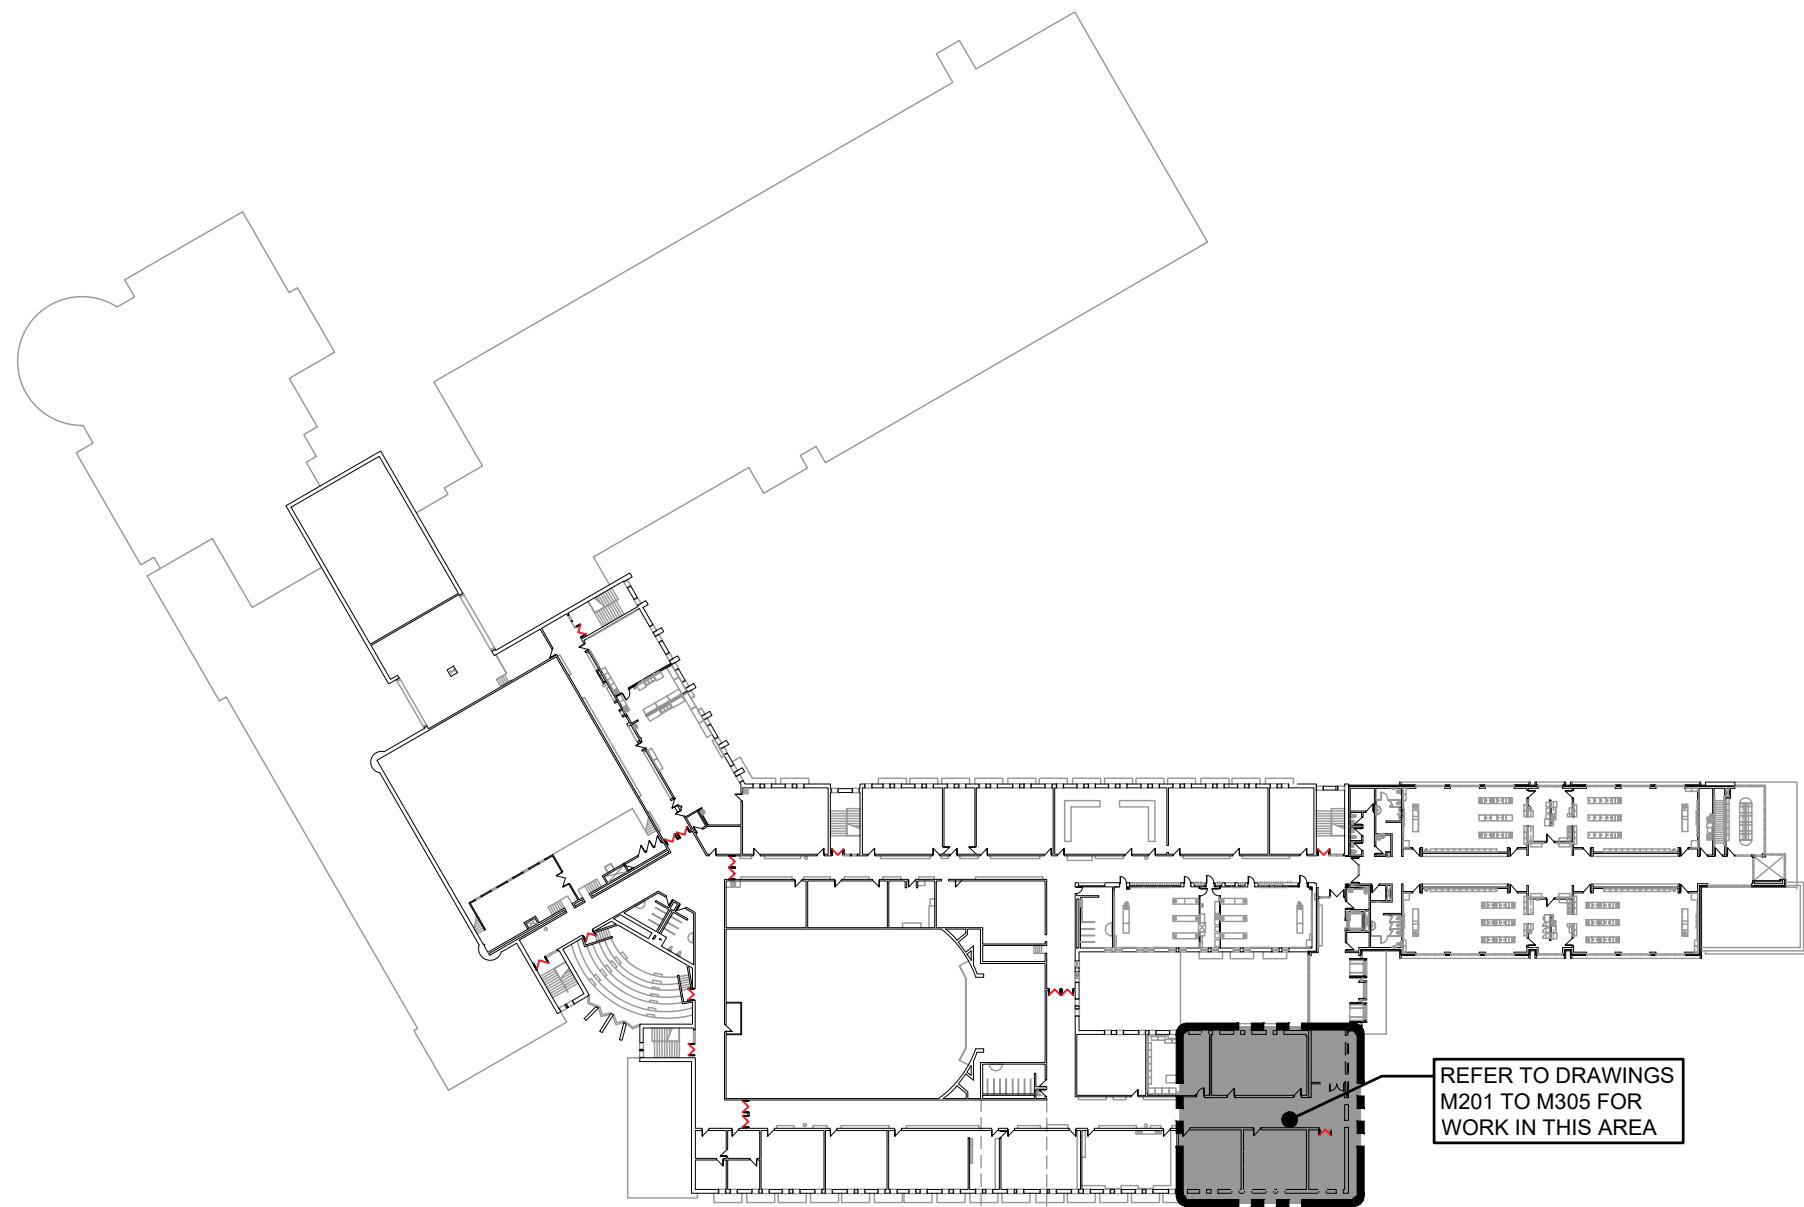

SECOND FLOOR

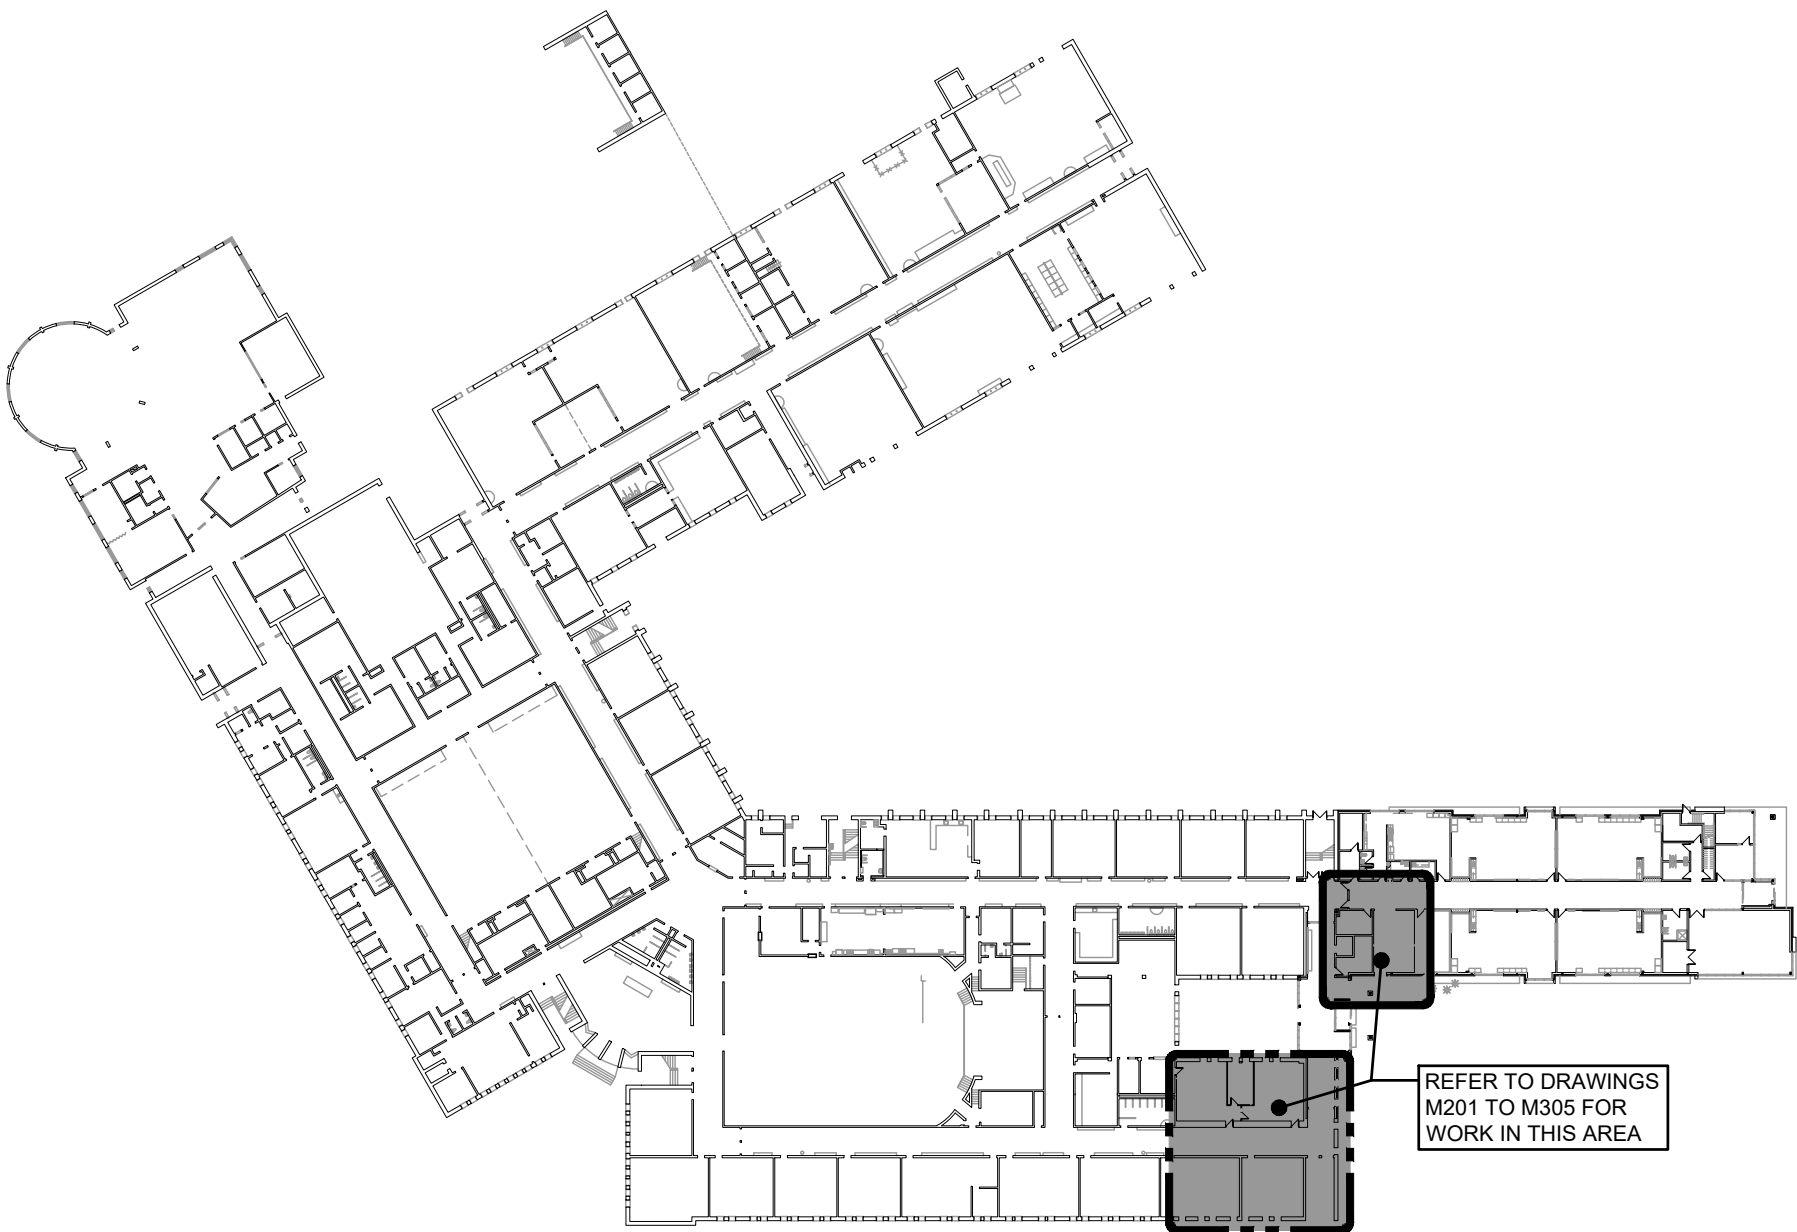

FIRST FLOOR

KEY PLAN
SCALE: N.T.S.

MECHANICAL LEGEND

Item	Description	Item	Description	Item	Description
	ITEM TO BE REMOVED		PIPE DOWN		ACOUSTIC DUCT LINING
	CUT EXISTING & CONNECT NEW PIPING		PIPE UP		THERMAL INSULATION
	FLOW DIRECTION		FLEXIBLE CONNECTION		BRANCH LINE SPIN-IN COLLAR
	POTABLE COLD WATER		REDUCER/INCREASER		CW BALANCING DAMPER
	POTABLE HOT WATER		UNION		BALANCING DAMPER
	EXISTING SAN ABOVE FLOOR		STRAINER		BACKDRAFT DAMPER
	EXISTING SAN BELOW FLOOR		VACUUM BREAKER		OPPOSED BLADE DAMPER
	SANITARY ABOVE FLOOR		SCREWED OR WELDED PIPE CAP		FIRE DAMPER
	SANITARY BELOW FLOOR		PLUG VALVE		FIRE/SMOKE DAMPER
	CONDENSATE DRAIN		BALL VALVE		RECTANGULAR DUCTWORK
	VENT		AIR VENT		RIGID ROUND DUCT
	SPRINKLER		VALVE ON RISER		FLEXIBLE ROUND DUCT
	HEATING WATER SUPPLY		BALANCING VALVE		ACOUSTICAL, FLEXIBLE ROUND DUCT
	HEATING WATER RETURN		2-WAY TEMPERATURE CONTROL VALVE		DIFFUSER/GRILLE SIZE (imp), TYPE & CAPACITY (dm)
	NATURAL GAS		3-WAY TEMPERATURE CONTROL VALVE		HYDRONIC HEATING SIZE, TYPE & CAPACITY
	REFRIGERANT LIQUID		RECESSED CABINET MOUNTED FIRE EXTINGUISHER		ACCESS DOOR
	REFRIGERANT SUCTION		WALL MOUNTED FIRE EXTINGUISHER		EXPANSION JOINT
	FLOOR DRAIN		FIRE BLANKET IN CABINET MOUNTED ON WALL		RETURN IN CABINET
	TRAP PRIMER		THERMOSTAT (WITH GUARD WHERE INDICATED)		ABOVE FINISHED FLOOR
	FLOOR CLEANOUT		CO2 SENSOR (WITH GUARD WHERE INDICATED)		ABOVE FINISHED ROOF
	LINE CLEANOUT		TURNING VANES		PRESSURE RELIEF DOOR
	TEE CONNECTION		SUPPLY AIR DUCT		EXISTING DUCT (SIZE AS INDICATED)
			RETURN/EXHAUST AIR DUCT		TRANSFER DUCT (SIZE AS INDICATED)

NFPA 96 EXHAUST HOOD SCHEDULE

Item	Type	Capacity cfm	SP in wc	Dimensions (inches)	Manufacturer & Model	Remarks
NFPA 96 EXHAUST HOOD (NFPA-1)	BOX CANOPY FILTER HOOD	847	0.46	42" L x 54" W	SPRING AIR FD-BR-MB-3.50/4.5	ISLAND STYLE C/W S.S. SHROUD/EXTENSION UP THRU CEILING (No. 4 FINISH) AND DUCT COLLAR. PROVIDE LIGHT AS SPECIFIED. PROVIDE REGULATED RELEASE FOR REMOTE SUPPRESSION SYSTEM INSTALLATION.
1. ACCEPTABLE MANUFACTURERS: SPRING AIR/GARLAND/GAYLORD/GREENHECK						

LOUVERED PENTHOUSE SCHEDULE

No.	Type	CFM	SP	Throat in.	Dimensions (LxWxH) in.	# of Louvers	Remarks
PH-1	EXHAUST	1200	0.03	44X12	52X20X44	2	MITRED CORNERS, STORMPROOF BLADES. PROVIDE ROOF CURB HEIGHT SUCH THAT BOTTOM LOUVER IS 36" AFR
GENERAL LOUVERED PENTHOUSE SCHEDULE NOTES: 1. STATIC PRESSURE 0.03 2. PROVIDE 900mm (36") HIGH ROOF CURB.							

PLUMBING FIXTURE SCHEDULE

Item	Type	Connection Sizes					Fixture		Trim		Accessories	
		HW	CW	TW	Drain	Vent	Acceptable Manufacturer	Fixture Description	Acceptable Manufacturer	Trim Description	Acceptable Manufacturer	Accessory Description
S-1	STAINLESS STEEL CLASSROOM SINGLE SINK	15	15		40	32	KINDRED LBS6808-1/3 NOVANNI 10171	SINK: SINGLE COMPARTMENT, LEDGE-BACK. FROM 1.0 mm (20 GAUGE) THICK TYPE 302 POLISHED STAINLESS STEEL, SELF-RIMMING, UNDERCOATED, CLAMPS. OVERALL SIZES: 520 mm X 510 mm X 200 mm (20 1/2" X 20" X 8").	DELTA 26T3944-R7 ZURN Z871B4 MOEN COMMERCIAL 6285 & S0030	FAUCET: CHROME PLATED BRASS, WITH 10" GOOSENECK SWING SPOUT, AERATOR, LEVER HANDLES, WASHERLESS CONTROLS, ACCESSORIES TO LIMIT MAXIMUM FLOW RATE TO 5.7 l/min (1.5 gpm) AT 413 kPa (60 psi).		WASTE FITTING: INTEGRAL STAINLESS STEEL BASKET STRAINER/STOPPER, TAILPIECE, CAST BRASS P-TRAP WITH CLEANOUT.
DS-1	STAINLESS STEEL DOUBLE SINK	15	15		40	32	KINDRED LBD6408-1/3 NOVANNI 20071	SINK: DOUBLE COMPARTMENT, LEDGE-BACK. FROM 1.0 mm (20 GAUGE) THICK TYPE 302 POLISHED STAINLESS STEEL, SELF-RIMMING, UNDERCOATED, CLAMPS. OVERALL SIZES: 790 mm X 520 mm X 200 mm (31 1/2" X 20 3/4" X 8").	DELTA 26T3944-R7 ZURN Z871B4 MOEN COMMERCIAL 6285 & S0030	FAUCET: CHROME PLATED BRASS, WITH 10" GOOSENECK SWING SPOUT, AERATOR, LEVER HANDLES, WASHERLESS CONTROLS, ACCESSORIES TO LIMIT MAXIMUM FLOW RATE TO 5.7 l/min (1.5 gpm) AT 413 kPa (60 psi).		WASTE FITTING: INTEGRAL STAINLESS STEEL BASKET STRAINER/STOPPER, TAILPIECE, CAST BRASS P-TRAP WITH CLEANOUT.
WS-1	WASHER SUPPLY VALVE	15	15				WATTS DWB ZURN WM2961 DELTA	ENCASED WASHING MACHINE VALVE COMPLETE WITH SINGLE LEVER HANDLE VALVE, HEAVY-DUTY MOUNTING STRAPS, KNOCKOUTS FOR A RIGHT OR LEFT MOUNTING, AND A TAILPIECE THAT ADAPTS EASILY TO EITHER ABS OR PVC STANDPIPE.				
FD-1	FLOOR DRAIN				NOTED	40	ZURN ZN415B MIFAB F1100-C CONTOUR C2000-R6 WATTS FD-100-C-A	GENERAL DUTY CAST IRON BODY, ADJUSTABLE HEAD, NICKEL BRONZE STRAINER, INTEGRAL SEEPAGE PAN, AND CLAMPING COLLAR. USE SQUARE STRAINER IN TILED AREAS AND ROUND STRAINER ELSEWHERE. C/W TRAP PRIMER				

GENERAL NOTES

- ALL DRAWINGS ARE TO BE READ IN CONJUNCTION WITH THE PREPARED SPECIFICATION.
- THIS CONTRACTOR SHALL TRACK REVISIONS ON SITE AND SUBMIT AS-BUILTS TO CONSULTANT TO DIGITIZE. REFER TO SPECIFICATIONS 21 02 51, 22 02 51 & 23 02 51.
- SANITARY VENT PIPING IS NOT SHOWN. PROVIDE ALL NECESSARY VENT PIPING FROM ALL FIXTURES FOR A COMPLETE SYSTEM TO ALL LOCAL PLUMBING CODE & LOCAL AUTHORITY REQUIREMENTS, CONNECTED TO EXISTING VENTS OR NEW VENTS AS REQUIRED. CO-ORDINATE VENT LOCATION(S) WITH GENERAL CONTRACTOR. MAINTAIN MIN 14" OF FROM ANY AIR INLET. INSTALL VENT PIPING HIGH IN JOIST SPACE.
- WHERE DUCTWORK PENETRATES CORRIDOR WALL, CENTER DUCT(S) BETWEEN OWSJ.
- CONTRACTOR TO LOCATE ISOLATION VALVES / FREEZE PIPING / OR OTHERWISE DRAIN SYSTEMS TO ALLOW PROPOSED WORK TO PROCEED. REFILL SYSTEMS AS INDICATED.
- REFER TO SPECIFICATIONS FOR CONFORMANCE REQUIREMENTS.

MAKE-UP UNIT SCHEDULE

Item	Type	Supply Air Fan Data				Electrical Data				HEATING		Manufacturer	Model	Weight (lbs) (approx.)	Remarks
		Service	Capacity cfm	Size hp	ESP in wc	Voltage	MCA	MOCP	Outdoor Air %	Medium	Heating Input (MBH)				
MUA-3	OUTDOOR MAKE UP AIR	EXISTING FAMILY STUDIES 1-220	1609	1.5	2.21"	208/3/60	6.38	15	100%	GAS	200	SPRING AIR	SFT10-IGOD-1	1000±	C/W MOTOR RATED FOR VFD (DEMAND VENTILATION TRUEFLOW), 600mm HIGH ROOF CURB
1. ACCEPTABLE MANUFACTURERS: SPRING AIR/GARLAND/GAYLORD/GREENHECK															

GRILLE SCHEDULE

Item	Type	Equalizing Grid	Volume Damper	Acceptable Manufacturer	Description
R1	CEILING RETURN GRILLE (NON-DUCTED)	NO	NONE	EH PRICE 80-CH	1/2x1/2x1/2 ALUMINUM EGGRATE CORE. C/W CHANNEL BORDER FOR LAY-IN T-BAR CEILING.
R2	EXHAUST GRILLE (DUCTED)	NO	NONE	EH PRICE 80-FA	1/2x1/2x1/2 ALUMINUM EGGRATE CORE. C/W 1 1/4" FLAT BORDER & SCREWED FASTENING FOR SURFACE MOUNTING.

GENERAL GRILLE SCHEDULE NOTES:

- ACCEPTABLE MANUFACTURERS: EH PRICE, NAILOR, TITUS, KRUEGER, CARNES, METALAIRE.
- GRILLE COLOURS ARE SELECTED BY ARCHITECT FROM STANDARD COLOUR CHART, UNLESS OTHERWISE NOTED.
- PAINT INTERIOR OF DUCTWORK BEHIND GRILLE MATTE BLACK (WHERE VISIBLE THRU GRILLE).


CAPACITY INDICATED ON SCHEDULE REFER TO SPECIFICATION FOR CONSTRUCTION STANDARDS, ACCESSORIES AND ADDITIONAL INFORMATION.

NOTE:
The contractor shall verify all dimensions and report all errors and discrepancies to the Consultant before commencement of the work. The drawings show general arrangement of services. Follow as closely as actual building construction will permit. Obtain approval for relocation of service from Consultant before commencement of the work. The drawings do not indicate all offsets fitting and accessories which may be required. Provide the same to meet the required conditions. Drawings and specifications, etc., prepared and issued by the Consultant are the property of the Consultant and must be returned at the completion of the project. These documents are not to be duplicated or copied without the consent of the Consultant. Do not scale this drawing. © 2008 DEI Consulting Engineers Inc.


01	ISSUED FOR PERMIT AND TENDER	2025.04.10
No.	REVISIONS	date
PROJECT NORTH		TRUE NORTH
scale		AS NOTED

reference	
project no. 25-092	client reference number
sheet no.	
M 2 0 1 0 0	


KEY PLAN

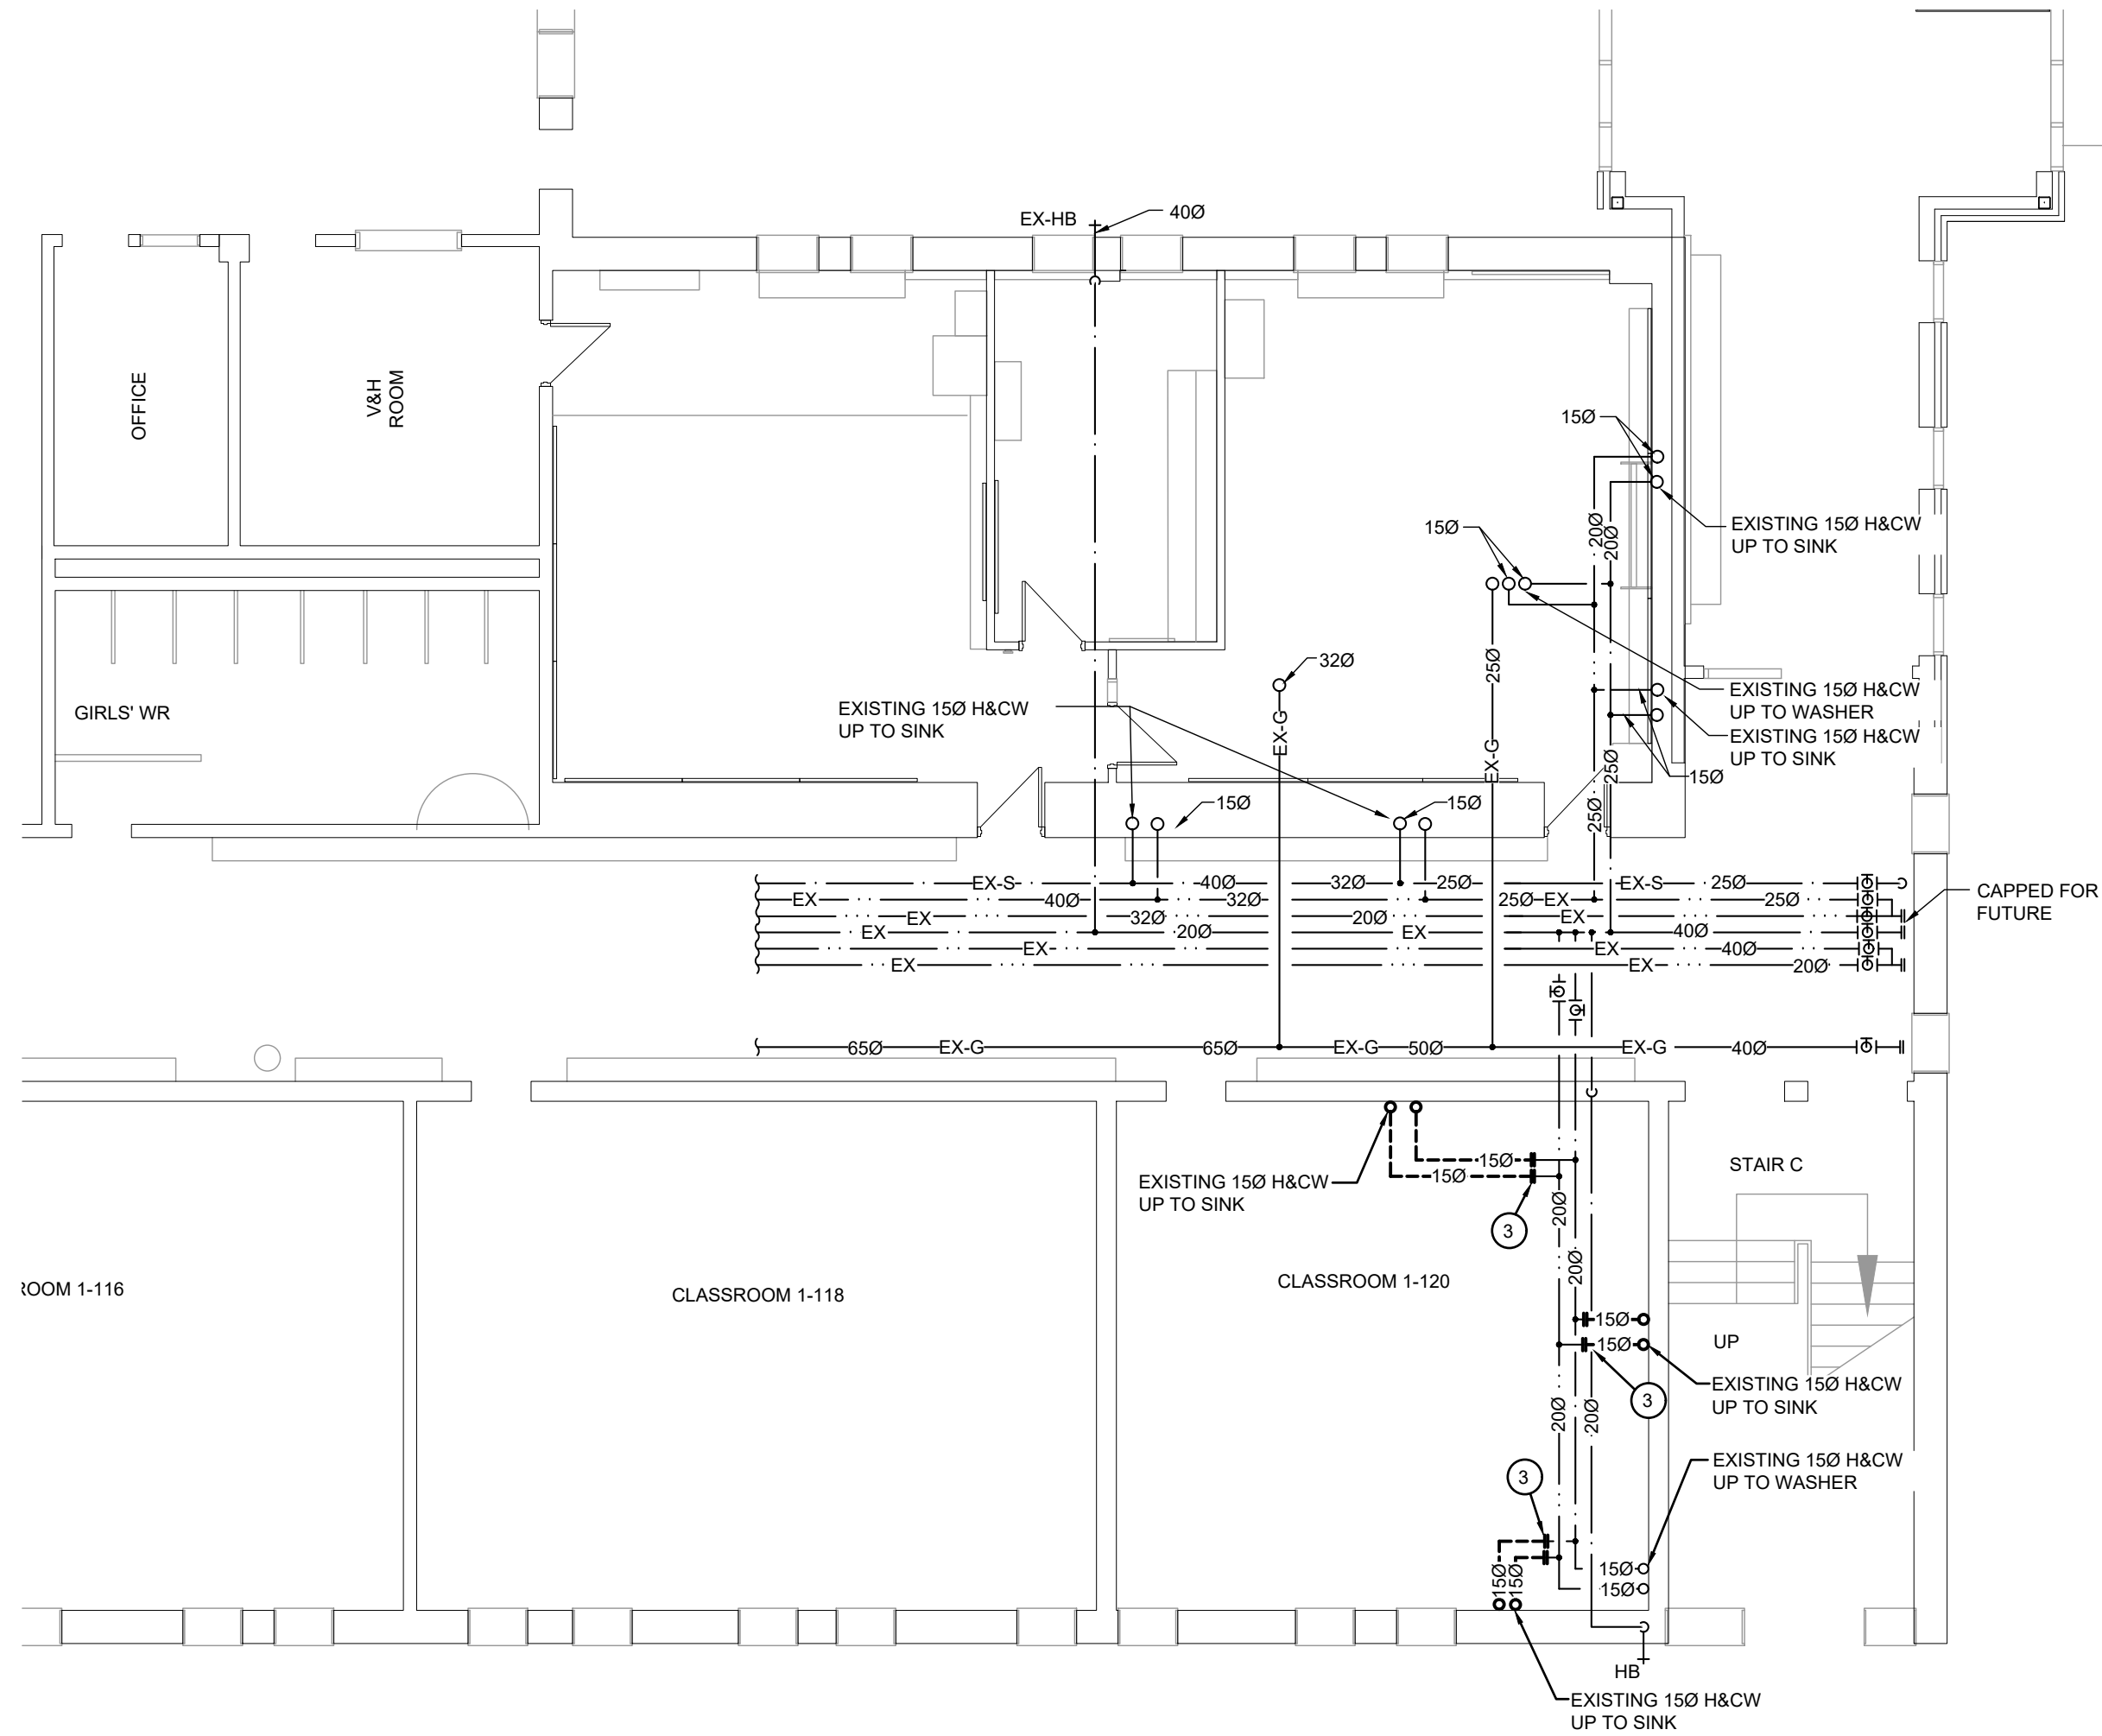

FIRST FLOOR PART PLAN 'A' - DOMESTIC DEMOLITION
SCALE: 1:100

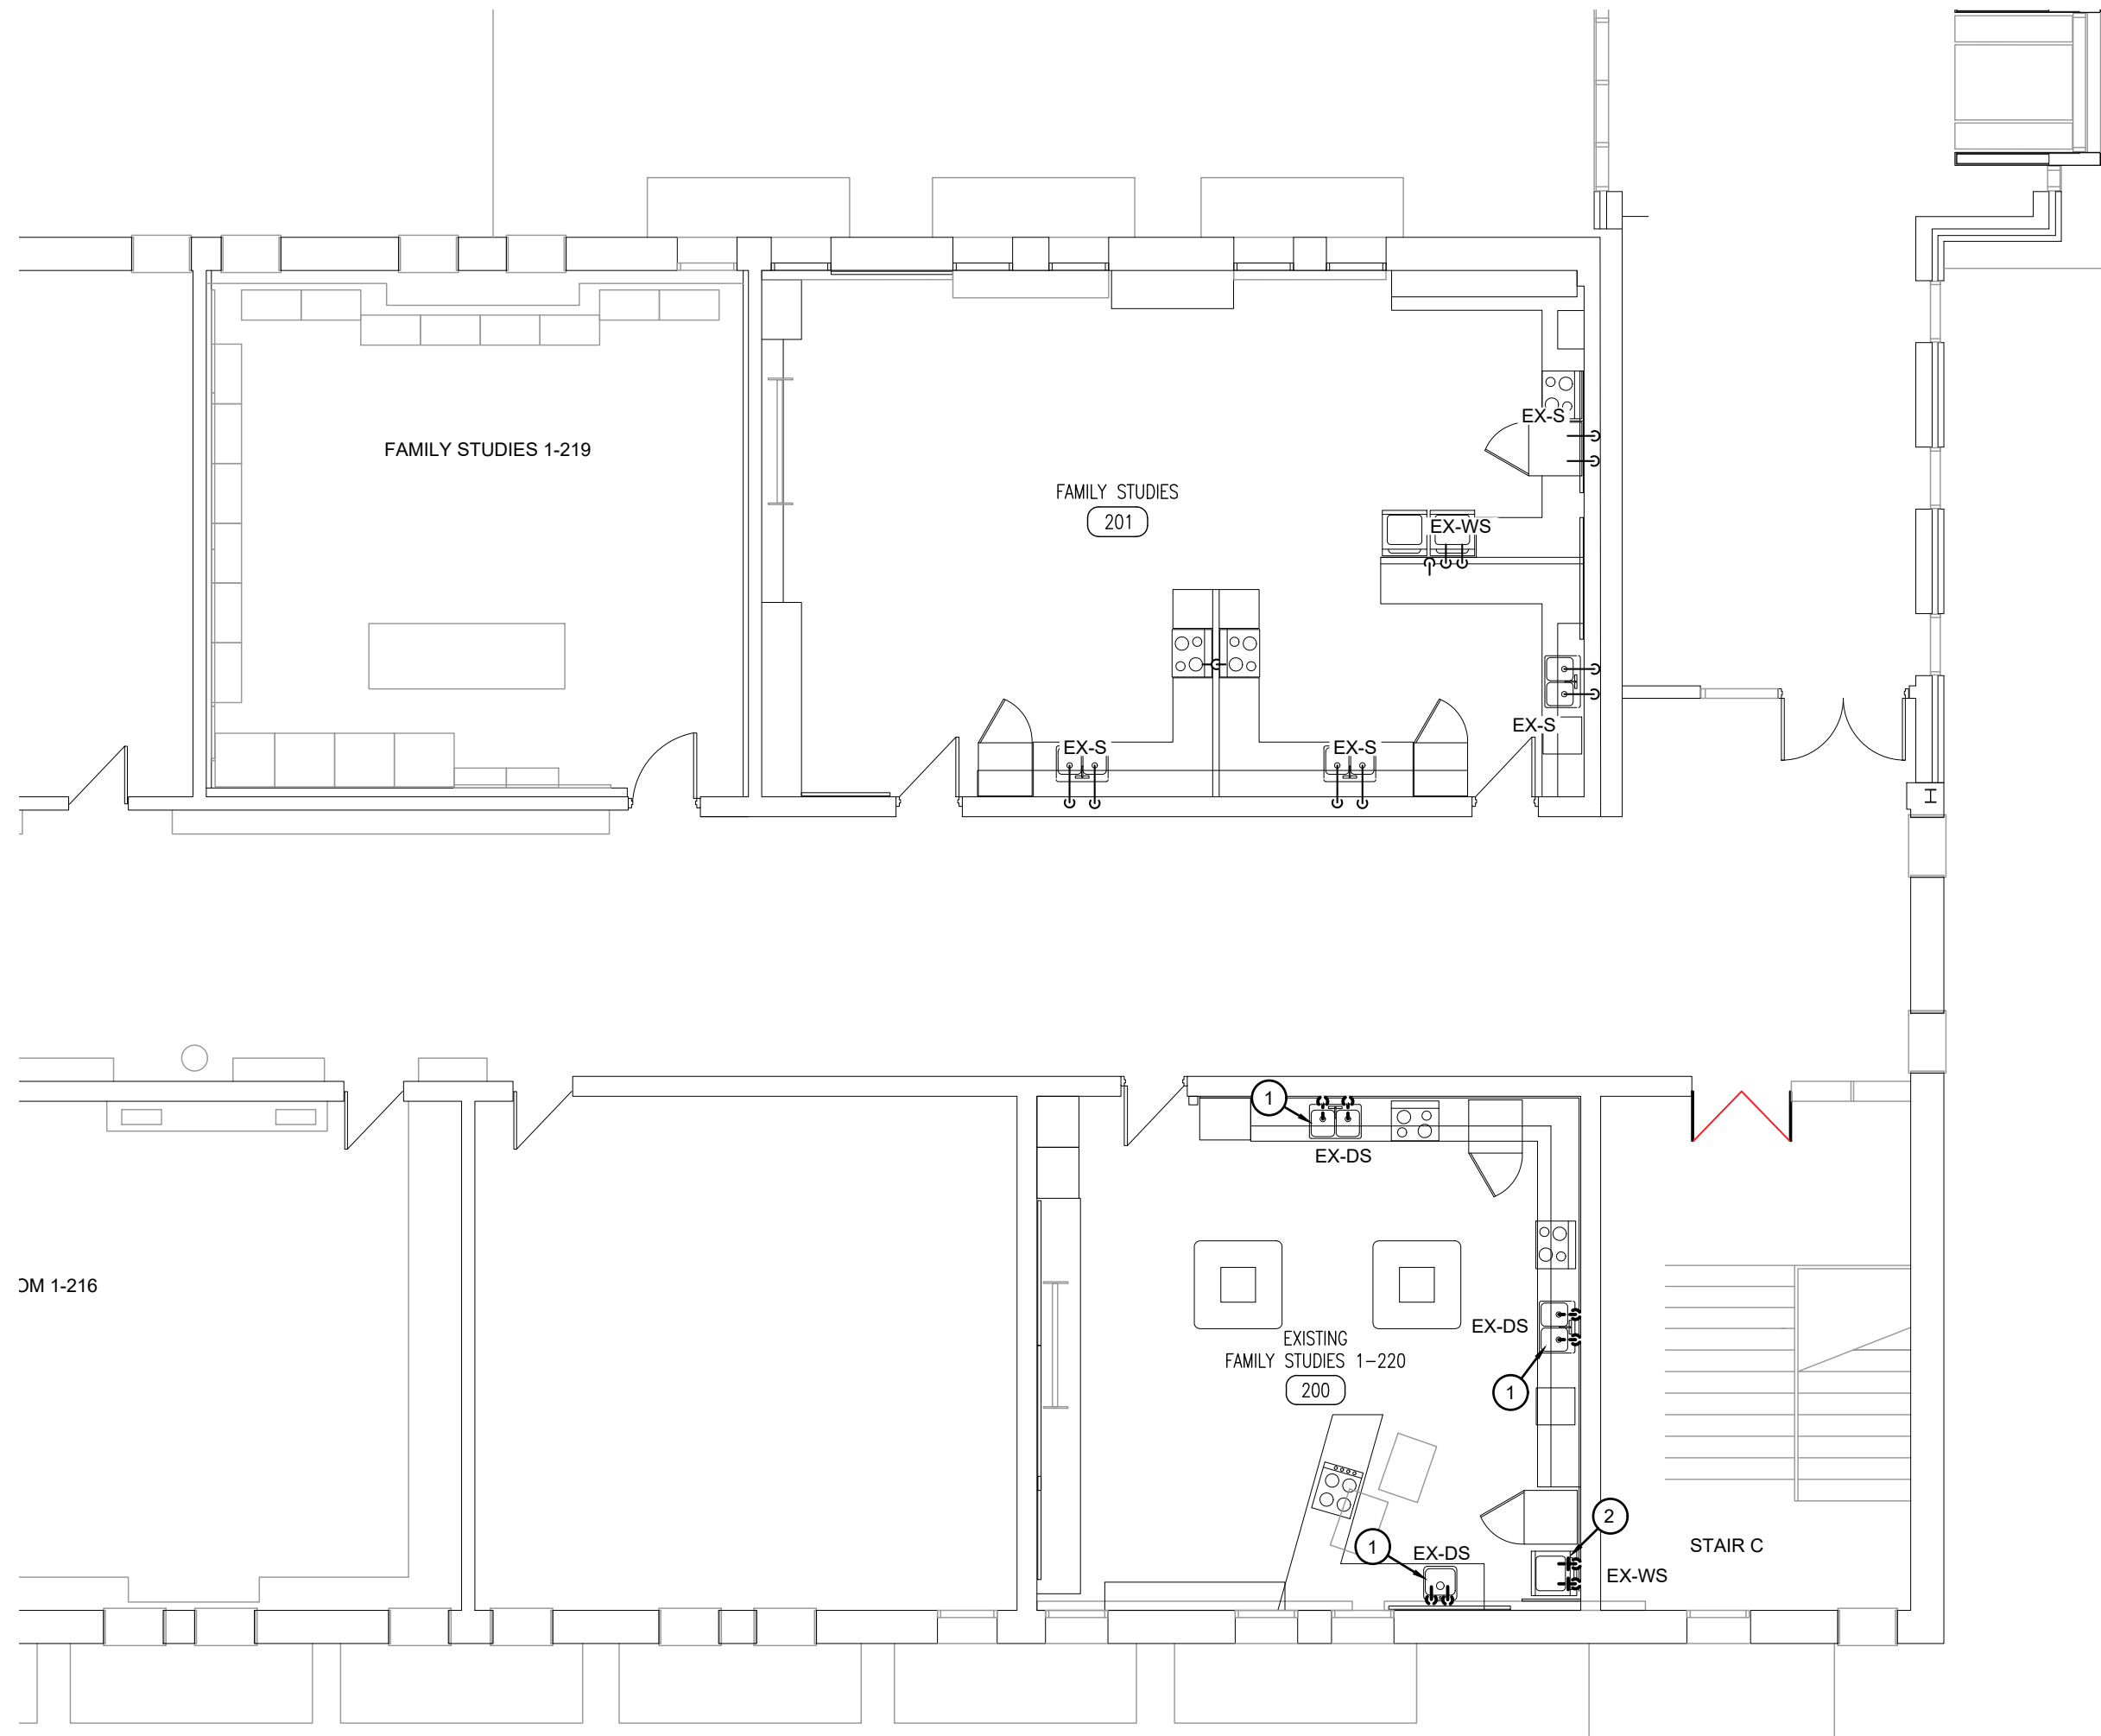

SECOND FLOOR PART PLAN 'A' - DOMESTIC DEMOLITION
SCALE: 1:100

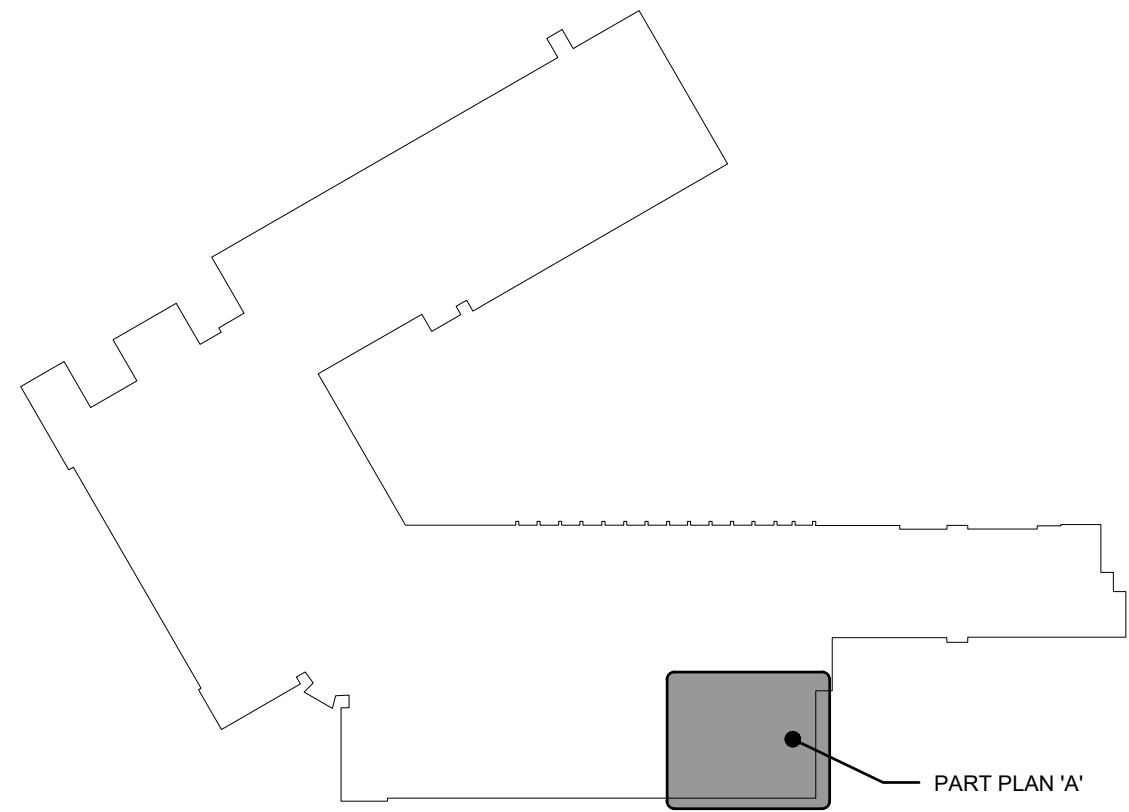

KEY PLAN

GENERAL DEMOLITION NOTES

- EXISTING MECHANICAL ITEMS NOT SHOWN SHALL REMAIN UNLESS NOTED OTHERWISE.
- EXISTING MECHANICAL ITEMS SHOWN BUT NOT NOTED AS BEING REMOVED OR RENOVATED SHALL REMAIN AS PRESENTLY INSTALLED AND OPERATING.
- THIS CONTRACTOR SHALL BE RESPONSIBLE FOR VERIFYING ON SITE ALL LOCATIONS AND SIZES OF ALL SERVICES & EQUIPMENT PRIOR TO THE COMMENCEMENT OF WORK.
- ALL OPENINGS THAT RESULT FROM THE REMOVAL OF EQUIPMENT OR SERVICES SHALL BE NEATLY PATCHED WITH SUITABLE NEW MATERIALS TO SUIT EXISTING CONSTRUCTION.
- PLUMBING VENTS ARE NOT INDICATED OR IDENTIFIED. REMOVE ALL REDUNDANT VENTS WHILE MAINTAINING INTEGRITY OF EXISTING SYSTEMS TO REMAIN.
- REMOVAL OF EXISTING PIPING, OR DUCT SYSTEMS INCLUDES REMOVAL OF ALL HANGERS, INSULATION, FITTINGS, ETC.
- MAINTAIN INTEGRITY OF EXISTING SYSTEMS THAT ARE TO REMAIN OR BE MODIFIED.
- INSTALL NEW SYSTEM OR SERVICES WHERE REQUIRED TO MAINTAIN SYSTEM OPERATION PRIOR TO DEMOLITION OF EXISTING SERVICES.
- THIS CONTRACTOR IS TO REMOVE & REPLACE CEILINGS AS REQUIRED FOR REMOVAL/REPLACEMENT OF SERVICES.

SPECIFIC DEMOLITION NOTES

- EXISTING PLUMBING FIXTURE TO BE REMOVED COMPLETE. EXISTING DRAINAGE AND DOMESTIC PIPING CUT, CAPPED AND REMOVED BEYOND COMPLETE.
- EXISTING PLUMBING FIXTURE TO BE REMOVED COMPLETE. EXISTING DRAINAGE AND DOMESTIC PIPING CUT AT WALL/FLOOR AND REMOVED BEYOND COMPLETE.
- EXISTING DOMESTIC PIPING TO BE CUT, CAPPED AND REMOVED BEYOND COMPLETE.

NOTE:
The contractor shall verify all dimensions and report all errors and discrepancies to the Consultant before commencement of the work.
The drawings show general arrangement of services. Follow as closely as actual building construction will permit. Obtain approval for relocation of service from Consultant before commencement of the work.
The drawings do not indicate all offsets fitting and accessories which may be required. Provide the same to meet the required conditions.
Drawings and specifications, etc., prepared and issued by the Consultant are the property of the Consultant and must be returned at the completion of the project. These documents are not to be duplicated or copied without the consent of the Consultant.
Do not scale this drawing.
© 2026 DEI Consulting Engineers Inc.

DEI
Consulting Engineers
MECHANICAL | ELECTRICAL | AQUATIC
55 Northland Road, Waterloo, ON N2V 2Y8
Phone: 519-745-3553
Website: deiassociates.ca
Project Number: 2602

01	ISSUED FOR PERMIT AND TENDER	2025.04.10
No.	REVISIONS	date
PROJECT NORTH		TRUE NORTH
Scale		AS NOTED


LICENSED PROFESSIONAL ENGINEER
10 Apr 26
M.B. WHITE
10014907
PROVINCE OF ONTARIO
drawn by AP
last worked on by AP
2026.03.17
checked by SO
print date 4.10.2026

BJC
architects + assoc's. inc.


client
WATERLOO REGION DISTRICT SCHOOL BOARD
51 ARDELT AVE KITCHENER ONTARIO
project
GRAND RIVER COLLEGIATE INSTITUTE RENOVATION
175 INDIAN RD KITCHENER ONTARIO

drawing title
FIRST & SECOND FLOOR PART PLANS - DEMOLITION


reference
project no. 25-092 client reference number
sheet no. **M20200**

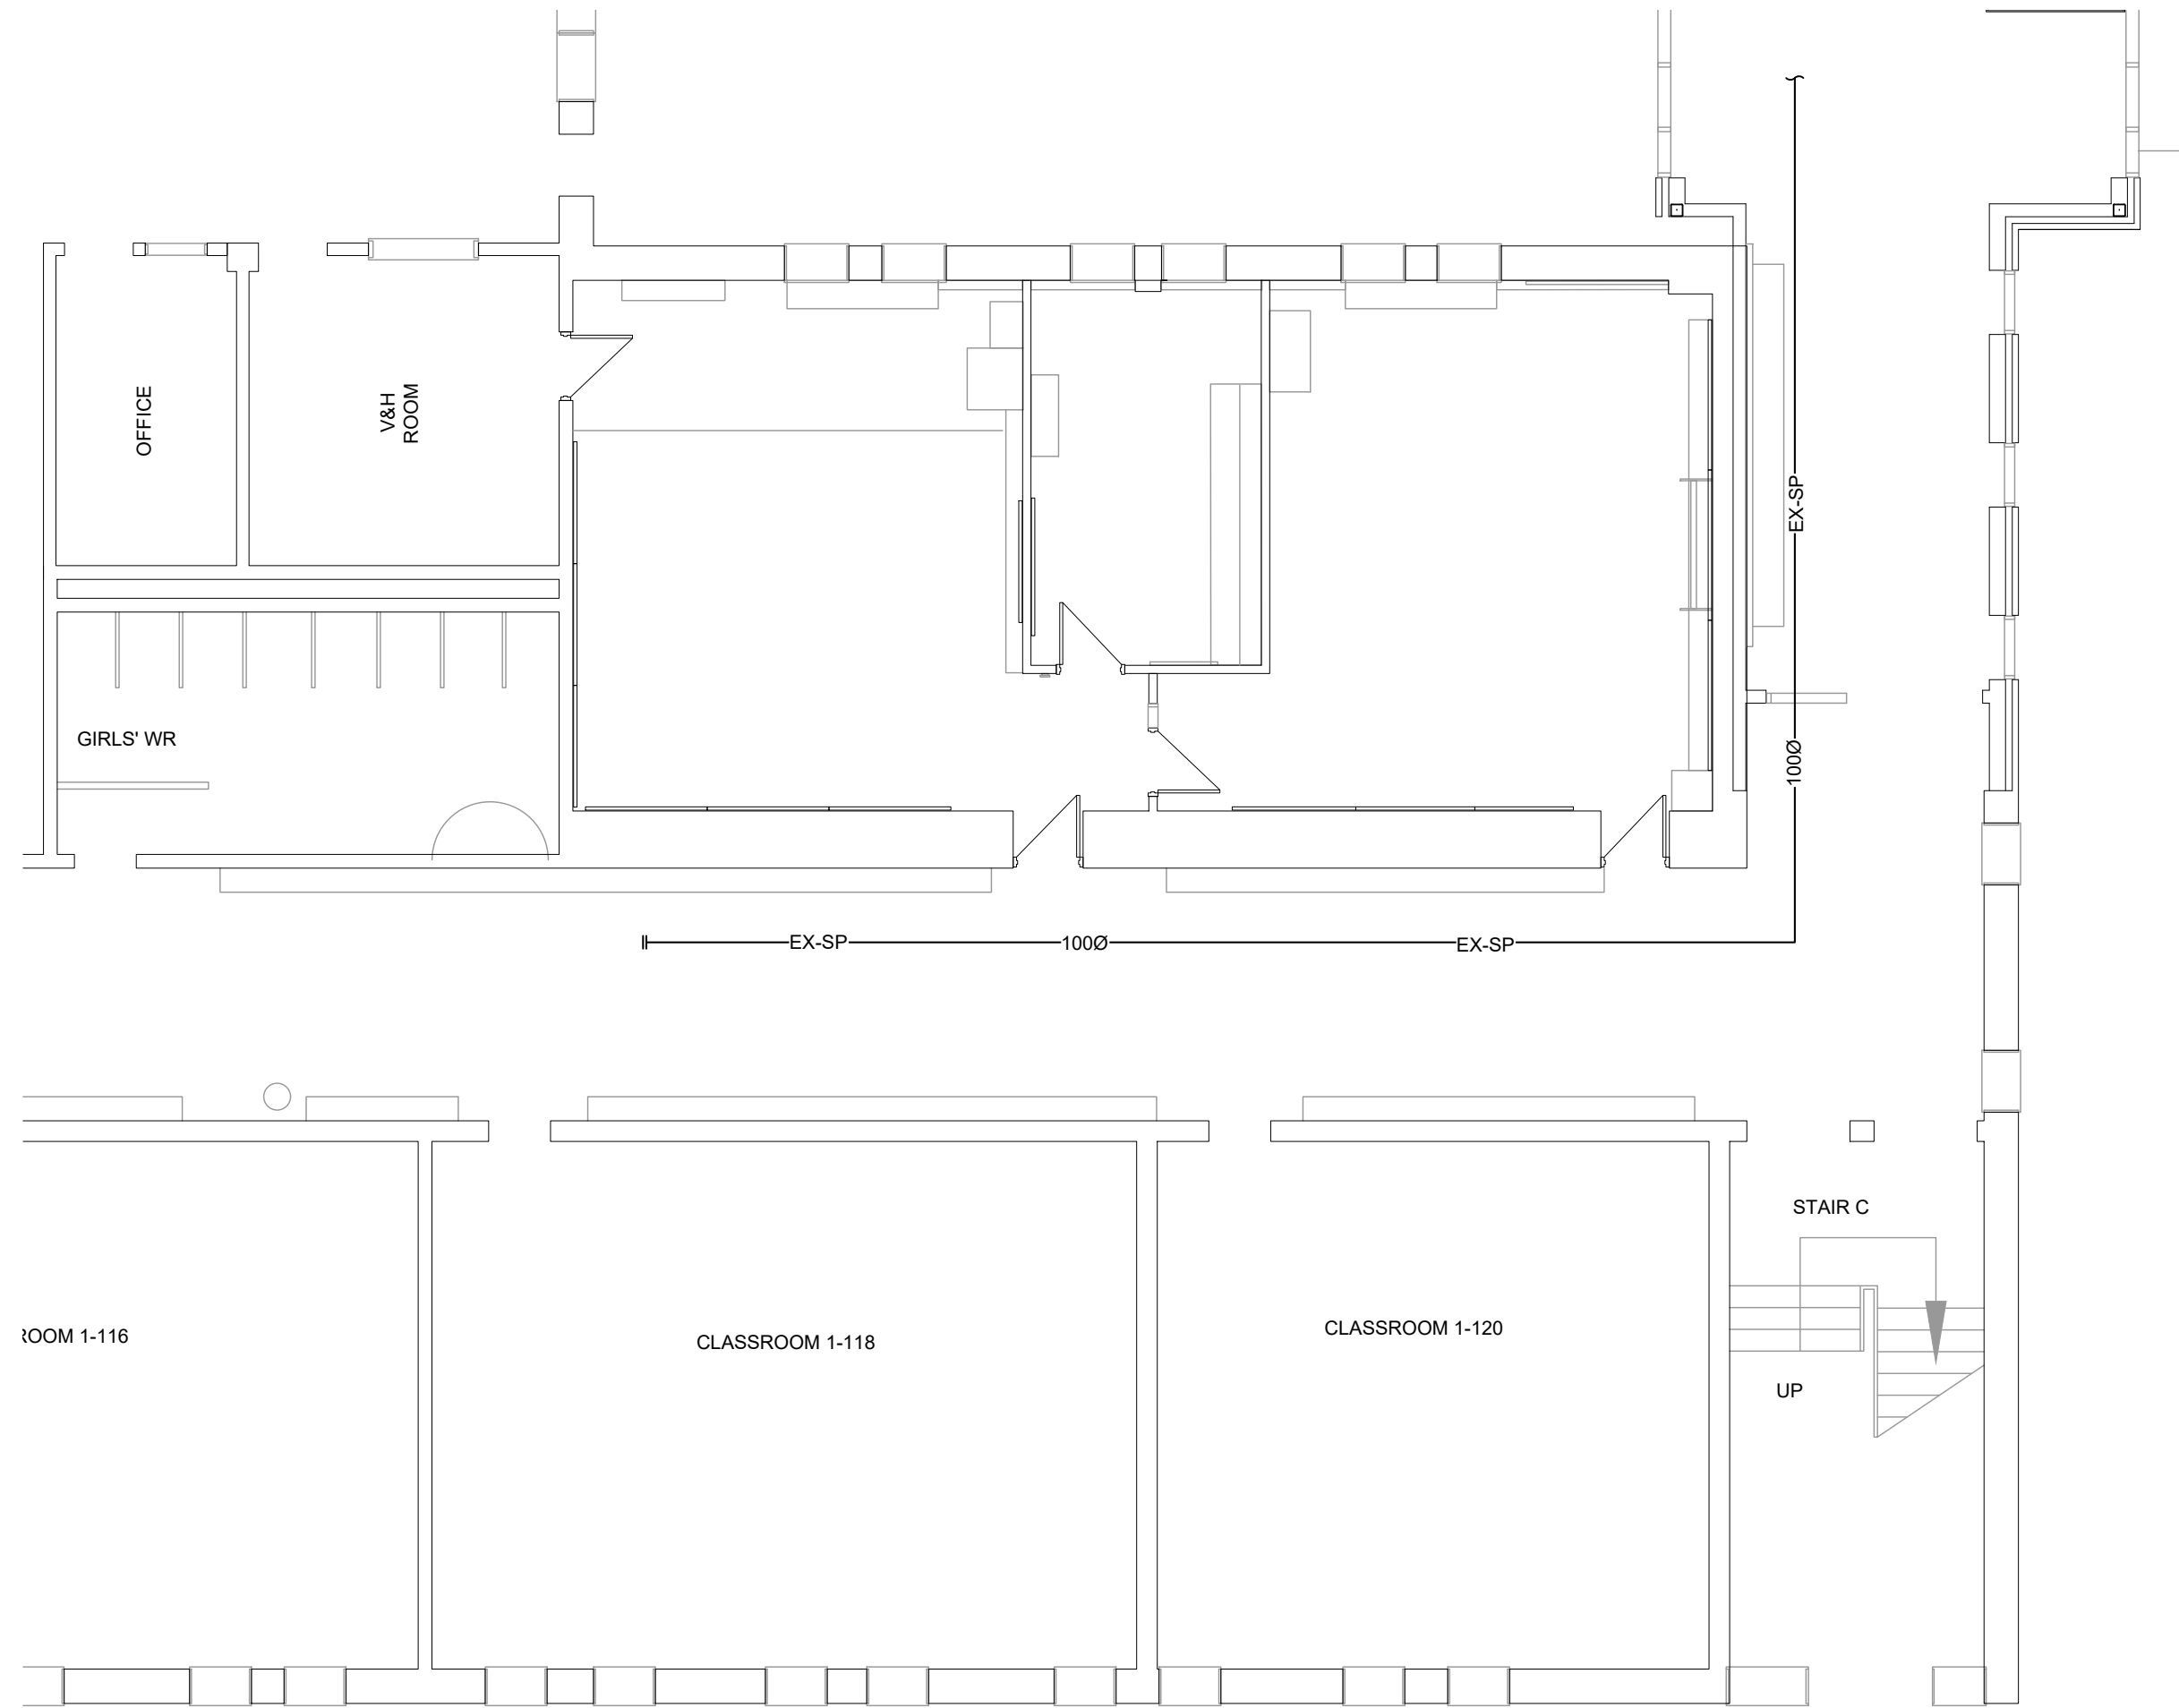


FIRST FLOOR PART PLAN 'A' - SPRINKLER DEMOLITION
SCALE: 1:100

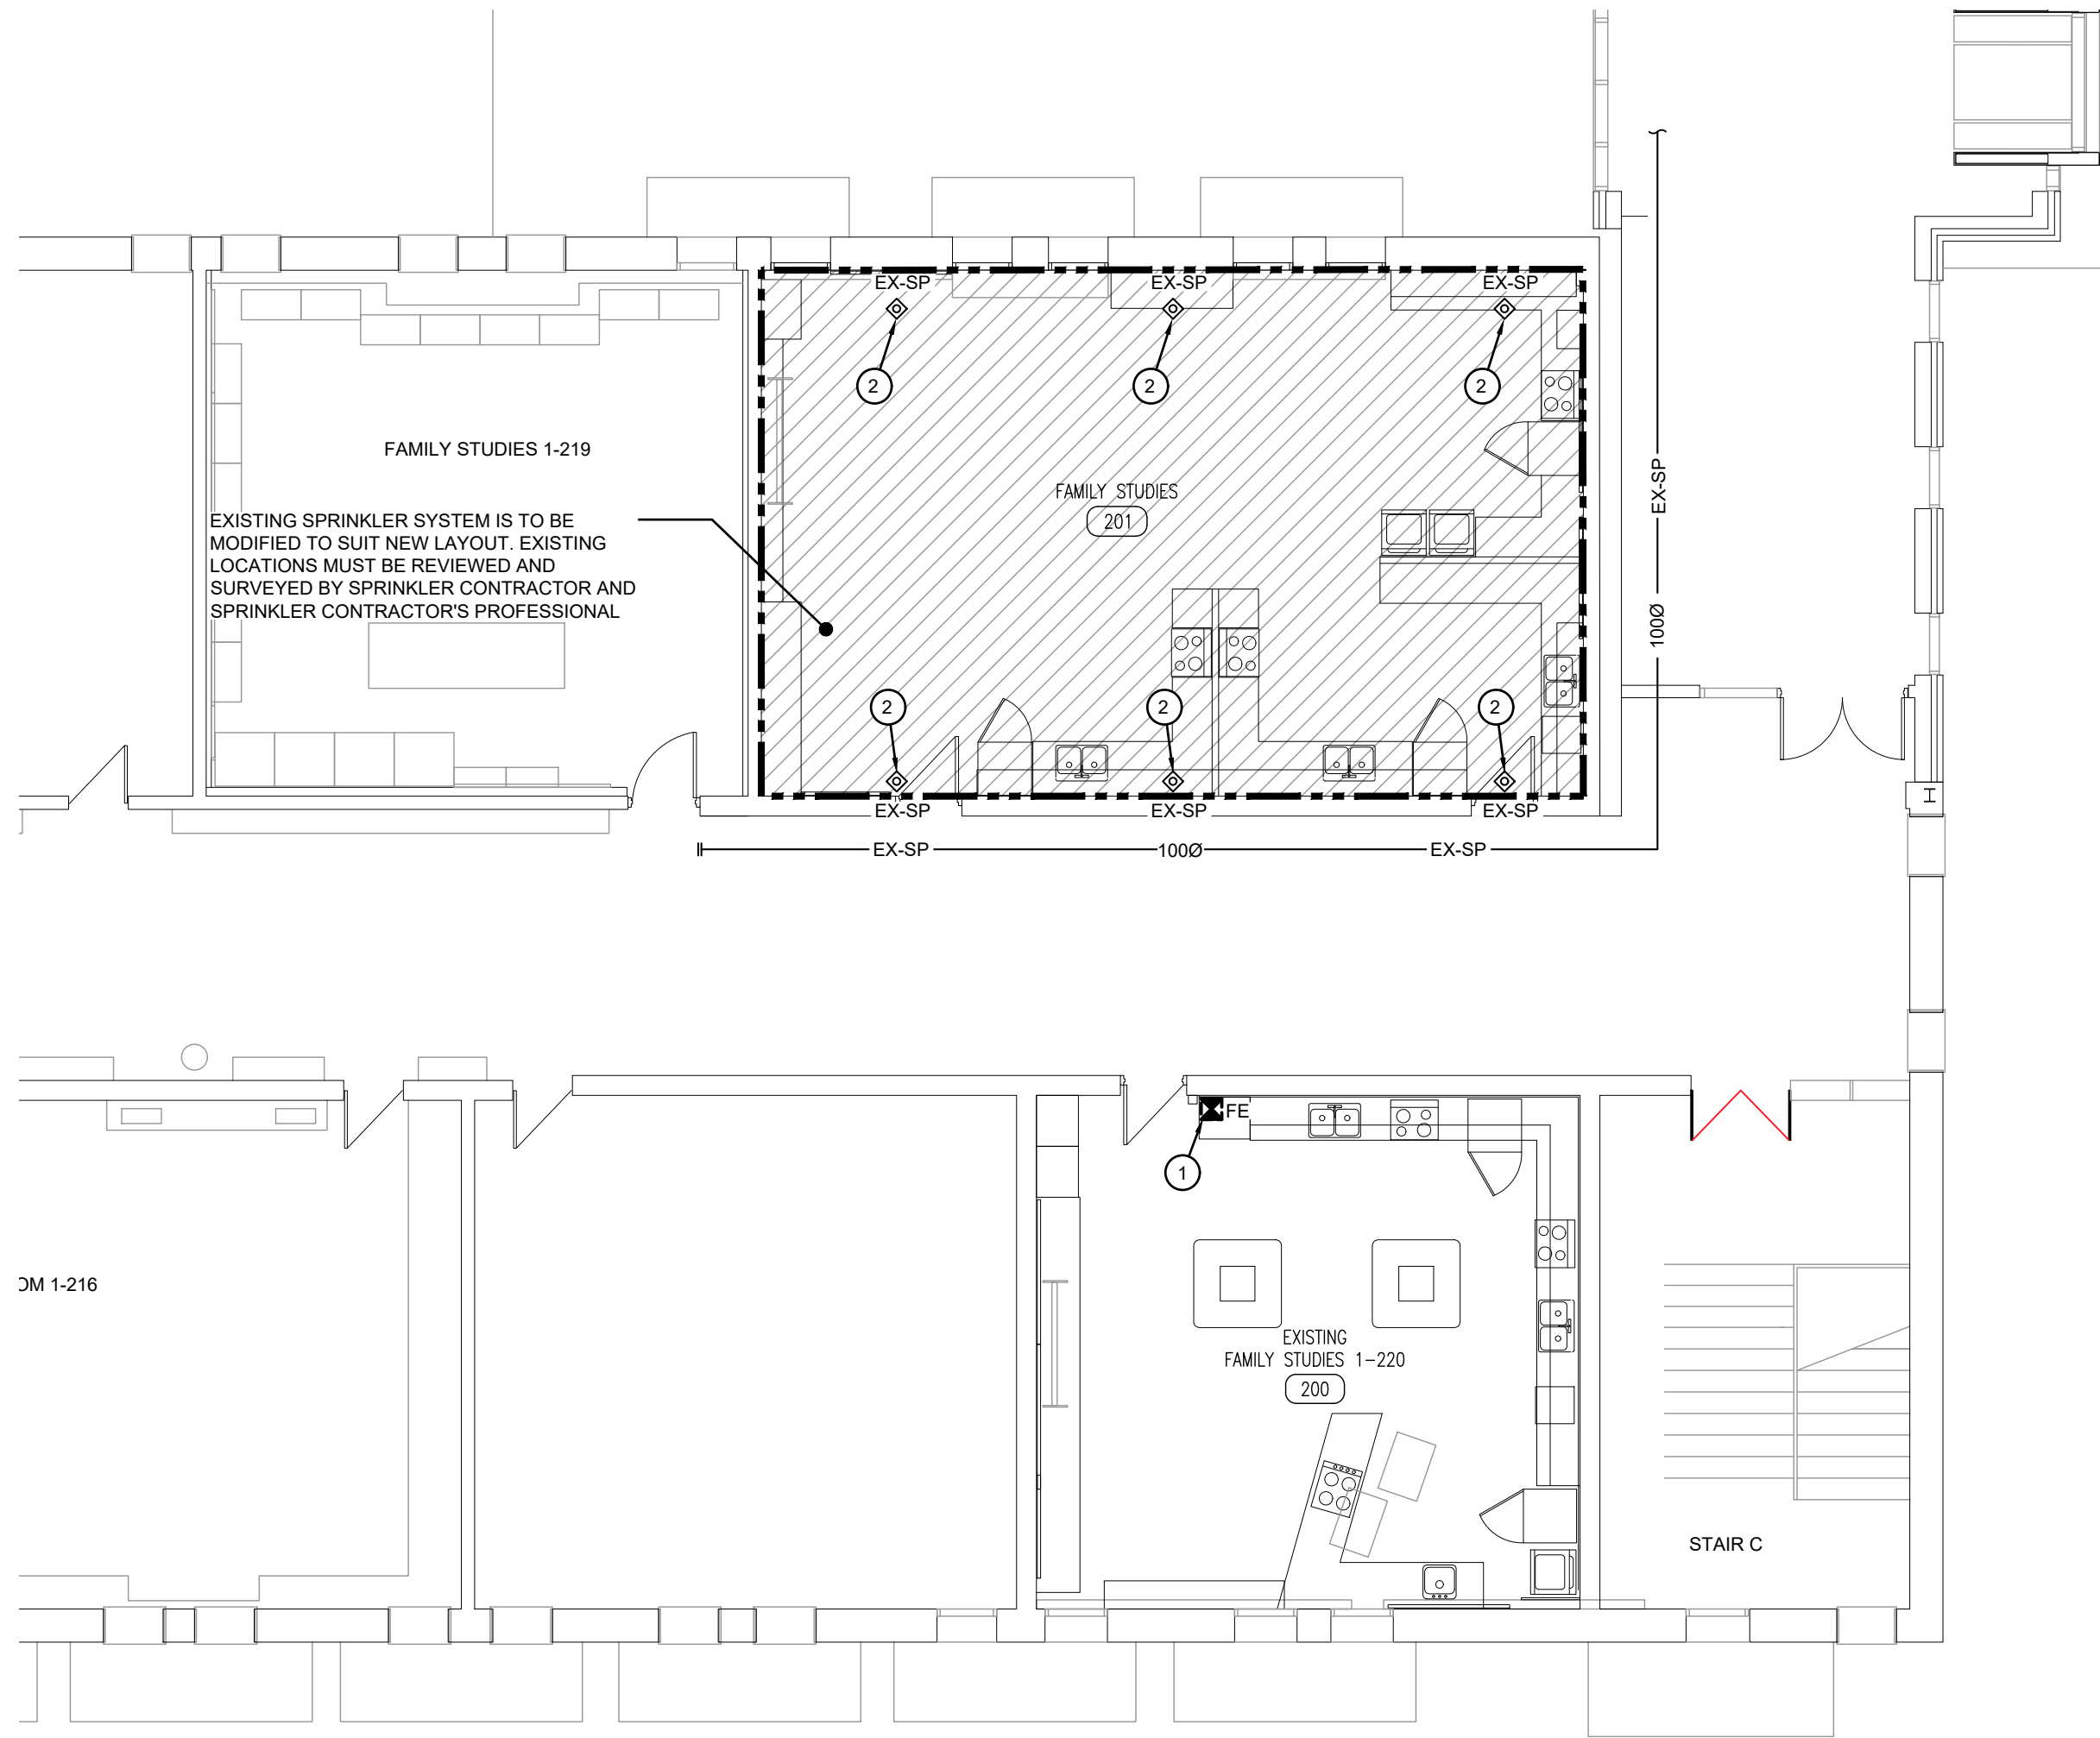

SECOND FLOOR PART PLAN 'A' - SPRINKLER DEMOLITION
SCALE: 1:100

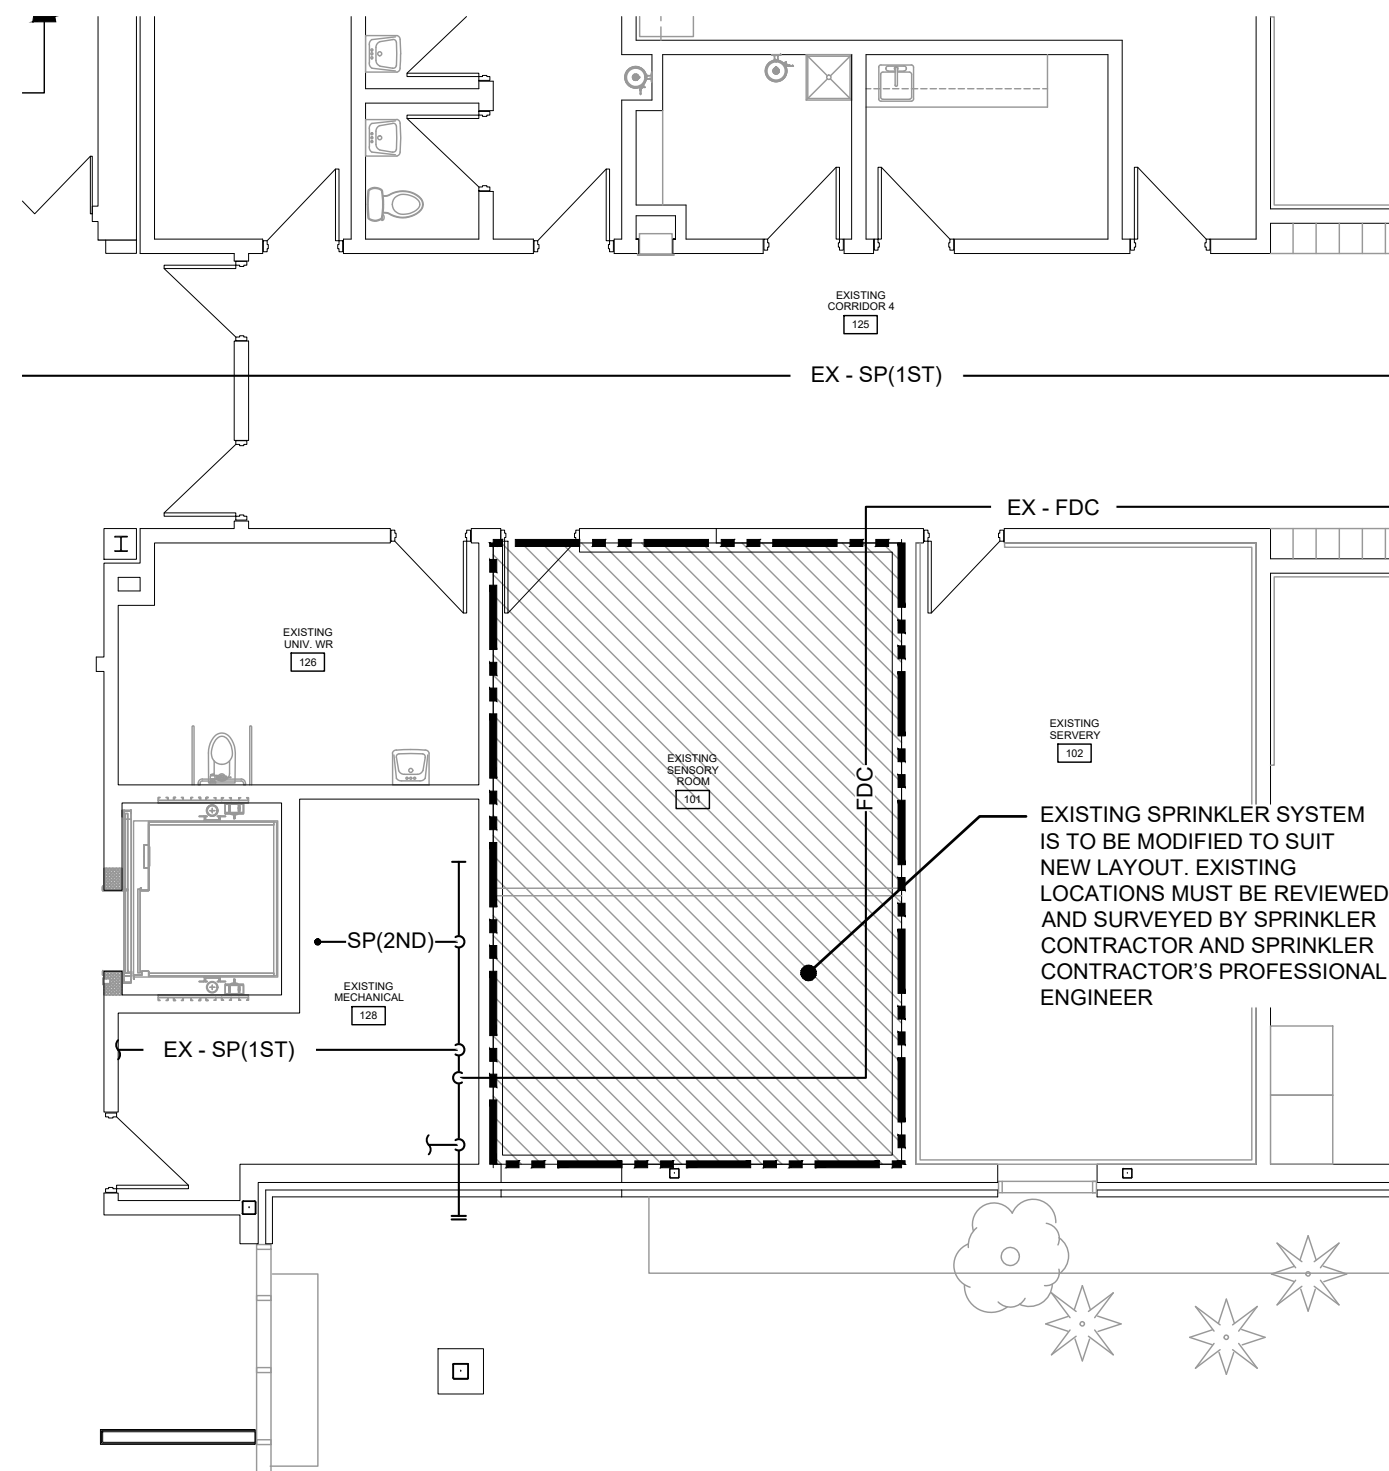

FIRST FLOOR PART PLAN 'B'- SPRINKLER DEMOLITION
SCALE: 1:100

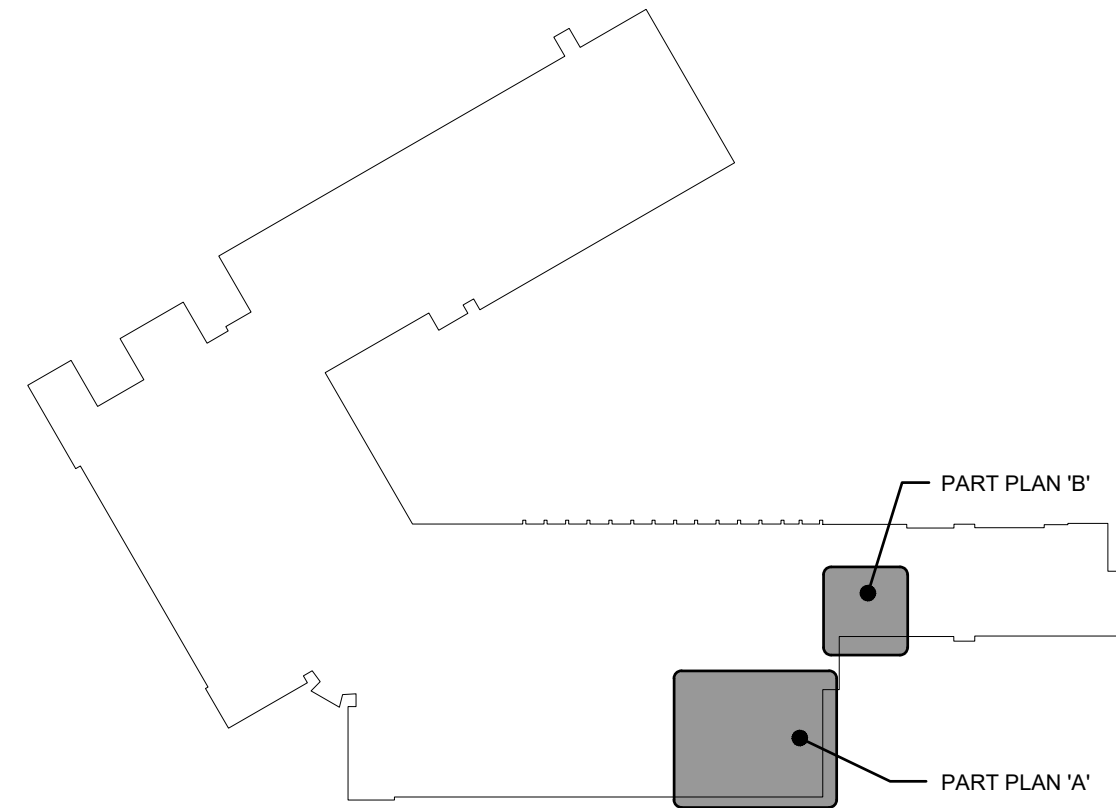

KEY PLAN



GENERAL DEMOLITION NOTES

- EXISTING MECHANICAL ITEMS NOT SHOWN SHALL REMAIN UNLESS NOTED OTHERWISE.
- EXISTING MECHANICAL ITEMS SHOWN BUT NOT NOTED AS BEING REMOVED OR RENOVATED SHALL REMAIN AS PRESENTLY INSTALLED AND OPERATING.
- THIS CONTRACTOR SHALL BE RESPONSIBLE FOR VERIFYING ON SITE ALL LOCATIONS AND SIZES OF ALL SERVICES & EQUIPMENT PRIOR TO THE COMMENCEMENT OF WORK.
- ALL OPENINGS THAT RESULT FROM THE REMOVAL OF EQUIPMENT OR SERVICES SHALL BE NEATLY PATCHED WITH SUITABLE NEW MATERIALS TO SUIT EXISTING CONSTRUCTION.
- PLUMBING VENTS ARE NOT INDICATED OR IDENTIFIED. REMOVE ALL REDUNDANT VENTS WHILE MAINTAINING INTEGRITY OF EXISTING SYSTEMS TO REMAIN.
- REMOVAL OF EXISTING PIPING, OR DUCT SYSTEMS INCLUDES REMOVAL OF ALL HANGERS, INSULATION, FITTINGS, ETC.
- MAINTAIN INTEGRITY OF EXISTING SYSTEMS THAT ARE TO REMAIN OR BE MODIFIED.
- INSTALL NEW SYSTEM OR SERVICES WHERE REQUIRED TO MAINTAIN SYSTEM OPERATION PRIOR TO DEMOLITION OF EXISTING SERVICES.
- THIS CONTRACTOR IS TO REMOVE & REPLACE CEILINGS AS REQUIRED FOR REMOVAL/REPLACEMENT OF SERVICES.

SPECIFIC DEMOLITION NOTES


- EXISTING FIRE EXTINGUISHER BEING REMOVED COMPLETE.
- EXISTING SPRINKLER HEAD(S) TO BE REMOVED & REPLACE W/ NEW SPRINKLER HEAD TO NFPA REQUIREMENTS.

NOTE:
The contractor shall verify all dimensions and report all errors and discrepancies to the Consultant before commencement of the work.
The drawings show general arrangement of services. Follow as closely as actual building construction will permit. Obtain approval for relocation of service from Consultant before commencement of the work.
The drawings do not indicate all offsets fitting and accessories which may be required. Provide the same to meet the required conditions.
Drawings and specifications, etc., prepared and issued by the Consultant are the property of the Consultant and must be returned at the completion of the project. These documents are not to be duplicated or copied without the consent of the Consultant.
Do not scale this drawing.
© 2026 DEI Consulting Engineers Inc.

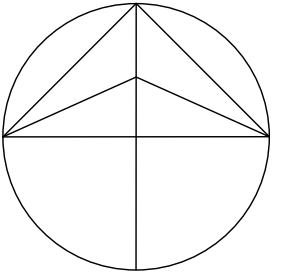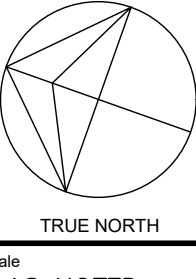
01	ISSUED FOR PERMIT AND TENDER	2025.04.10
No.	REVISIONS	date
		
PROJECT NORTH		TRUE NORTH
Scale		AS NOTED

	drawn	AP
	last worked on	2026.03.17
	checked	SO
	print date	4.10.2026


client	WATERLOO REGION DISTRICT SCHOOL BOARD
51 ARDELT AVE KITCHENER	ONTARIO
project	GRAND RIVER COLLEGIATE INSTITUTE RENOVATION
175 INDIAN RD KITCHENER	ONTARIO

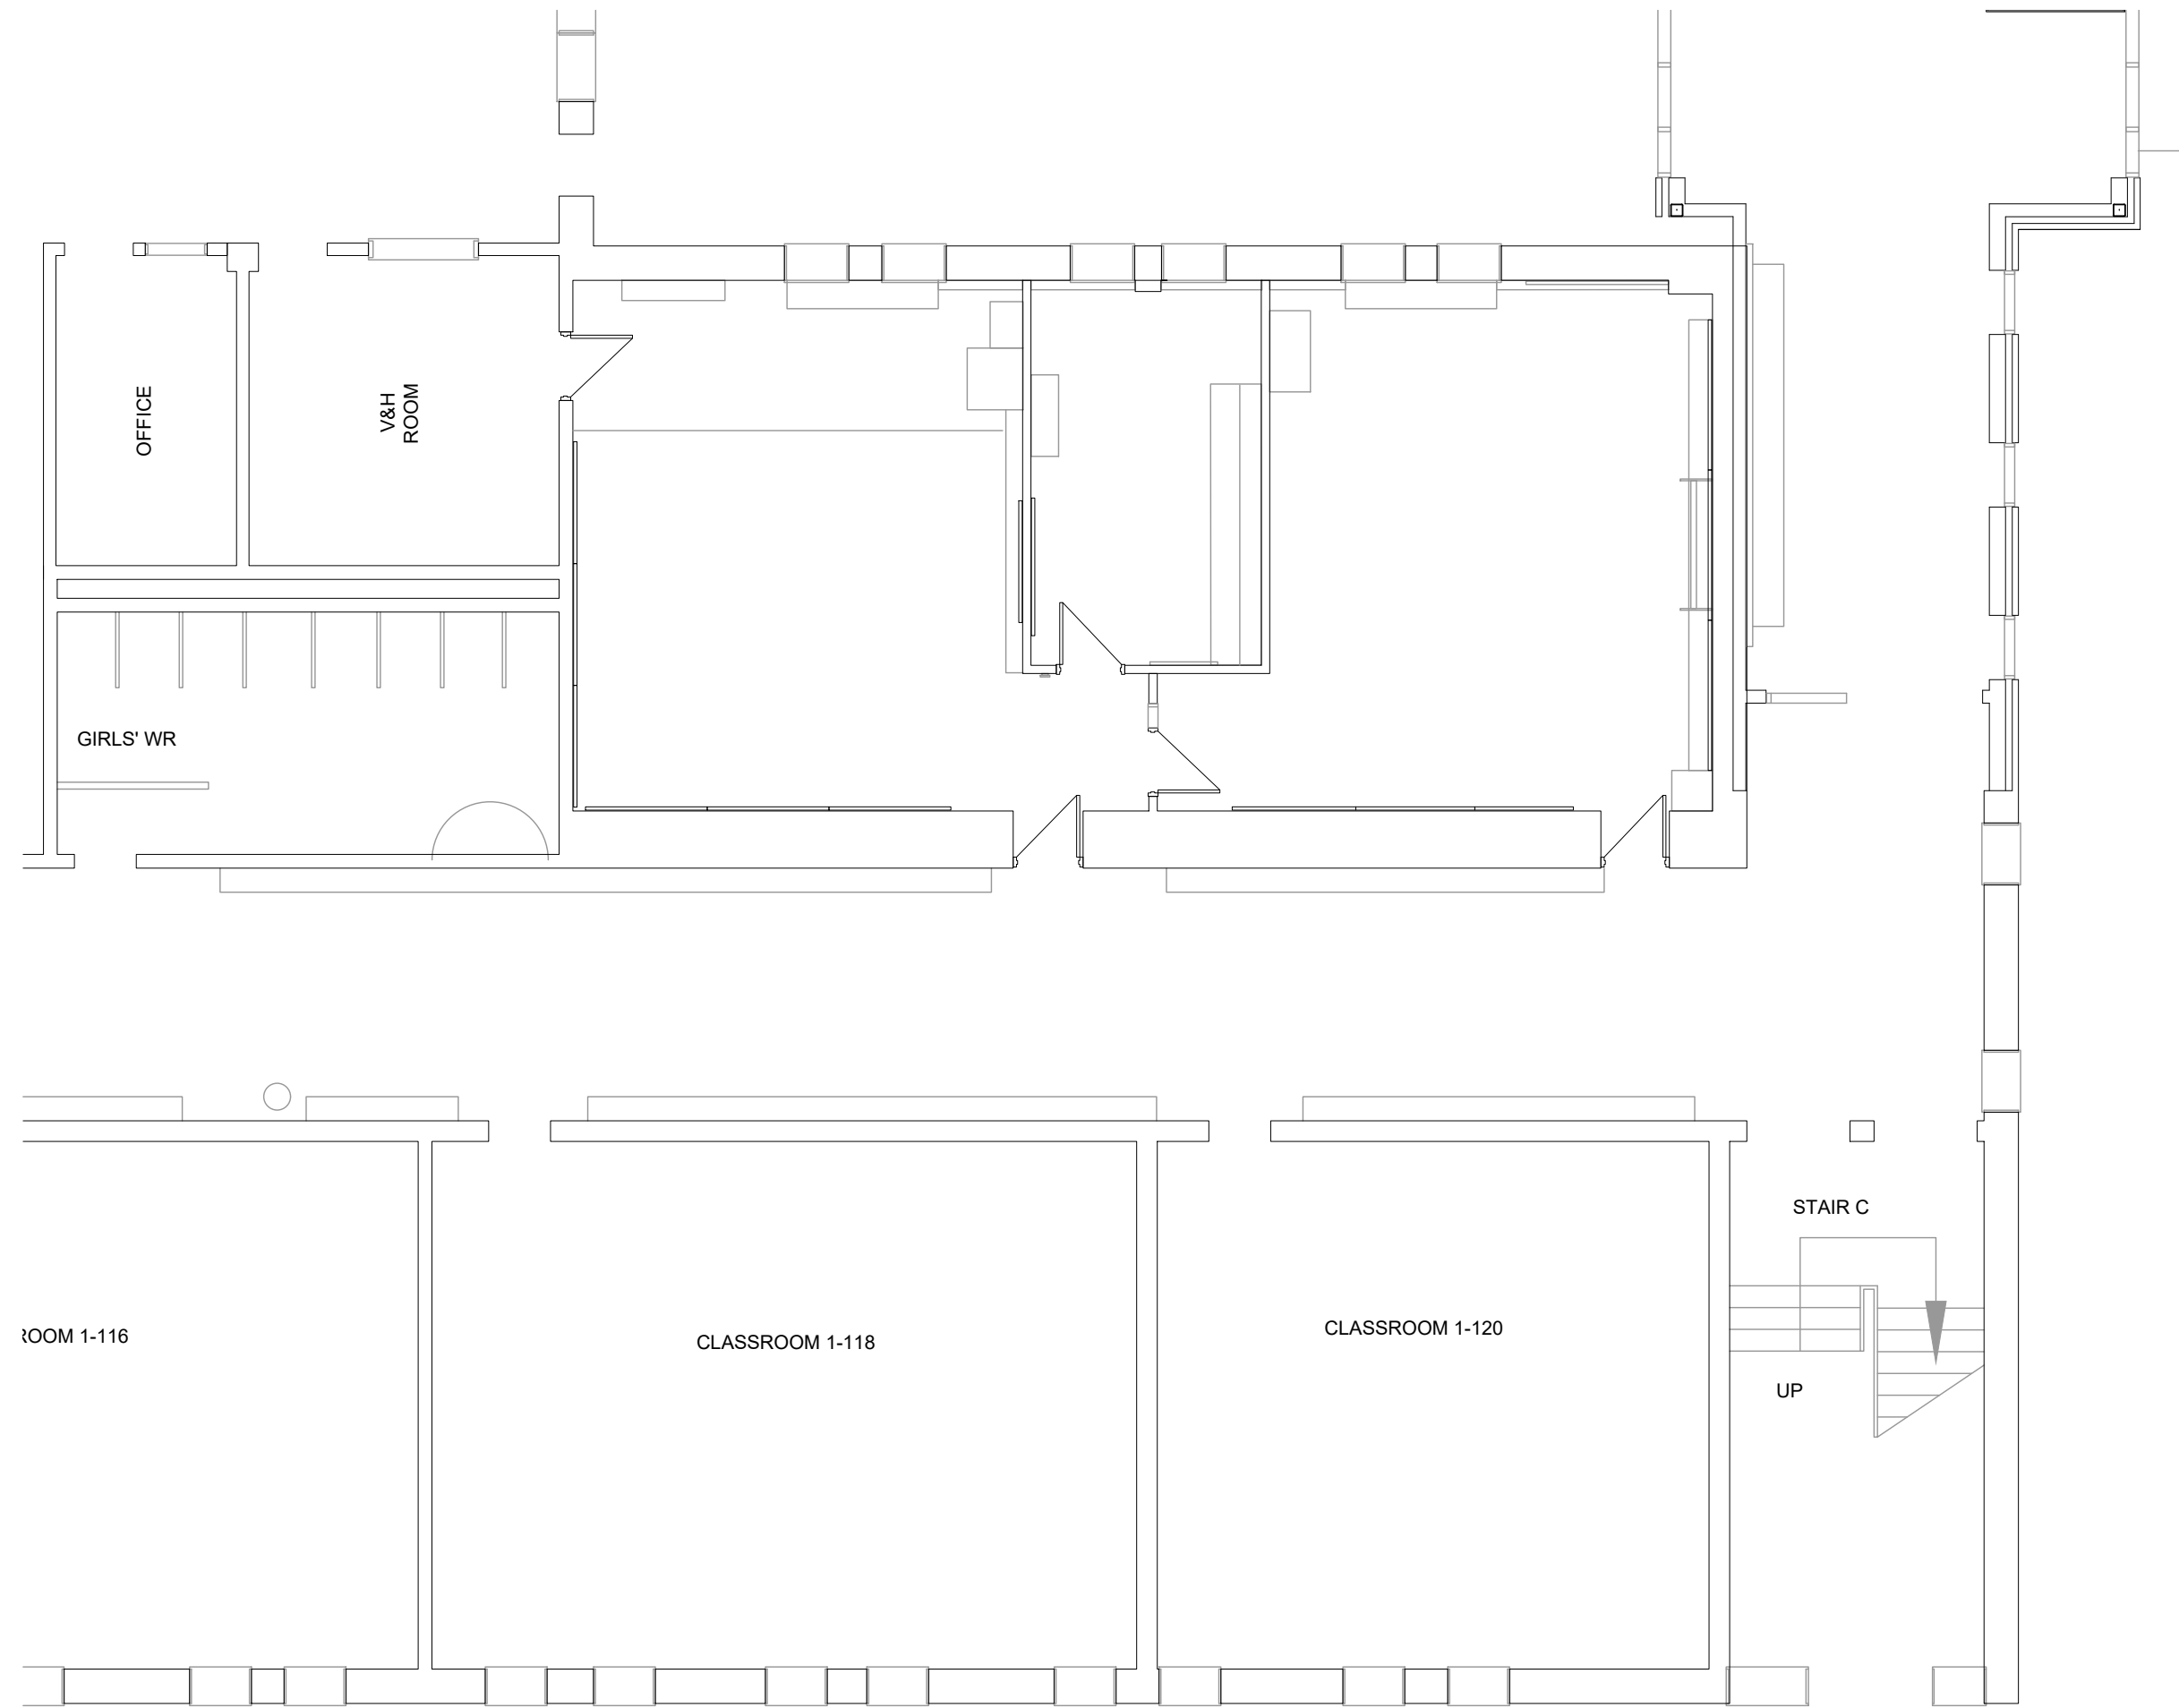


FIRST FLOOR PART PLAN 'A' - VENTILATION DEMOLITION
SCALE: 1:100

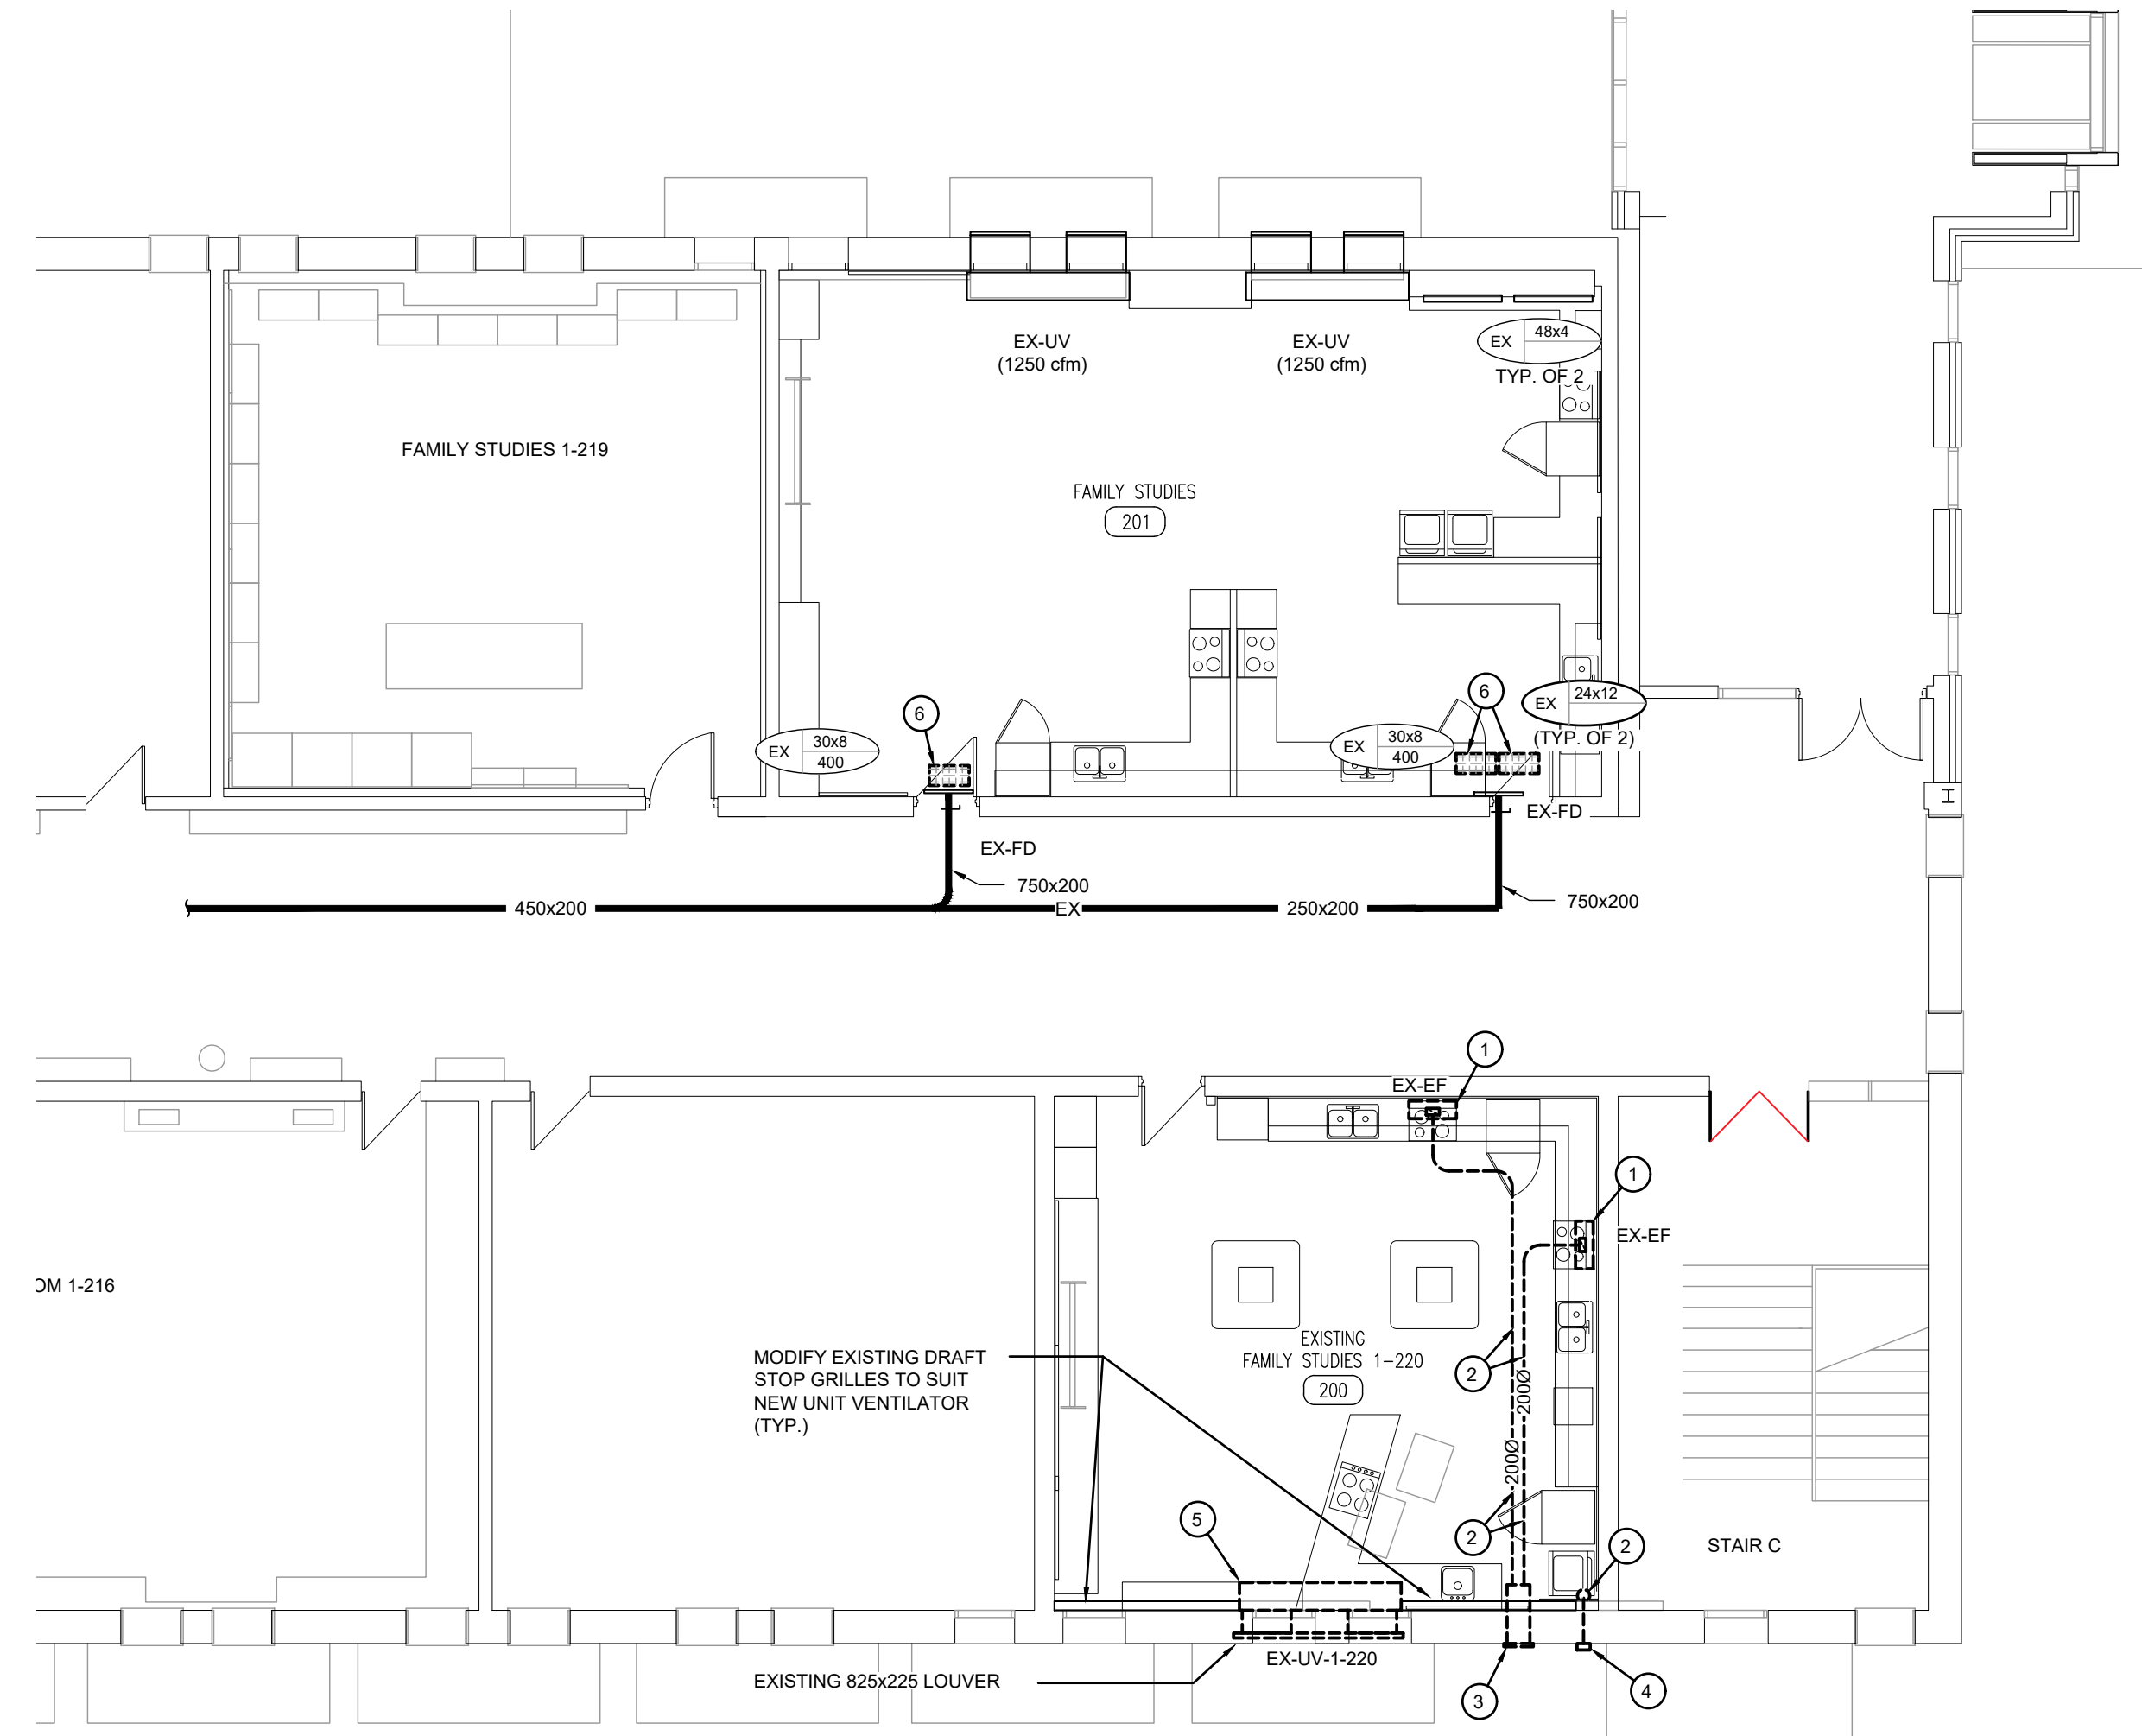

SECOND FLOOR PART PLAN 'A' - VENTILATION DEMOLITION
SCALE: 1:100

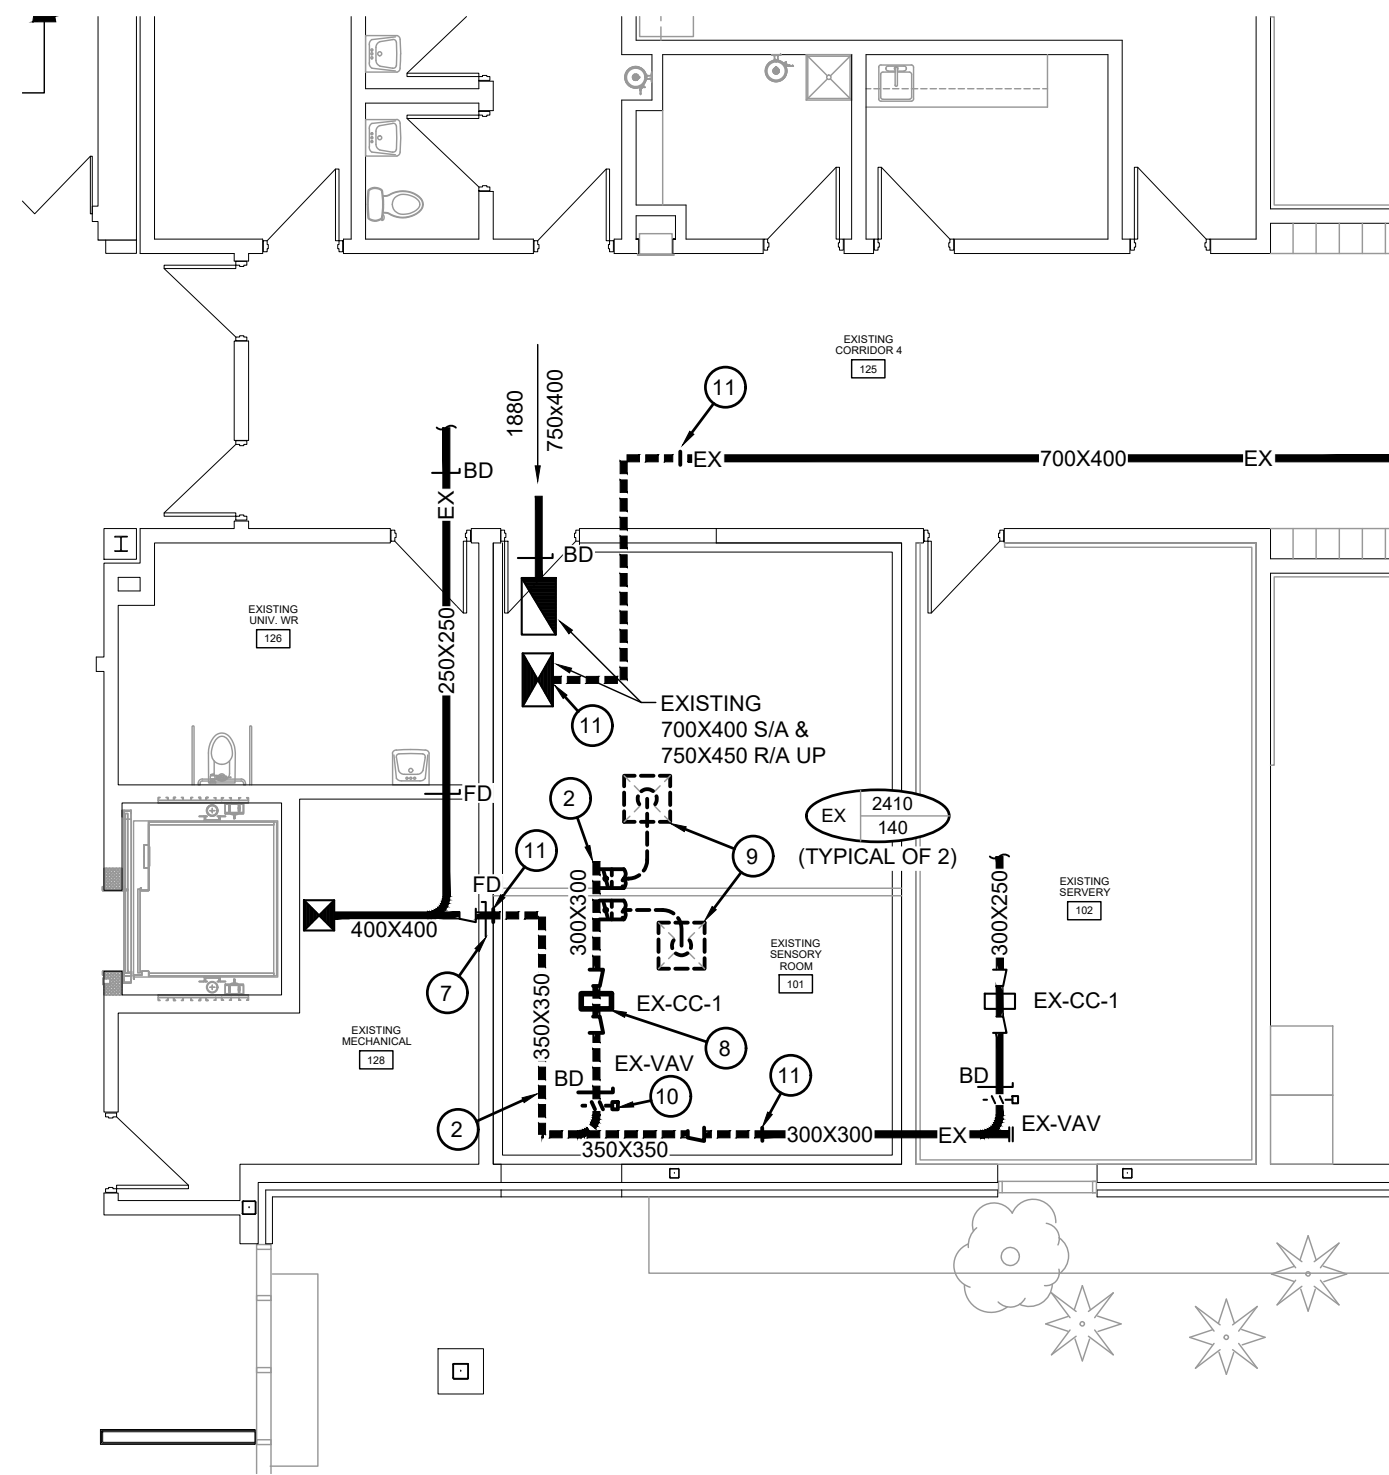

FIRST FLOOR PART PLAN 'B' - VENTILATION DEMOLITION
SCALE: 1:100

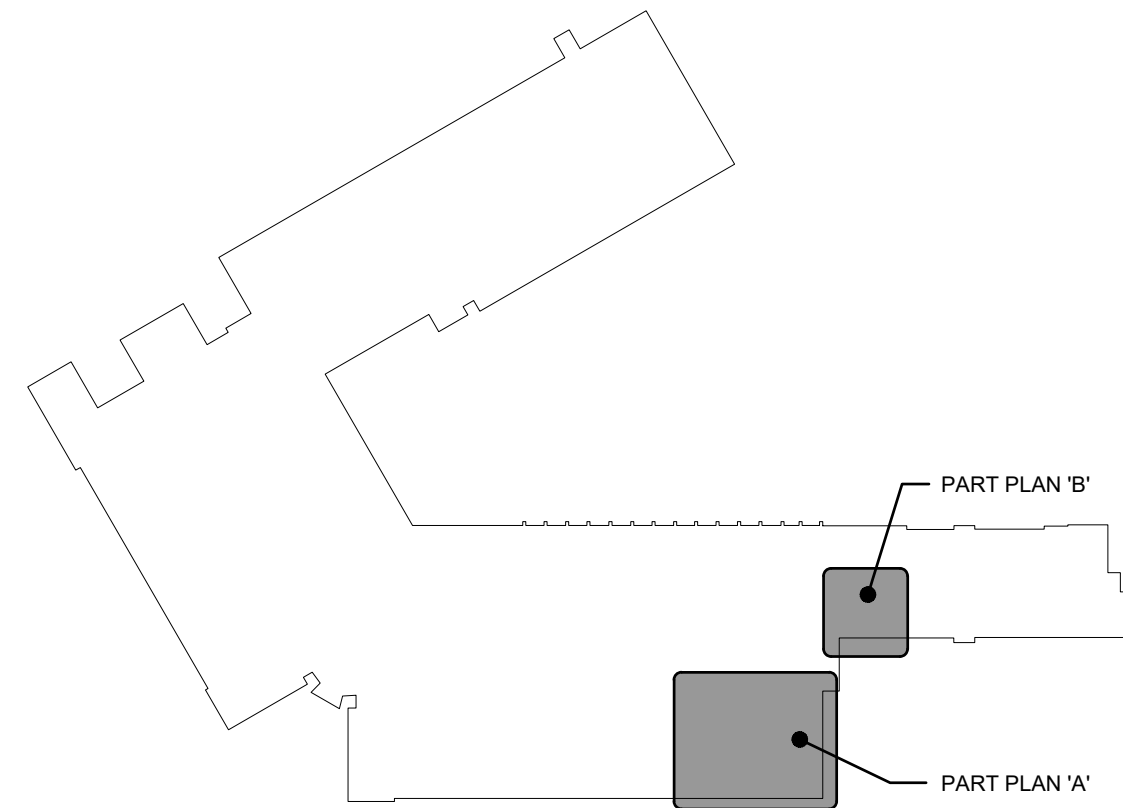

KEY PLAN



GENERAL DEMOLITION NOTES

- EXISTING MECHANICAL ITEMS NOT SHOWN SHALL REMAIN UNLESS NOTED OTHERWISE.
- EXISTING MECHANICAL ITEMS SHOWN BUT NOT NOTED AS BEING REMOVED OR RENOVATED SHALL REMAIN AS PRESENTLY INSTALLED AND OPERATING.
- THIS CONTRACTOR SHALL BE RESPONSIBLE FOR VERIFYING ON SITE ALL LOCATIONS AND SIZES OF ALL SERVICES & EQUIPMENT PRIOR TO THE COMMENCEMENT OF WORK.
- ALL OPENINGS THAT RESULT FROM THE REMOVAL OF EQUIPMENT OR SERVICES SHALL BE NEATLY PATCHED WITH SUITABLE NEW MATERIALS TO SUIT EXISTING CONSTRUCTION.
- PLUMBING VENTS ARE NOT INDICATED OR IDENTIFIED. REMOVE ALL REDUNDANT VENTS WHILE MAINTAINING INTEGRITY OF EXISTING SYSTEMS TO REMAIN.
- REMOVAL OF EXISTING PIPING, OR DUCT SYSTEMS INCLUDES REMOVAL OF ALL HANGERS, INSULATION, FITTINGS, ETC.
- MAINTAIN INTEGRITY OF EXISTING SYSTEMS THAT ARE TO REMAIN OR BE MODIFIED.
- INSTALL NEW SYSTEM OR SERVICES WHERE REQUIRED TO MAINTAIN SYSTEM OPERATION PRIOR TO DEMOLITION OF EXISTING SERVICES.
- THIS CONTRACTOR IS TO REMOVE & REPLACE CEILINGS AS REQUIRED FOR REMOVAL/REPLACEMENT OF SERVICES.

SPECIFIC DEMOLITION NOTES

- EXISTING EXHAUST FAN TO BE REMOVED COMPLETE.
- EXISTING DUCTWORK TO BE REMOVED BEYOND COMPLETE.
- EXISTING BRICK VENT TO BE REMOVED BEYOND COMPLETE.
- EXISTING DRYER WALL VENT TO BE REMOVED COMPLETE.
- EXISTING UNIT VENTILATOR TO BE REMOVED COMPLETE. EXISTING LOUVERS & SLEEVE TO BE REMOVED COMPLETE.
- EXISTING GRILLES TO BE REMOVED COMPLETE.
- EXISTING FIRE DAMPER TO BE REMOVED COMPLETE.
- EXISTING COOLING COIL TO BE DISCONNECT AND RELOCATED.
- EXISTING DIFFUSER TO BE DISCONNECTED AND RELOCATED.
- EXISTING VAV CONTROL DAMPER TO BE DISCONNECTED AND RELOCATED.
- EXISTING DUCTWORK TO BE CUT AND REMOVED BEYOND COMPLETE.

NOTE:
The contractor shall verify all dimensions and report all errors and discrepancies to the Consultant before commencement of the work.
The drawings show general arrangement of services. Follow as closely as actual building construction will permit. Obtain approval for relocation of service from Consultant before commencement of the work.
The drawings do not indicate all offsets fitting and accessories which may be required. Provide the same to meet the required conditions.
Drawings and specifications, etc., prepared and issued by the Consultant are the property of the Consultant and must be returned at the completion of the project. These documents are not to be duplicated or copied without the consent of the Consultant.
Do not scale this drawing.
© 2026 DEI Consulting Engineers Inc.

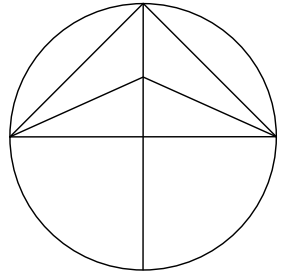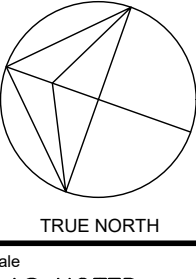01	ISSUED FOR PERMIT AND TENDER	2025.06.10
No.	REVISIONS	date
		
PROJECT NORTH		TRUE NORTH
Scale		AS NOTED

	Drawn	AP
	Last worked on	2026.03.17
	Checked	SO
	Print date	4.10.2026

client
**WATERLOO REGION
DISTRICT SCHOOL
BOARD**

51 ARDELT AVE
KITCHENER ONTARIO

project
**GRAND RIVER COLLEGIATE
INSTITUTE RENOVATION**



175 INDIAN RD
KITCHENER ONTARIO

drawing title
**FIRST & SECOND
FLOOR PART PLANS
- DEMOLITION**

reference

project no. 25-092 client reference number

sheet no.
M20500

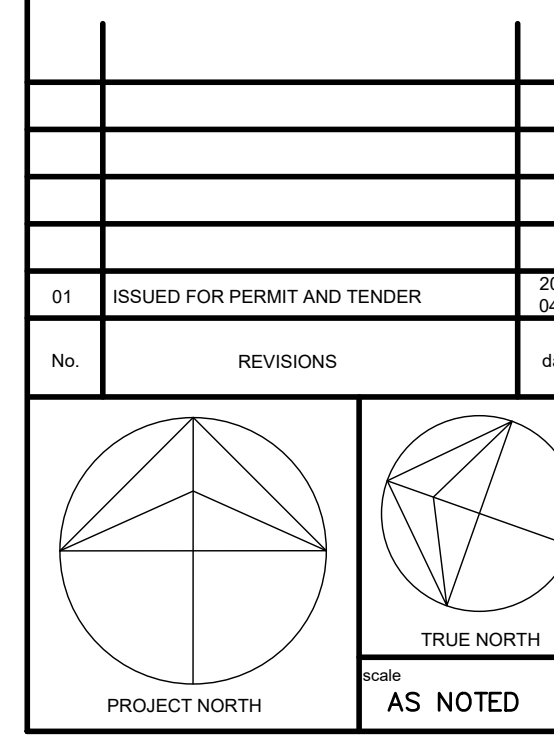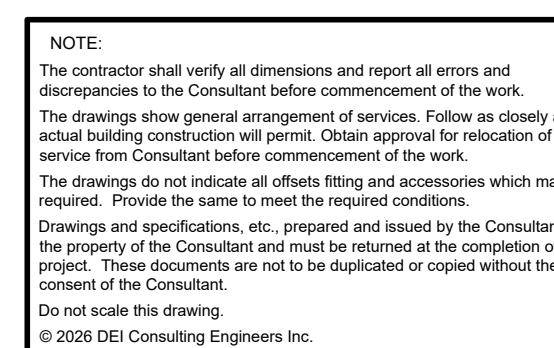

drawing title
FIRST & SECOND
FLOOR PART PLAN
- RENOVATION



reference	
project no. 25-092	client reference number
sheet no.	
M 3 0 1 0 0	



- ## SPECIFIC RENOVATION NOTES

- FIRST FLOOR PART PLAN 'B'- DRAINAGE RENOVATION**
SCALE: 1:100



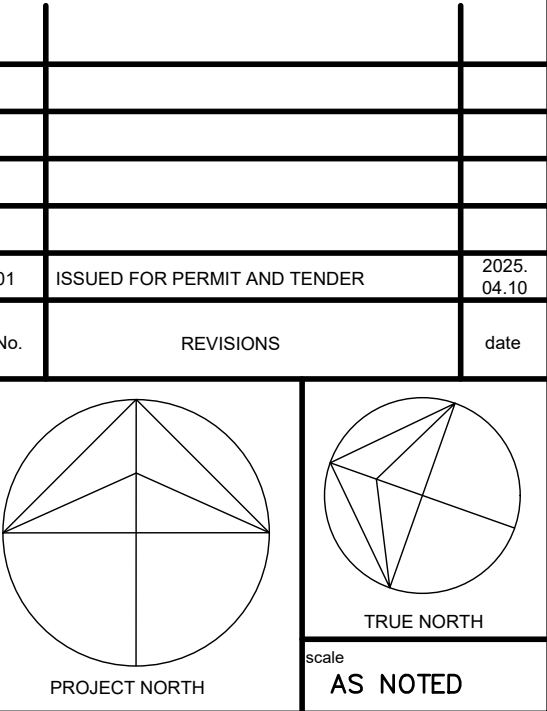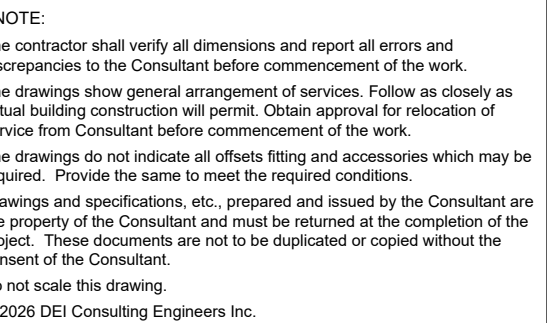

client	
WATERLOO REGION DISTRICT SCHOOL BOARD	
51 ARDELT AVE KITCHENER	ONTARIO
project	
GRAND RIVER COLLEGIATE INSTITUTE RENOVATION	
175 INDIAN RD KITCHENER	ONTARIO

drawing title



FIRST & SECOND
FLOOR PART PLANS
— RENOVATION

reference	
subject no. 25-092	client reference number
sheet no.	
M30200	



- ## GENERAL RENOVATION NOTES
- FREEZE OR DRAIN EXISTING PIPING AS REQUIRED TO FACILITATE CUT IN.
 - CO-ORDINATE ROUGH-IN AND MOUNTING HEIGHTS OF FIXTURES WITH MILLWORK AND ARCHITECTURAL DETAILS.




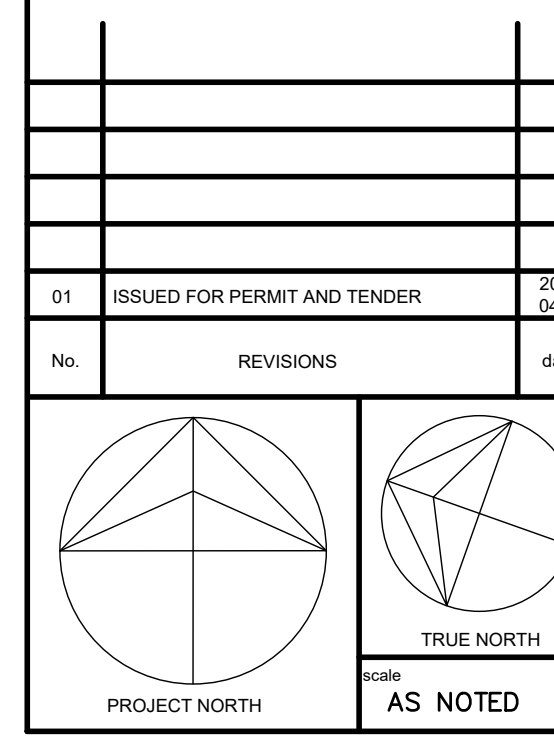
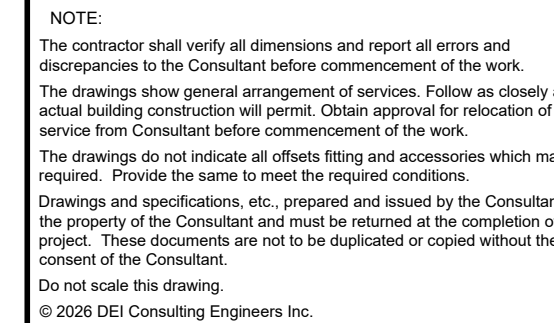


drawing title	
FIRST & SECOND FLOOR PART PLAN — RENOVATION	
reference	
project no. 25-092	client reference number
sheet no.	
M303 00	



- ## SPECIFIC RENOVATION NOTES
- A. EXISTING RELOCATED COOLING COIL. RECONNECT HW5&HW6 PIPING. PROVIDE NEW ISOLATION, BALANCING AND TEMPERATURE CONTROL VALVES.
 - B. EXISTING RELOCATED RADIATION. RECONNECT TO HW5&R PIPING. PROVIDE NEW ISOLATION, BALANCING AND TEMPERATURE CONTROL VALVES.
 - C. INSTALL NEW DDC THERMOSTAT AND CONTROL WIRING. FISH EXISTING W/AL OR PROVIDE NEW WIRE MOLD AS REQUIRED FOR NEW CONTROL WIRING.
 - D. INSTALL NEW DDC THERMOSTAT/ CO2 SENSOR & CONTROL WIRING. FISH EXISTING W/AL OR PROVIDE NEW WIRE MOLD AS REQUIRED FOR NEW CONTROL WIRING.



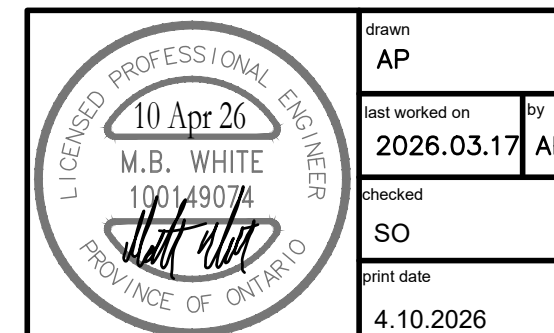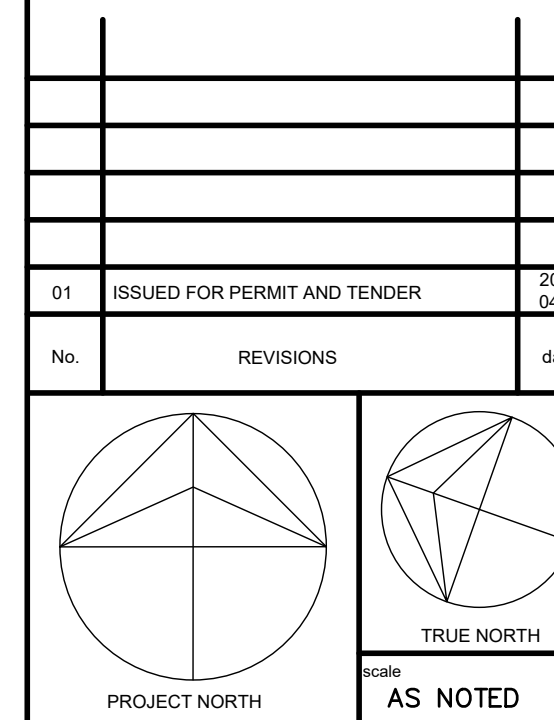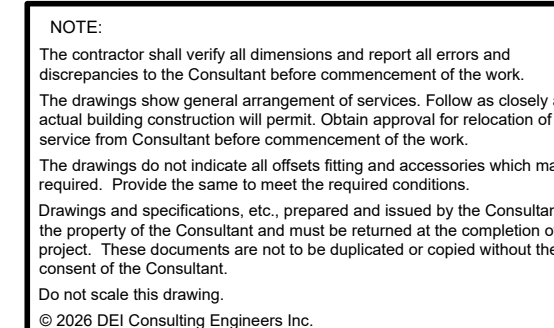

175 INDIAN RD
KITCHENER ONTARIO


drawing title
FIRST & SECOND
FLOOR PART PLAN
- RENOVATION

reference

project no. 25-092	client reference number
-----------------------	-------------------------



sheet no.	
-----------	--

	M	3	0	4	0	0
--	---	---	---	---	---	---

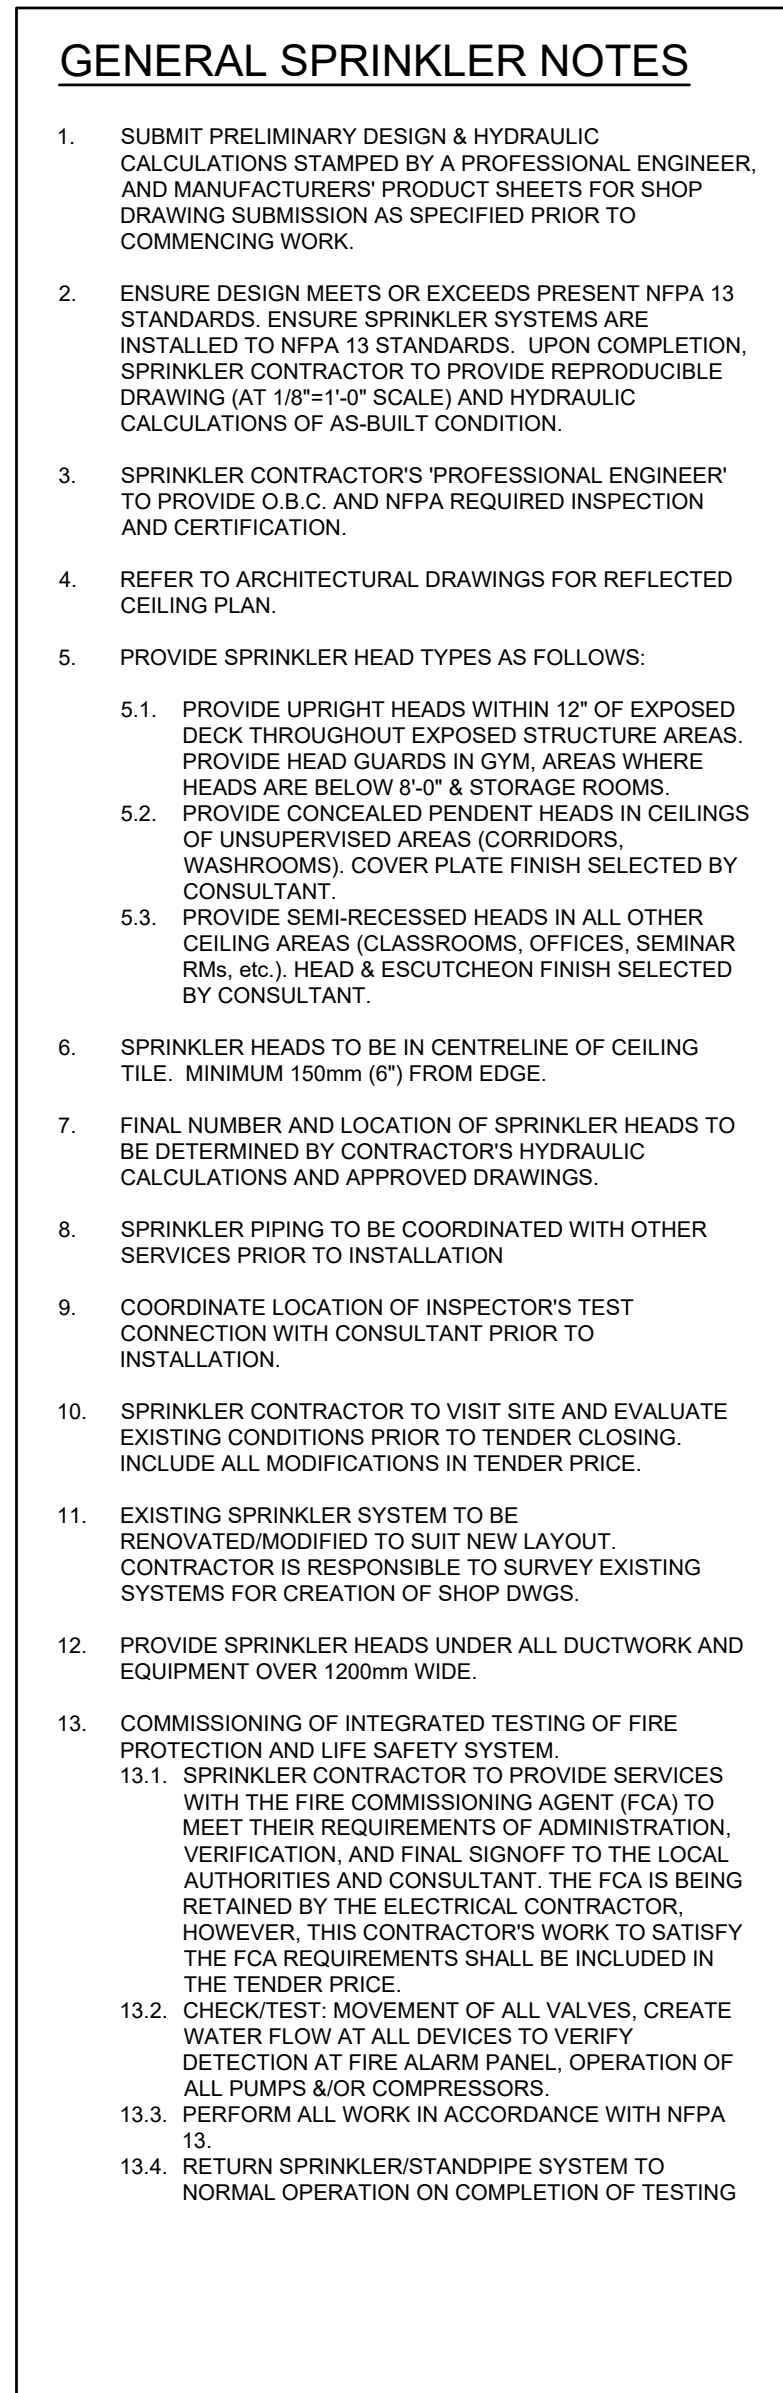


<u>SPRINKLER SCHEDULE</u>			
TYPE	SPRINKLER HEAD	COLOUR	REMARKS
1	SEMI-RECESSED PENDENT	WHITE	
2	CONCEALED PENDANT HEAD	WHITE	

SECOND FLOOR PART PLAN 'A' - SPRINKLER RENOVATION
SCALE: 1:100

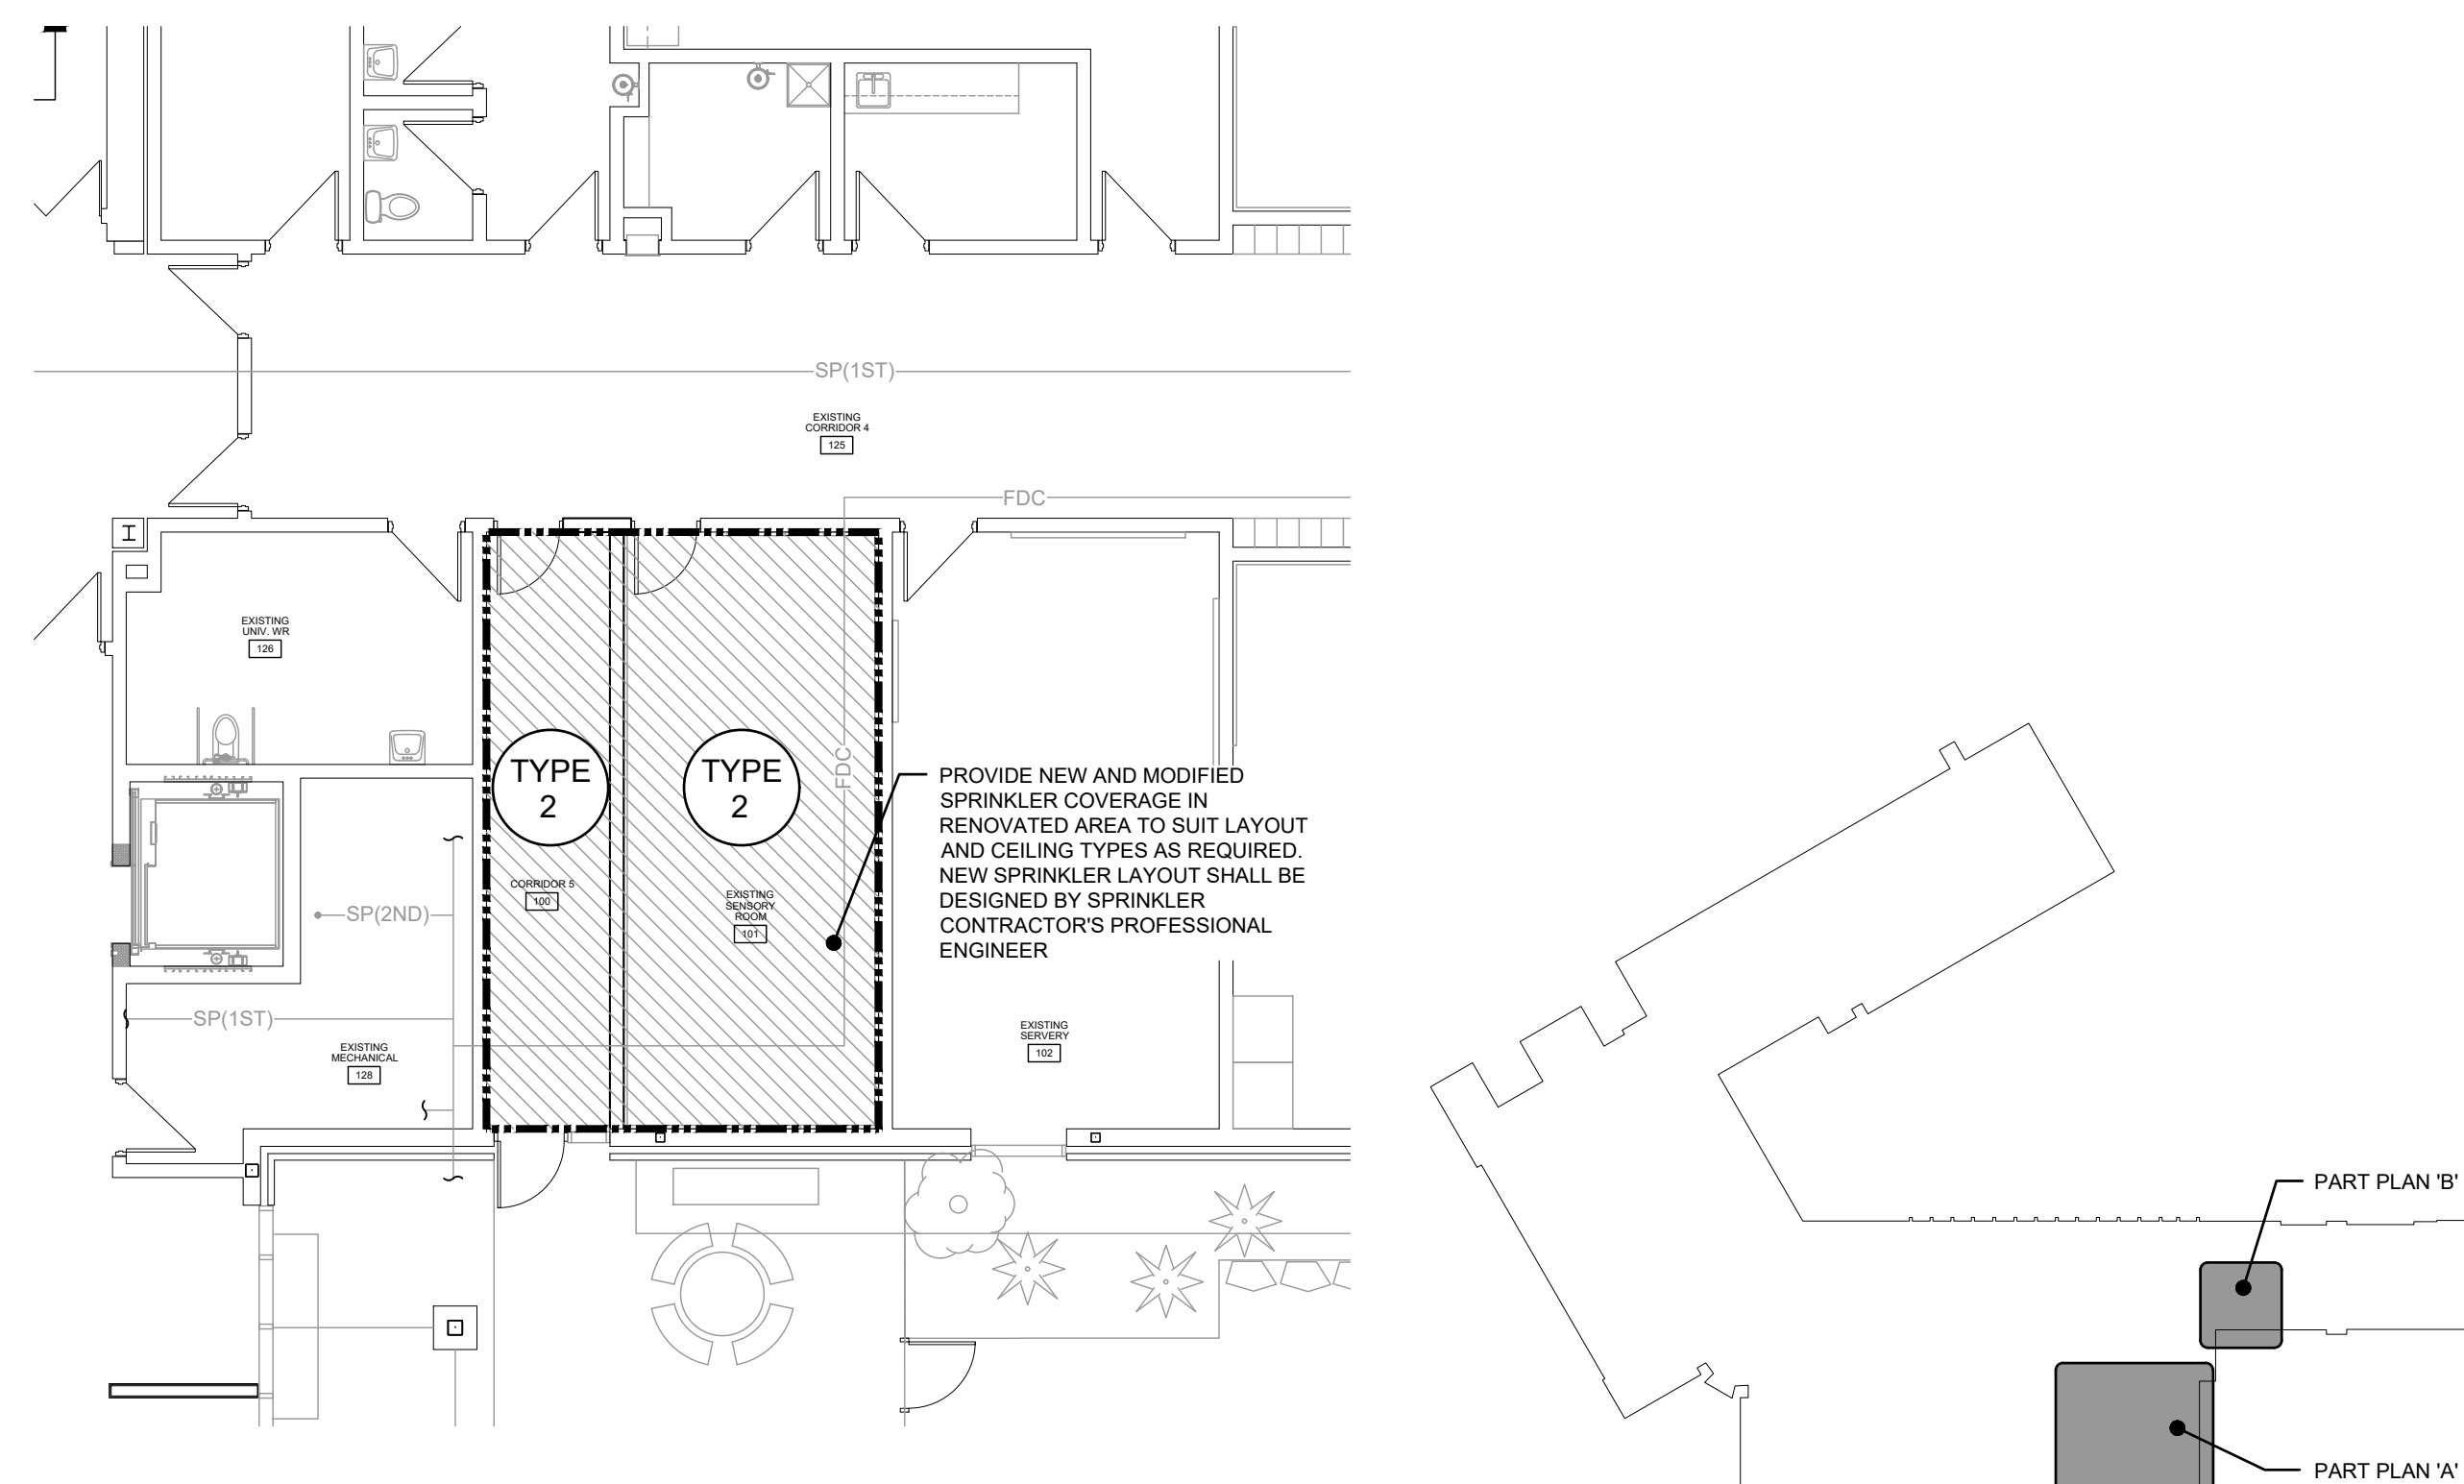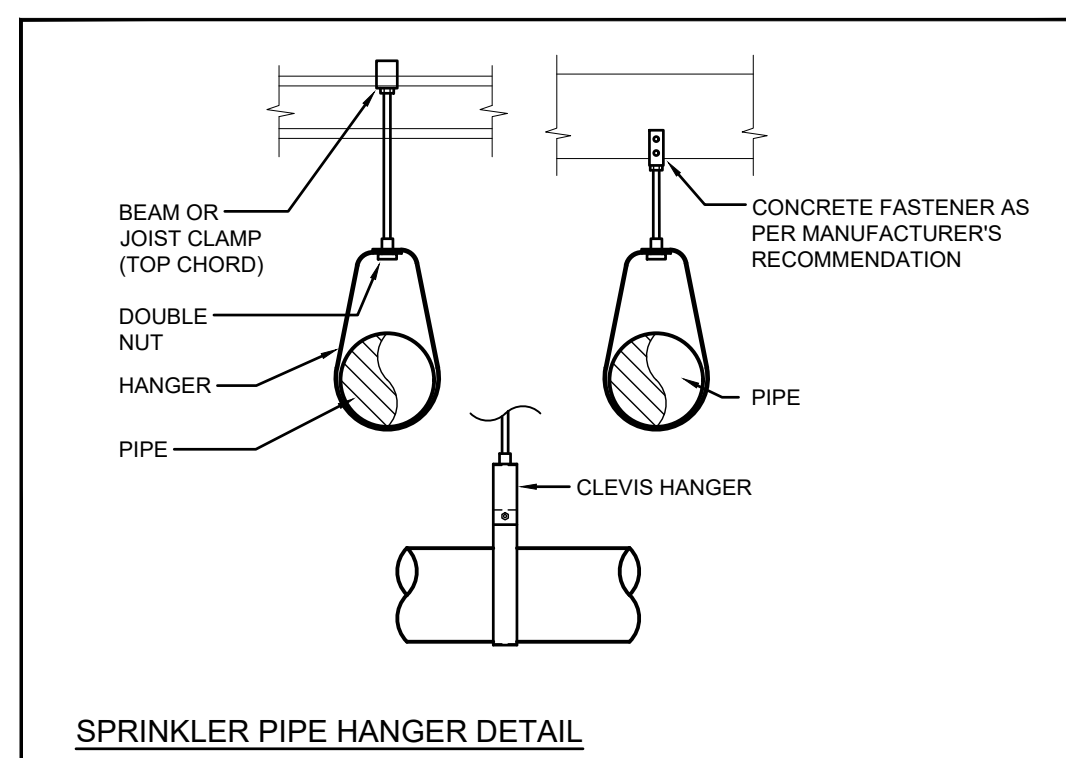

FIRST FLOOR PART PLAN 'B'- SPRINKLER RENOVATION
SCALE: 1:100

KEY PLAN

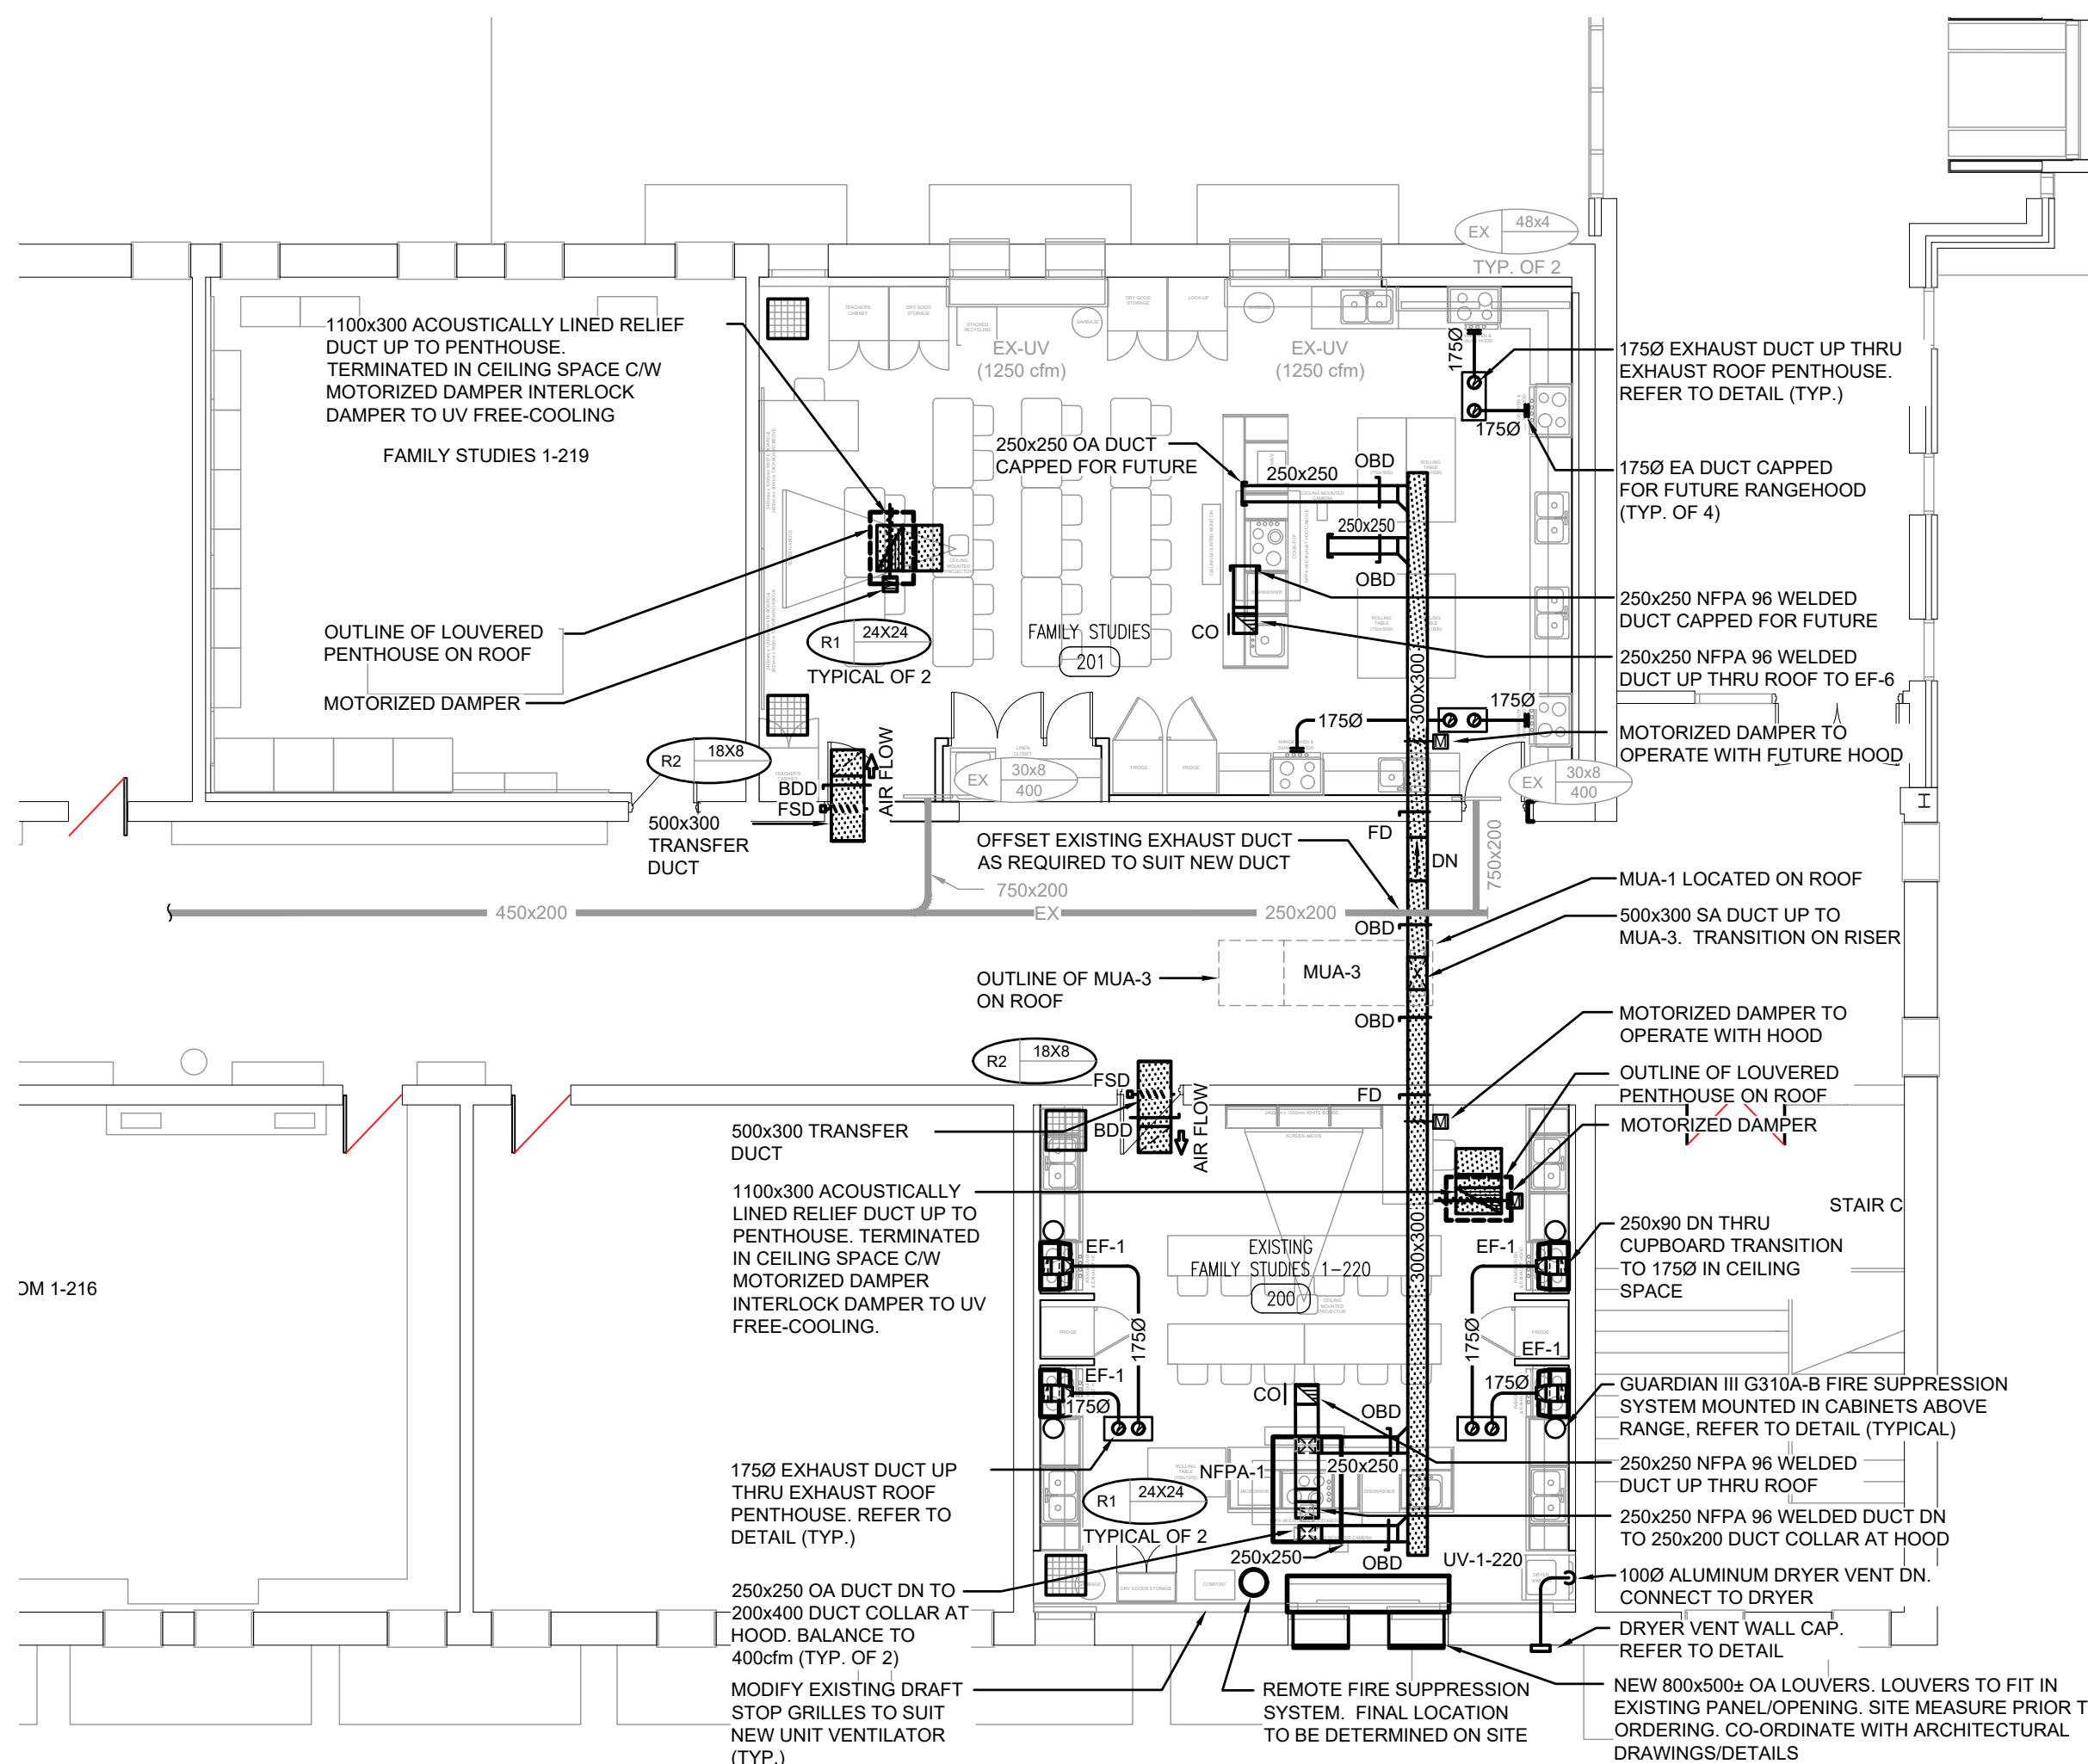


SECOND FLOOR PART PLAN 'B' - VENTILATION RENOVATION

GENERAL RENOVATION NOTES


- CO-ORDINATE ANY OWS/ BRIDGING RELOCATION OR REMOVAL/REPLACEMENT WITH THE GENERAL CONTRACTOR. PAY ALL COSTS REQUIRED TO MODIFY BRIDGING FOR INSTALLATION OF DUCTWORK.
- REFER TO M303 DRAWINGS FOR THERMOSTAT/SENSORS NOT INDICATED ON THIS DRAWING.
- CO-ORDINATE LOCATIONS OF GRILLES/DIFFUSERS WITH ARCHITECTURAL REFLECTED CEILING PLANS. FINAL LOCATION TO BE DETERMINED ON SITE. CONTRACTOR TO NOTIFY CONSULTANT OF ANY DISCREPANCIES PRIOR TO INSTALLATION. FAILURE TO DO SO WILL RESULT IN RELOCATION COSTS BORNE BY THIS CONTRACTOR.
- WHERE DUCTWORK PENETRATES CORRIDOR WALL, CENTER DUCT(S) BETWEEN OWS.

SPECIFIC RENOVATION NOTES



- A. EXISTING RELOCATED COOLING COIL RECONNECT WITH NEW DUCTWORK.
- B. EXISTING RELOCATED VAV RECONNECT WITH NEW DUCTWORK.
- C. INSTALL NEW FIRE SMOKE DAMPER IN EXISTING DUCTWORK.
- D. OUTDOOR AIR TEMPERATURE DISCHARGE CONTROLLER.
- E. INSTALL NEW SMOKE DAMPER IN EXISTING DUCTWORK.

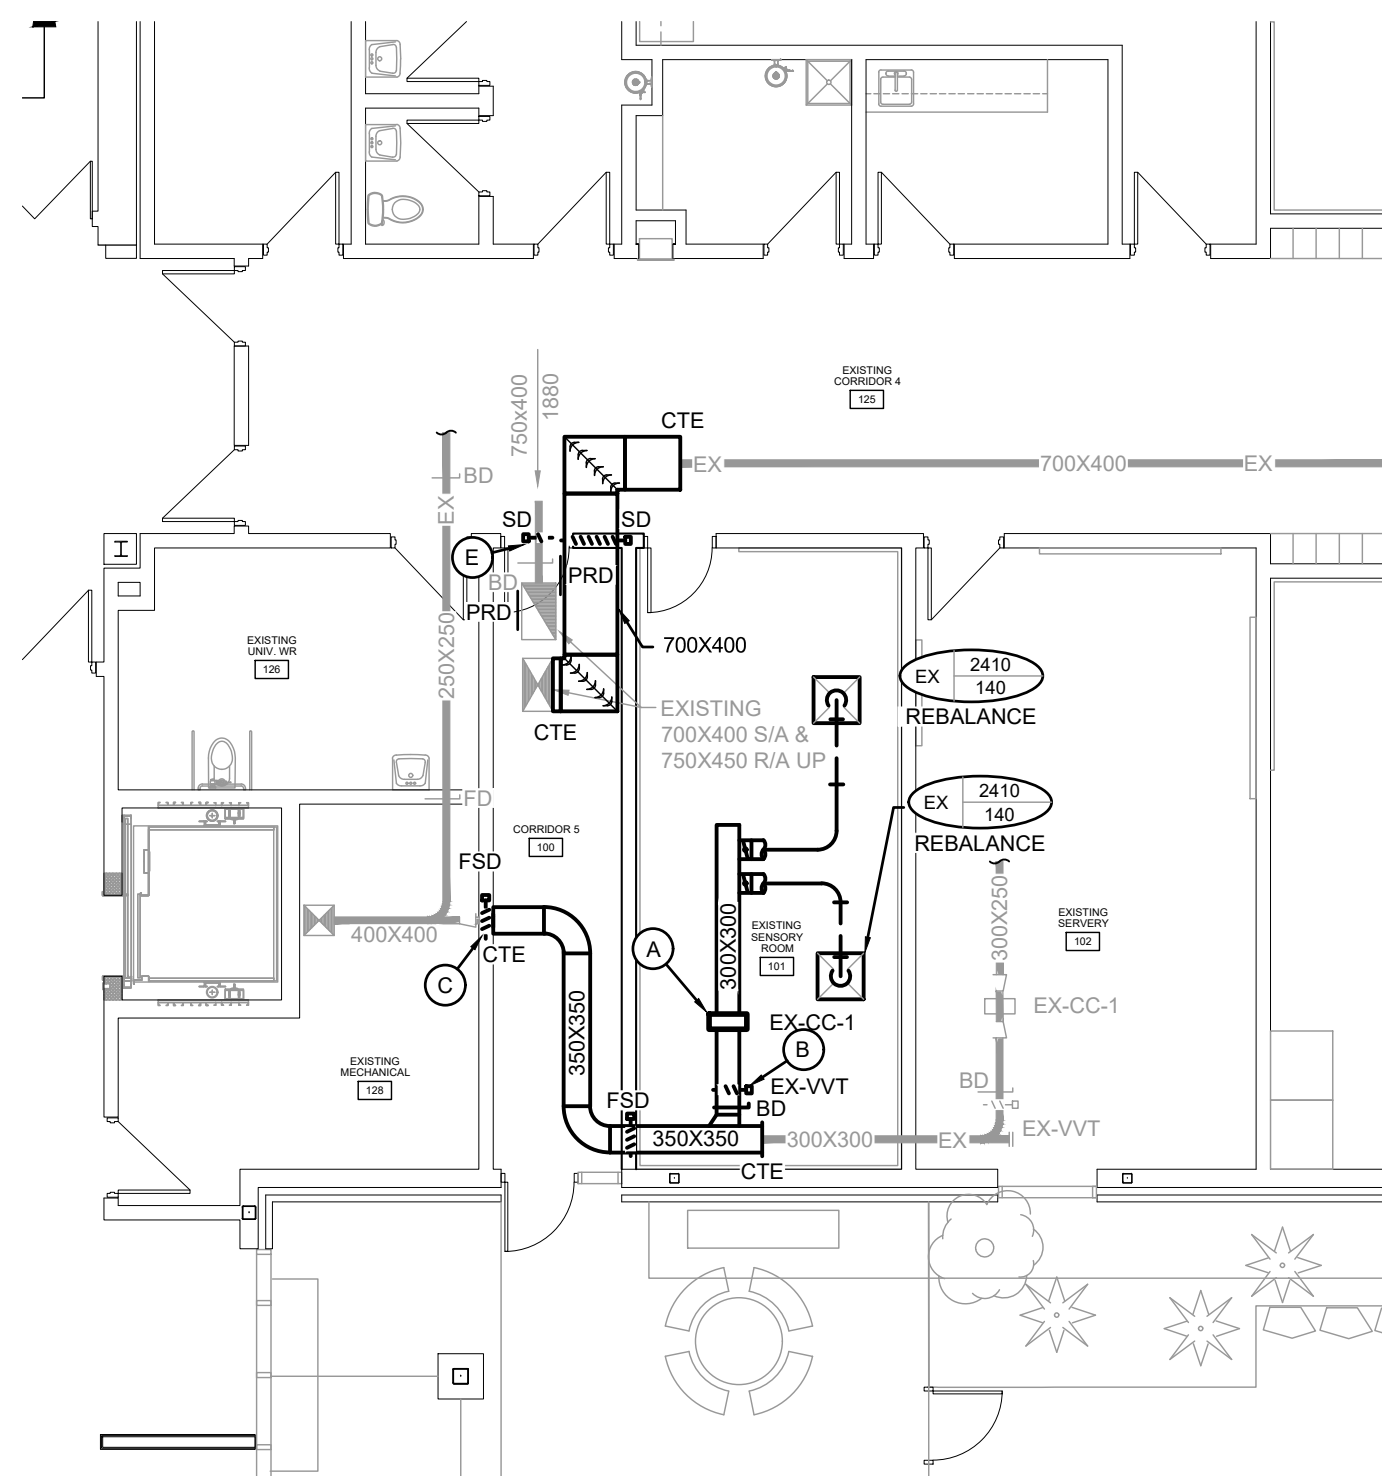

FIRST FLOOR PART PLAN 'B'- VENTILATION RENOVATION
SCALE: 1:100

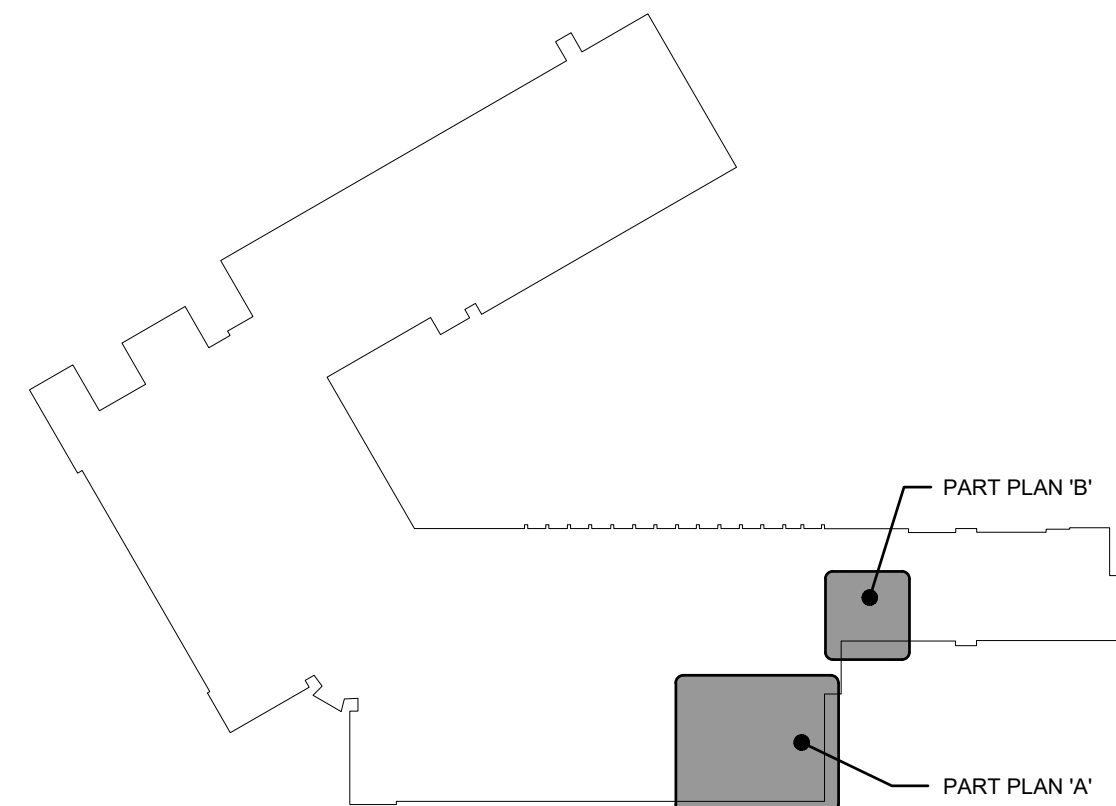

KEY PLAN

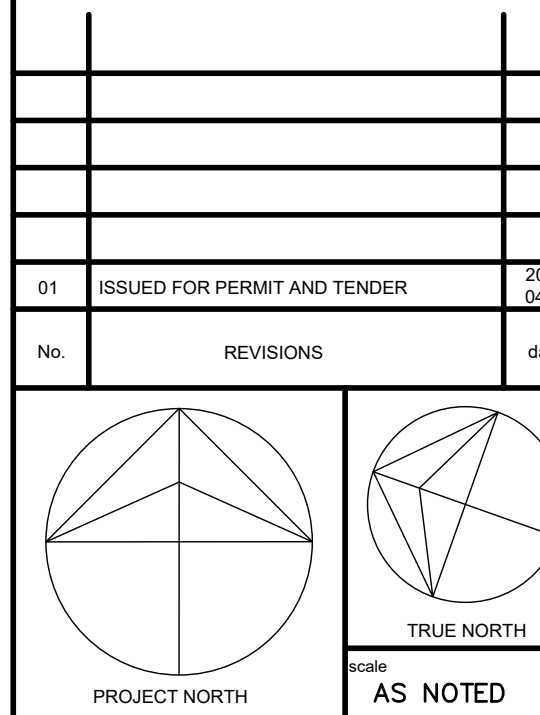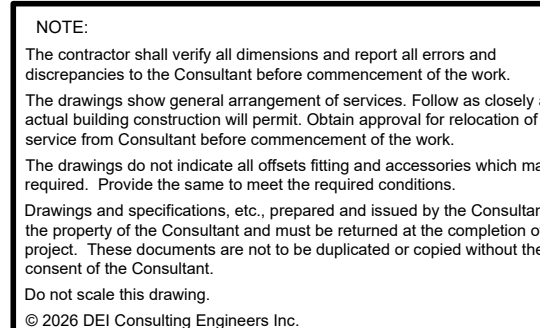

175 INDIAN RD
KITCHENER ONTARIO


sheet no.	
-----------	--














	M	4	0	1	0	0
--	----------	----------	----------	----------	----------	----------



SCALE: 1:100

 - MAINTAIN MINIMUM 3700mm (12'-0") LATERAL DISTANCE BETWEEN SANITARY VENTS AND ALL AIR INTAKE/EXHAUST OPENINGS.
- MAINTAIN MINIMUM 3000mm (10'-0") LATERAL DISTANCE BETWEEN PRV, FUEL FIRED APPLIANCE, AND/OR EXHAUST VENTS AND ALL AIR INTAKE/EXHAUST OPENINGS.
- ALL EQUIPMENT SHALL BE MINIMUM 3.0M FROM EDGE OF ROOF.



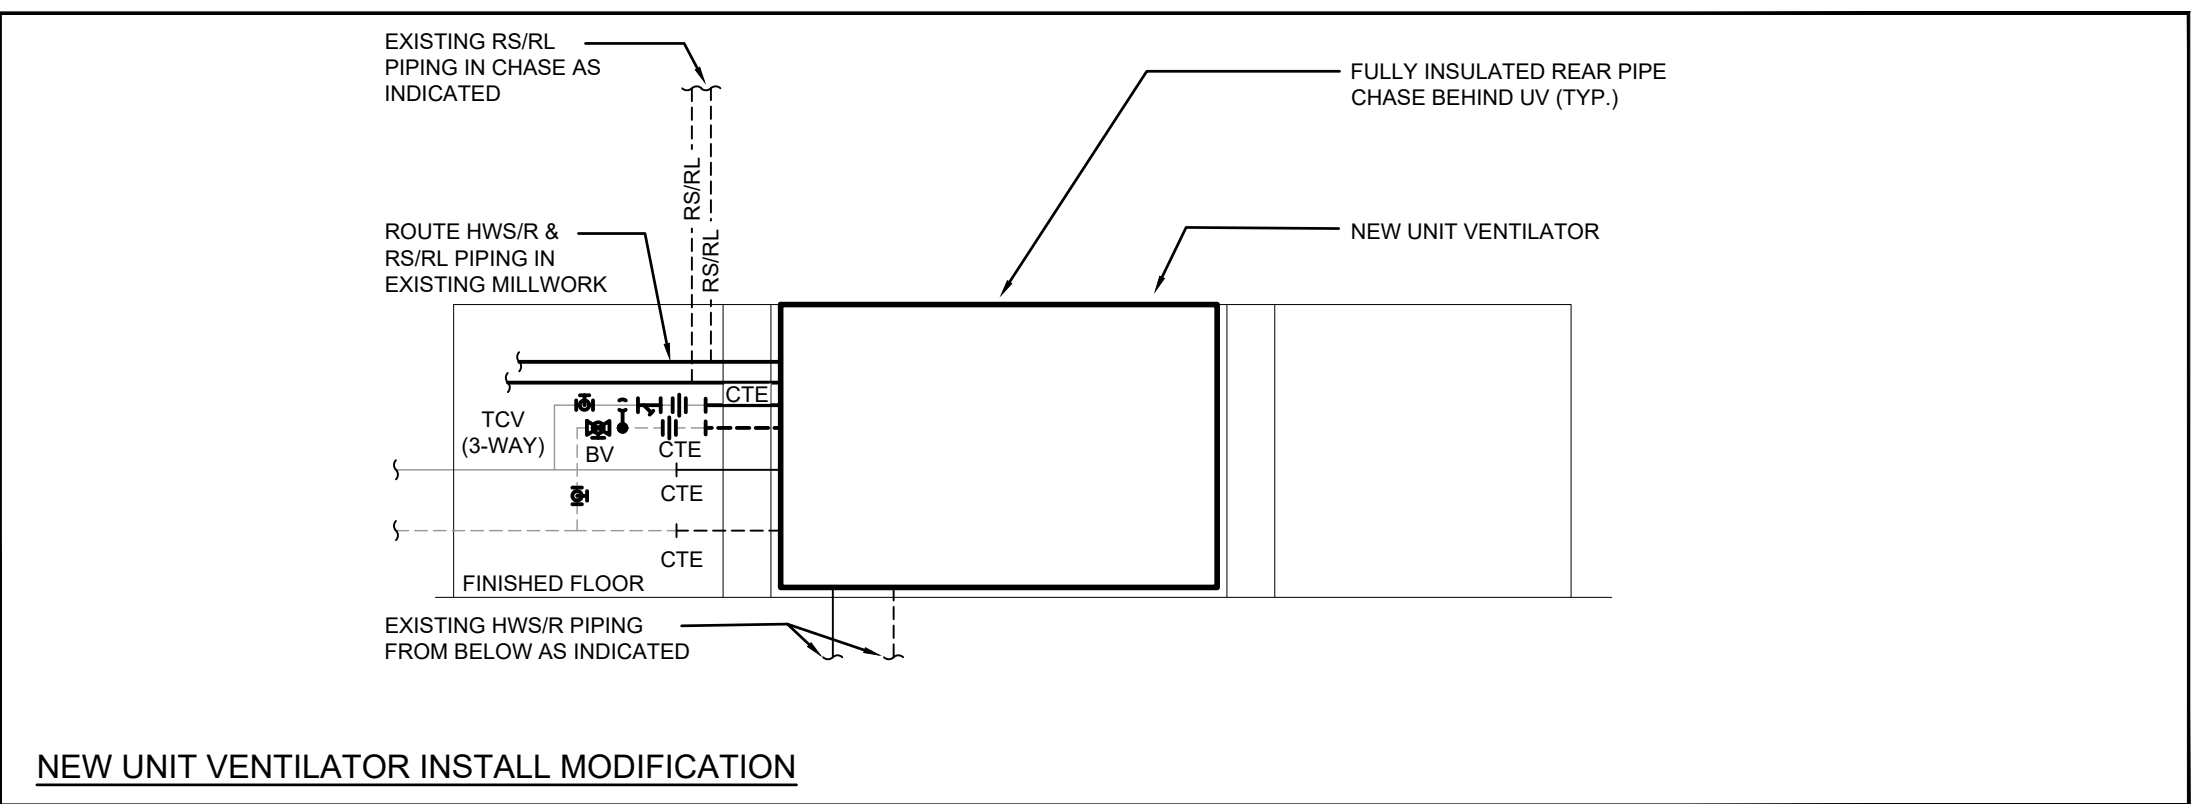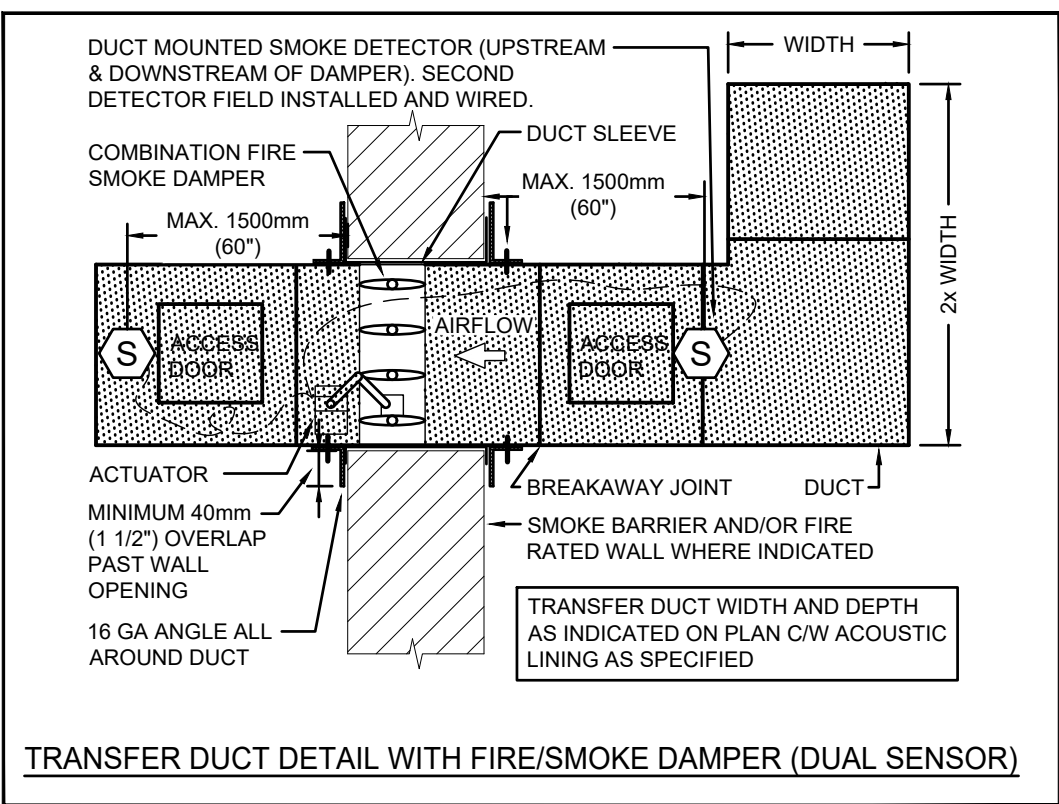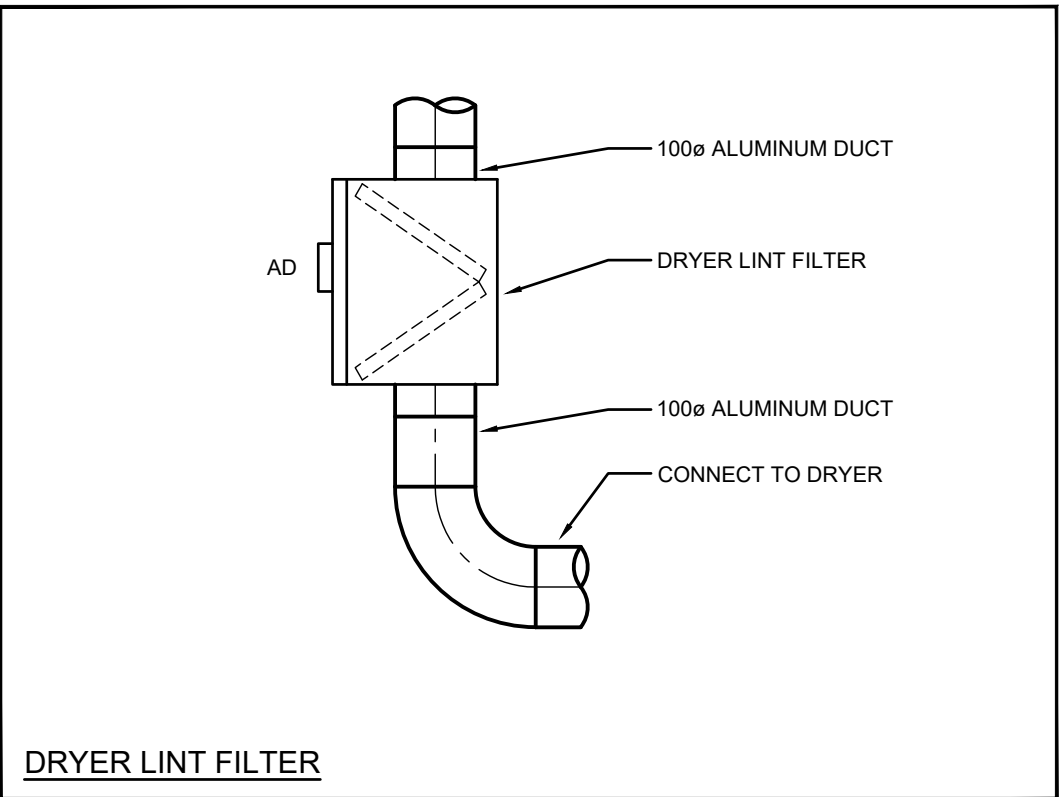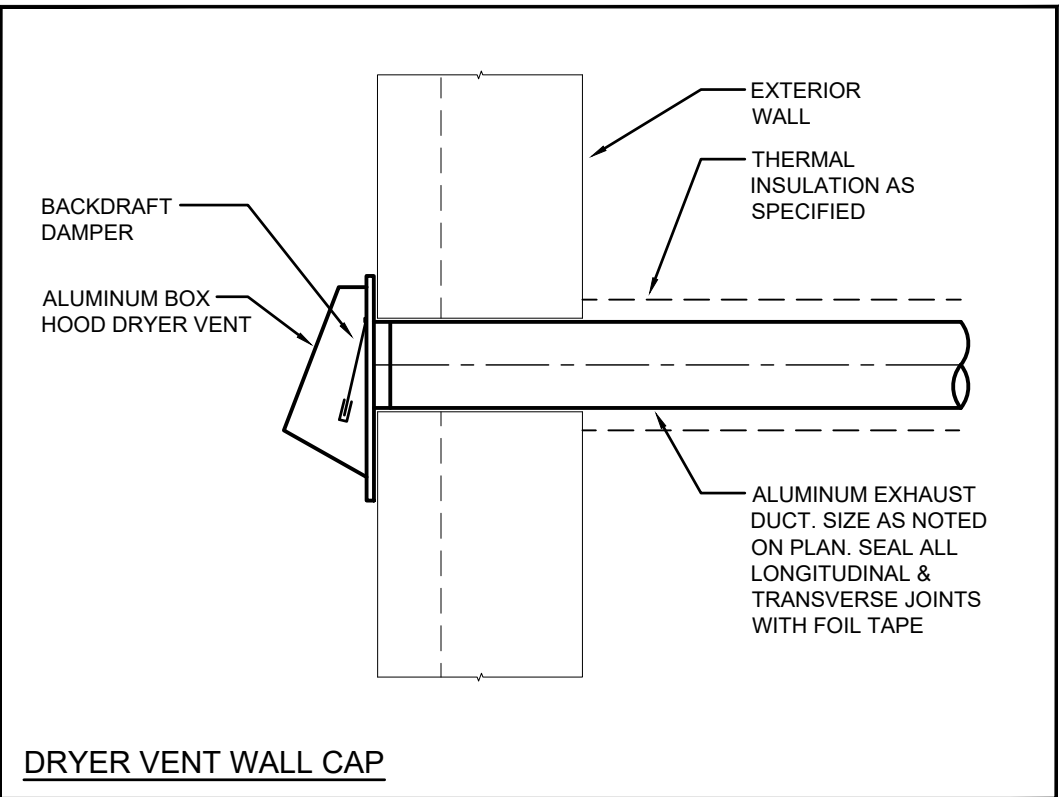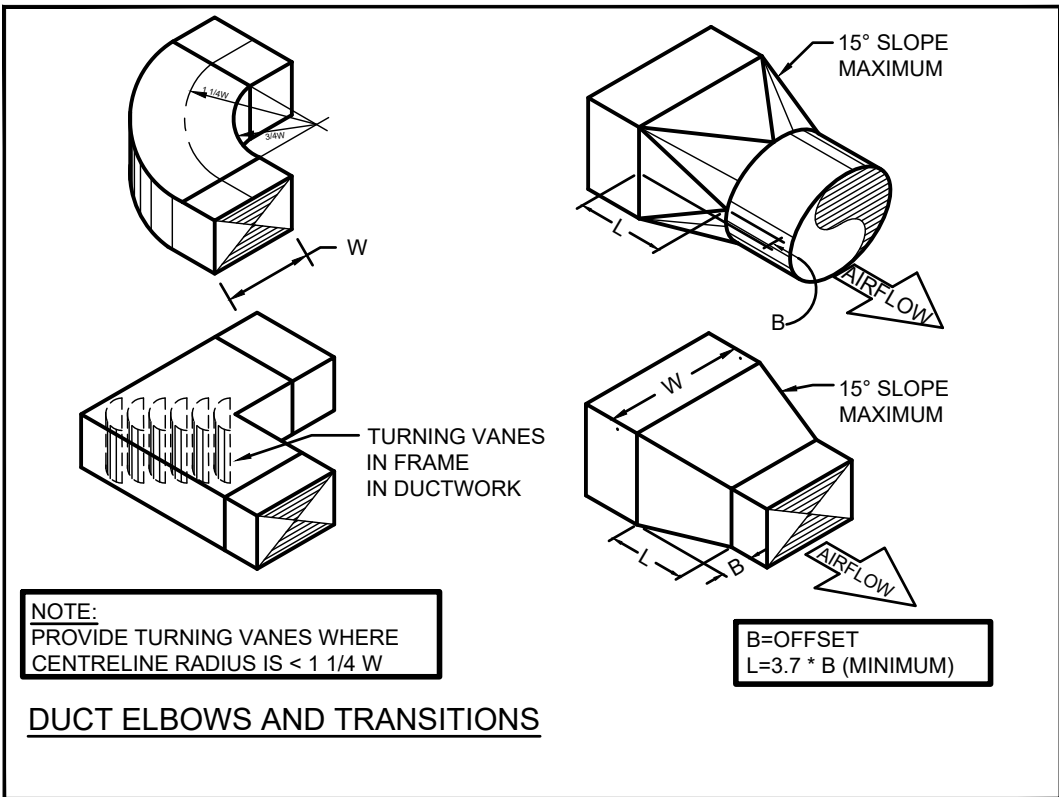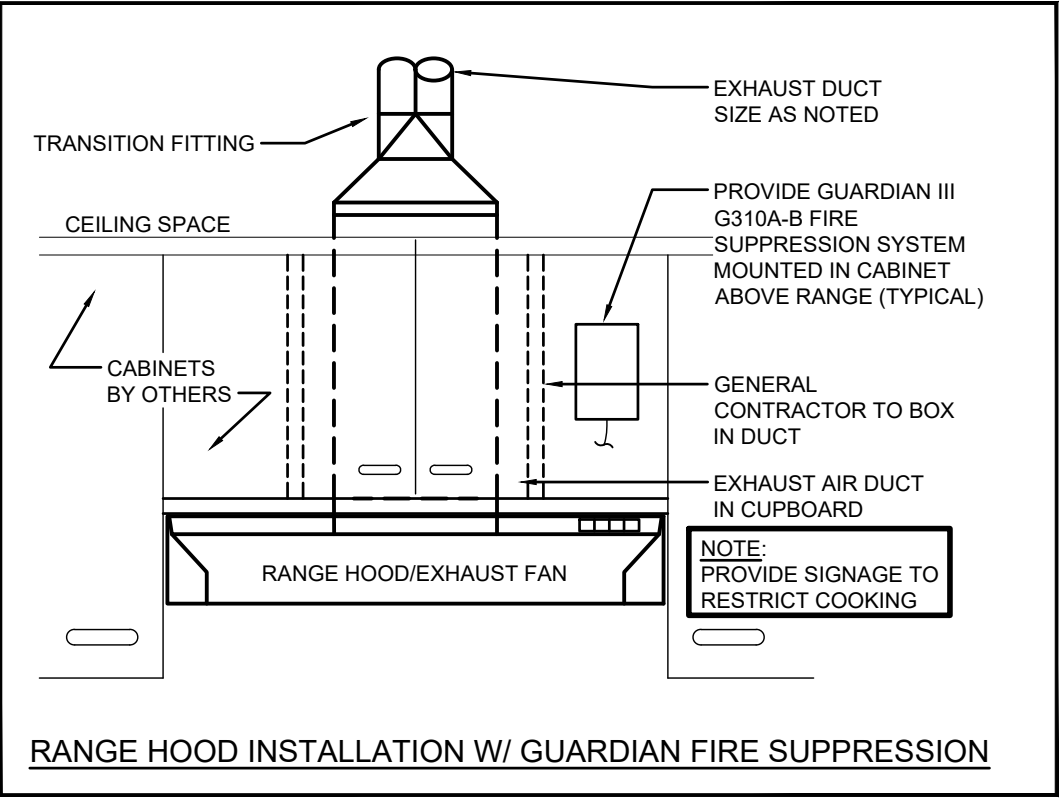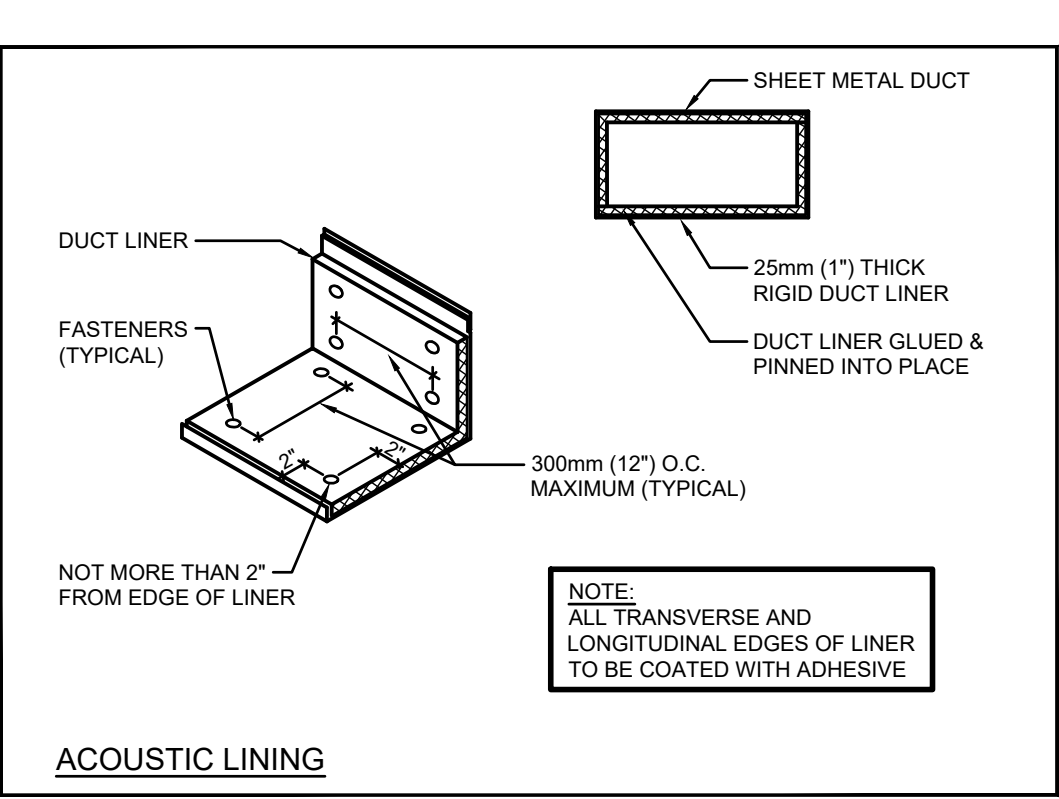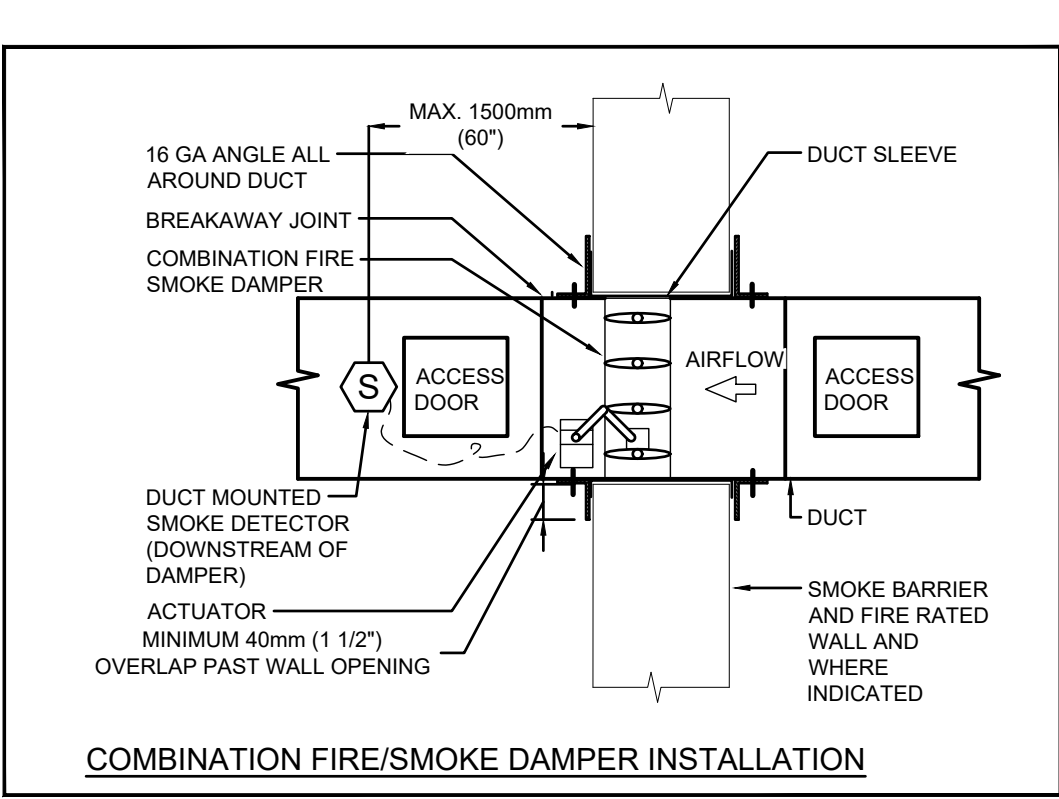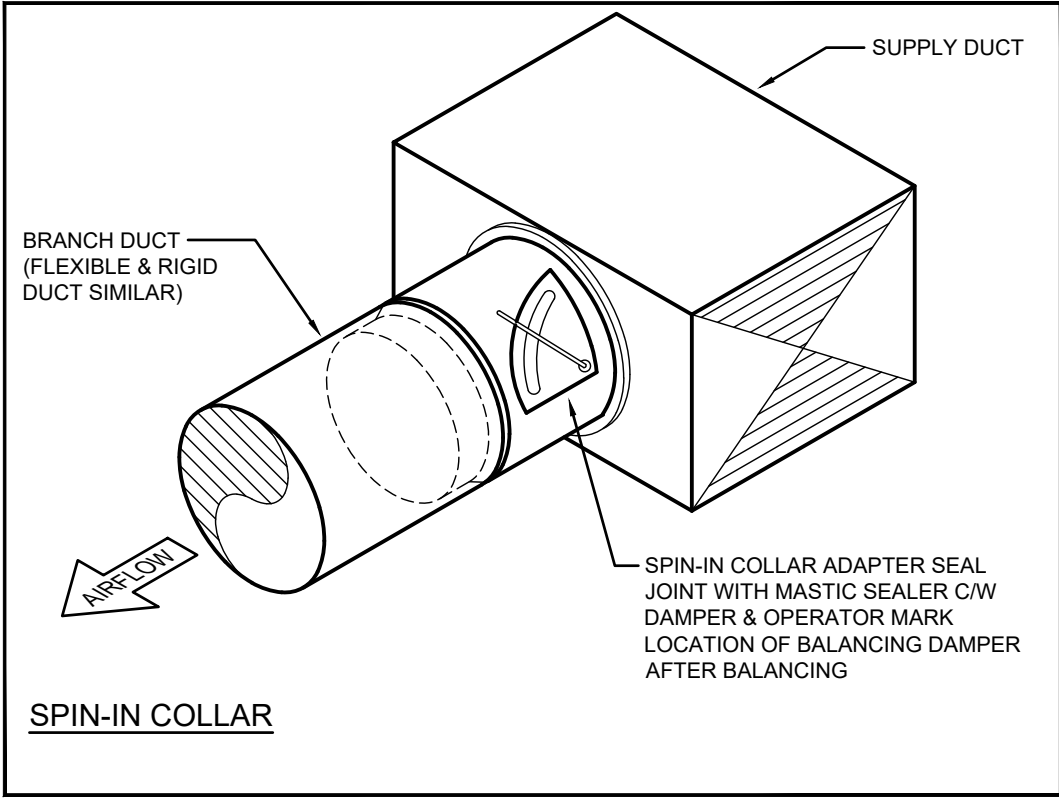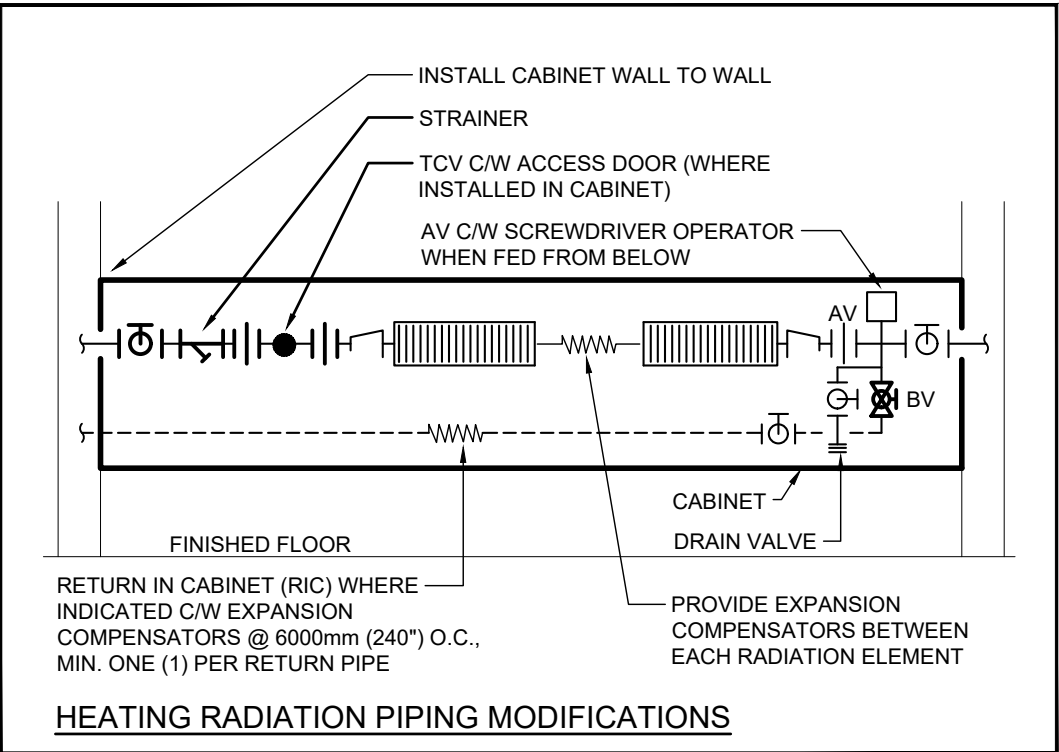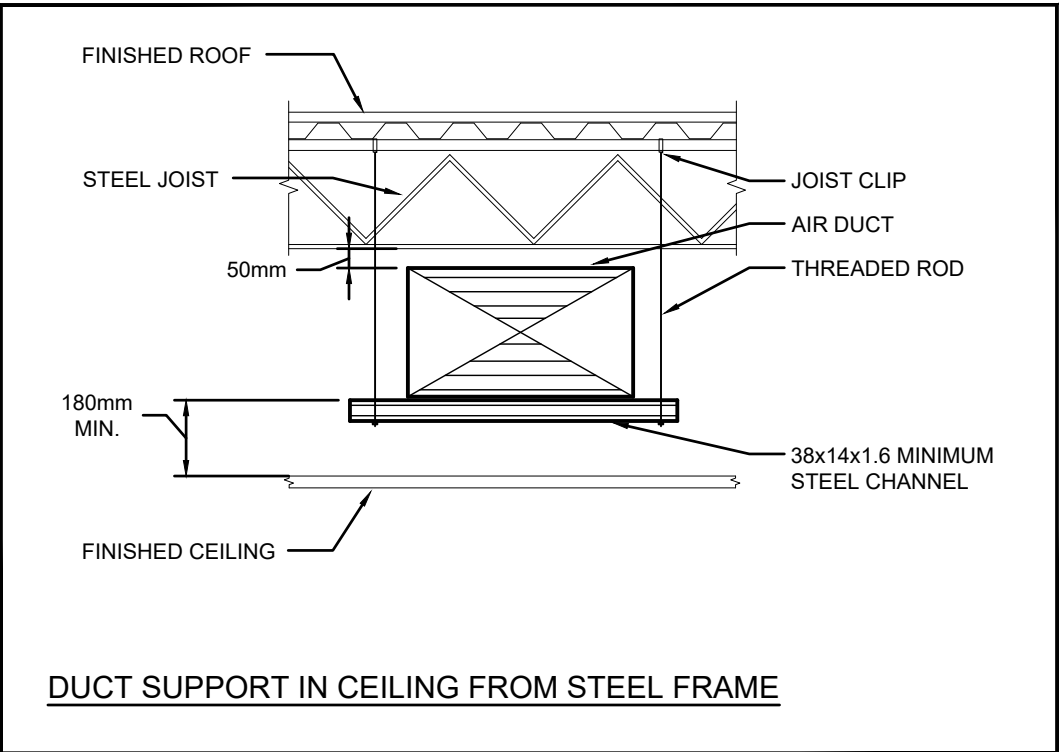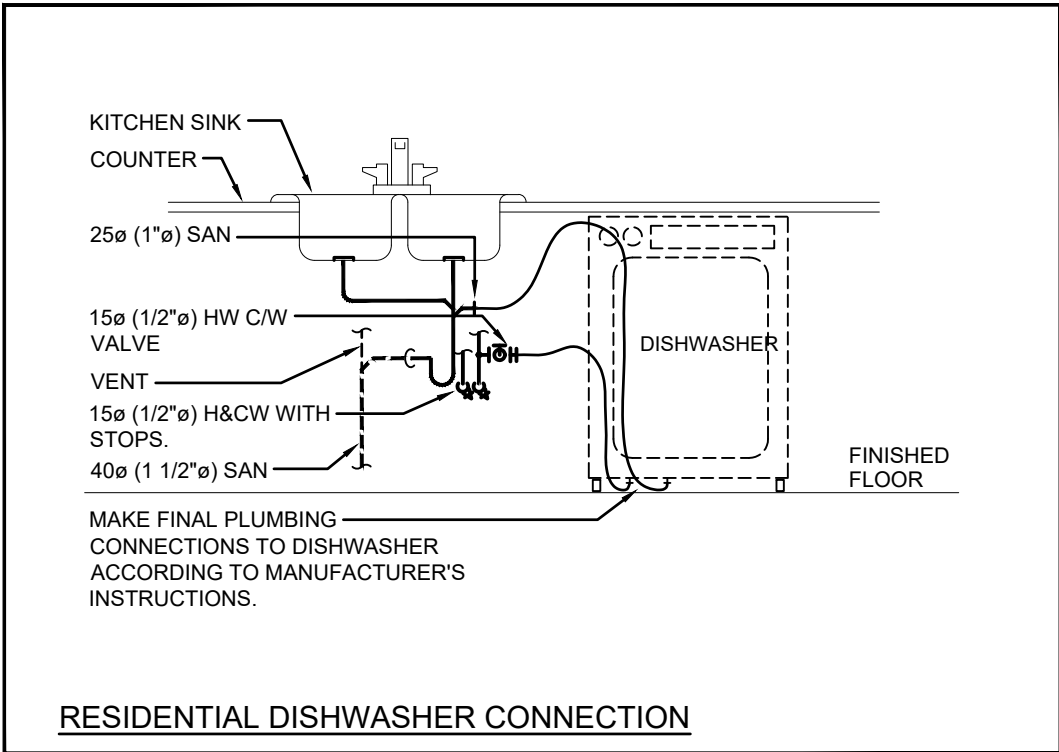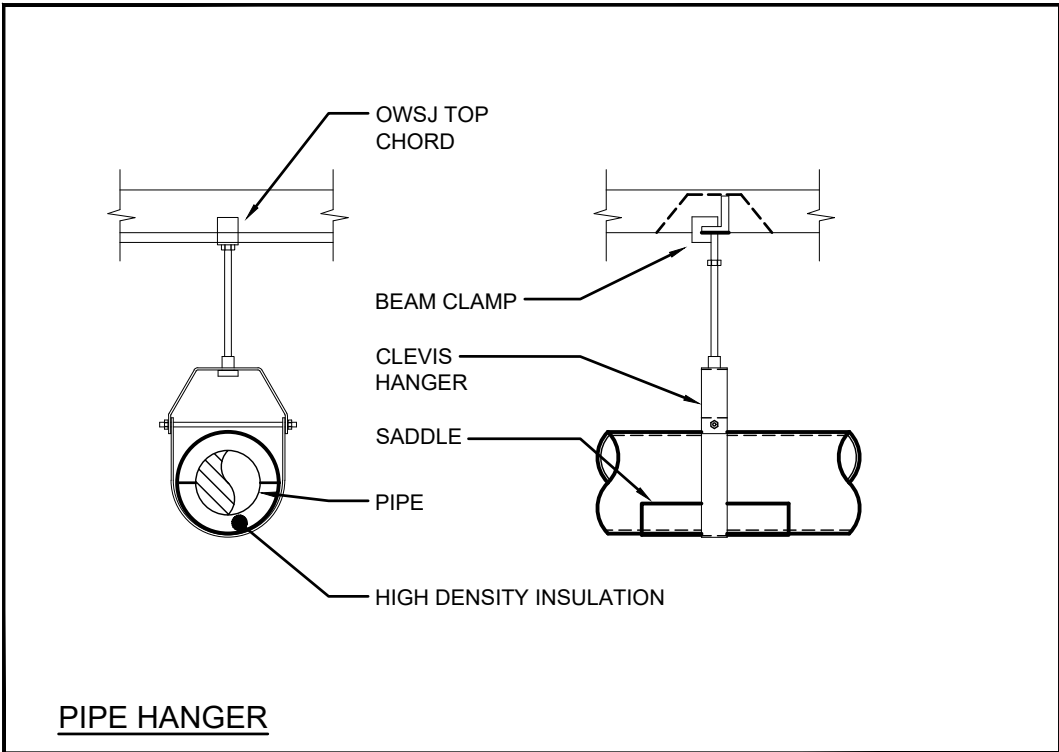


NOTE:
The contractor shall verify all dimensions and report all errors and discrepancies to the Consultant before commencement of the work. The drawings show general arrangement of services. Follow as closely as actual building construction will permit. Obtain approval for relocation of service from Consultant before commencement of the work. The drawings do not indicate all offsets fitting and accessories which may be required. Provide the same to meet the required conditions. Drawings and specifications, etc., prepared and issued by the Consultant are the property of the Consultant and must be returned at the completion of the project. These documents are not to be duplicated or copied without the consent of the Consultant. Do not scale this drawing. © 2024 DEI Consulting Engineers Inc.

DEI Consulting Engineers
MECHANICAL | ELECTRICAL | AQUATIC
 55 Northland Road, Waterloo, ON N2V 2Y8
 Phone: 519-745-3555
 Website: dei-associates.ca
 Project Number: x6092

01	ISSUED FOR PERMIT AND TENDER	2025.04.10
----	------------------------------	------------

No.	REVISIONS	date
-----	-----------	------

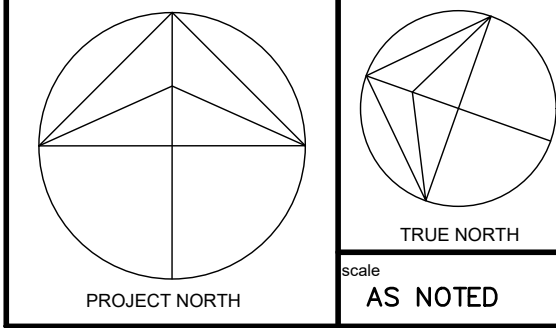

drawn by **AP**
 last worked on by **AP**
 2026.03.17
 checked by **SO**
 print date 4.10.2026

BJC
 architects + assoc. inc.

client
WATERLOO REGION DISTRICT SCHOOL BOARD
 51 ARDELT AVE KITCHENER ONTARIO
 project
GRAND RIVER COLLEGIATE INSTITUTE RENOVATION
 175 INDIAN RD KITCHENER ONTARIO


drawing title
DETAILS
 reference
 project no. 25-092 client reference number
 sheet no. **M50100**



- 'ER' INDICATES EXISTING ITEM TO REMAIN.
- 'R' INDICATES EXISTING ITEM IN RELOCATED POSITION.
- ALL DEVICES SHOWN ARE NEW UNLESS OTHERWISE NOTED.
- EXISTING ELECTRICAL EQUIPMENT NOT SHOWN SHALL REMAIN UNLESS OTHERWISE NOTED.
- MAINTAIN SERVICE TO ALL EXISTING DEVICES TO REMAIN.
- REVISE PANEL DIRECTORIES TO SUIT CHANGES (TYPED).

- 1 INDICATES EXISTING 120/208V 225A PANEL 'P1AA' (SQUARE D TYPE NQ 3PH, 4W, 60 CIRCUIT). PROVIDE NEW BREAKER(S) AND FEED TO NEW LOADS AS INDICATED ON PLANS. PROVIDE UPDATED TYPEWRITTEN PANEL DIRECTORY.

- 2 INDICATES PROPOSED LOCATION OF NEW PANEL AND TRANSFORMER TO BE SUPPLIED AND INSTALLED BY ELECTRICAL CONTRACTOR. COORDINATE EXACT PLACEMENT WITHIN MECHANICAL ROOM WITH SCHOOLBOARD REPRESENTATIVE PRIOR TO INSTALL.

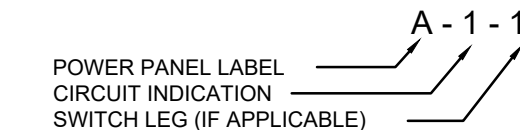GENERAL			CLOCK AS PER SPECIFICATIONS		PUSH-BUTTON STATION (QUANTITY OF BUTTONS AS PER PLANS)		DOOR CONTACT C/W 19mmC TO NEAREST SECURITY JUNCTION BOX (REFER TO DETAIL)
ER	INDICATED EXISTING ITEM TO REMAIN		TELEVISION OUTLET C/W 1" (27mm) TO CABLE MANAGEMENT SYSTEM.		CONTACTOR		LOW TEMPERATURE SENSOR, ROUGH IN AS A SINGLE GANG BOX MOUNTED HORIZONTALLY AT 150mm BELOW FINISHED CEILING LEVEL.
D	INDICATES EXISTING ITEM TO BE DELETED		HANGER SYSTEM (REFER TO DETAILS)		MOTOR CONNECTION		
R	INDICATES EXISTING ITEM TO BE RELOCATED IN RELOCATED POSITION		ADMINISTRATIVE CONTROL CONSOLE		POWER POLE		SECURITY JUNCTION BOX 150mm (6") SQUARE C/W COVER
WG	WIREGUARD		HANDSET (ND = NON-DIAL STYLE)		THERMOSTAT (RA=REVERSE ACTING)		CEILING MOUNTED CAMERA
GF	GROUND FAULT		P.A. CALL SWITCH		SOLENOID VALVE		HOLD-UP/PANIC PUSHBUTTON C/W 13mmC TO NEAREST SECURITY JUNCTION BOX.
WP	WEATHERPROOF		WALL MOUNTED SPEAKER (CS= COLUMN SPEAKER)		CURRENT SENSOR	ACCESS CONTROL	
TR	TAMPER RESISTANT		WALL MOUNTED SPEAKER C/W CALL-IN SWITCH		TRANSFORMER		MAG LOCK
CLG	CEILING MOUNTED		CEILING MOUNTED SPEAKER	ELECTRIC HEAT			ELECTRIC STRIKE. CONFIRM ROUGH IN WITH DOOR HARDWARE.
	NOTE INDICATOR		PROGRAM BELL		BASEBOARD ELECTRIC HEATER (TYPE AS INDICATED)		"PUSH-TO-LOCK" BUTTON
	MECHANICAL ITEM NO.		HORN SPEAKER		FAN FORCED ELECTRIC HEATER (TYPE AS INDICATED)		EMERGENCY PUSH BUTTON STATION
	OWNERS EQUIPMENT ITEM NO.		MICROPHONE OUTLET		UNIT HEATER (TYPE AS INDICATED)		"ASSISTANCE REQUIRED" DOME LIGHT WITH SOUNDER
STANDARD CIRCUIT LABELING			DOOR BELL	SAFE WELCOME DEVICES			"ASSISTANCE REQUIRED" INDICATOR LIGHT WITH SOUNDER
POWER PANEL LABEL CIRCUIT INDICATION SWITCH LEG (IF APPLICABLE) 			AUXILIARY ROUGH-IN FOR USE AS NOTED.		MONITOR		CARD/FOB READER ROUGH-IN AS A SINGLE GANG BOX AT 1100mm AFF C/W 13mmC TO ELECTRIC STRIKE IN ADJACENT DOOR FRAME. CONFIRM ROUGH-IN WITH DOOR HARDWARE.
					POWER SUPPLY		
					CALL SWITCH STATION		

NOTE:

- The contractor shall verify all dimensions and report all errors and discrepancies to the Consultant before commencement of the work.
- The drawings show general arrangement of services. Follow as closely as actual building construction will permit. Obtain approval for relocation of services from the Consultant before commencement of the work.
- The drawings do not indicate all offsetting and accessories which may be required. Provide the same to meet the required conditions.
- Drawings and specifications, etc., prepared and issued by the Consultant are the property of the Consultant and must be returned at the completion of the project. These documents are not to be duplicated or copied without the consent of the Consultant.
- Do not scale this drawing.

© 2026 DEI Consulting Engineers Inc.



DEI
Consulting Engineers

MECHANICAL | ELECTRICAL | AQUATIC

55 Northland Road, Waterloo, ON N2V 1Y8
Phone: 519-725-3555
Website: deiasociates.ca
Project Number: 26092

01	ISSUED FOR PERMIT AND TENDER	2025, 04.02
No.	REVISIONS	date

 Professional Engineers
Ontario *DM* 04-2-2026
Limited Engineering Licensee
Name: D.G. MCCONKEY
Number: 100230476
Limitations: Detailed design, reporting, and specifications for all building electrical systems, site servicing and review of conformity for these systems in new and renovation construction
Association of Professional Engineers of Ontario

PROJECT NORTH

Drawn
CT

Last worked on
4.2.2026

By
CT

Checked
DM

Scale
AS NOTED

BJC

architects + assocs. inc.

client
WATERLOO REGION
DISTRICT SCHOOL
BOARD

51 ARDELT AVE
KITCHENER ONTARIO

project
GRAND RIVER COLLEGIATE
INSTITUTE RENOVATION

175 INDIAN RD
KITCHENER ONTARIO

drawing title









OVERALL KEYPLAN
AND LEGEND

reference

project no. 25-092	client reference number
-----------------------	-------------------------

sheet no.	
-----------	--

	E	1	0	1	0	0
--	---	---	---	---	---	---

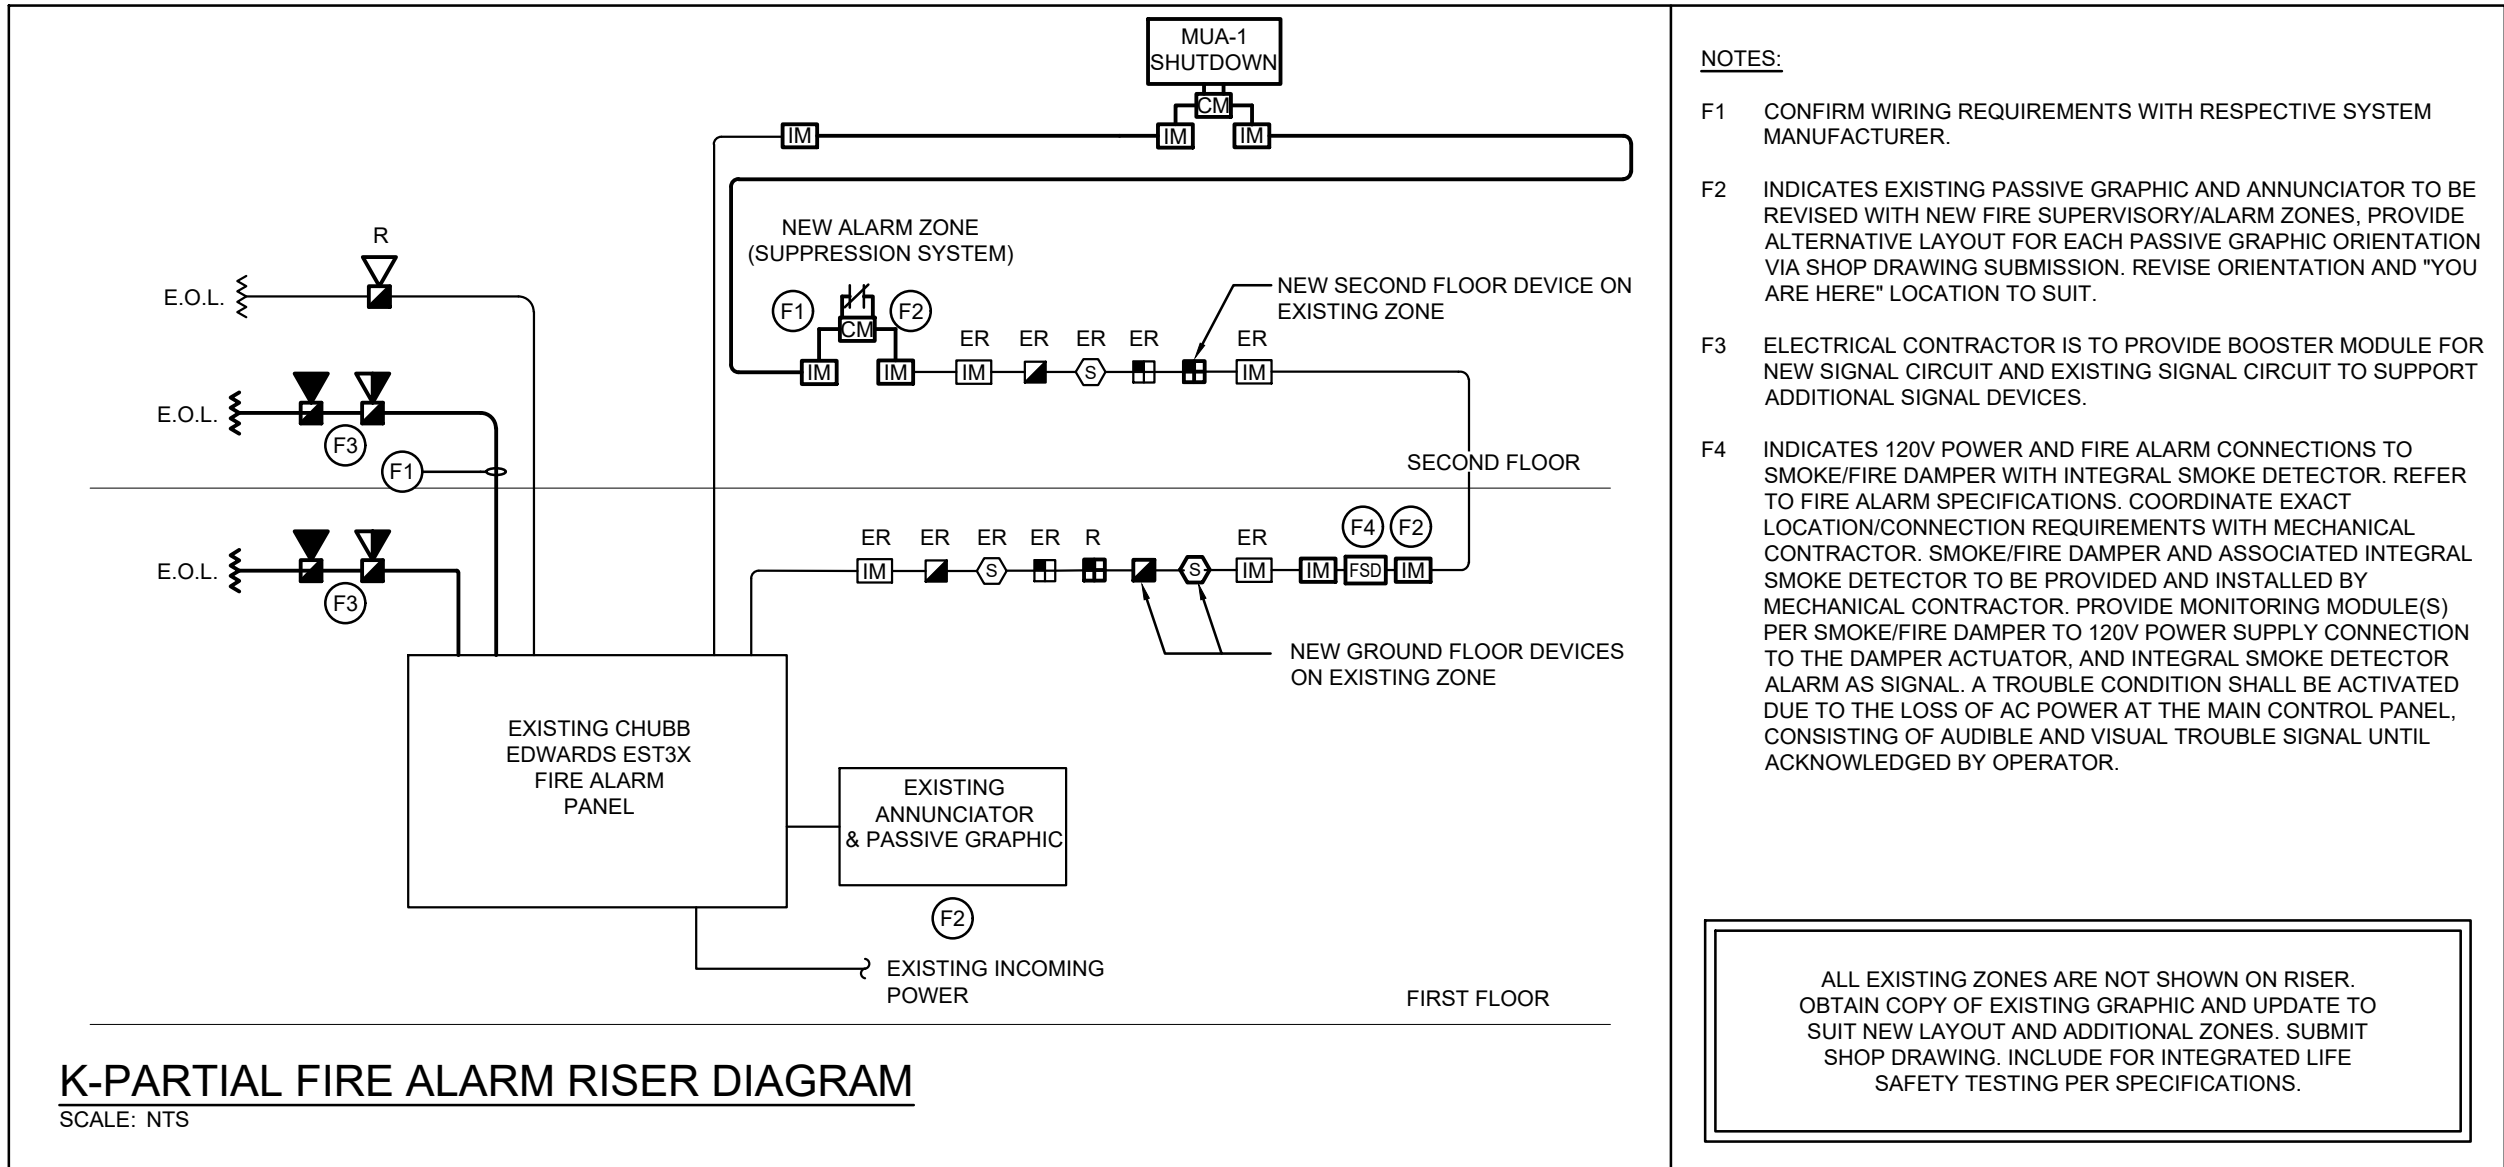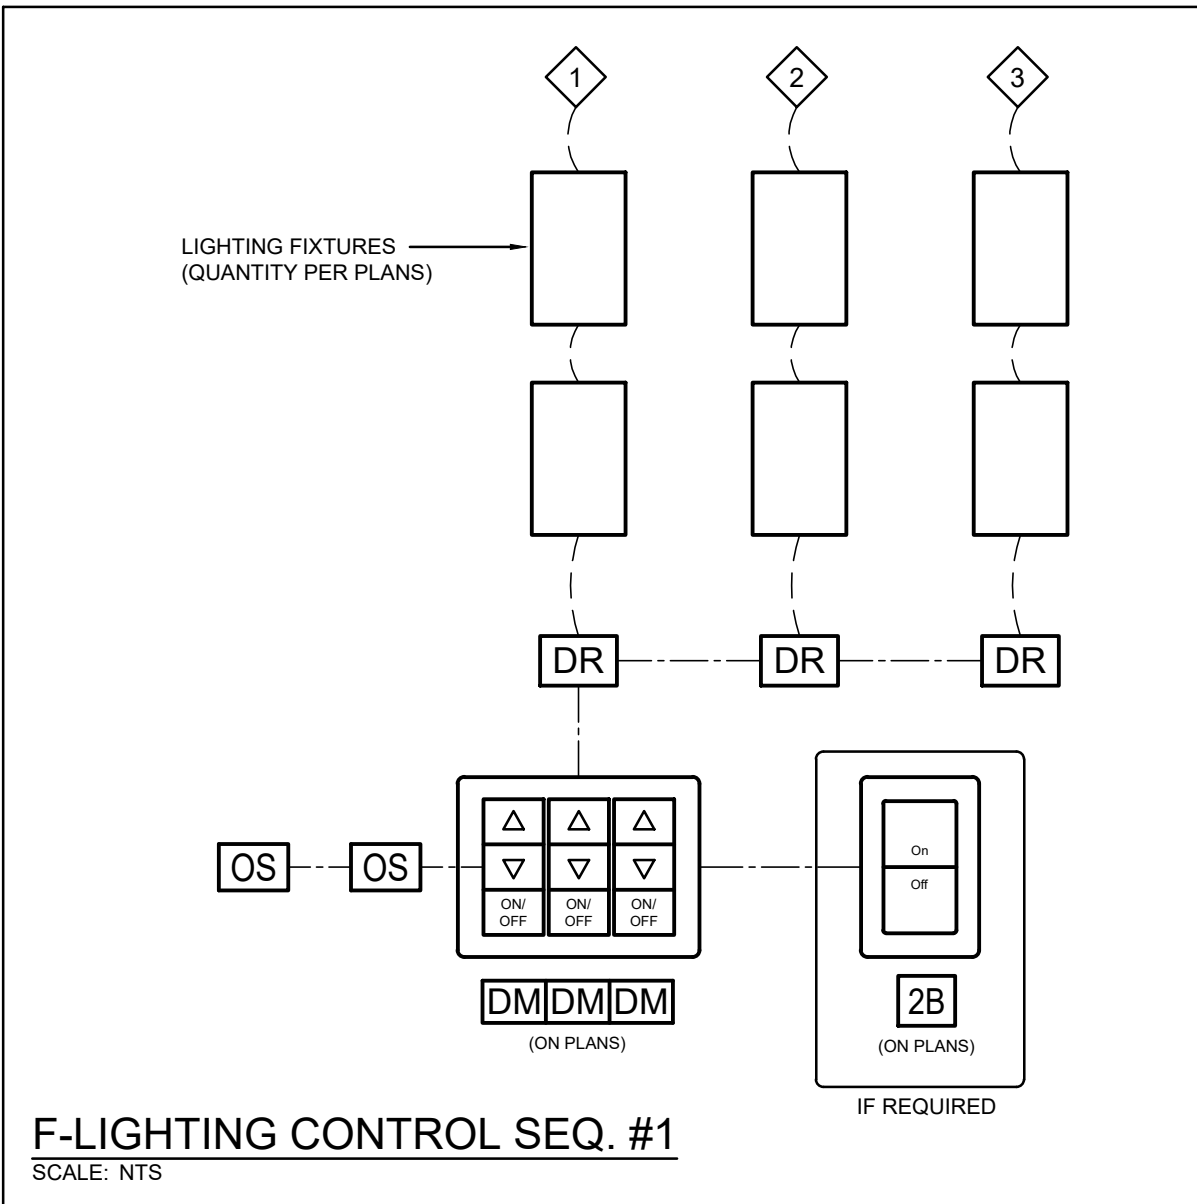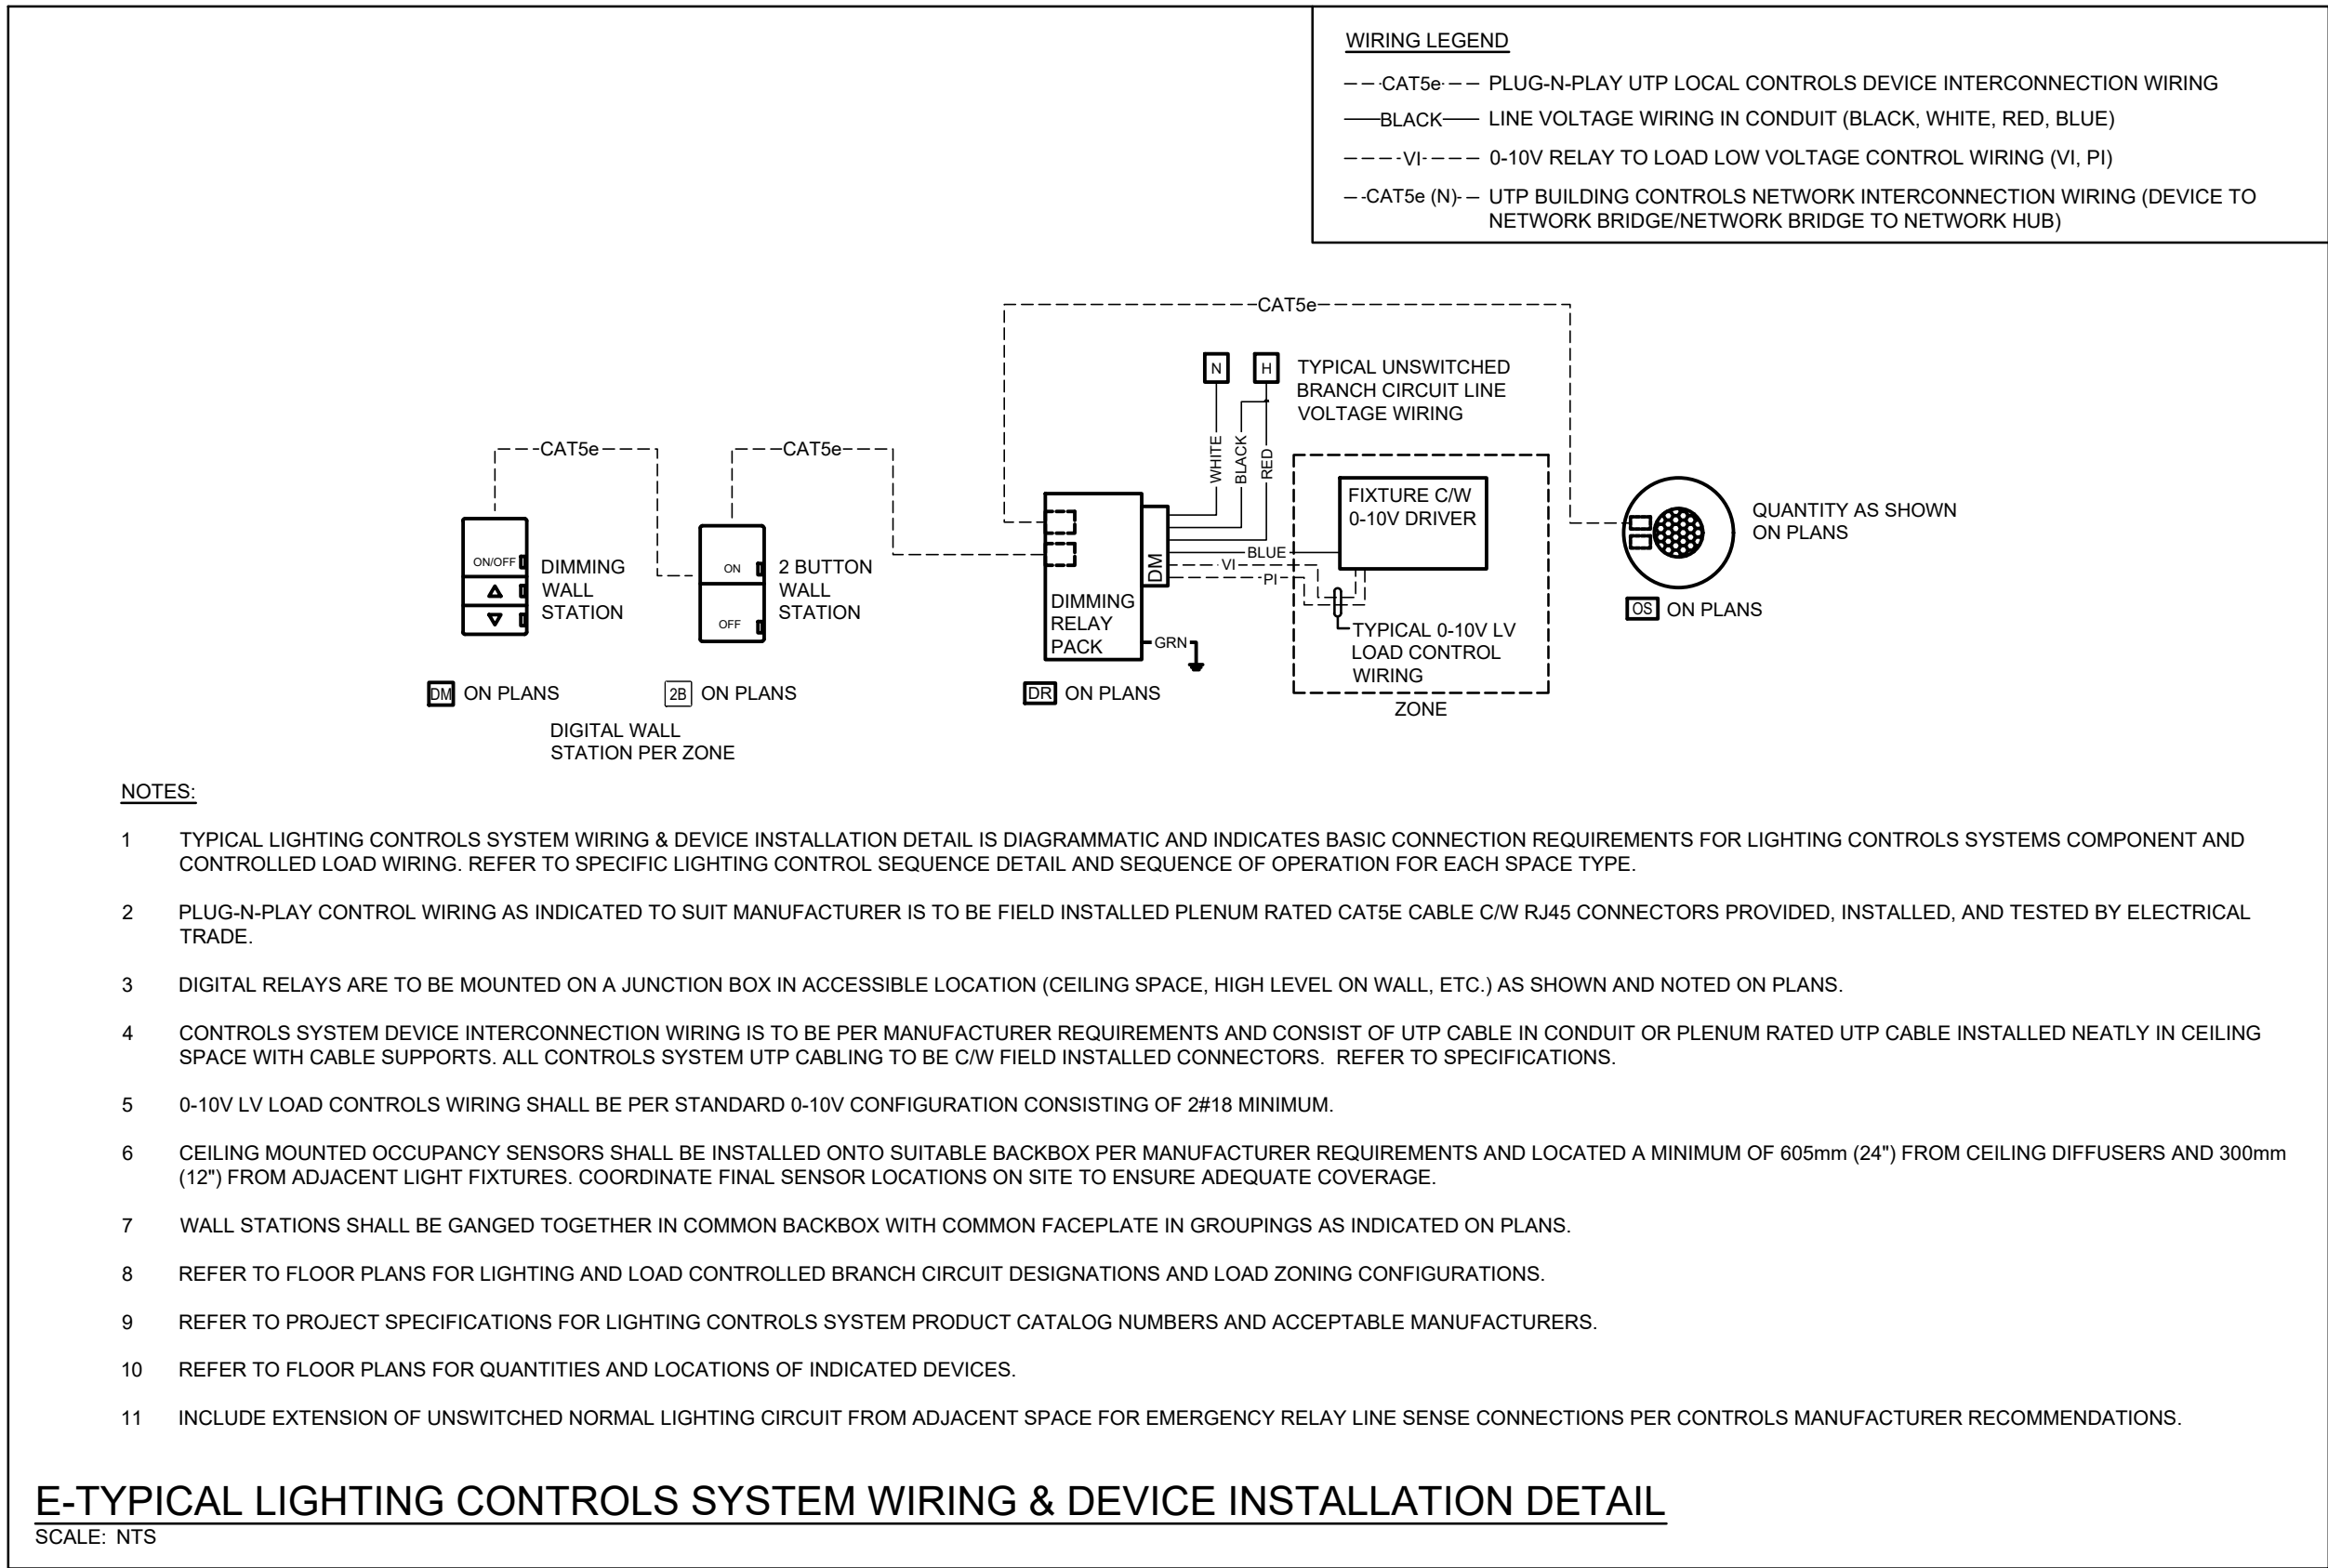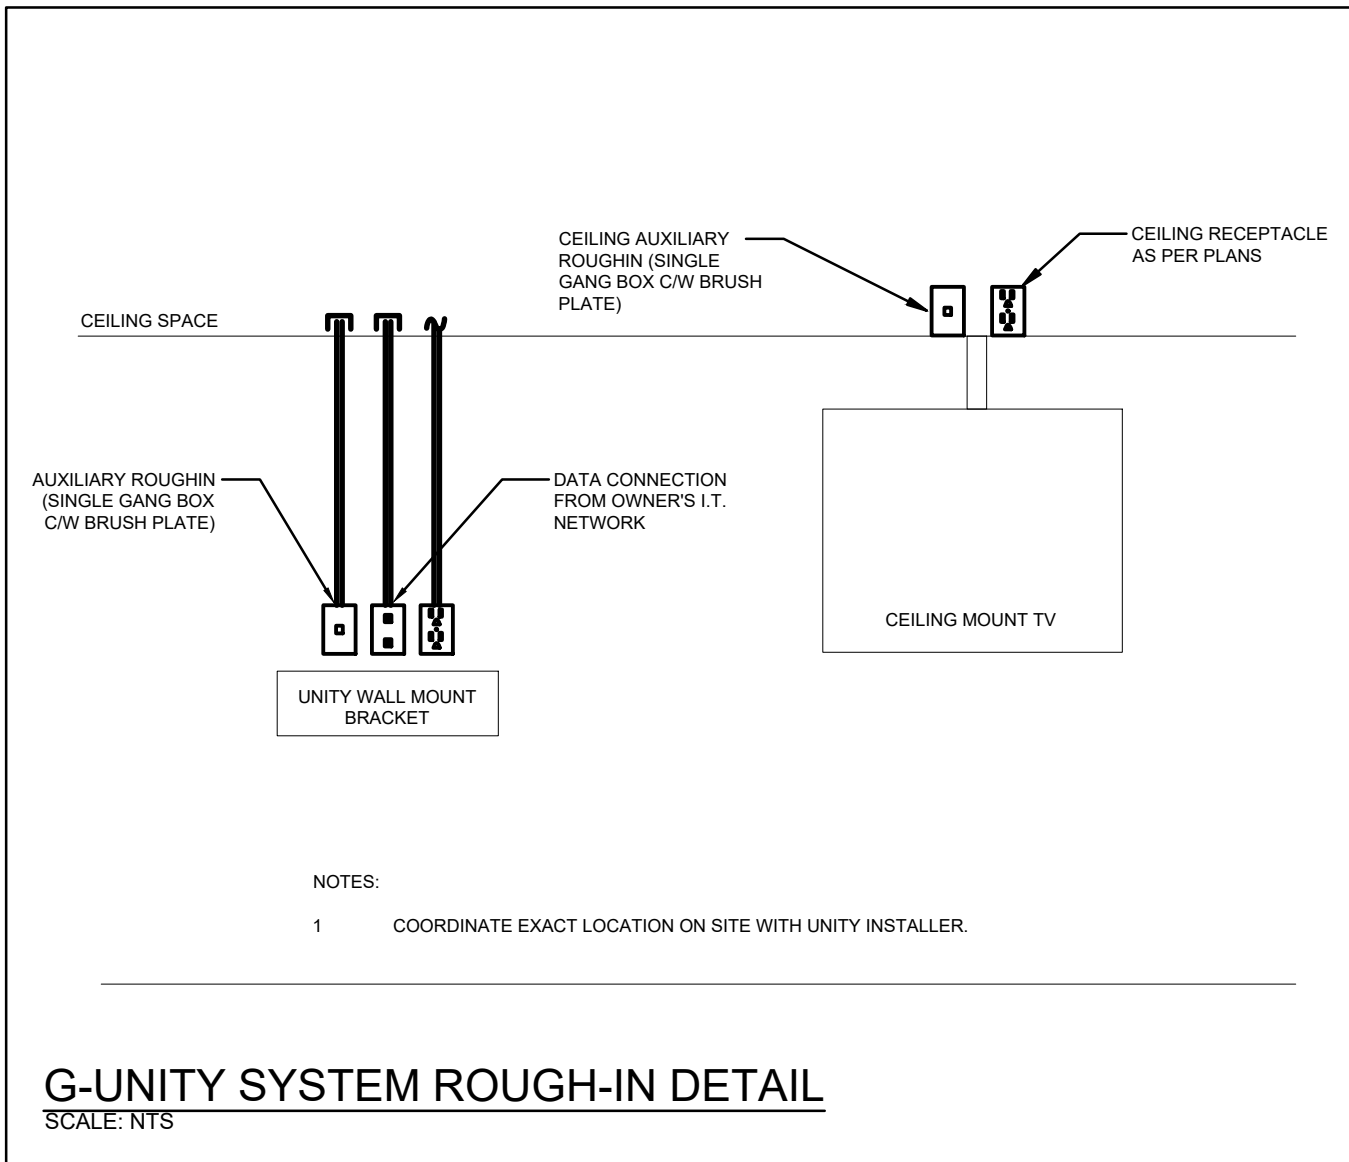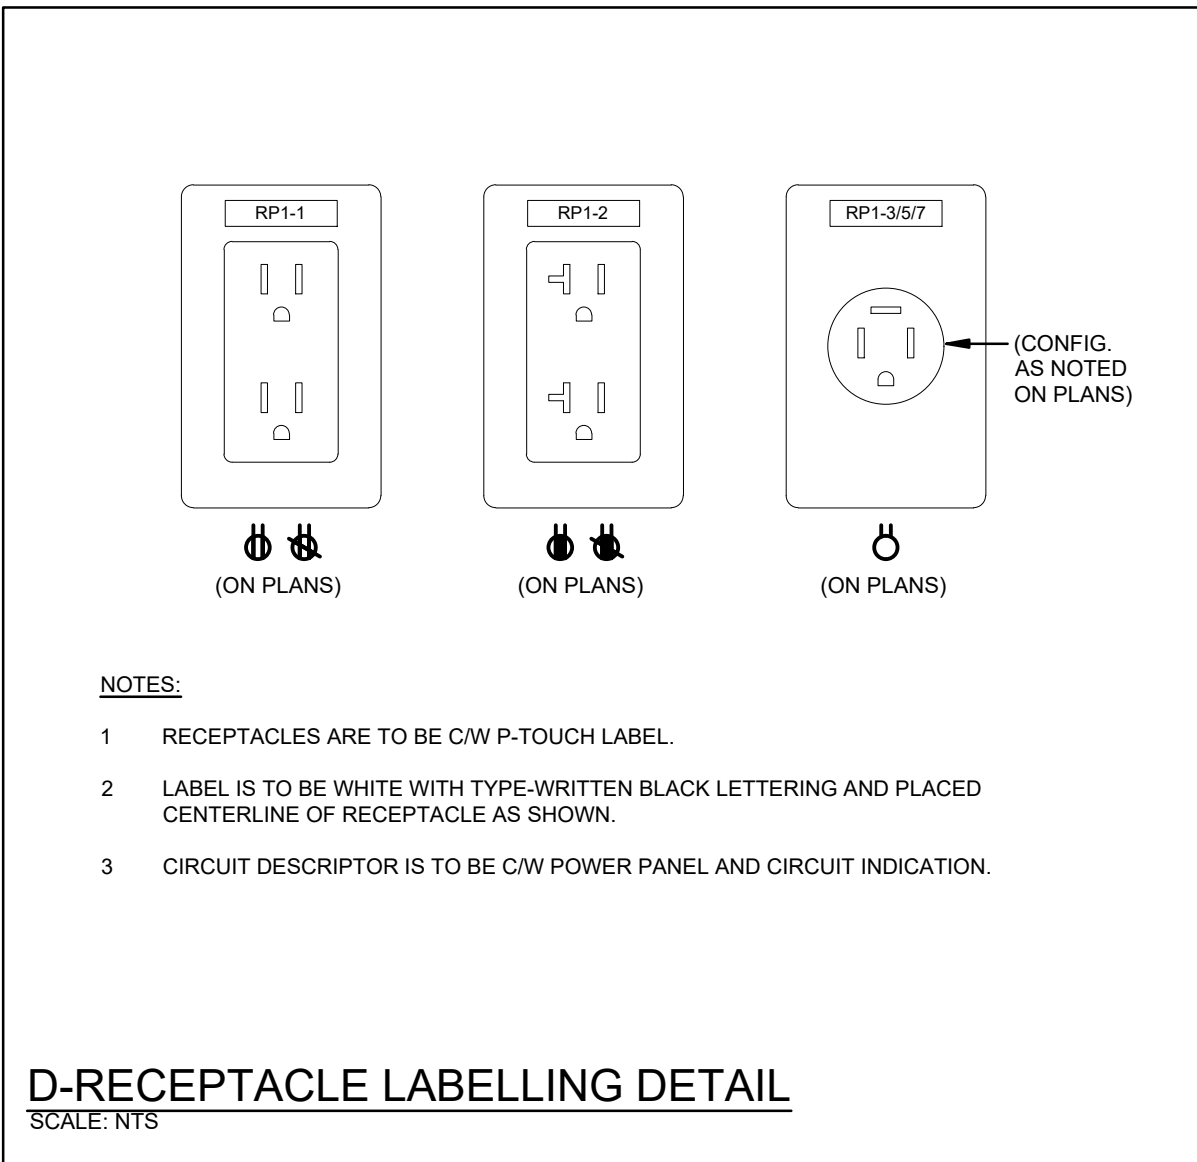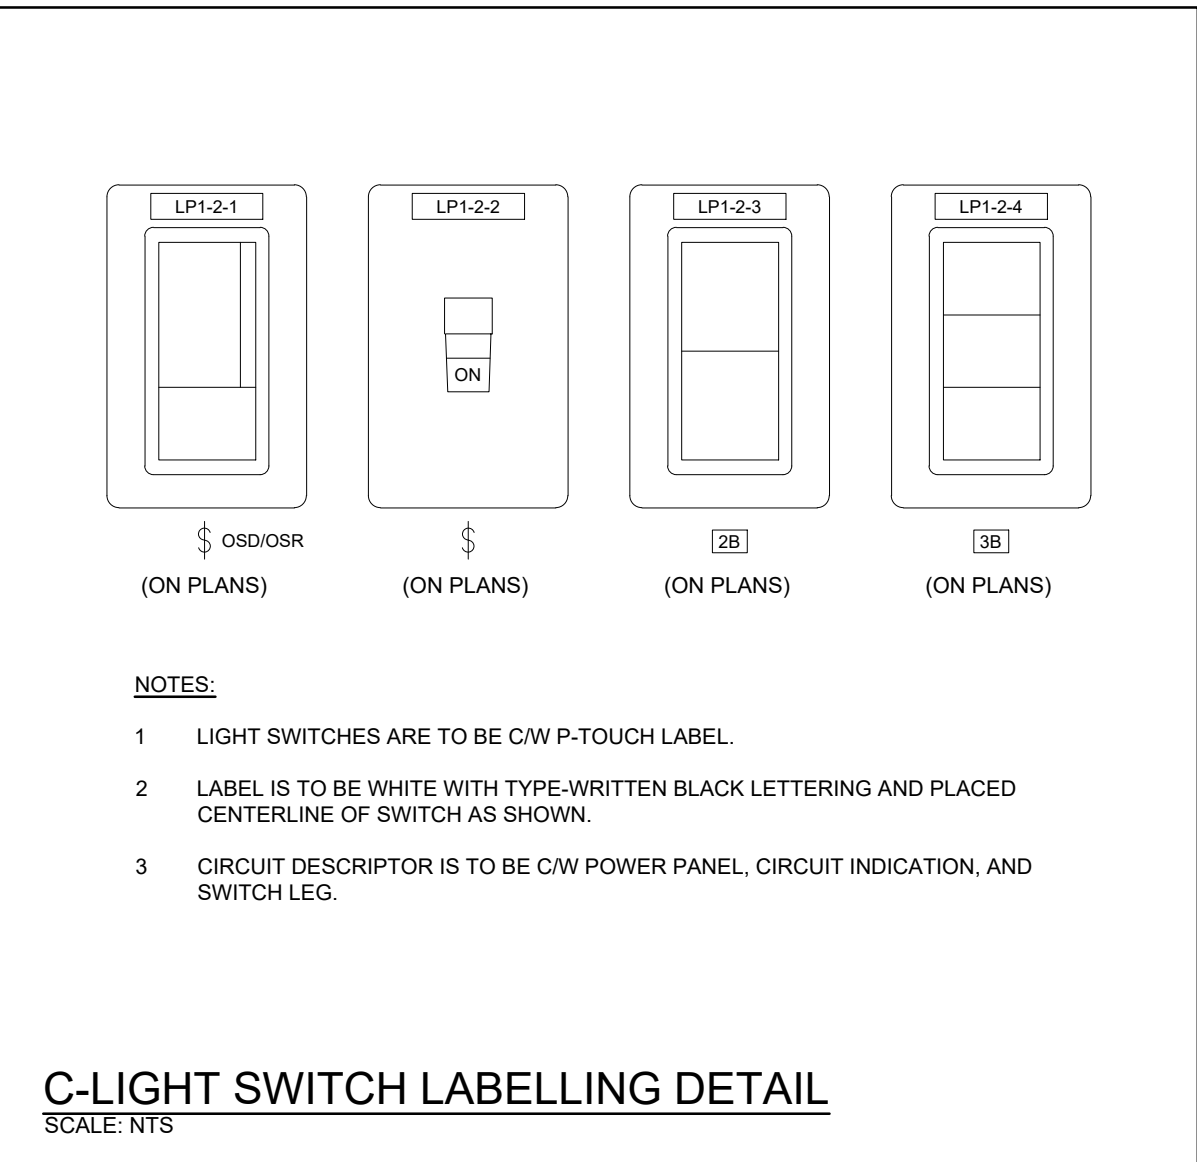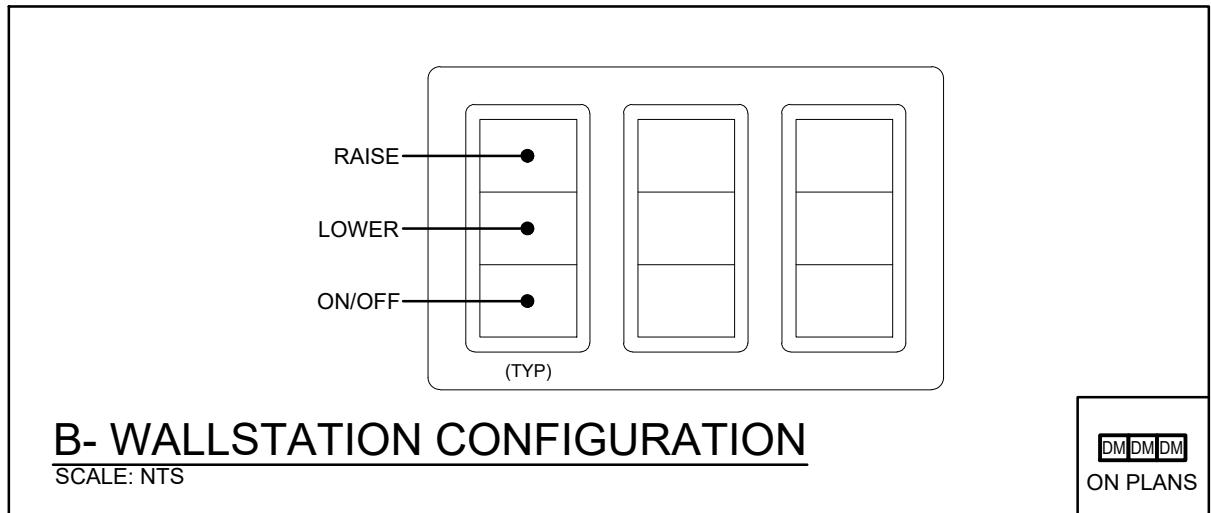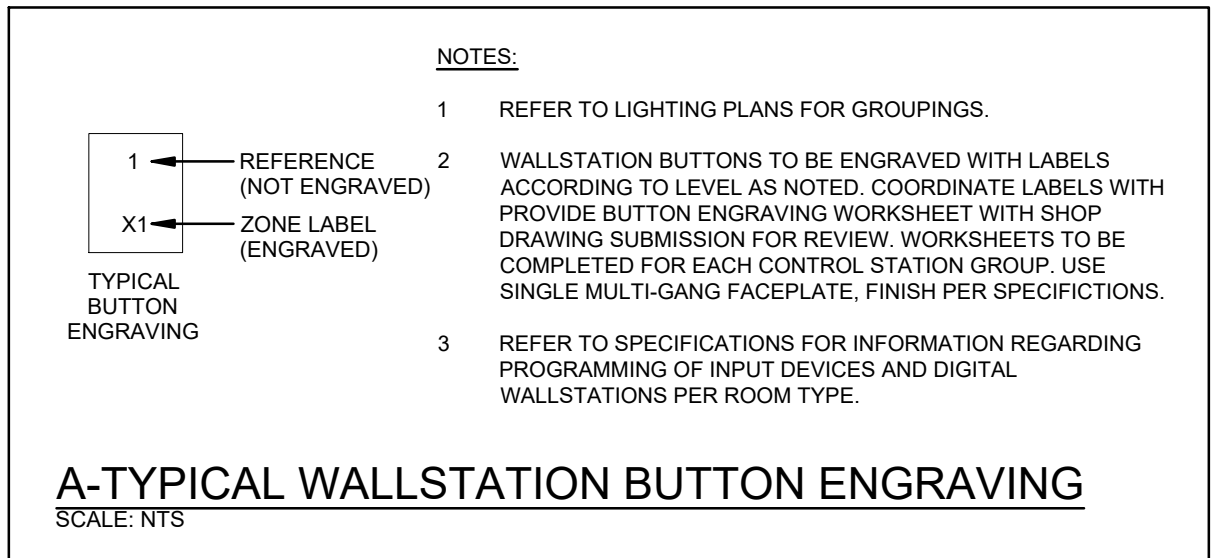

NOTE:

The contractor shall verify all dimensions and report all errors and discrepancies to the Consultant before commencement of the work.

The drawings show general arrangement of services. Follow as closely as actual building construction will permit. Obtain approval for relocation of service from Consultant before commencement of the work.

The drawings do not indicate all offsets fitting and accessories which may be required. Provide the same to meet the required conditions.

Drawings and specifications, etc., prepared and issued by the Consultant are the property of the Consultant and must be returned at the completion of the project. These documents are not to be duplicated or copied without the consent of the Consultant.

Do not scale this drawing.

© 2024 DEI Consulting Engineers Inc.

DEI

Consulting Engineers

MECHANICAL | ELECTRICAL | AQUATIC

55 Northland Road, Waterloo, ON N2V 2Y8

Phone: 519-745-3555

Website: deiassociates.ca

Project Number: x6092

01	ISSUED FOR PERMIT AND TENDER	2025.04.02
No.	REVISIONS	date

Professional Engineer
Ontario

04-2-2026

Limited Engineering Licensee

Name: D.G. MCCONKEY

Number: 100230476

Limitations: Detailed design, reporting, and specifications for all building electrical systems, site servicing and review of conformity for these systems in new and renovation construction

Association of Professional Engineers of Ontario

Drawn
CT

Last worked on
4.2.2026

By
CT

Checked
DM

Scale
AS NOTED

BJC

architects + assocs. inc.

client
WATERLOO REGION DISTRICT SCHOOL BOARD

51 ARDELT AVE
KITCHENER ONTARIO

project
GRAND RIVER COLLEGIATE INSTITUTE RENOVATION

175 INDIAN RD
KITCHENER ONTARIO

drawing title

DETAILS


reference

project no.
25-092

client reference number

sheet no.

E 1 0 2 0 0

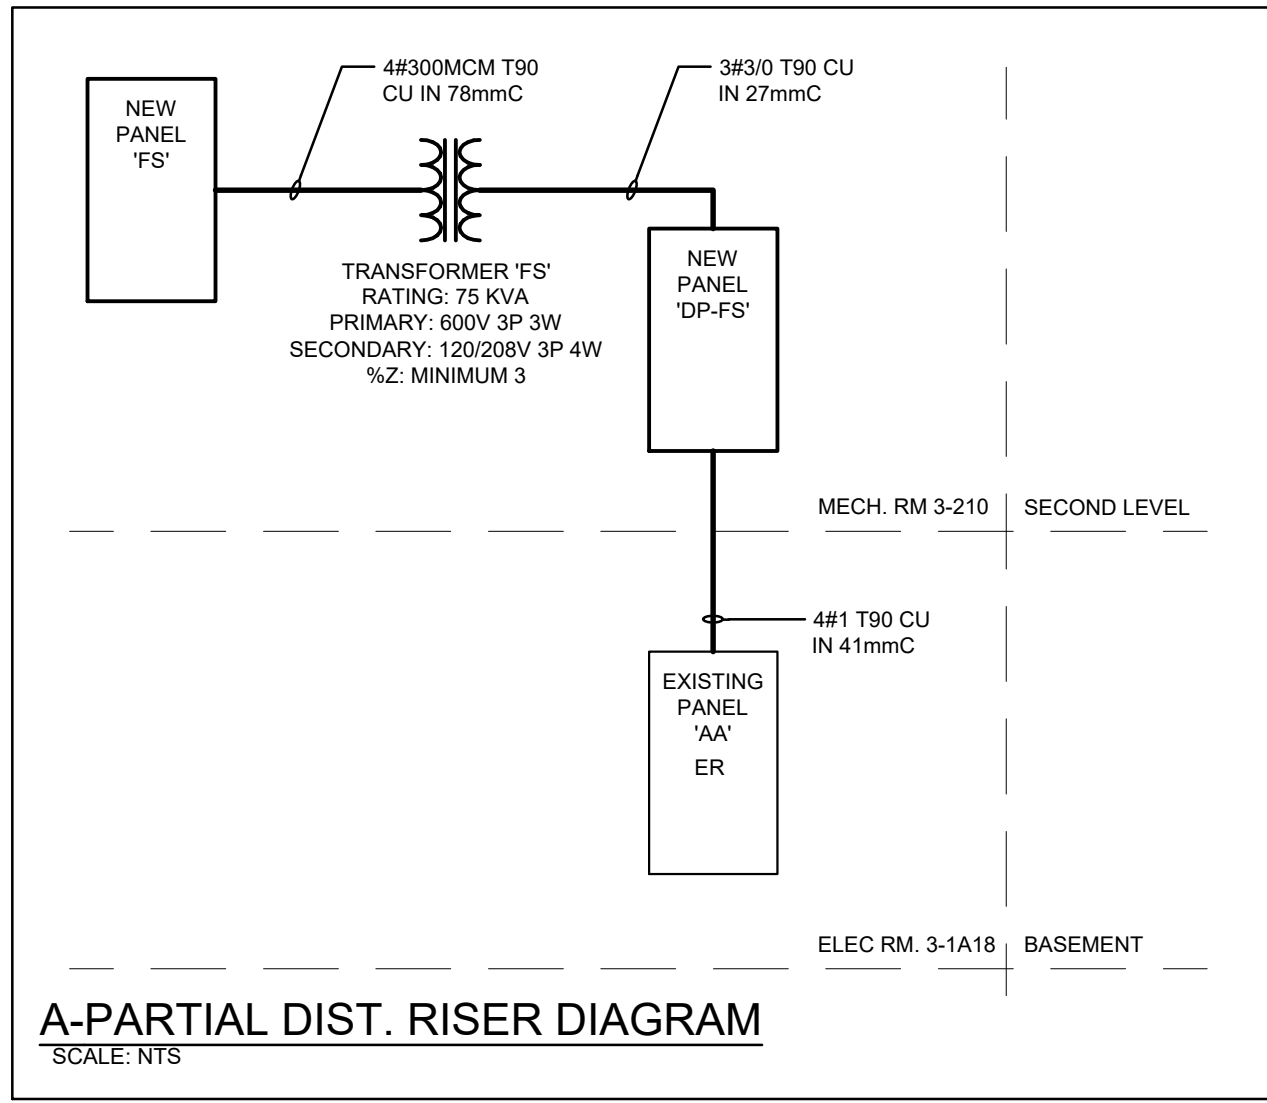

EQUIPMENT WIRING SCHEDULE

Description			Electrical Data			Starter			Ctrl Device			Isolating Device			Remote Items										Other	Interlock															
Mechanical Item	Description	Provided By	Voltage	Size hp/kW/Amps	Phase	MCCP	Magnetic	Manual	Combination	Contactor	VFD	ECM	Hand/Off/Auto	On/Off Selector	Start/Stop PB	High/Low/Off	Pilot Light	Motor Rated Switch c/w Pilot Light	Disconnect	WP Disconnect	Breaker/Fuse	Starter/Device Wired by	Thermostat	RA Thermostat	Programmable Time Clock	Variable Speed Control	Current Sensor	Dual Voltage Relay	Interval Timer	VRF System Control Panel	Smoke Control System Panel	Control Panel	Wired by	Bldg Auto System	Wired By	Miscellaneous 1	Miscellaneous 2	Interlock to	Interlock by	Remarks	
EF-1	RESIDENTIAL RANGE HOOD	M	120	FHP	1													E		E	E	E			M																
EF-5	ROOF TOP NFPA	M	208	1/2 HP	3								E						E	E	E										M	M/E	E	M	M			MUA-3	E	HAND-OFF-AUTO SHALL ONLY HAVE HAND AND AUTO FUNCTIONALITY. ON/OFF OF FAN VIA KITCHEN HOOD CONTROL PANEL	
MUA-3	OUTDOOR KITCHEN MUA	M	208	6.38 AMP	3	15													E	E	E	M											M	M	M			EF-5	E		
UV-1-220	UNIT VENTILATOR	M	120	6.3 AMP	1	15													E	E	E	M											M	M	M			CU-1-220	M		
H-1	CABINET HEATER	M	120	FHP	1														E	E	E	M											M	M	M						

E = ELECTRICAL
M = MECHANICAL
O = OTHERS

LIGHTING CONTROL SYSTEMS SEQUENCE OF OPERATION

Space Type	Room Names	Control Sequence / Control Device(s):	Control System
Classrooms	TYPICAL	Sequence: ON: Lights turned on to 50% output setting via occupancy sensor(s). ADJUST: The occupant manually adjusts lighting rows within the room to desired level or preset via scene station. OFF: 5 minutes after the room has been vacated, the lights will automatically turn off. OVERRIDE: User manually adjusts fixture zone lighting levels or on/off and that state shall remain without reverting to previous state unless sensors do not detect occupancy for extended period, whereby normal sensor operation is to resume.	DIGITAL ROOM CONTROL SYSTEM
SYSTEM DESCRIPTIONS: <u>DIGITAL OCCUPANCY AND DAYLIGHT CONTROL SYSTEMS</u> DIGITAL ROOM CONTROL RELAY POWER PACKS. REFER TO SPECIFICATIONS SECTION 26 05 75.		<u>LINE VOLTAGE OCCUPANCY CONTROL SYSTEM</u> LINE VOLTAGE WALL SENSOR SWITCHES AND LINE VOLTAGE POWER PACKS WITH HARD WIRED SENSORS. REFER TO SPECIFICATIONS SECTION 26 05 75.	

LIGHT FIXTURE SCHEDULE (INTERIOR)

Item	Manufacturer/Catalog Number	Voltage	Lamp					Mounting	Required Listings	Description
			Type	Lumens	Colour Temperature	Wattage	CRI			
A1	COOPER CAT. #24C22-LD5-40-UNV-L840-CD-1 LITHONIA CAT. #2BLT4 40L AD5M MVOLT G21 LP840 GENLYTE CFI CAT. #2FGXG43L840-4-R-UNV-DIM	120V	LED	4257	4000K	30.4W	80	RECESSED	N/A	2'X4' (610mmX1220mm) VOLUMETRIC LED TROFFER C/W SMOOTH FROSTED ACRYLIC CENTRE LENS, 1% 0-10V DIMMING DRIVER, AND WHITE FINISH.
EMERG. BATT. (LINEAR STYLE)	AIMLITE #EBWL SERIES: EM-7 #EBWL-EMWHT-TB-2-ATD/VDR LUMACELL #LBL SERIES EM-7 #LBL-EM C/W KIT-5R-L	120V	LED	N/A	N/A	14W	N/A	RECESSED	IC	LONG LIFE, SEALED RECHARGABLE VANDAL RESISTANT BATTERY C/W ADJUSTABLE 14W LED MODULES, POLYCARBONATE BODY, 90 MINUTE BATTERY DURATION, RECESSED T-BAR MOUNTING, AND AUTOTEST FEATURE.
EXIT LIGHTS	AIMLITE CAT. #RPAWUMWHTUNVDC STANPRO CAT. #RMTEDUMBA-UDC/BBX-TE-BA-U LUMACELL CAT. #LA3WU	12V/120V	LED	N/A	N/A	2.5 WATT (MAX) AC 2 WATT (MAX) DC	N/A	SURFACE	N/A	LED EXTRUDED ALUMINUM PICTOGRAM FIXTURE C/W GREEN FACE AND WHITE LEGEND, UNIVERSAL MOUNTING TO SUIT WALL, END OR CEILING, AND MAXIMUM 2.5" (63mm) THICKNESS. FACES AND CHEVRONS TO SUIT DRAWINGS.
Notes: 1. LED LUMEN VALUES QUOTED FOR FIXTURES ARE TO BE CONSIDERED MINIMUM, AND AS ABSOLUTE OR DELIVERED LUMENS. LUMEN VALUES SHOULD NOT EXCEED MORE THAN 10% OF SPECIFIED OUTPUT. 2. TENDER PRICE TO INCLUDE ONLY APPROVED MANUFACTURERS LISTED ON SCHEDULE. EQUAL MANUFACTURERS ARE NOT BEING CONSIDERED FOR THIS TENDER UNLESS SPECIFICALLY IDENTIFIED ON SCHEDULE FOR NOTED FIXTURE TYPES. FOR NOTED APPROVED EQUALS TO BE CONSIDERED APPROVED, MANUFACTURERS/SUPPLIERS MUST CONFIRM THE PROPOSED EQUAL BY EMAIL WITH CONSULTANT'S OFFICE PRIOR TO PROJECT ADDENDUM PERIOD CLOSE. 3. IT IS THE RESPONSIBILITY OF THIS ELECTRICAL CONTRACTOR TO IDENTIFY TO THE ELECTRICAL CONSULTANT'S ATTENTION ANY DISCREPANCIES BETWEEN THE FIXTURE CATALOG NUMBER AND FIXTURE DESCRIPTION, AND OR VOLTAGE, OUTPUT, OR MOUNTING, PRIOR TO TENDER CLOSE. NO EXTRAS WILL BE ENTERTAINED FOR FAILURE TO DO SO. FINAL FIXTURE CHARACTERISTICS AND DESCRIPTION WILL BE MARKED BY CONSULTANT AT THE TIME OF SHOP DRAWING REVIEW. FOR THE PURPOSES OF BIDDING, INCLUDE FOR A FIXTURE MATCHING THE VOLTAGE, MOUNTING, LOCATION AND NOTATIONS SHOWN ON LIGHTING DESIGN DRAWINGS.										

PANEL 'FS'

MAINS: 400A
VOLTAGE: 120/208V
RATING: 3P 4W
NEUTRAL: FULL
MOUNTING: RECESSED
ACCESSORIES:

CONTRACTOR TO COORDINATE FINAL ROOM NAMES AND NUMBERS NOTED WITH INFORMATION ISSUES DURING CONSTRUCTION AND ADJUST DIRECTORIES TO SUIT.

Description	Breaker	Type	Circuit#	A	B	C	Circuit#	Type	Breaker	Description
UNIT VENTILATOR UV-1-220	15A	--	1	*			2	--	15A	C.R 1-220 RANGEHOOD
FAM. STUD. 220 MW REC	20A	--	3	*			4	--	15A	C.R 1-220 RANGEHOOD
FAMILY STUDIES FSD'S	15A	--	5	*			6	--	15A	C.R 1-220 RANGEHOOD
FAM. STUD. 220 DRYER REC	30A	--	7	*			8	--	15A	C.R 1-220 RANGEHOOD
FAM. STUD. 220 STOVE REC	2P	--	9	*			10	--	50A	FAM. STUD. 220 STOVE REC
FAM. STUD. 220 STOVE REC	50A	--	11	*			12	--	2P	
FAM. STUD. 220 STOVE REC	2P	--	13	*			14	--	50A	FAM. STUD. 220 STOVE REC
FAM. STUD. 220 STOVE REC	50A	--	15	*			16	--	2P	
FAM. STUD. 220 STOVE REC	2P	--	17	*			18	--	50A	FAM. STUD. 220 STOVE REC
FAM. STUD. 220 WASH. MACH.	20A	--	19	*			20	--	2P	
FAM. STUD. 220 FRIDGE REC	15A	--	21	*			22	--	20A	FAM. STUD. 220 T-SLOT RECS
FAM. STUD. 220 FRIDGE REC	15A	--	23	*			24	--	20A	FAM. STUD. 220 T-SLOT RECS
TEACHER DESK RECEPTACLE	15A	--	25	*			26	--	20A	FAM. STUD. 220 T-SLOT RECS
PROJECTOR RECEPTACLE	15A	--	27	*			28	--	20A	FAM. STUD. 220 T-SLOT RECS
CEILING TV RECEPTACLE	15A	--	29	*			30	5mA	15A	DISHWASHER
ISLAND T-SLOT REC	20A	--	31	*			32	5mA	15A	NFPA HOOD LTG
ISLAND T-SLOT REC	20A	--	33	*			34	--	15A	UNITY SYSTEM POWER
FAM. STUD. 221 PROJECTOR	15A	--	35	*			36	--	15A	FAM. STUD. 221 UNITY RECS
FAM. STUD. 220 GEN. RECS	15A	--	37	*			38	--	20A	FAM. STUD. 220 T-SLOT RECS
SPACE			39	*			40	--	20A	FAM. STUD. 220 T-SLOT RECS
SPACE			41	*			42	--		SPACE
SPACE			43	*			44	--		SPACE
SPACE			45	*			46	--		SPACE
SPACE			47	*			48	--		SPACE
SPACE			49	*			50	--		SPACE
ROOFTOP NFPA EXHAUST EF-5	15A		51	*			52	--		SPACE
			53	*			54	--	20A	ROOFTOP T-SLOT RECEPTACLE
	3P		55	*			56	--	15A	INDOOR KITCHEN MUA -3
SPACE			57	*			58	--		
SPACE			59	*			60	--	3P	
SPACE			61	*			62	--		SPACE
SPACE			63	*			64	--		SPACE
SPACE			65	*			66	--		SPACE
SPACE			67	*			68	--		SPACE
SPACE			69	*			70	--		SPACE
SPACE			71	*			72	--		SPACE

NOTES:
THE INDICATED PANEL ASSEMBLY MUST HAVE AN INTERRUPTING CAPACITY OF 10000 AIC. PROVIDE BY EITHER FULLY RATED BREAKERS OR INTEGRATED EQUIPMENT RATING WITH THE UPSTREAM BREAKER.

PANEL 'DP-FS'

MAINS: 225A
VOLTAGE: 347/600V
RATING: 3P 4W
NEUTRAL: FULL
MOUNTING: SURFACE
ACCESSORIES: SPRINKLER HOOD

CONTRACTOR TO COORDINATE FINAL ROOM NAMES AND NUMBERS NOTED WITH INFORMATION ISSUES DURING CONSTRUCTION AND ADJUST DIRECTORIES TO SUIT.

Description	Breaker	Type	Circuit#	A	B	C	Circuit#	Type	Breaker	Description
SPARE	15A	--	1	*			2	--	15A	SPARE
SPACE	--	--	3	*			4	--		
SPACE	3P	--	5	*			6	--	3P	
SPACE	--	--	7	*			8	--		SPACE
SPACE	--	--	9	*			10	--		SPACE
SPACE	--	--	11	*			12	--		SPACE
SPACE	--	--	13	*			14	--		SPACE
SPACE	--	--	15	*			16	--		SPACE
SPACE	--	--	17	*			18	--		SPACE
SPACE	--	--	19	*			20	--		SPACE
SPACE	--	--	21	*			22	--		SPACE
SPACE	--	--	23	*			24	--		SPACE
SPACE	--	--	25	*			26	--		SPACE
SPACE	--	--	27	*			28	--		SPACE
SPACE	--	--	29	*			30	--		SPACE
SPACE	--	--	31	*			32	--		SPACE
SPACE	--	--	33	*			34	--		SPACE
SPACE	--	--	35	*			36	--		SPACE
SPACE	90A	--	37	*			38	--	90A	TX-FS
SPACE	--	--	39	*			40	--		
SPACE	3P	--	41	*			42	--	3P	

NOTES:
THE INDICATED PANEL ASSEMBLY MUST HAVE AN INTERRUPTING CAPACITY OF 10000 AIC. PROVIDE BY EITHER FULLY RATED BREAKERS OR INTEGRATED EQUIPMENT RATING WITH THE UPSTREAM BREAKER.

EXISTING PANEL 'AA'

MAINS: 225A
VOLTAGE: 347/600V
RATING: 3P 4W
NEUTRAL: FULL
MOUNTING: SURFACE
ACCESSORIES: SPRINKLER HOOD

CONTRACTOR TO COORDINATE FINAL ROOM NAMES AND NUMBERS NOTED WITH INFORMATION ISSUES DURING CONSTRUCTION AND ADJUST DIRECTORIES TO SUIT.

Description	Breaker	Type	Circuit#	A	B	C	Circuit#	Type	Breaker	Description
ROOFTOP HEATING/HV-2 UNIT	30A	--	1	*			2	--	20A	EXTERIOR PARKING LTG.
SPACE	--	--	3	*			4	--		SPACE
SPACE	3P	--	5	*			6	--		SPACE
ROOFTOP HEATING/HV-3 UNIT	30A	--	7	*			8	--		SPACE
SPACE	--	--	9	*			10	--		SPACE
ROOFTOP HEATING/HV-4 UNIT	30A	--	11	*			12	--		SPACE
SPACE	--	--	13	*			14	--		SPACE
SPACE	3P	--	15	*			16	--		SPACE
SPACE	--	--	17	*			18	--		SPACE
SPACE	--	--	19	*			20	--		SPACE
SPACE	--	--	21	*			22	--		SPACE
SPACE	--	--	23	*			24	--		SPACE
SPACE	--	--	25	*			26	--		SPACE
SPACE	--	--	27	*			28	--		SPACE
SPACE	--	--	29	*			30	--		SPACE
SPACE	90A	--	31	*			32	--	20A	SPARE
SPACE	--	--	33	*			34	--	20A	SPARE
SPACE	3P	--	35	*			36	--	20A	SPARE
TRANSFORMER 'A1'	90A	--	37	*			38	--	15A	SPARE
SPACE	--	--	39	*			40	--	15A	SPARE
SPACE	3P	--	41	*			42	--	15A	SPARE

PROPOSED PANEL 'AA'

Description	Breaker	Type	Circuit#	A	B	C	Circuit#	Type	Breaker	Description
ROOFTOP HEATING/HV-2 UNIT	30A	--	1	*			2	--	20A	EXTERIOR PARKING LTG.
SPACE	--	--	3	*			4	--		SPACE
SPACE	3P	--	5	*			6	--		SPACE
ROOFTOP HEATING/HV-3 UNIT	30A	--	7	*			8	--		SPACE
SPACE	--	--	9	*			10	--		SPACE
ROOFTOP HEATING/HV-4 UNIT	30A	--	11	*			12	--		SPACE
SPACE	--	--	13	*			14	--		SPACE
SPACE	3P	--	15	*			16	--		SPACE
SPACE	--	--	17	*			18	--		SPACE
SPACE	--	--	19	*			20	--		SPACE
SPACE	--	--	21	*			22	--		SPACE
SPACE	--	--	23	*			24	--		SPACE
SPACE	--	--	25	*			26	--	125A	DIST. PANEL 'DP-FS'
SPACE	--	--	27	*			28	--		
SPACE	--	--	29	*			30	--	3P	
SPACE	90A	--	31	*			32	--	20A	SPARE
SPACE	--	--	33	*			34	--	20A	SPARE
SPACE	3P	--	35	*			36	--	20A	SPARE
TRANSFORMER 'A1'	90A	--	37	*			38	--	15A	SPARE
SPACE	--	--	39	*			40	--	15A	SPARE
SPACE	3P	--	41	*			42	--	15A	SPARE

DESIGNATION
ER INDICATES EXISTING SERVICE AND BREAKER THAT SHOULD REMAIN UNLOCKED.
'SP' INDICATES EXISTING BREAKER THAT MAY BECOME SPARE DUE TO DEMOLITION. (CONFIRM ON SITE).
'RW' INDICATES EXISTING BREAKER THAT SHOULD BE REWIRED TO SERVICE DEVICES INDICATED ON PLAN.
'SB' INDICATES SPARE BREAKER TO BE USED FOR NEW SERVICE INDICATED.
'NB' INDICATES NEW BREAKER AND WIRING TO SERVICE INDICATED. PROVIDE MOUNTING HARDWARE AS REQUIRED.
'D' INDICATES EXISTING BREAKER TO BE REMOVED COMPLETE. PROVIDE FILLER PLATES AS REQUIRED.
NOTES:
THIS CONTRACTOR IS TO INVESTIGATE BREAKERS AND REVISE PANEL SCHEDULES TO SUIT RENOVATION, NOTING ANY BREAKERS THAT BECOME SPARE DUE TO DEMOLITION. THIS CONTRACTOR IS ALSO TO NOTIFY THE CONSULTANT OF ANY BREAKERS THAT ARE INDICATED TO BE DEMOLISHED OR REUSED, BUT WHICH ARE IN USE BY OTHER DEVICES OR SERVICES.








NOTE:
The contractor shall verify all dimensions and report all errors and discrepancies to the Consultant before commencement of the work.
The drawings show general arrangement of services. Follow as closely as actual building construction will permit. Obtain approval for relocation of service from Consultant before commencement of the work.
The drawings do not indicate all offsets fitting and accessories which may be required. Provide the same to meet the required conditions.
Drawings and specifications, etc., prepared and issued by the Consultant are the property of the Consultant and must be returned at the completion of the project. These documents are not to be duplicated or copied without the consent of the Consultant.
Do not scale the drawing.
© 2024 DEI Consulting Engineers Inc.










01	ISSUED FOR PERMIT AND TENDER	2025.04.02
No.	REVISIONS	date

Professional Engineer
Ontario
Limited Engineering Licensee
Name: D.G. McCONKEY
Number: 100230476
Limitations: Detailed design, reporting,

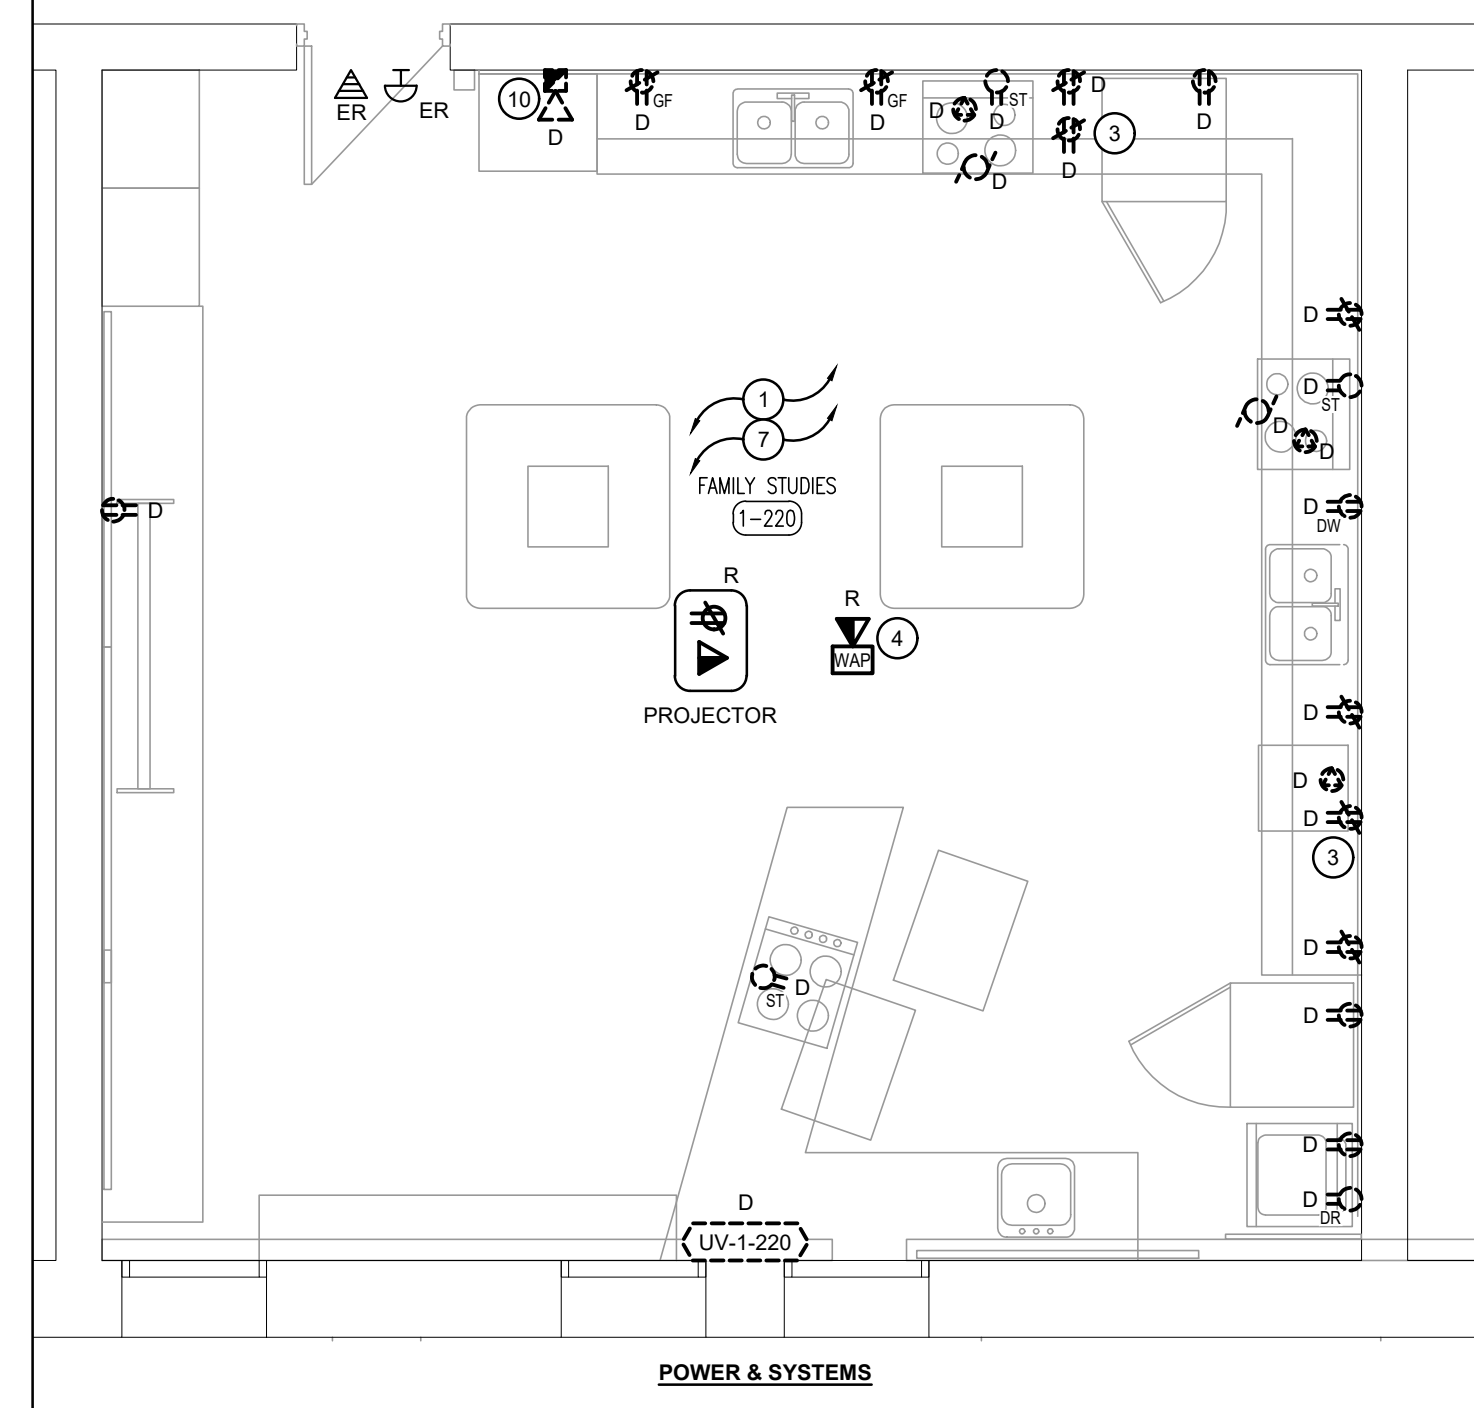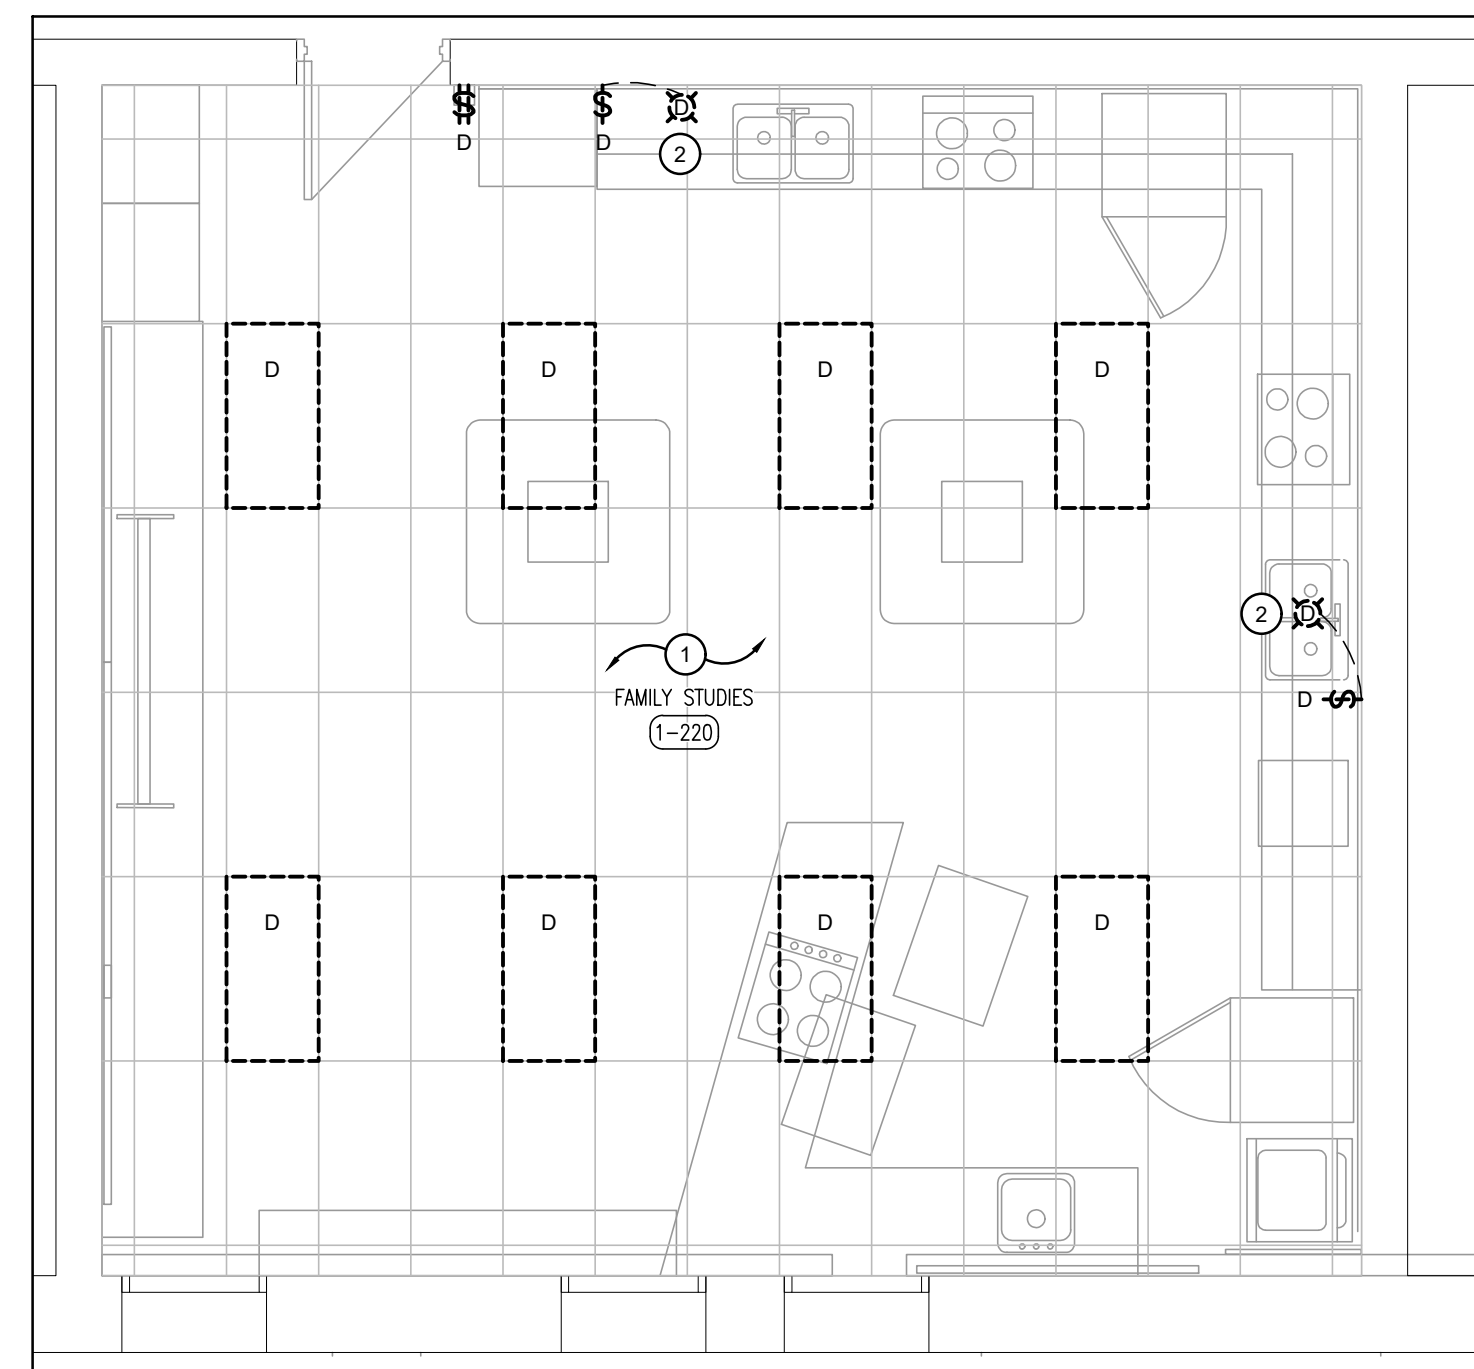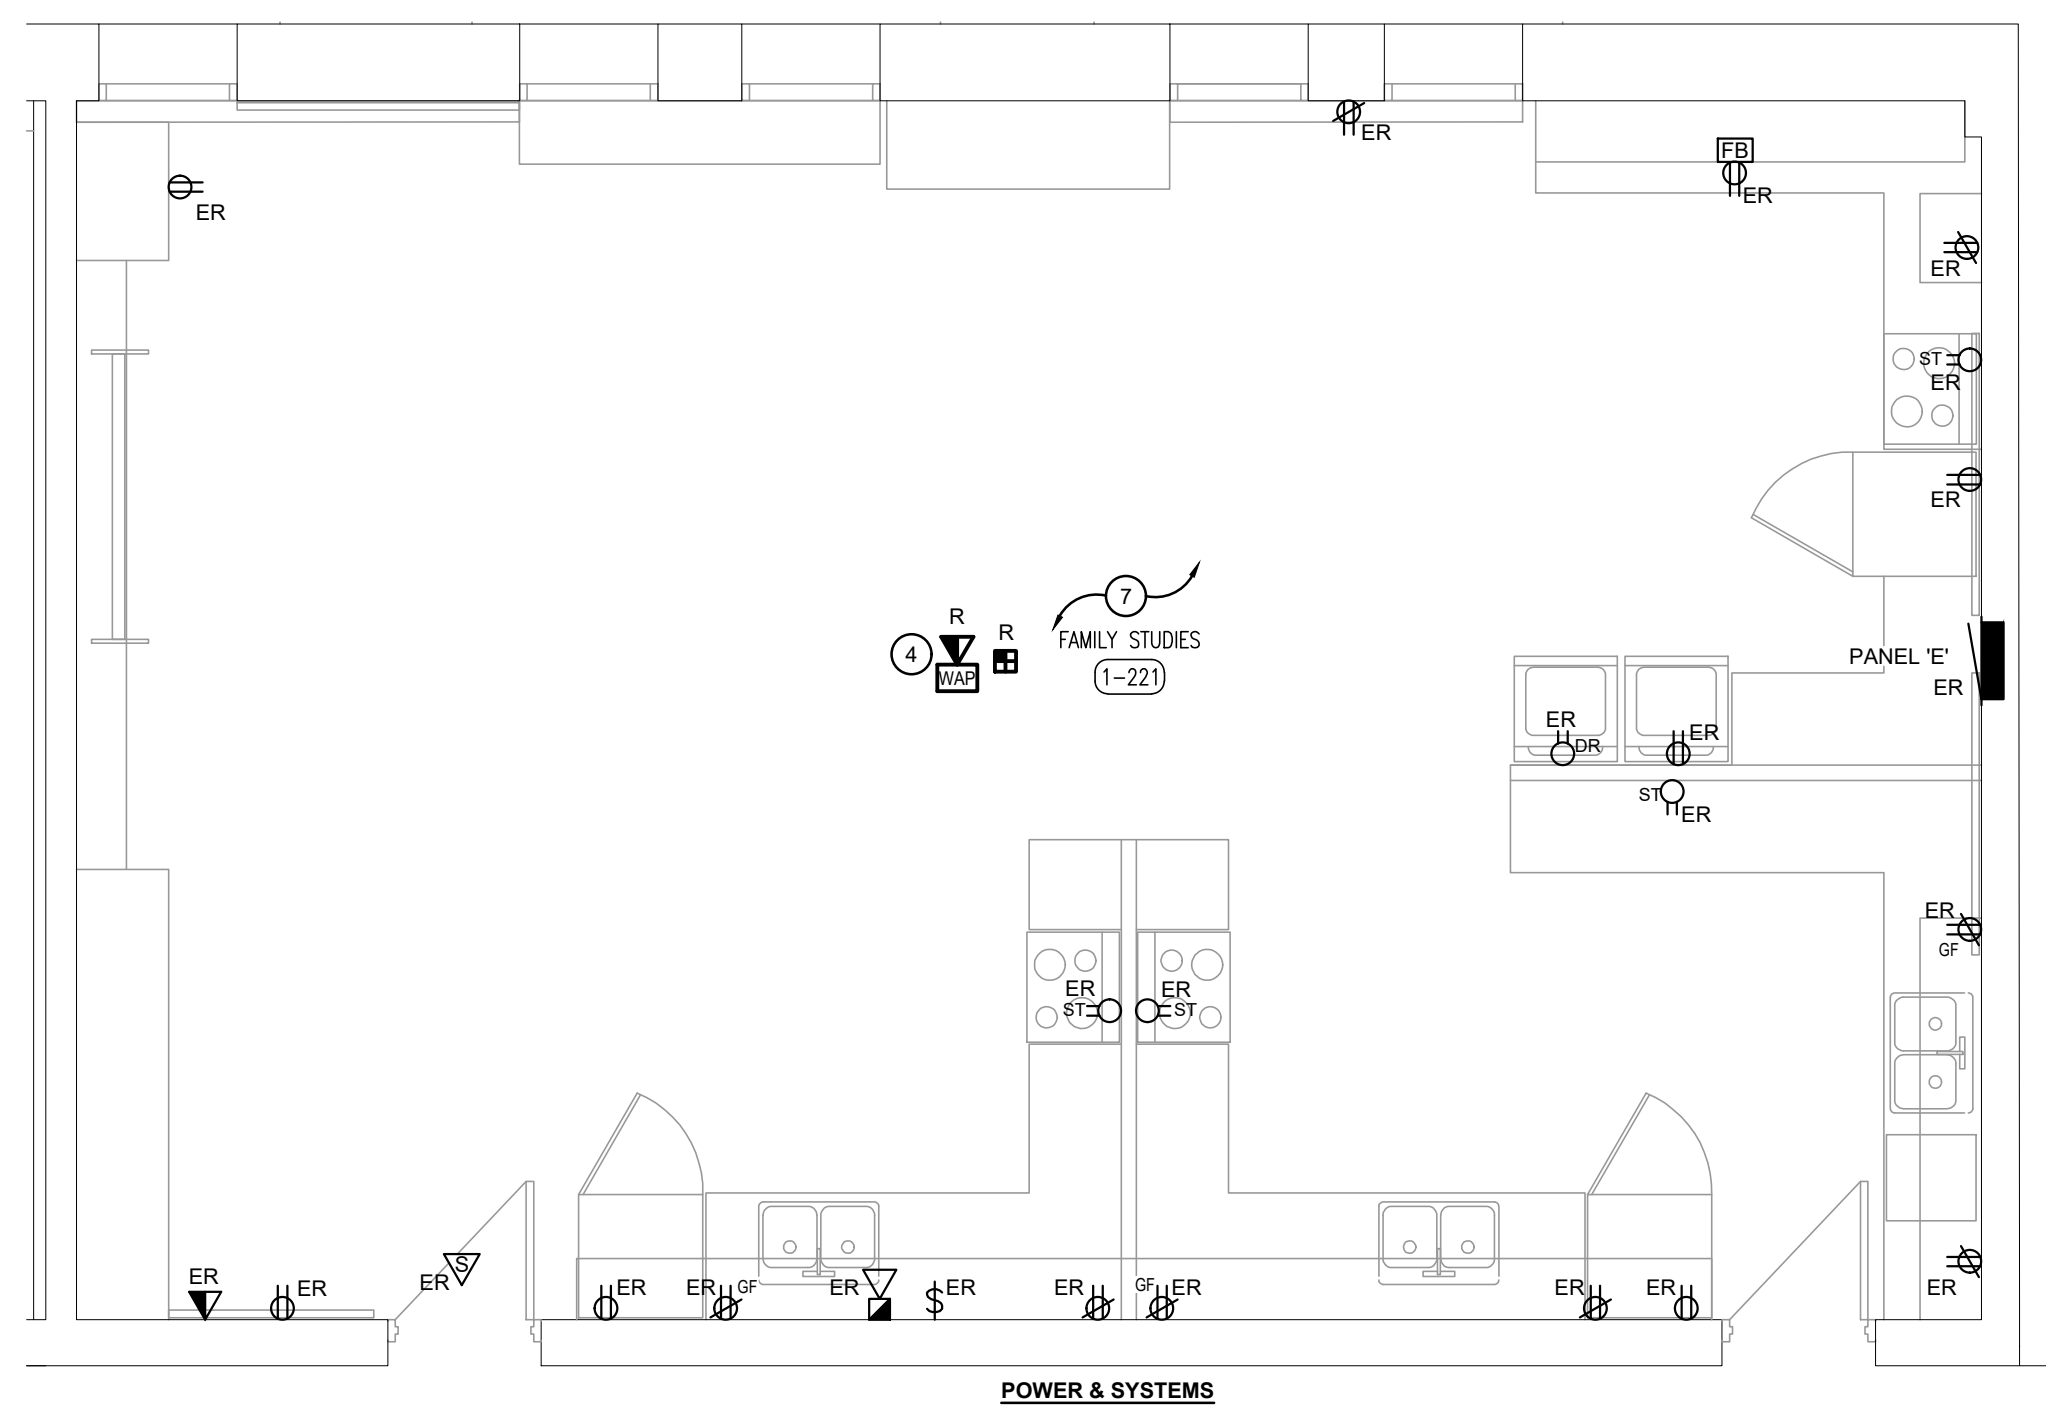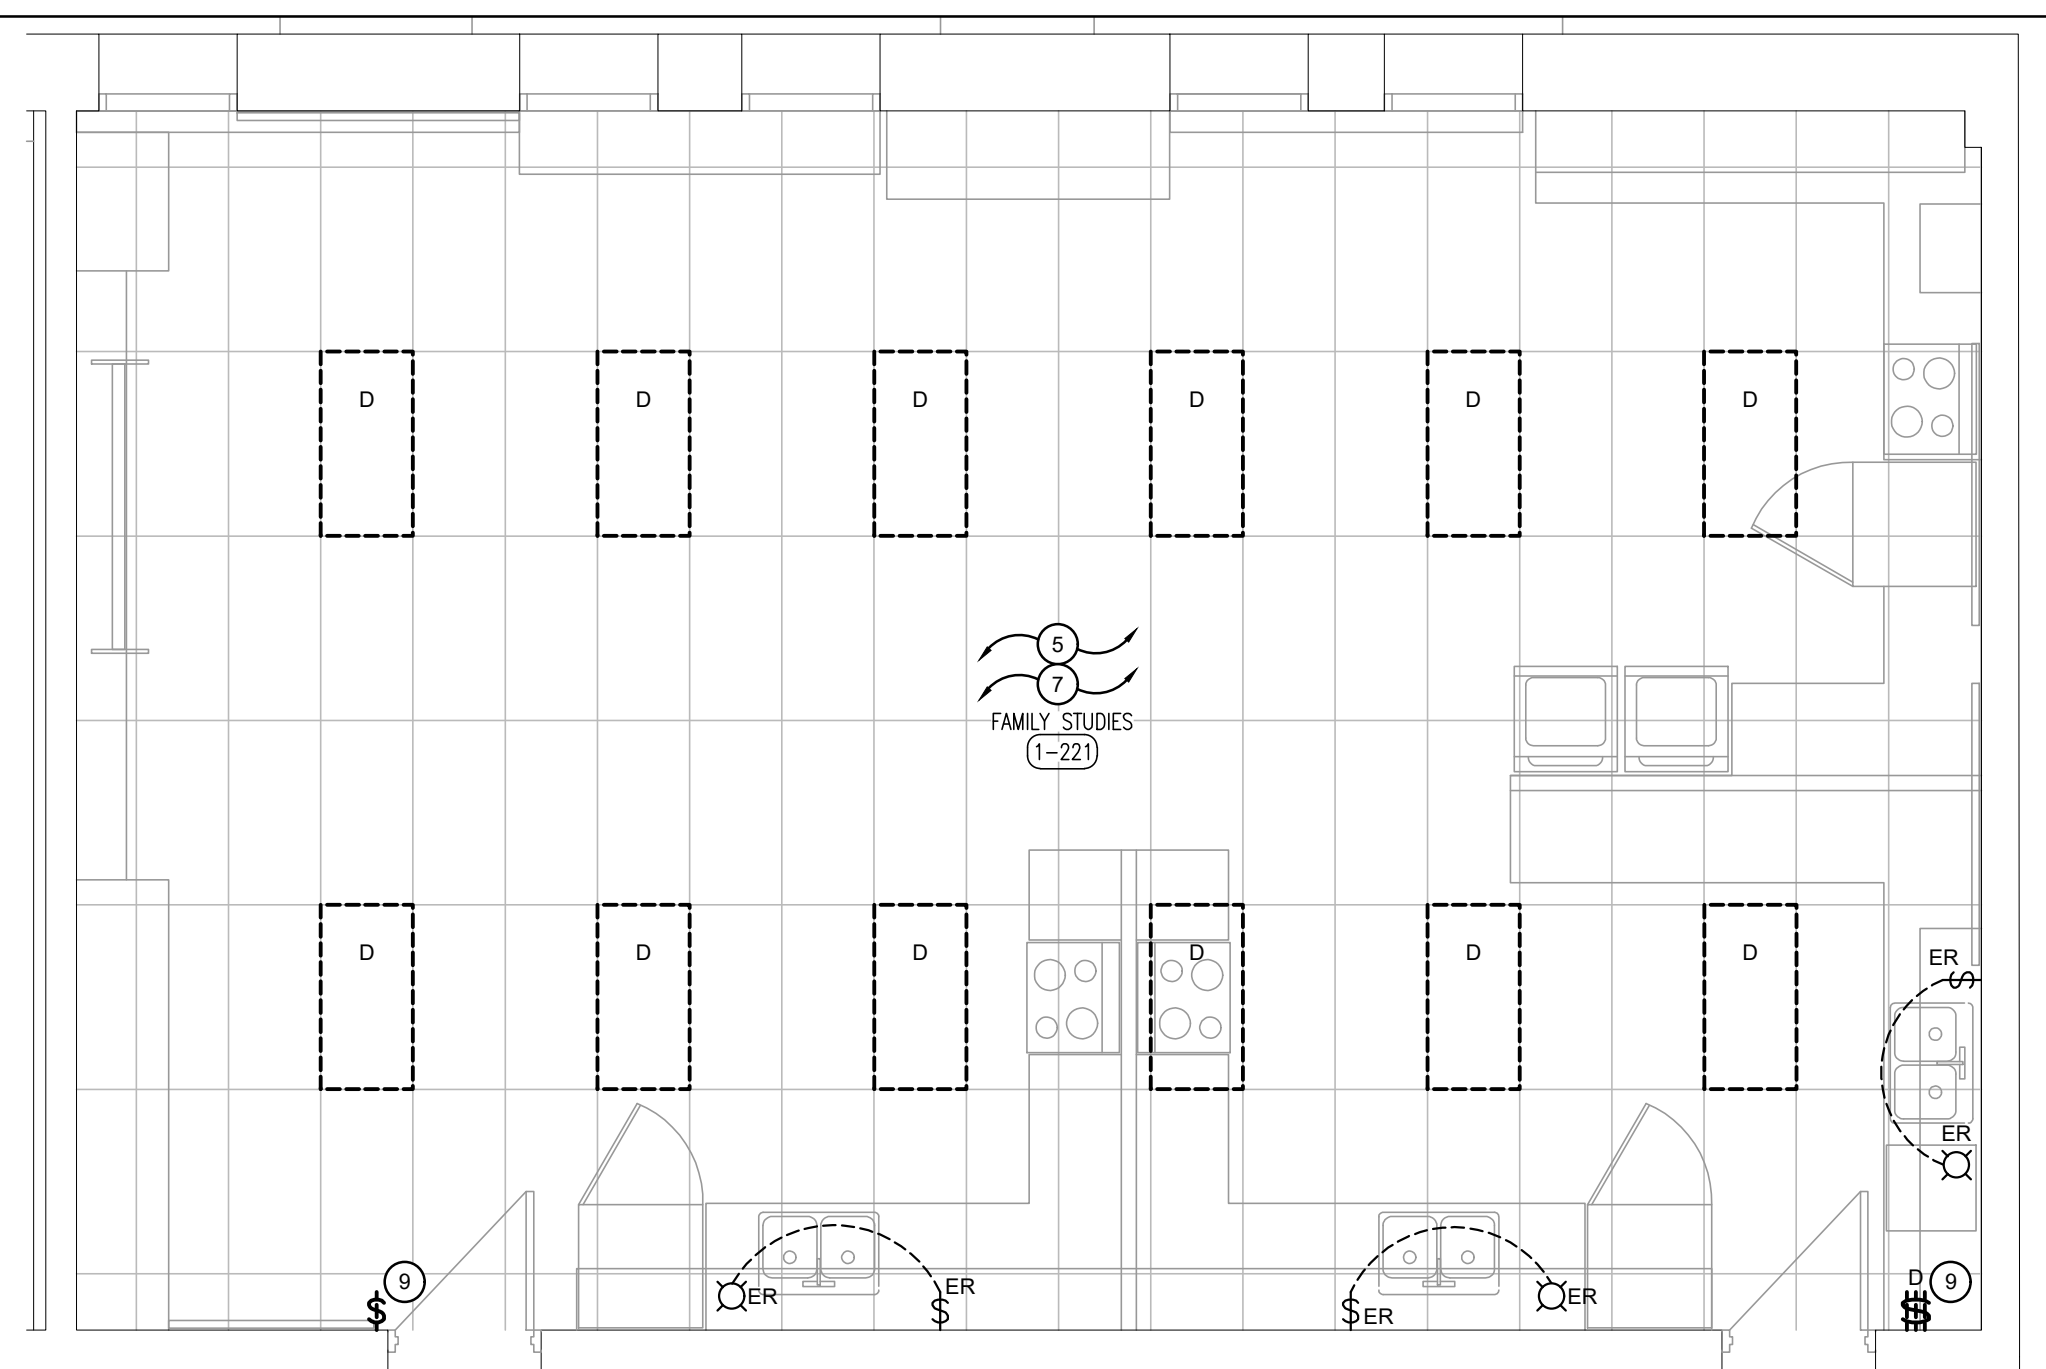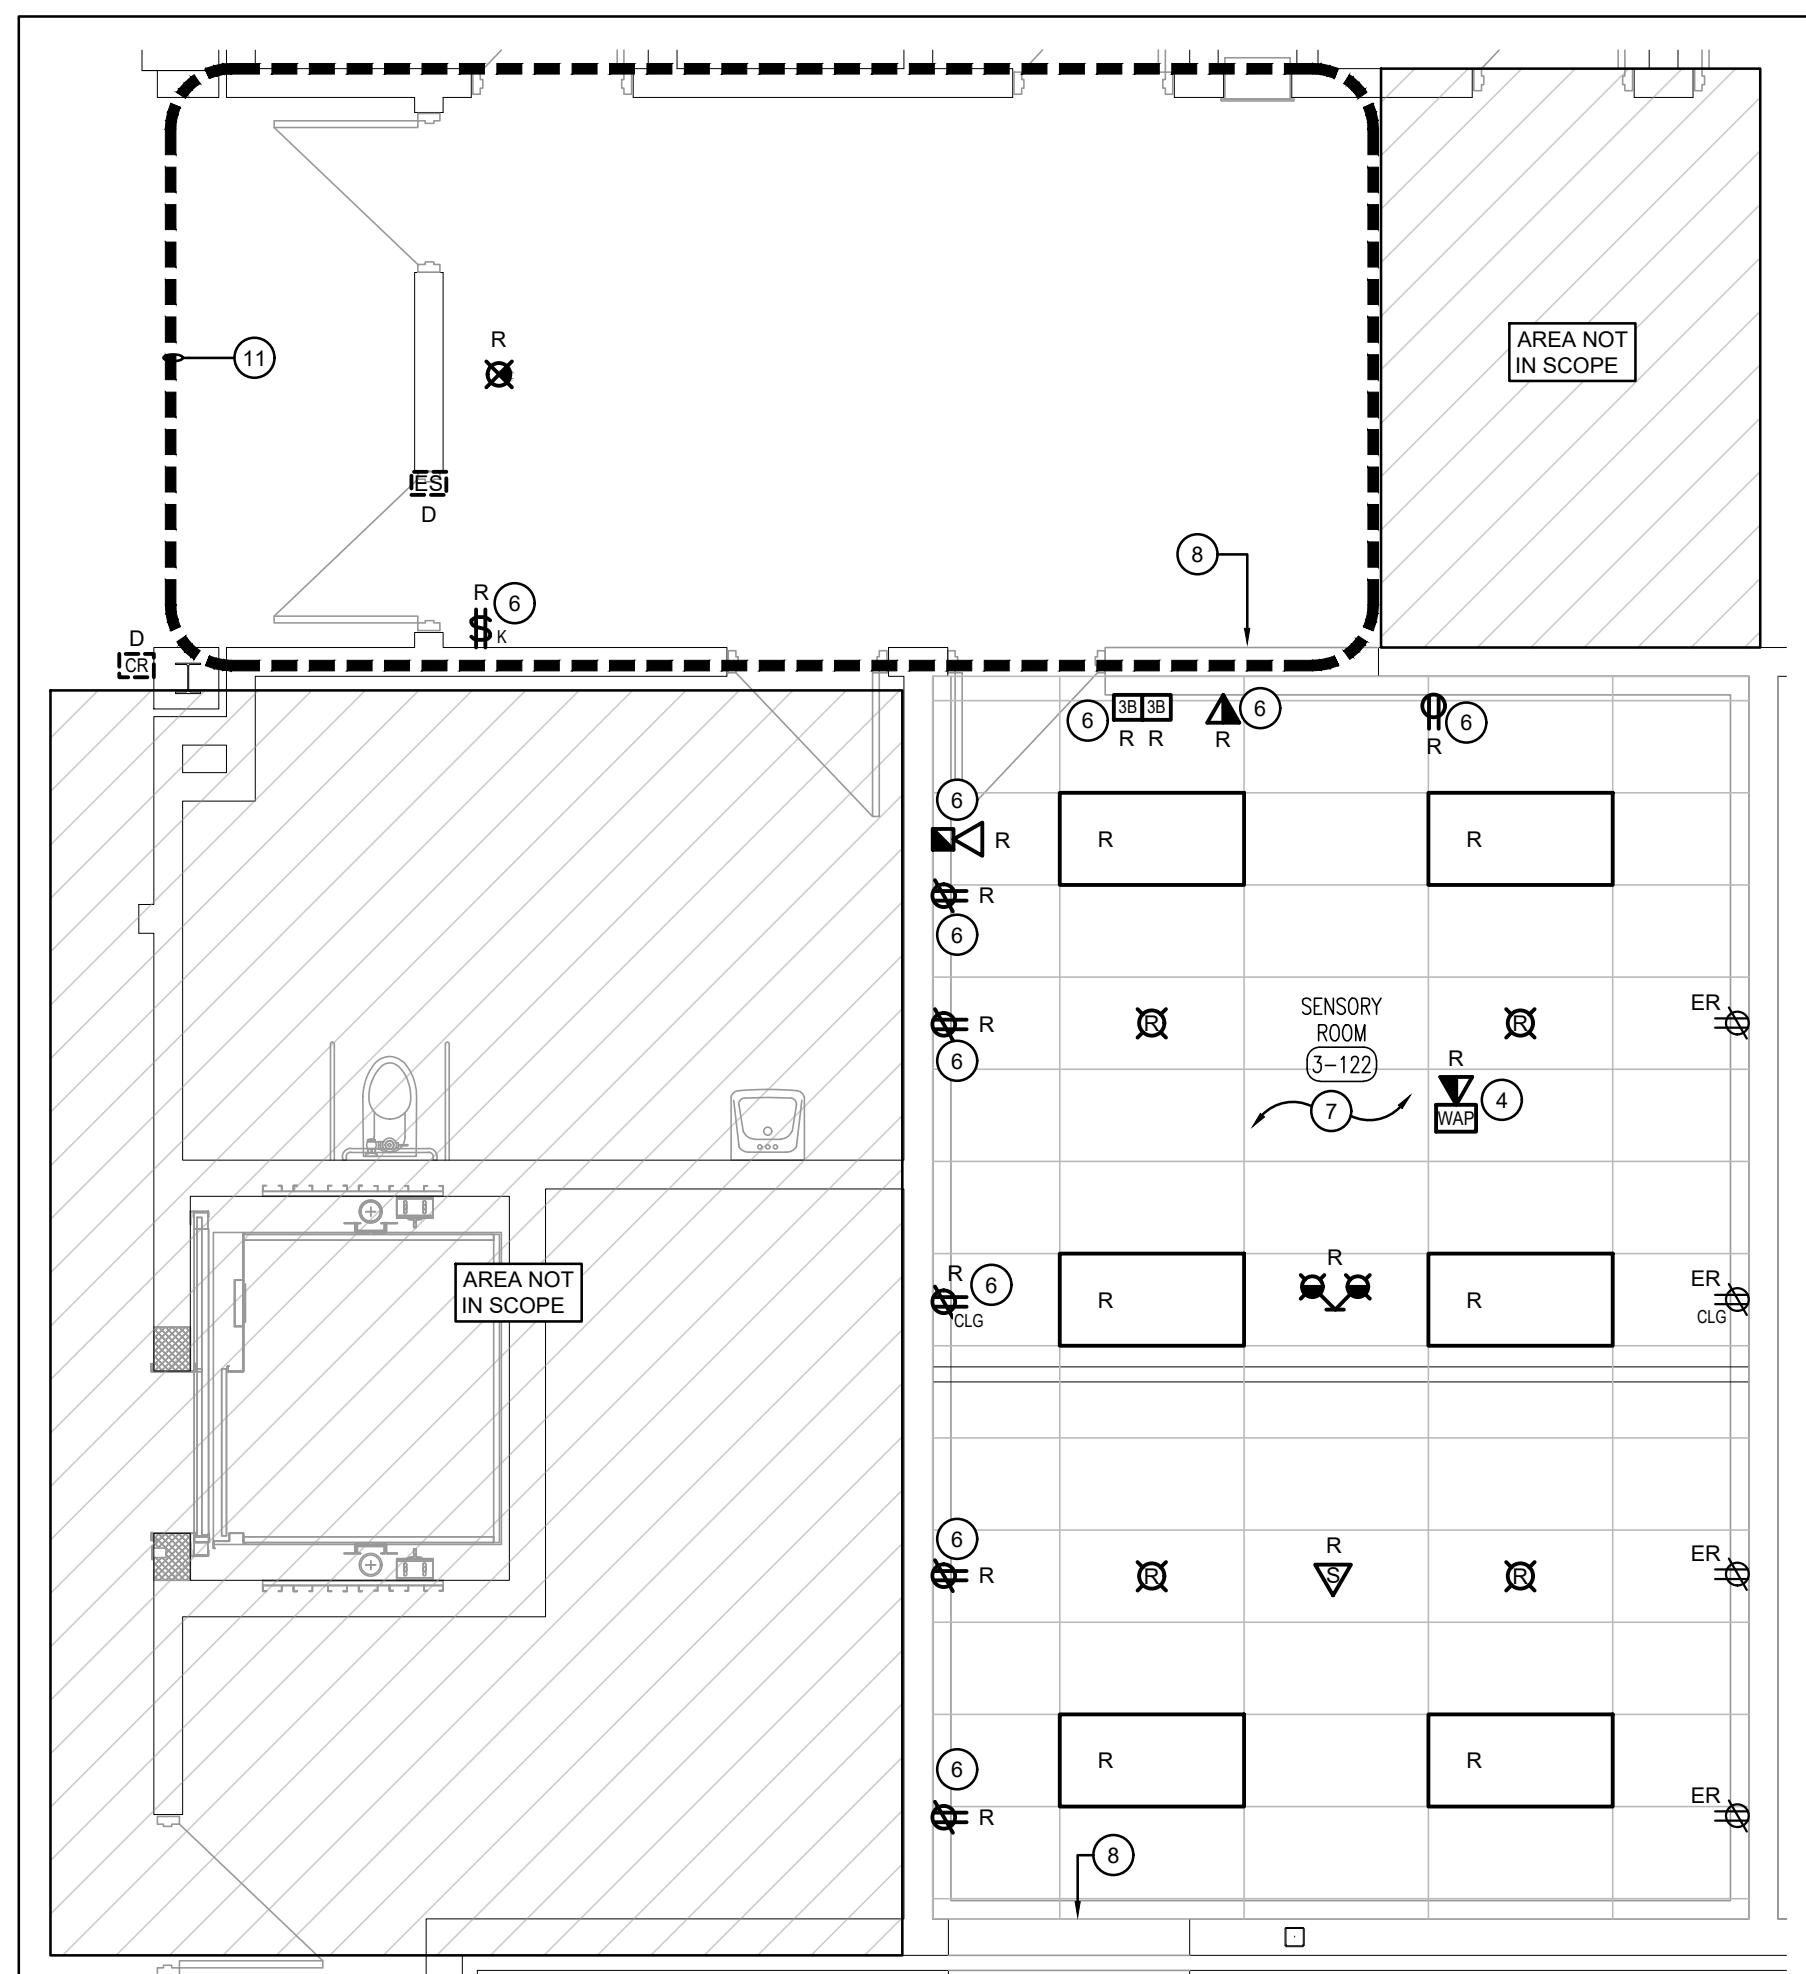

Sheet no. **E 201 00**

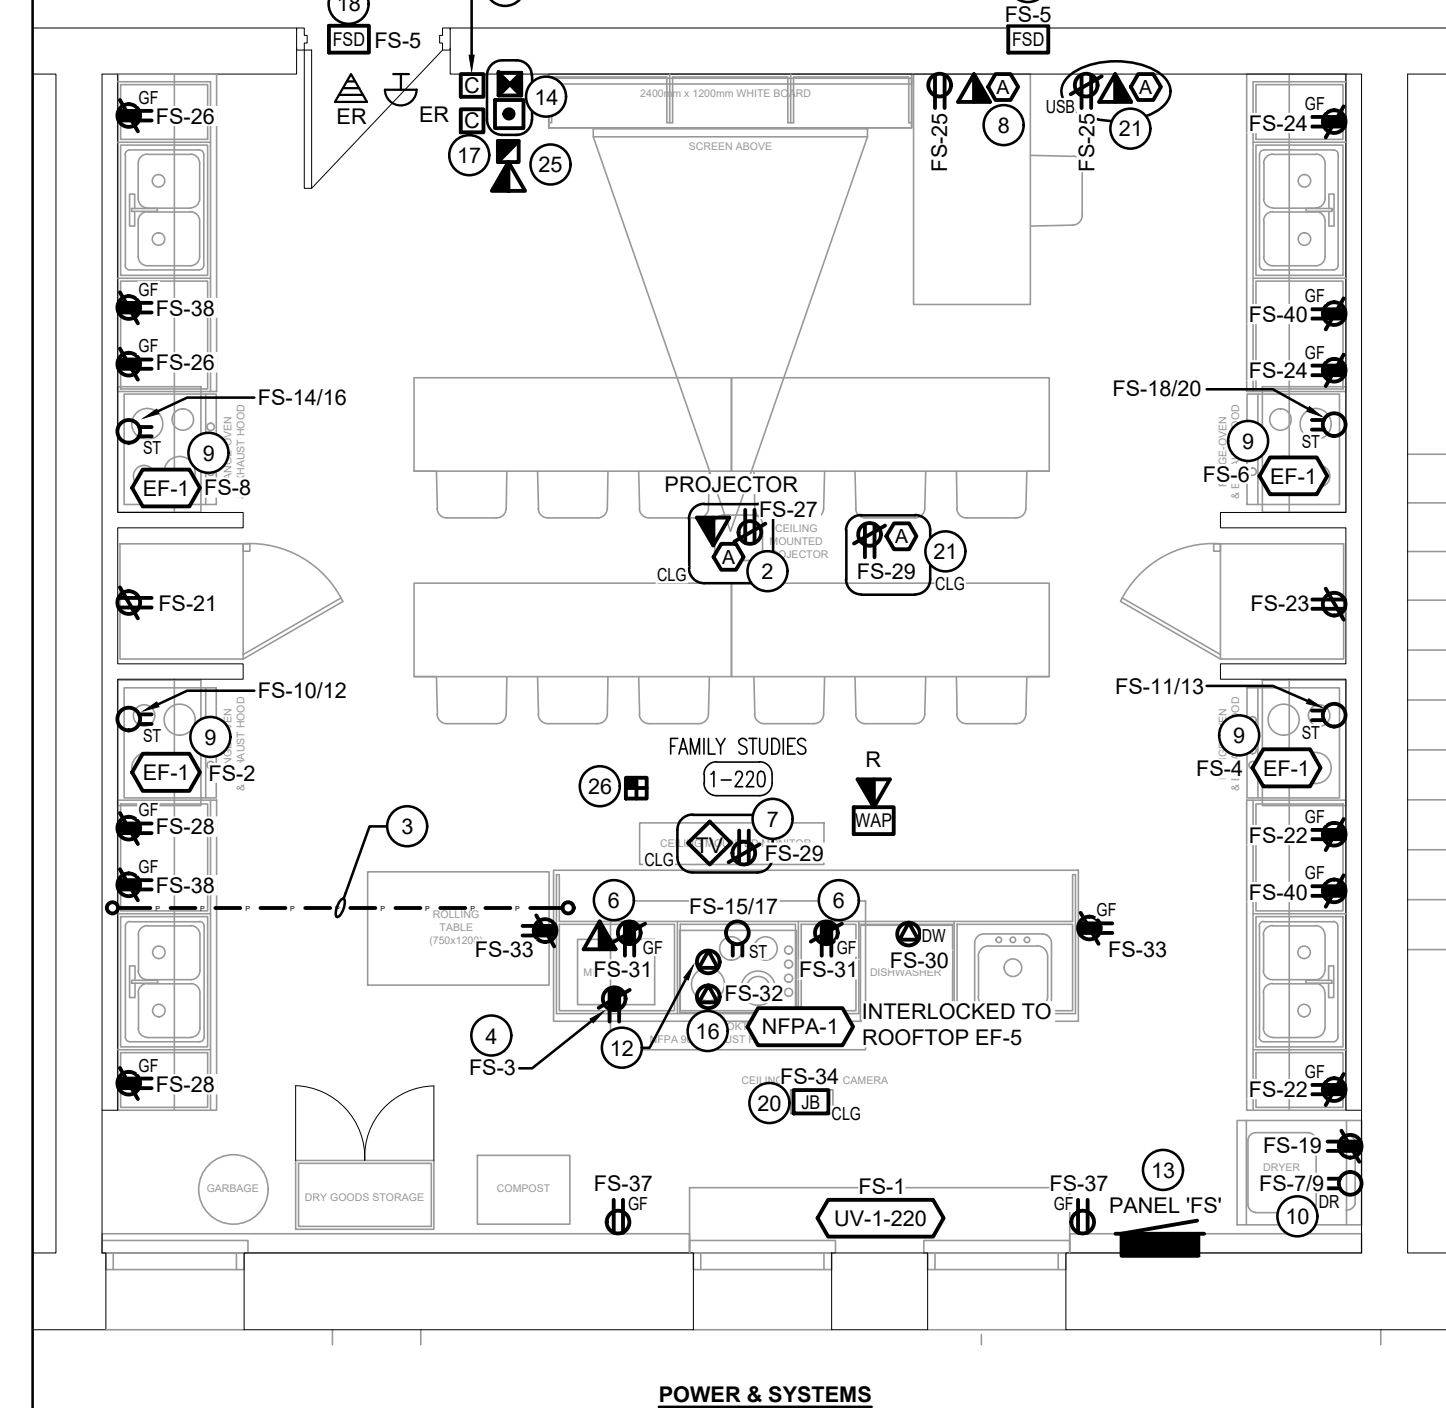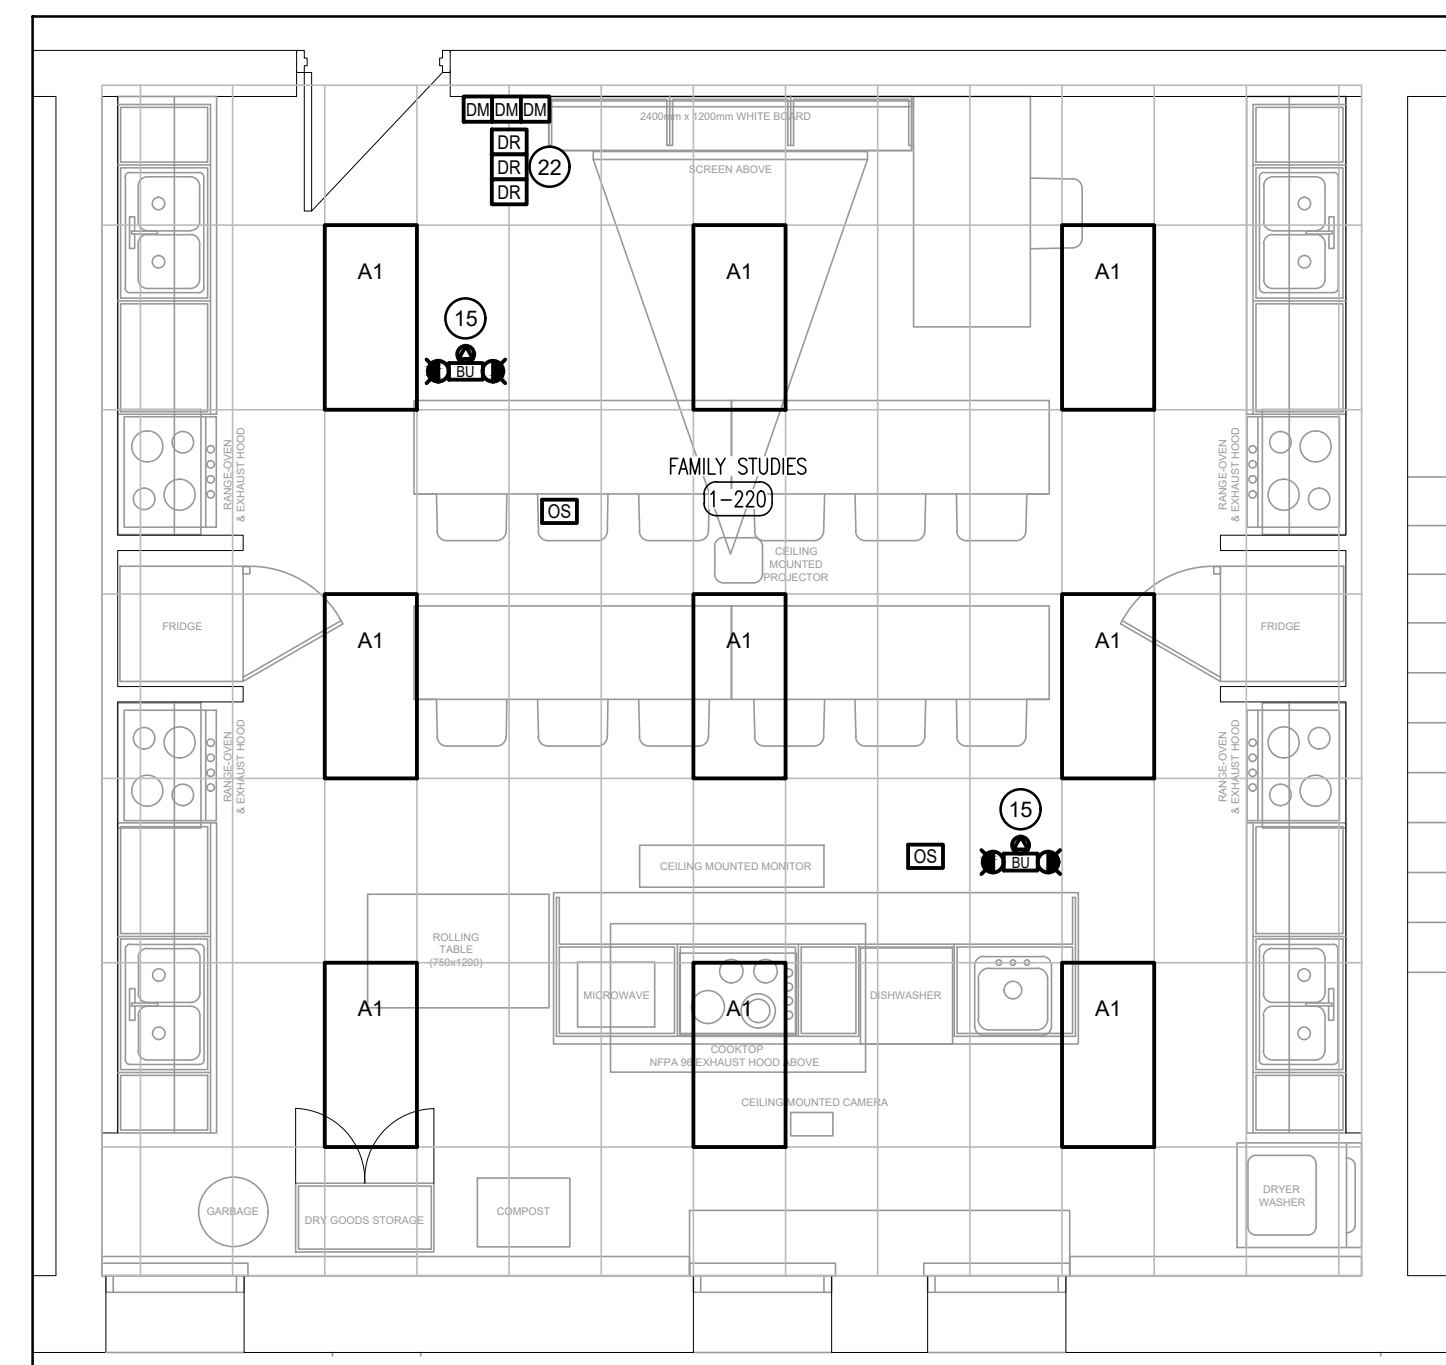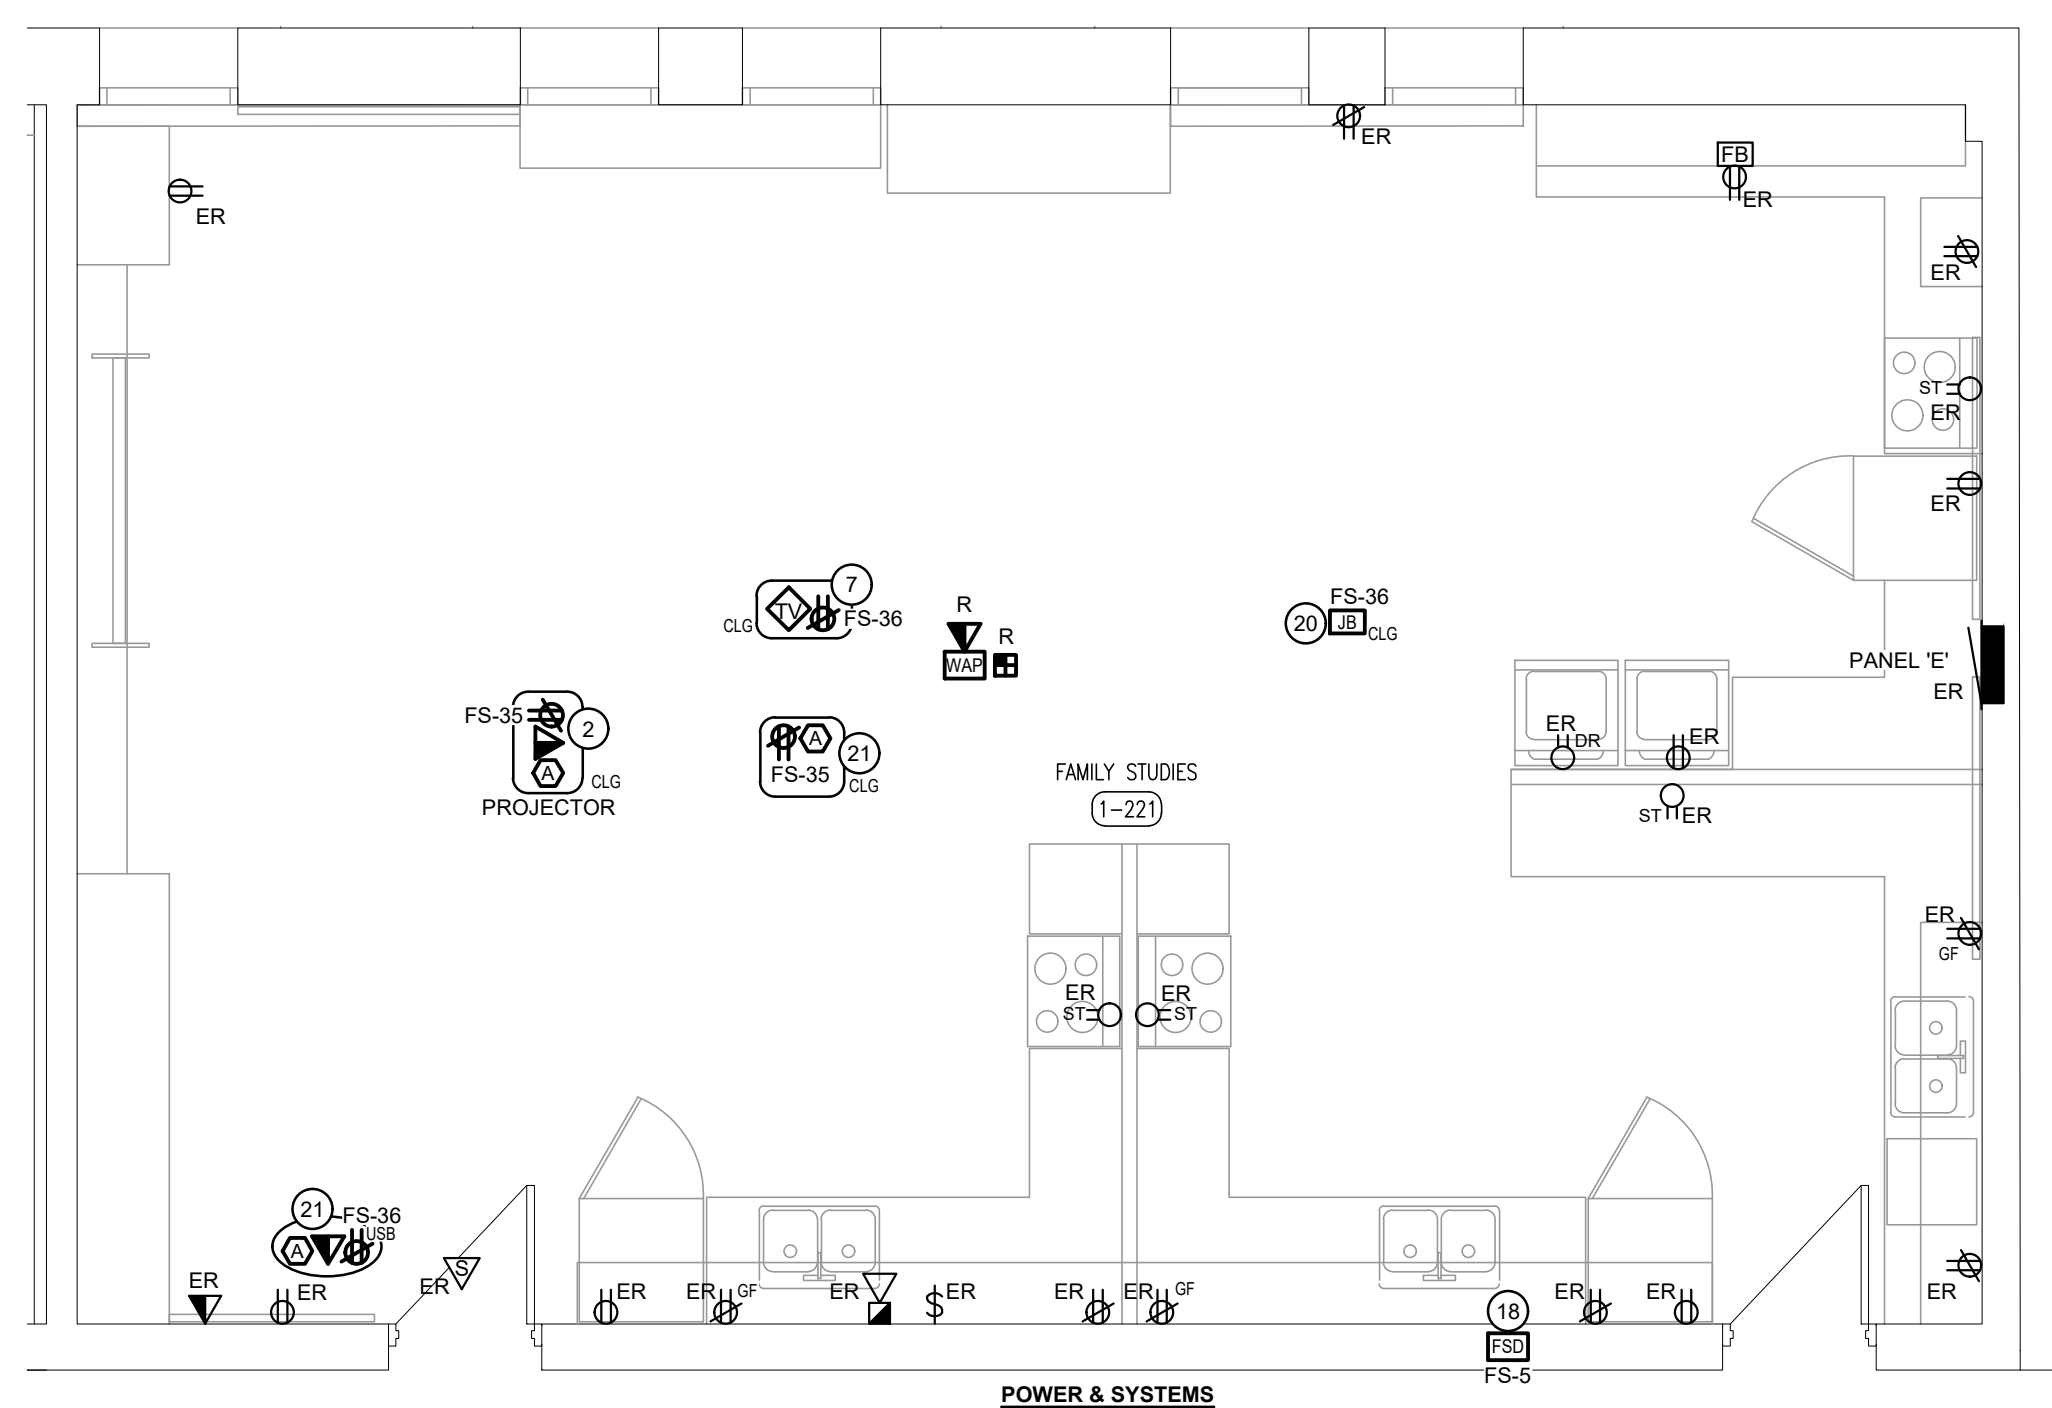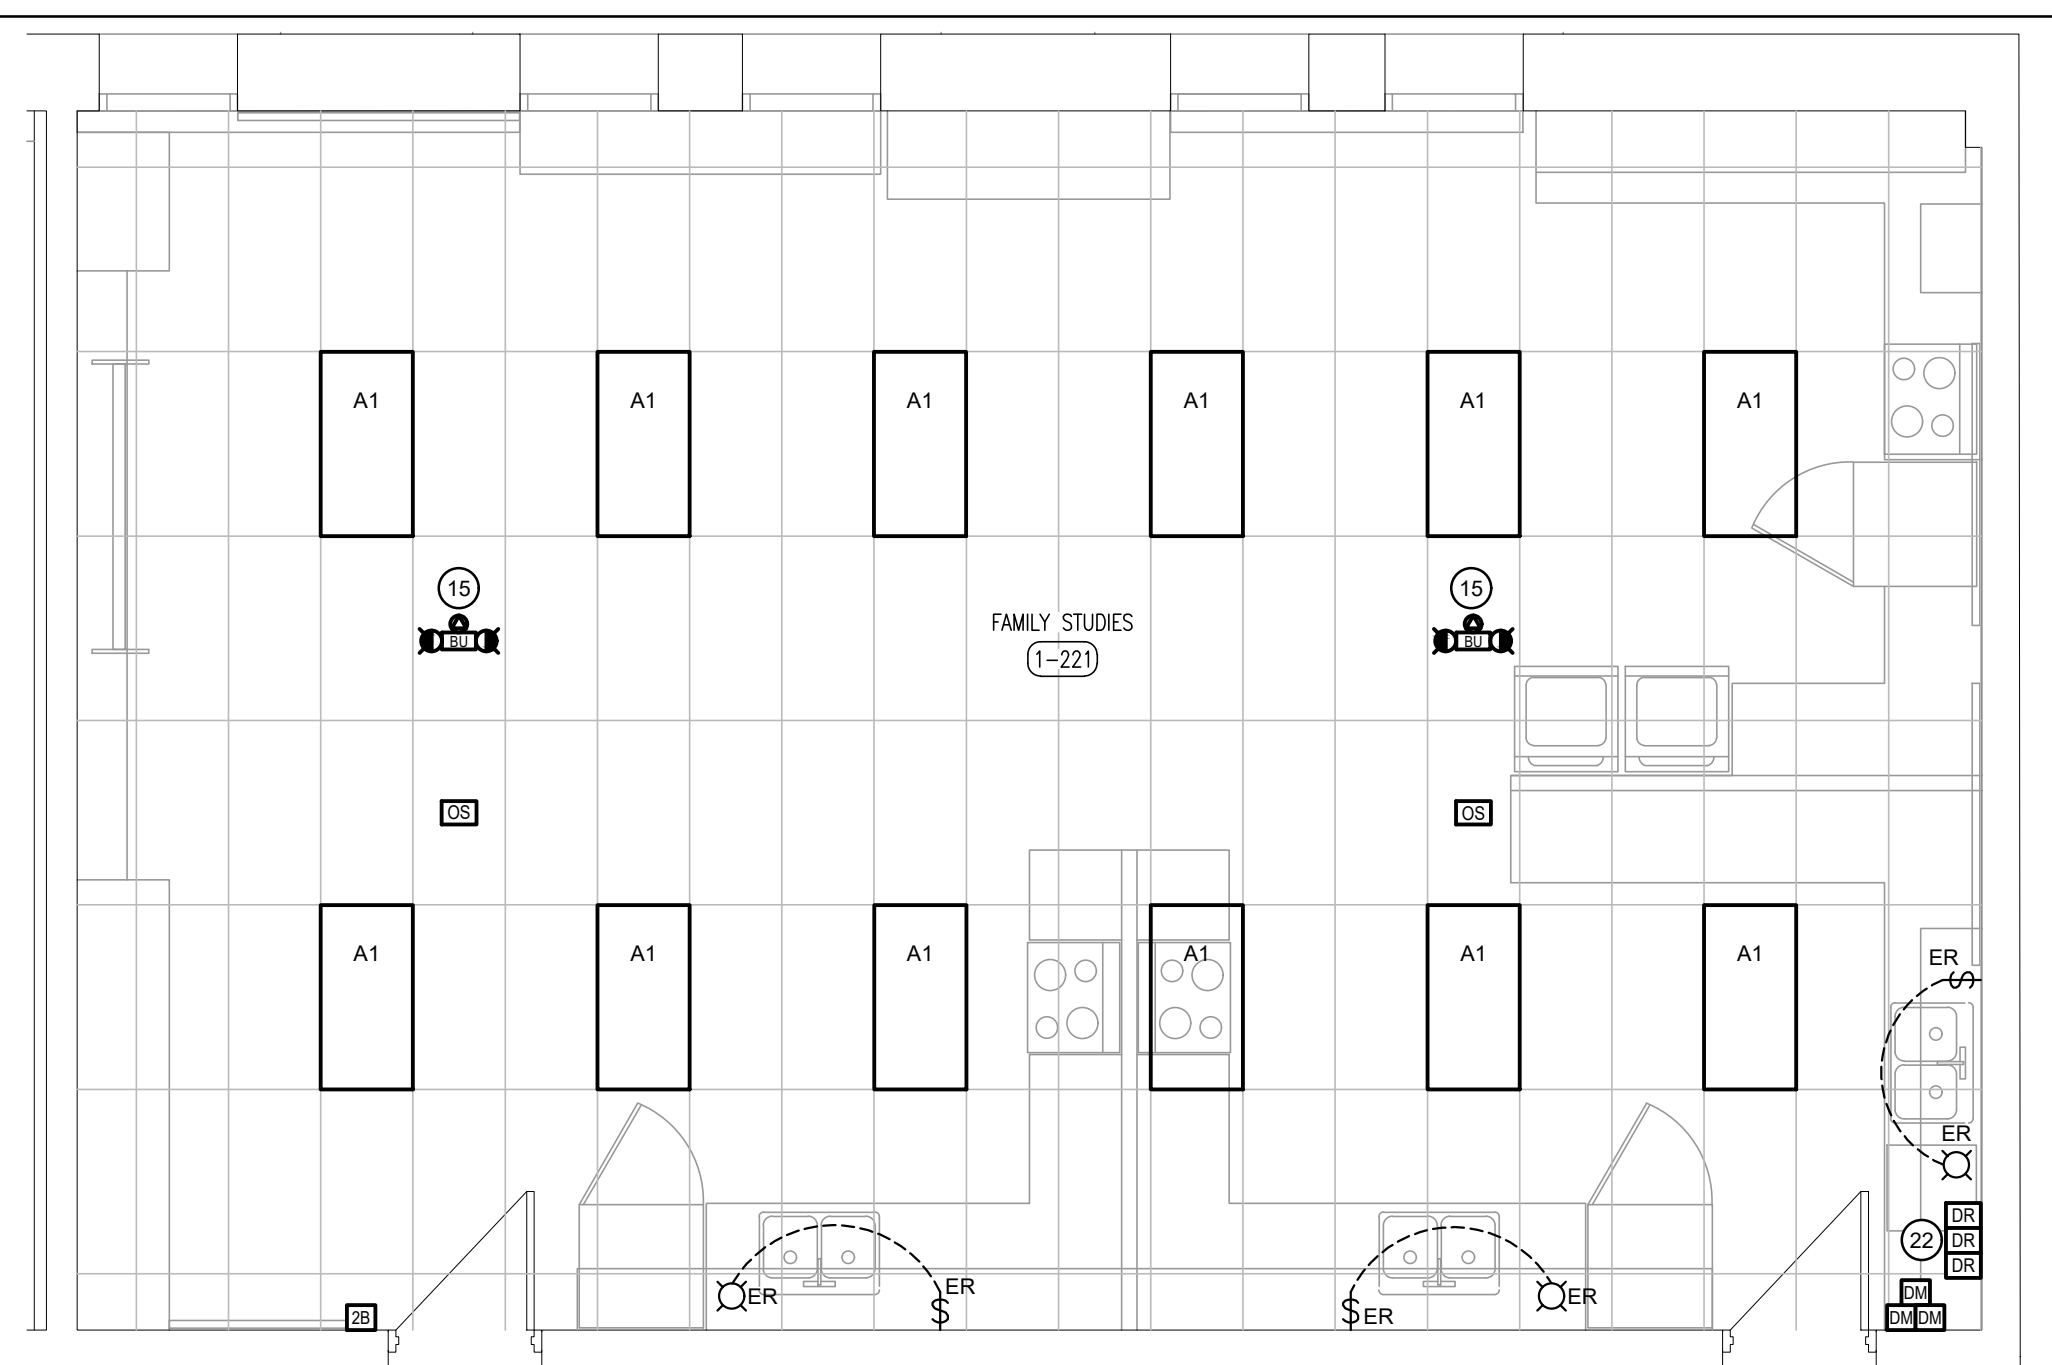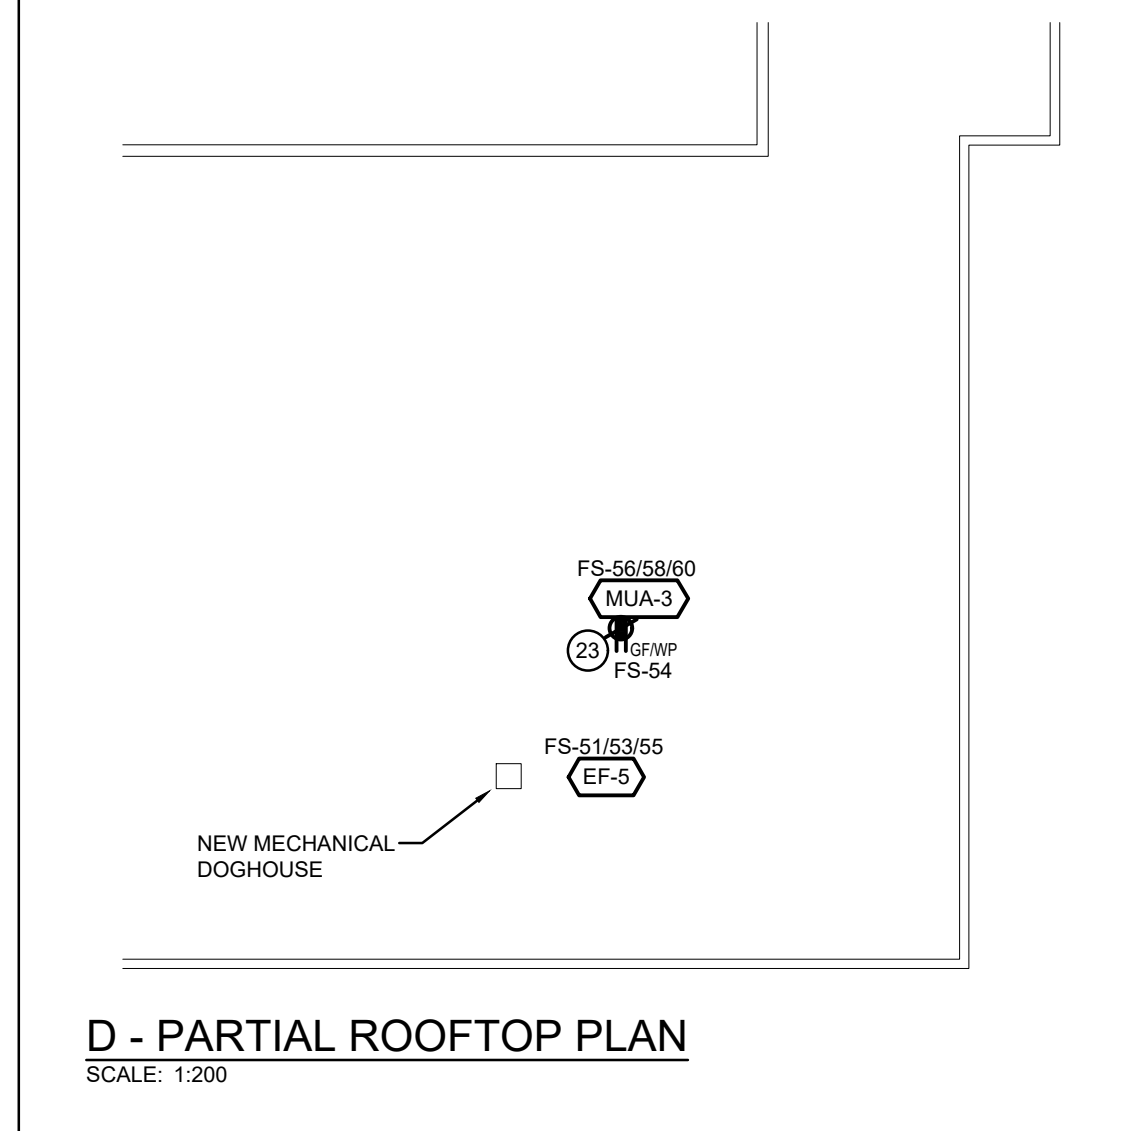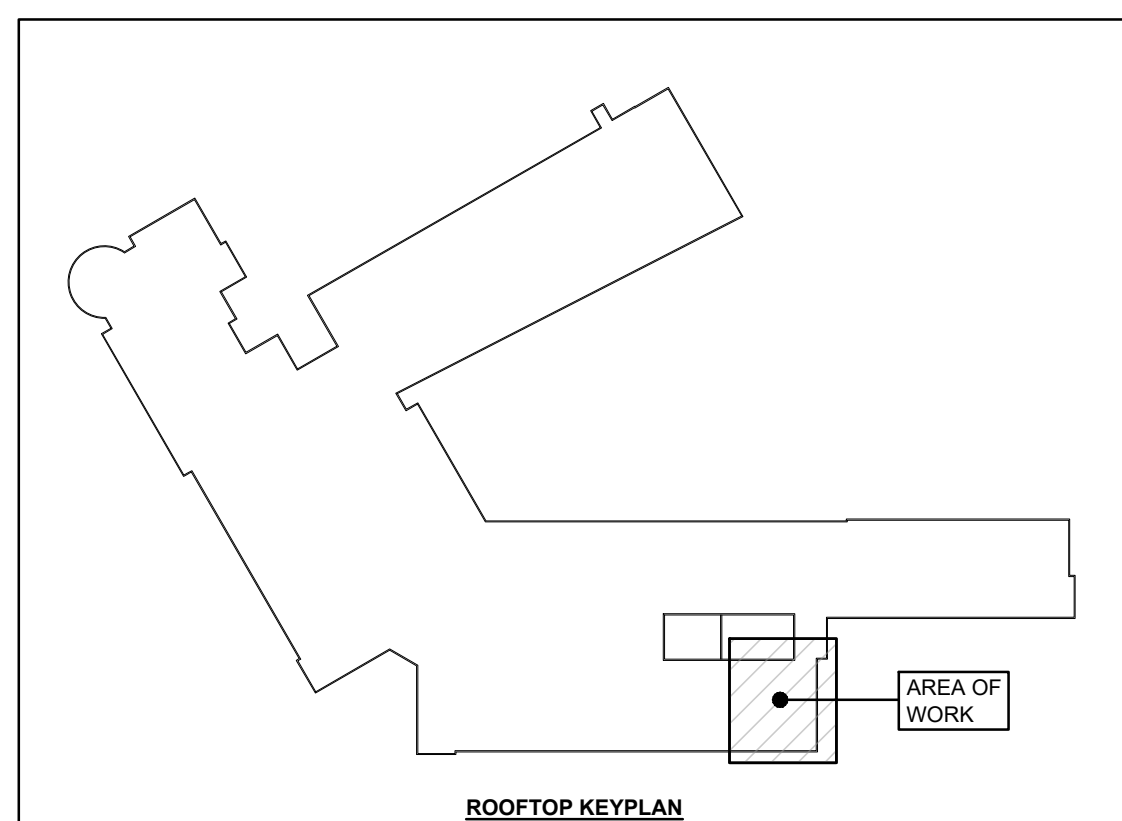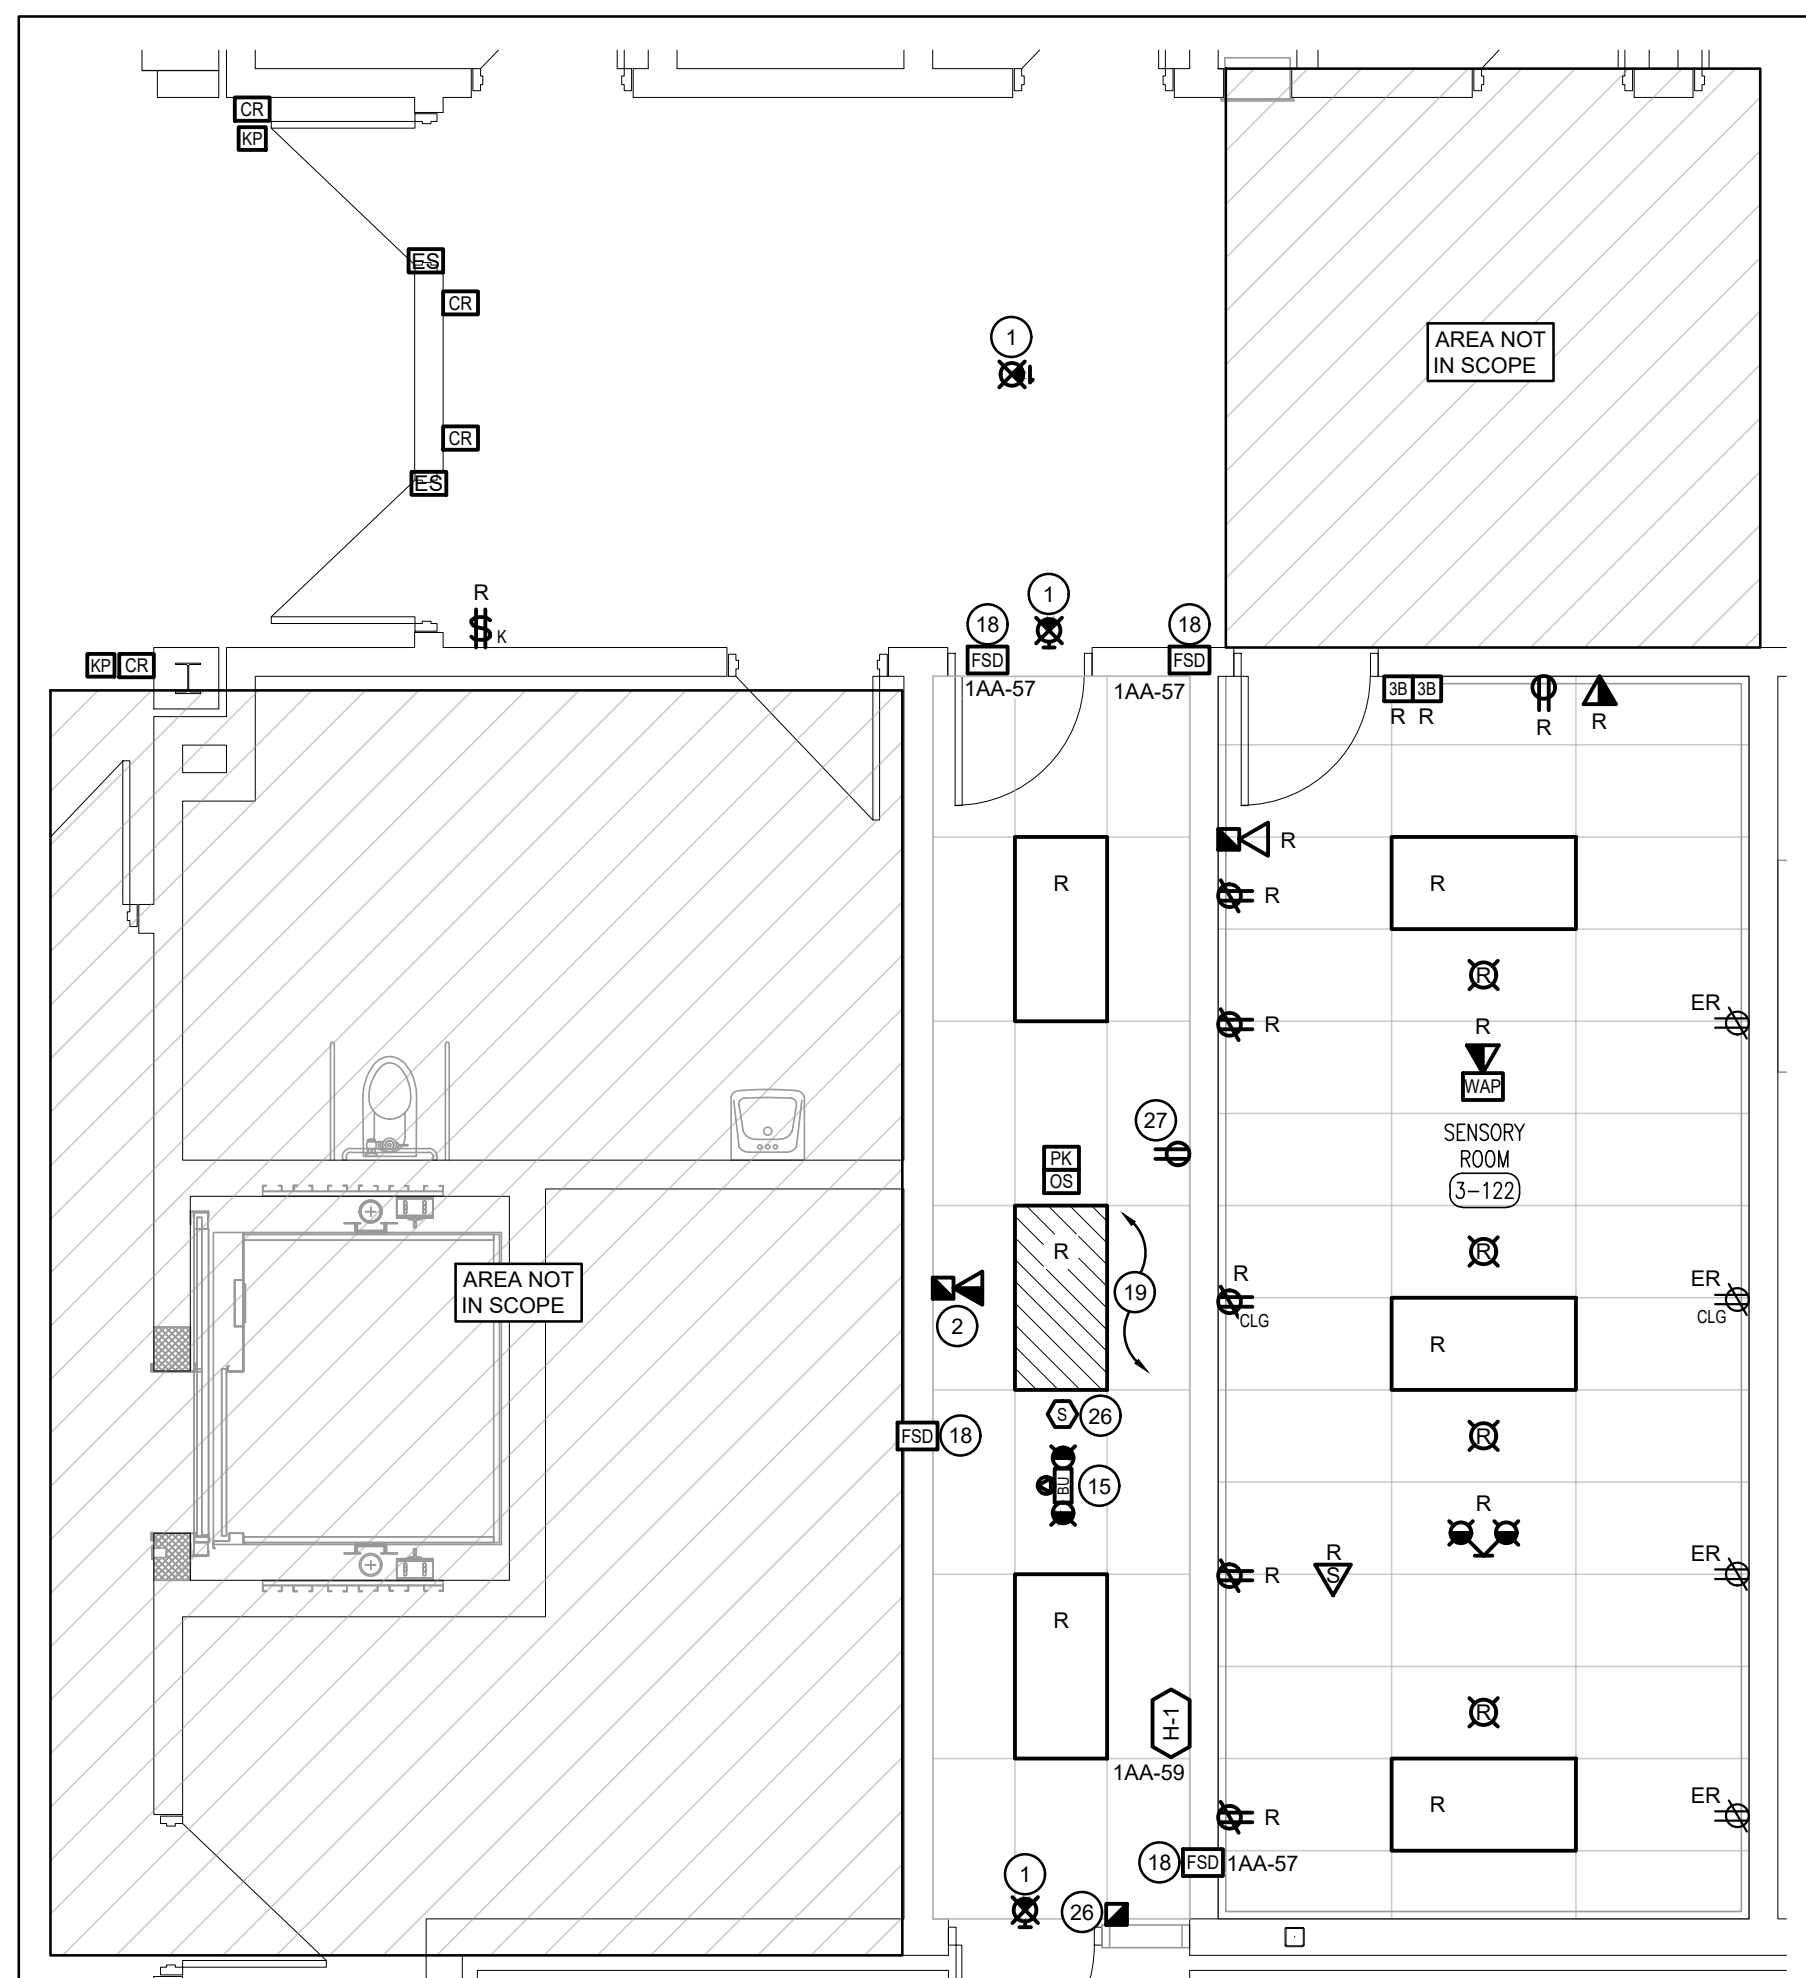

NOTES: CIRCUIT LABELS

PROVIDE P-TOUCH LABELS INDICATING PANEL AND CIRCUIT LABEL ON ALL LIGHT SWITCH, LIGHTING CONTROL STATION, AND RECEPTACLE DEVICE FACEPLATES. INCLUDE SWITCH LEG INDICATION FOR LIGHTING CONTROLS AND SWITCHES.

REFER TO SPECIFICATIONS FOR
FURTHER DETAILS AND REQUIREMENTS.

SUPPRESSION SYSTEM NOTES

- | | |
|---|--|
| A | PROVIDE 120V UNSWITCHED POWER FROM CIRCUIT AS NOTED FOR SUPPRESSION SYSTEM. |
| B | PROVIDE CONTROL WIRING FROM SUPPRESSION SYSTEM SUCH THAT IN A FIRE CONDITION, SYSTEM MUST SHUT OFF ALL POWER AND/OR FUEL TO ALL APPLIANCES BELOW EXHAUST HOOD. CONNECT TO FIRE ALARM SYSTEM. |
| C | CONNECT OUTPUT OF SUPPRESSION SYSTEM TO CONTACTORS FEEDING ELECTRICAL EQUIPMENT BENEATH HOOD AS NOTED. |
| D | CONNECT OUTPUT OF SUPPRESSION SYSTEM TO GAS SOLENOID. |
| E | PROVIDE INTERCONNECT FOR SHUTDOWN OF KITCHEN MAKEUP AIR UNIT MUA-1. |

ALL CONDUIT AND WIRING FOR DEVICES LOCATED IN LAB BENCHES SHALL BE INSTALLED UNDERNEATH FLOOR SLAB. COORDINATE DETAILS AND REQUIREMENTS WITH ARCHITECT AND OWNER PRIOR TO INSTALLATION.

GENERAL DEMOLITION NOTES

- 'ER' INDICATES EXISTING ITEM TO REMAIN.
- 'R' INDICATES EXISTING ITEM IN RELOCATED POSITION.
- ALL DEVICES SHOWN ARE NEW UNLESS OTHERWISE NOTED.
- EXISTING ELECTRICAL EQUIPMENT NOT SHOWN SHALL REMAIN UNLESS OTHERWISE NOTED.
- MAINTAIN SERVICE TO ALL EXISTING DEVICES TO REMAIN.
- REVISE PANEL DIRECTORIES TO SUIT CHANGES (TYPED).

SPECIFIC RENOVATION NOTES

- 1 CONNECT NEW EXIT SIGN TO EXISTING EXIT SIGN CIRCUIT. EXTEND EXISTING CIRCUIT AS REQUIRED.
- 2 INDICATED DEVICES ARE TO BE INSTALLED IN RECESSED BOX FOR CEILING PROJECTOR MOUNT. CONFIRM EXACT LOCATION ON SITE PRIOR TO ROUGH-IN TO ENSURE PROPER DIRECTION/ORIENTATION FROM SCREEN. RECESSED PROTECTION BOX IS TO BE EQUAL TO FSR CAT #CB-22P.
- 3 INDICATES THREE (3) 21mm CONDUITS RUNNING UNDER FLOOR FOR ISLAND DEVICES. CONDUITS SHALL STUB UP THROUGH FLOOR WITHIN WALL AND MILLWORK AS SHOWN. COORDINATE EXACT LOCATION OF WALL AND MILLWORK PRIOR TO INSTALLATION. IN SCIENCE ROOM, CONTRACTOR IS TO CUT FLOOR TO INSTALL FEEDS. FLOOR MUST BE SCANNED PRIOR TO CUTTING PER SPECIFICATIONS.
- 4 INDICATES RECEPTACLE DEDICATED TO UNDER-COUNTER MICROWAVE. COORDINATE WITH MILLWORK CONTRACTOR PRIOR TO INSTALLATION.
- 5 INDICATES HARDWIRED CONNECTION TO COOKTOP INTEGRATED IN COUNTER. COORDINATE WITH SHOP DRAWINGS MILLWORK CONTRACTOR PRIOR TO INSTALLATION.

SPECIFIC RENOVATION NOTES CONT'D

- 6 INDICATES POWER TO BE MOUNTED ON INSTRUCTOR'S DESK. COORDINATE WITH ARCHITECT FOR EXACT MOUNTING LOCATION.
- 7 INDICATES CEILING MOUNTED RECEPTACLE AND TV OUTLET FOR FUTURE VIDEO MONITOR. COORDINATE EXACT LOCATION WITH ARCHITECT PRIOR TO INSTALLATION.
- 8 INDICATES AUXILIARY OUTLET ROUGH-IN FOR PROJECTOR SIGNAL INPUT AT SAME HEIGHT AS ADJACENT OUTLETS CW 2mmC TO CEILING SPACE.
- 9 INDICATES LOCATION OF OVERHEAD RANGEHOOD. COORDINATE INSTALLATION HEIGHT OF JUNCTION BOX WITH ARCHITECTURAL ELEVATIONS AND MILLWORK DRAWINGS PRIOR TO INSTALLATION.
- 10 INDICATES DEDICATED RECEPTACLE FOR STACKED WASHER/DRYER. COORDINATE RECEPTACLE MOUNTING LOCATION WITH SHOP DRAWINGS PRIOR TO INSTALLATION.
- 11 PROVIDE CONTROL WIRING FROM SUPPRESSION SYSTEM SUCH THAT IN A FIRE CONDITION, SYSTEM MUST SHUT OFF ALL POWER AND/OR FUEL TO ALL APPLIANCES BELOW EXHAUST HOODS. PROVIDE SINGLE-POLE CONTACT TO SUIT QUANTITY OF BRANCH CIRCUITS FOR ITEMS BEING SHUTDOWN. PROVIDE SUITABLE COIL VOLTAGE AND CONTROLS TRANSFORMER TO SUIT NFA HOOD PANEL. INTERLOCK. REFER TO SUPPRESSION SYSTEM NOTES FOR ADDITIONAL INFORMATION. CONNECT TO FIRE ALARM SYSTEM.
- 12 INDICATES NFA HOOD ABOVE TEACHERS ISLAND. COORDINATE WITH SHOP DRAWINGS AND MECHANICAL TRADE PRIOR TO INSTALLATION. INTERLOCK WITH NFA MUA. REFER TO SUPPRESSION SYSTEM NOTES FOR ADDITIONAL INFORMATION.
- 13 INDICATES APPROXIMATE LOCATION OF NEW RECESSED PANEL FS'. REFER TO PARTIAL DISTRIBUTION RISER ON DRAWING E103 FOR ADDITIONAL INFORMATION.
- 14 INDICATES COMBINATION STARTER AND PUSH BUTTON STATION FOR NFA EXHAUST FAN. COORDINATE LOCATION ON-SITE WITH MECHANICAL CONTRACTOR.
- 15 CONNECT NEW EMERGENCY FIXTURE TO UNSWITCHED SIDE OF LOCAL LIGHTING CIRCUIT. EXTEND EXISTING CIRCUIT AS REQUIRED.

SPECIFIC RENOVATION NOTES CONT'D

- 16 INDICATES HOOD LIGHTING TO BE WIRED TO LOCATION INTEGRAL TO HOOD. COORDINATE WITH HOOD SUPPLIER. CONNECT TO CIRCUIT AS NOTED ON SCHEDULE.
- 17 CONNECT (X1) 208V, 50A-3P CONTACTOR CONTROLLING HOOD EXHAUST FAN CIRCUIT. CONNECT COIL POWER THROUGH FIRE SUPPRESSION SYSTEM CONTACTS
- 18 INDICATES 120V POWER AND FIRE ALARM CONNECTIONS TO SMOKE/FIRE DAMPER WITH INTEGRAL SMOKE DETECTOR. REFER TO FIRE ALARM RISER DIAGRAM.
- 19 CONNECT INDICATED RELOCATED LIGHT FIXTURES AND NEW CONTROL DEVICES TO ADJACENT CORRIDOR LIGHTING CIRCUIT AND CONTROLS.
- 20 INDICATES 120V POWER IN JUNCTION BOX IN CEILING FOR FUTURE CEILING MOUNTED CAMERA.
- 21 INDICATES DEVICES FOR UNITY SYSTEM. COORDINATE EXACT LOCATION WITH UNITY INSTALLER ON SITE. REFER TO DETAIL G/E102.
- 22 INDICATES DIGITAL ROOM CONTROLLER RELAY(S) INSTALLED WITHIN ACCESSIBLE CEILING SPACE FOR CONTROL OF NOTED MOTION SENSOR(S). REFER TO LIGHTING CONTROL DETAILS.
- 23 PROVIDE T-SLOT GROUND FAULT RECEPTACLE COMPLETE WITH "HEAVY DUTY IN-USE" WEATHER-PROOF COVER. COORDINATE PLACEMENT WITH MECHANICAL TRADE. INDICATED DEVICE IS TO BE MOUNTED ±96" (960mm) ABOVE FINISHED FLOOR LEVEL.
- 24 FEED INDICATED DEVICE FROM DOGHOUSE (PROVIDED BY MECHANICAL) ALONG MECHANICAL PIPING. COORDINATE EXACT LOCATION WITH MECHANICAL CONTRACTOR.
- 25 CONNECT INDICATED FIRE ALARM DEVICE TO EXISTING SIGNAL CIRCUIT. PROVIDE BOOSTER MODULE AS REQUIRED.
- 26 INDICATES NEW FIRE ALARM INITIATING DEVICE TO BE CONNECTED TO EXISTING ZONE.
- 27 CONNECT NEW RECEPTACLE TO ADJACENT EXISTING LOCAL GENERAL RECEPTACLE CIRCUIT.

NOTE:

The contractor shall verify all dimensions and report all errors and discrepancies to the Consultant before commencement of the work.

The drawings show general arrangement of services. Follow as closely as actual building construction will permit. Obtain approval for relocation of service from Consultant before commencement of the work.

The drawings do not indicate all offsets fitting and accessories which may be required. Provide the same to meet the required conditions.

Drawings and specifications, etc., prepared and issued by the Consultant are the property of the Consultant and must be returned at the completion of project. These documents are not to be duplicated or copied without the consent of the Consultant.

Do not scale this drawing.

© 2026 DEE Consulting Engineers Inc.



DEI
Consulting Engineers
MECHANICAL | ELECTRICAL | AQUATIC

55 Northland Road, Waterloo, ON N2V 1Y8
 Phone: 519-725-3555
 Website: deiconsociates.ca
 Project Number: 26092

01	ISSUED FOR PERMIT AND TENDER	2022 04
No.	REVISIONS	date


 Professional Engineers Ontario *DM* 04-2-2011

Limited Engineering License

Name: D.G. MCCONKEY
Number: 100230476

Limitations: Detailed design, reporting, and specification of all building electrical systems, site servicing and review of construction drawings for conformity for these systems in new and renovation construction.

Association of Professional Engineers of Ontario

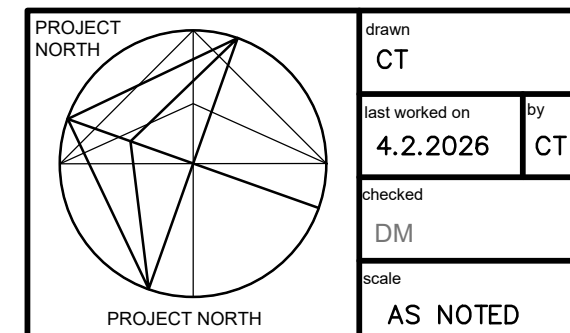

BJC
architects + assocs. inc.

client
WATERLOO REGION
DISTRICT SCHOOL
BOARD

51 ARDELT AVE
KITCHENER ONTARIO

project
GRAND RIVER COLLEGIATE
INSTITUTE RENOVATION

175 INDIAN RD
KITCHENER ONTARIO

drawing title
FIRST, SECOND, &
ROOFTOP PARTIAL
RENOVATION PLAN

reference	
project no. 25-092	client reference number
sheet no.	

	E	3	0	1	0	0
--	---	---	---	---	---	---